


Town of FERNDALE, WASHINGTON

SEWAGE SYSTEM IMPROVEMENTS

AXTON ROAD INTERCEPTOR


SCHEDULES I & II

00210.00 2.7.06 100120

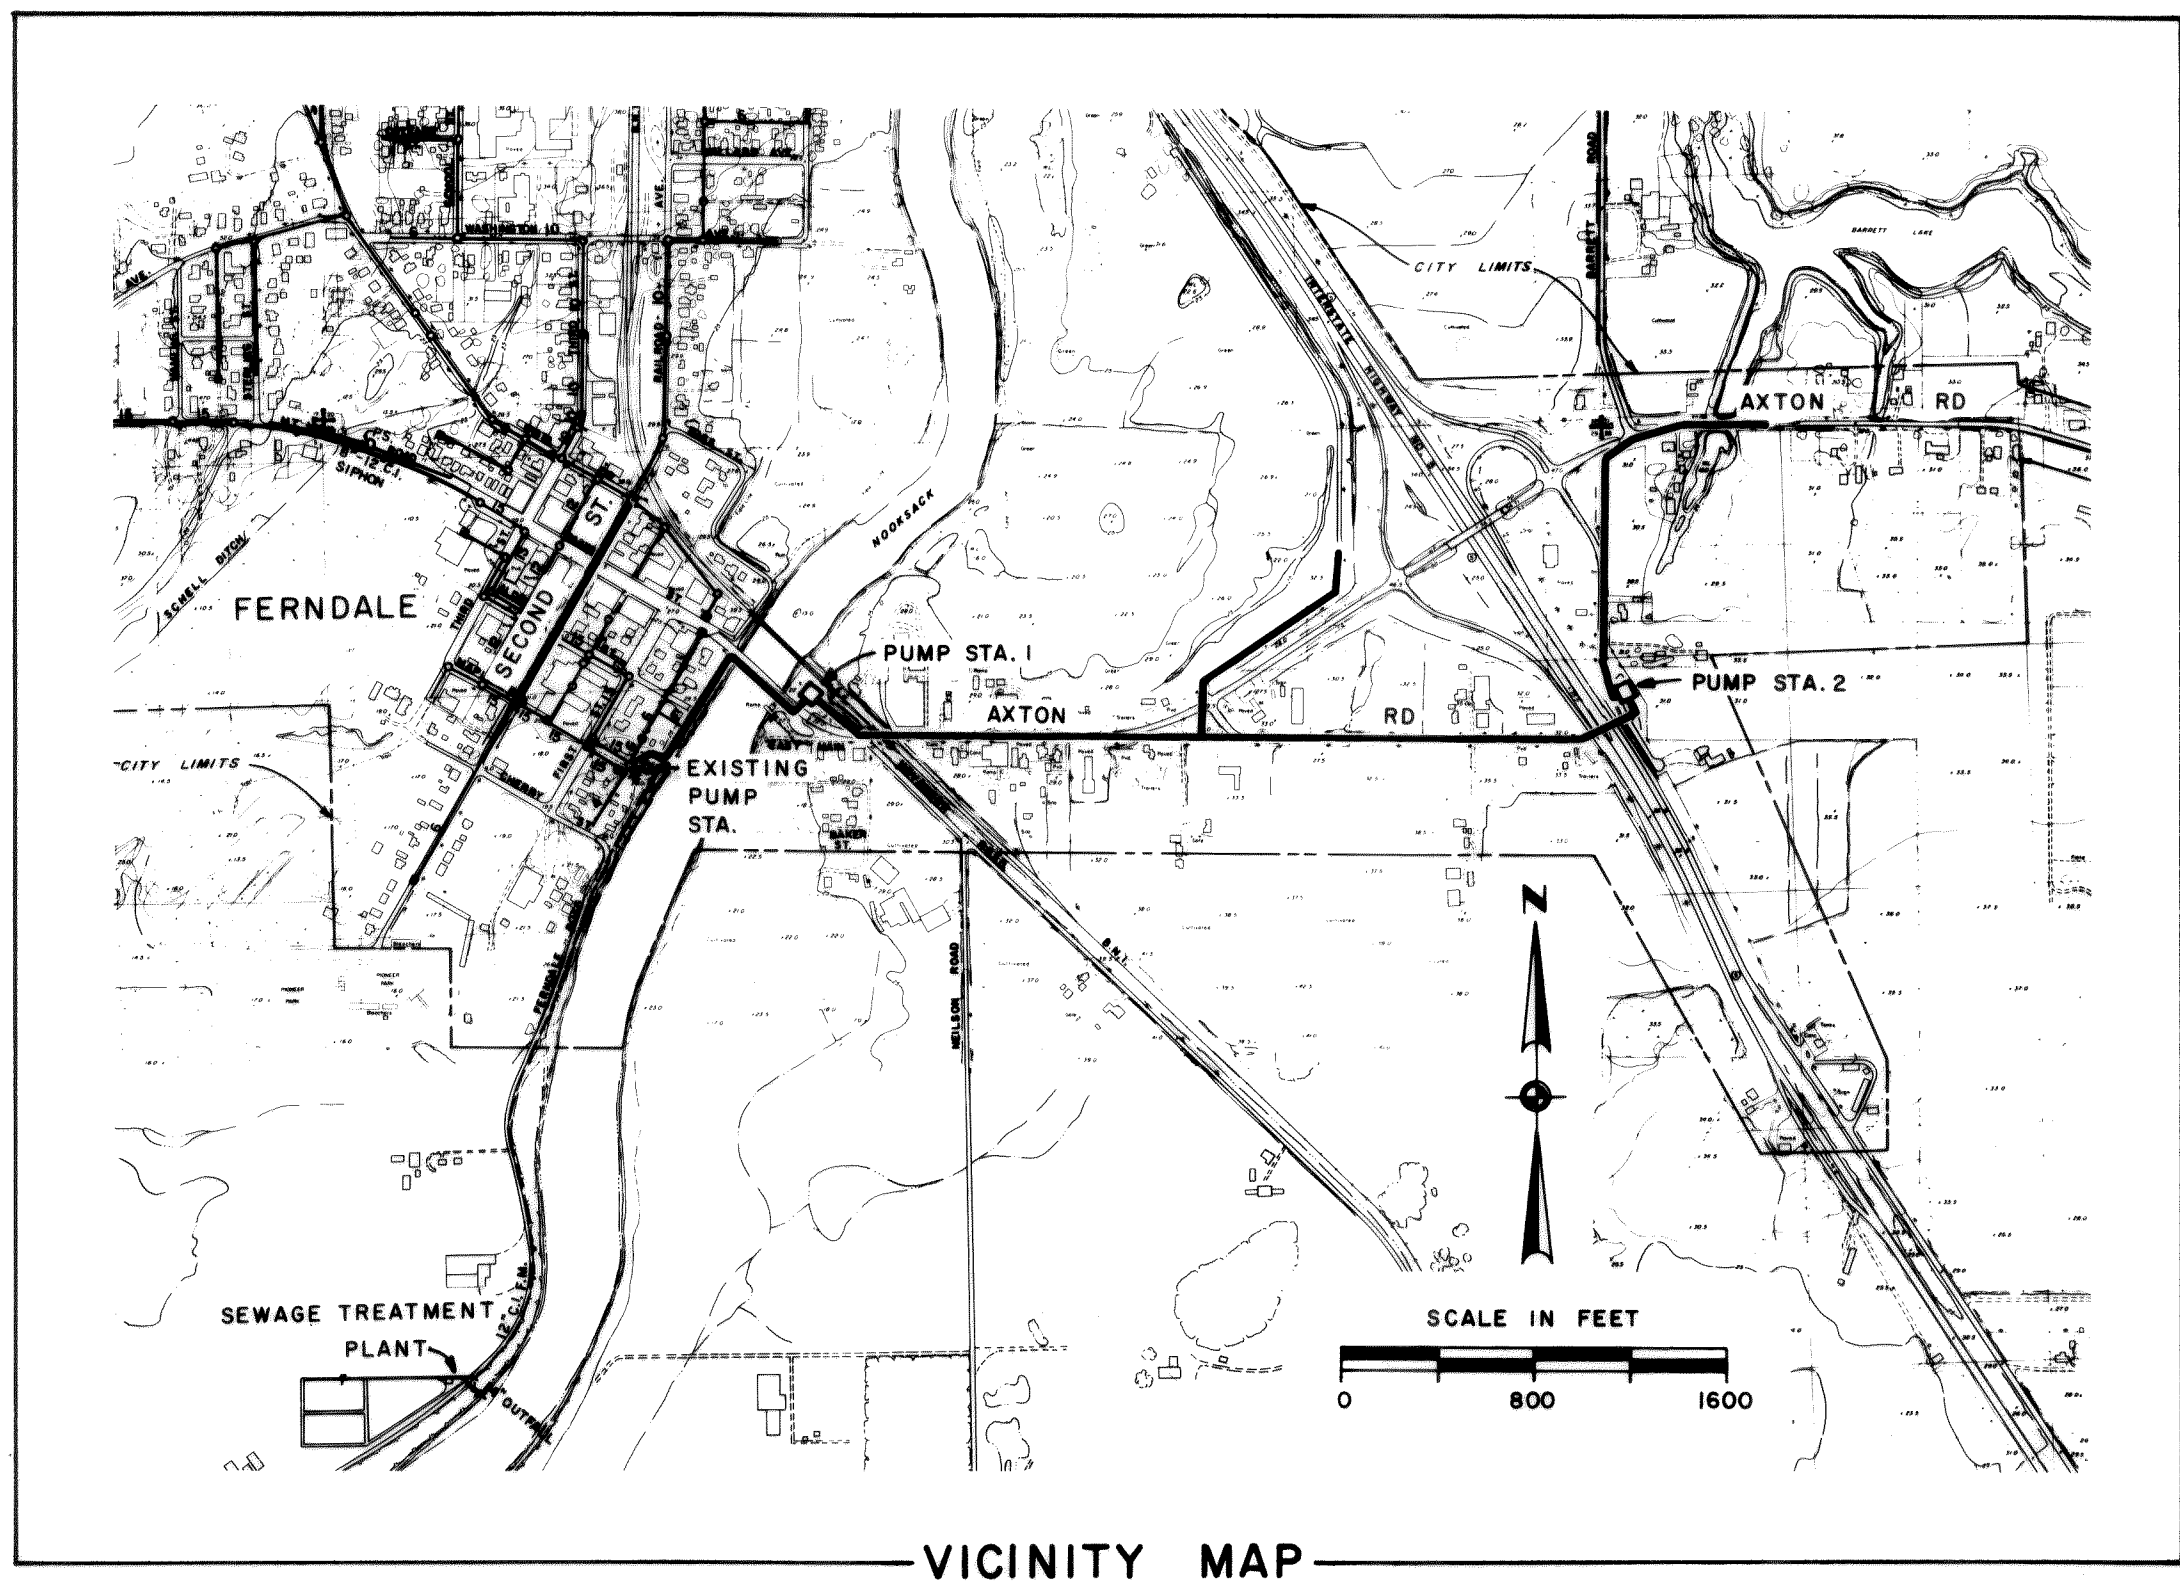

INDEX TO DRAWINGS








SHT. NO.	TITLE	SHT. NO.	TITLE
<u>SCHEDULE I</u>		<u>SCHEDULE I (CONT.)</u>	
GENERAL		ELECTRICAL	
G1	GENERAL NOTES & LEGEND	E1	VICINITY MAP & SITE PLAN-ELECTRICAL
G2	PUMP STATION 1 SITE PLAN	E2	EXISTING PUMP STATION EQUIPMENT REMOVAL
G3	PUMP STATION 2 SITE PLAN	E3	EXISTING PUMP STATION EQUIPMENT INSTALLATION
G4	PUMP STATION 1 & 2 LANDSCAPING PLAN	E4	EXISTING PUMP STATION NEW WORK ELECTRICAL ONE LINE DIAGRAM
G5	EXISTING SEWAGE TREATMENT PLANT MODIFICATIONS	E5	EXISTING PUMP STATION ELECTRICAL CONTROL SCHEMATICS
ARCHITECTURAL		E6	PUMP STATION 1 & 2 ELECTRICAL LIGHTING PLAN
A1	PUMP STATION 1 & 2 ARCHITECTURAL PLAN & ELEVATIONS	E7	PUMP STATION 1 & 2 ELECTRICAL SECTION & DETAILS
A2	PUMP STATION 1 & 2 ARCHITECTURAL DETAILS	E8	PUMP STATION 1 ELECTRICAL POWER PLAN
STRUCTURAL		E9	PUMP STATION 2 ELECTRICAL POWER PLAN
S1	PUMP STATION 1 & 2 STRUCTURAL ROOF & FLOOR PLANS	E10	PUMP STATION 1 & 2 ELECTRICAL ONE LINE DIAGRAMS
S2	PUMP STATION 1 & 2 STRUCTURAL WALL PLAN & SECTIONS	E11	PUMP STATION 1 & 2 ELECTRICAL CONTROL SCHEMATICS
S3	PUMP STATION 1 & 2 STRUCTURAL PLATFORM PLAN & DETAILS	<u>SCHEDULE II</u>	
S4	PUMP STATION 1 & 2 STRUCTURAL DETAILS	UTILITY	
S5	PUMP STATION 1 & 2 STRUCTURAL DETAILS	U1	FRONT STREET & AXTON ROAD PLAN & PROFILE
S6	PUMP STATION 1 & 2 STRUCTURAL DETAILS	U2	AXTON ROAD PLAN & PROFILE
MECHANICAL		U3	AXTON ROAD & GOLF COURSE ROAD PLAN & PROFILE
M1	EXISTING PUMP STATION MECHANICAL MODIFICATIONS	U4	SECOND STREET PLAN & PROFILE (DELETED)
M2	EXISTING PUMP STATION MECHANICAL MODIFICATIONS	U-4A	SEWER REPLACEMENT PLAN & PROFILE
M3	PUMP STATION 1 MECHANICAL PLANS	U5	NOOKSACK RIVER BRIDGE CROSSING
M4	PUMP STATION 1 MECHANICAL SECTIONS	U6	NOOKSACK RIVER BRIDGE CROSSING DETAILS
M5	PUMP STATION 1 MECHANICAL SECTION	U7	SEWER DETAILS
M6	PUMP STATION 2 PLANS	U8	SEWER DETAILS
M7	PUMP STATION 2 SECTIONS		
M8	PUMP STATION 2 SECTION		

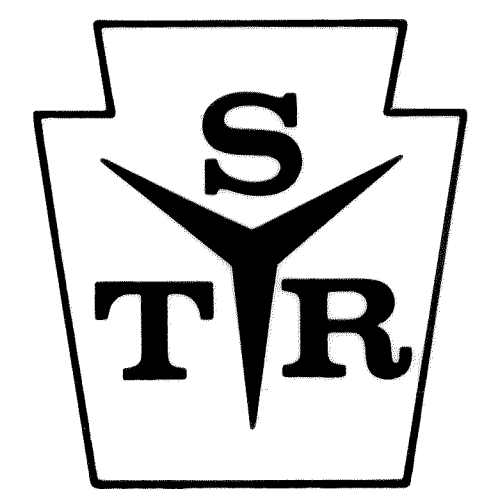

Stevens, Thompson & Runyan, Inc.
Engineers / Planners
 PORTLAND • SEATTLE • BOISE • ANCHORAGE

MICROFILMED
 MICROFILMED

       
GENERAL NOTES

1. ALL ELEVATIONS REFER TO MEAN SEA LEVEL.
2. DETAIL OR SECTION NUMBERING SYSTEM:
SEE SECT  DETAIL OR SECTION NUMBER.
SHEET NUMBER ON WHICH DETAIL OR SECTION NUMBER APPEARS.
SECTION  DETAIL OR SECTION NUMBER.
SHEET NUMBER ON WHICH DETAIL OR SECTION WAS TAKEN.
3. SCHEDULE II
1. ALL SEWER LINE DIMENSIONS ARE HORIZONTAL DISTANCES.
2. ALL TRENCHING, BEDDING, BACKFILL AND SURFACE RESTORATION SHALL BE IN ACCORDANCE WITH DETAILS —  AND  UNLESS OTHERWISE NOTED.
3. ALL MANHOLES SHALL BE IN ACCORDANCE WITH DETAILS —     AND  UNLESS OTHERWISE NOTED.
4. WHERE STUBS IN MH'S ARE INDICATED ON THE PLANS THEY SHALL BE IN ACCORDANCE WITH DETAIL 
5. REPLACE ALL PRIVATE SIDEWALKS, STEPS AND DRIVEWAYS TO MATCH EXISTING. (SEE SPECIFICATIONS).
6. LOCATIONS OF EXISTING UTILITIES ARE APPROXIMATE ONLY AND MAY NOT BE SHOWN. IT SHALL BE THE CONTRACTOR'S RESPONSIBILITY TO DETERMINE THE EXACT LOCATION OF ALL UTILITIES WITHIN THE CONSTRUCTION LIMITS.
7. INSTALL SIDE SEWERS TO EDGE OF RIGHT OF WAY IN LOCATIONS SHOWN ON PLANS. CONSTRUCT IN ACCORDANCE WITH DETAIL 


LEGEND

EXISTING	THIS CONTRACT


- NOTE:
1. PREDICTED 100YR FLOOD ELEV 26.5
 2. FOR LOCATION OF SCHEDULE II MANHOLES, FORCE MAIN & SEWER SEE SHT U1 & U5

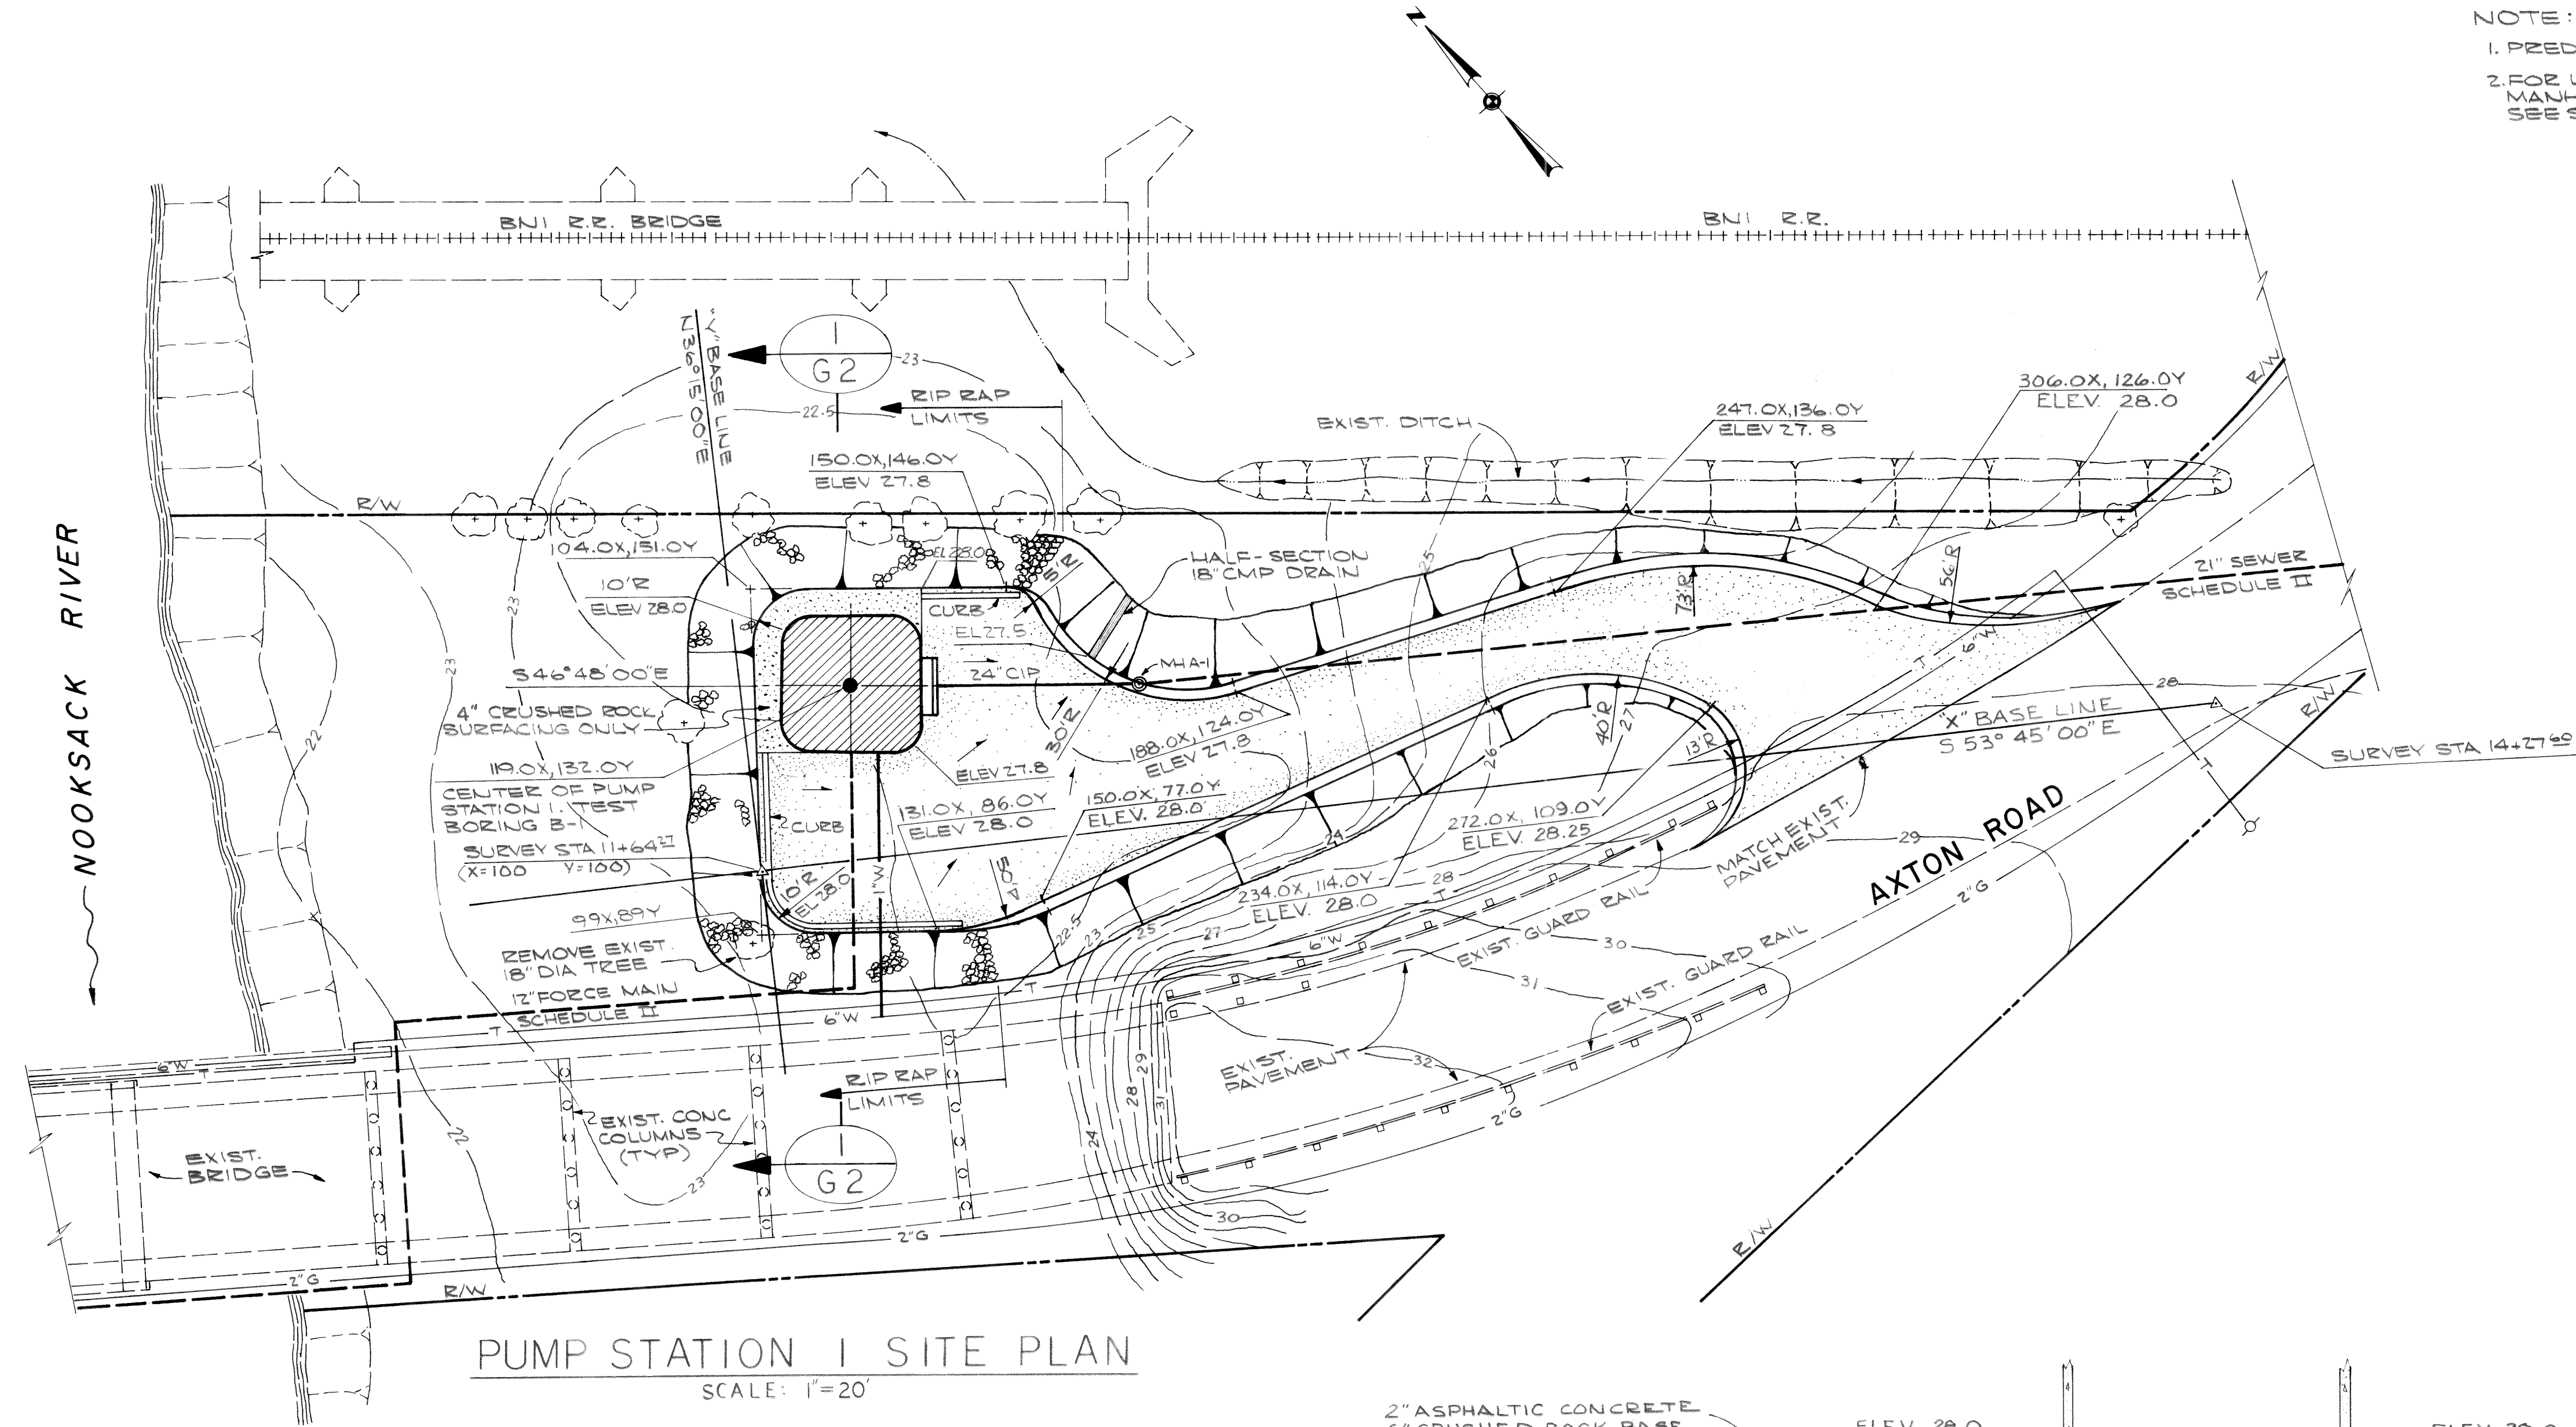


PUMP STATION I SITE PLAN
SCALE: 1"=20'

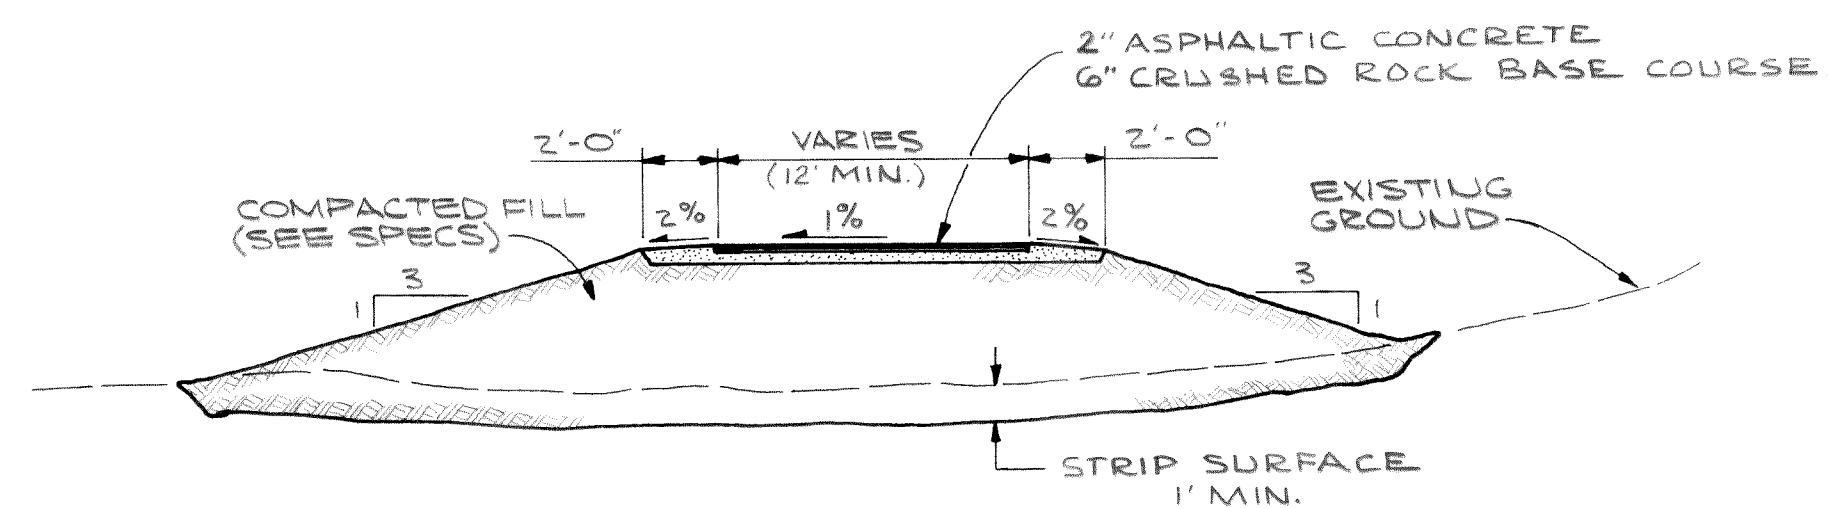

PUMP STATION I ACCESS ROAD
NO SCALE

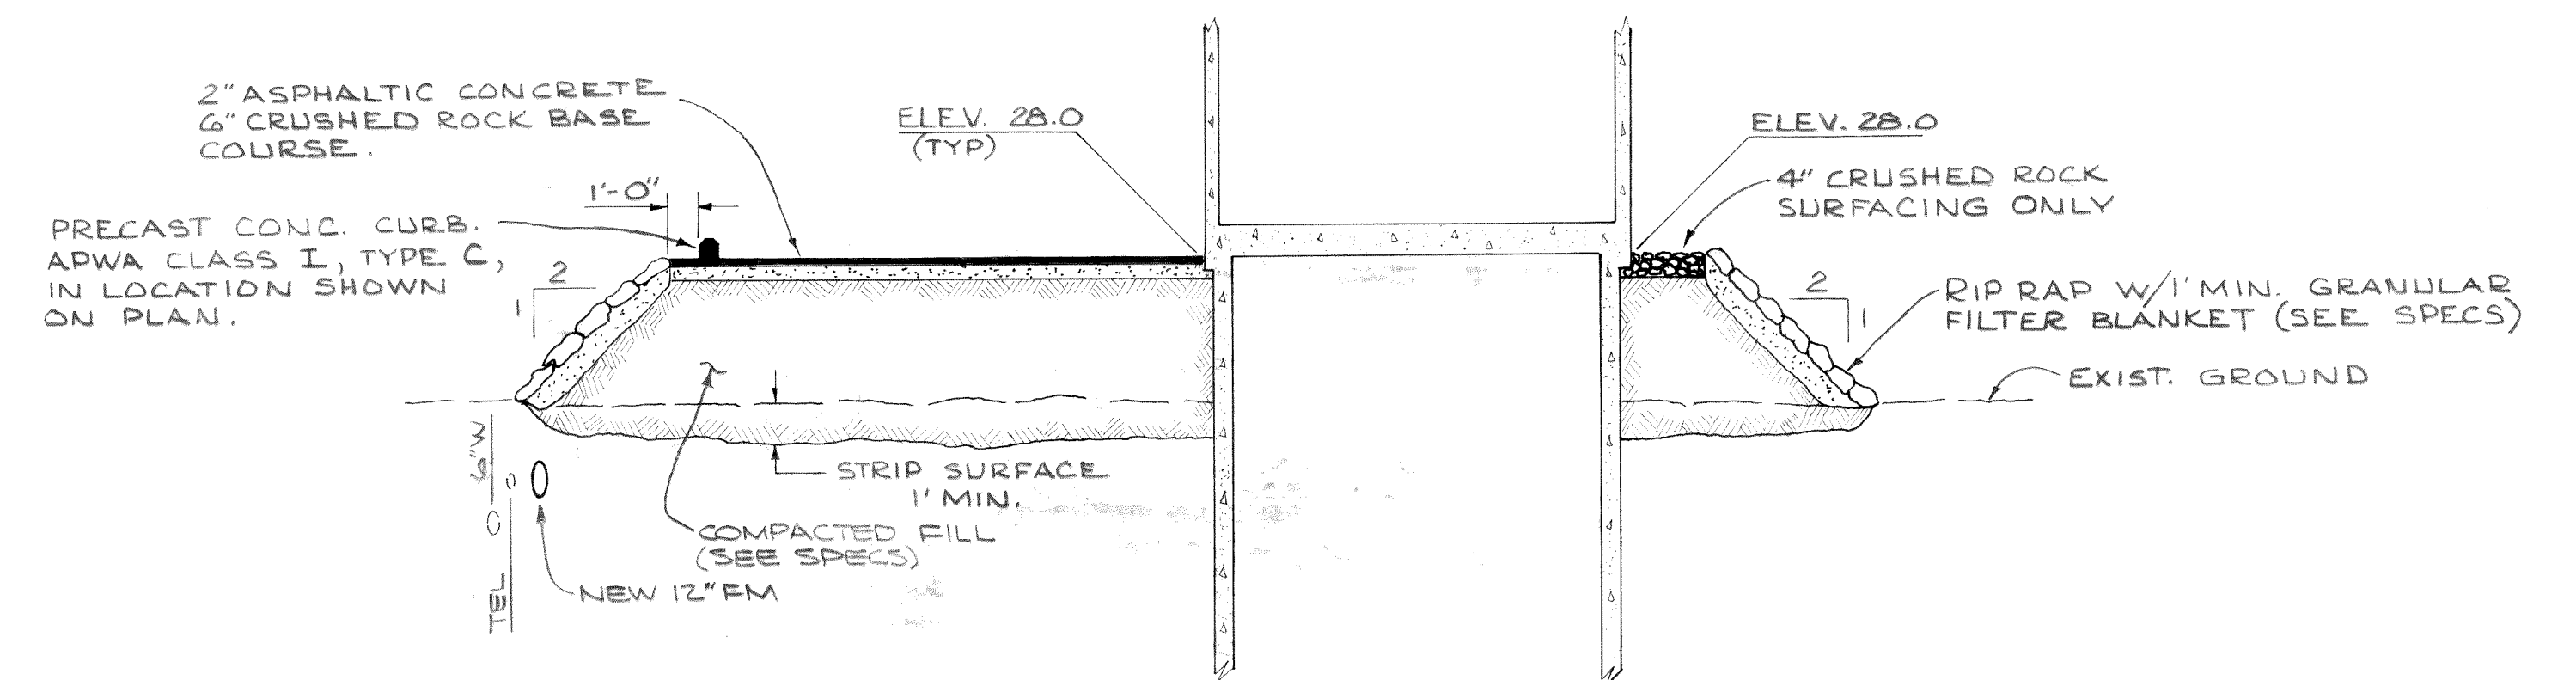

PUMP STATION I PARKING AREA
NO SCALE

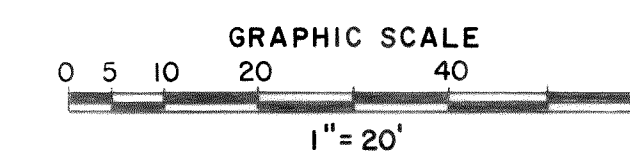

DESIGNED T.S.	APPROVED <i>Ted Stricklin</i>
DRAWN J.M.H.	SCALE AS SHOWN DATE JULY, 1972
CHECKED <i>HTG</i>	FILE 71-S-425.002



Stevens, Thompson & Runyan, Inc.
Engineers/Planners
PORTLAND SEATTLE BOISE


TOWN OF FERNDALE, WASHINGTON
AXTON ROAD INTERCEPTOR
SCHEDULE I

PUMP STATION I
SITE PLAN


G2
5

MICROFILMED


00210.004 2-7-66 K/L

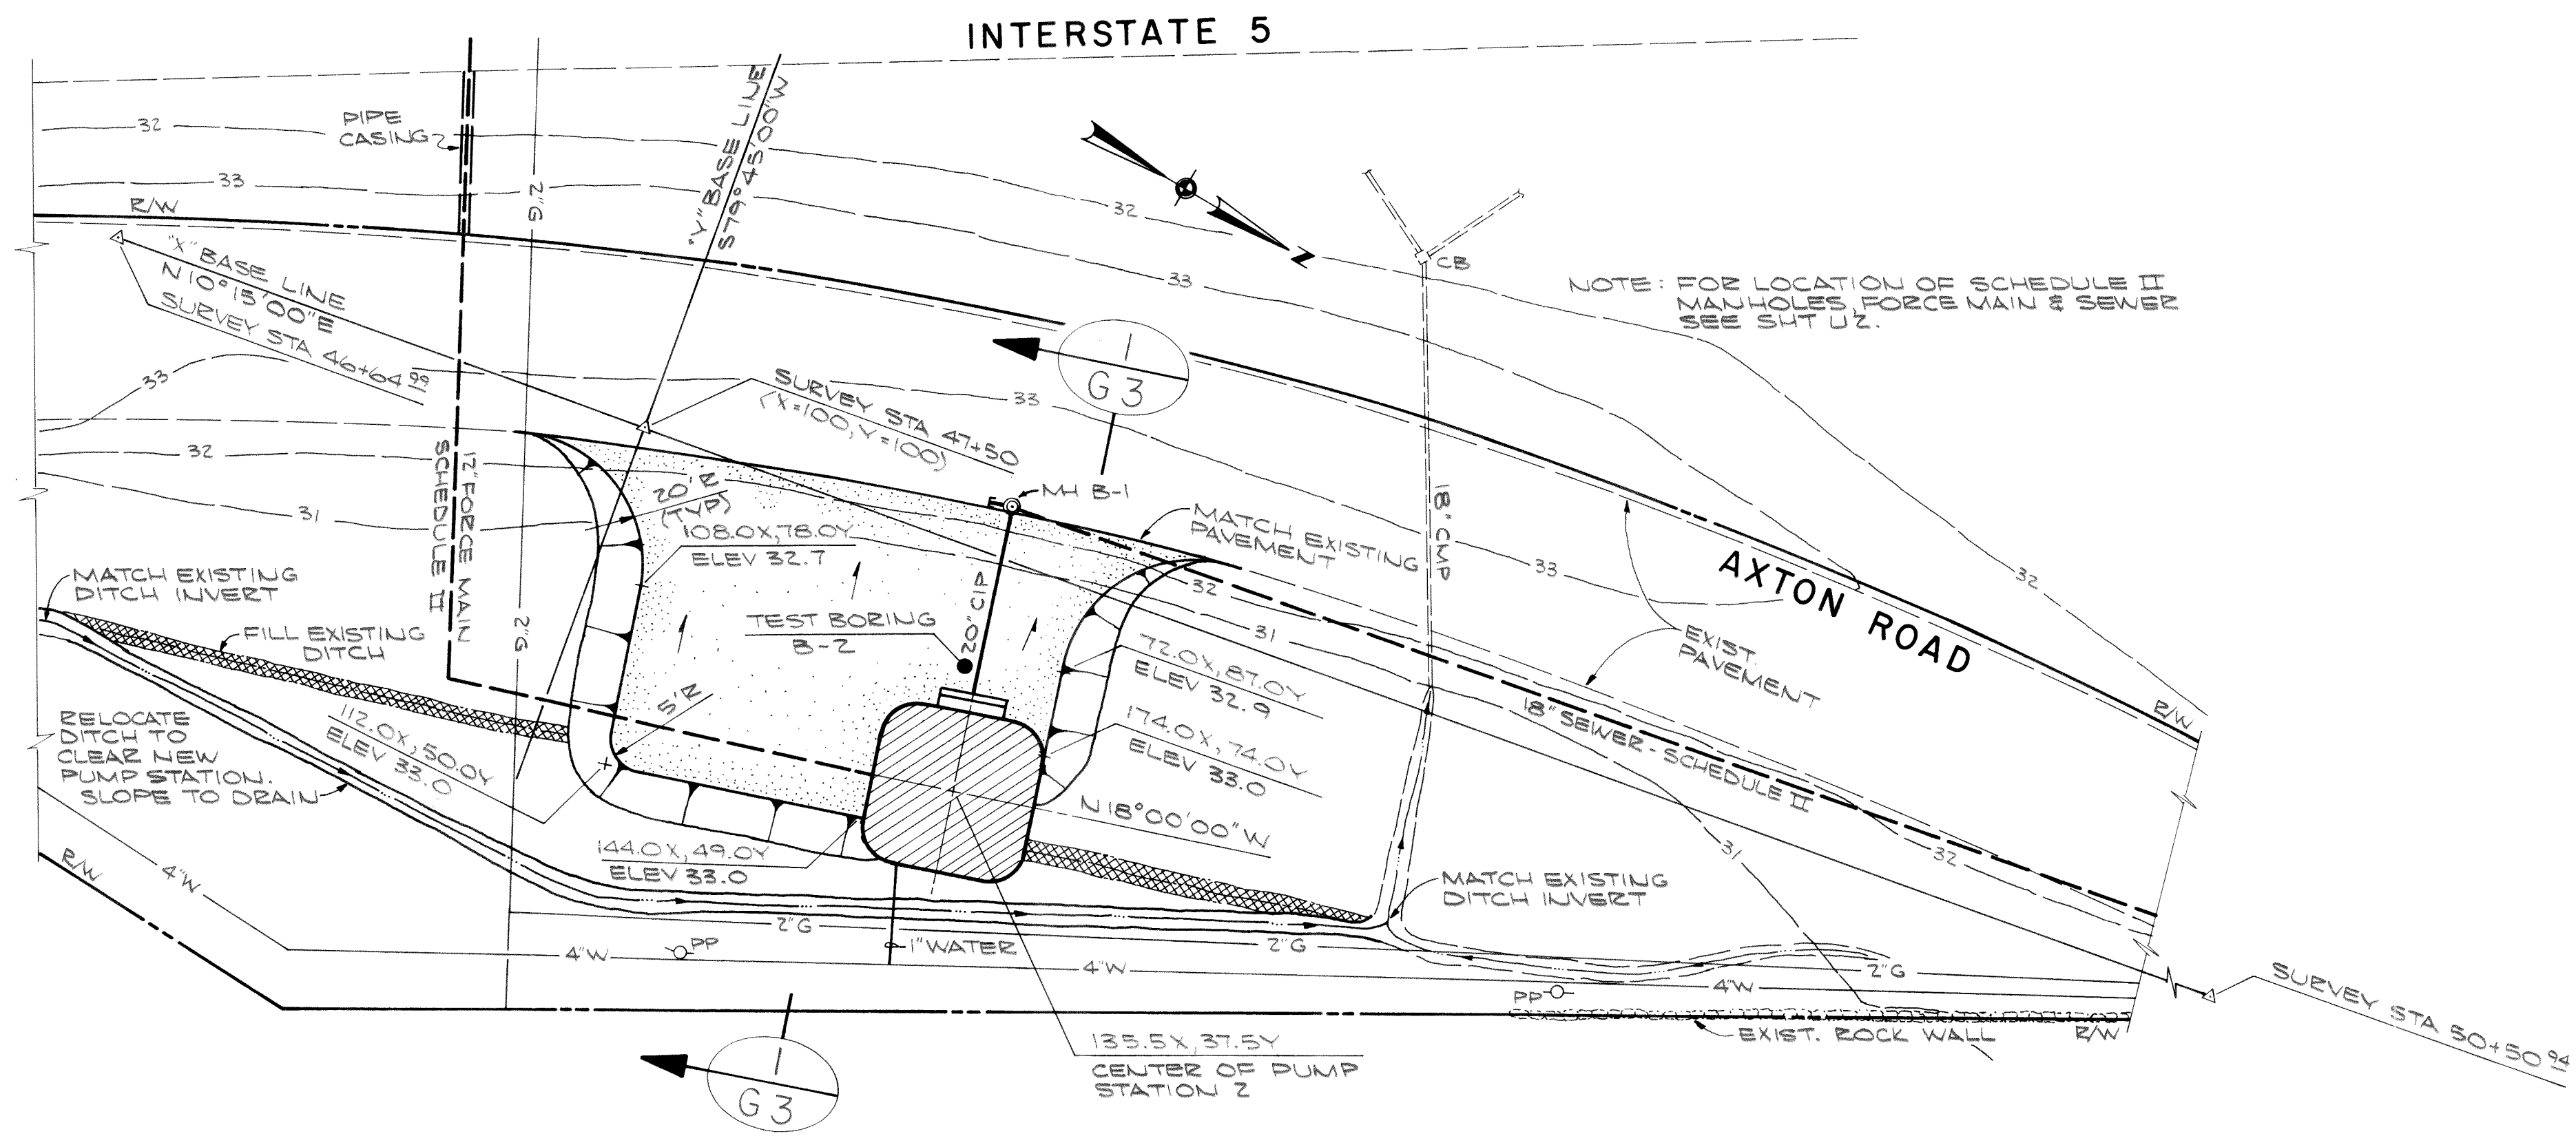


PUMP STATION 2 SITE PLAN
SCALE: 1"=20'

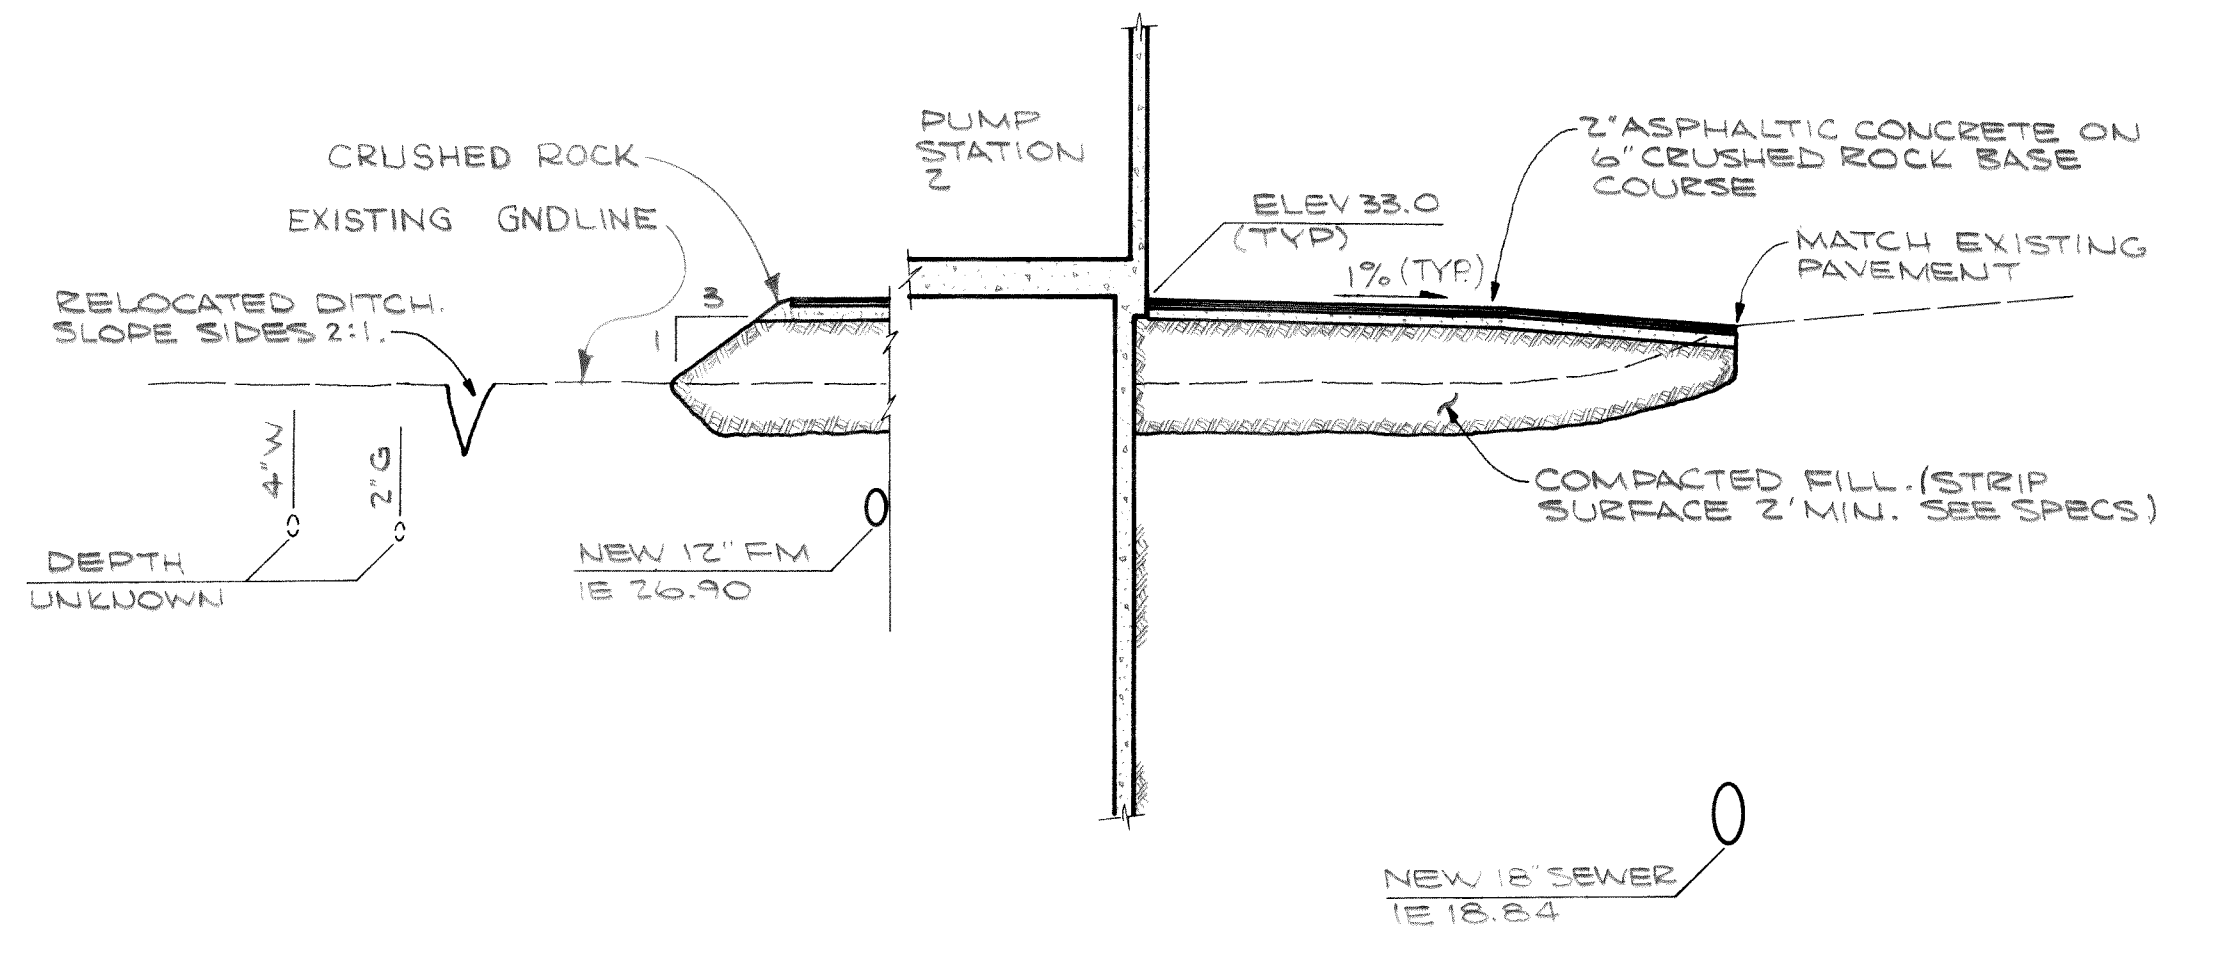

PUMP STATION 2 SITE SECTION
NO SCALE

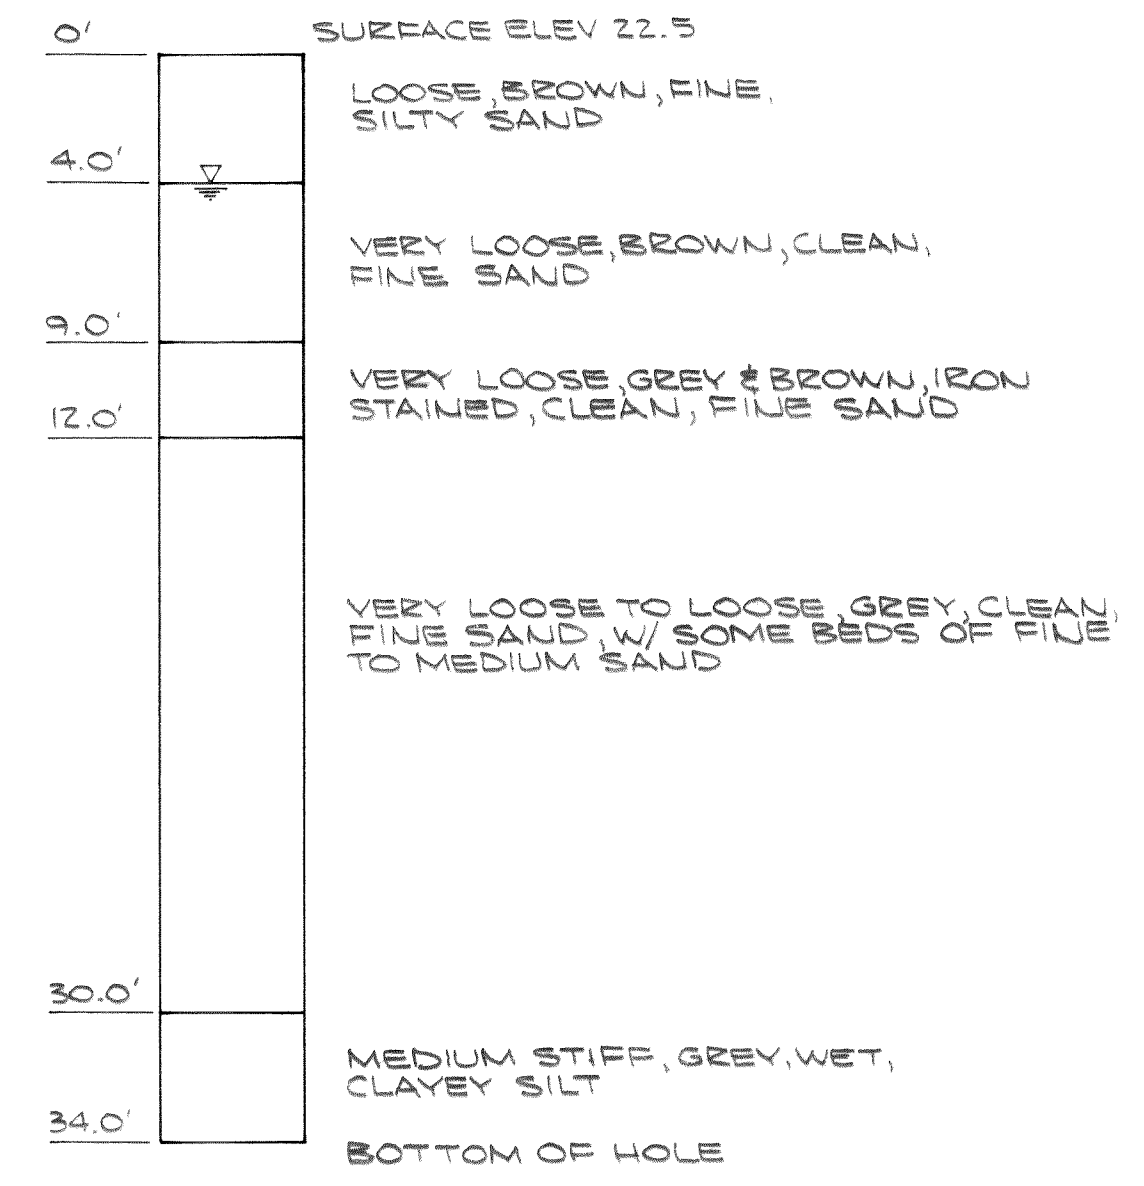


TEST BORING B-1

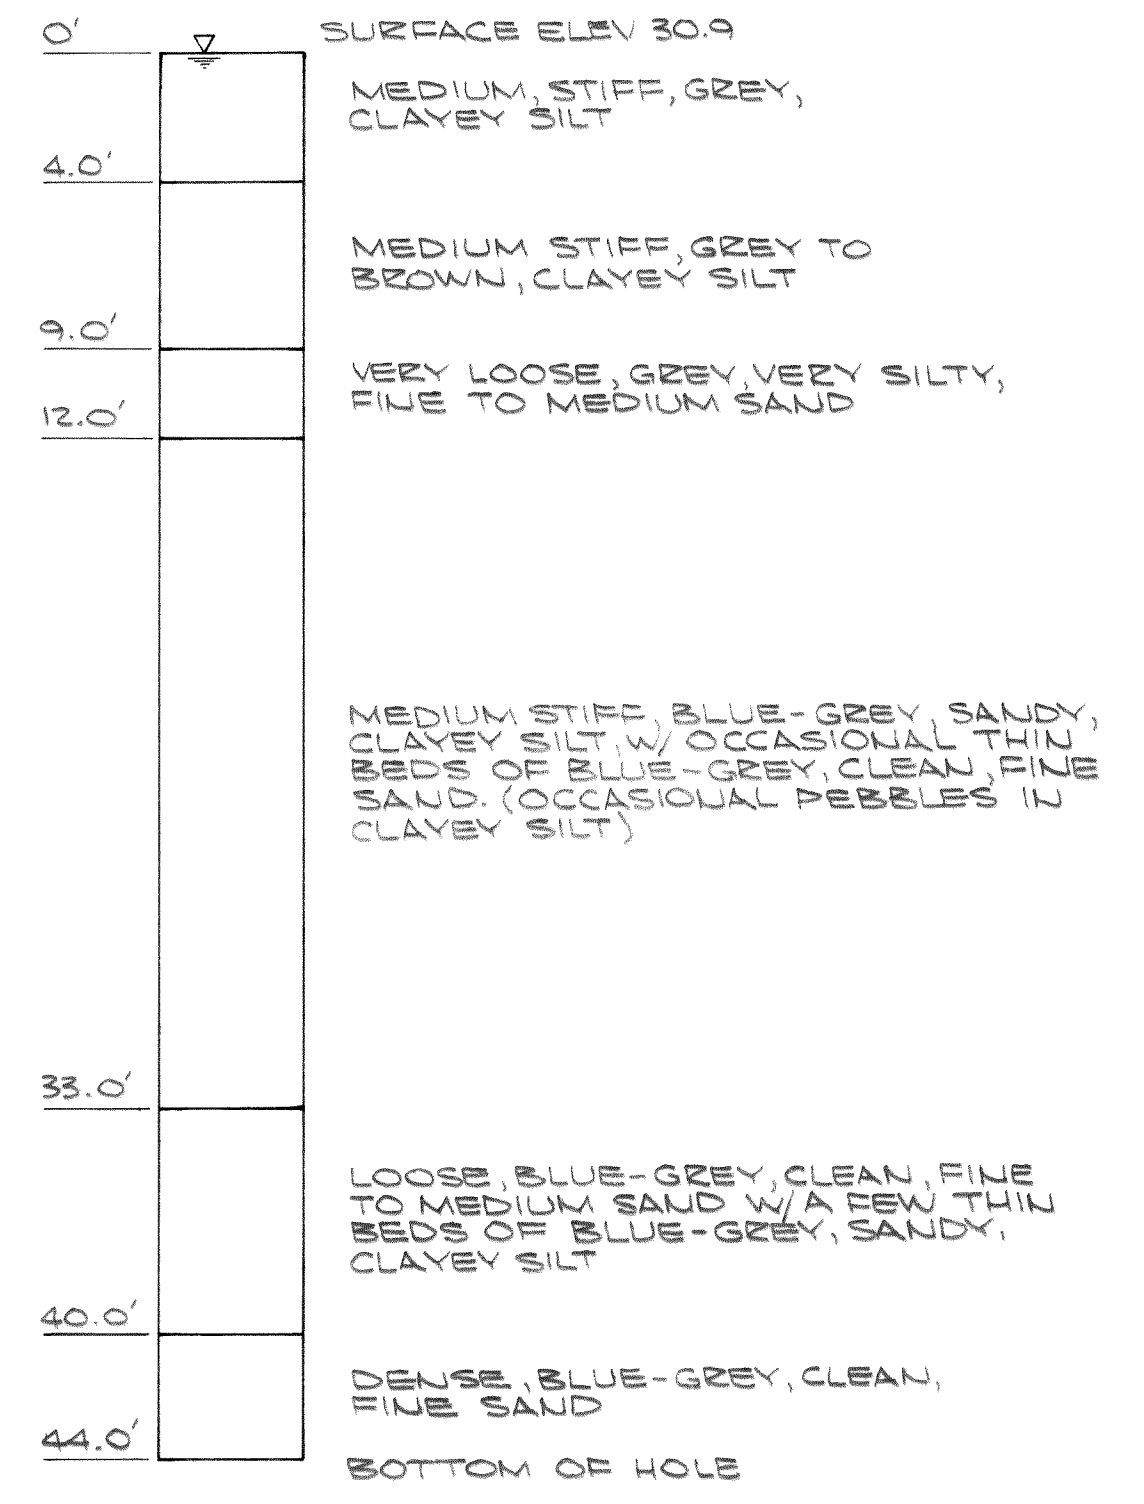



TEST BORING B-2

NOTE:
TEST HOLES HAVE BEEN BORED TO INDICATE SUBSURFACE MATERIALS AT PARTICULAR LOCATIONS AND ARE SHOWN ON THE PLANS. INVESTIGATIONS CONDUCTED OF SUBSURFACE CONDITIONS ARE FOR THE PURPOSE OF STUDY AND DESIGN, AND NEITHER THE TOWN OF FERNDAL NOR THE CONSULTANT ASSUMES ANY RESPONSIBILITY WHATEVER IN RESPECT TO THE SUFFICIENCY OR ACCURACY OF THE BORINGS THUS MADE, OR OF THE LOG OF TEST BORINGS, OR OF OTHER INVESTIGATIONS, OR OF THE INTERPRETATION MADE THEREOF; AND THERE IS NO WARRANTY OR GUARANTEE, EITHER EXPRESSED OR IMPLIED, THAT THE CONDITIONS INDICATED BY SUCH INVESTIGATIONS ARE REPRESENTATIVE OF THOSE EXISTING THROUGHOUT SUCH AREA, OR ANY PART THEREOF, OR THAT UNLOOKED FOR DEVELOPMENTS MAY OCCUR.

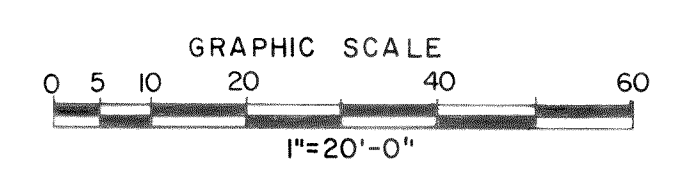


				DESIGNED T. S.	APPROVED <i>Ted Stricklin</i>		Stevens, Thompson & Runyan, Inc. <i>Engineers/Planners</i> PORTLAND SEATTLE BOISE	TOWN OF AXTON	FERNDAL, WASHINGTON ROAD INTERCEPTOR SCHEDULE I	PUMP STATION 2 SITE PLAN	G3 5	
				DRAWN J. M. H.	SCALE AS SHOWN							DATE JULY, 1972
DATE	NO.	REVISION	BY	CHECKED <i>TH</i>	FILE 71-S-425.002							

MICROFILMED

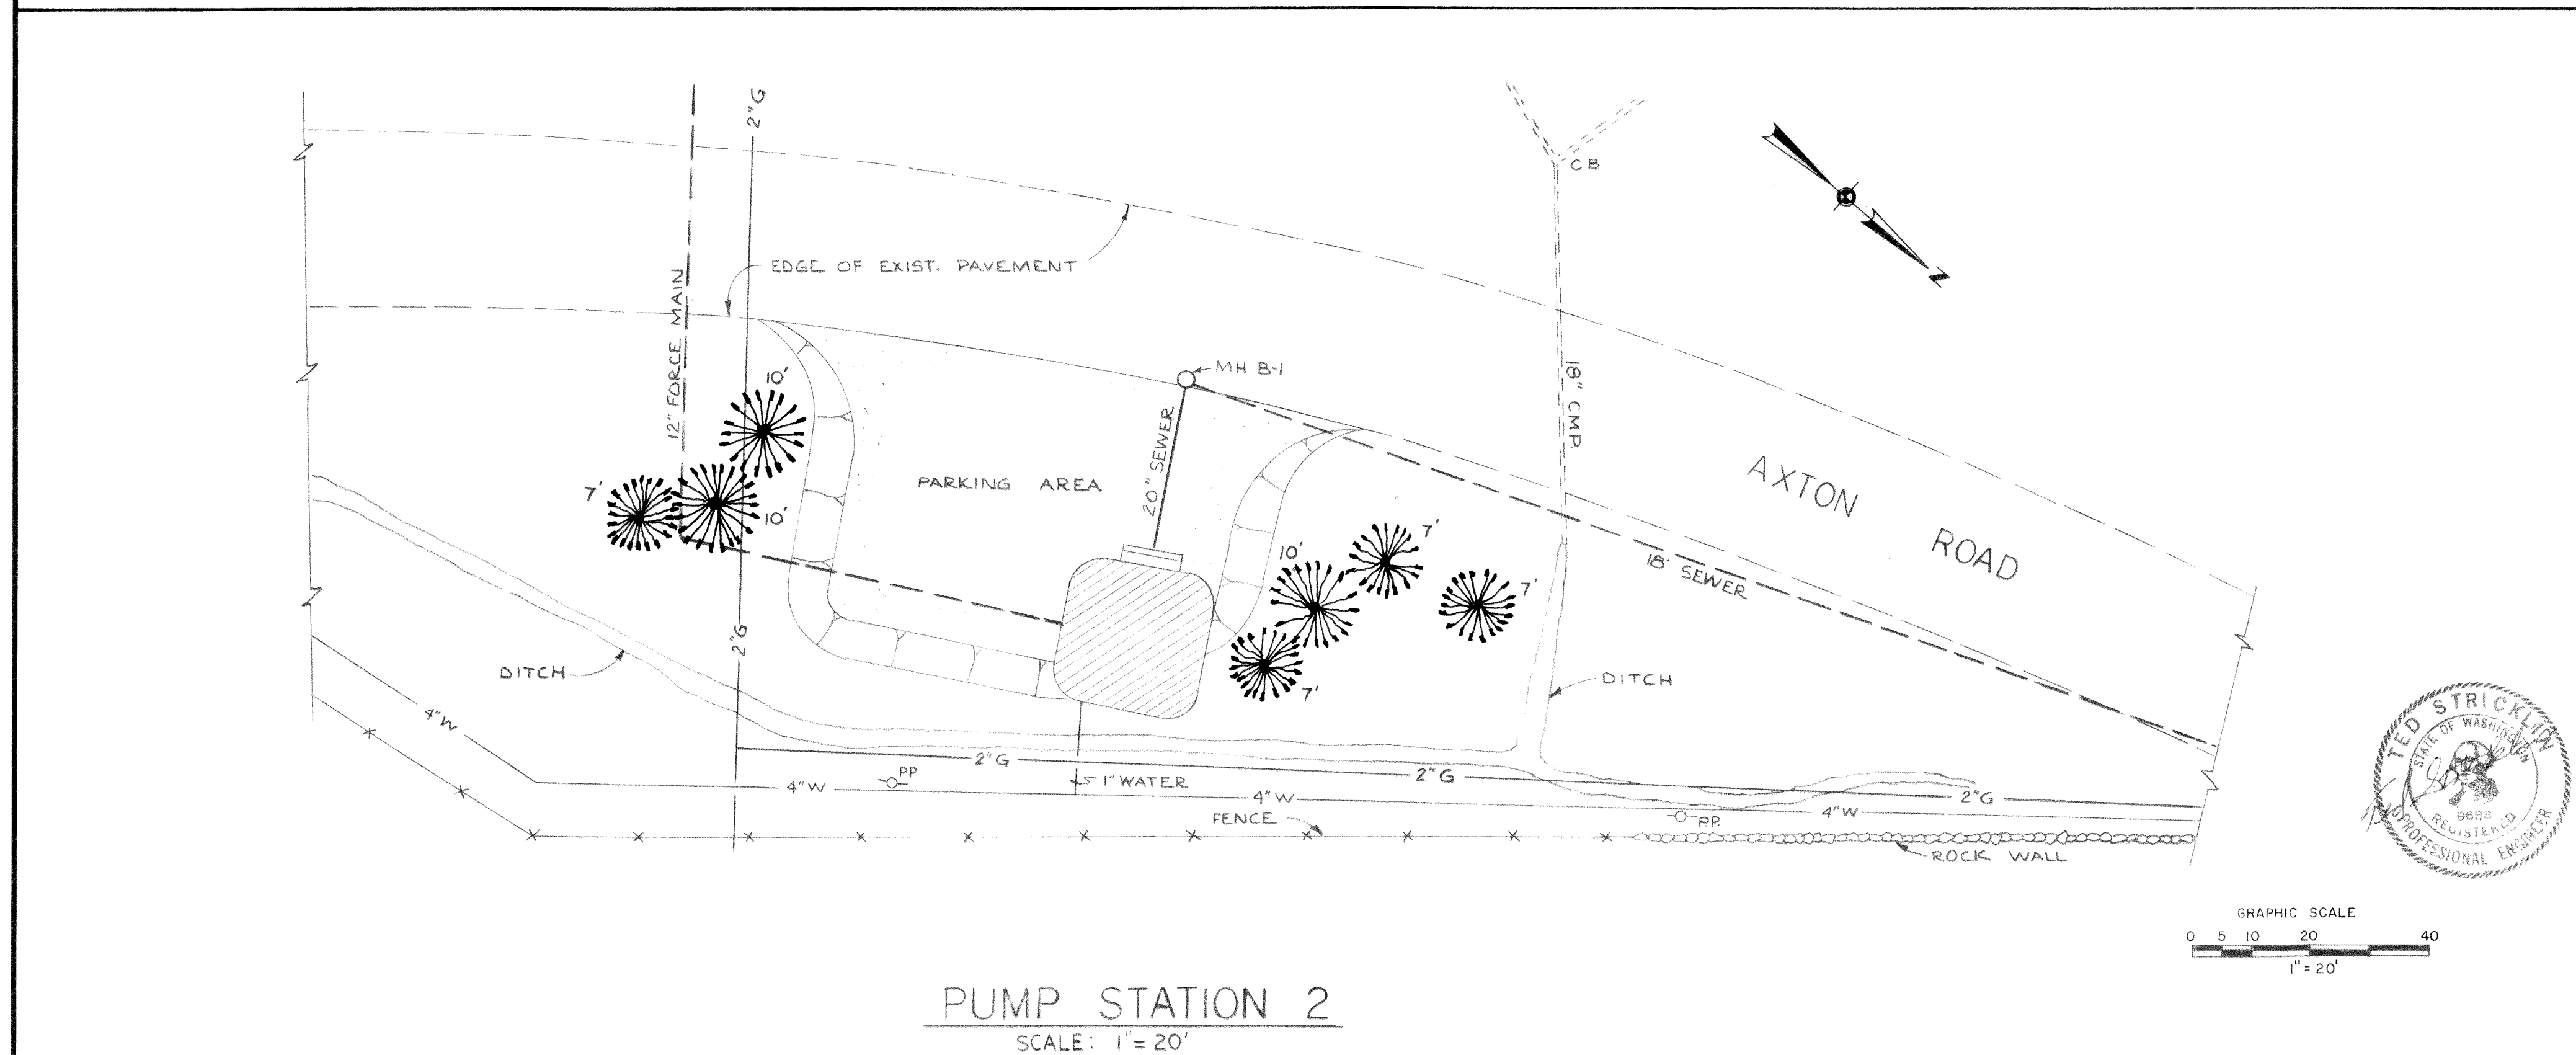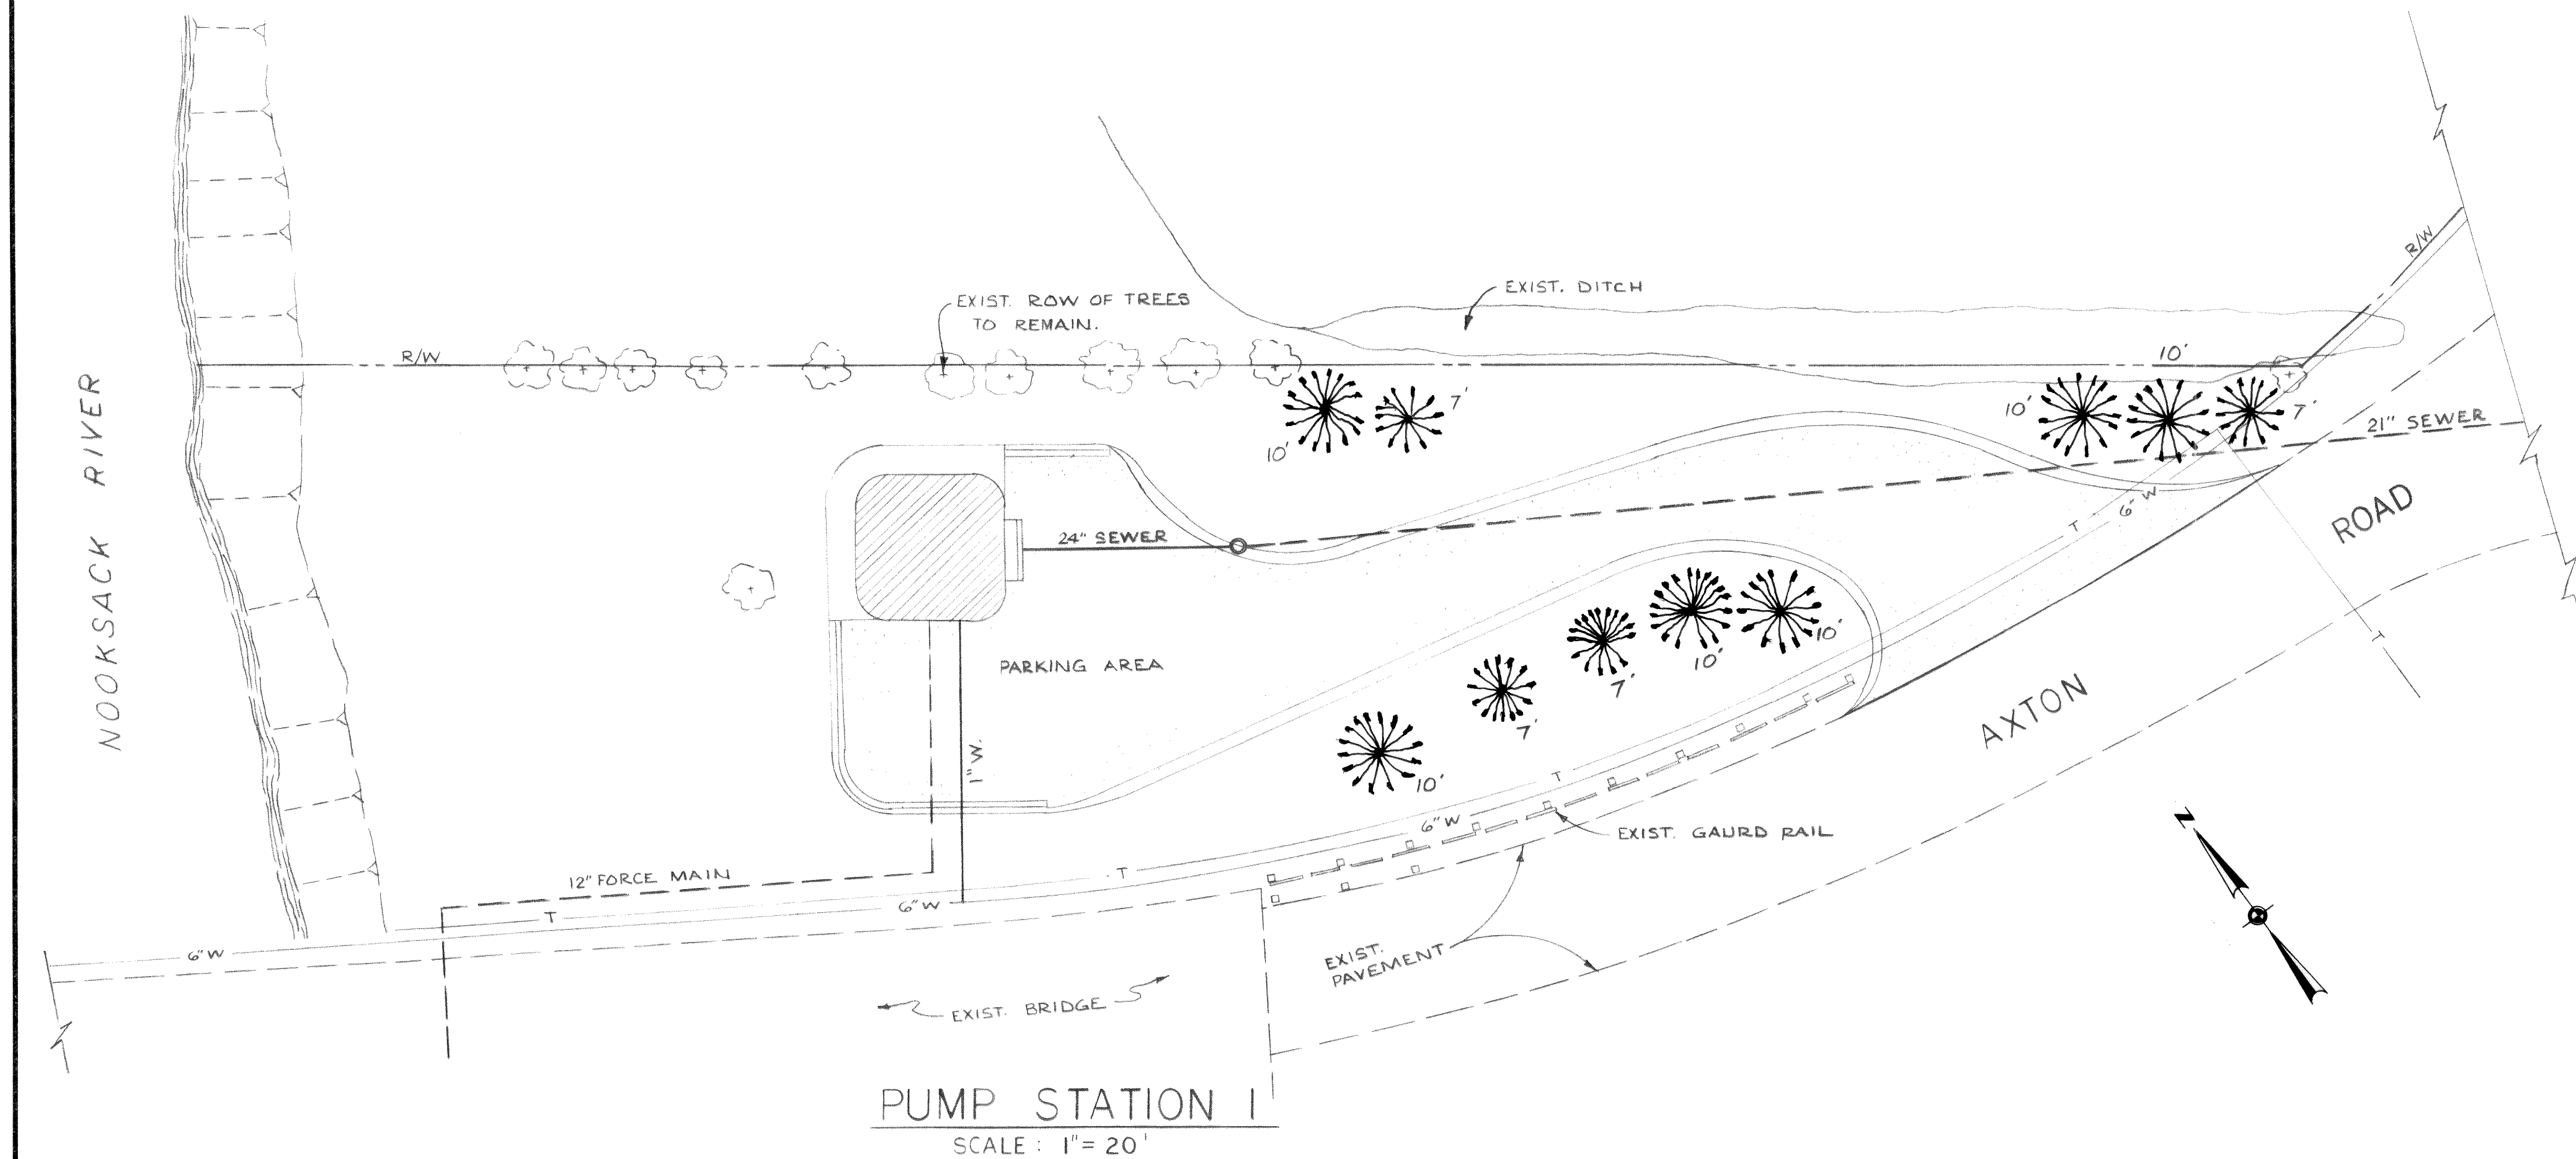


NOTES:

- ALL SLOPE AREAS SHALL BE SEEDED WITH MIXTURE AS SPECIFIED. ALL "RAW" AREAS LEFT AS A RESULT OF CONSTRUCTION ACTIVITIES SHALL BE SEEDED WITH THE SPECIFIED SEED MIXTURE MINUS THE DOUGLAS FIR SEED INGREDIENT.
- TREES ON THE PLANS ARE SHOWN IN THEIR APPROXIMATE LOCATIONS. STAKE LOCATIONS PRIOR TO PLANTING FOR APPROVAL BY THE ENGINEER. ADJUSTMENTS SHALL BE MADE IN THE FIELD AS NECESSARY.

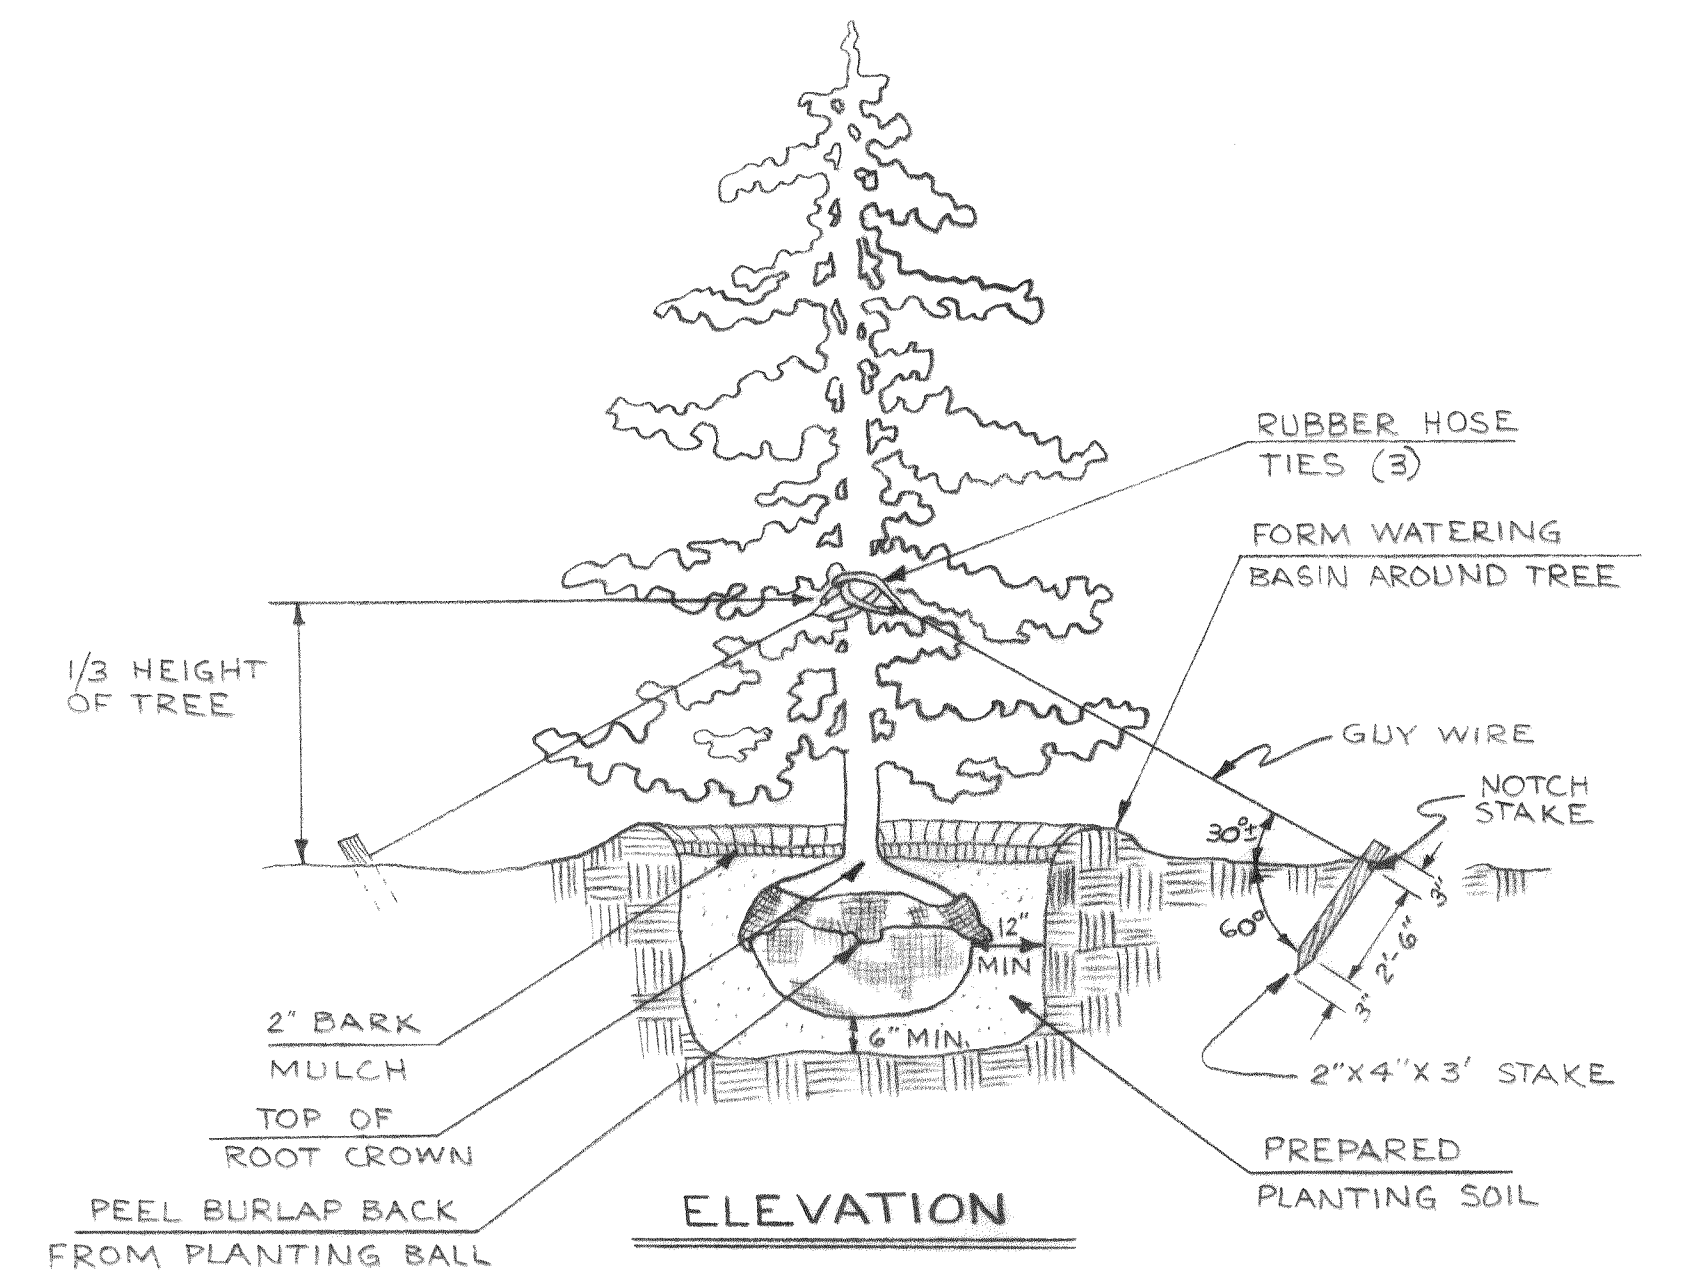

NOTE:

THE THREE GUY WIRES SHALL CONSIST OF 2 STRANDS OF 12 GAGE GALV. WIRE, TWISTED TOGETHER TO TAKE UP THE FASTENING SLACK.

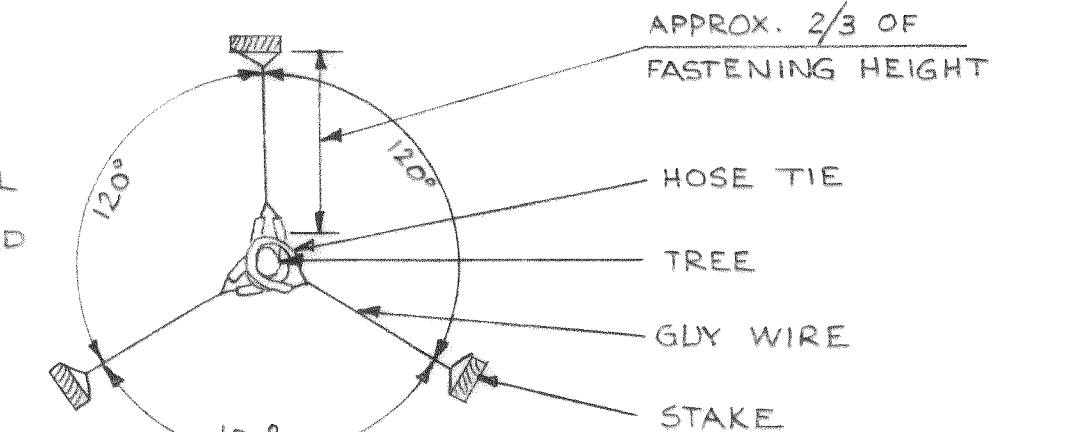

EVERGREEN TREE PLANTING AND GUYING

PLANT MATERIAL

BOTANICAL NAME	COMMON NAME	QUANT	SIZE	SPEC.	SPAC'G.
PSEUDOTSUGA MENZIESII	DOUGLAS FIR	8	10'	B & B	AS SHOWN
PSEUDOTSUGA MENZIESII	DOUGLAS FIR	9	7'	B & B	AS SHOWN

SEED MIXTURE

BOTANICAL NAME	COMMON NAME	% OF MIXTURE BY WEIGHT
FESTUCA RUBRA	RED FESCUE	40%
AGROSTIS TENNIS	COLONIAL BENTGRASS	5%
LOLIUM PERENE	PERNIAL RYE	35%
TRIFOLIUM REPENS	WHITE CLOVER	10%
PSEUDOTSUGA MENZIESII	DOUGLAS FIR	10%

DESIGNED	L.A.W.	APPROVED	<i>Paul Hornum</i>
DRAWN	J.L.B.	SCALE	AS SHOWN
DATE	JULY, 1972	FILE	71-425.002

Stevens, Thompson & Runyan, Inc.
Engineers/Planners
PORTLAND SEATTLE BOISE







TOWN OF FERNDAL, WASHINGTON
AXTON ROAD INTERCEPTOR
SCHEDULE I

PUMP STATION 1 & 2
LANDSCAPING PLAN

G4
5


MICROFILMED

- NOTES:
1. Relocate Float Type Flow Transmitter From Distribution Structure To Chlorination Building. Locate Per Manufacturer's Requirements.
 2. Recalibrate Transmitter and Flow Recorder.
 3. Abandon Existing Cable From Flow Recorder To Distribution Structure
 4. Thoroughly Clean Top Surface of Distribution Box. Apply Colma Fix Bonding Compound To Mating Surface Per Manufacturer's Requirements

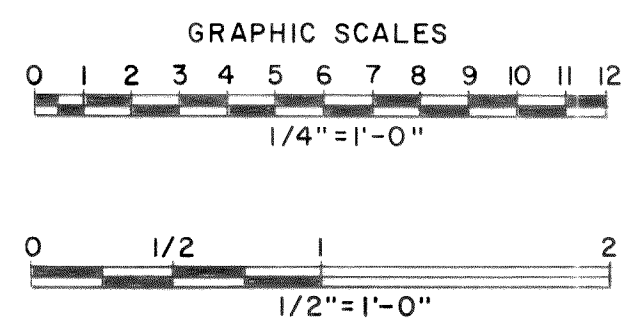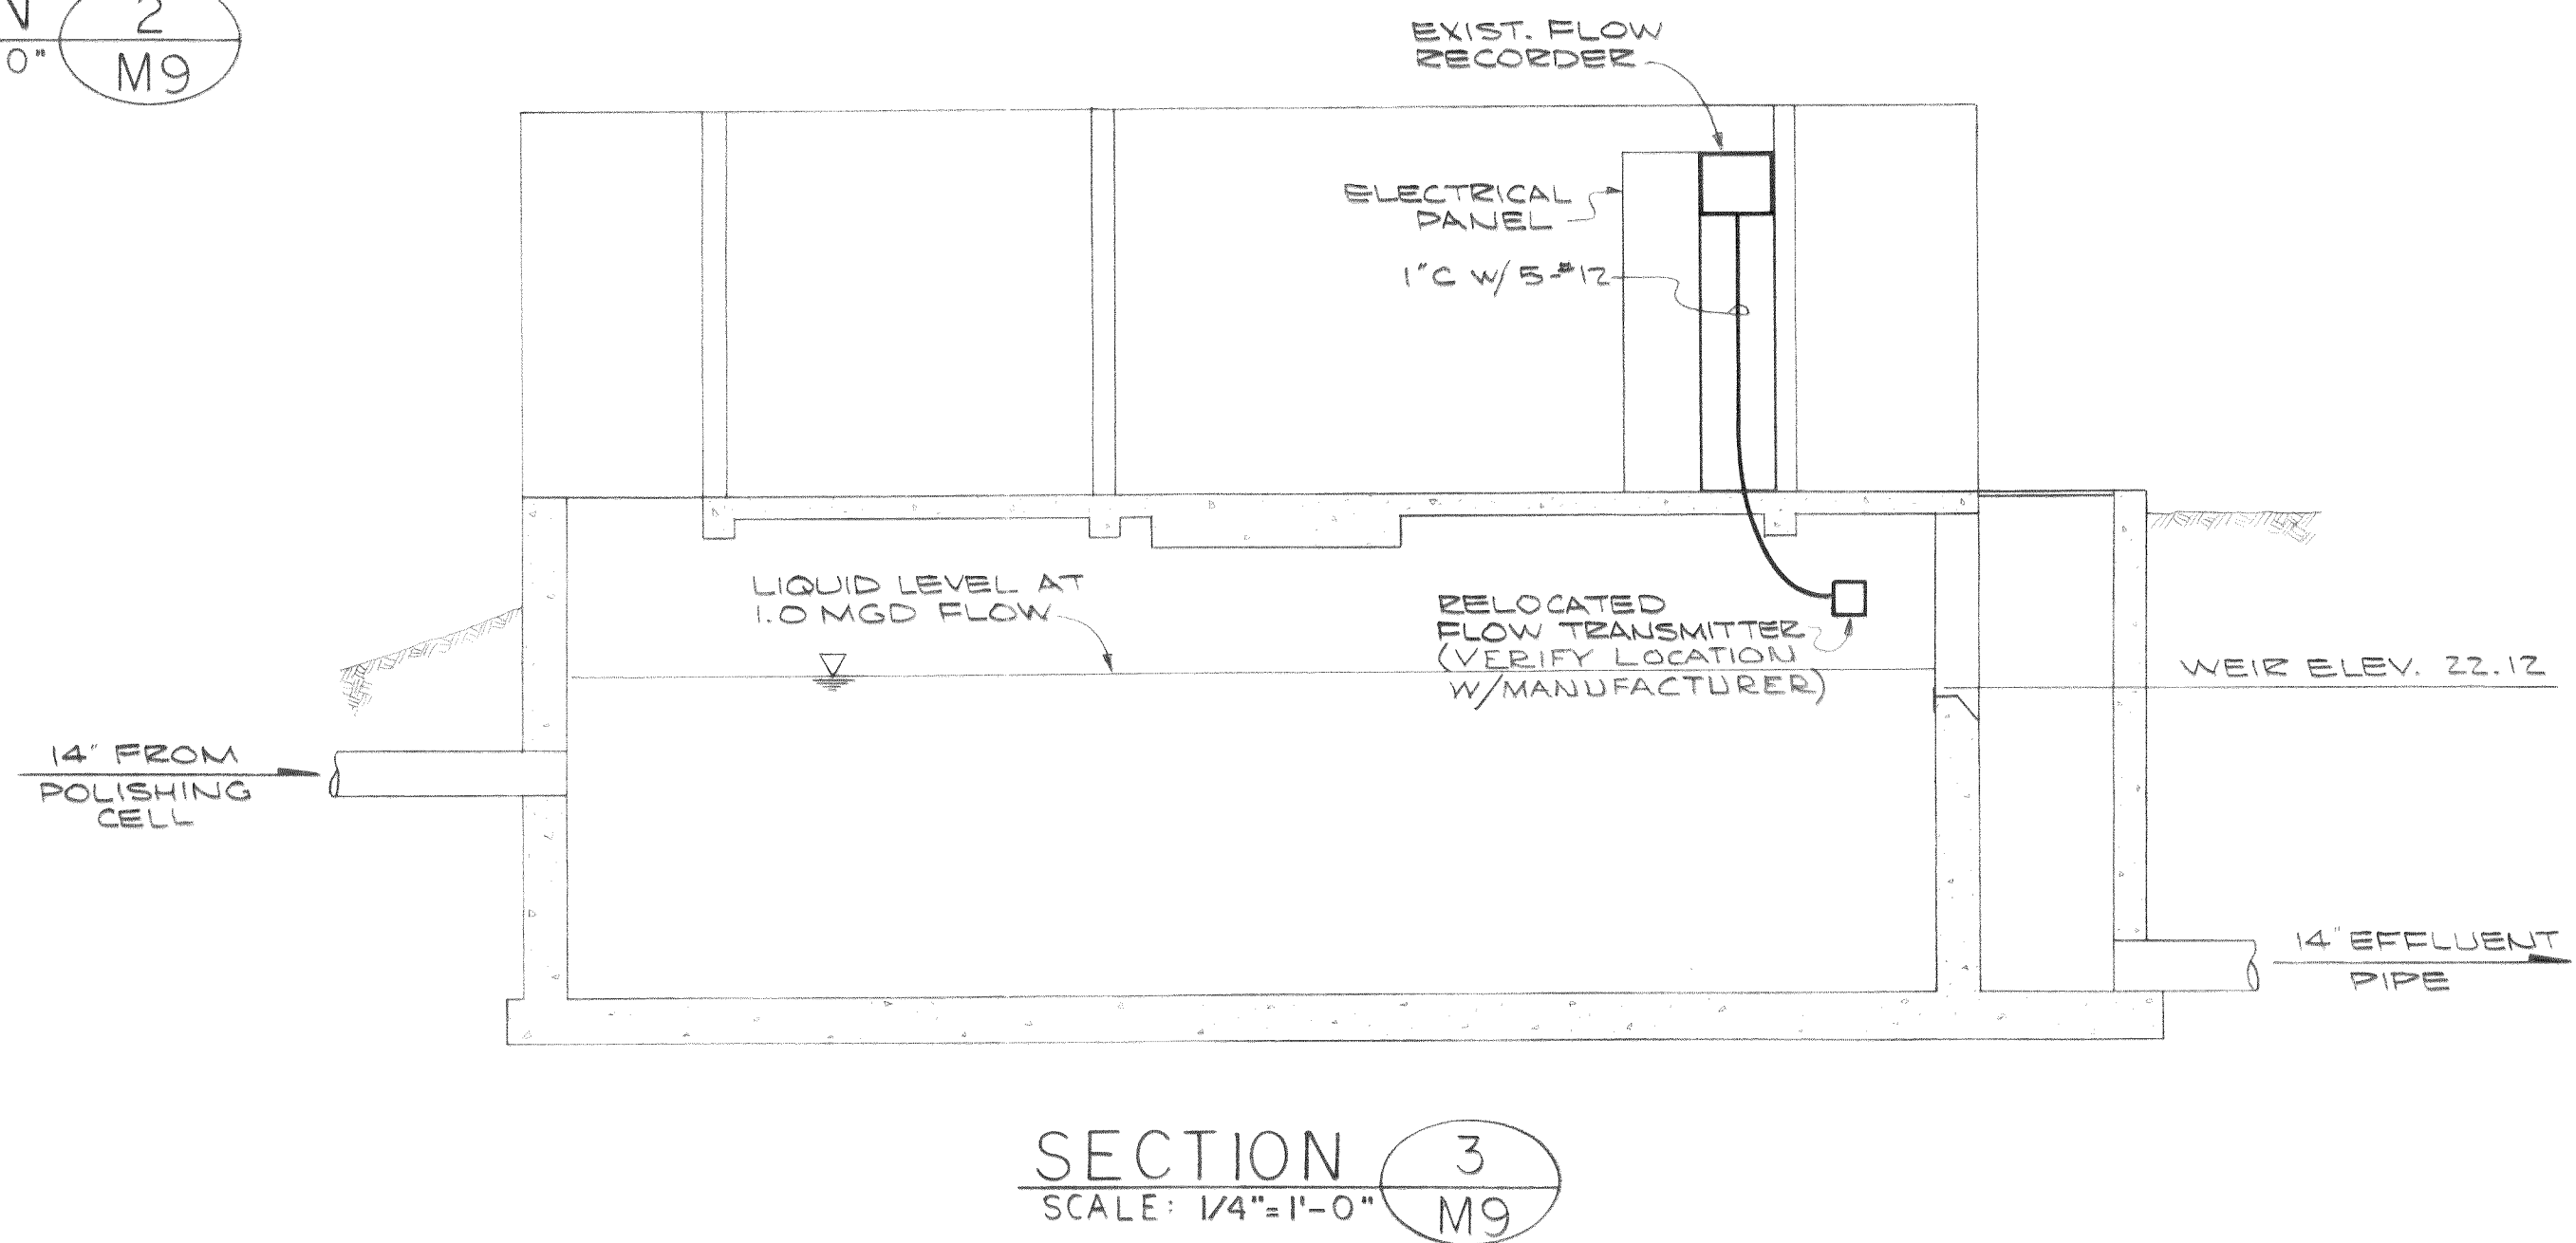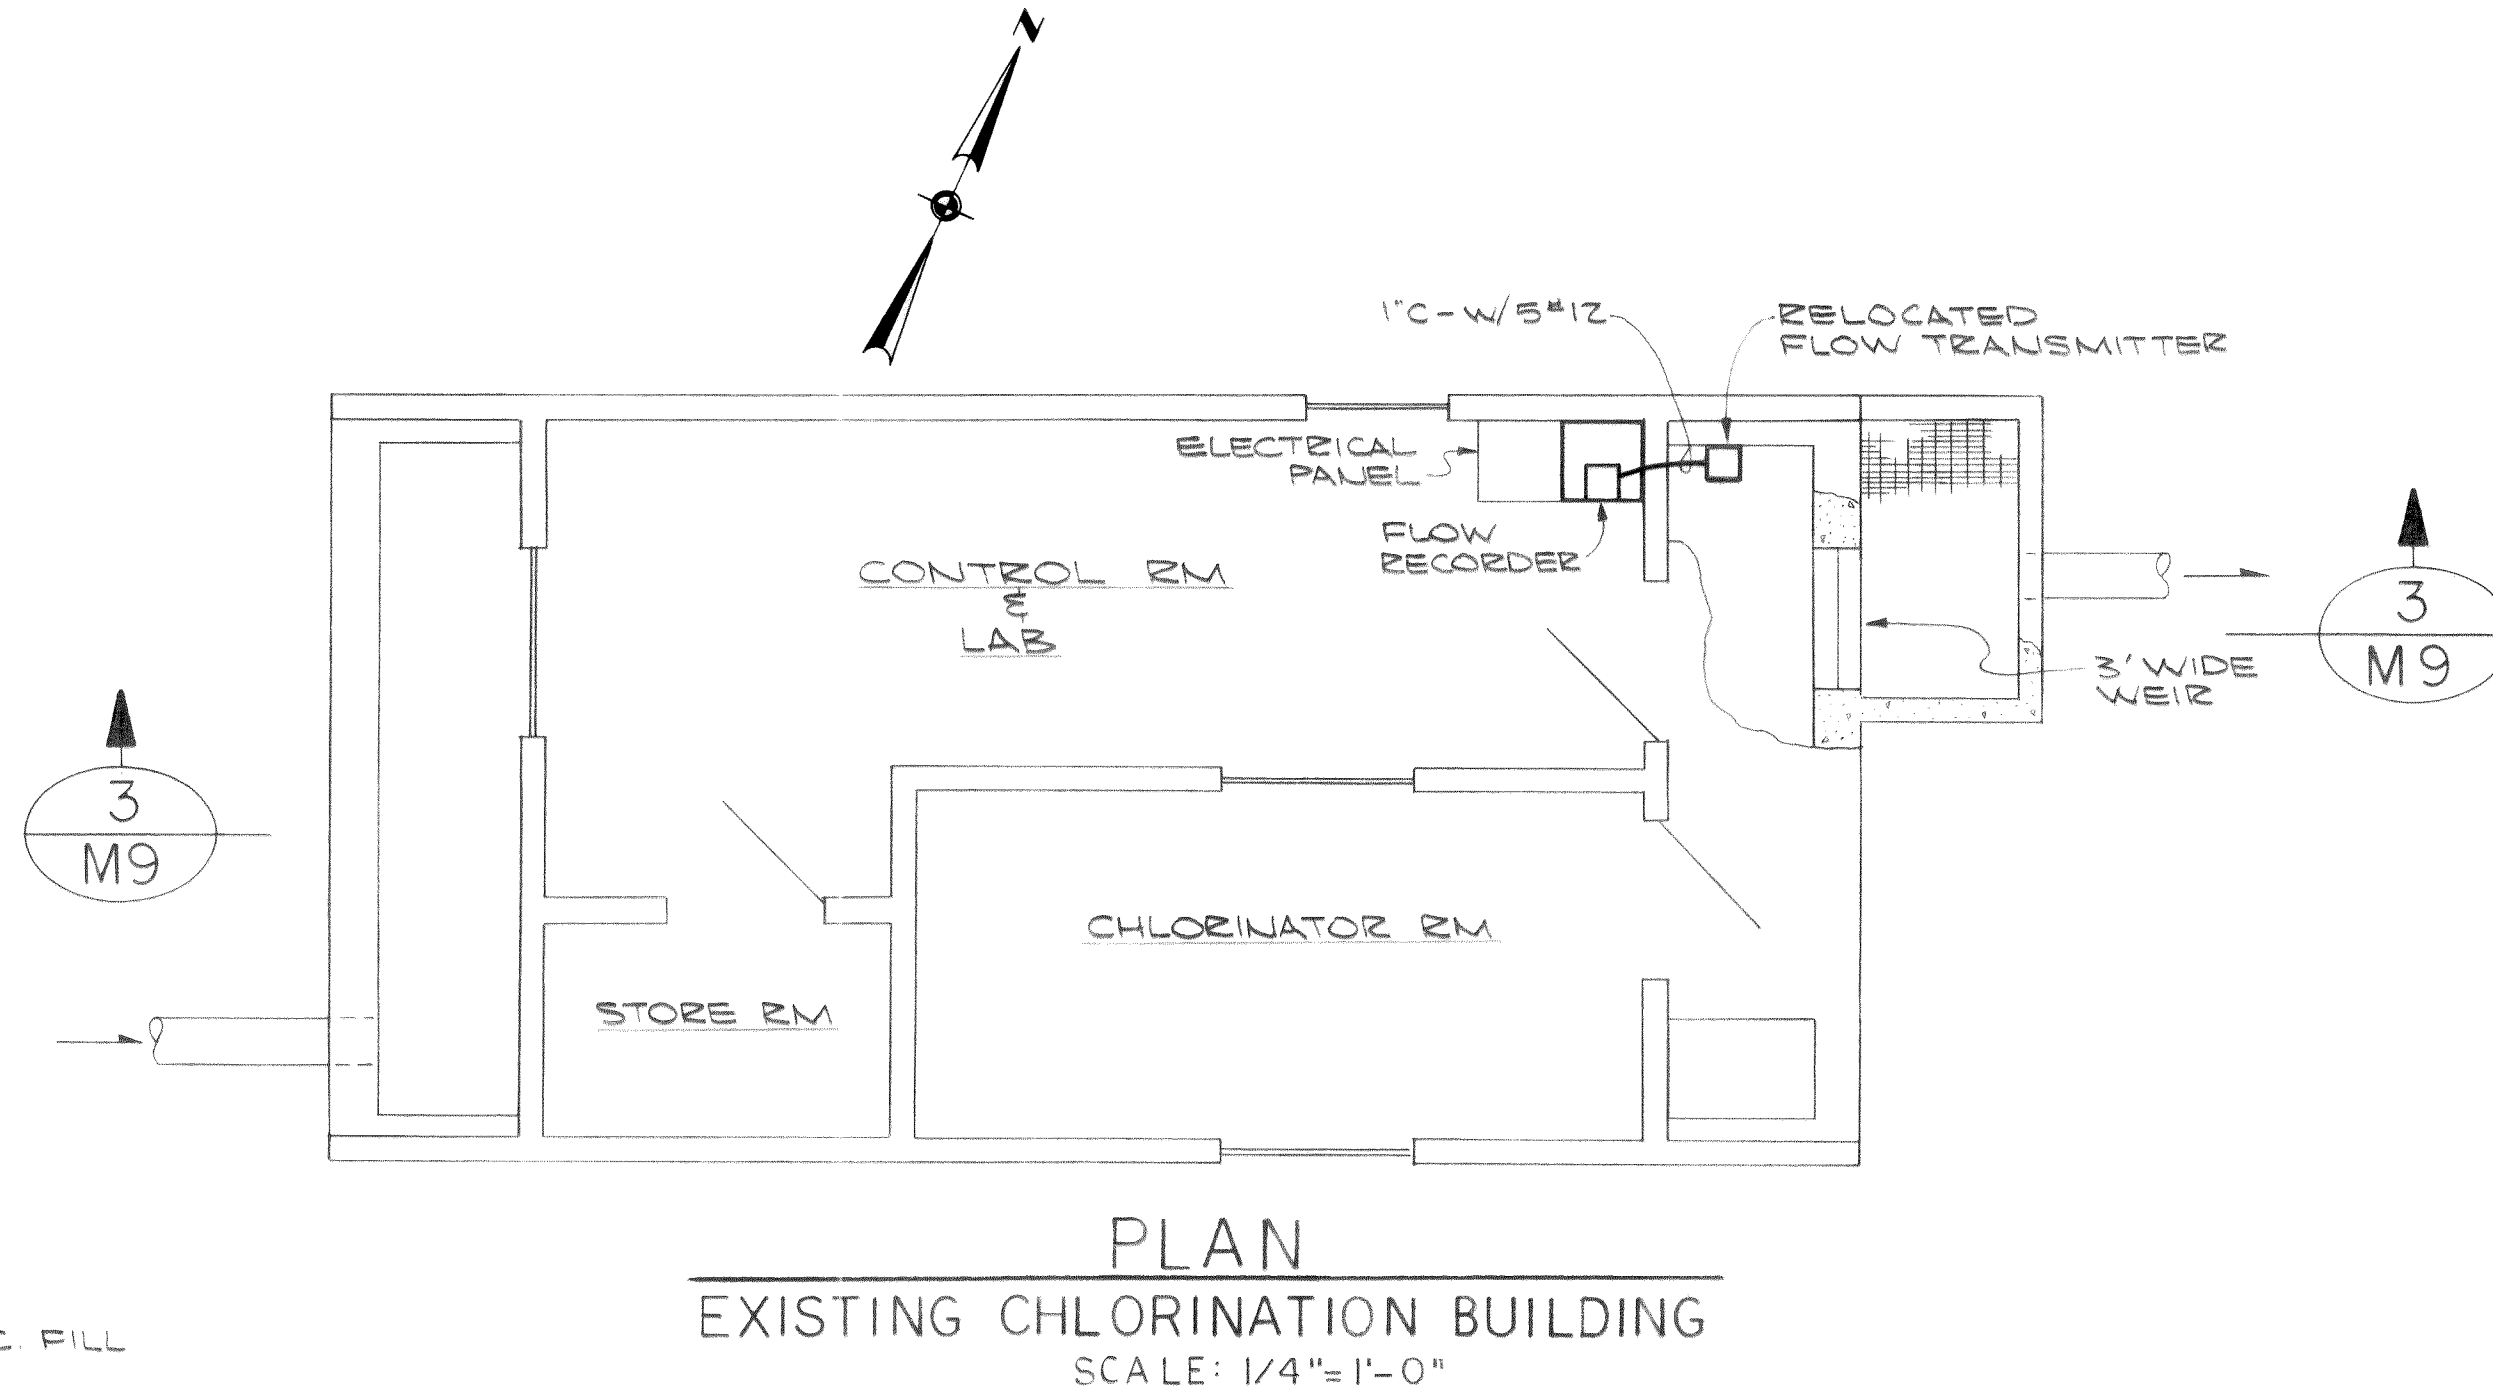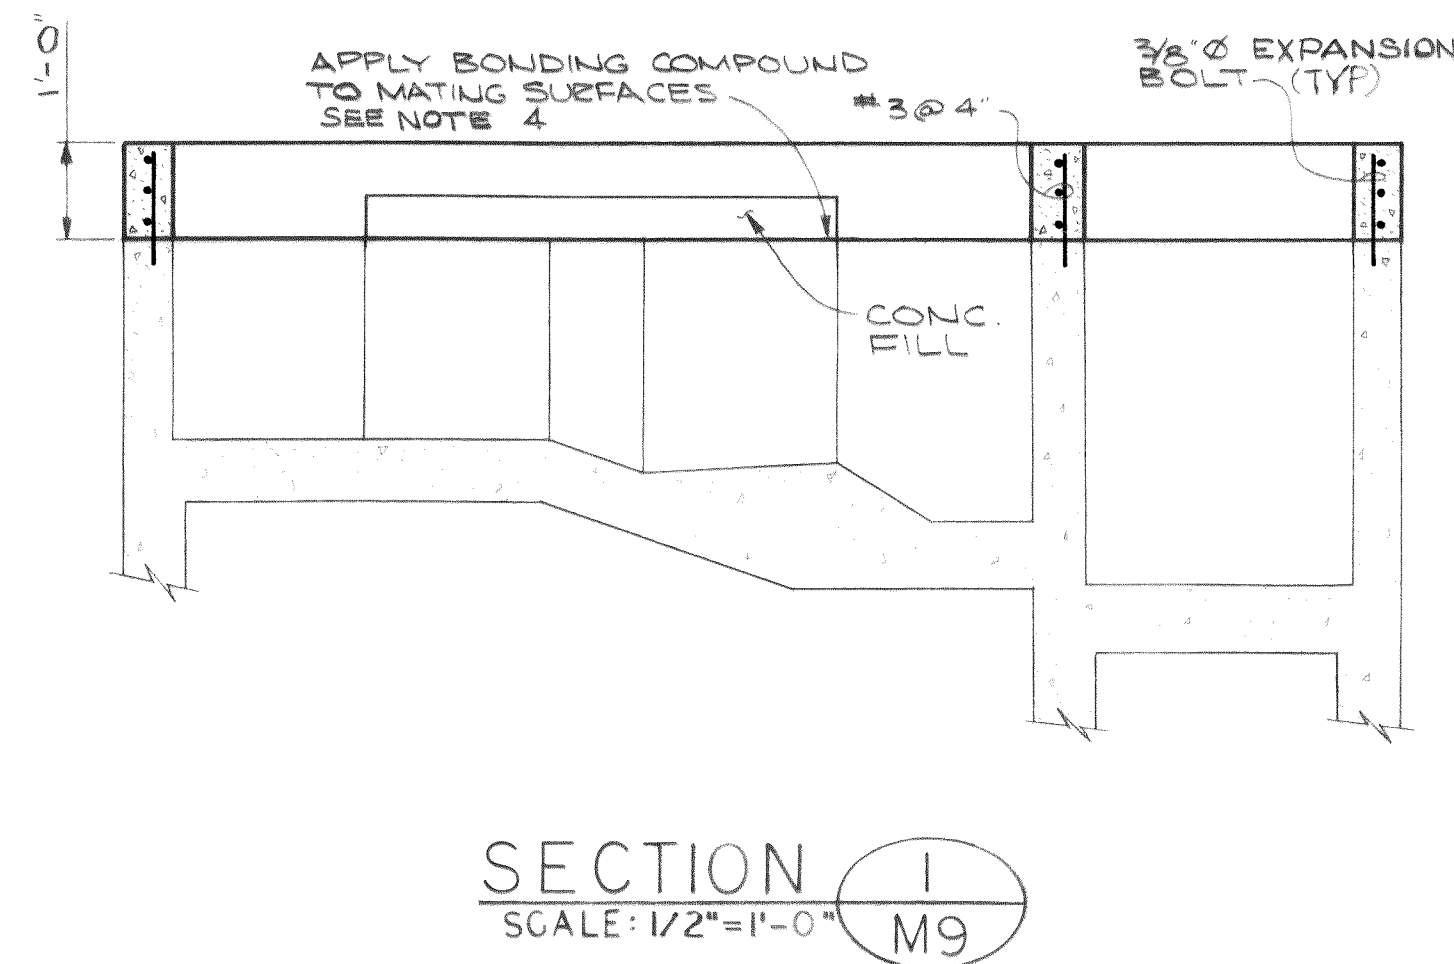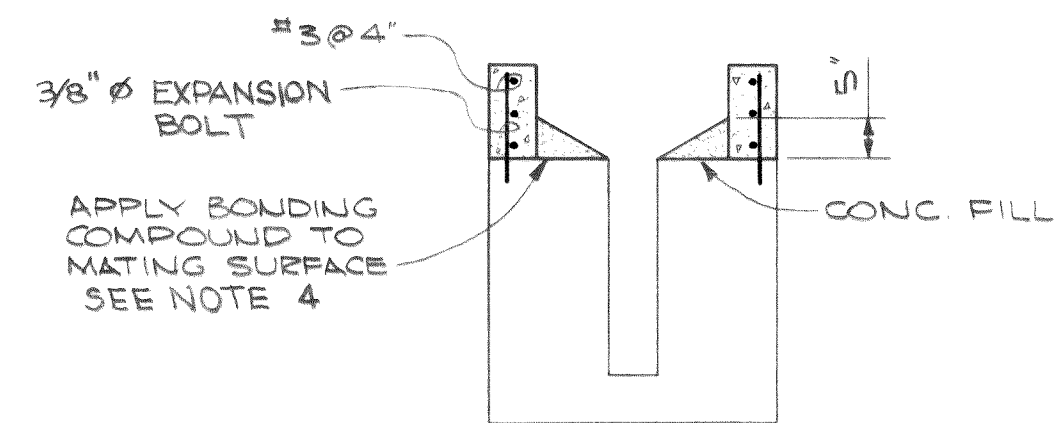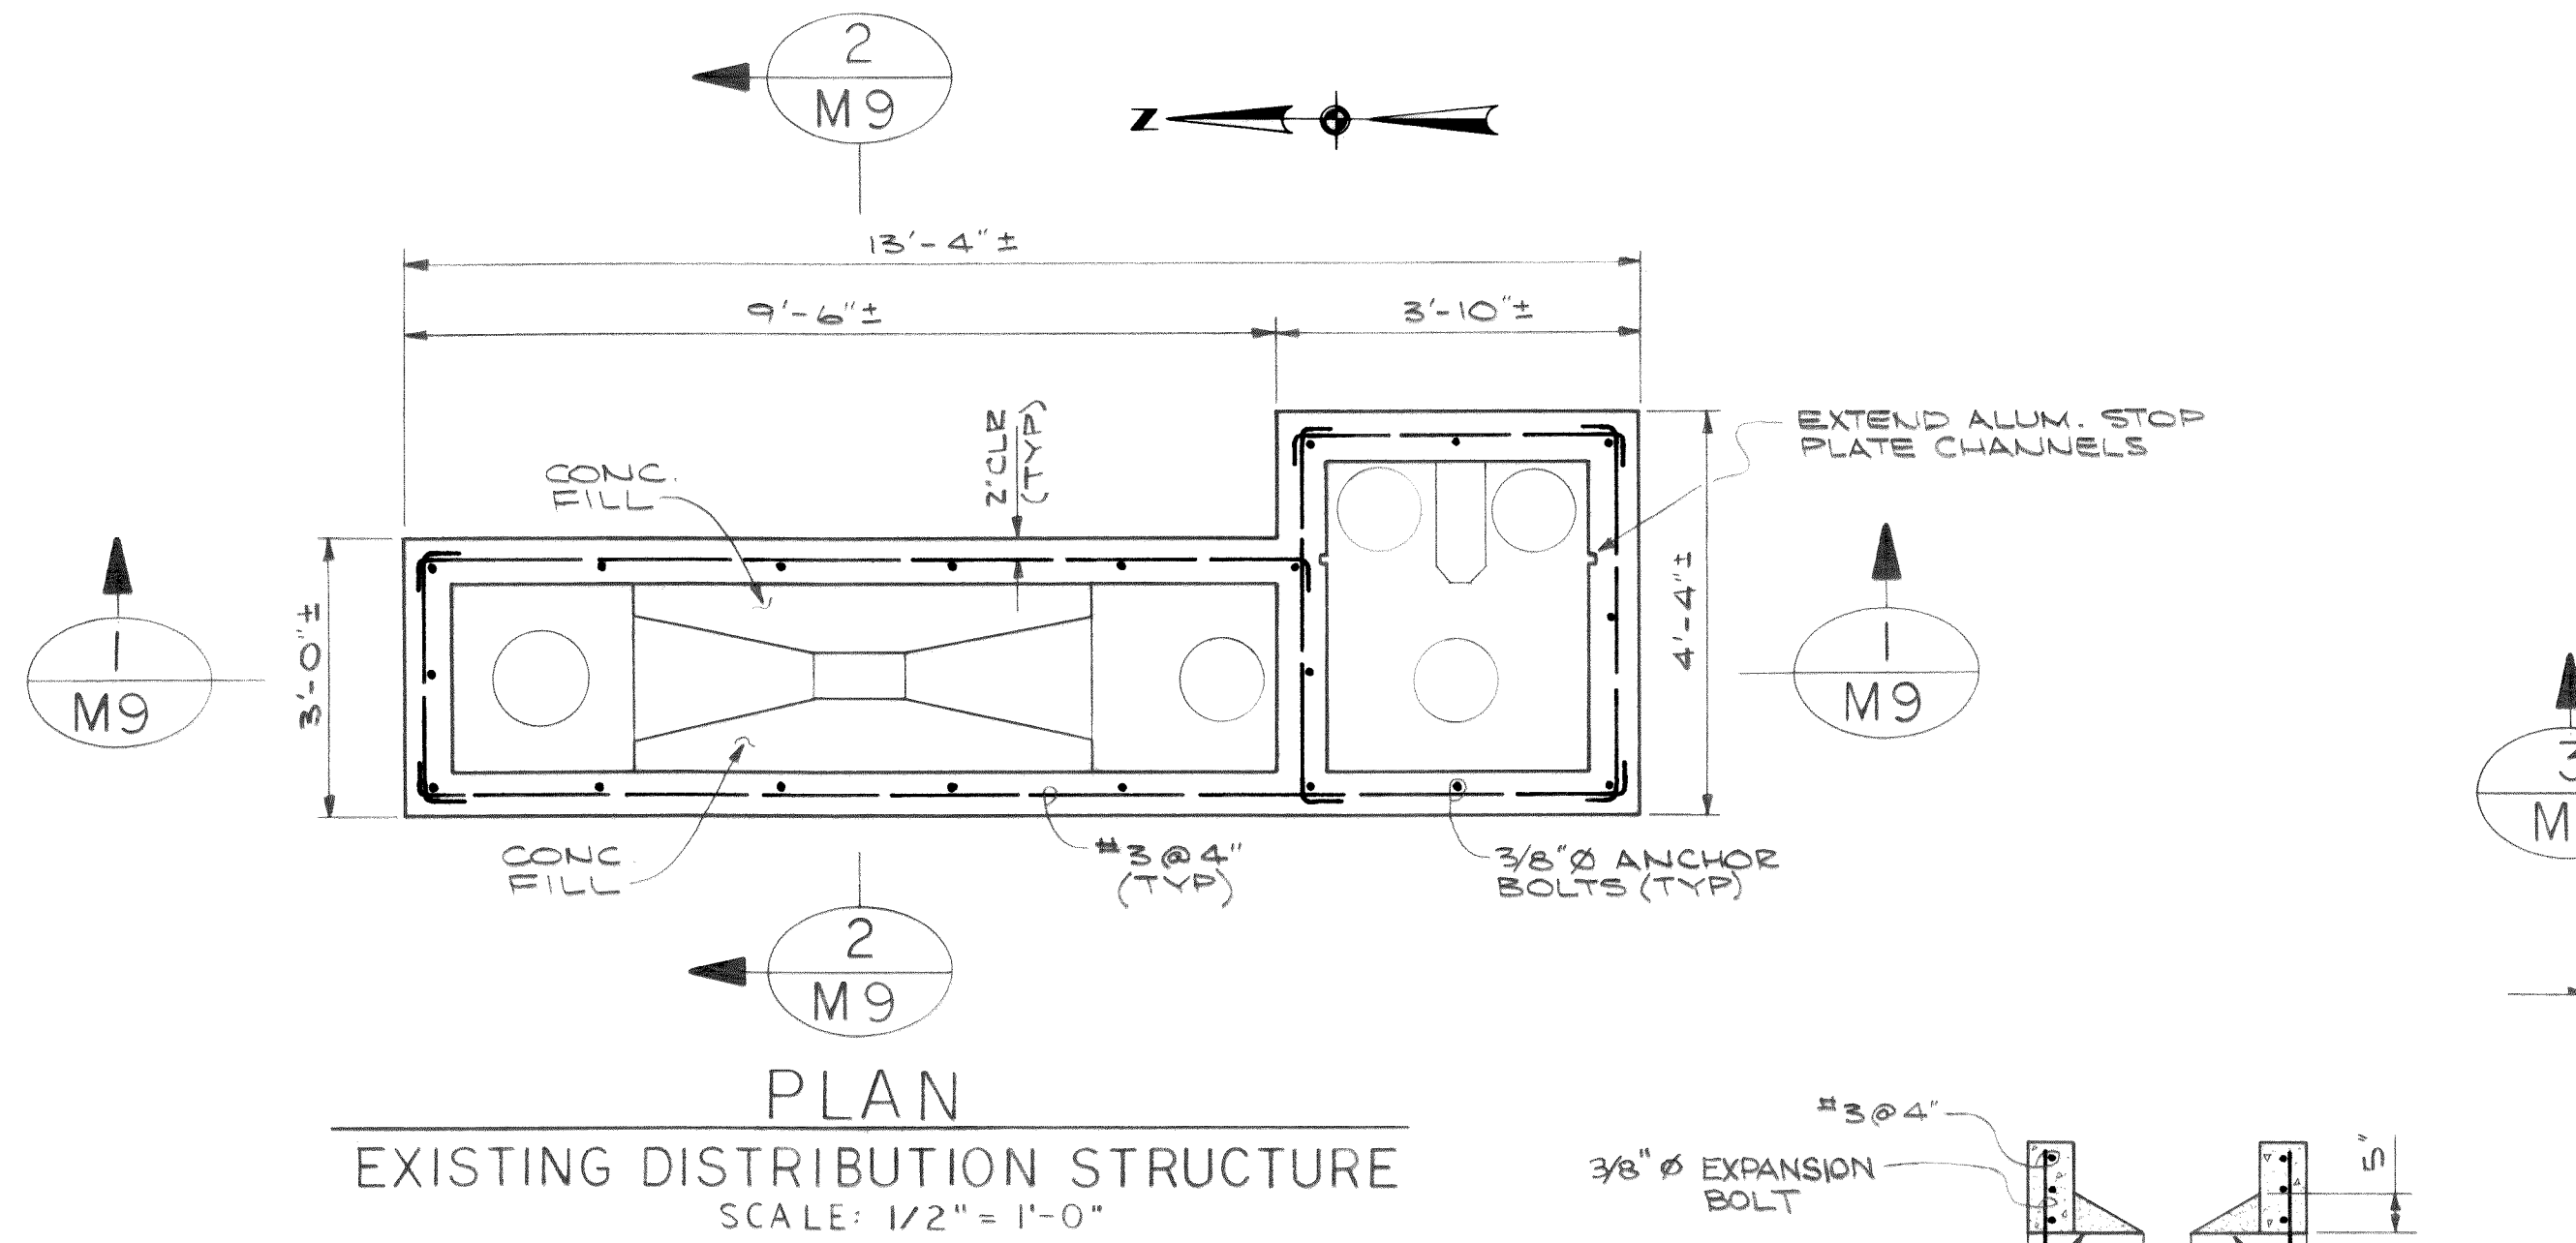


DESIGNED T.S.	APPROVED <i>Ted Strickland</i>	Stevens, Thompson & Runyan, Inc. Engineers / Planners PORTLAND SEATTLE BOISE	TOWN OF FERNDAL, WASHINGTON AXTON ROAD INTERCEPTOR SCHEDULE I	EXISTING SEWAGE TREATMENT PLANT G5 MODIFICATIONS	5
DRAWN J.M.H.	SCALE AS SHOWN DATE JULY, 1972				
CHECKED <i>dlc</i>	FILE 71- S- 425.002				
DATE NO. REVISION	BY				




MICROFILMED

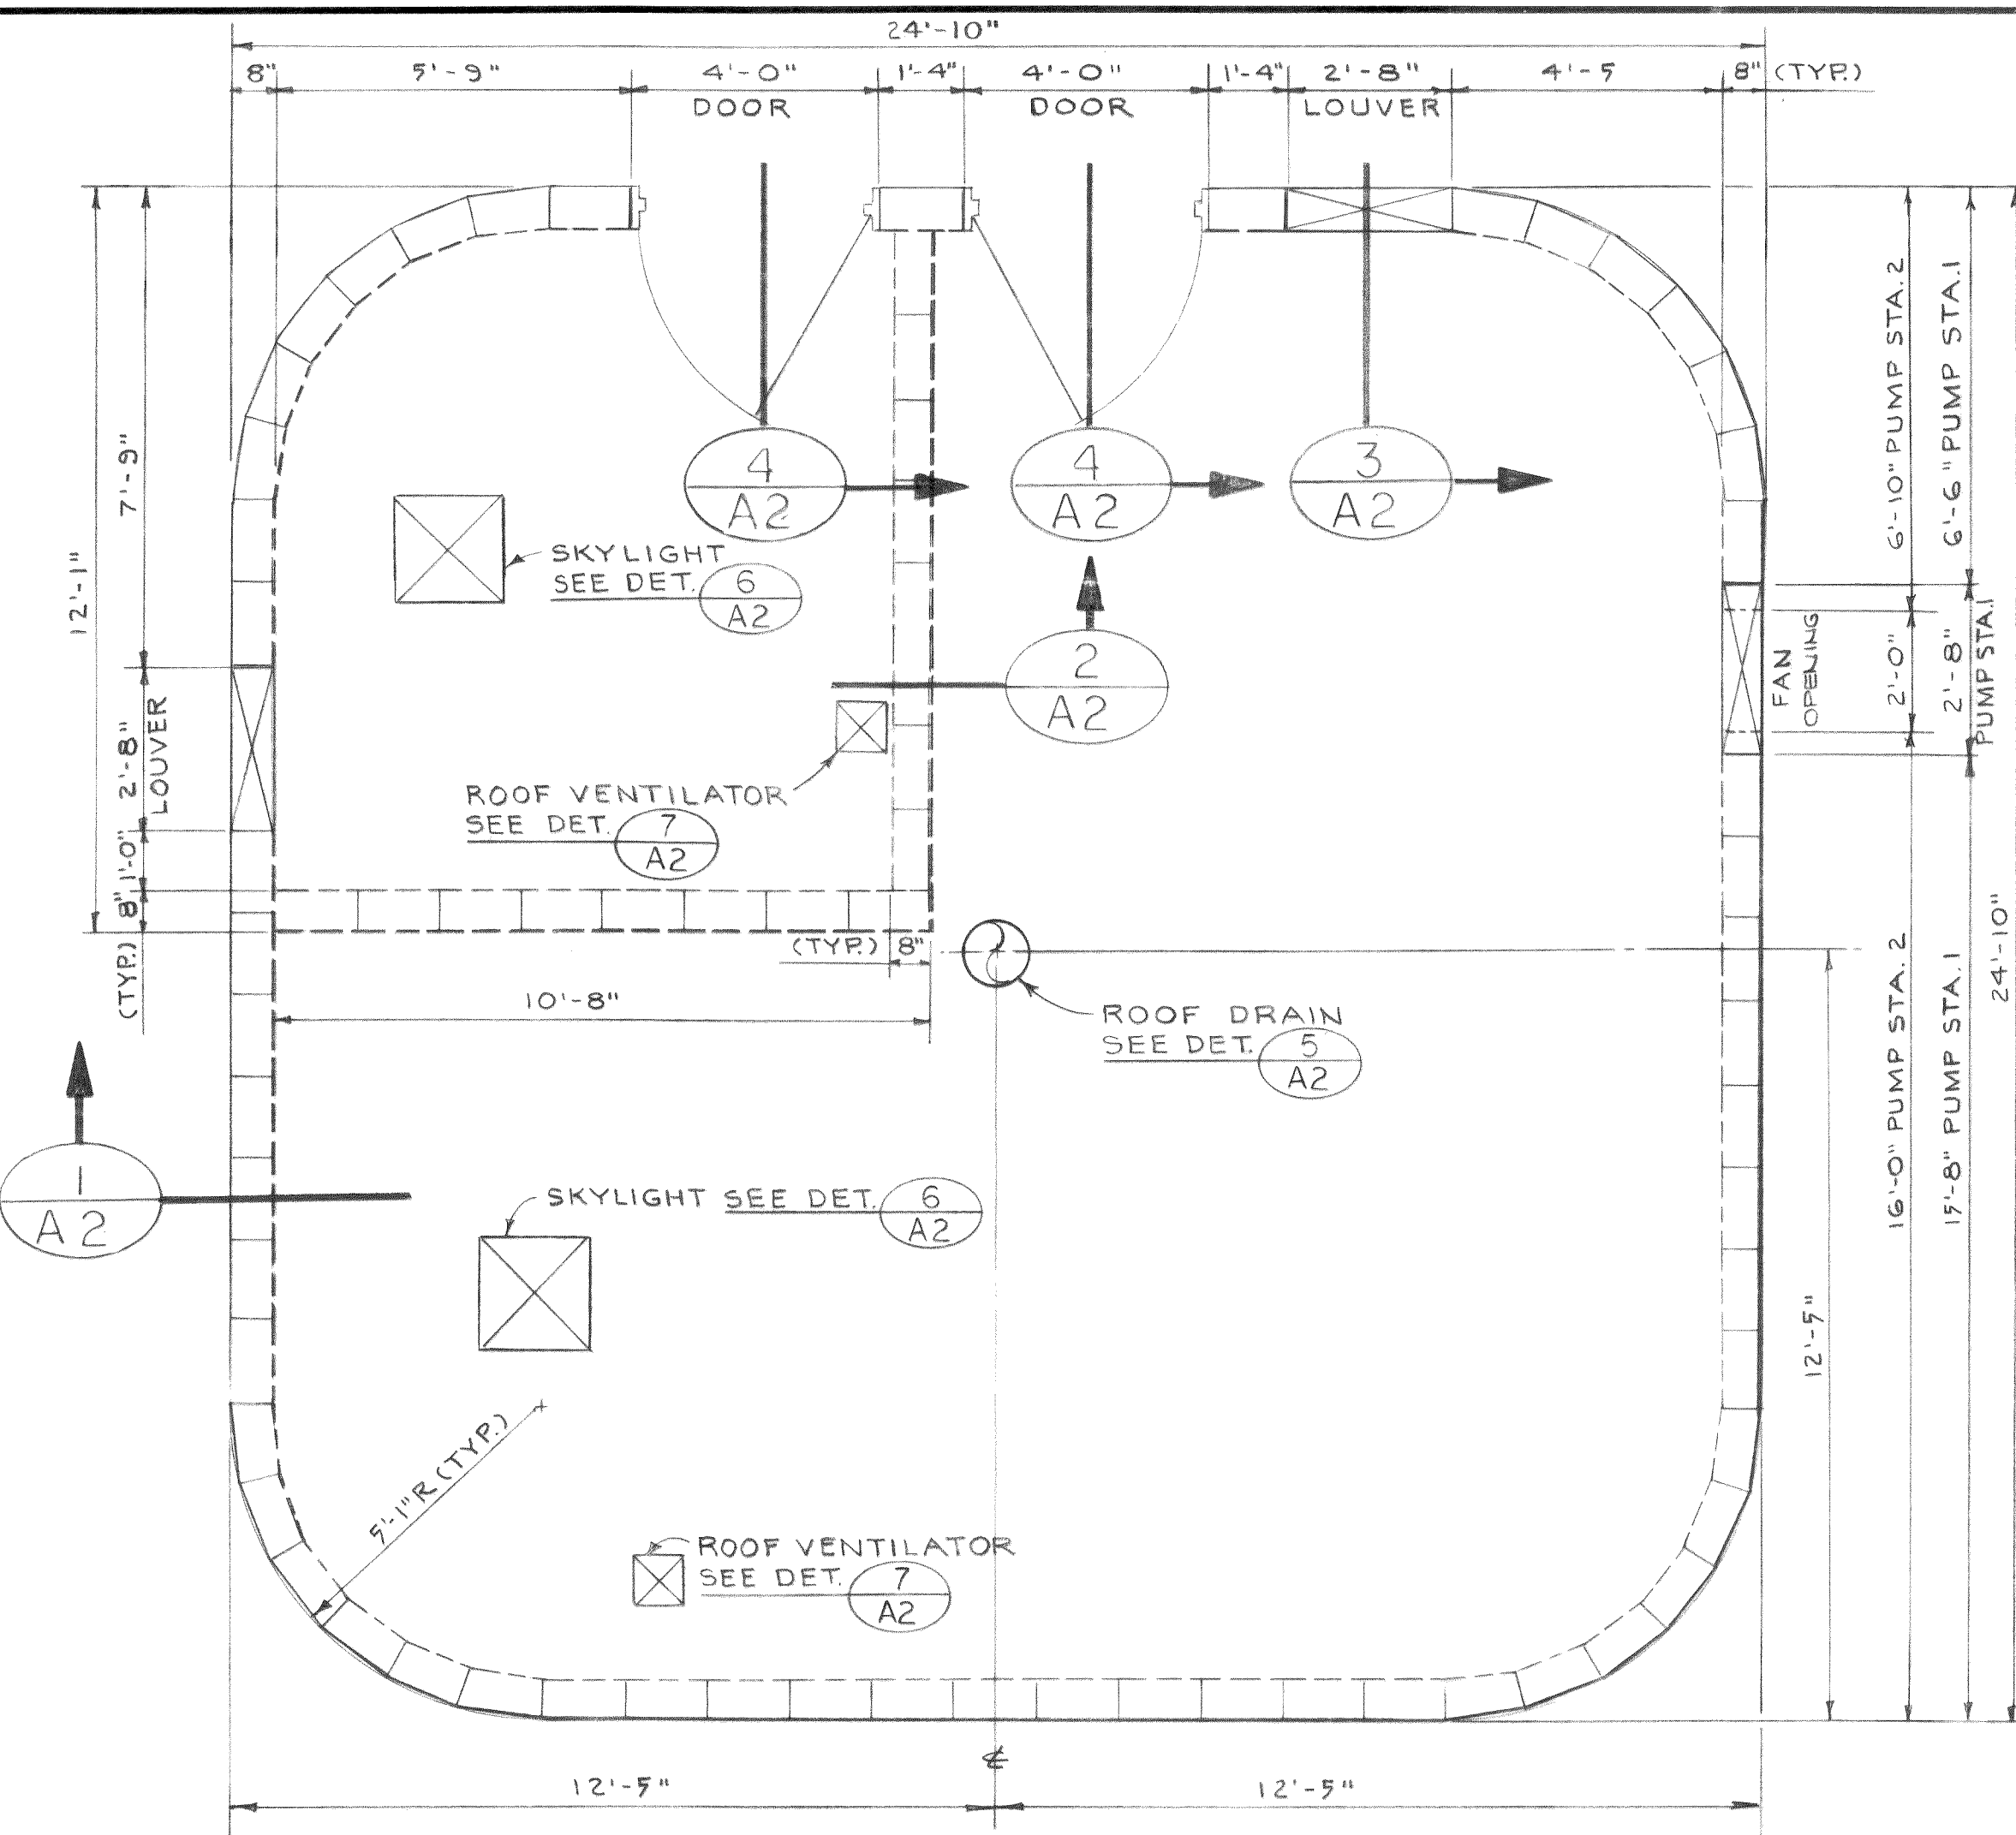


PLAN
PUMP STATION 1 & 2
SCALE: 3/8" = 1'-0"

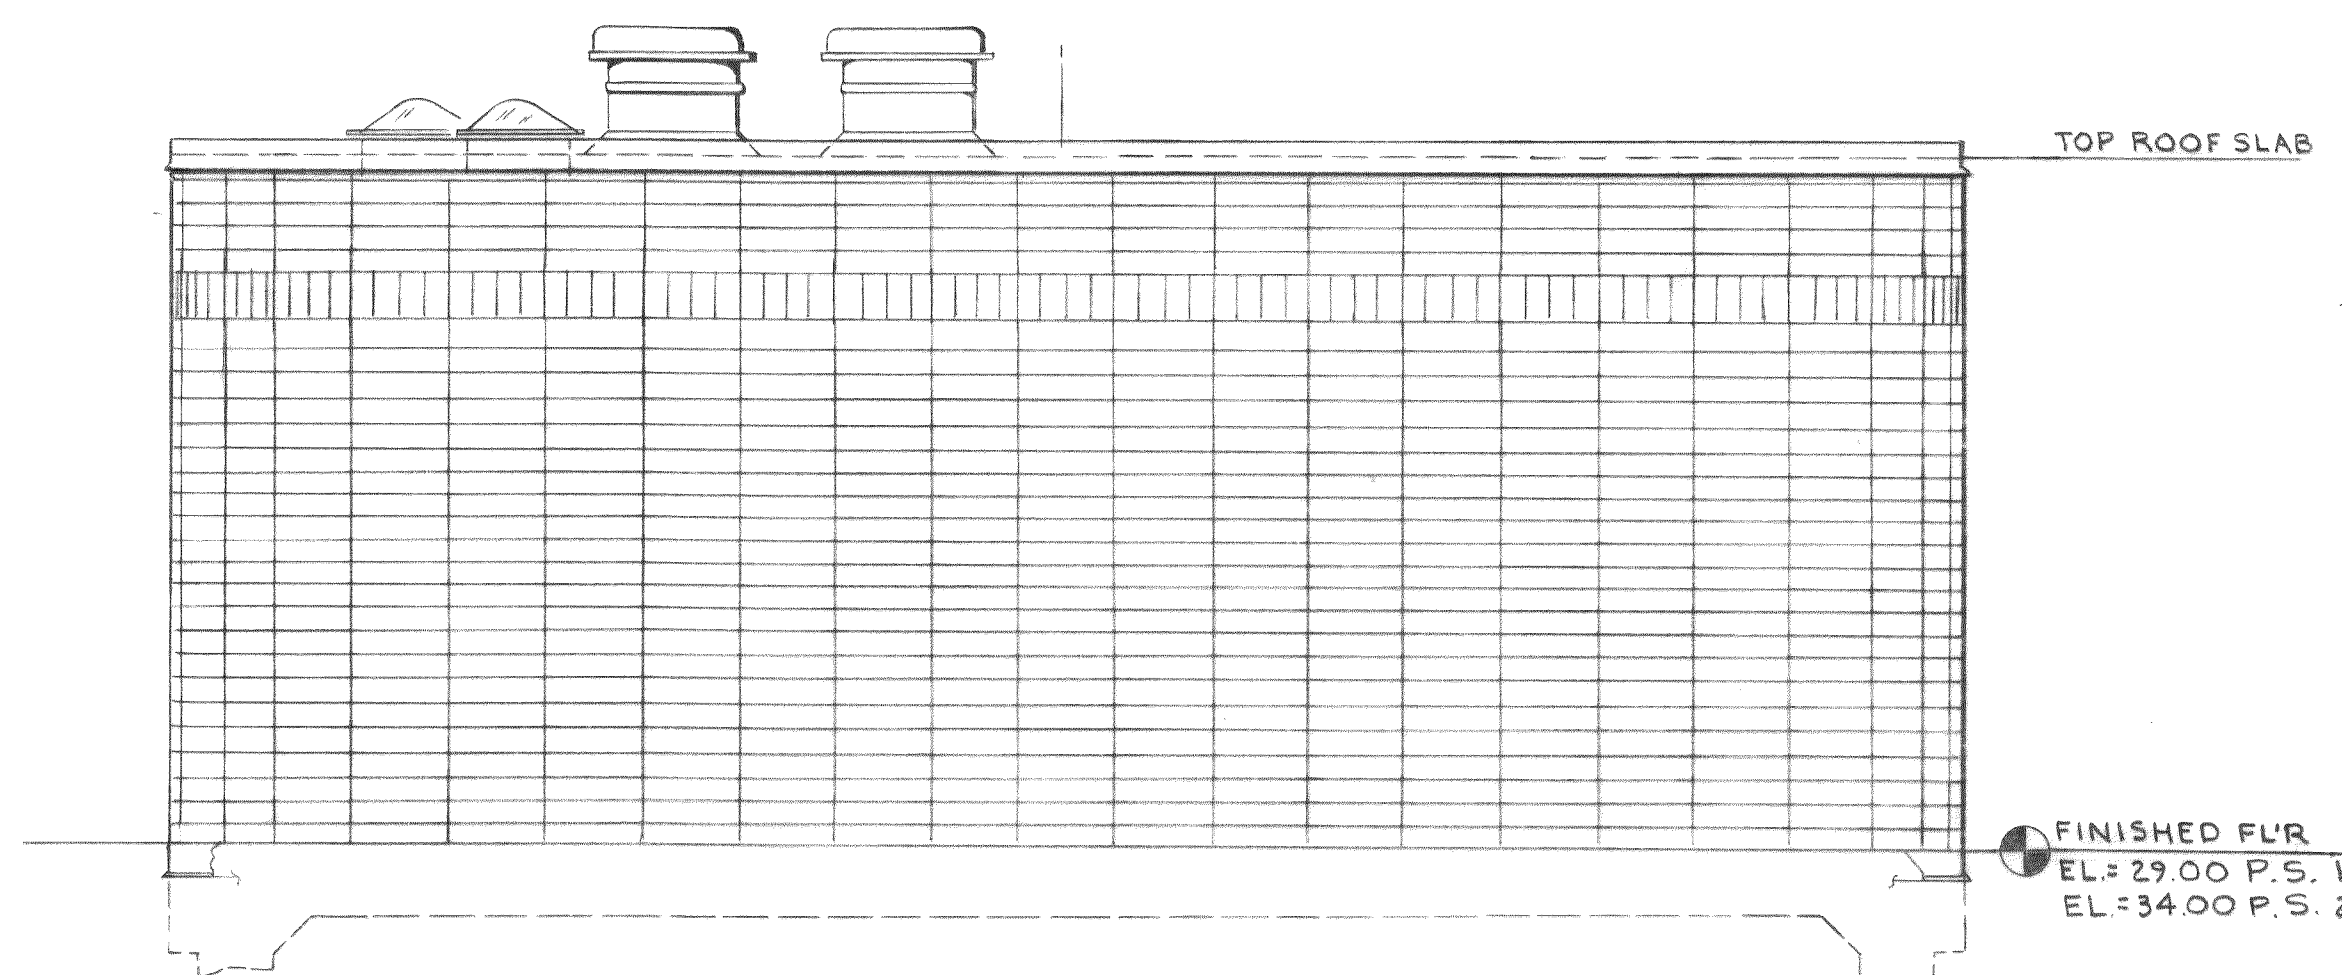


WEST ELEVATION P.S. 1
EAST ELEVATION P.S. 2
SCALE: 3/8" = 1'-0"

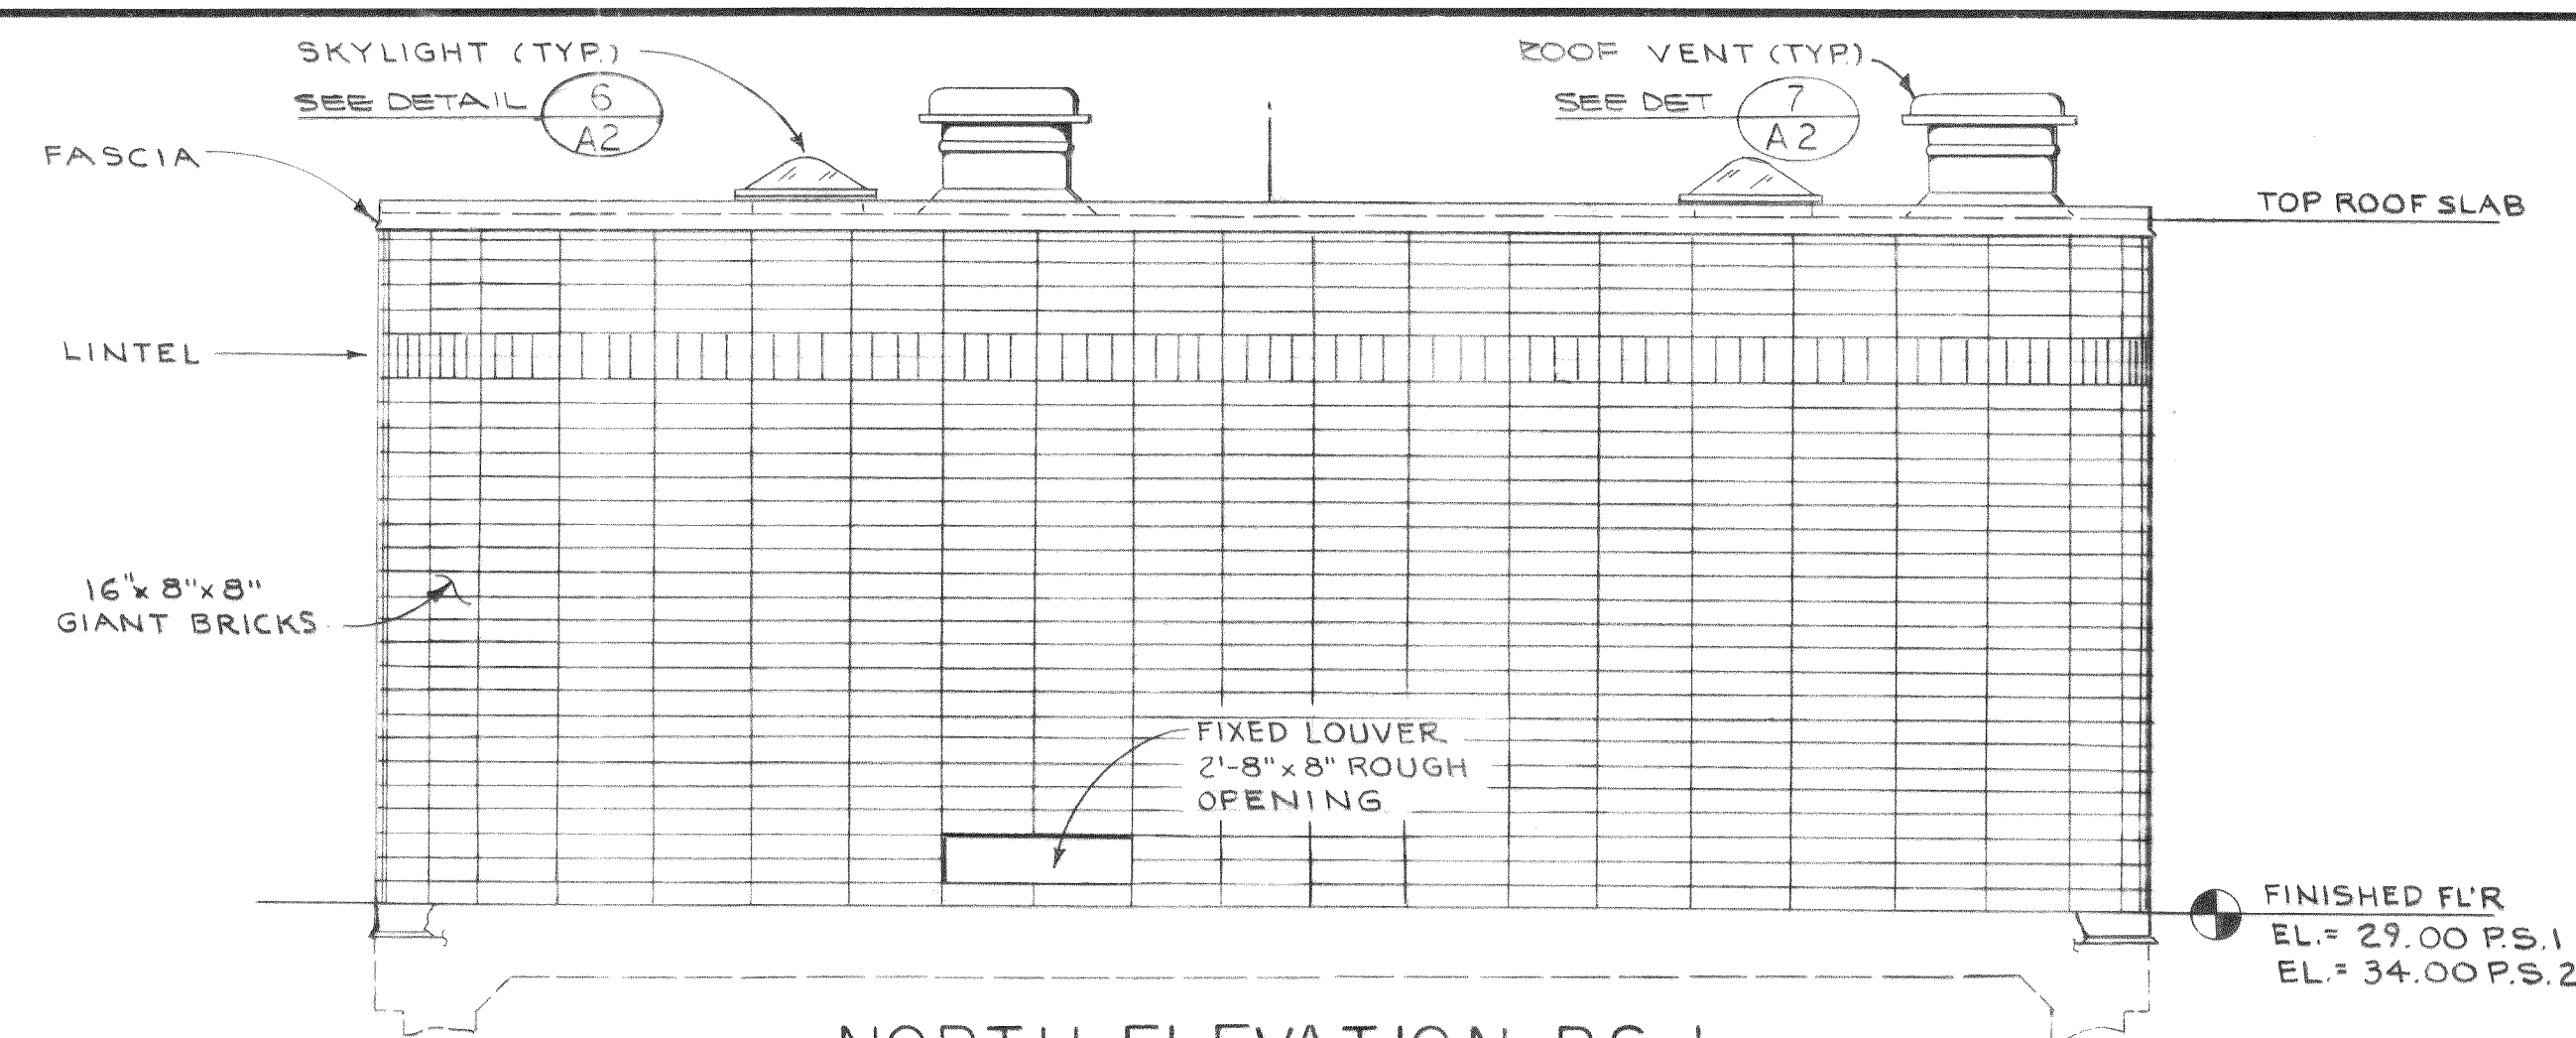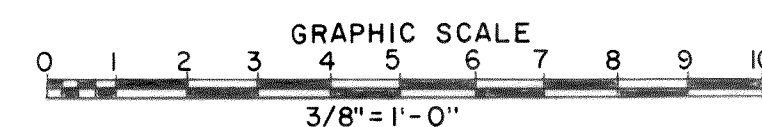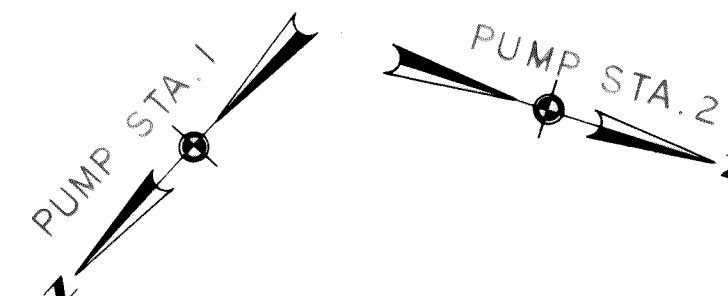

NORTH ELEVATION-P.S. 1
SOUTH ELEVATION-P.S. 2
SCALE: 3/8" = 1'-0"

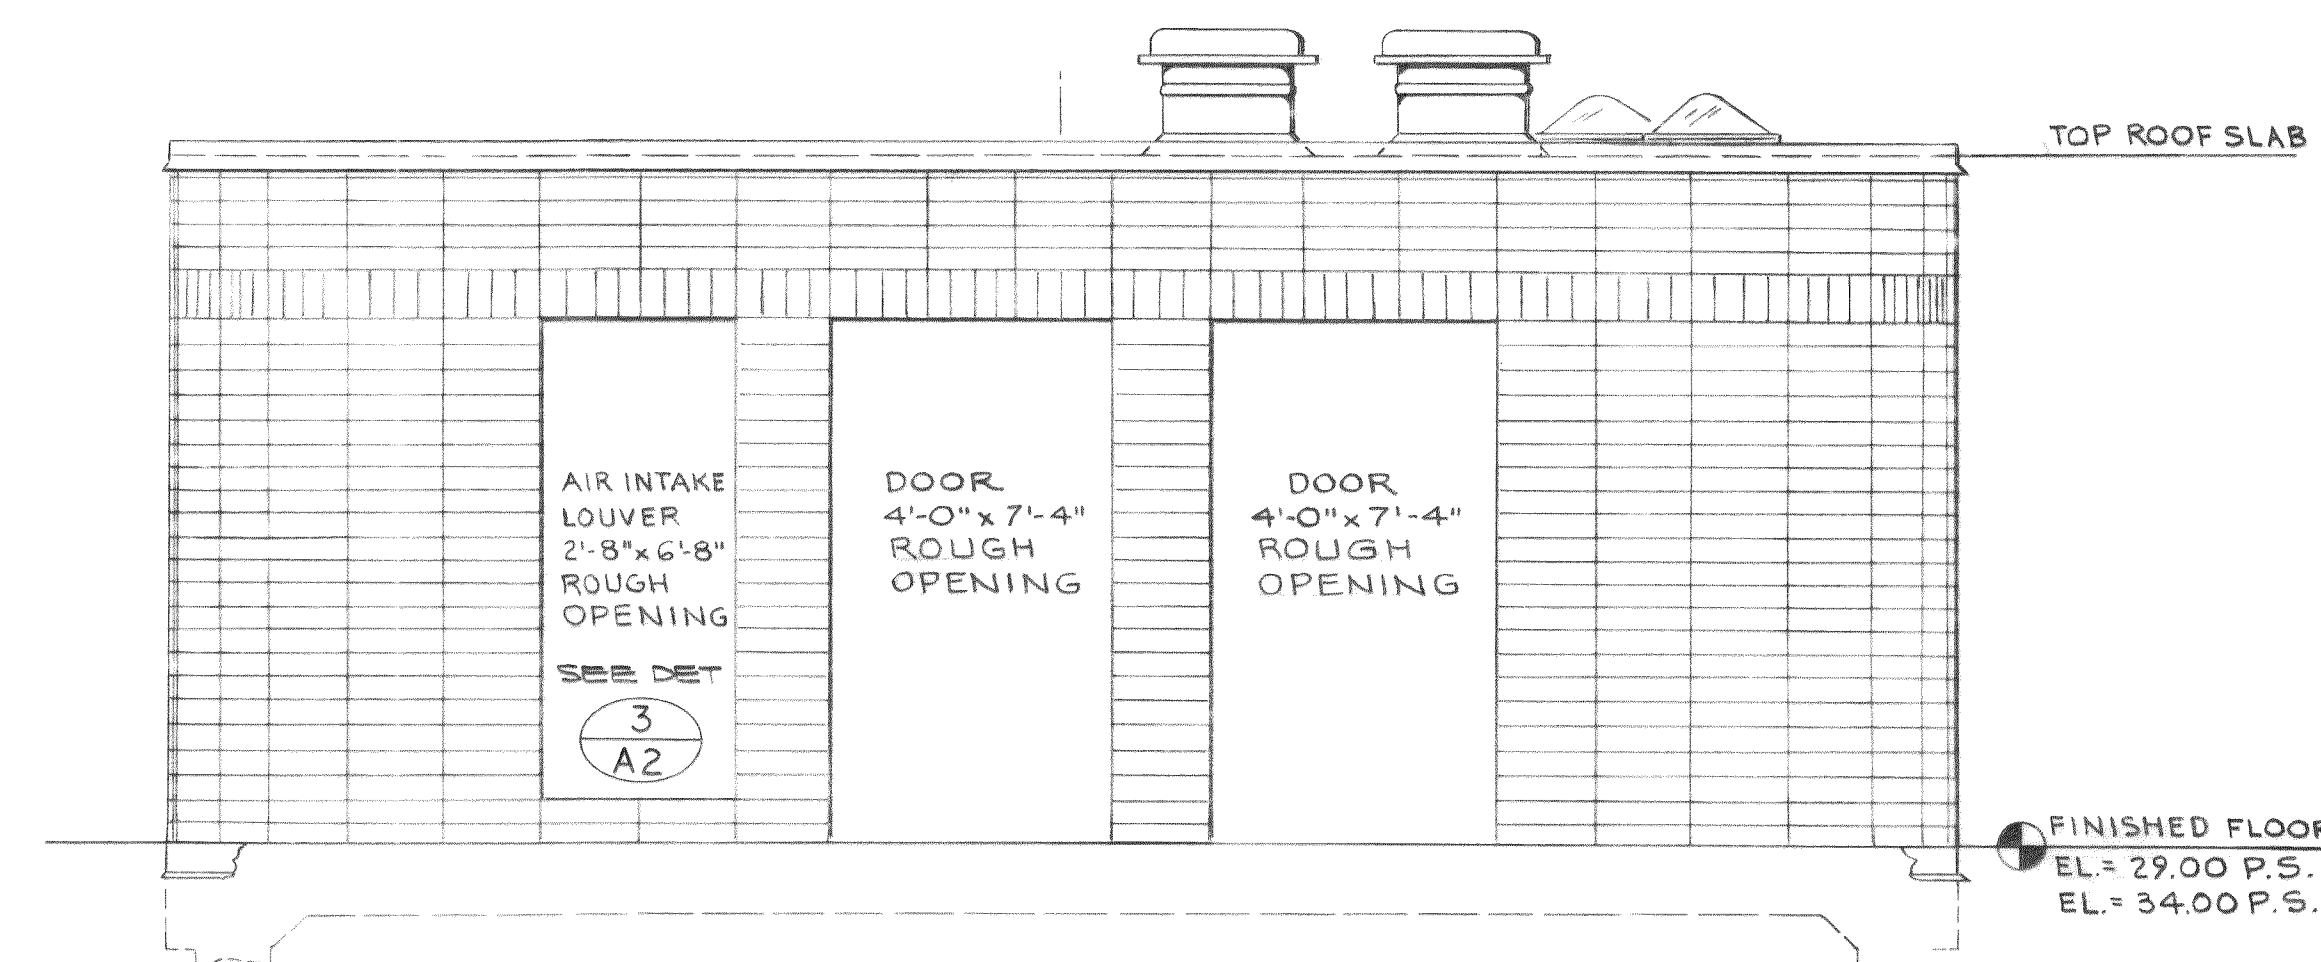


EAST ELEVATION-P.S. 1
WEST ELEVATION-P.S. 2
SCALE: 3/8" = 1'-0"

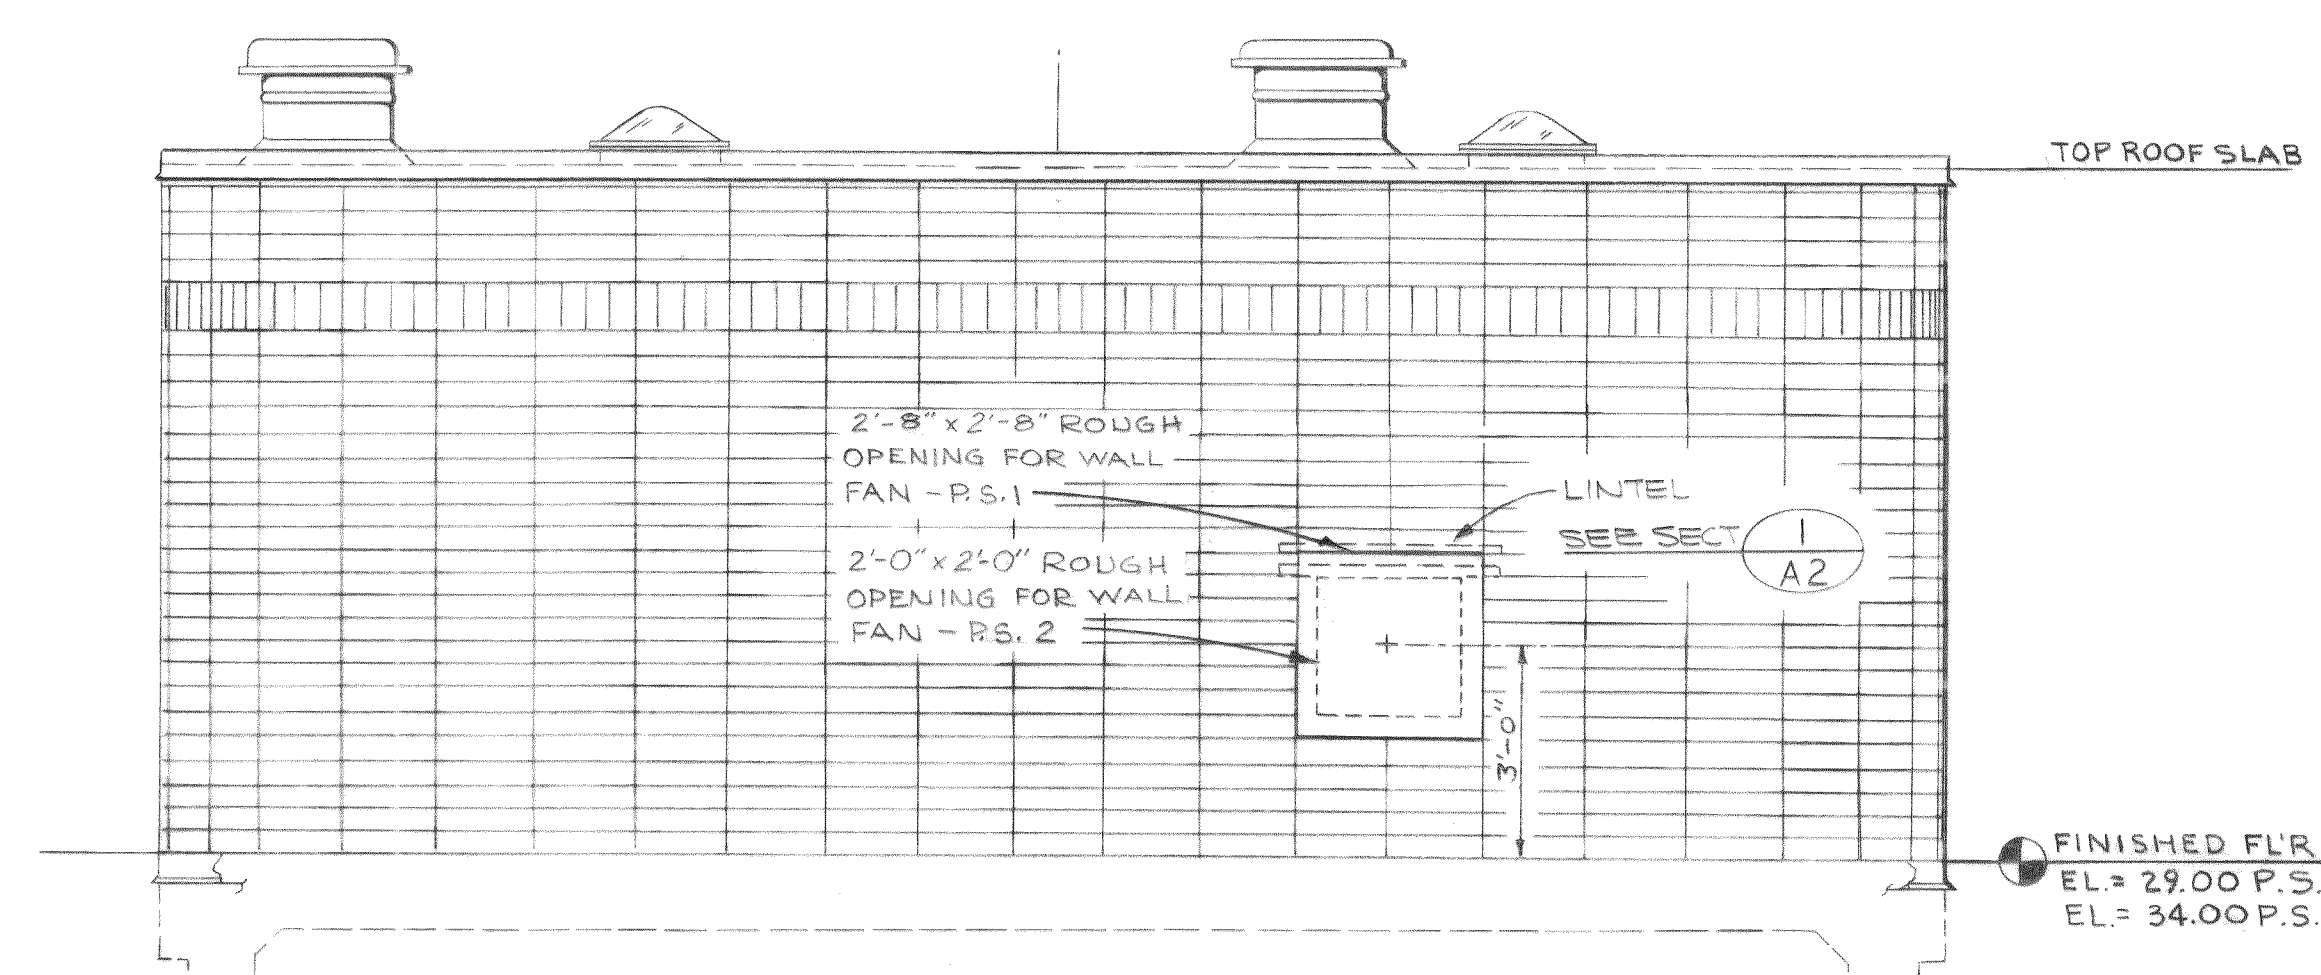

SOUTH ELEVATION-P.S. 1
NORTH ELEVATION-P.S. 2
SCALE: 3/8" = 1'-0"

NOTE:
THIS DRAWING TYP. FOR
STATIONS 1 AND 2
EXCEPT WHERE NOTED
OTHERWISE.

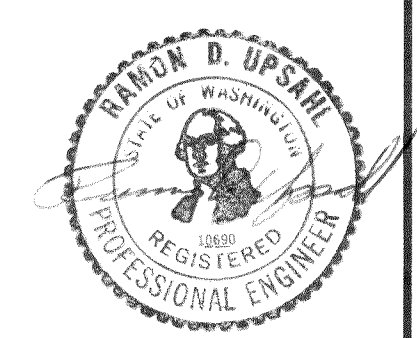

DESIGNED	RDU	APPROVED	<i>Ed. H. H. H.</i>
DRAWN	E. J.	SCALE	AS SHOWN
DATE	NO.	REVISION	BY
CHECKED	<i>LL</i>	FILE	71-S-425.002


ST
Stevens, Thompson & Runyan, Inc.
Engineers/Planners
PORTLAND SEATTLE BOISE

TOWN OF FERNDAL, WASHINGTON
AXTON ROAD INTERCEPTOR
SCHEDULE I


PUMP STATION 1 & 2
ARCHITECTURAL PLAN & ELEVATIONS

A1
2


MICROFILMED

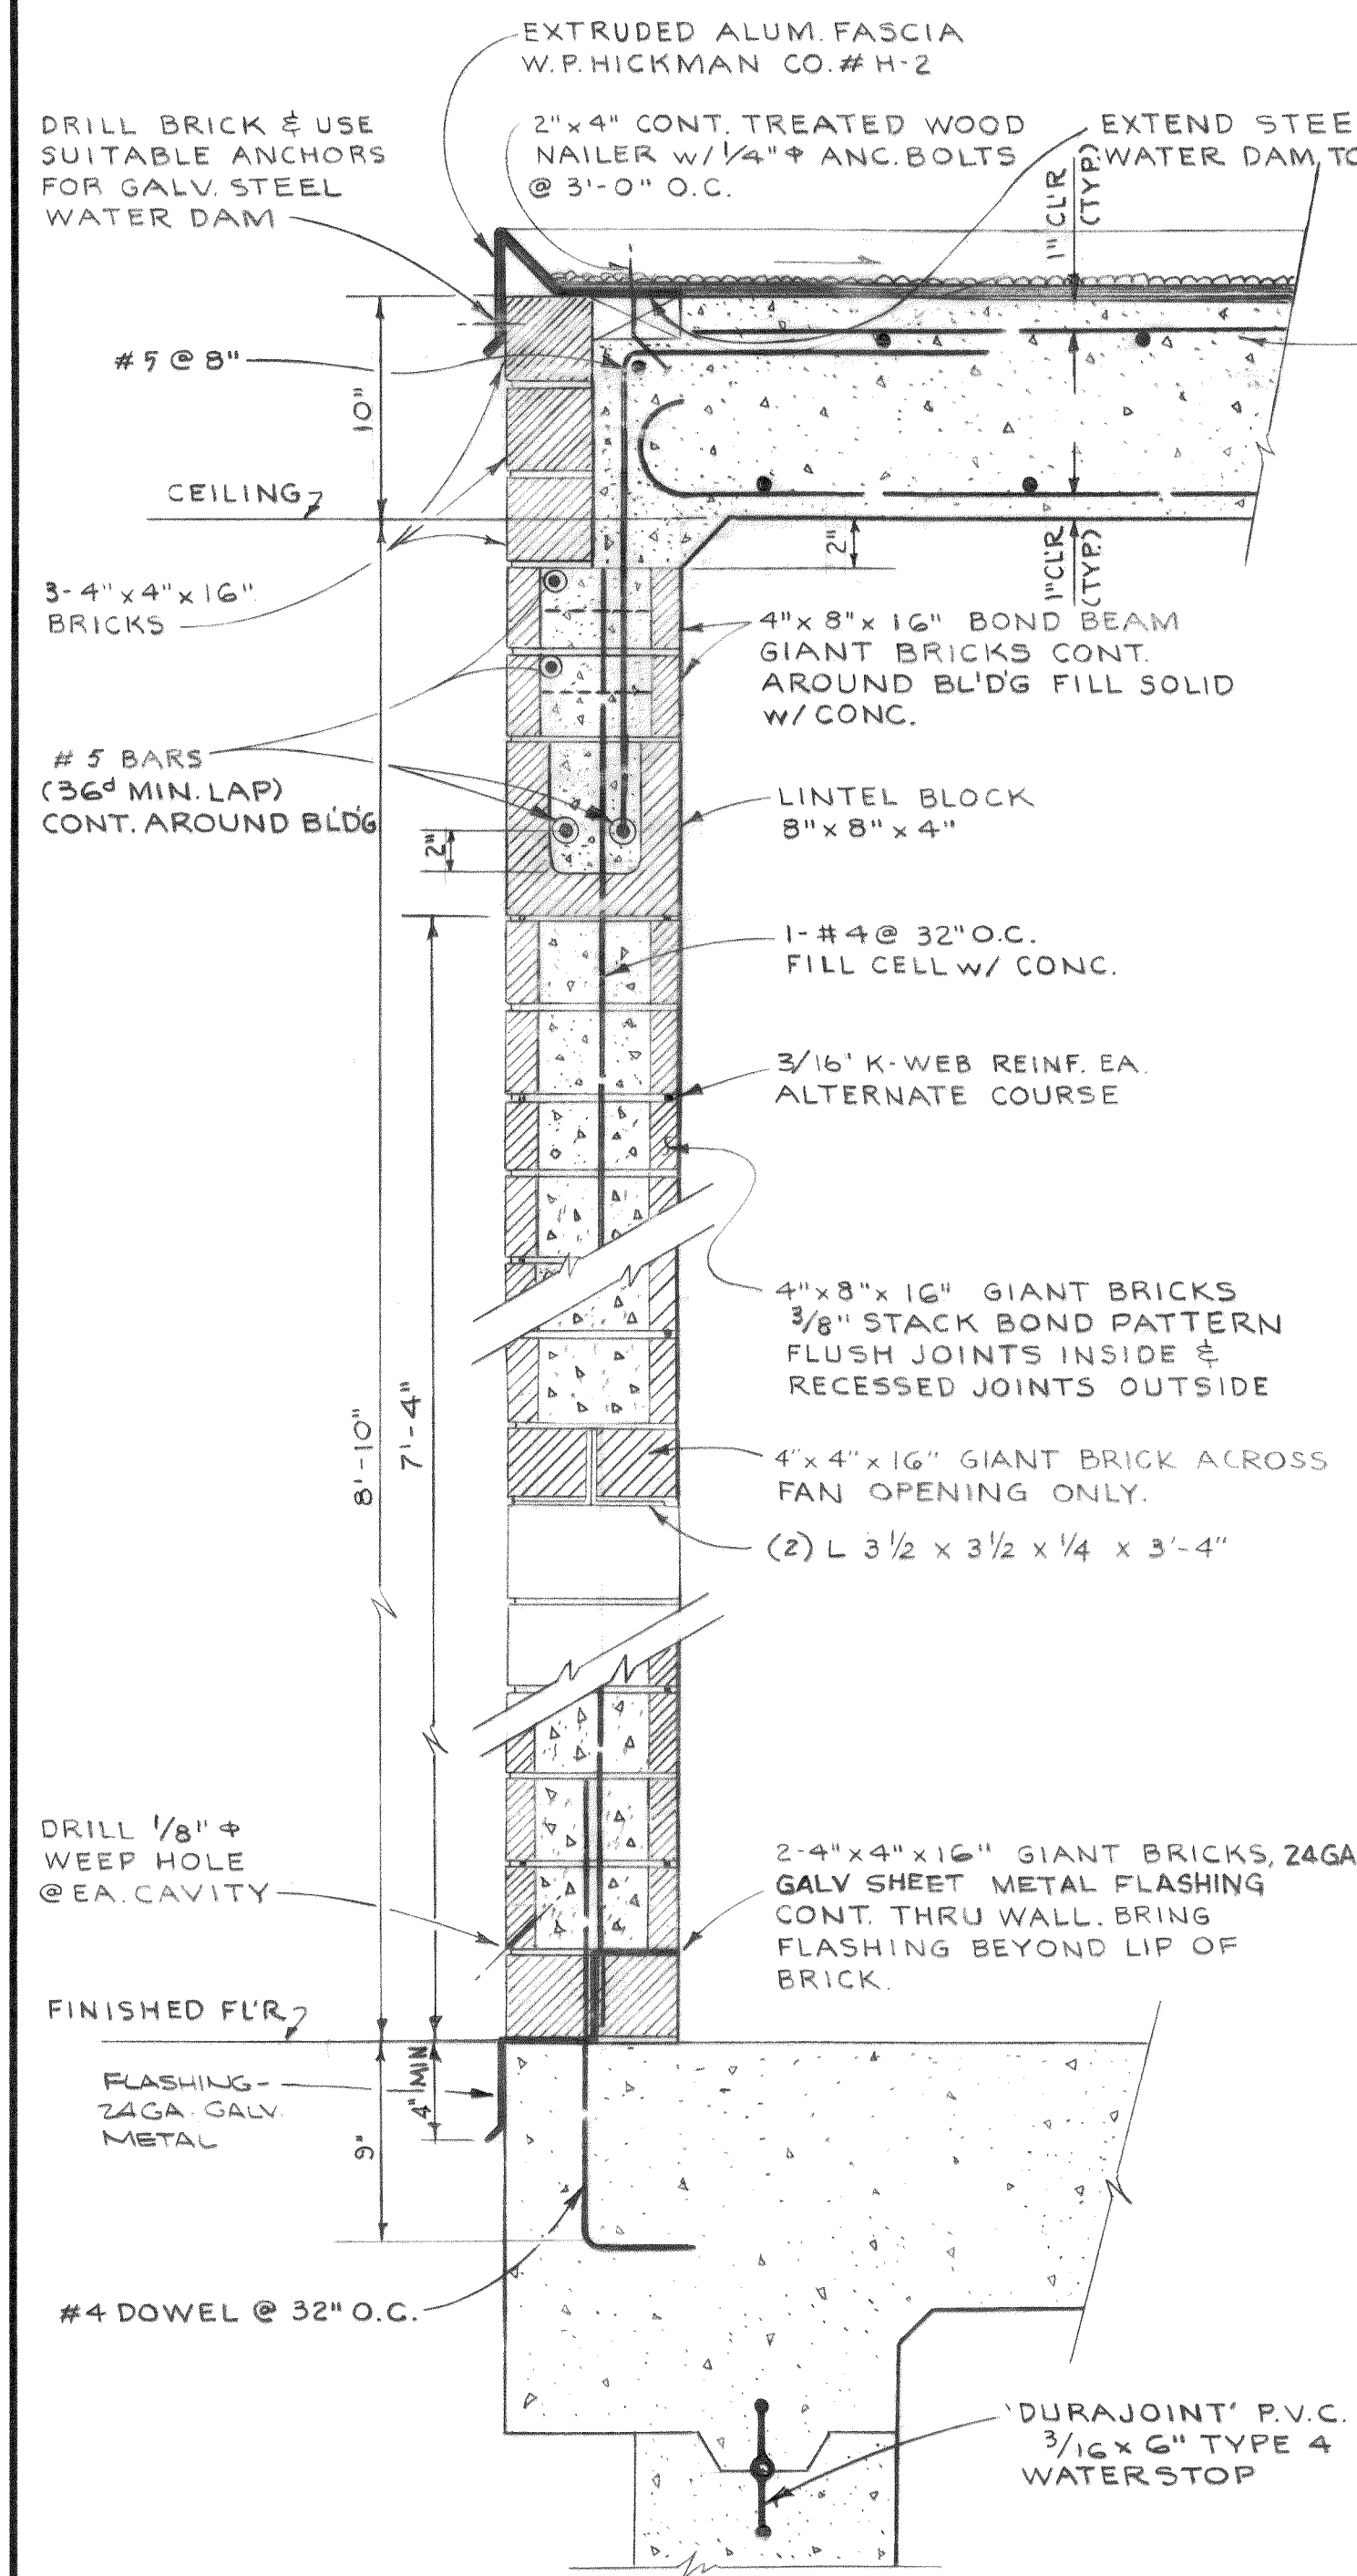


SECTION 1
EXTERIOR WALL
SCALE: 1 1/2" = 1'-0"

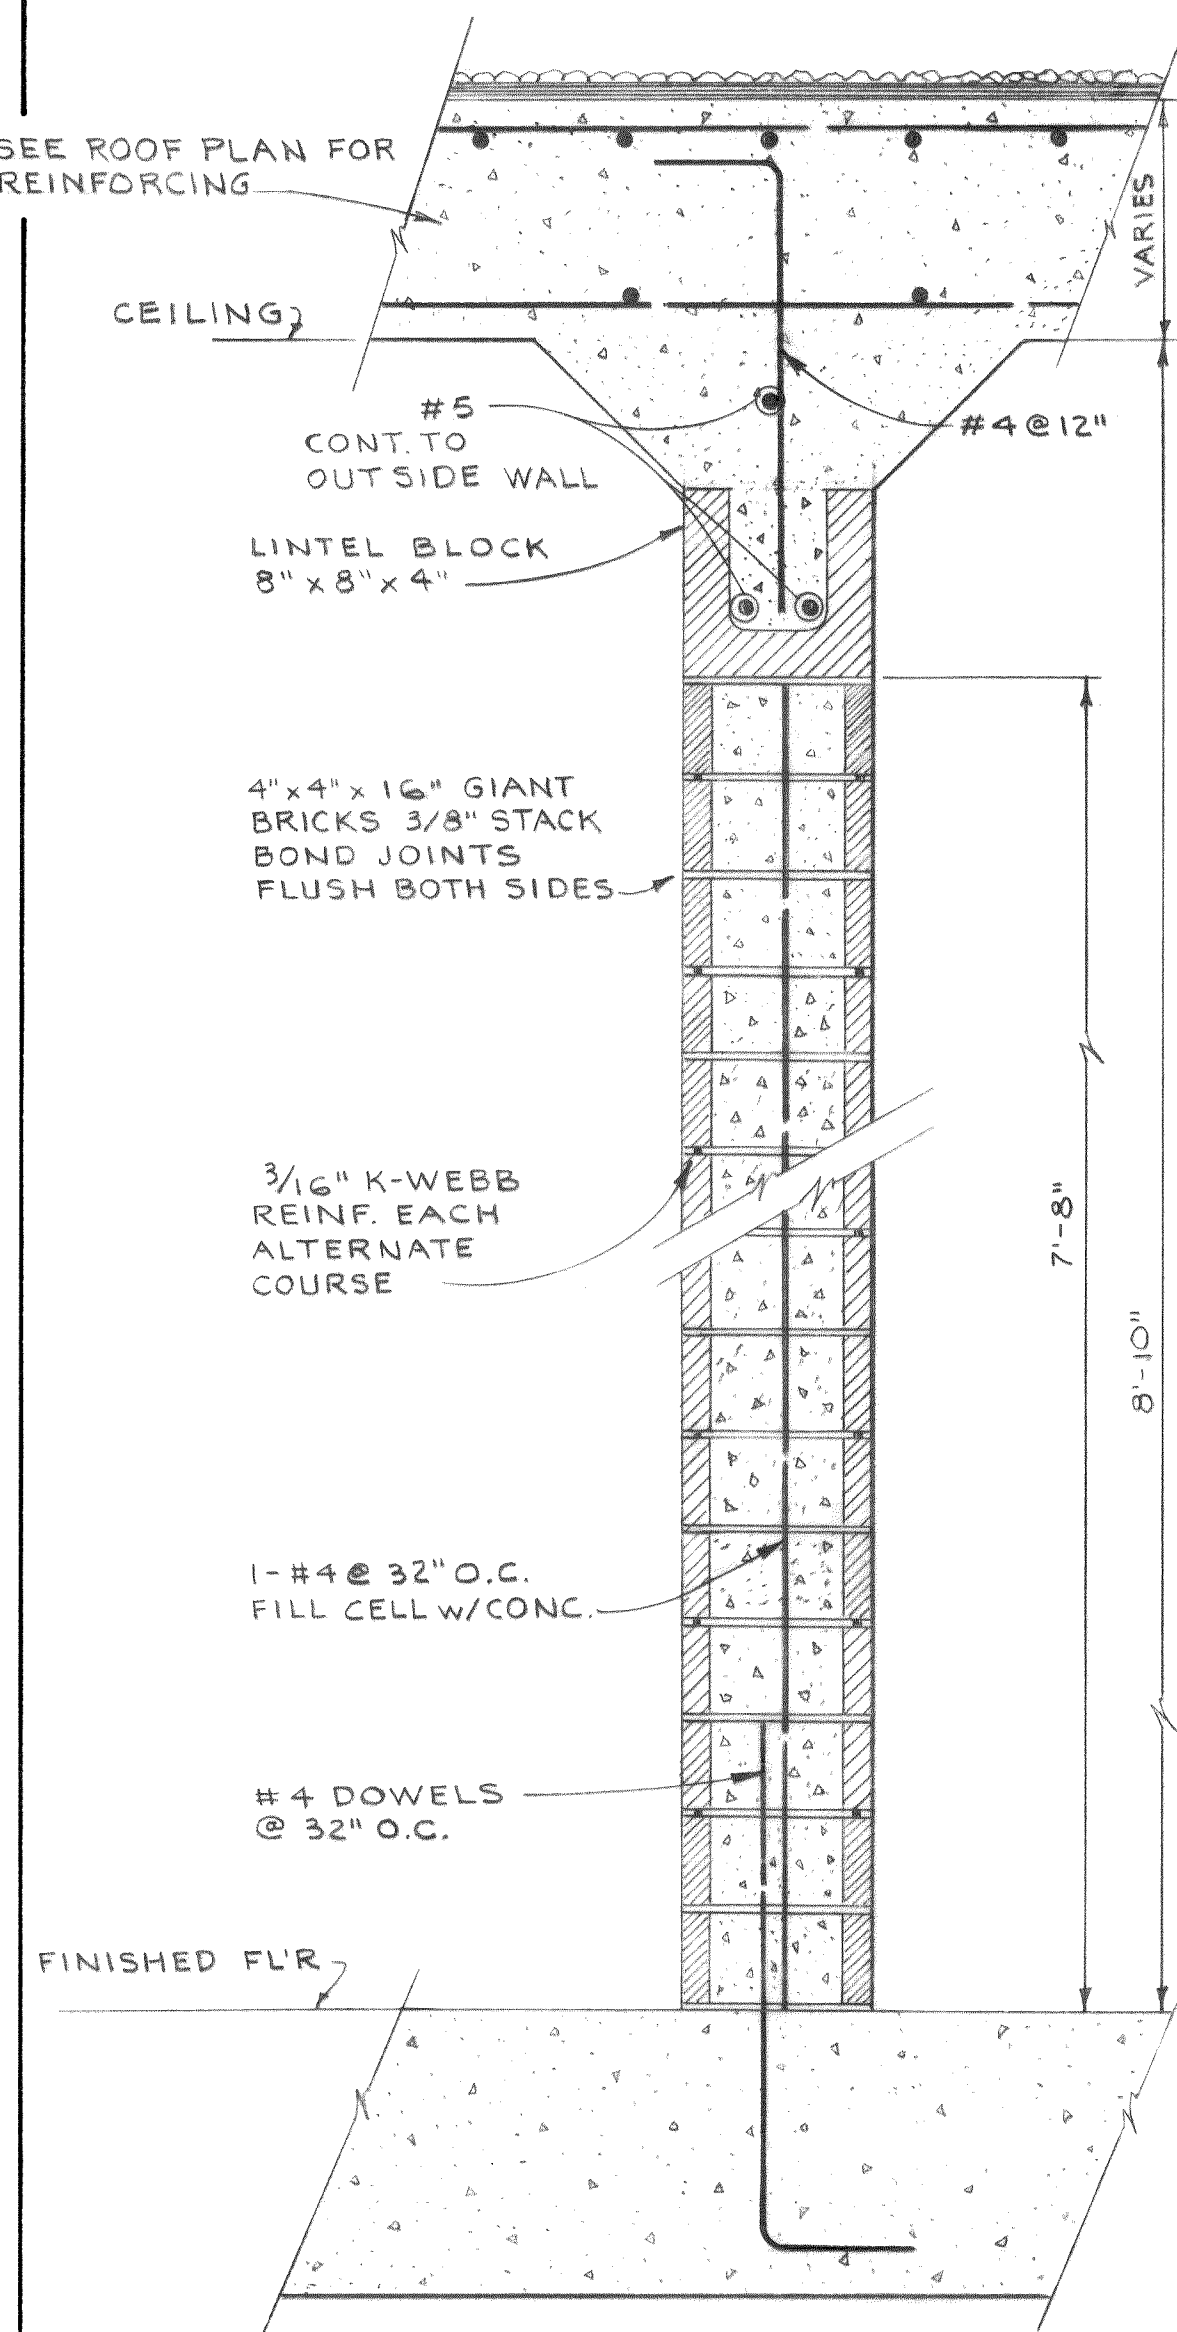


SECTION 2
INTERIOR WALL
SCALE: 1 1/2" = 1'-0"

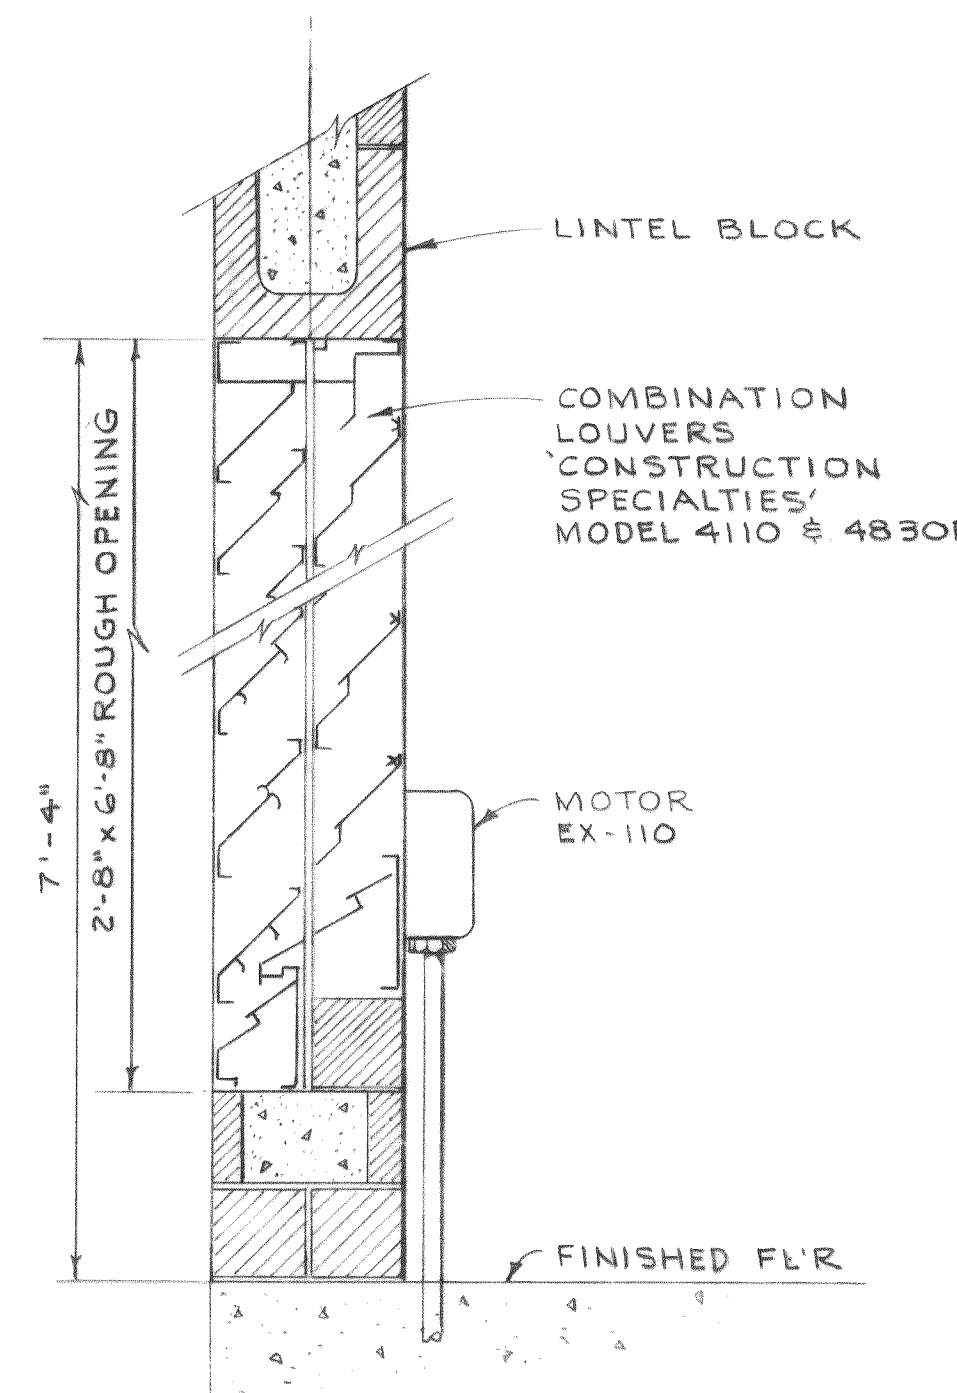


SECTION 3
AIR INTAKE LOUVER
SCALE: 3" = 1'-0"

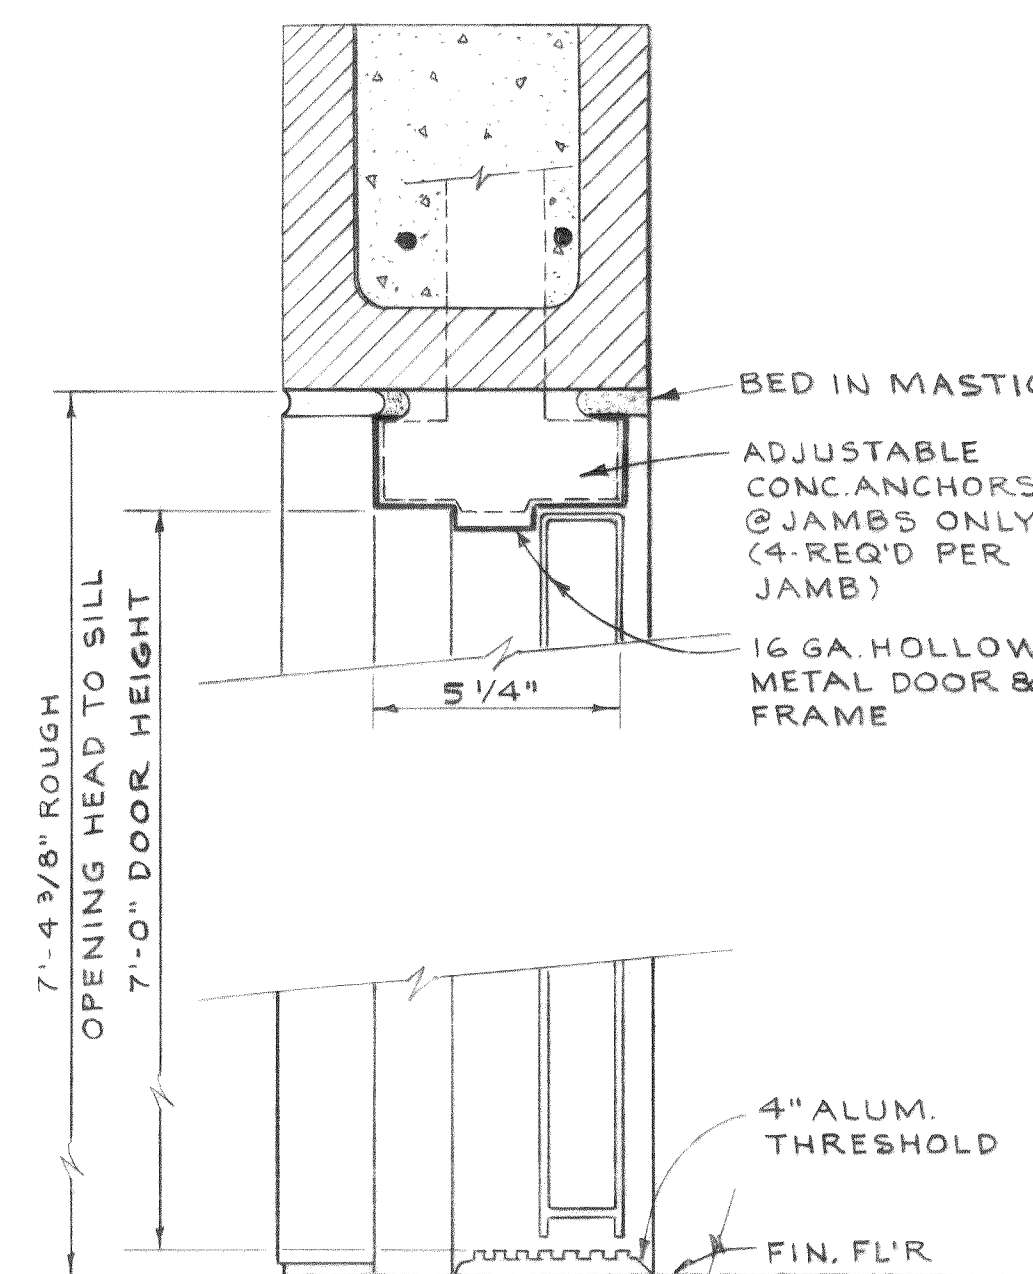


SECTION 4
DOOR
SCALE: 3" = 1'-0"

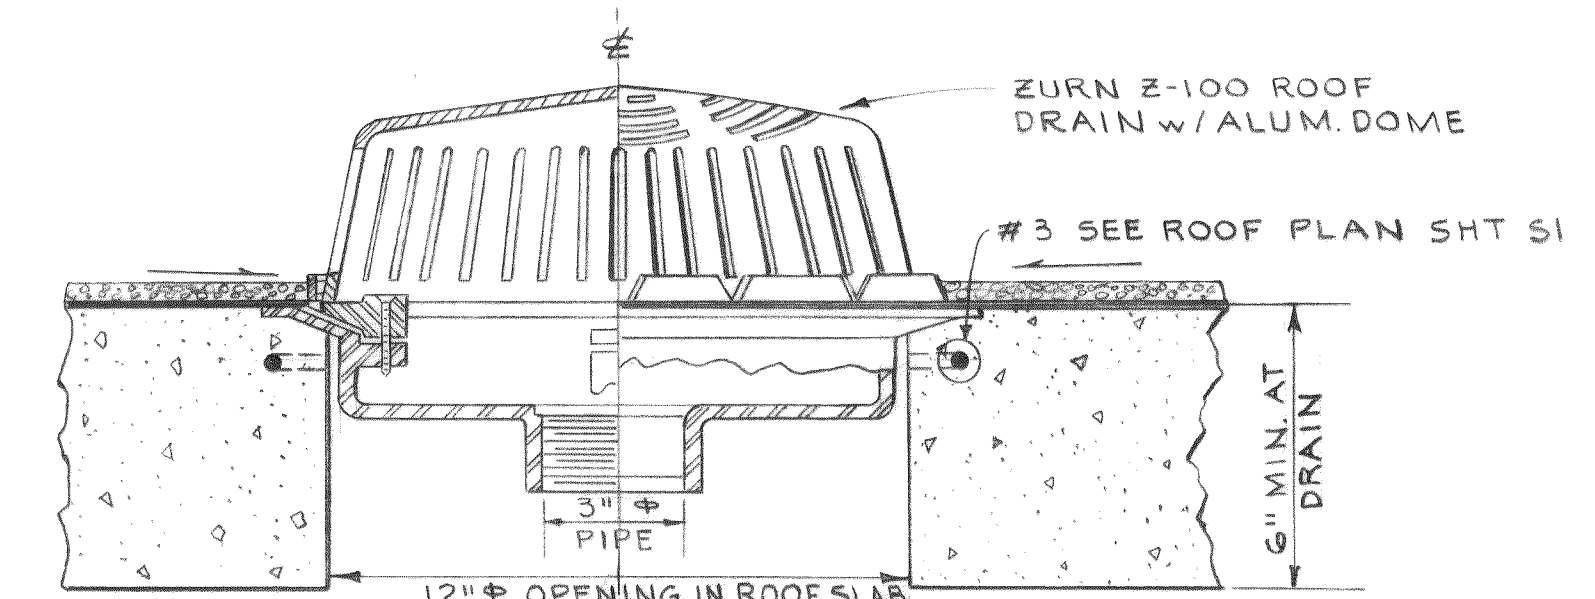



DETAIL 5
ROOF DRAIN
SCALE: 3 1/2" = 1'-0"

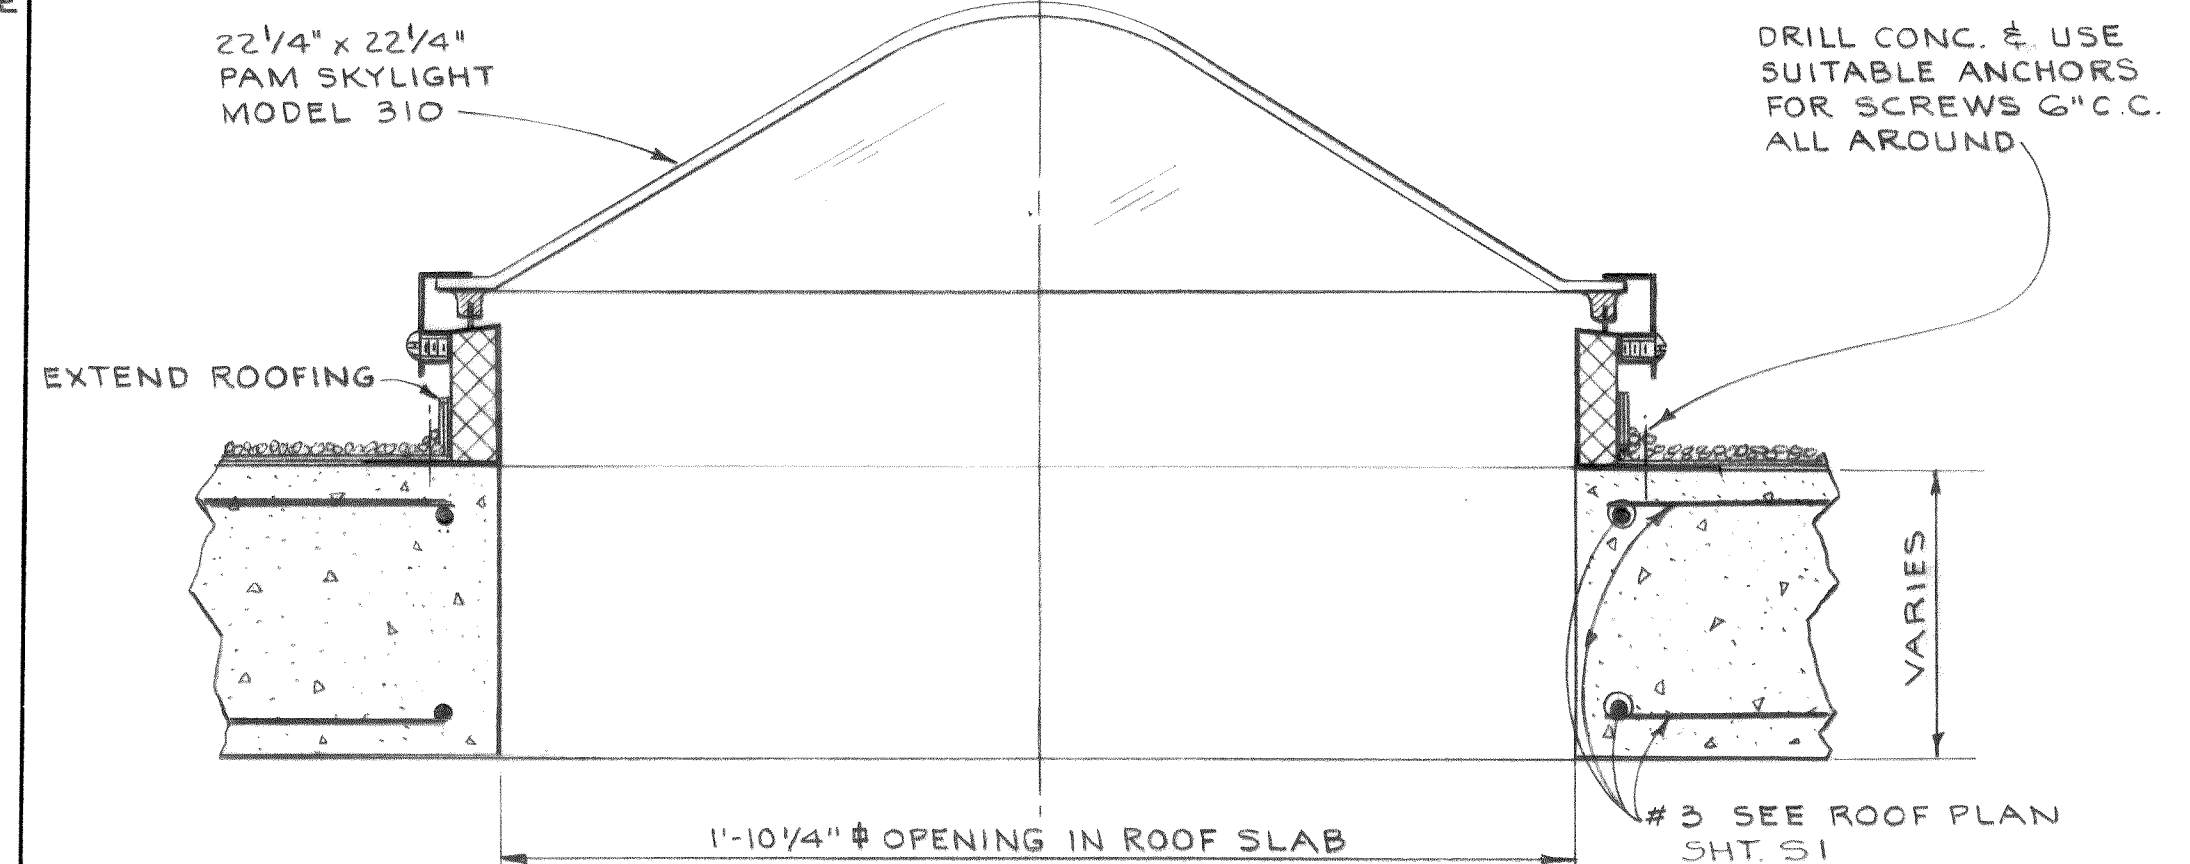

DETAIL 6
SKYLIGHT
SCALE: 3" = 1'-0"

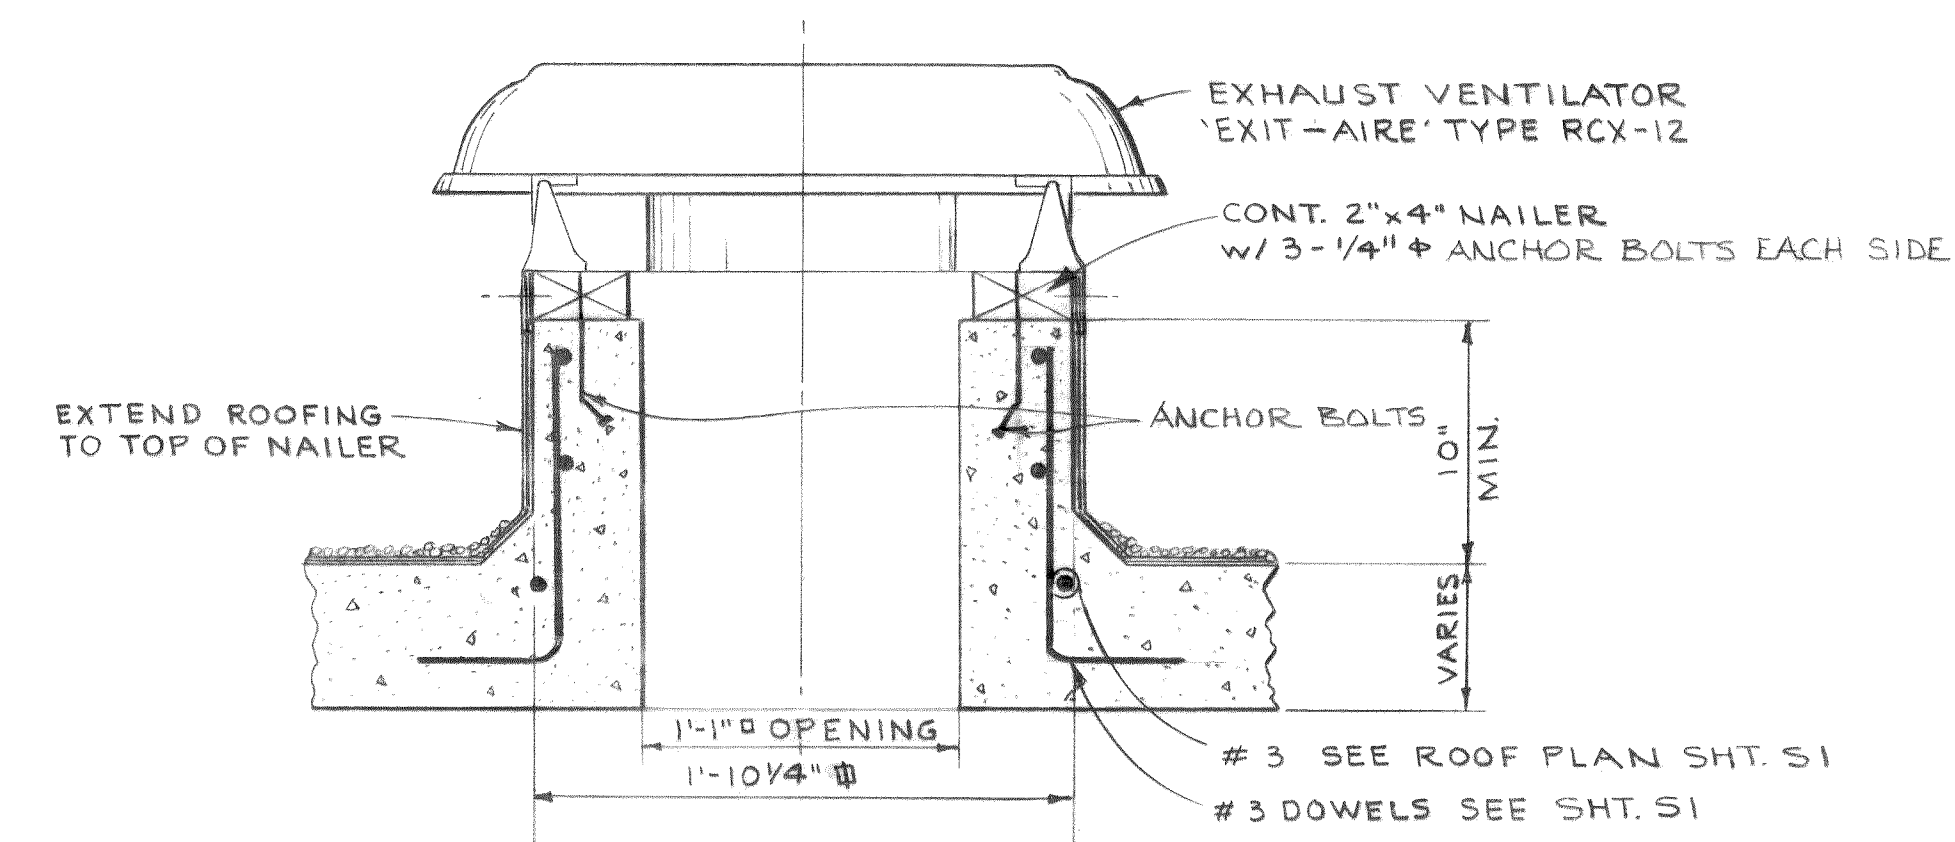

DETAIL 7
VENTILATOR
SCALE: 1 1/2" = 1'-0"

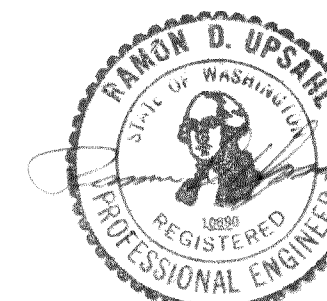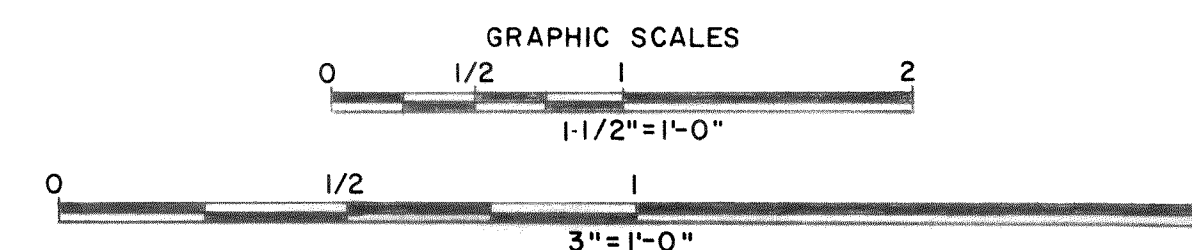

DESIGNED	RDU	APPROVED	John Runyan
DRAWN	E.J.	SCALE	AS SHOWN
DATE		DATE	JULY, 1972
NO.		FILE	71-S-425.002
REVISION			



ST
Stevens, Thompson & Runyan, Inc.
Engineers/Planners
PORTLAND SEATTLE BOISE

TOWN OF FERNDAL, WASHINGTON
AXTON ROAD INTERCEPTOR
SCHEDULE I

PUMP STATION 1 & 2
ARCHITECTURAL DETAILS

A2
2

MICROFILMED

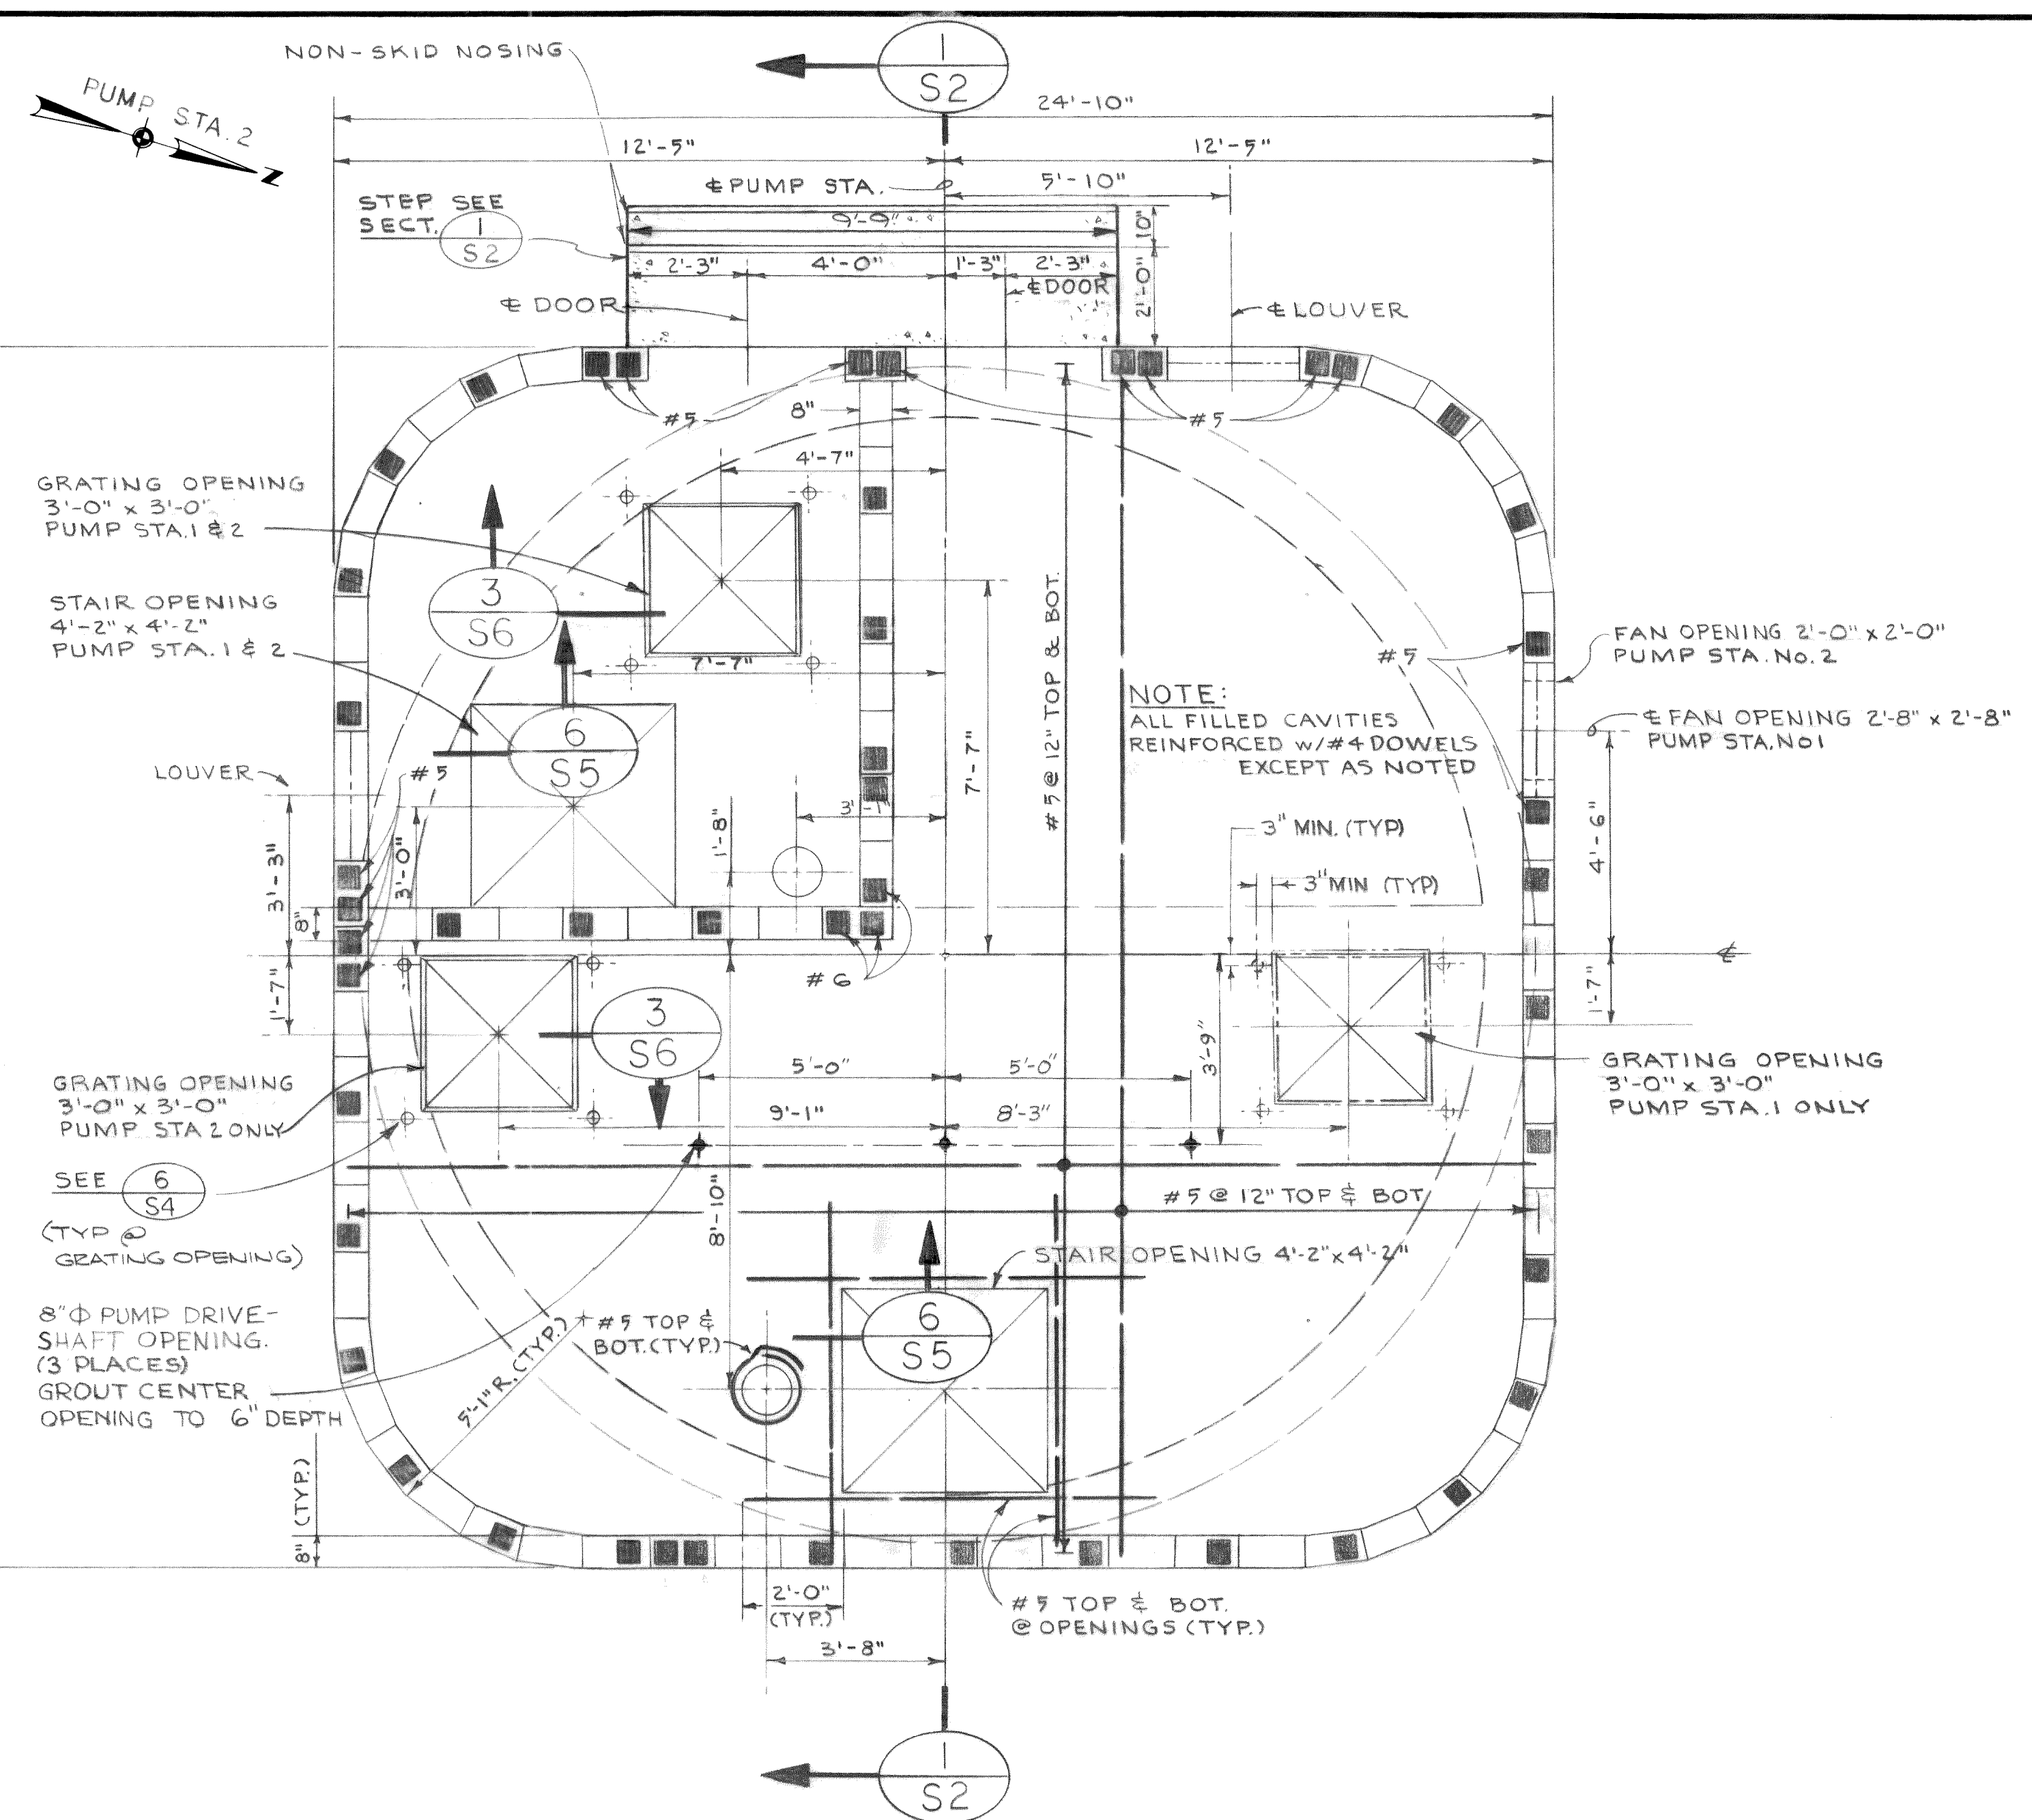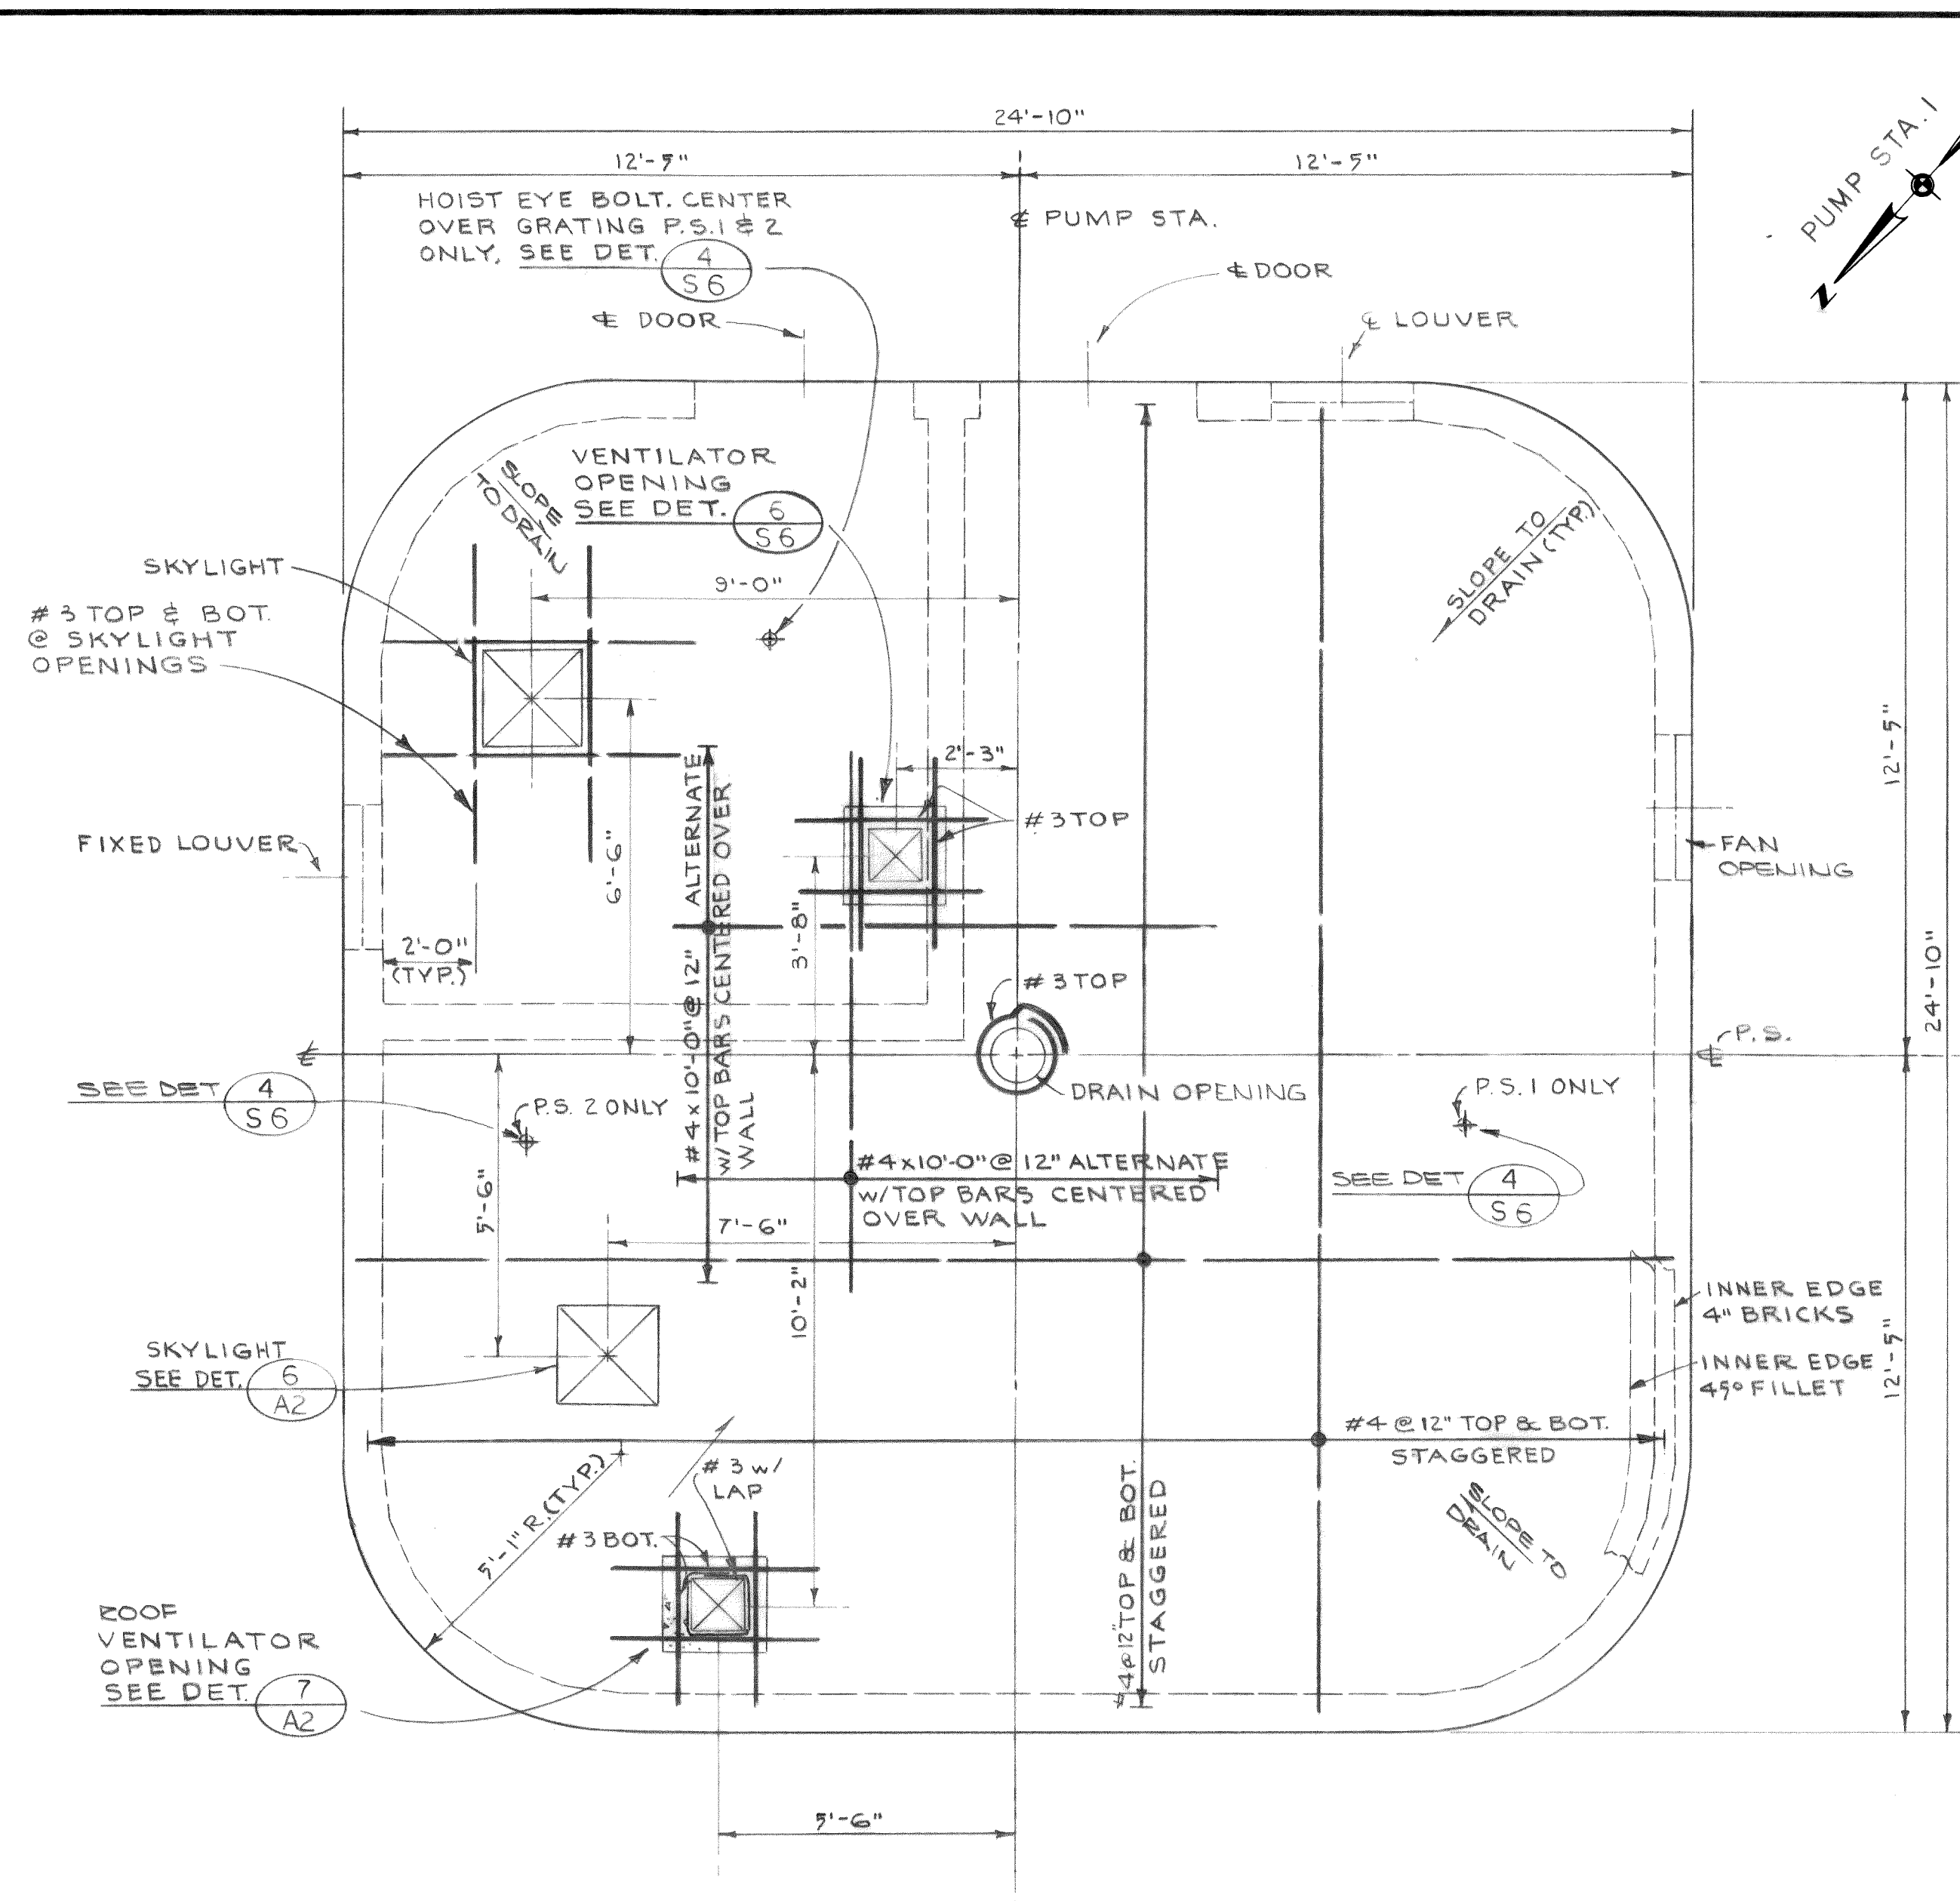

NOTES

DESIGN SPECIFICATIONS

Uniform Building Code (UBC)
American Concrete Institute (ACI)
American Institute of Steel Construction (AISC)

DESIGN LOADS

Roof Live Load	40 PSF
Floor Live Load	100 PSF + Mechanical
Wind	25 PSF
Seismic	Zone 3

GENERAL

- 1) The contractor may use other methods of construction for the foundation than those shown provided that he submit drawings and procedures to the engineer for review.
- 2) For general details and dimensions not shown on the structural drawings, see the architectural, mechanical and electrical drawings.

CONCRETE



- 1) Structural concrete is to be $f'_c = 3500$ psi @ 28 days plus 15% for test cylinders

REINFORCING STEEL

- 1) All mild steel reinforcing is to be hard grade deformed bars in accordance with ASTM A615, Grade 60. Detail and place as per ACI Manual 315 and Code 318.

MISC. METAL

- 1) All structural steel is to be ASTM A-36
- 2) Steel machine bolts to be ASTM A-307.
- 3) All aluminum shapes and plates to be 6061-T6
- 4) Stainless steel bolts to be type 304.

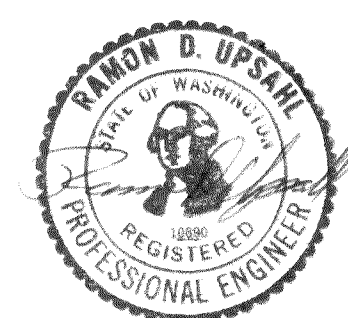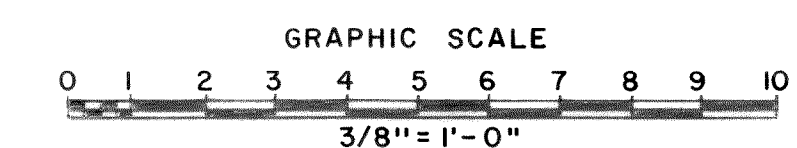

				DESIGNED RDU	APPROVED <i>[Signature]</i>
				DRAWN E. J.	SCALE AS SHOWN DATE JULY, 1972
DATE	NO.	REVISION	BY	CHECKED <i>[Signature]</i>	FILE 71-S-425.002



Stevens, Thompson & Runyan, Inc.
Engineers/Planners



PORTLAND SEATTLE BOISE

TOWN OF FERNDALE, WASHINGTON
AXTON ROAD INTERCEPTOR
SCHEDULE I

PUMP STATION 1 & 2 STRUCTURAL ROOF & FLOOR PLANS

SI	6
----	---

MICROFILMED

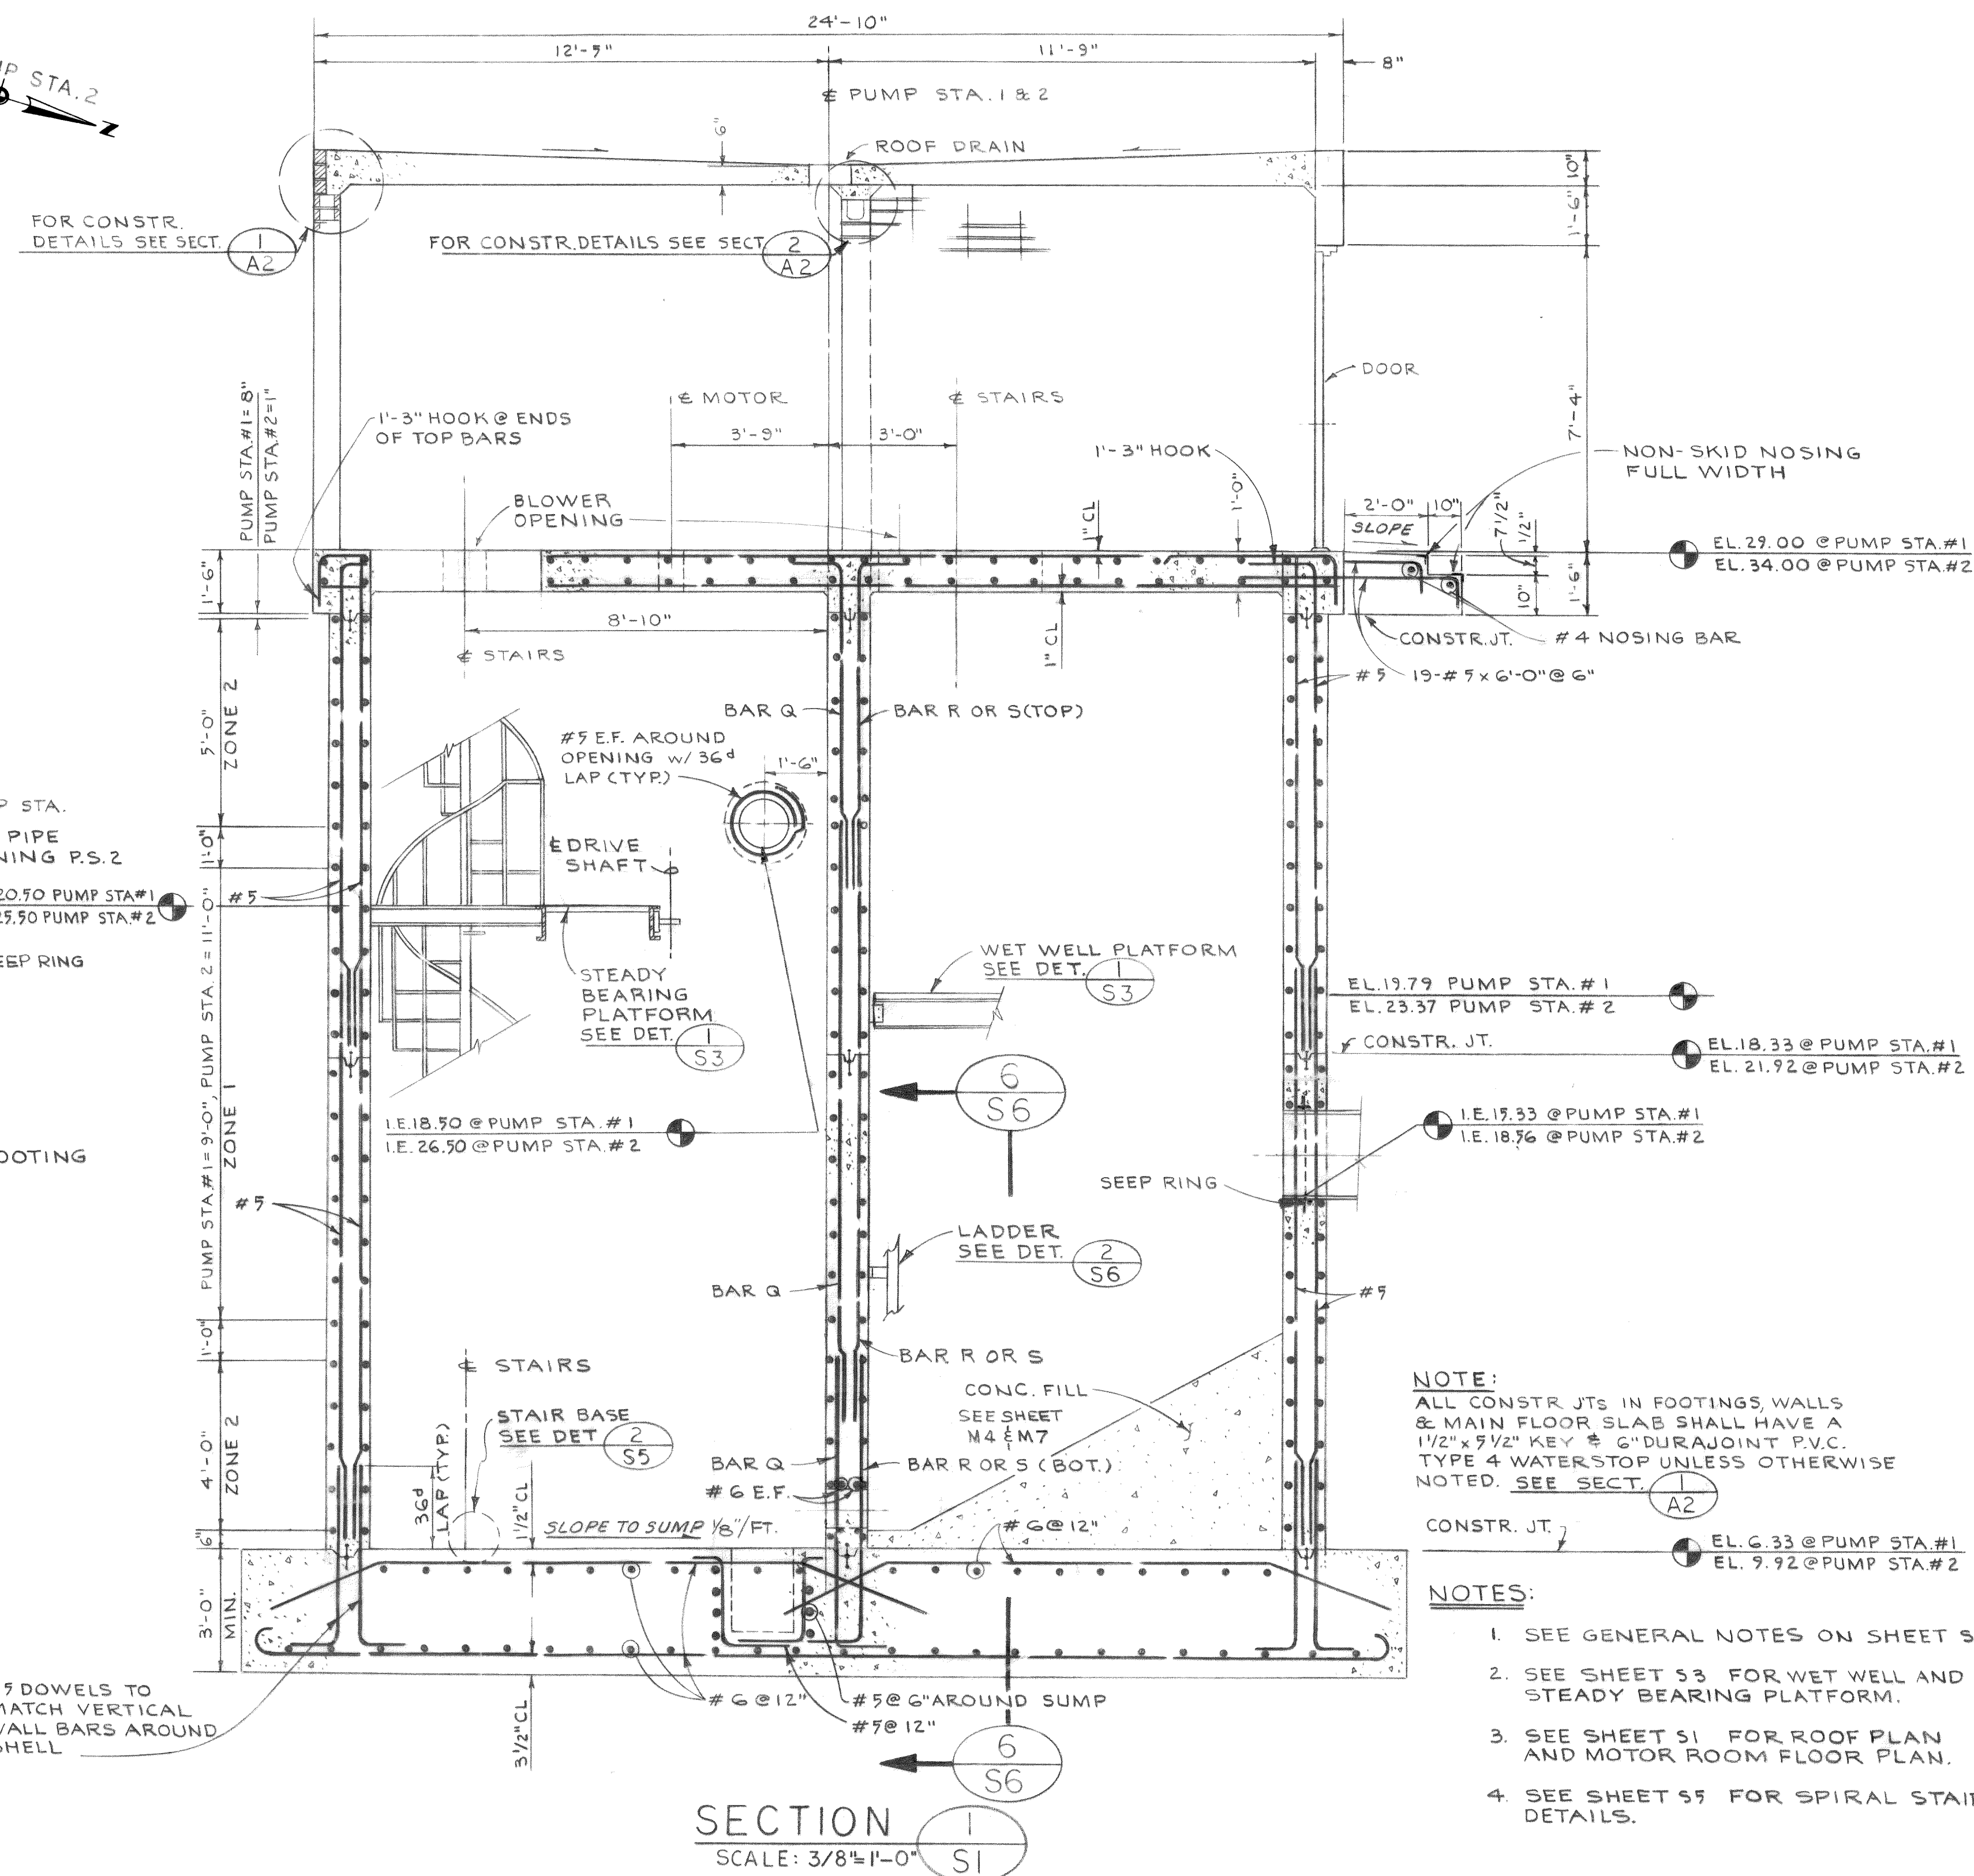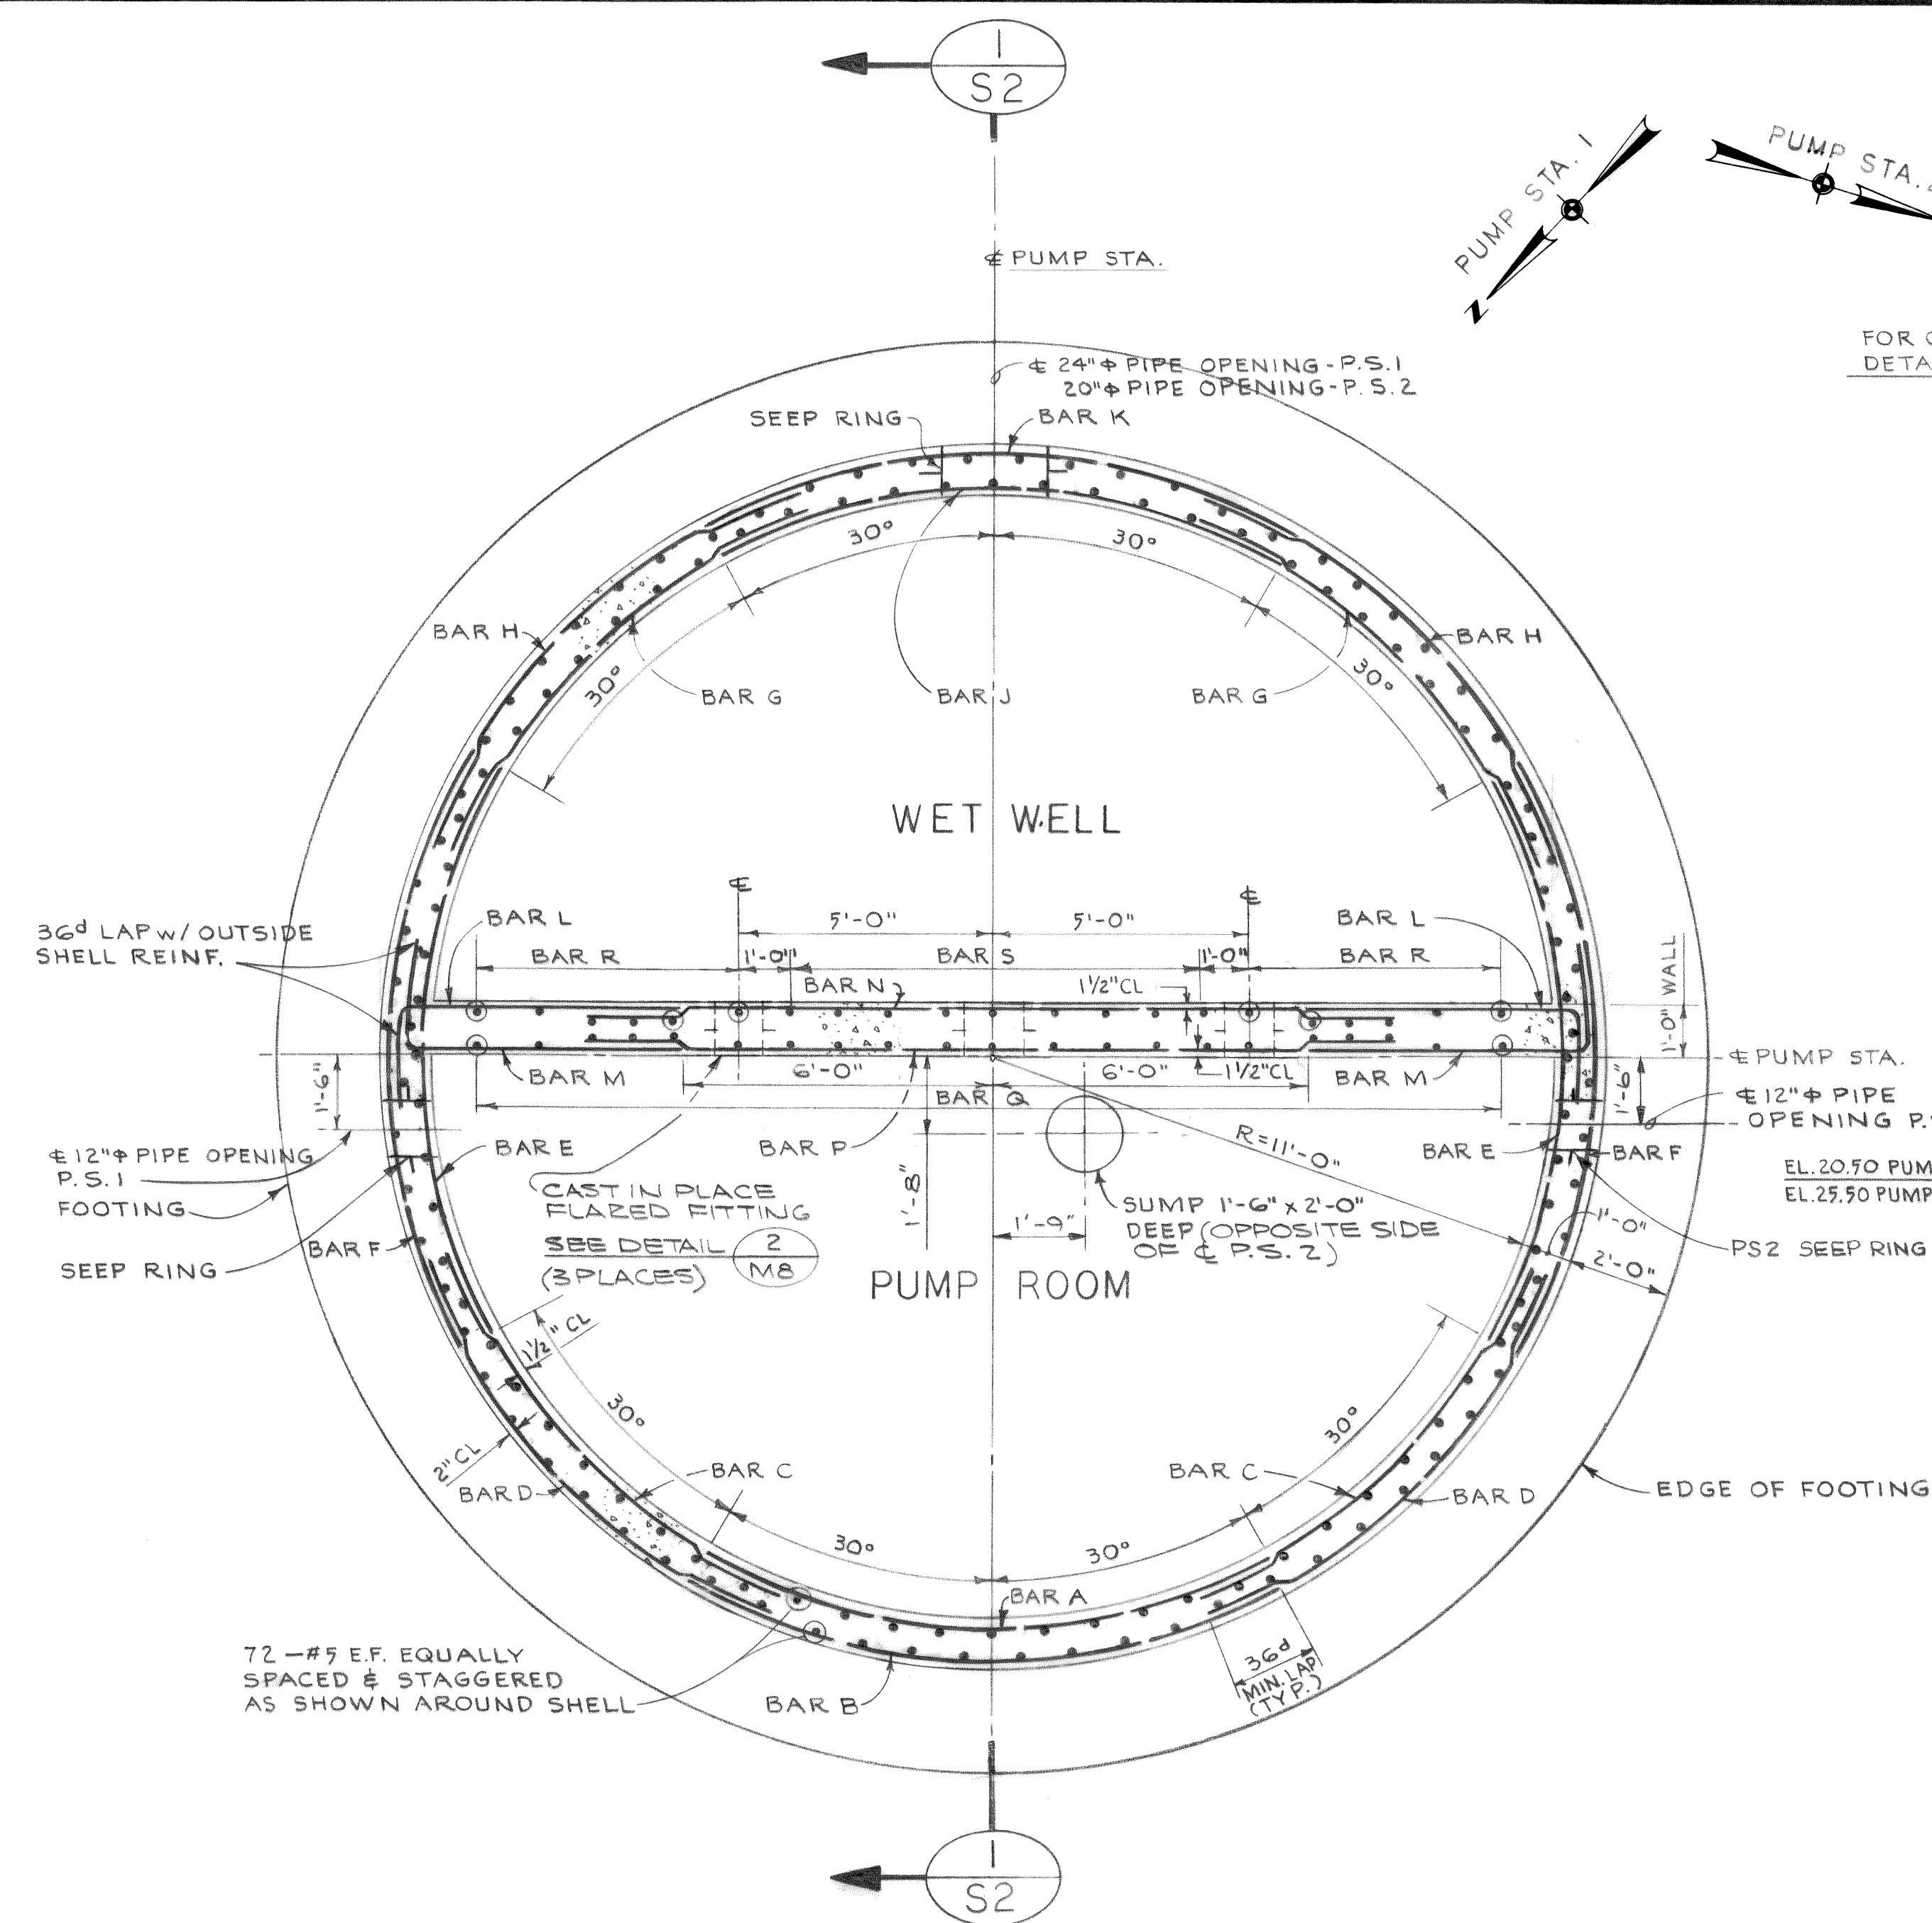

REINFORCING BAR SCHEDULE																	
BAR ZONE	A	B	C	D	E	F	G	H	J	K	L	M	N	P	Q	R	S
1	# 4@12"	# 4@12"	# 4@12"	# 4@12"	# 5@12"	# 6@12"	# 6@12"	# 6@12"	# 6@12"	# 6@12"	# 7@6"	# 6@12"	# 5@12"	# 6@6"	# 6@12"	# 5@12"	# 5@12"
2	# 4@12"	# 4@12"	# 4@12"	# 4@12"	# 5@12"	# 5@12"	# 4@12"	# 4@12"	# 4@12"	# 4@12"	# 5@12"	# 5@12"	# 5@12"	# 5@12"	# 5@12"	# 8@12"	# 7@12" Top # 8@12" Bottom

				DESIGNED <i>RDU</i>	APPROVED <i>Paul Herman</i>
				DRAWN <i>E. J.</i>	SCALE <i>AS SHOWN</i> DATE <i>JULY, 1972</i>
DATE	NO.	REVISION	BY	CHECKED <i>AKS</i>	FILE <i>71-S-425.002</i>



Stevens, Thompson & Runyan, Inc.
Engineers/Planners

PORTLAND SEATTLE BOISE


TOWN OF FERNDALE, WASHINGTON
AXTON ROAD INTERCEPTOR
SCHEDULE I

PUMP STATION 1 & 2 STRUCTURAL WALL PLAN & SECTION


S2

MICROFILMED




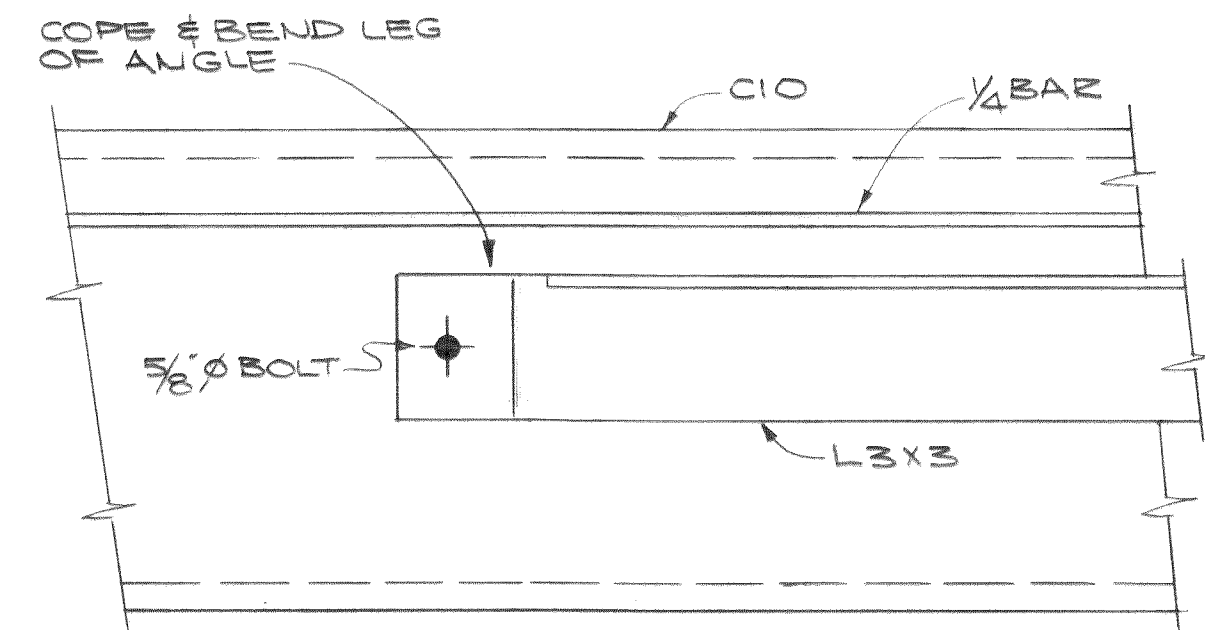


DETAIL 7
SCALE: 3"=1'-0" S3

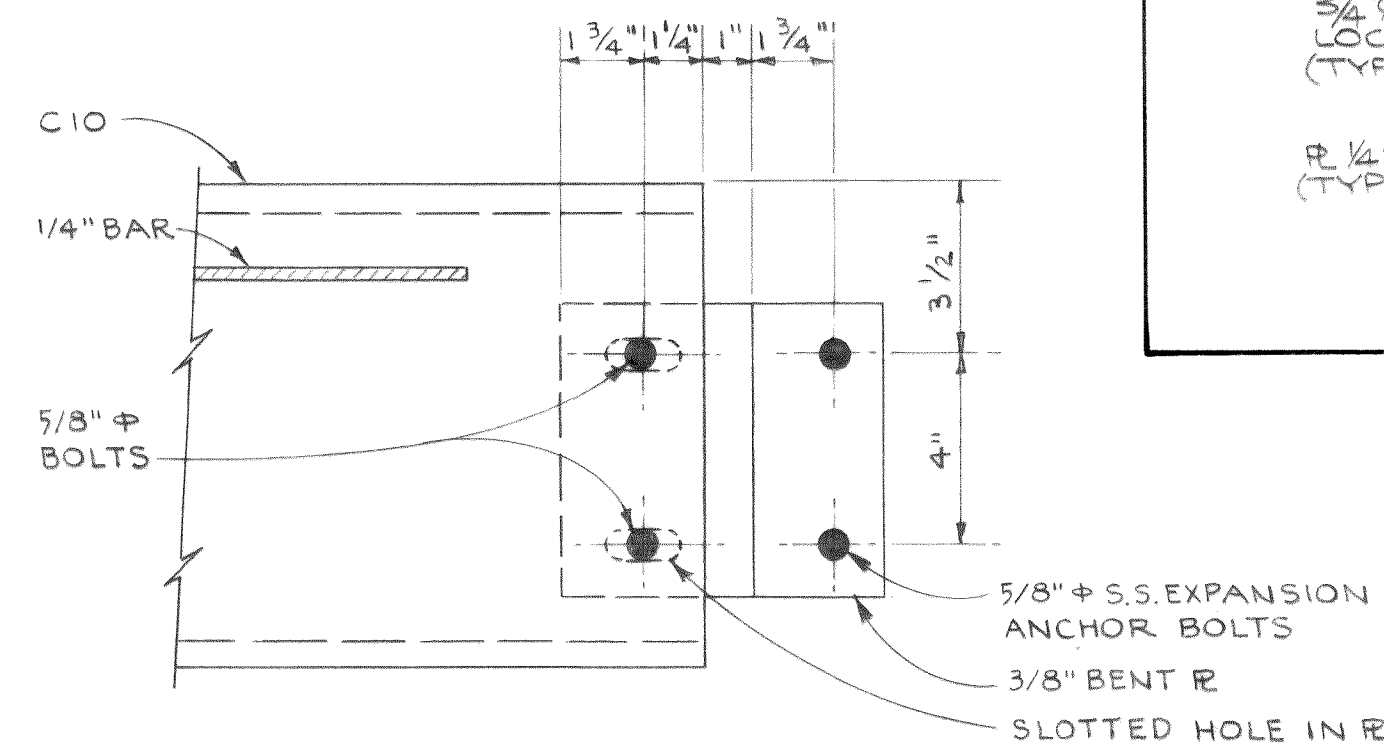


SECTION 1
SCALE: 3"=1'-0" S3

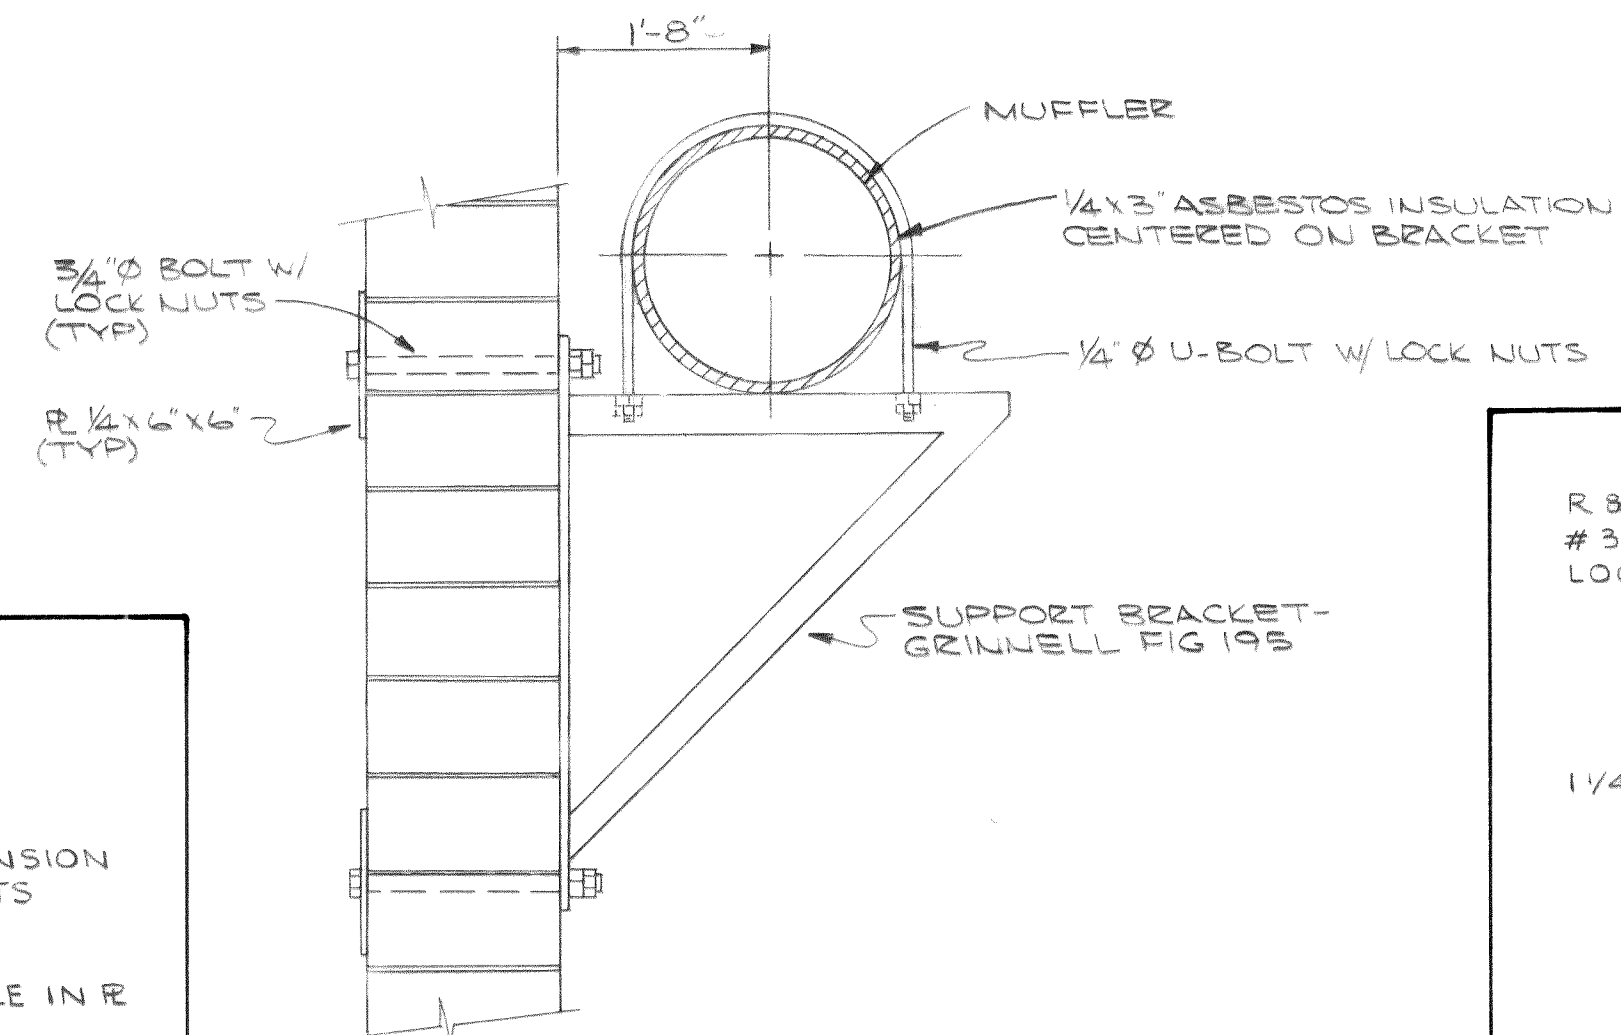


DETAIL 7
GENERATOR MUFFLER SUPPORT
NO SCALE M2

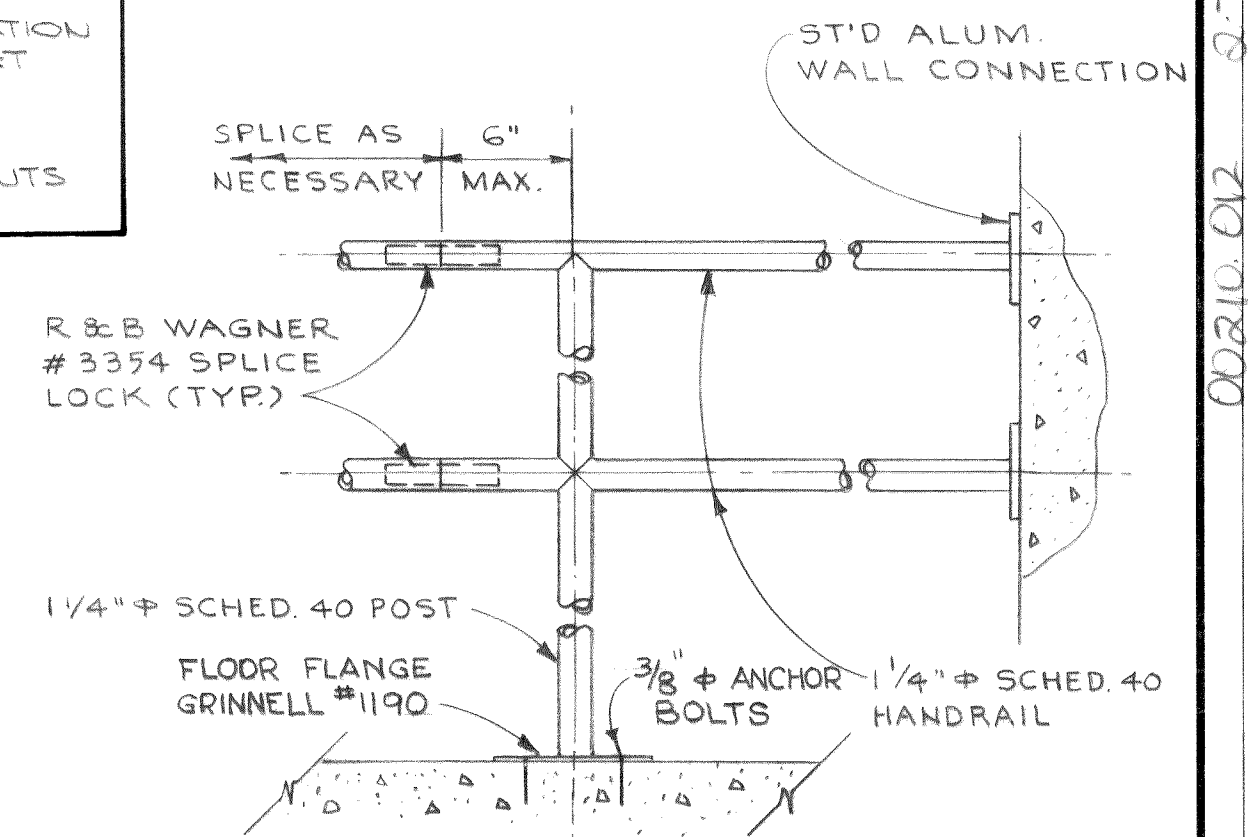


DETAIL 5
SCALE: 1 1/2"=1'-0" M4

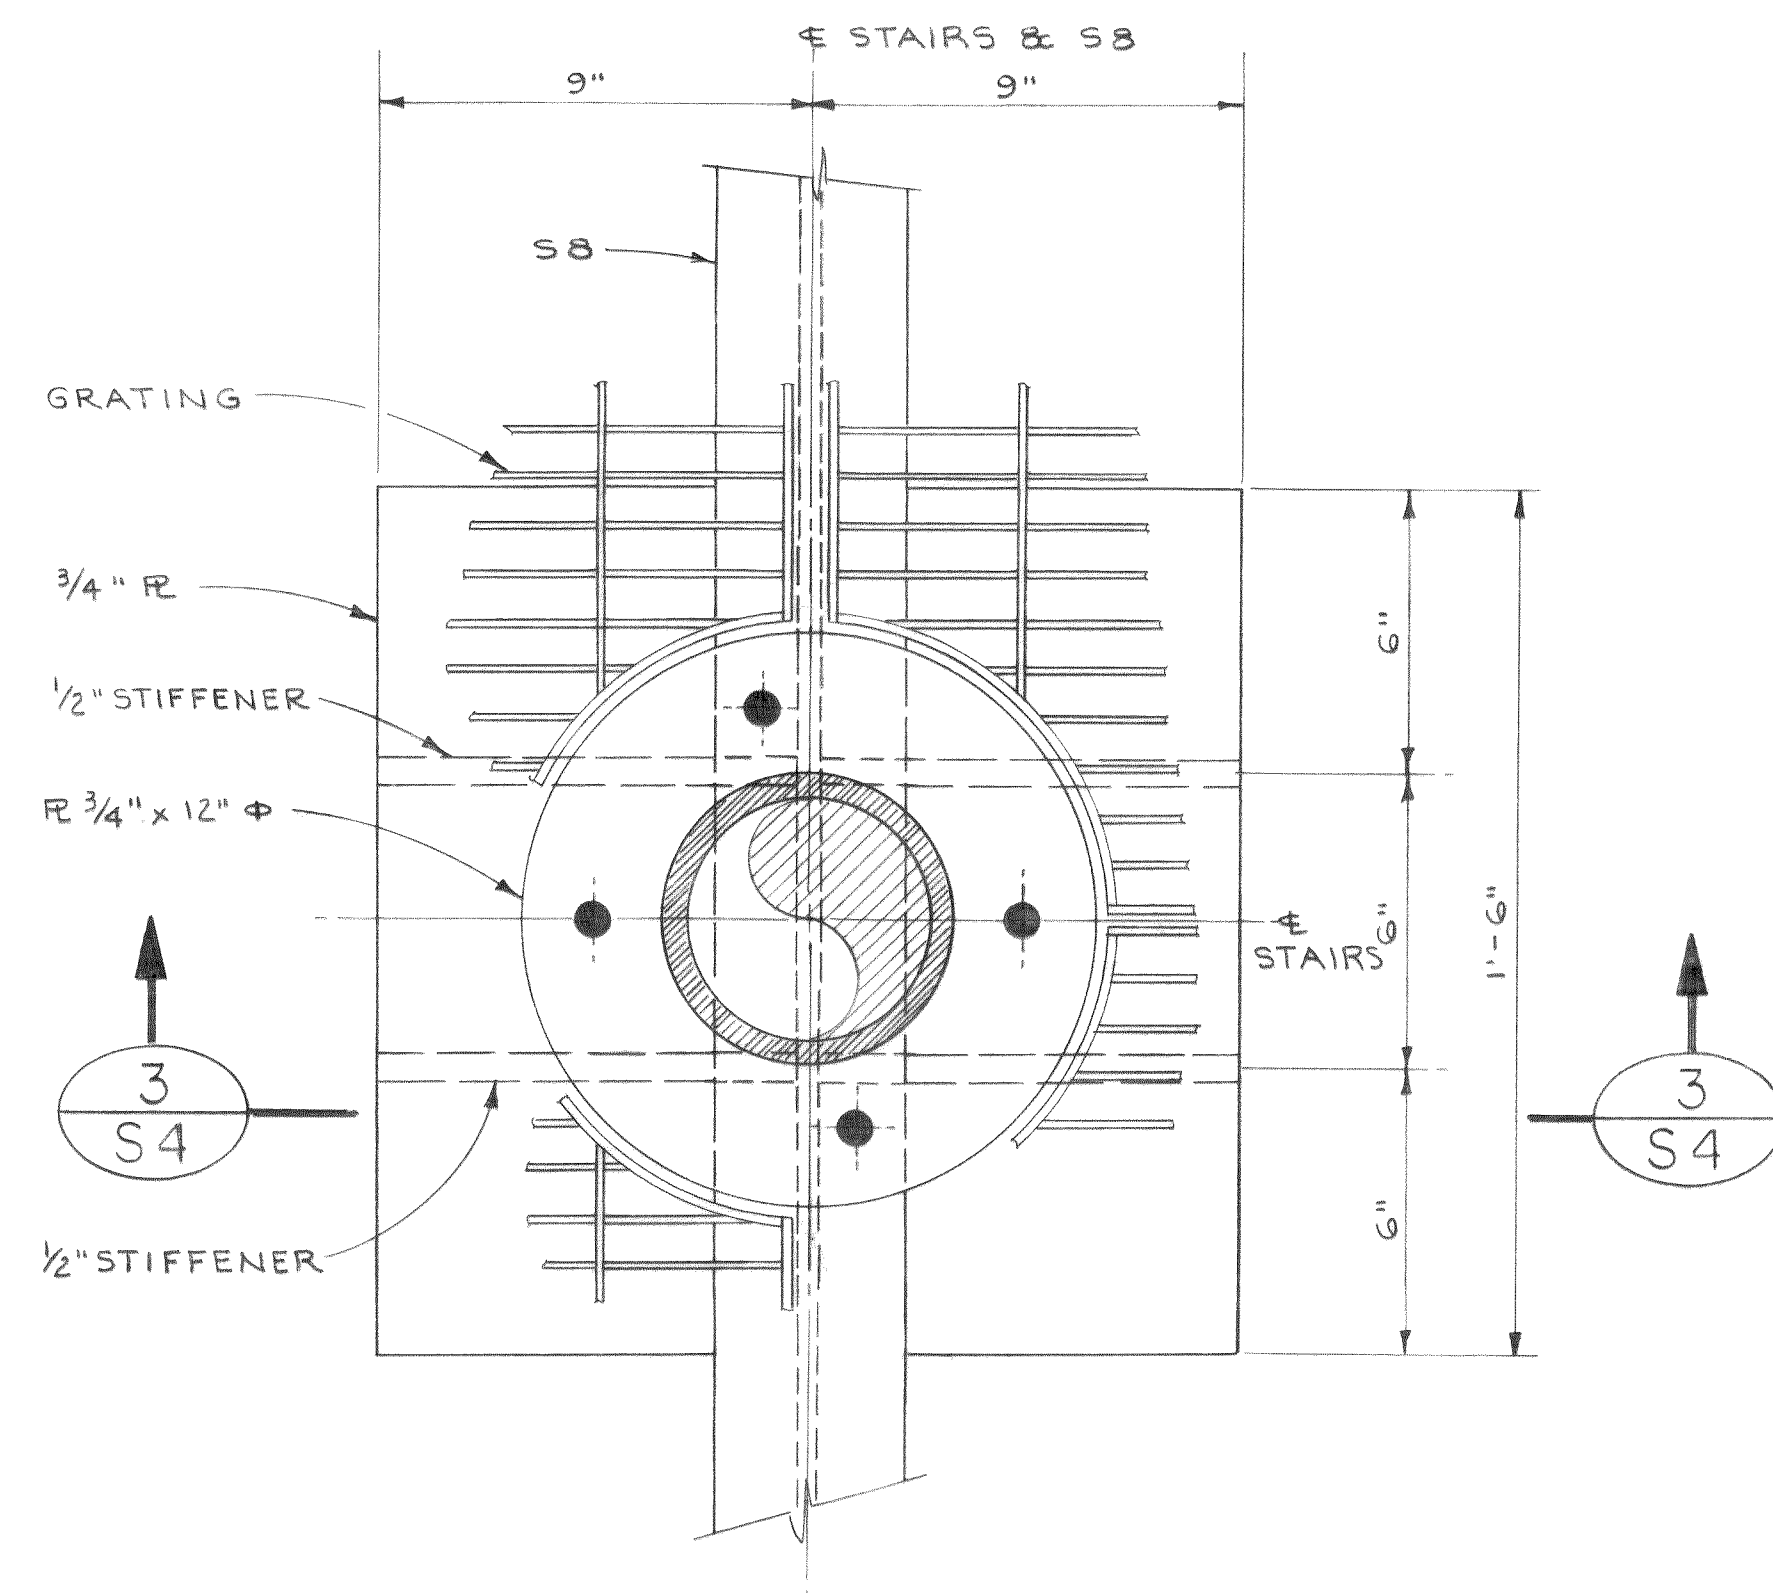


DETAIL 2
SCALE: 3"=1'-0" S3

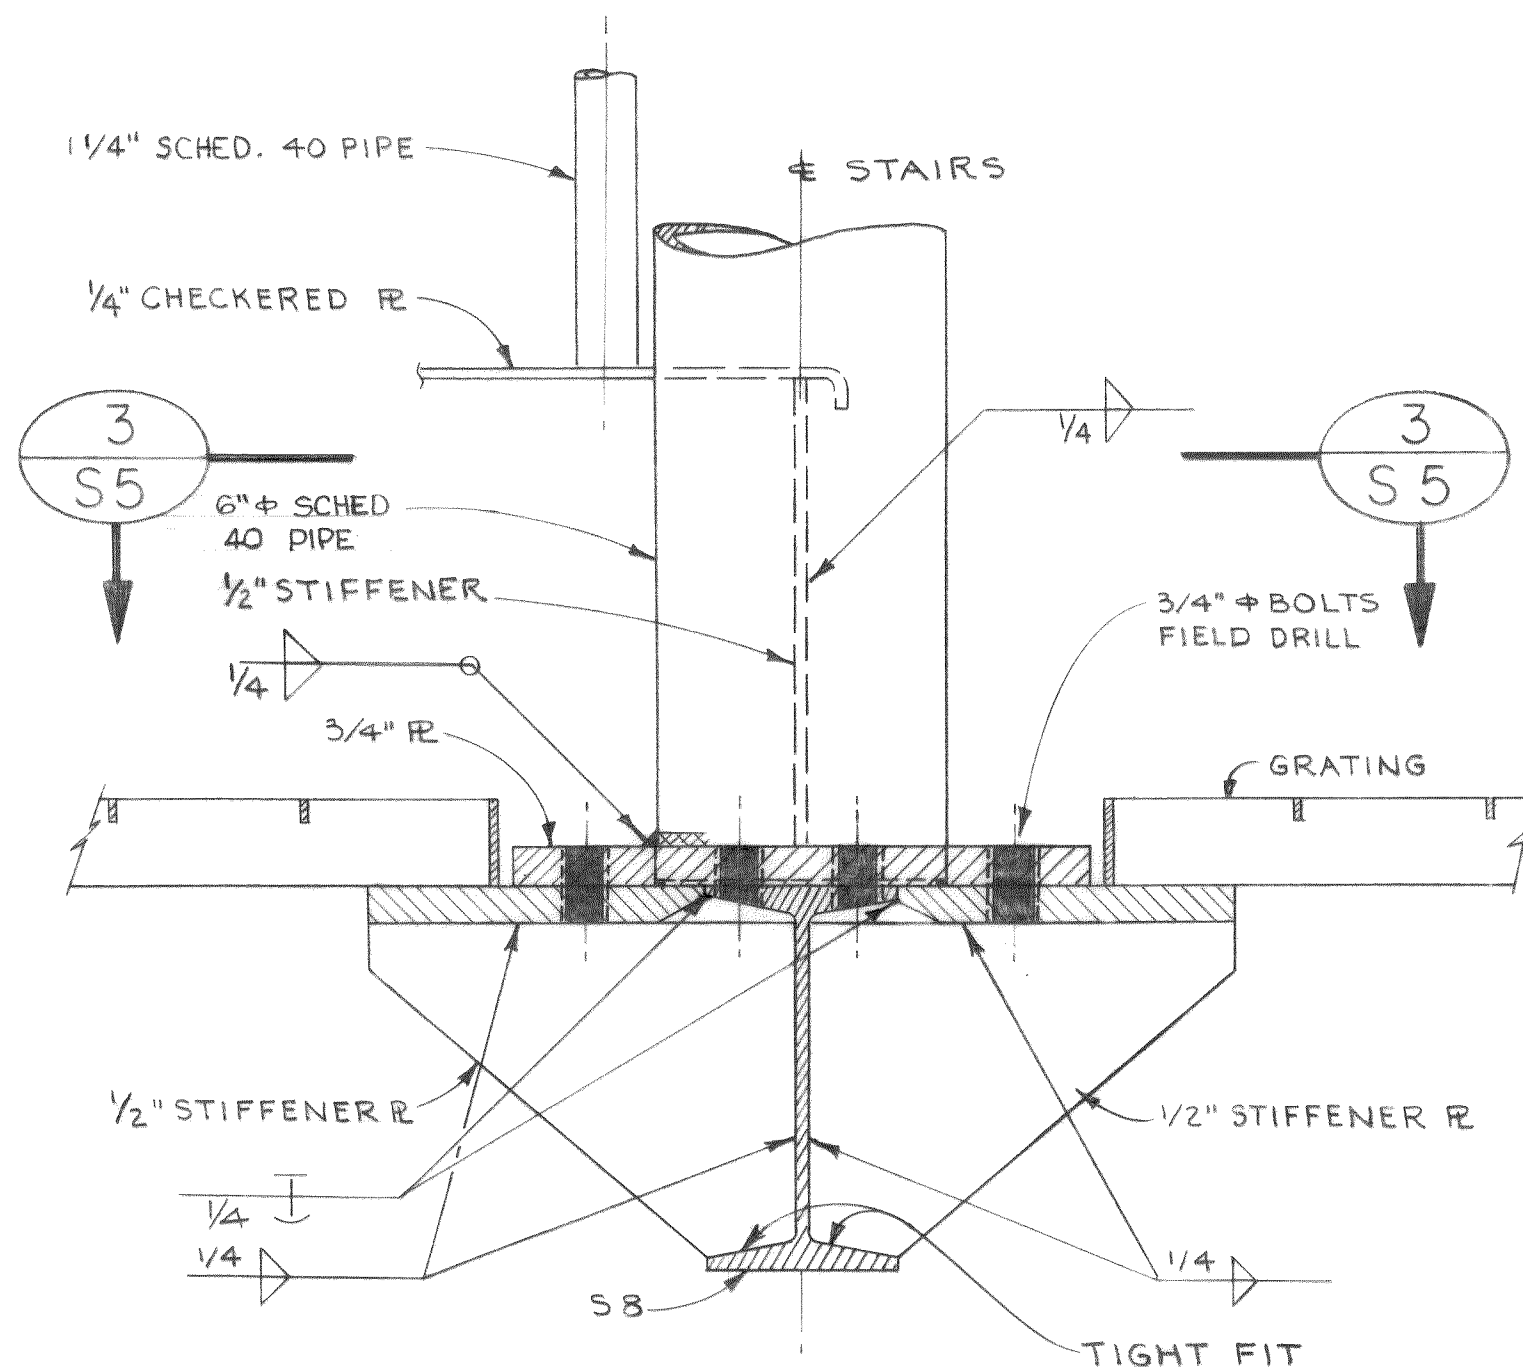


SECTION 3
SCALE: 3"=1'-0" S4

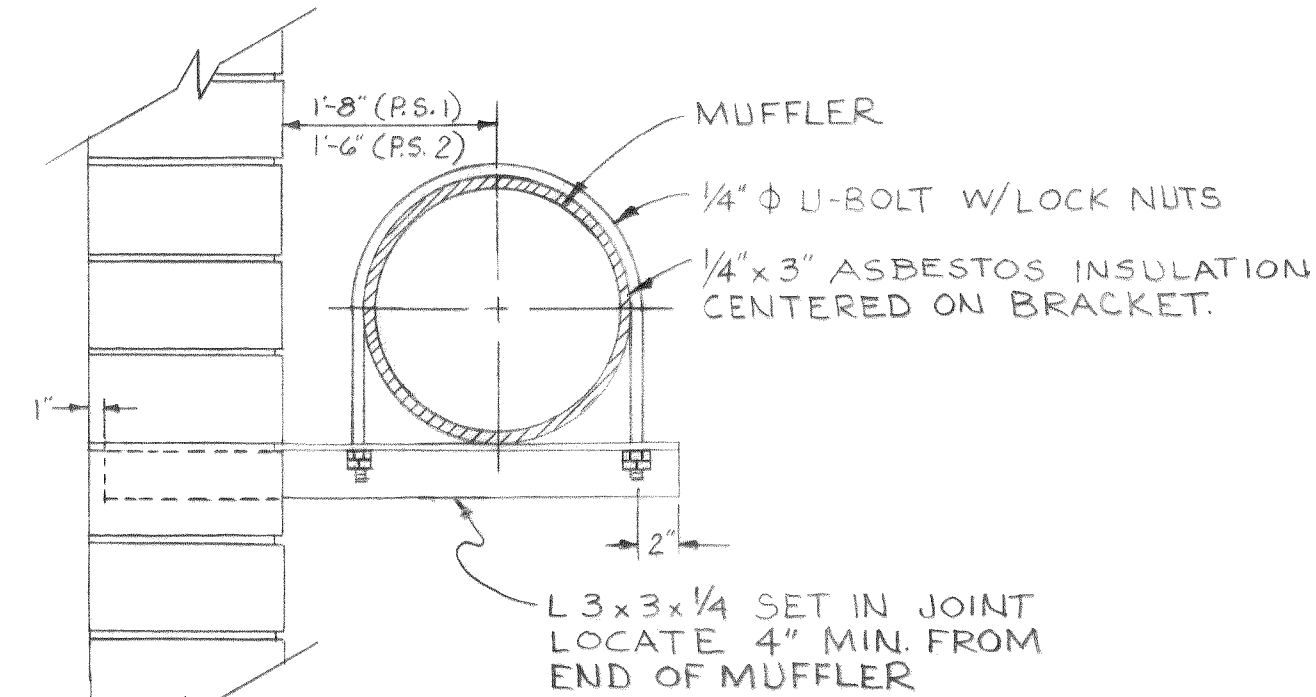


DETAIL 8
GENERATOR MUFFLER SUPPORT
NO SCALE M2

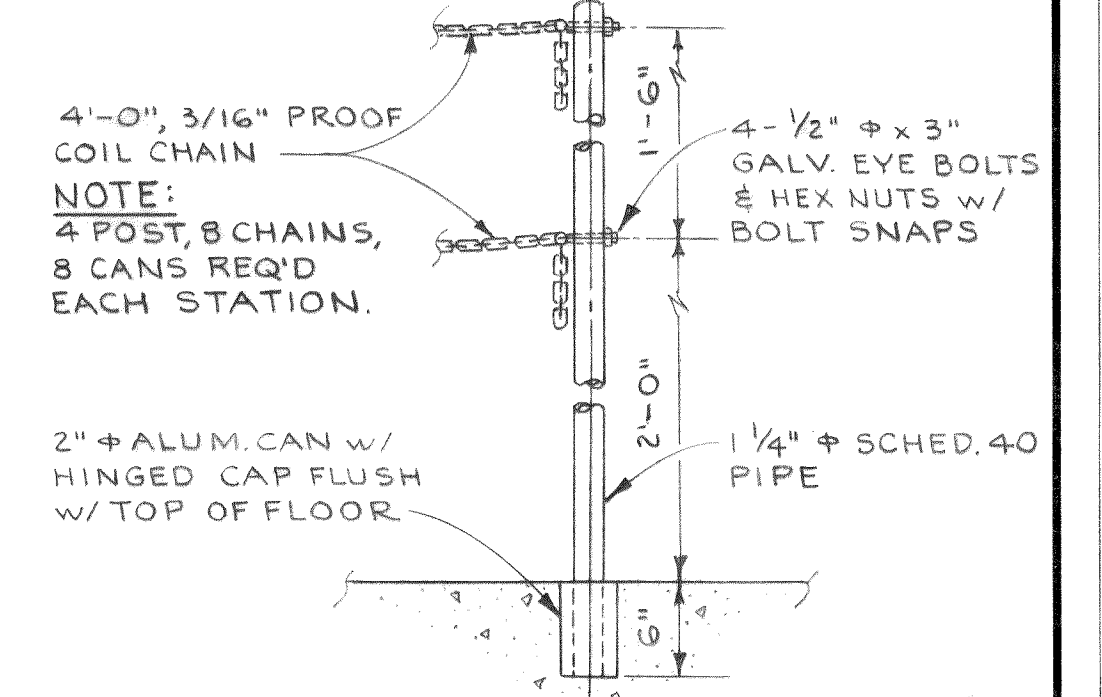

DETAIL 6
SAFETY POST
NO SCALE S1

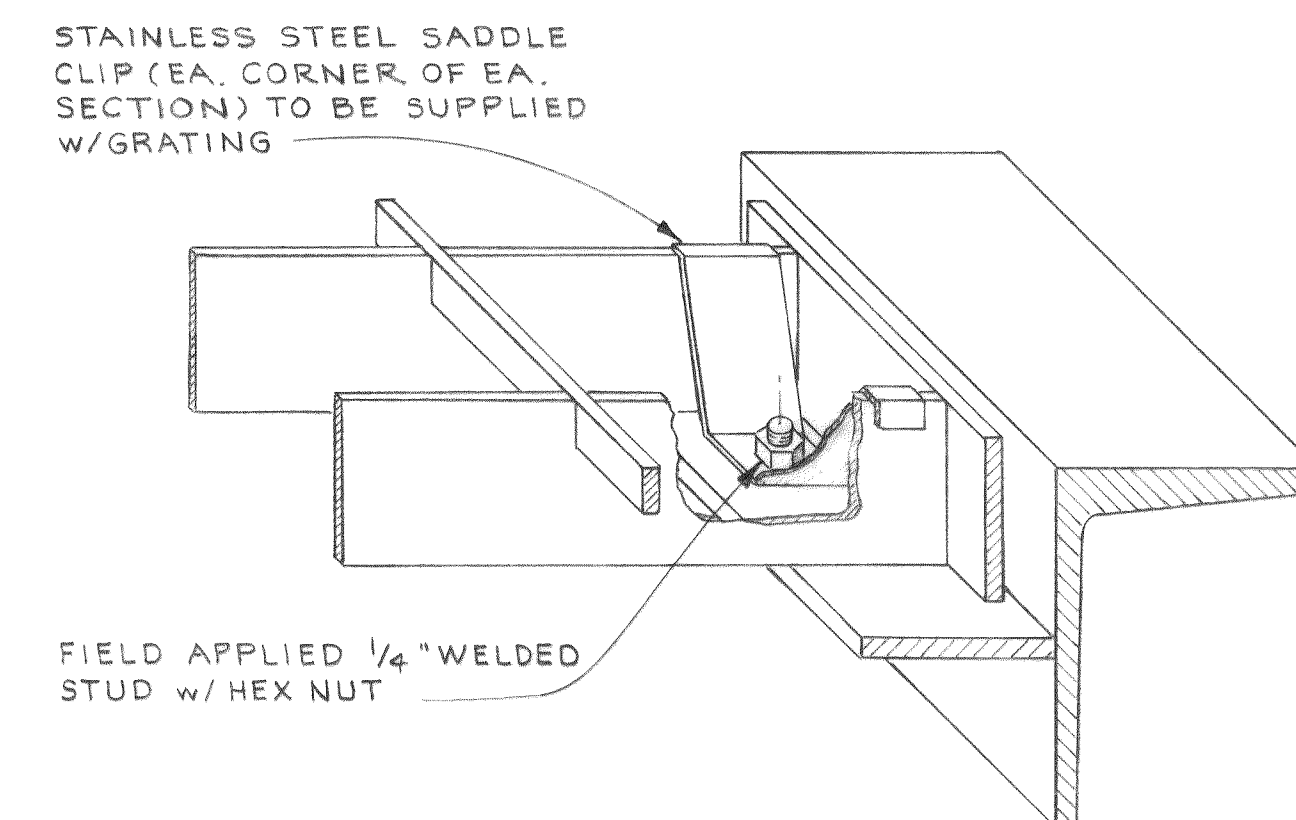

DETAIL 4
NO SCALE S3

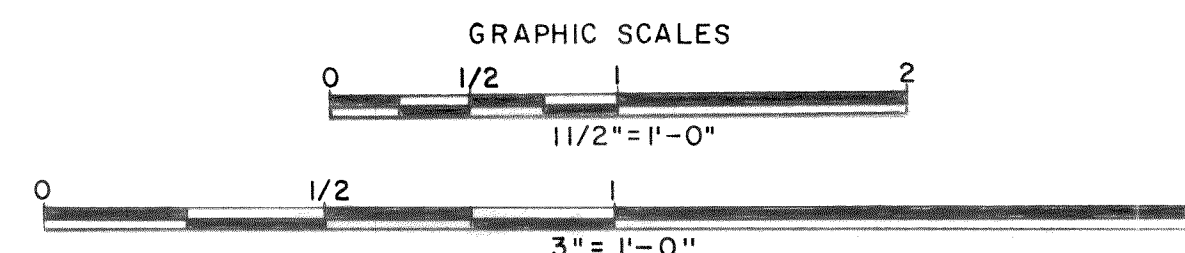

DESIGNED	RDU	APPROVED	<i>John H. Hume</i>
DRAWN	E. J.	SCALE	AS SHOWN
DATE		DATE	JULY, 1972
REVISION		FILE	71-S-425.002




Stevens, Thompson & Runyan, Inc.
Engineers/Planners
PORTLAND SEATTLE BOISE

TOWN OF FERNDAL, WASHINGTON
AXTON ROAD INTERCEPTOR
SCHEDULE I


PUMP STATION 1 & 2
STRUCTURAL DETAILS

S4
6


MICROFILMED

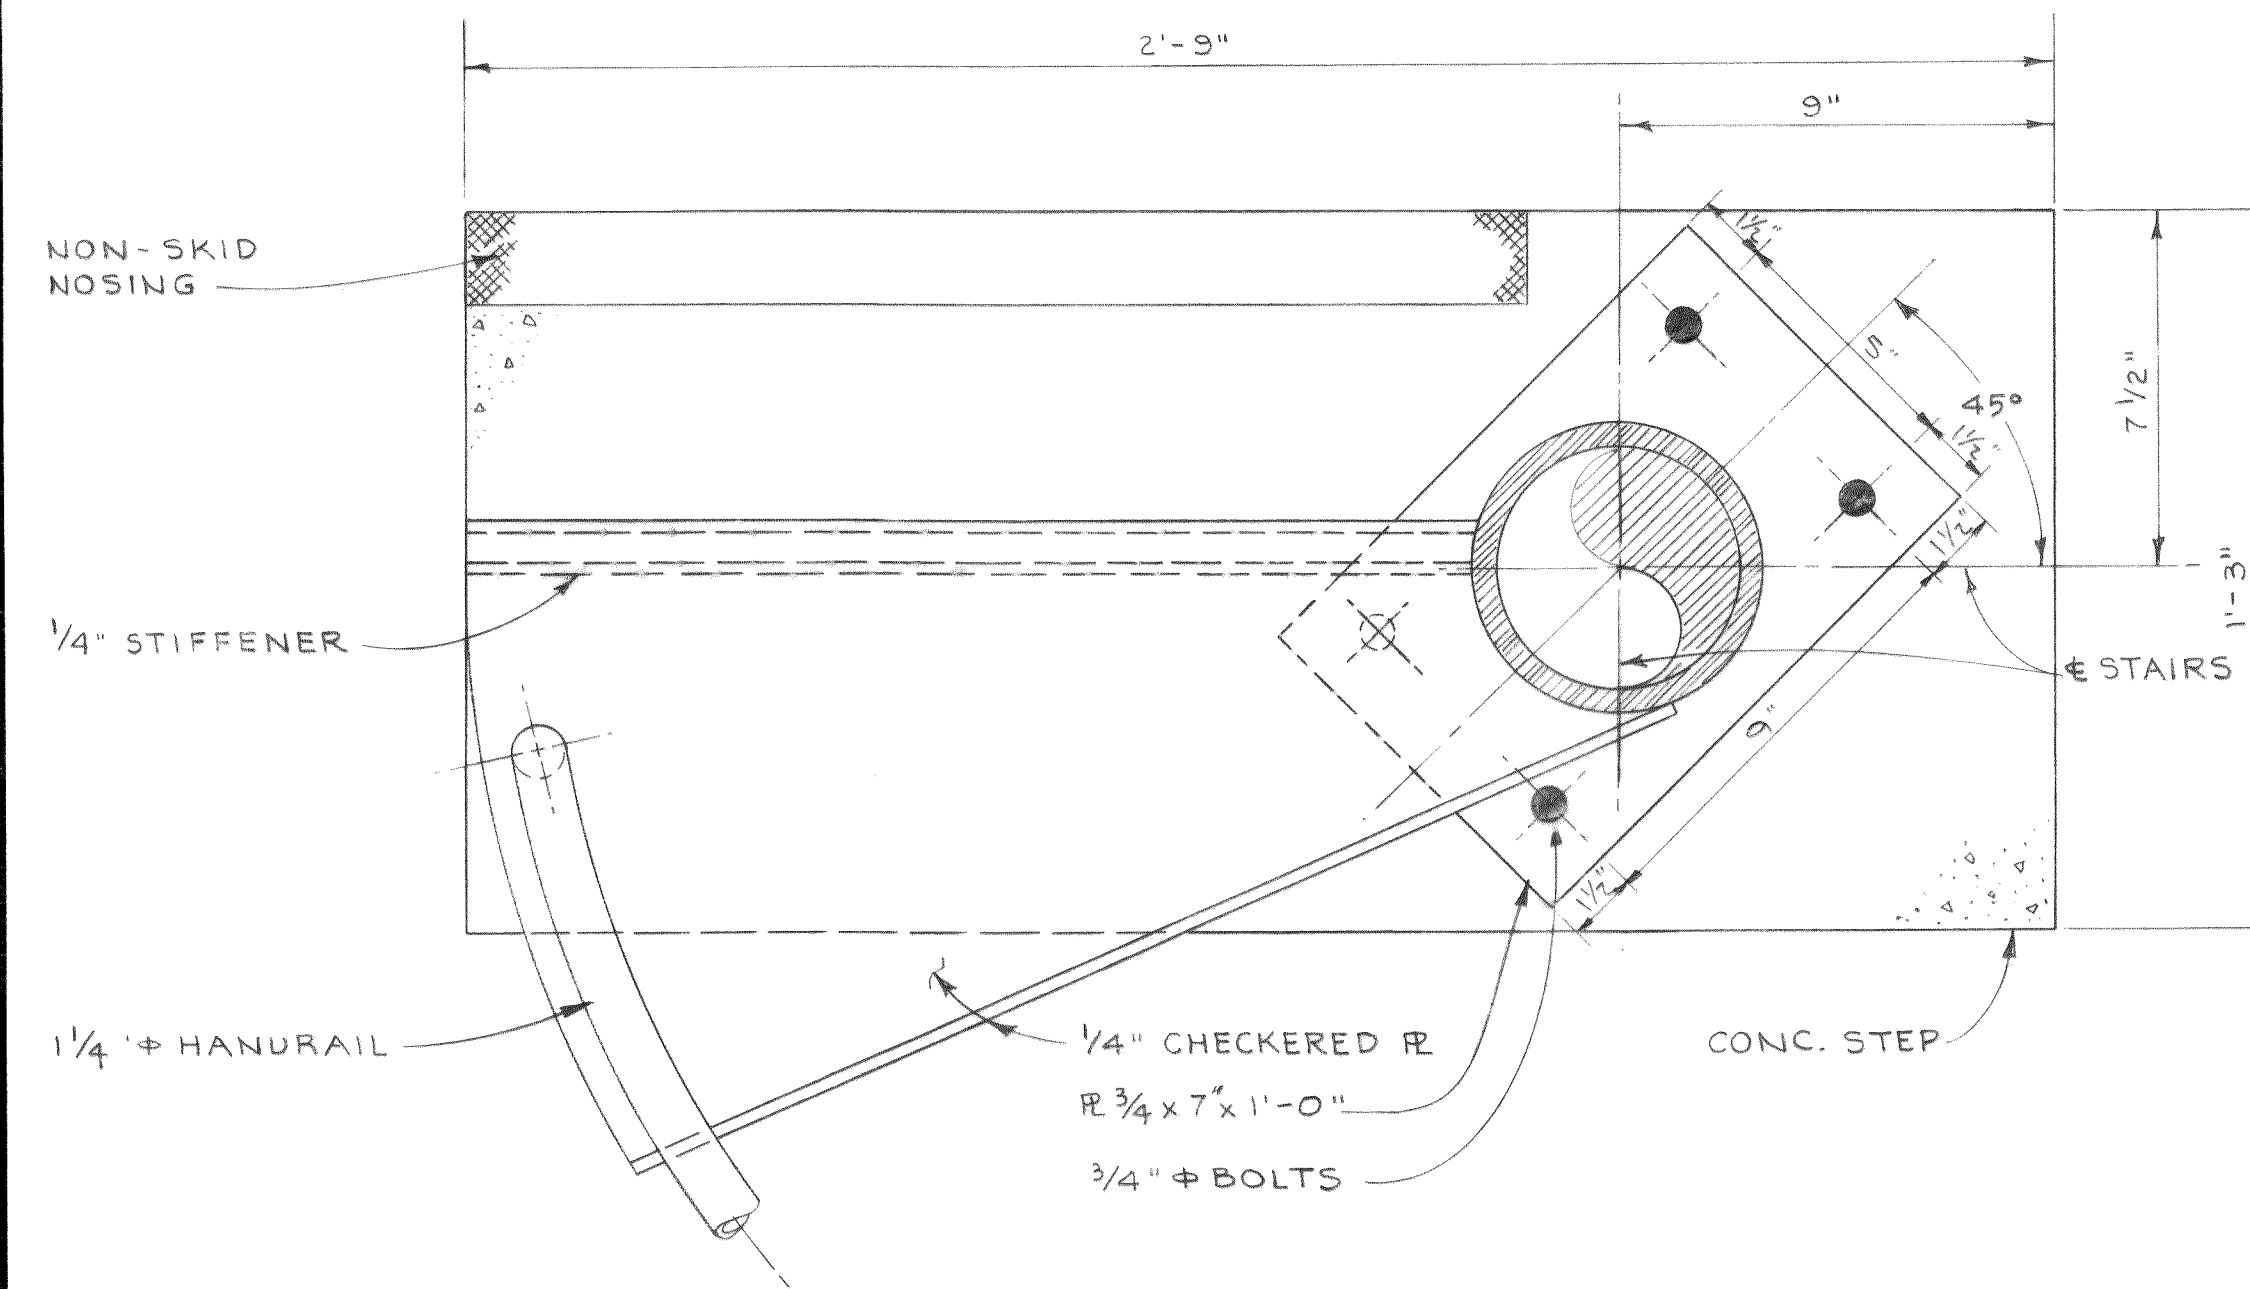


SECTION 1
SCALE: 3"=1'-0" S5

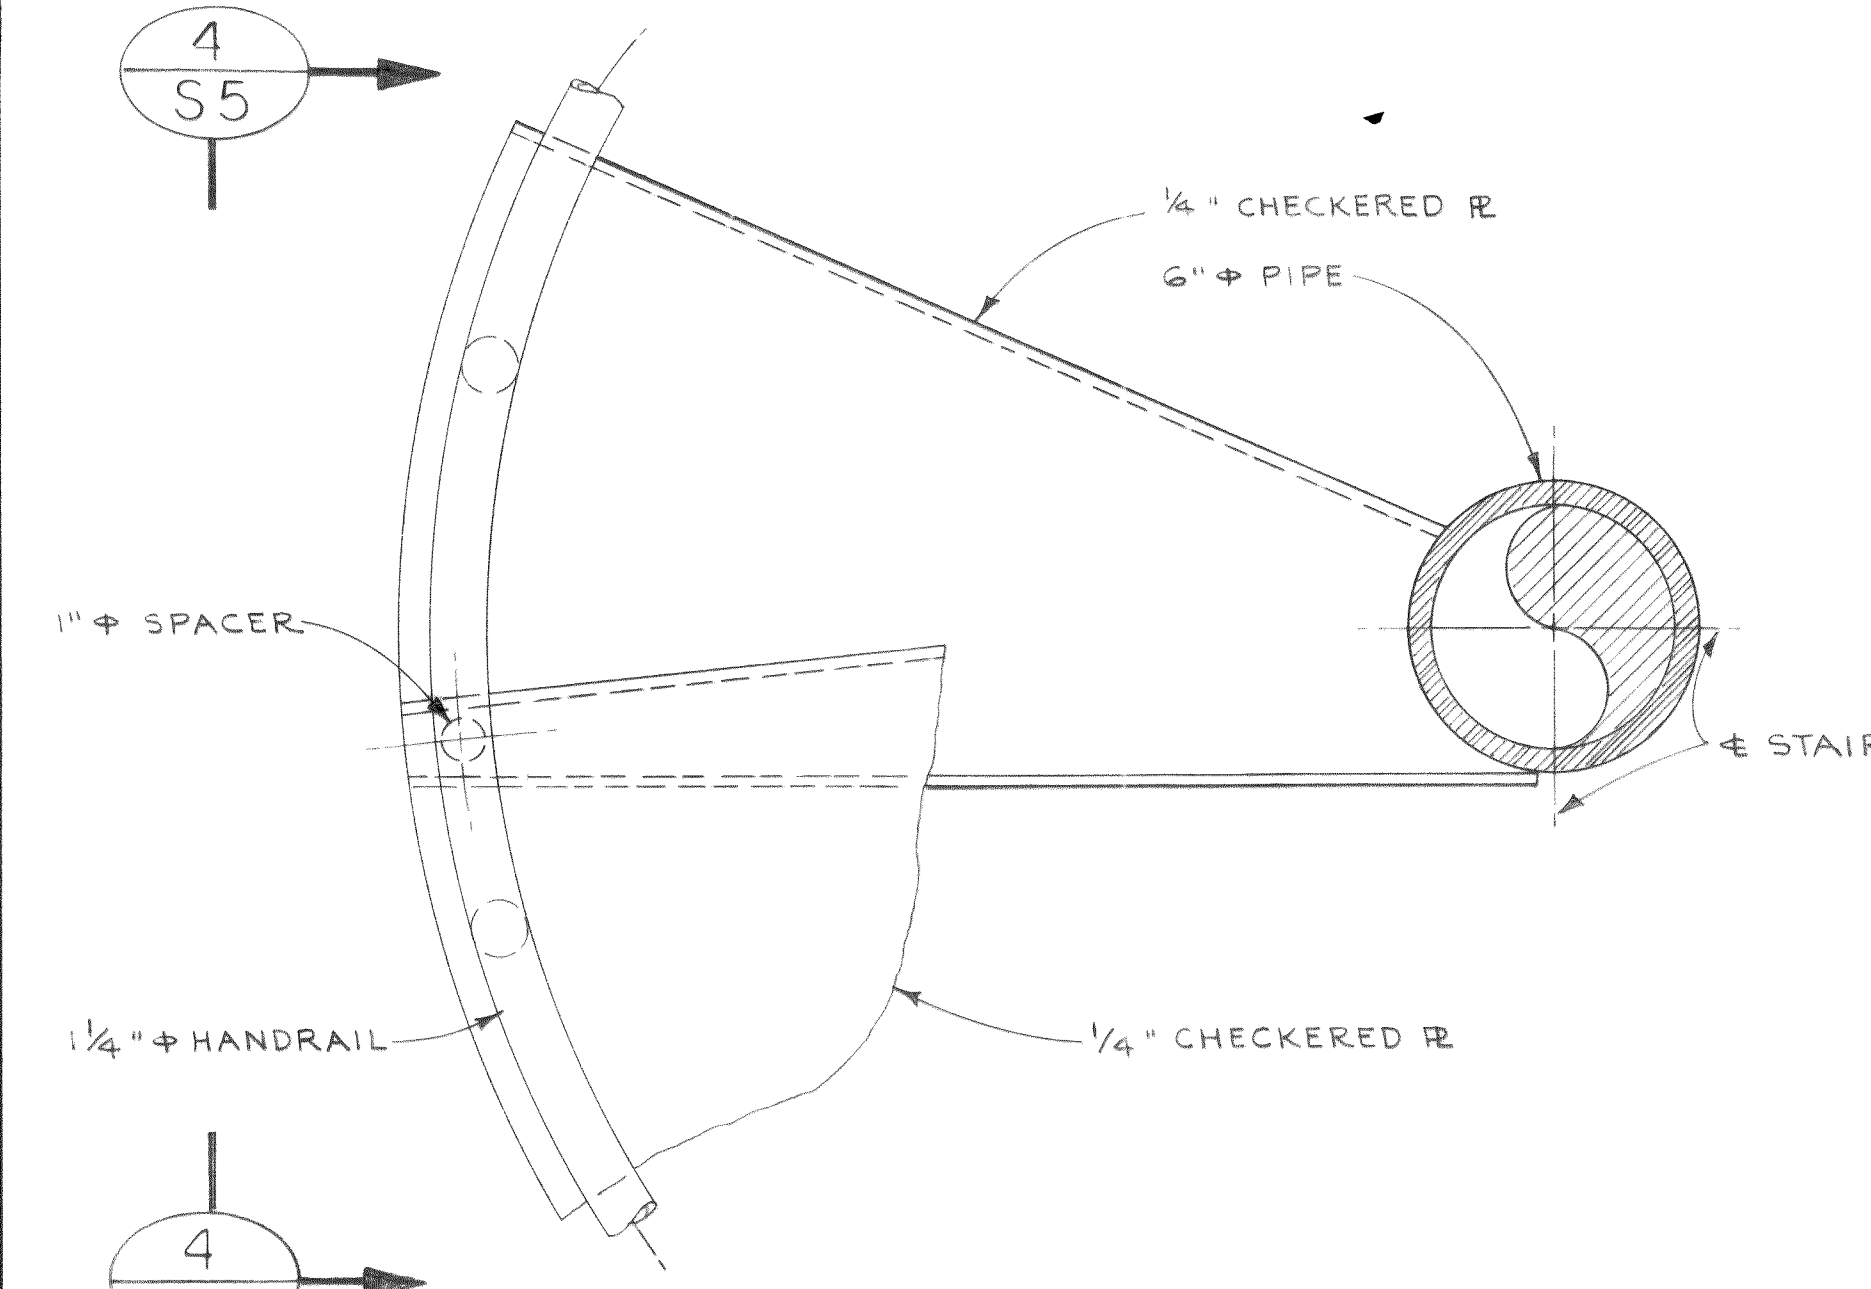


SECTION 3
SCALE: 3"=1'-0" S4

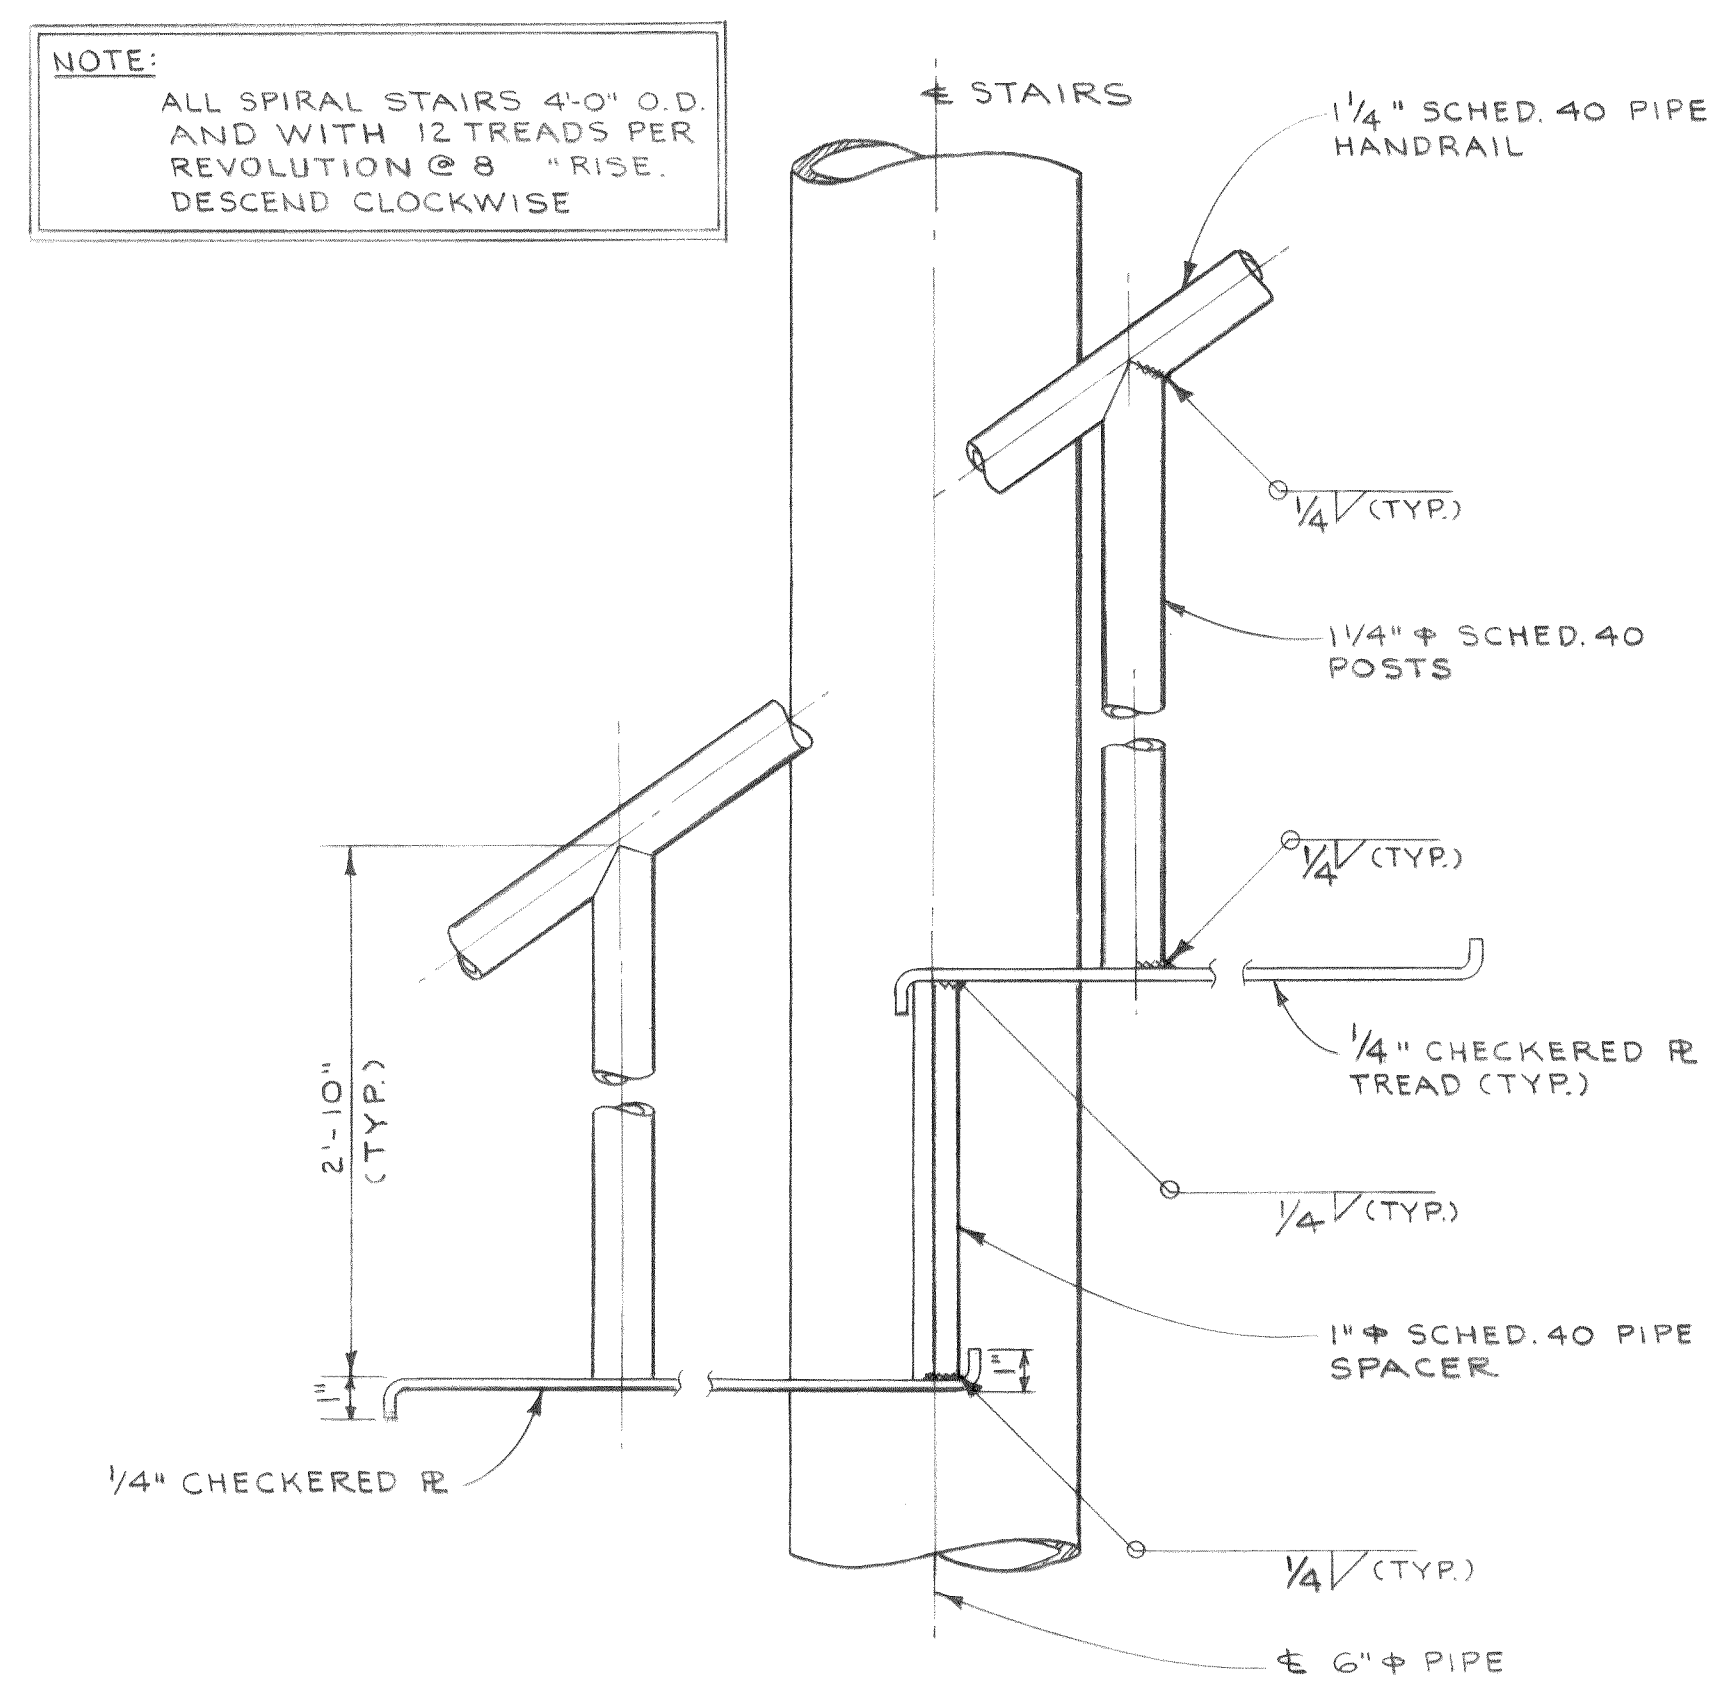


SECTION 5
SCALE: 3"=1'-0" S5

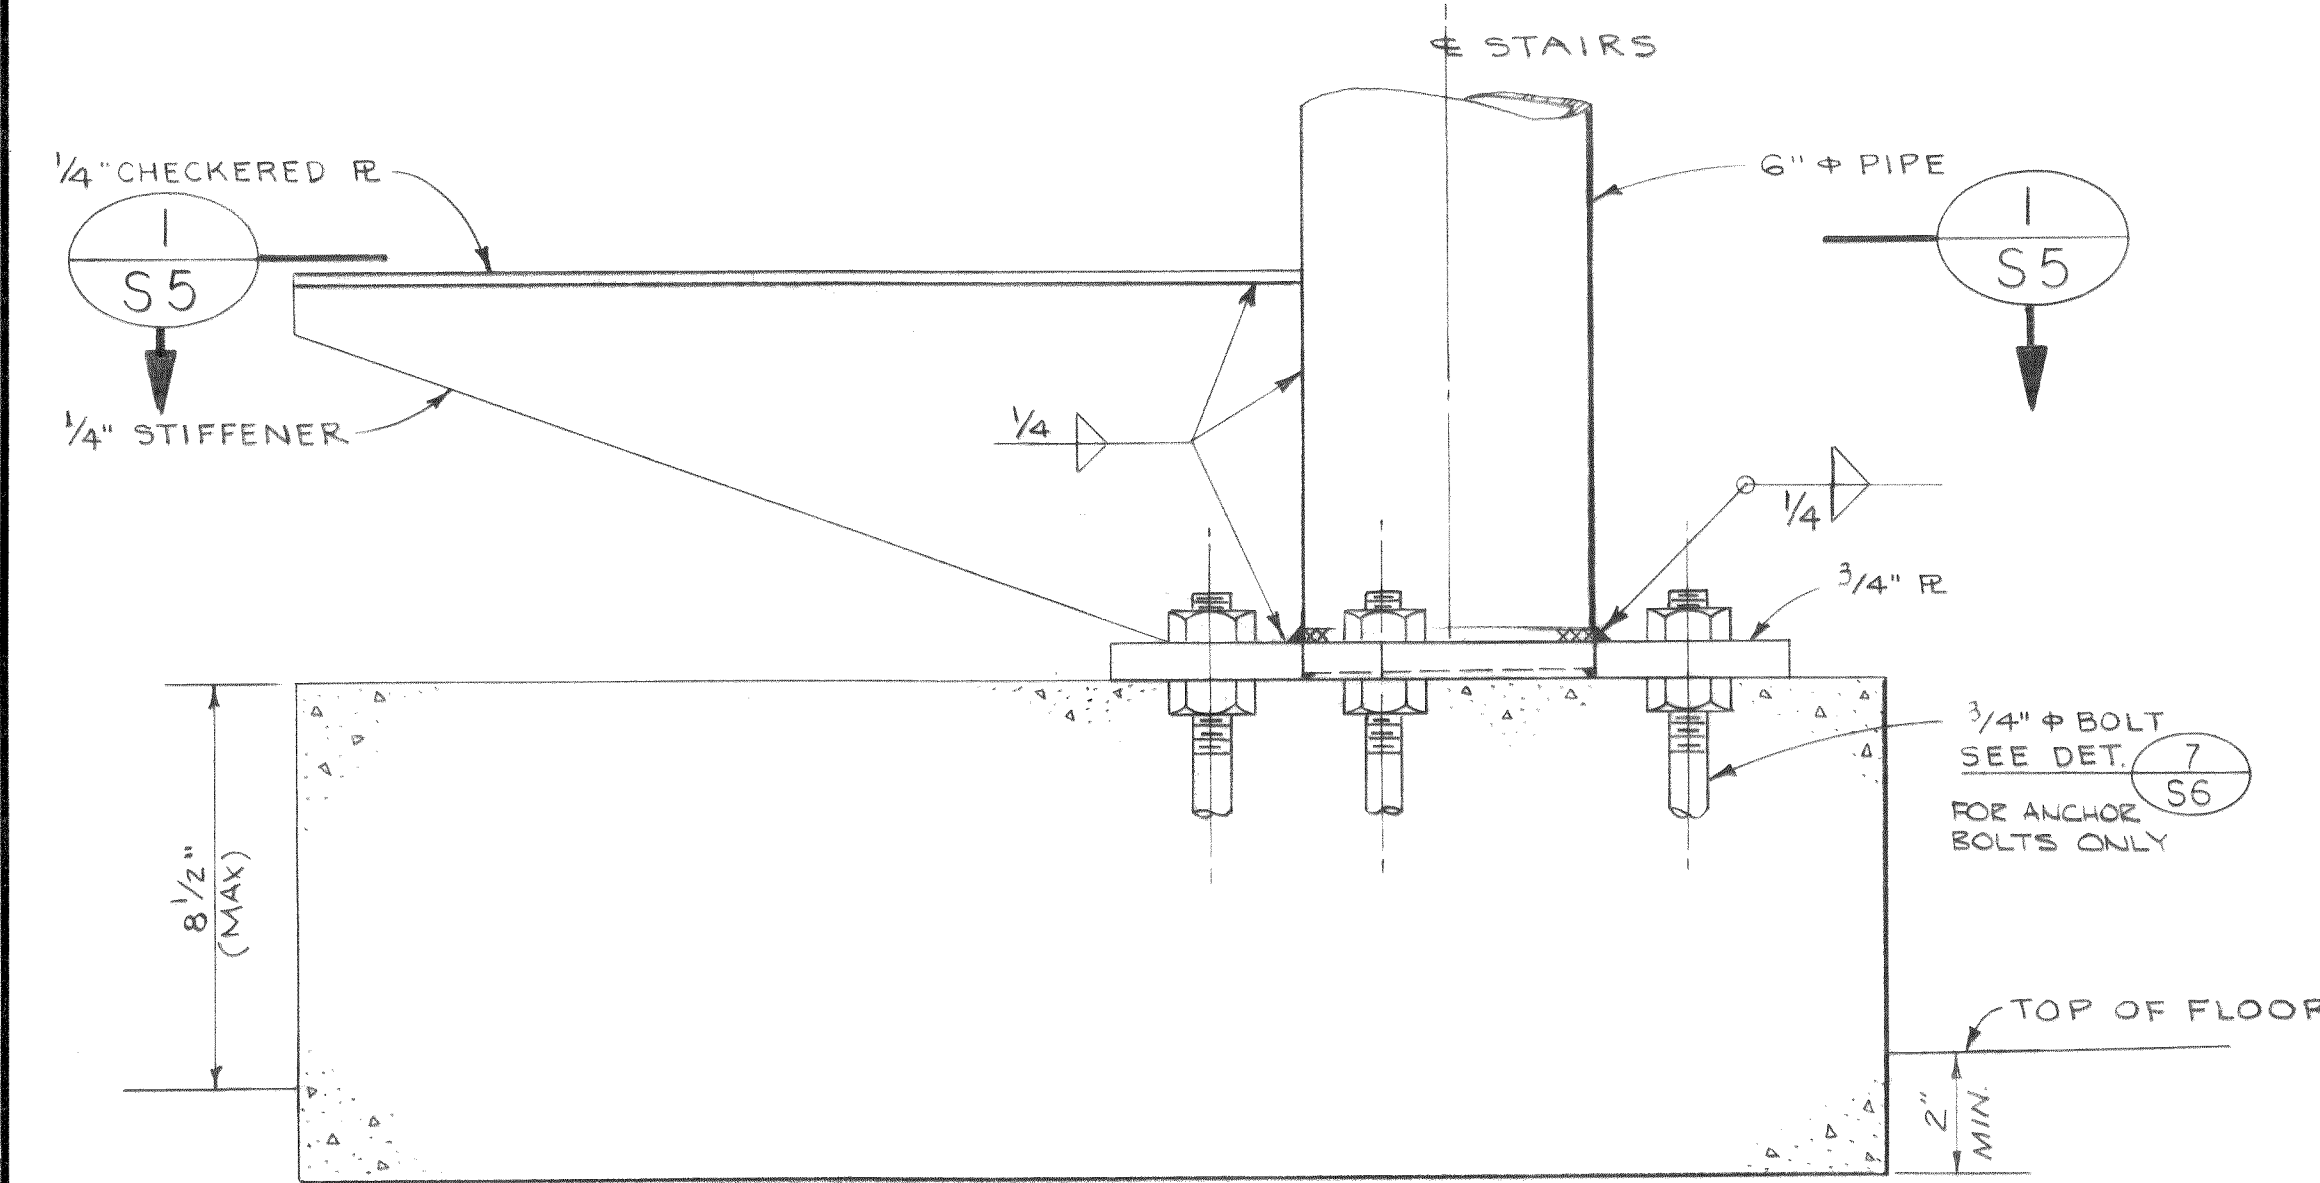


DETAIL 2
SCALE: 3"=1'-0" S2

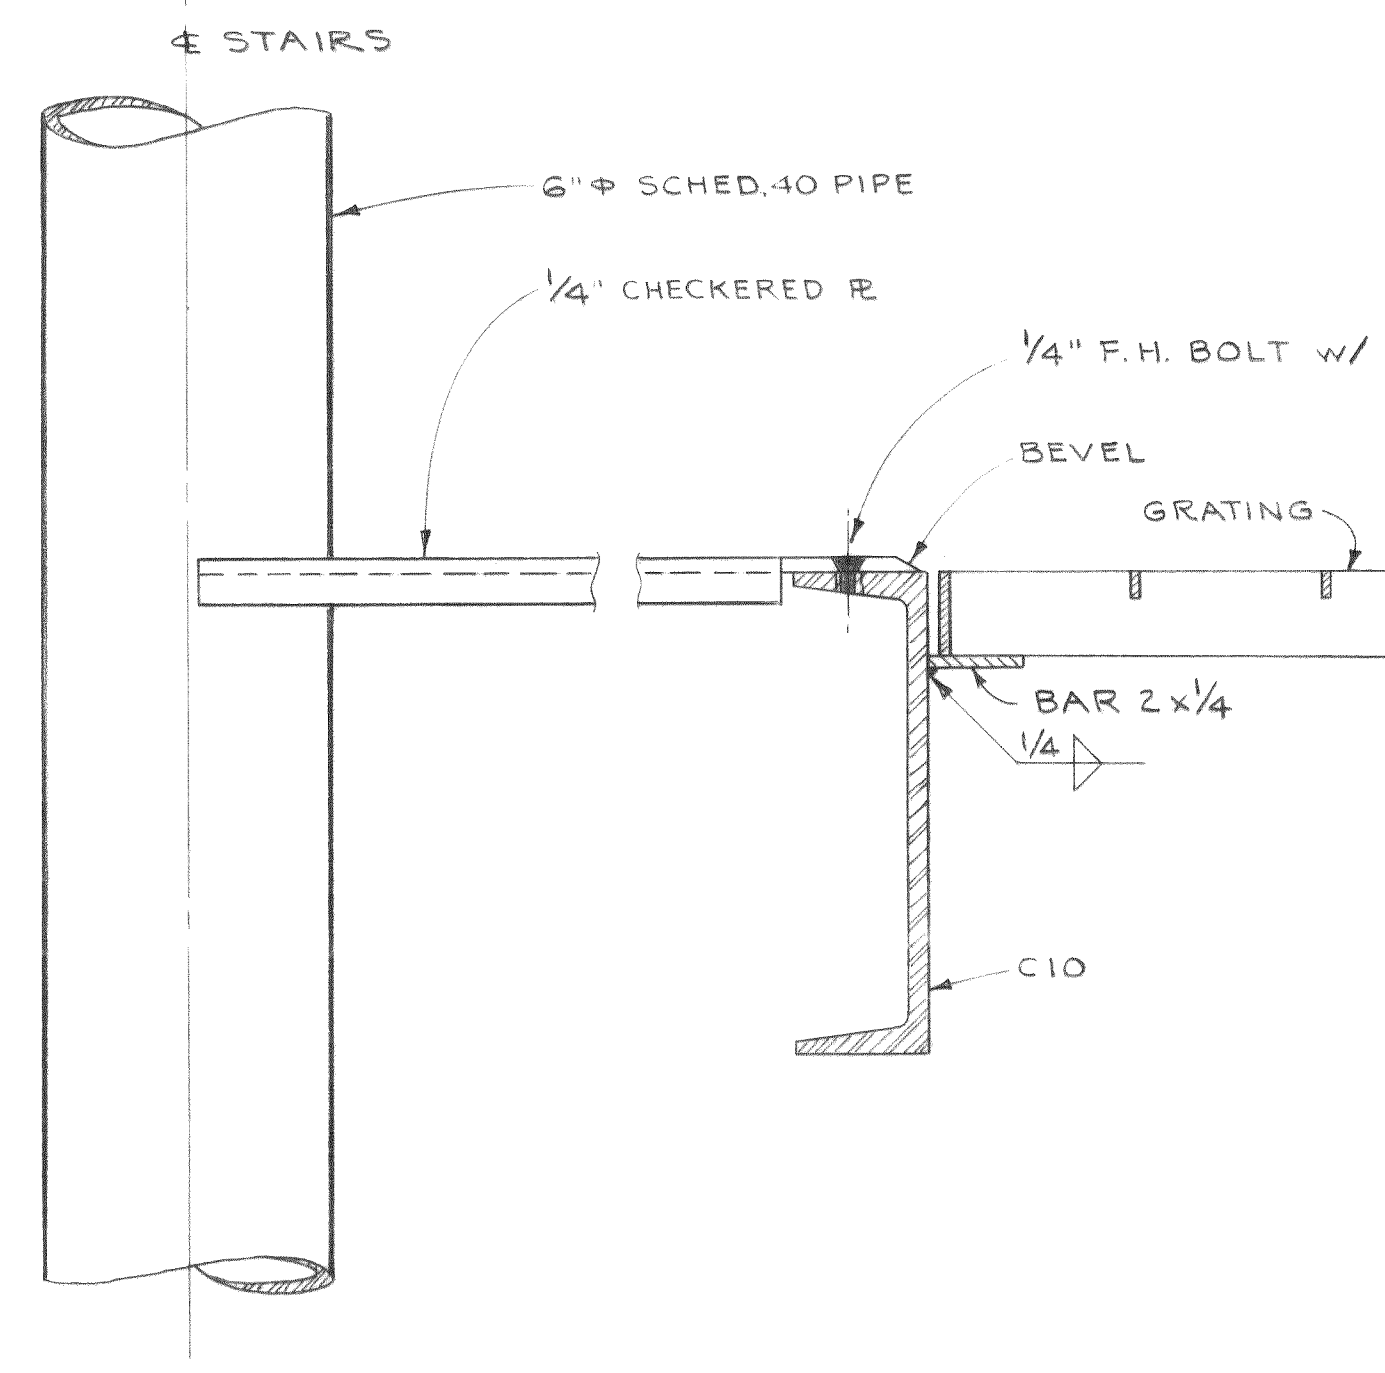


SECTION 4
SCALE: 3"=1'-0" S3

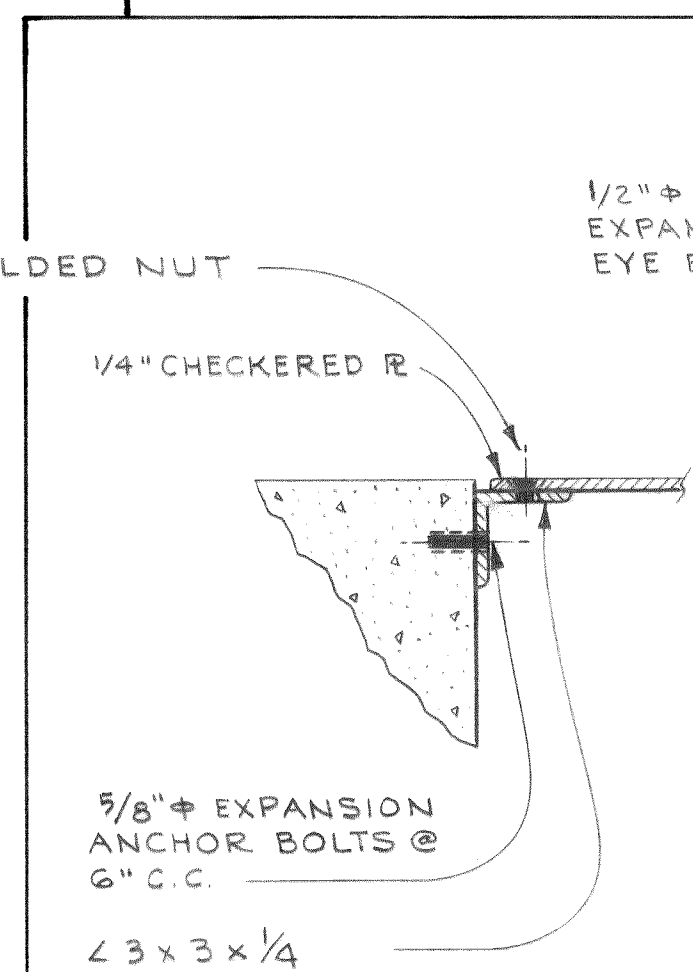

SECTION 6
SCALE: 3"=1'-0" S1

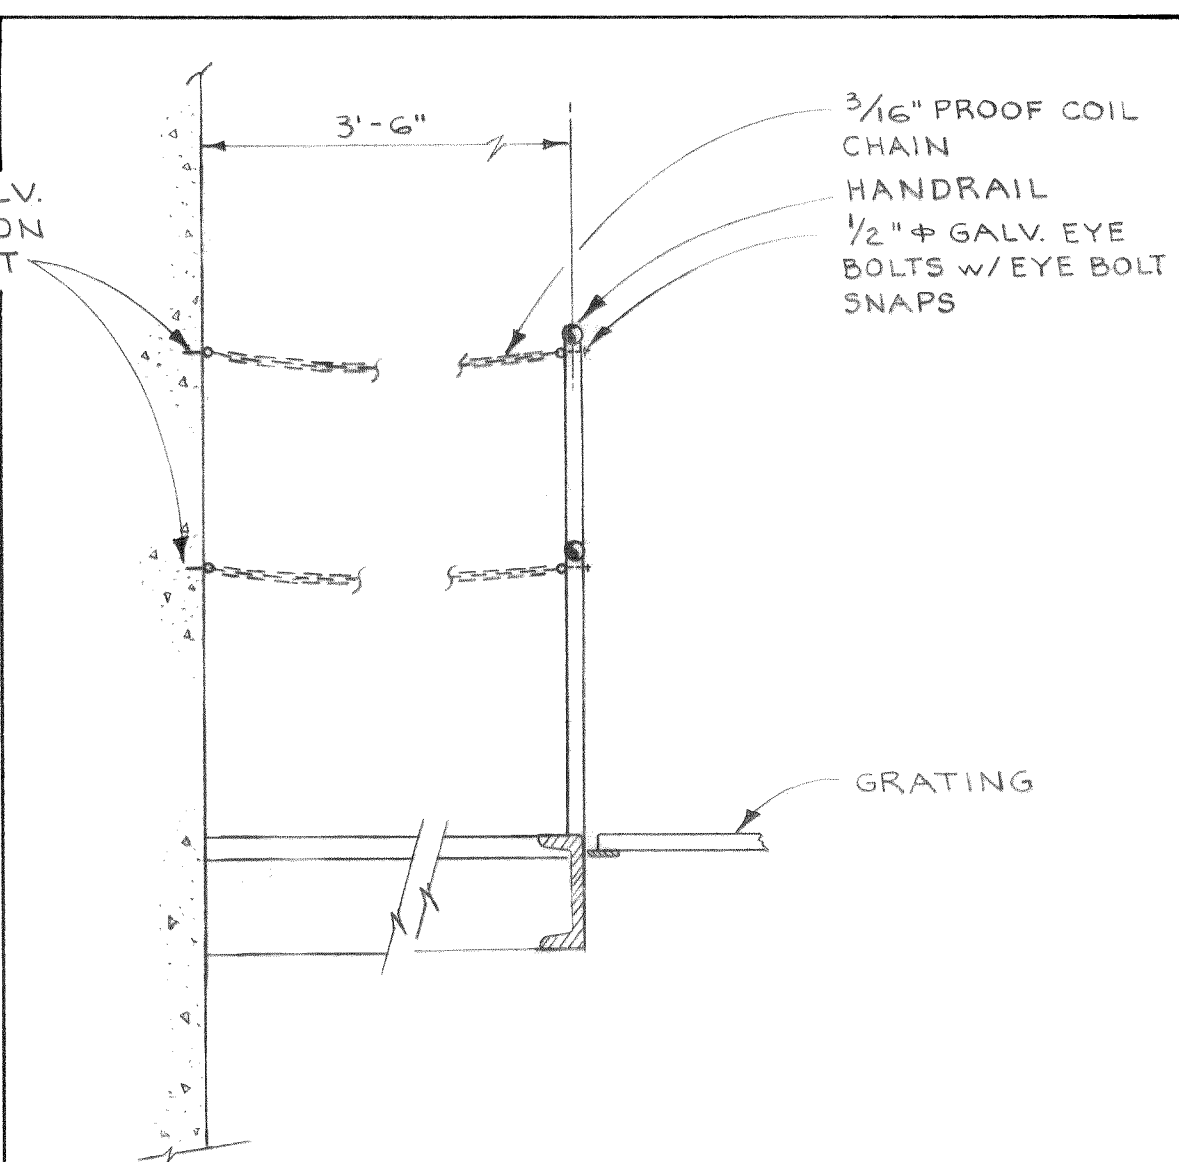

DETAIL 7
NO SCALE M4

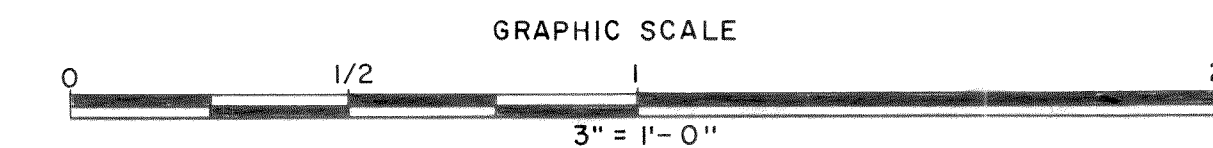


NOTE:
ALL SPIRAL STAIRS 4'-0" O.D.
AND WITH 12 TREADS PER
REVOLUTION @ 8" RISE.
DESCEND CLOCKWISE

DESIGNED	RDW	APPROVED	<i>Paul H. Runyan</i>
DRAWN	E.J.	SCALE	AS SHOWN
DATE		DATE	JULY, 1972
NO.		FILE	71-S-425.002
REVISION			

ST **Stevens, Thompson & Runyan, Inc.**
Engineers/Planners
PORTLAND SEATTLE BOISE


TOWN OF FERDALE, WASHINGTON
AXTON ROAD INTERCEPTOR
SCHEDULE I


PUMP STATION 1 & 2
STRUCTURAL DETAILS

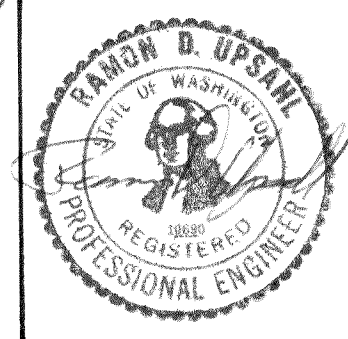


S5
6

MICROFILMED

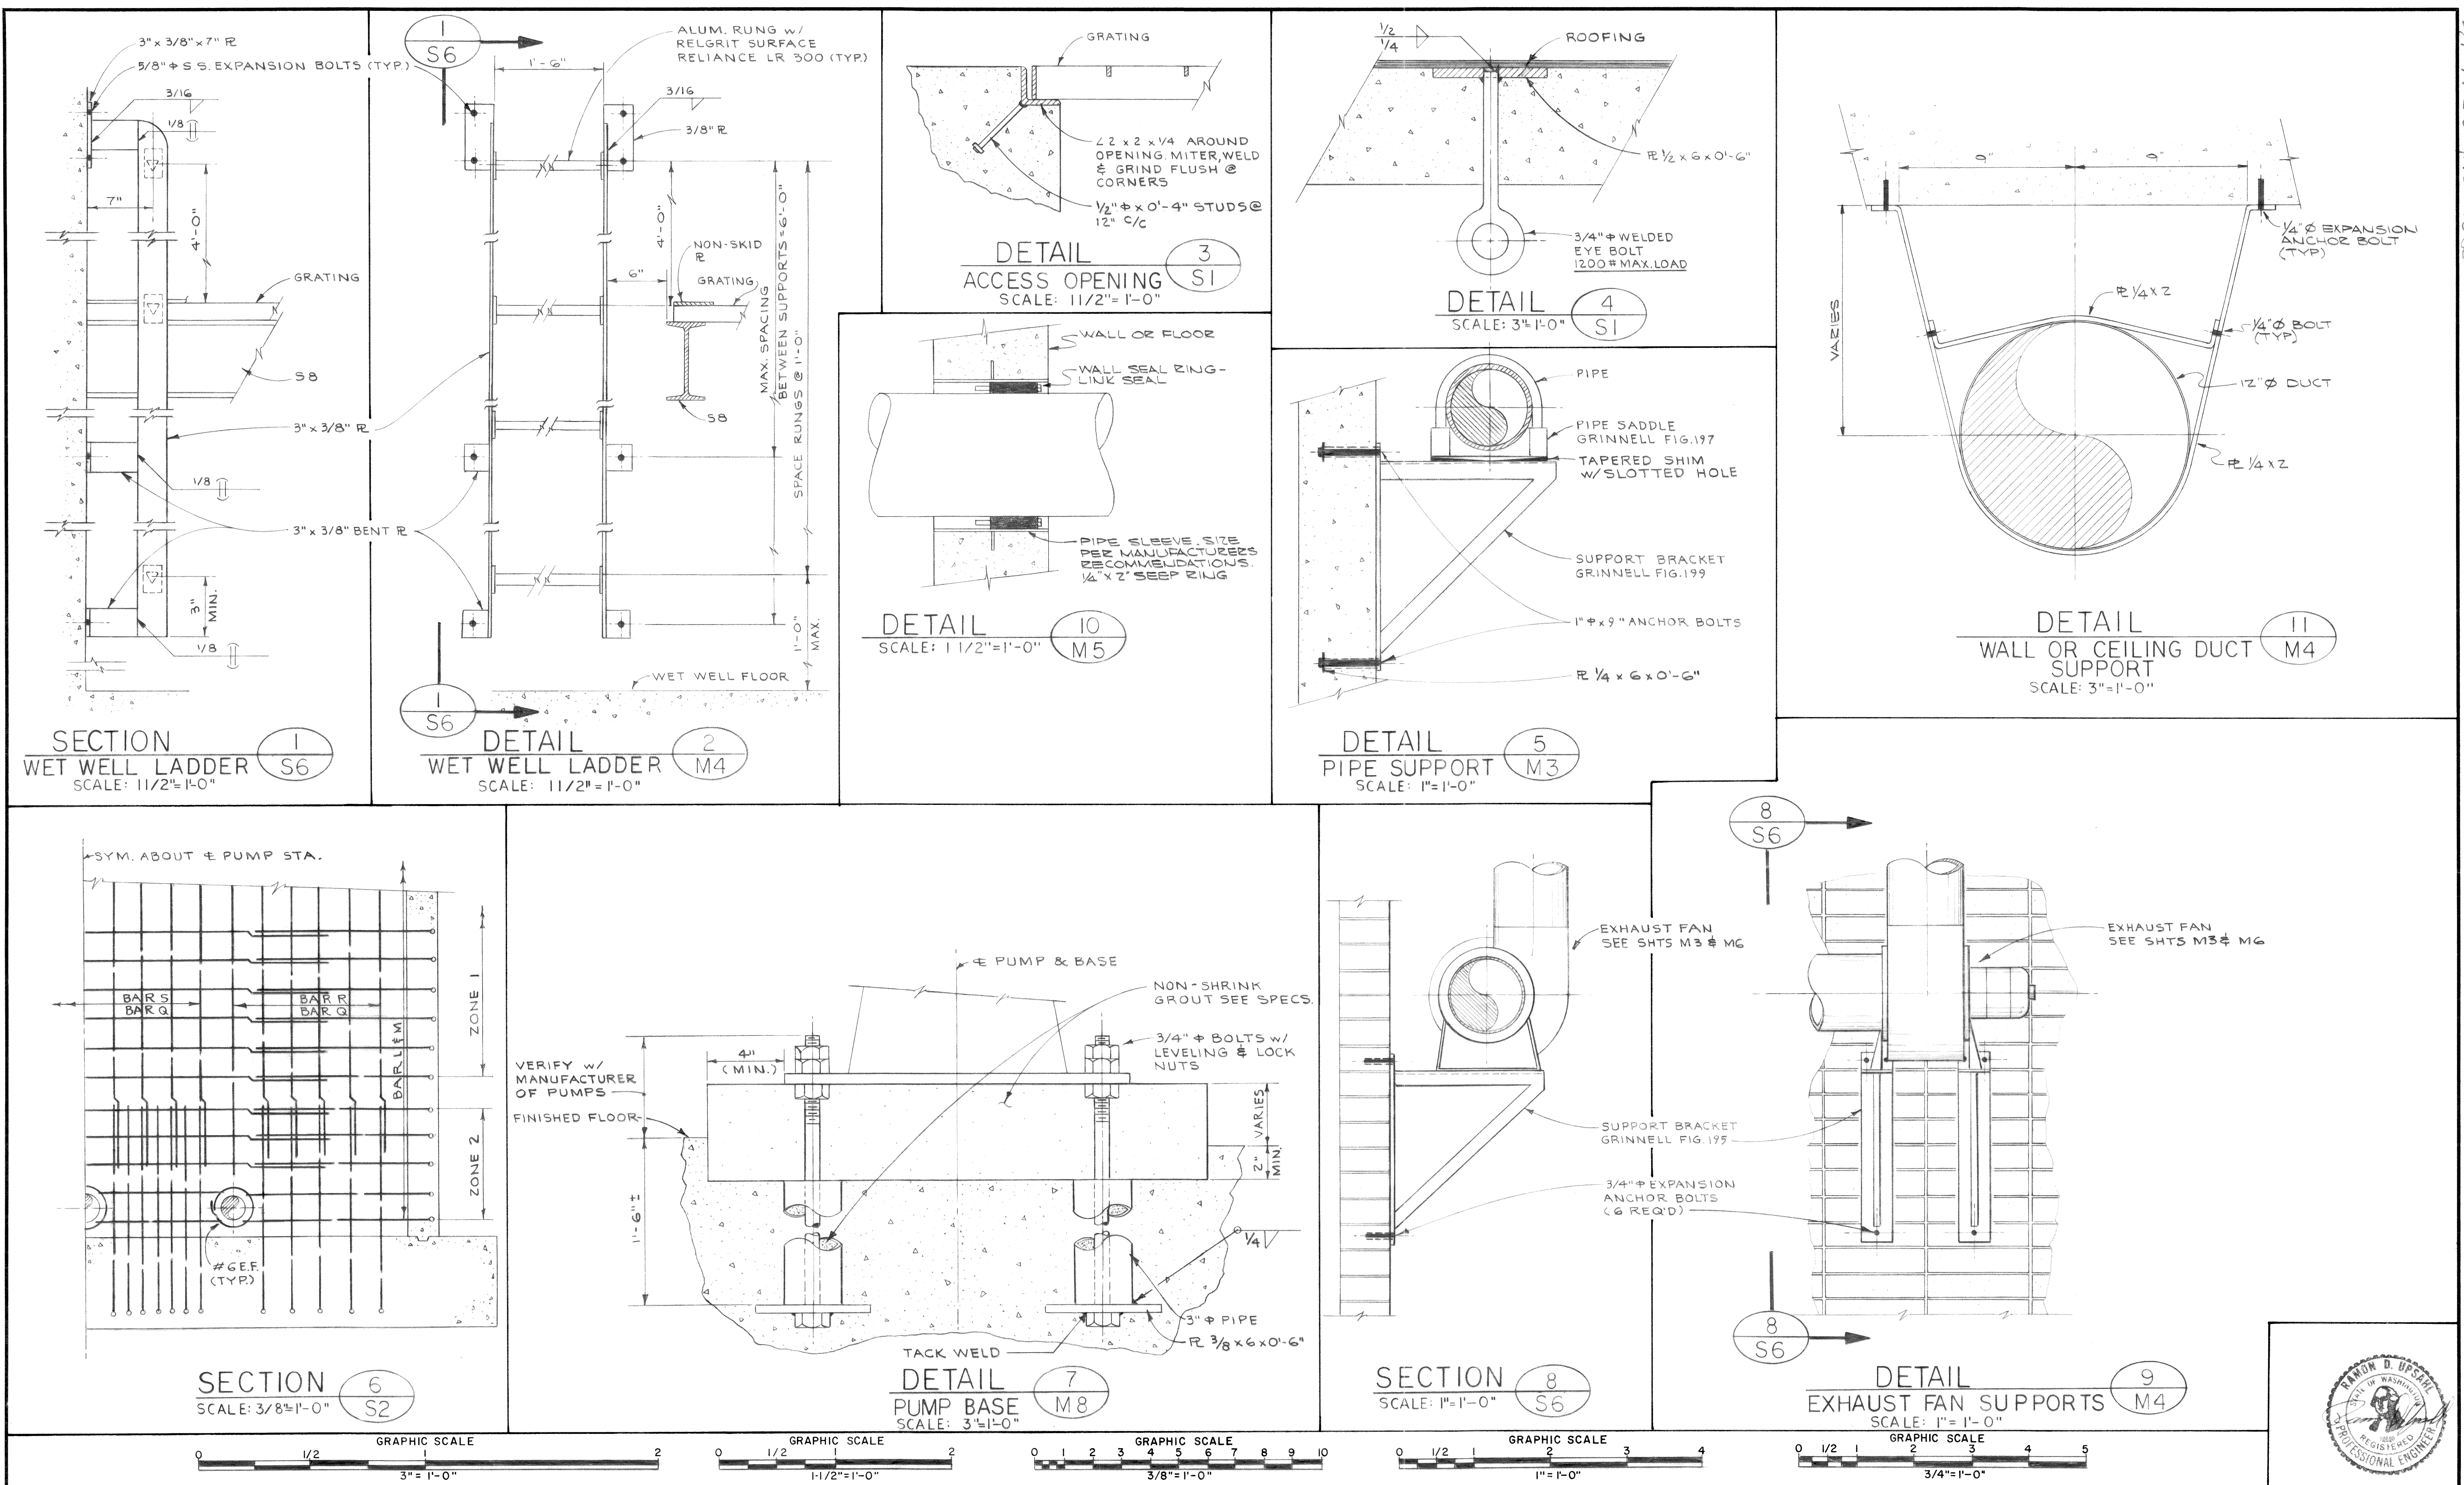

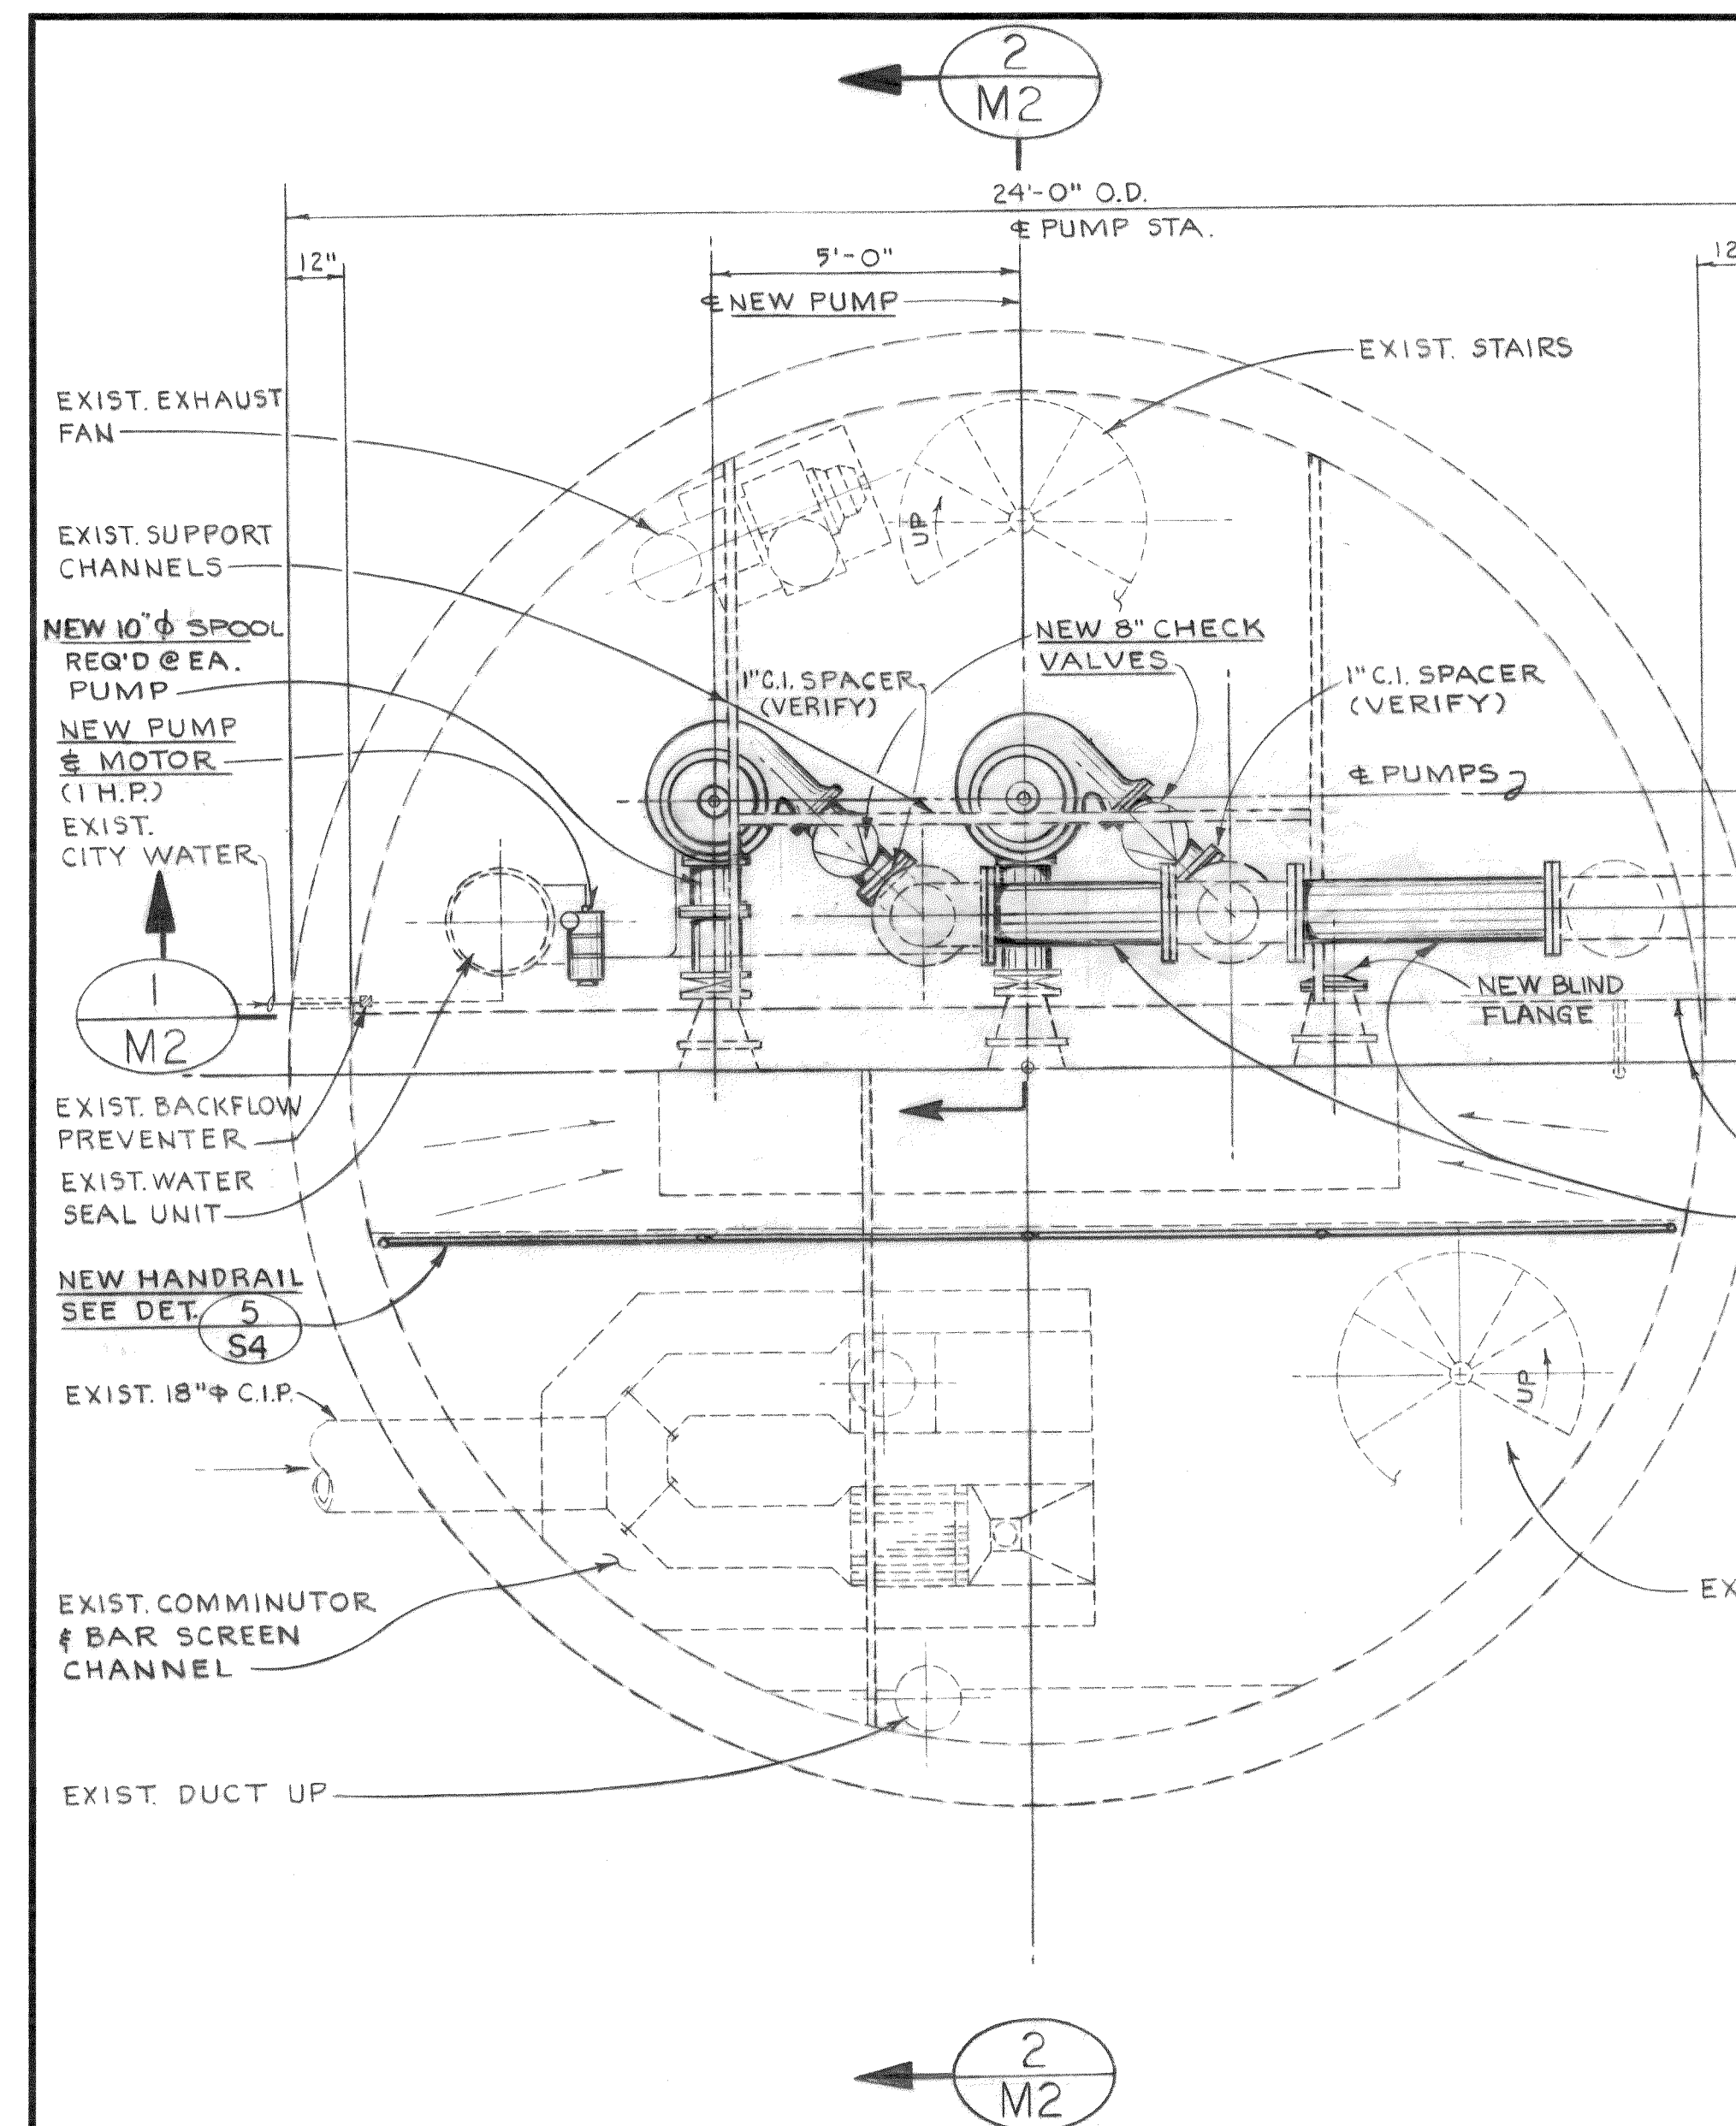


PUMP ROOM PLAN
SCALE: $\frac{3}{8}" = 1'-0"$

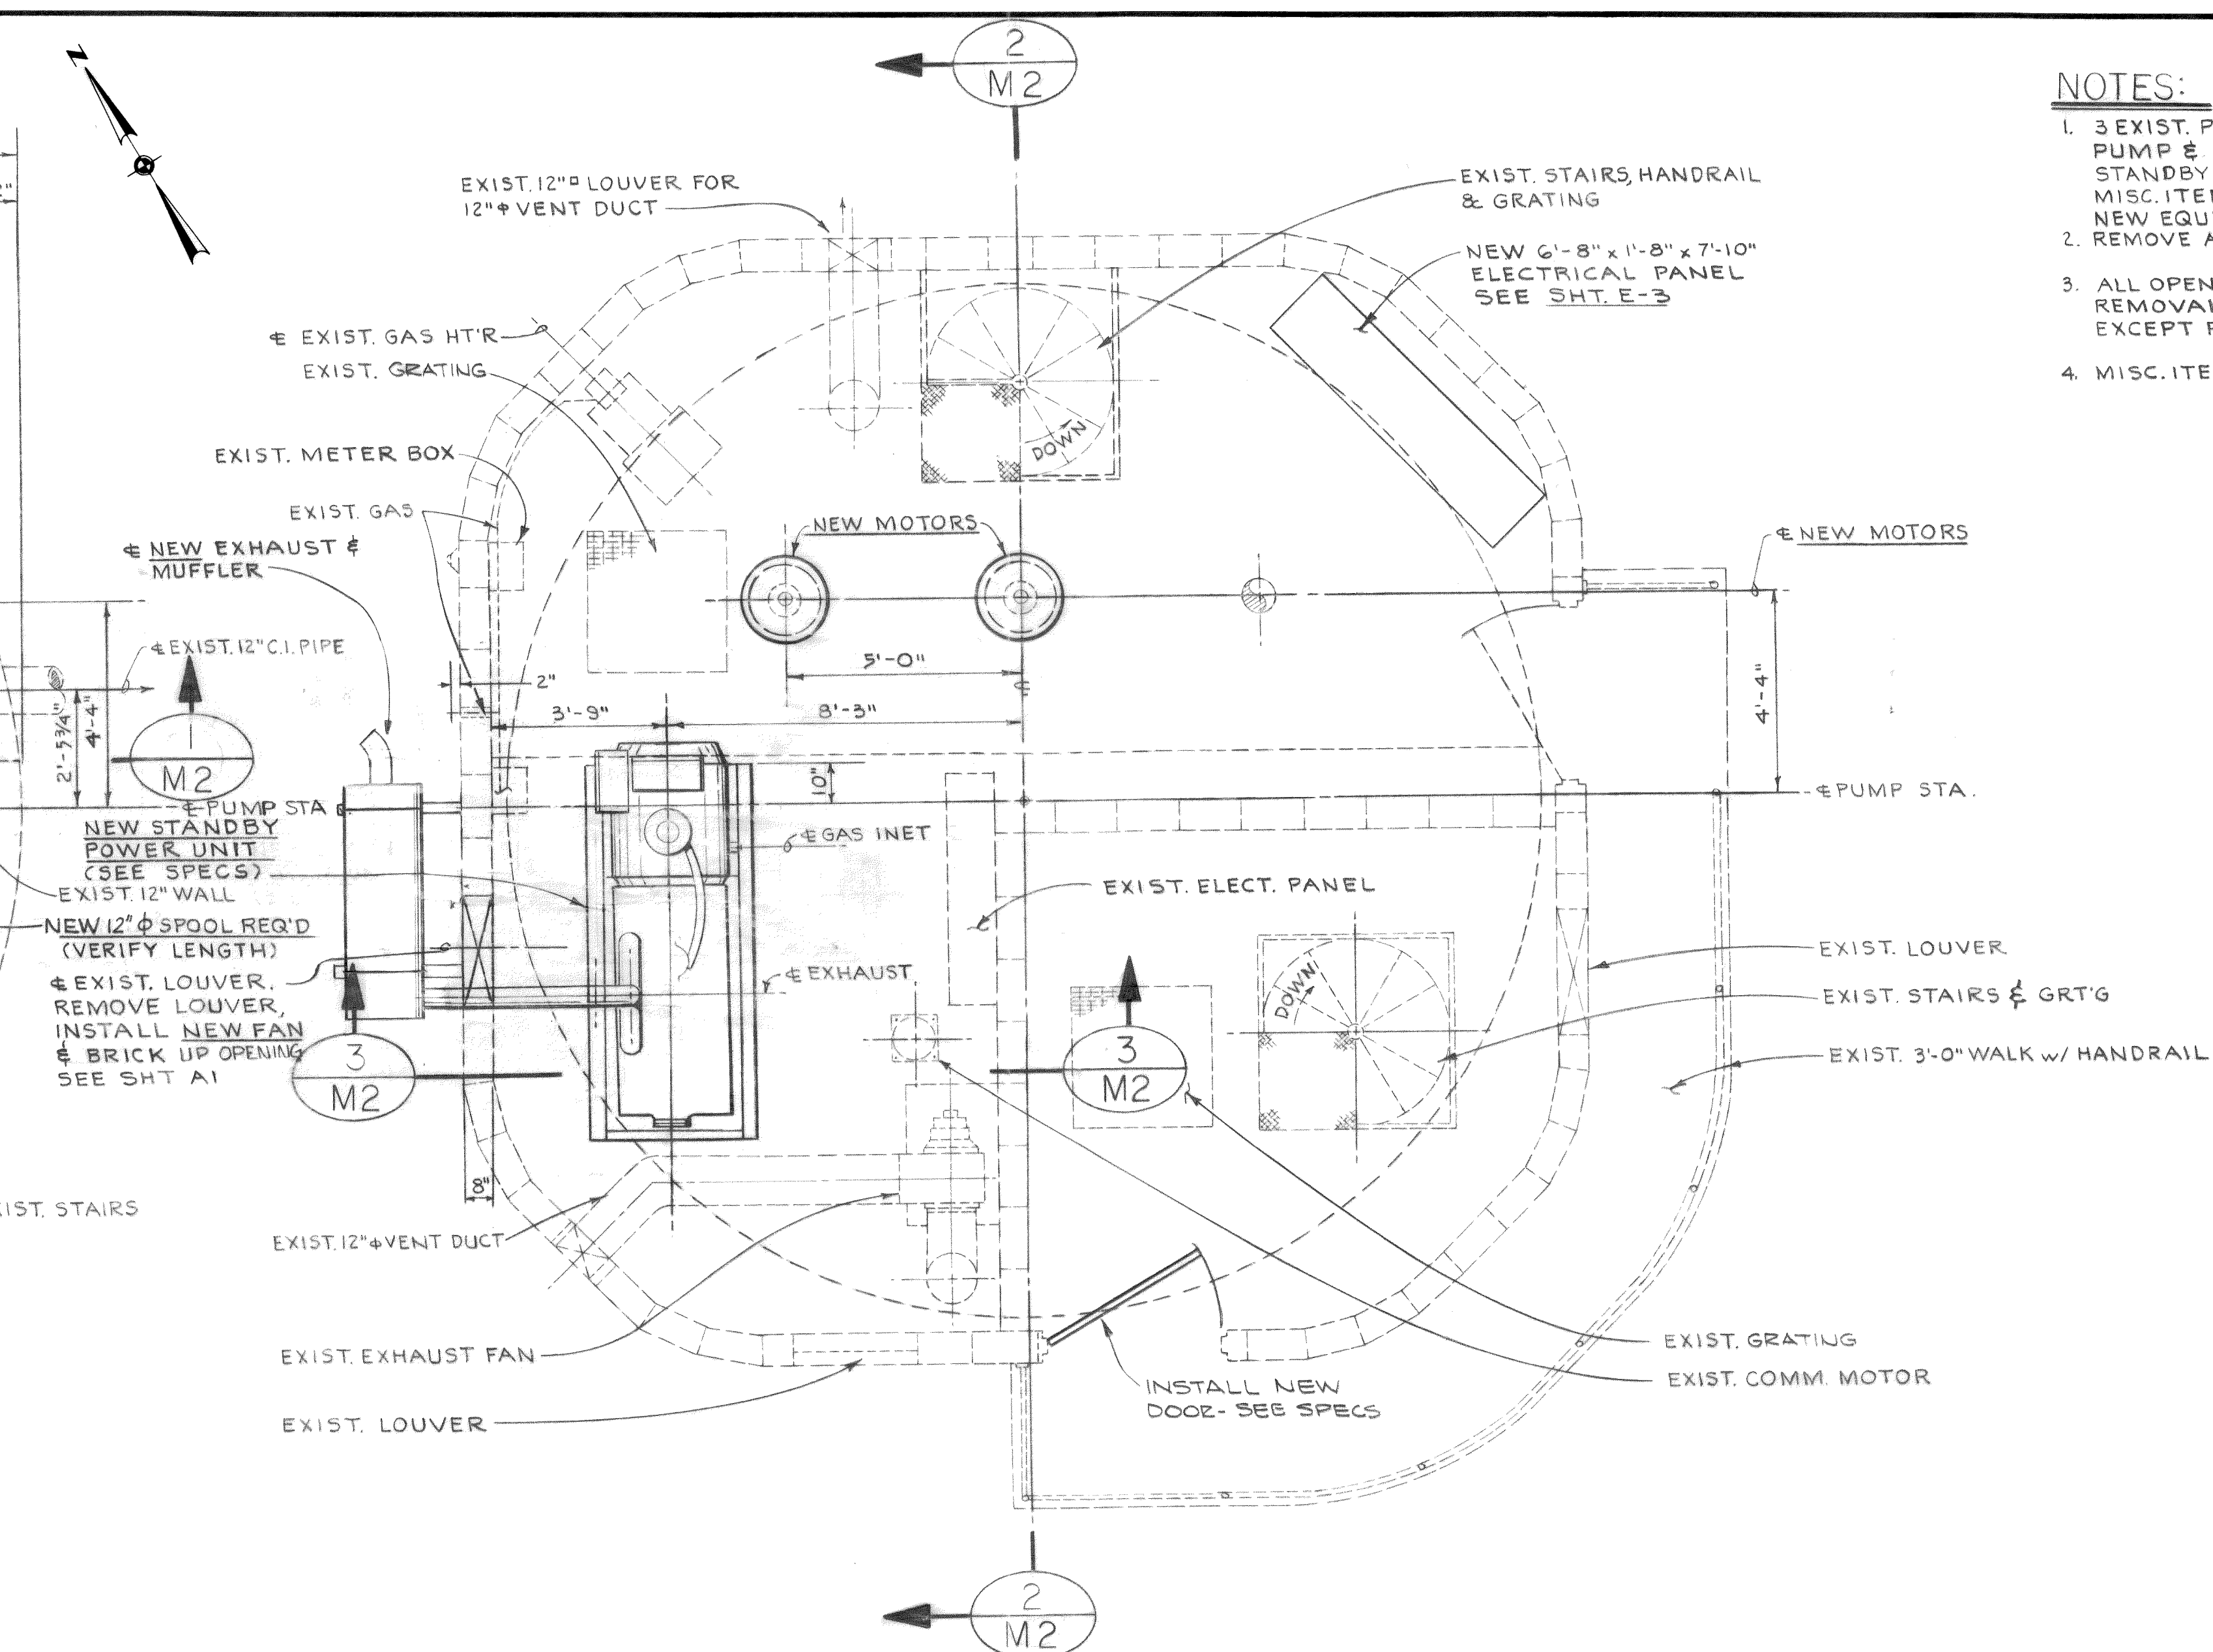

MOTOR ROOM PLAN
SCALE: $\frac{3}{8}" = 1'-0"$

- NOTES:**
- 3 EXIST. PUMPS & MOTORS, WATER SEAL PUMP & MOTOR, ELECTRICAL PANEL, STANDBY POWER GENERATOR & RELATED MISC. ITEMS TO BE REMOVED & REPLACED w/ NEW EQUIP. AS INDICATED.
 - REMOVE ALL VALVE STANDS, STEMS & SUPPORTS.
 - ALL OPEN HOLES CAUSED BY EQUIPMENT REMOVAL TO BE GROUTED FULL DEPTH EXCEPT PUMP DRIVE SHAFT.
 - MISC. ITEMS TO BE REMOVED SEE SHT. E-2

- LEGEND**
- EXIST. STRUCT, PIPING, MOTORS & PUMPS
 - NEW STRUCT, PIPES, MOTORS, PUMPS & DETAILS.

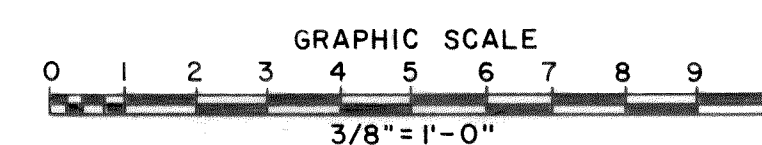

DESIGNED T.S.	APPROVED <i>Teddy Runyan</i>
DRAWN E.J.	SCALE AS SHOWN DATE JULY, 1972
CHECKED <i>AB</i>	FILE 71-S-425.002

ST
TR

Stevens, Thompson & Runyan, Inc.
Engineers/Planners


PORTLAND SEATTLE BOISE

TOWN OF FERDALE, WASHINGTON
AXTON ROAD INTERCEPTOR
SCHEDULE I


EXISTING PUMP STATION
MECHANICAL MODIFICATIONS

MI
8



MICROFILMED

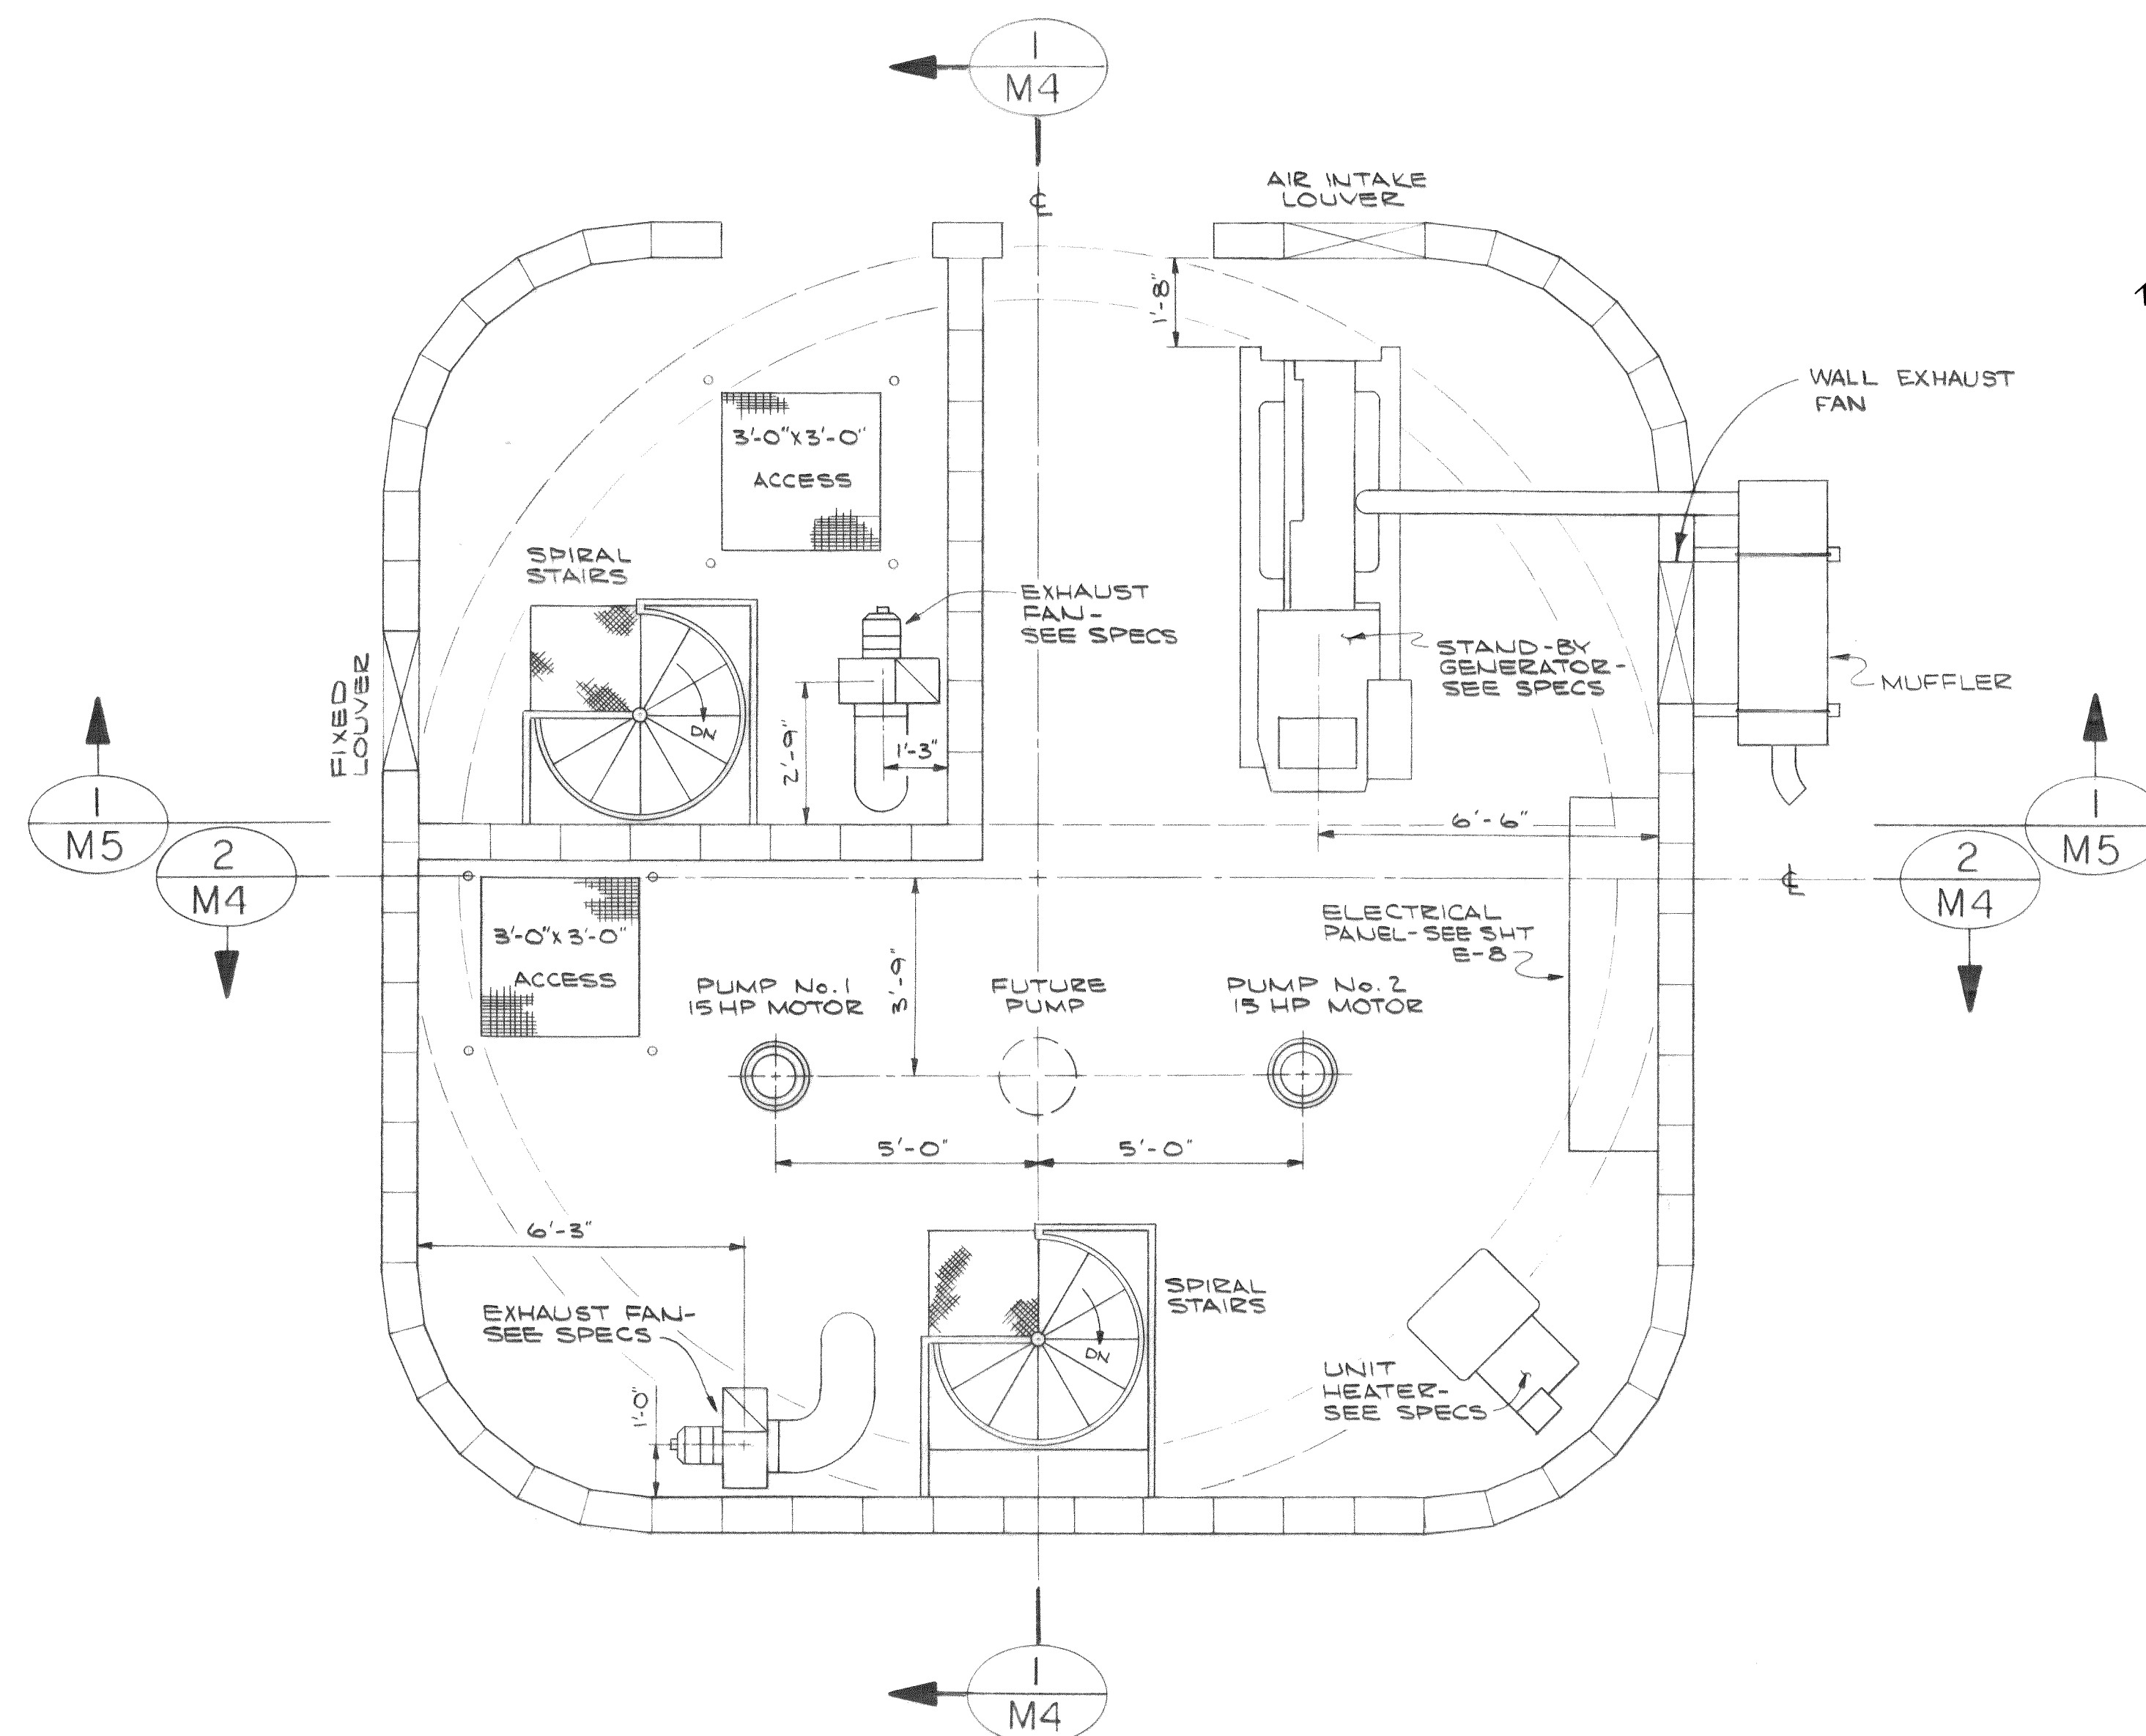

PLAN
MOTOR ROOM FLOOR
SCALE: 3/8"=1'-0"

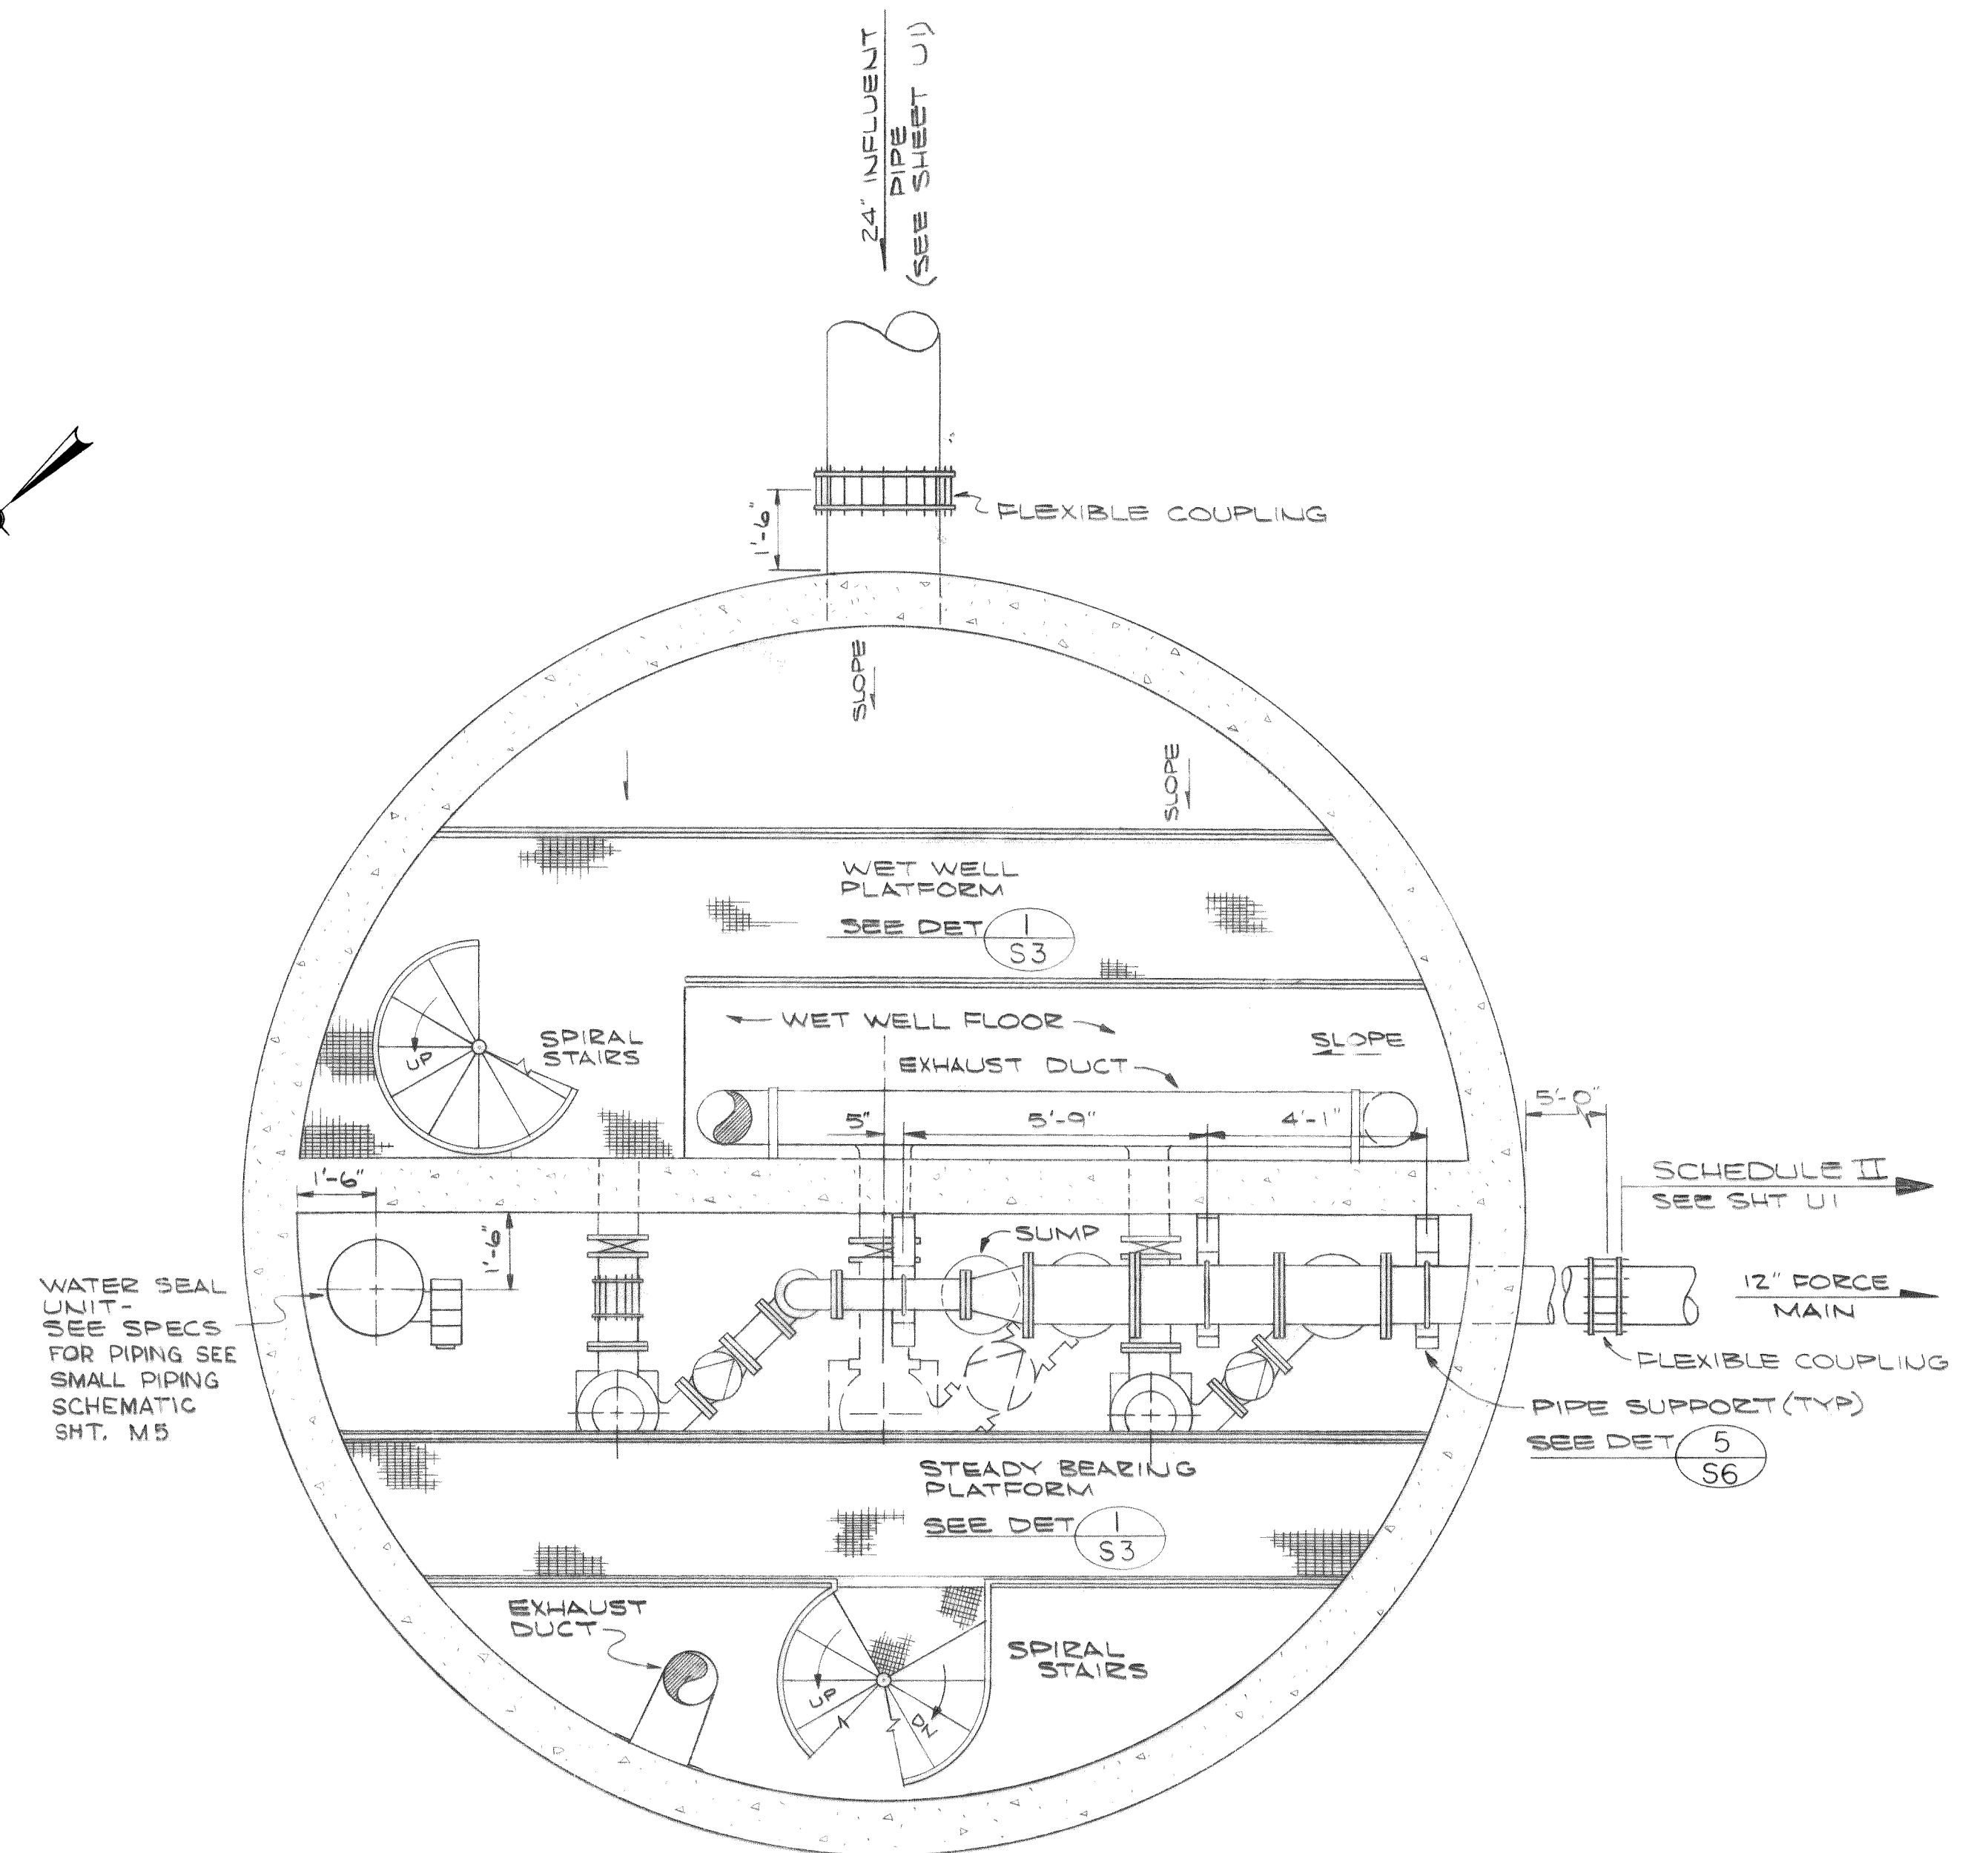

PLAN
PUMP ROOM & WET WELL
SCALE: 3/8"=1'-0"

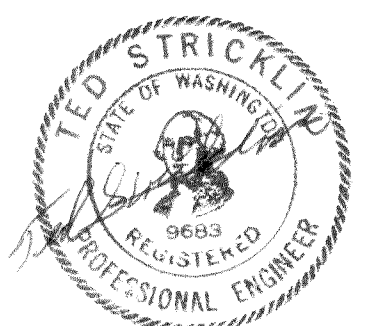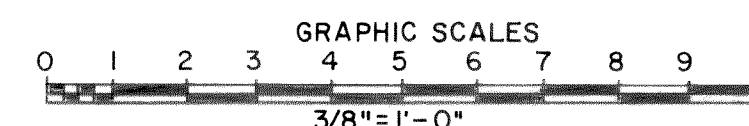

DESIGNED	T.S.	APPROVED	<i>Tech. Runyan</i>
DRAWN	J.M.H.	SCALE	AS SHOWN
DATE		DATE	JULY, 1972
NO.		FILE	71-S-425.002
REVISION		CHECKED	<i>L.H.</i>
BY			



Stevens, Thompson & Runyan, Inc.
Engineers/Planners
PORTLAND SEATTLE BOISE


TOWN OF FERNDAL, WASHINGTON
AXTON ROAD INTERCEPTOR
SCHEDULE I

PUMP STATION I
MECHANICAL PLANS


M3
8

MICROFILMED


00810.017 8-7-06 KR

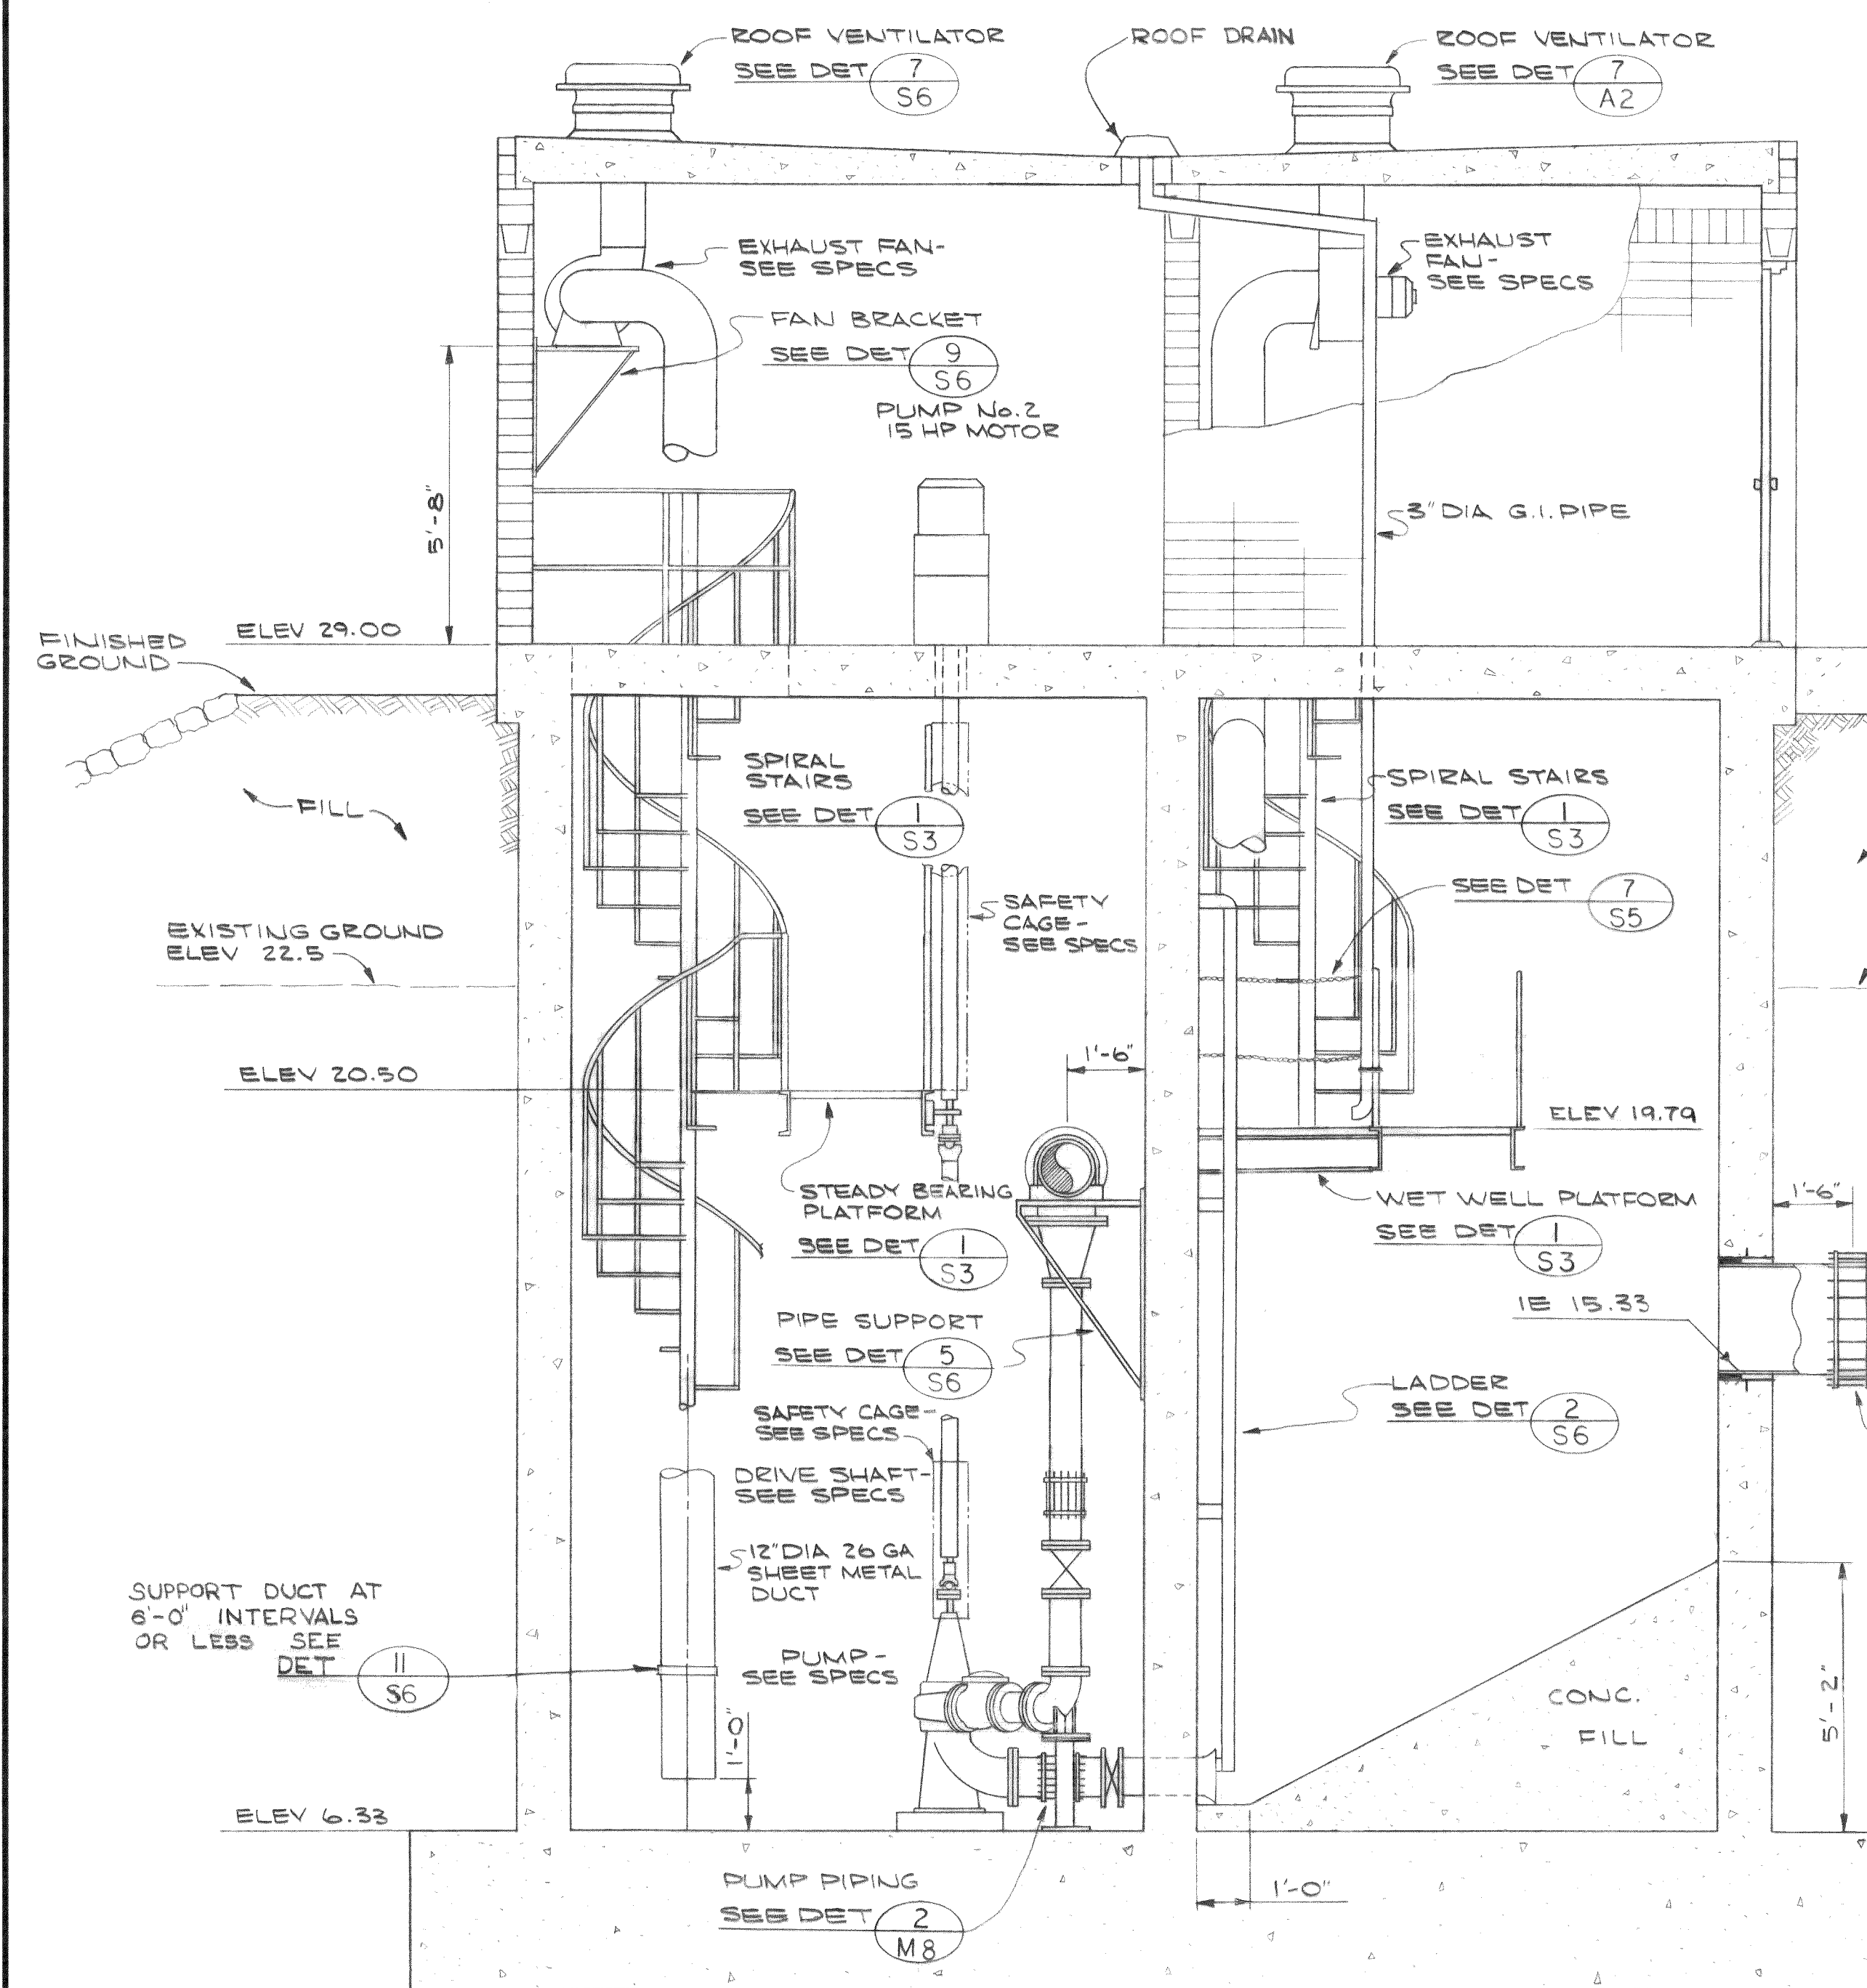

SECTION 1
SCALE 3/8"=1'-0"

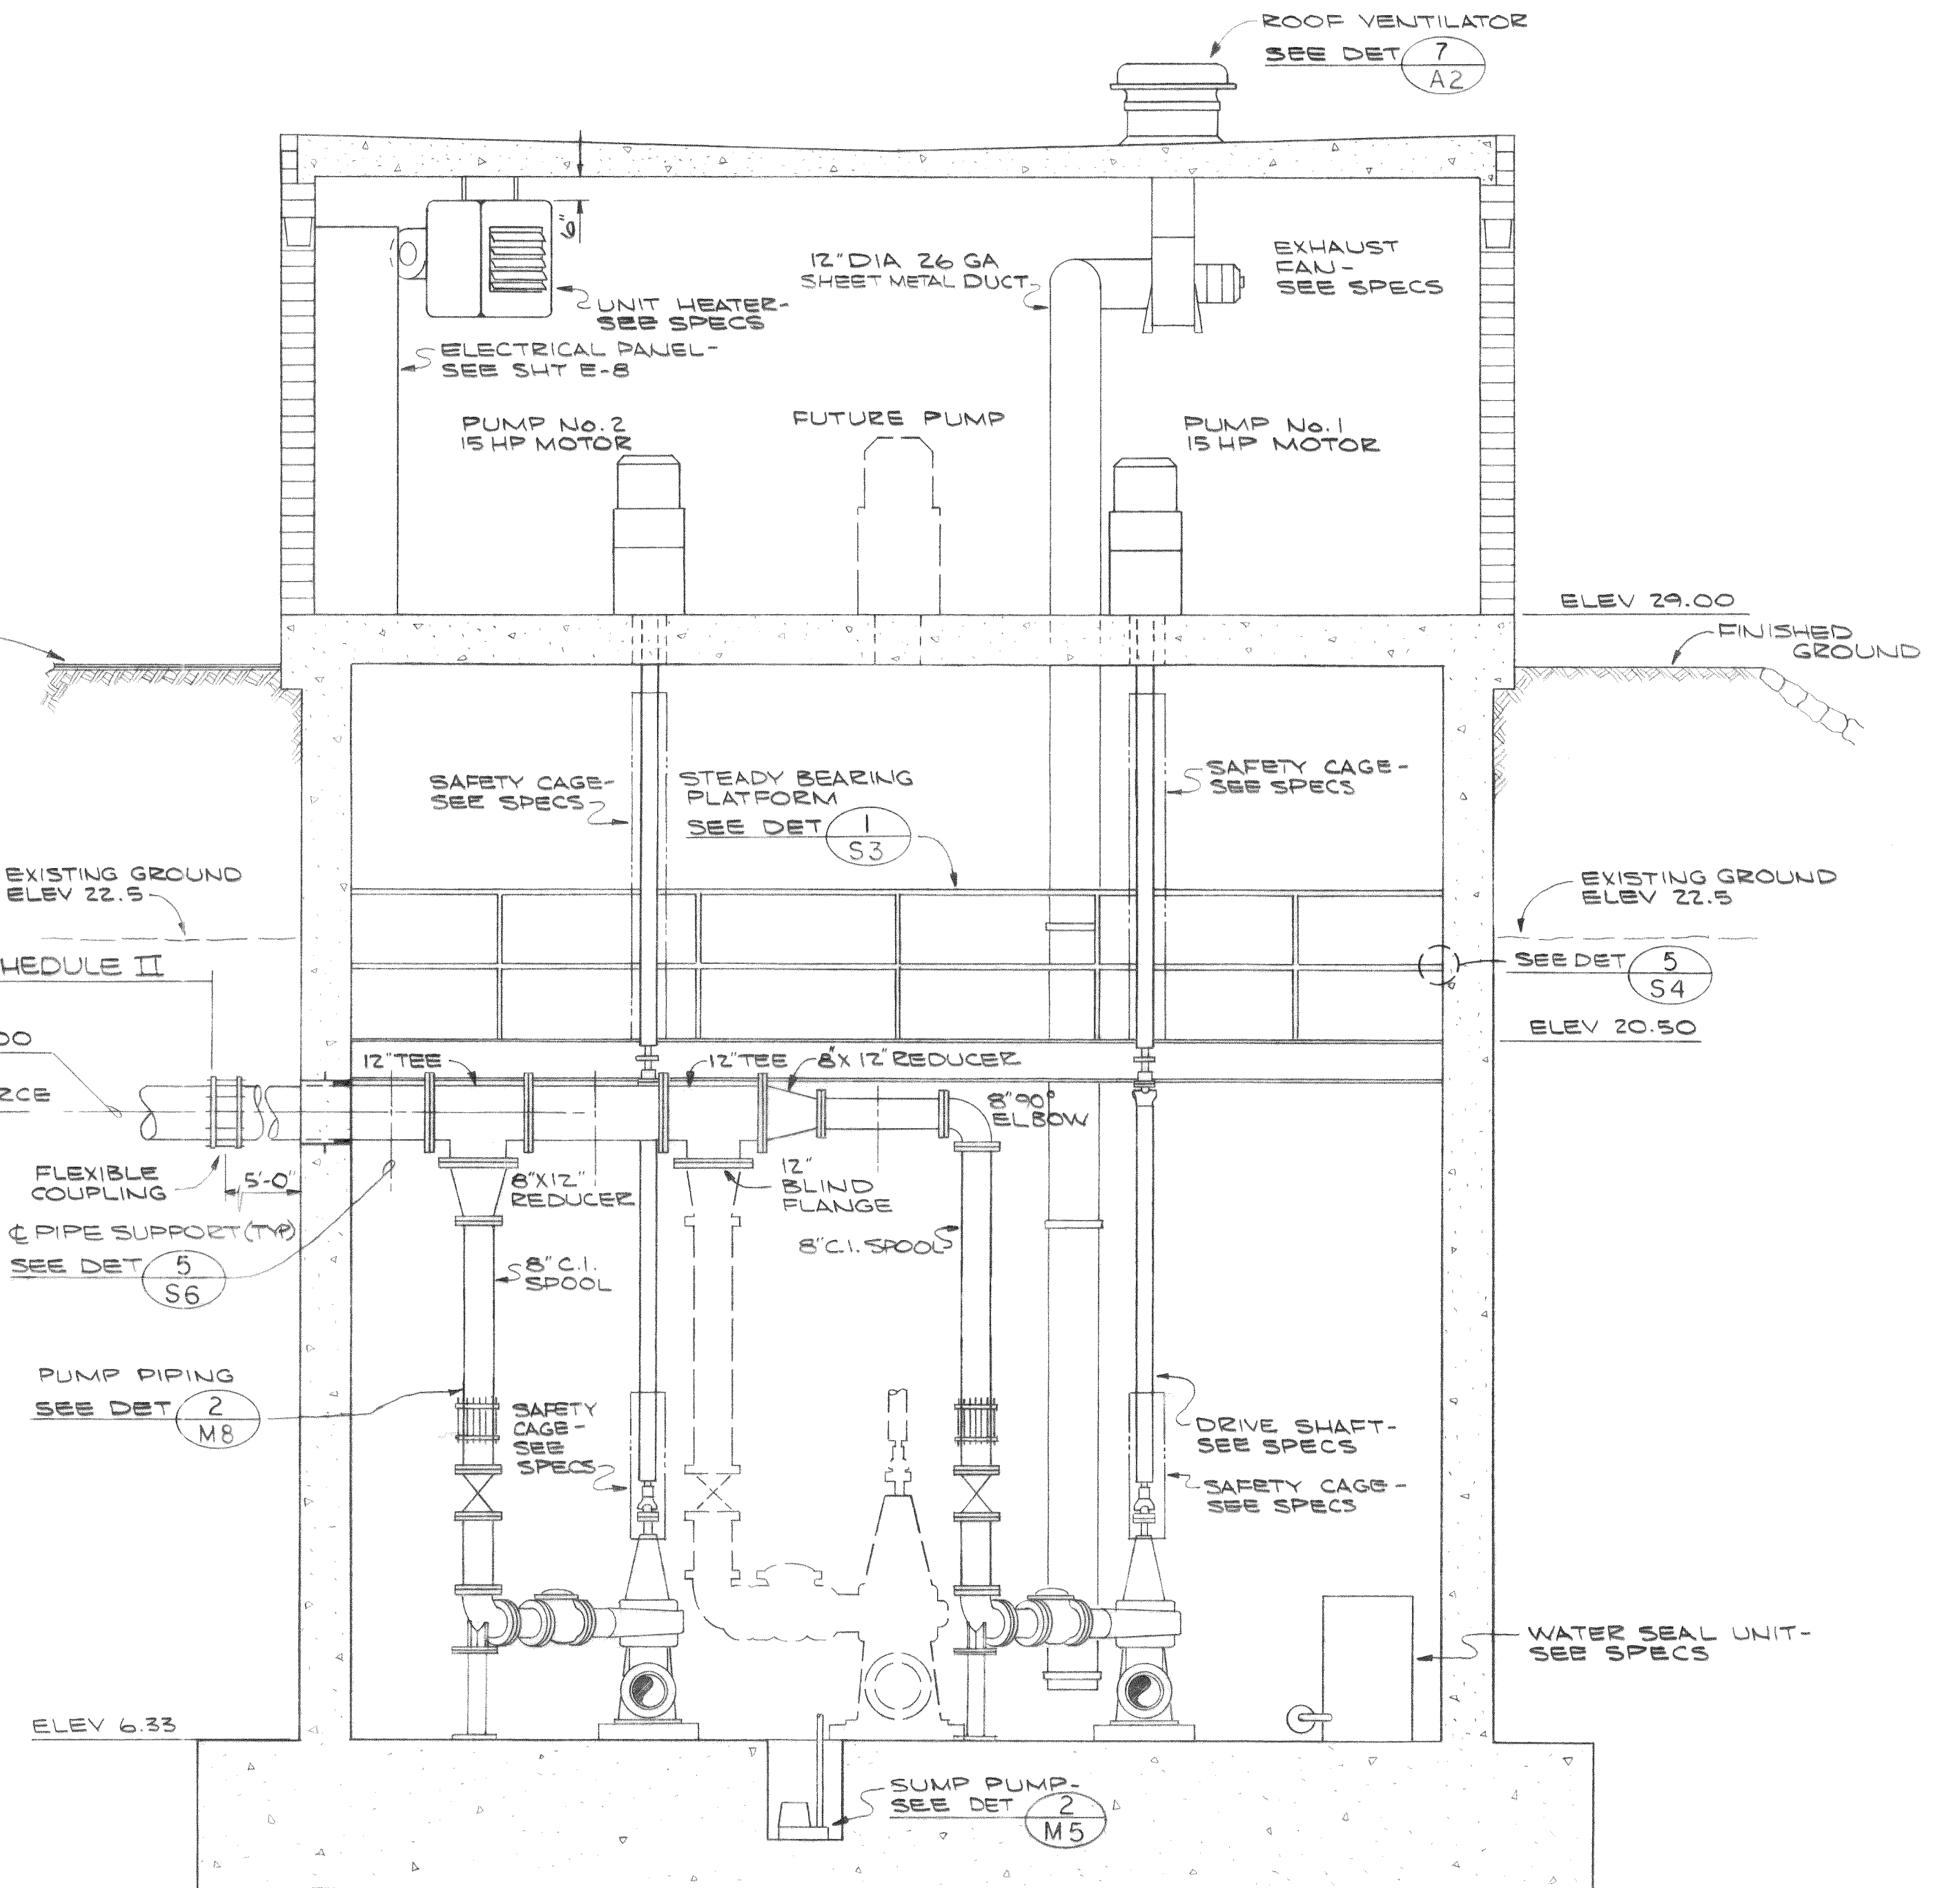

SECTION 2
SCALE 3/8"=1'-0"

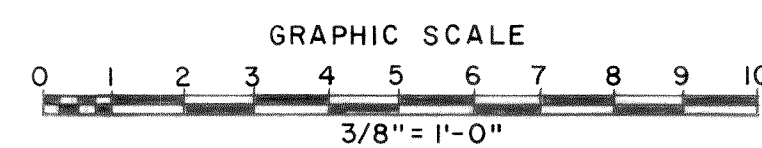

DESIGNED T. S.	APPROVED <i>Rich. H. H.</i>
DRAWN J. M. H.	SCALE AS SHOWN DATE JULY, 1972
CHECKED <i>ATC</i>	FILE 71-S-425.002




Stevens, Thompson & Runyan, Inc.
Engineers/Planners
PORTLAND SEATTLE BOISE


TOWN OF FERDALE, WASHINGTON
AXTON ROAD INTERCEPTOR
SCHEDULE I

PUMP STATION I
MECHANICAL SECTIONS


M4
8

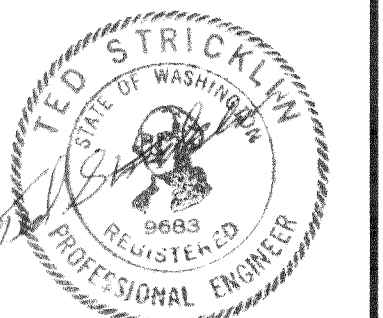

MICROFILMED


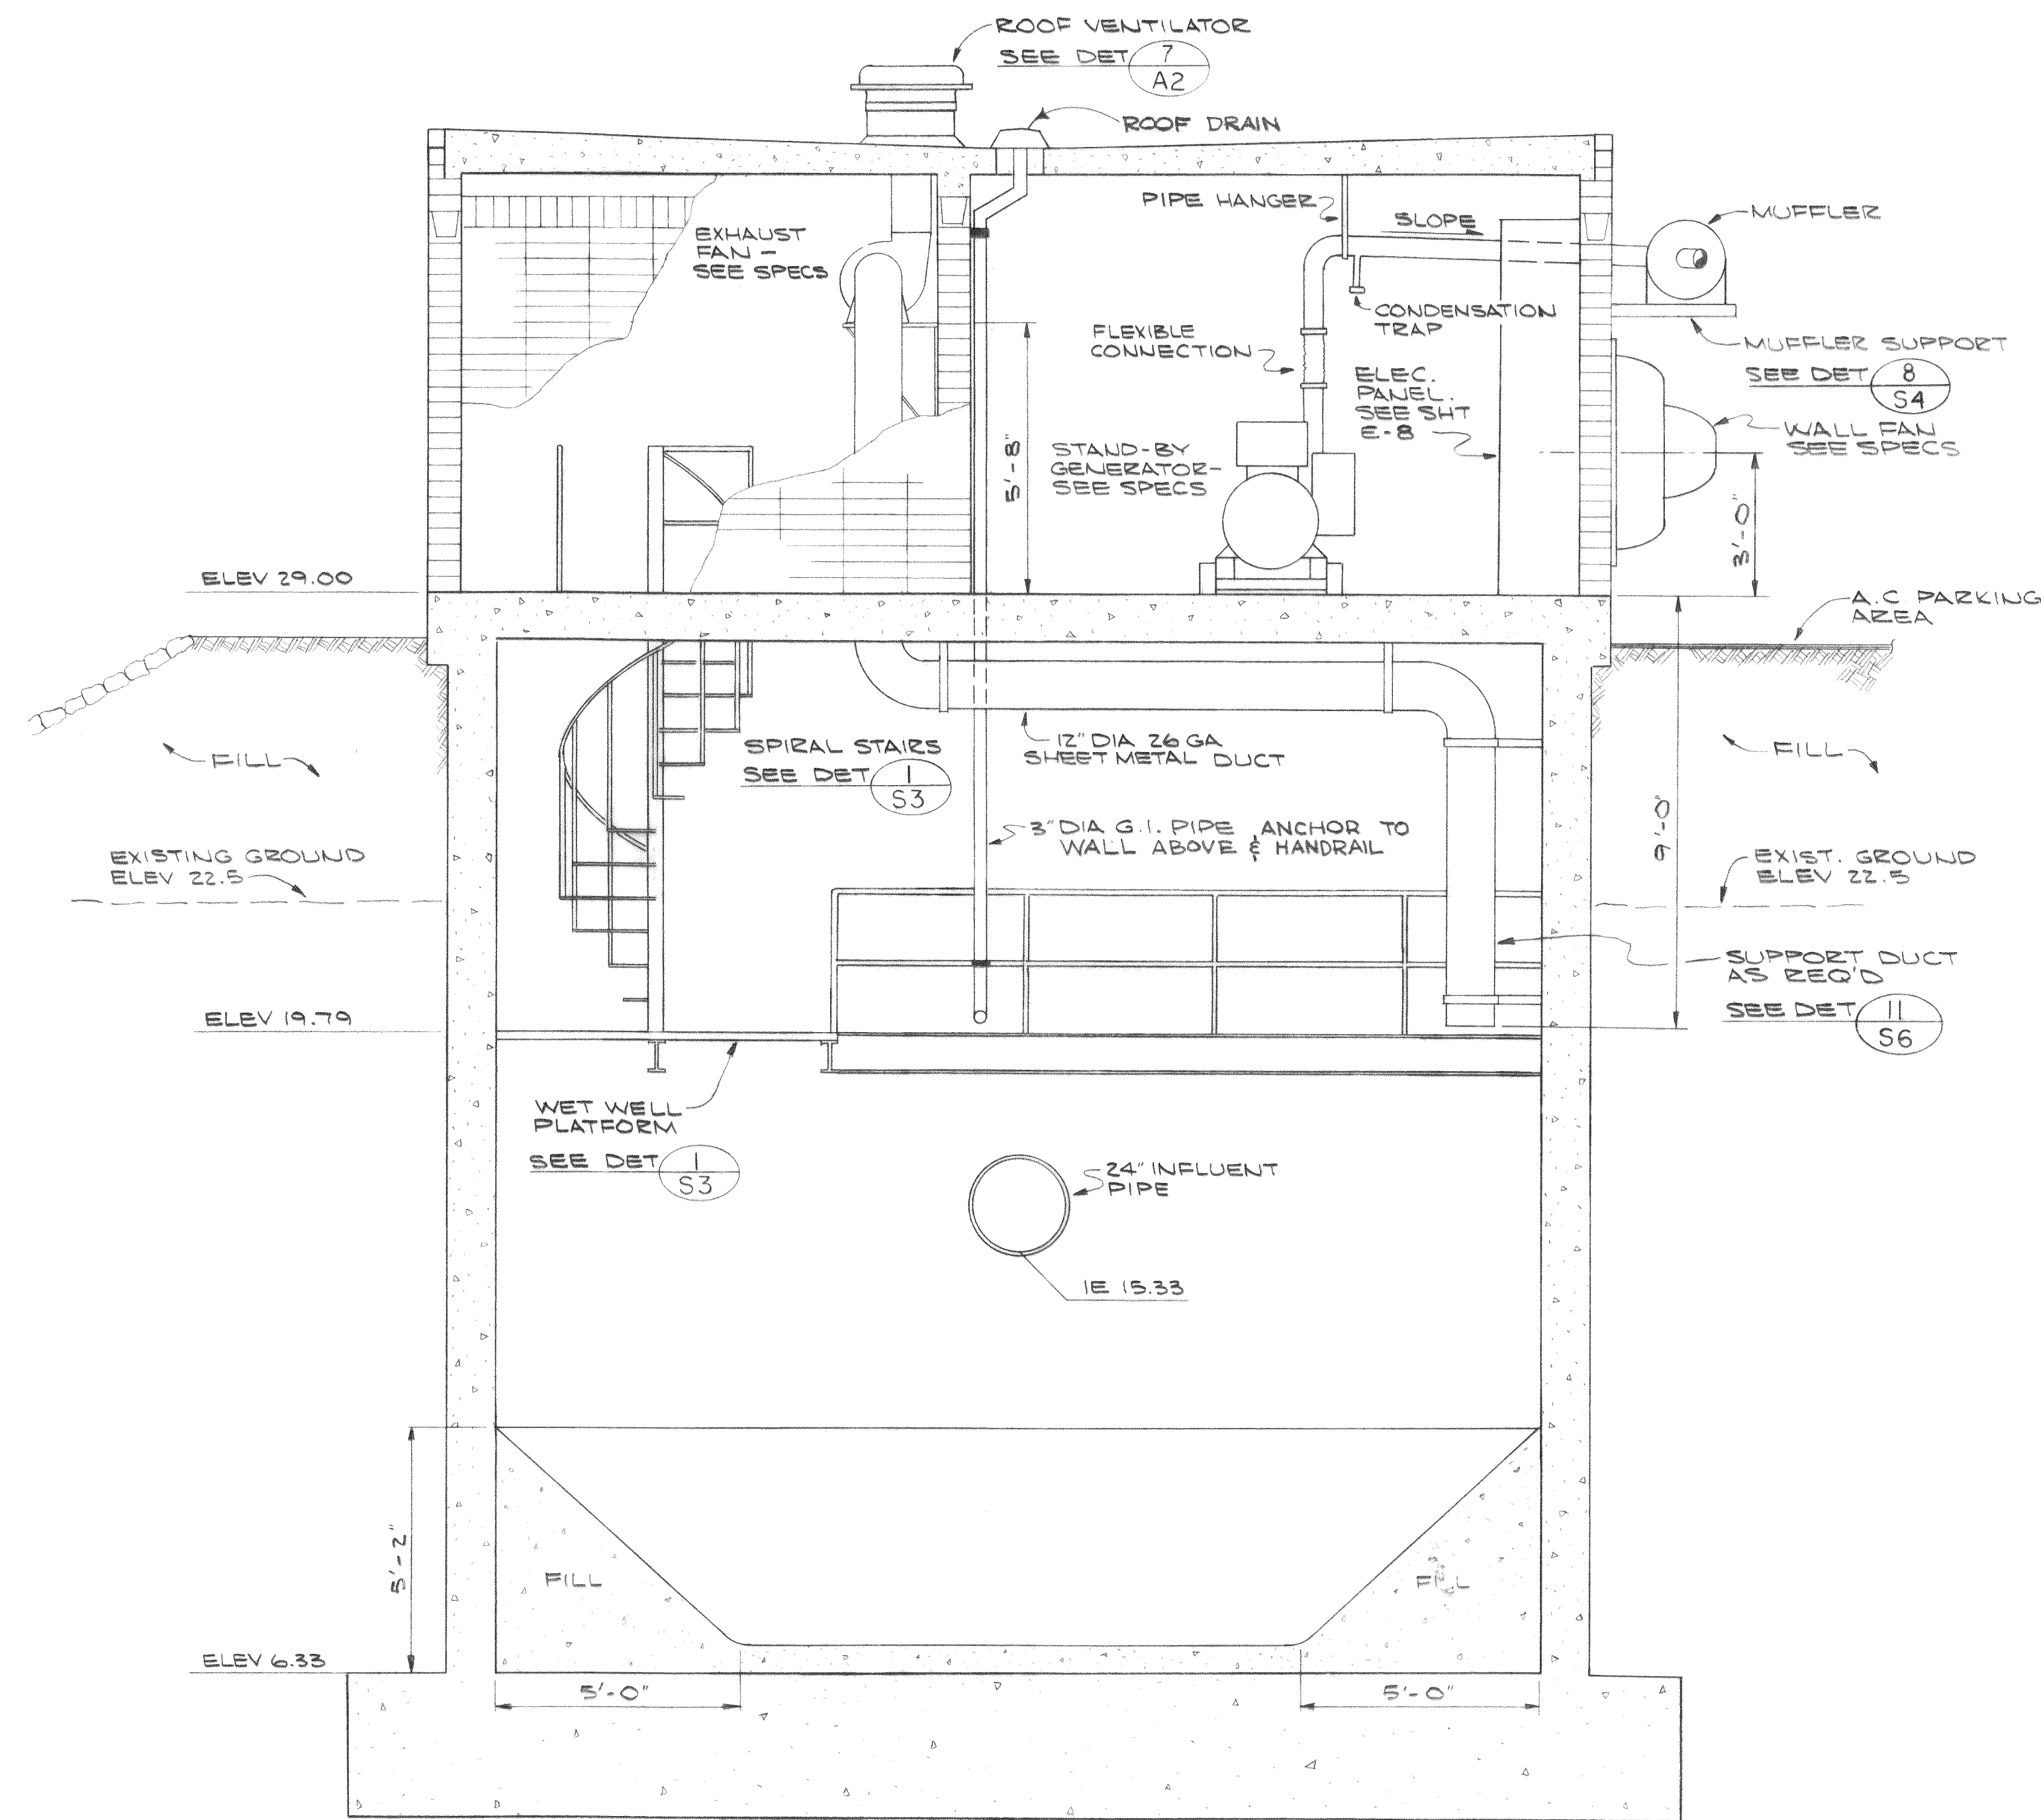


SECTION 1 M3
SCALE 3/8"=1'-0"

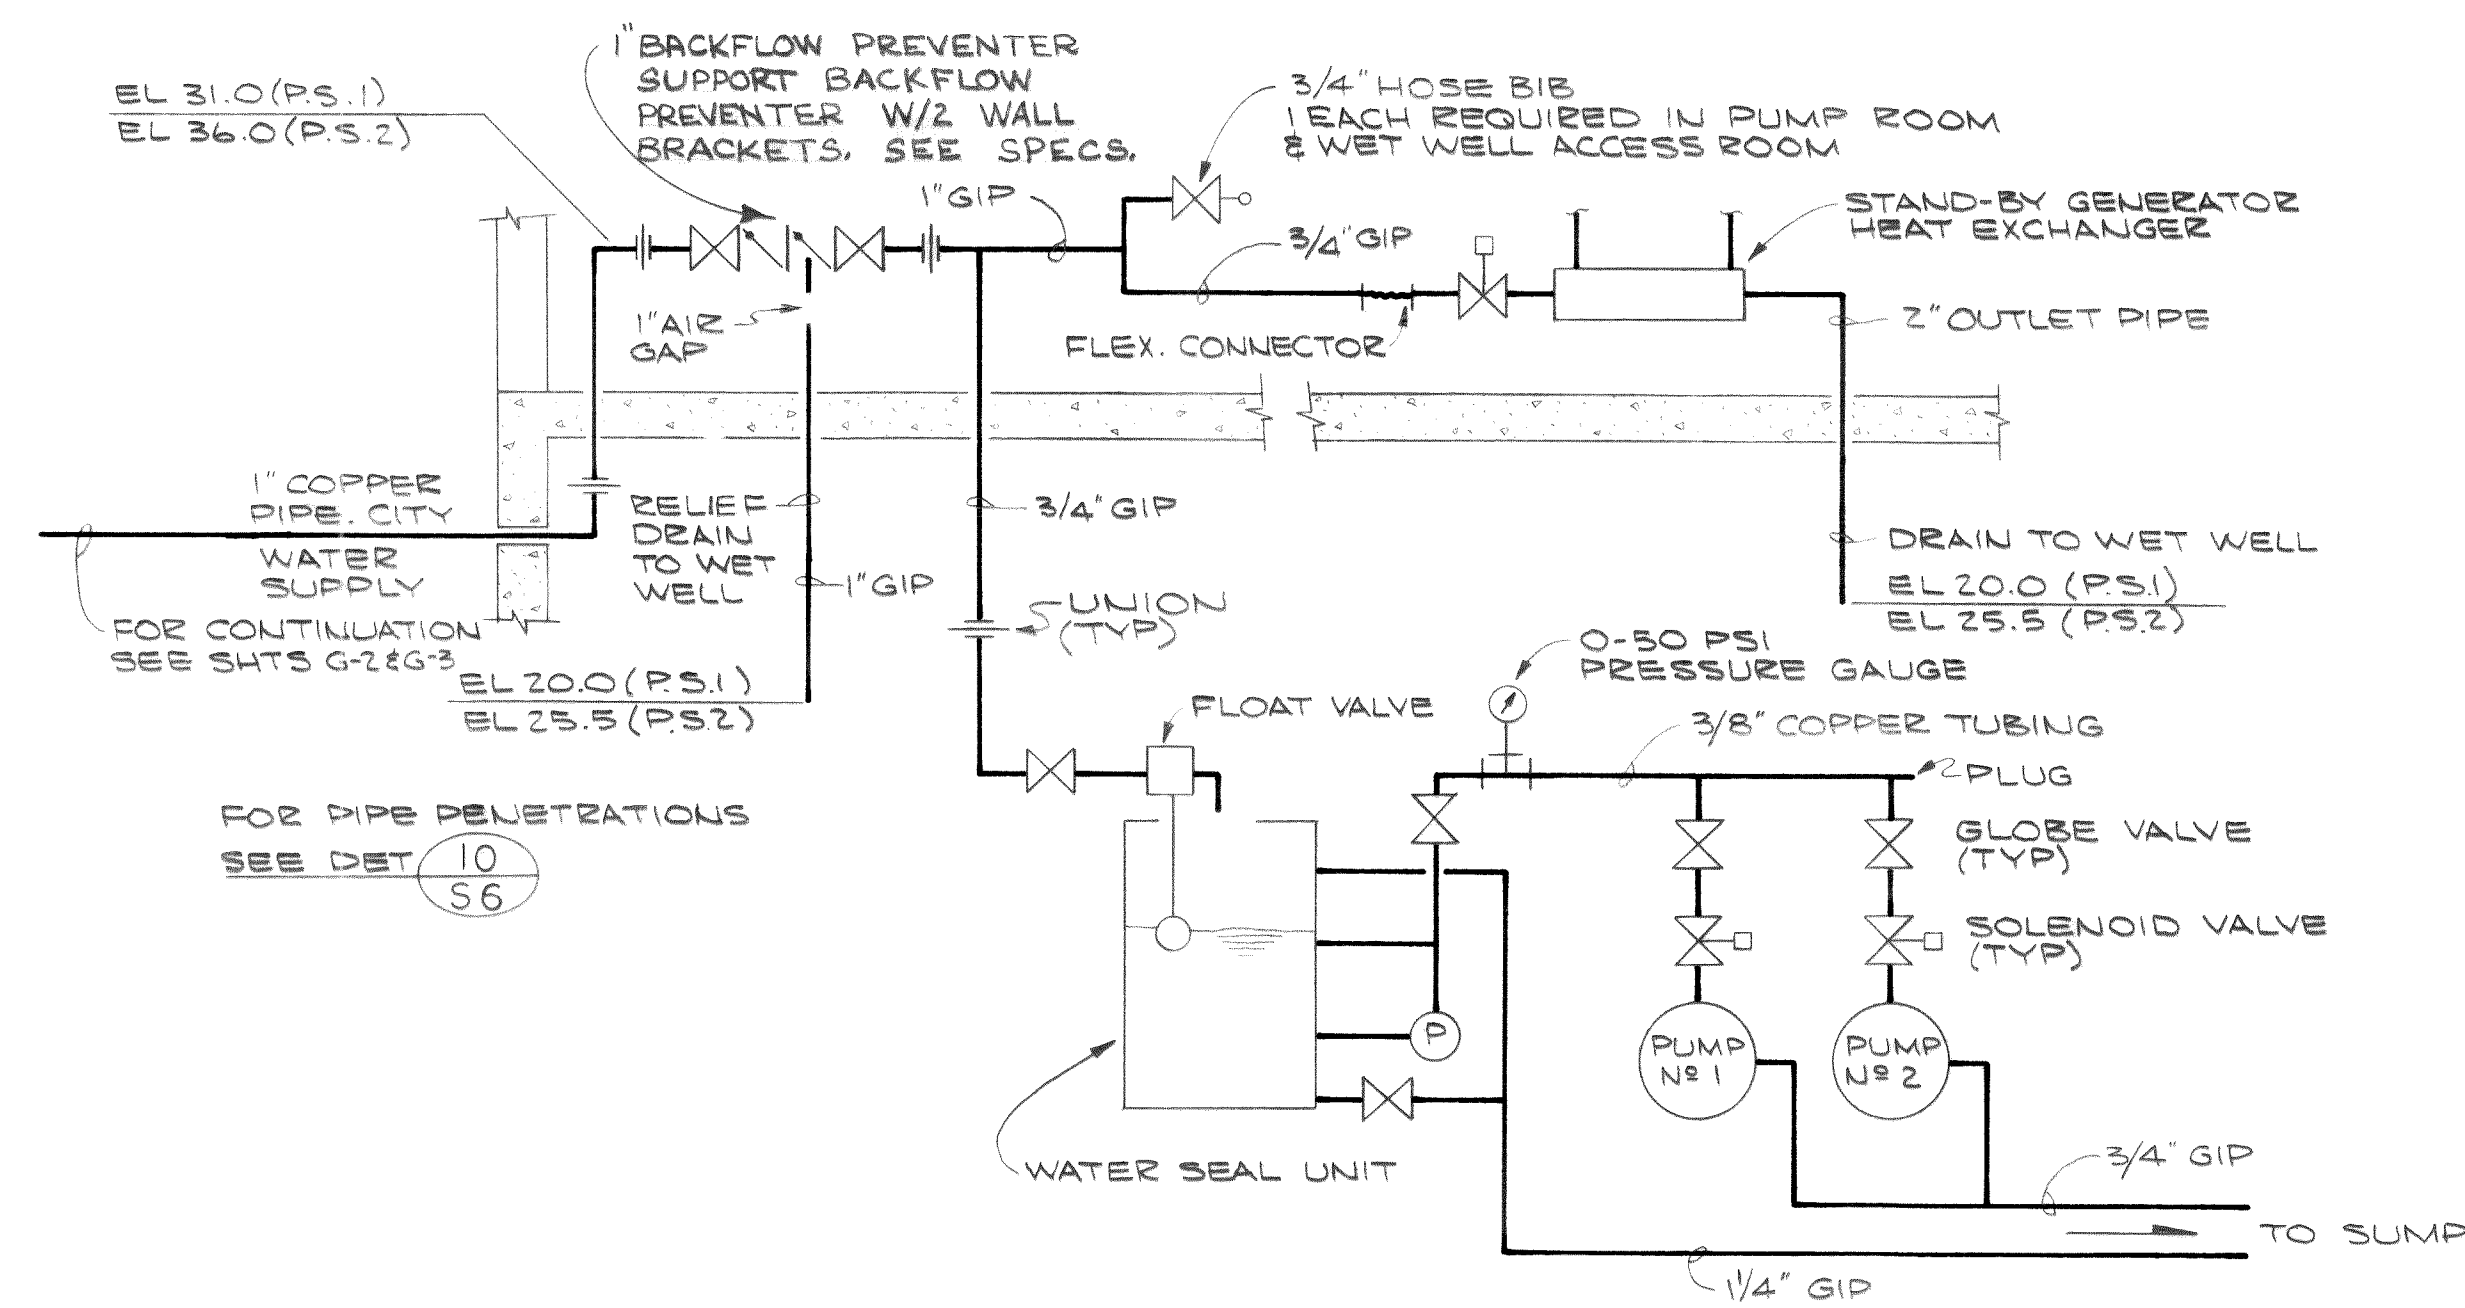

NOTE: SUPPORT ALL SMALL PIPING FROM WALLS IN HORIZONTAL AND VERTICAL RUNS TO PREVENT SAG OR MOVEMENT.

FOR GAS PIPING SCHEMATIC SEE SHEET M.3.

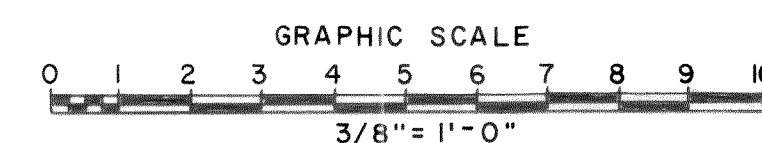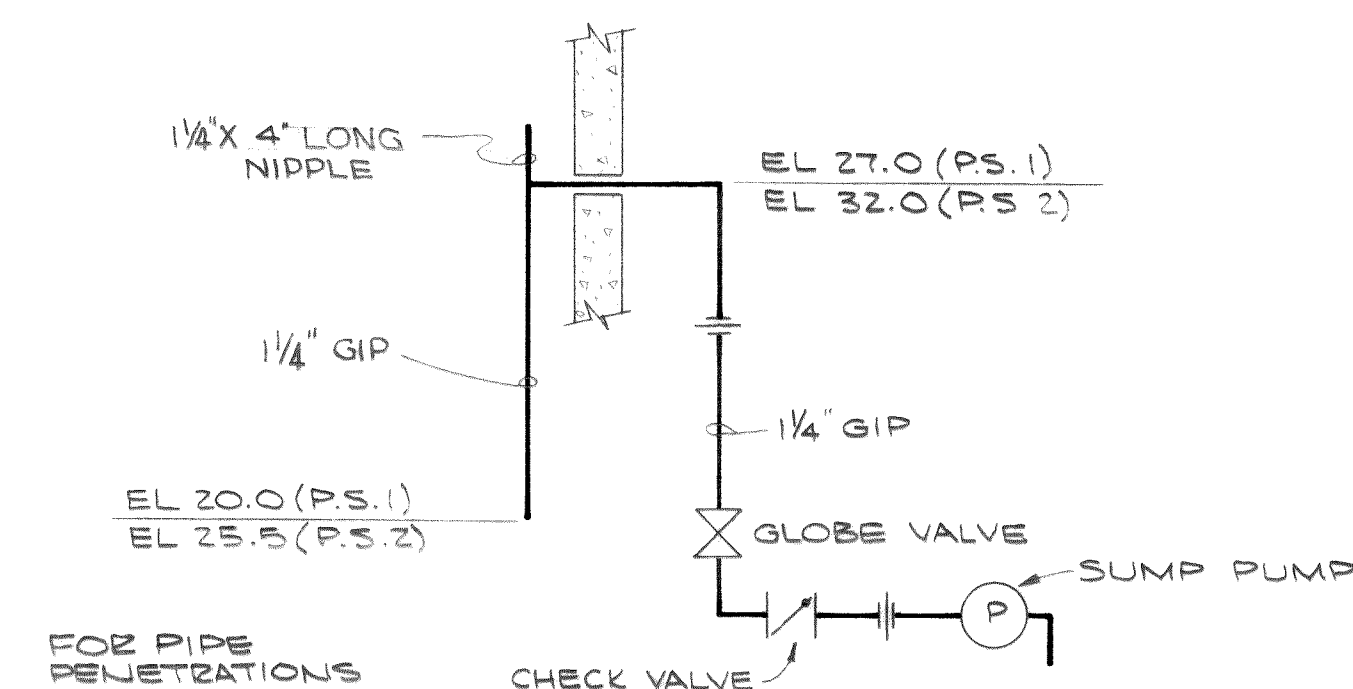

DESIGNED T.S.	APPROVED <i>Ted Stricklin</i>
DRAWN J.M.H.	SCALE AS SHOWN DATE JULY, 1972
CHECKED <i>LTB</i>	FILE 71-S-425.002

ST Stevens, Thompson & Runyan, Inc.
Engineers/Planners
PORTLAND SEATTLE BOISE


TOWN OF FERNDAL, WASHINGTON
AXTON ROAD INTERCEPTOR
SCHEDULE I

PUMP STATION 1
MECHANICAL SECTION



M5
8

MICROFILMED

00210.020 2-7-06 KR

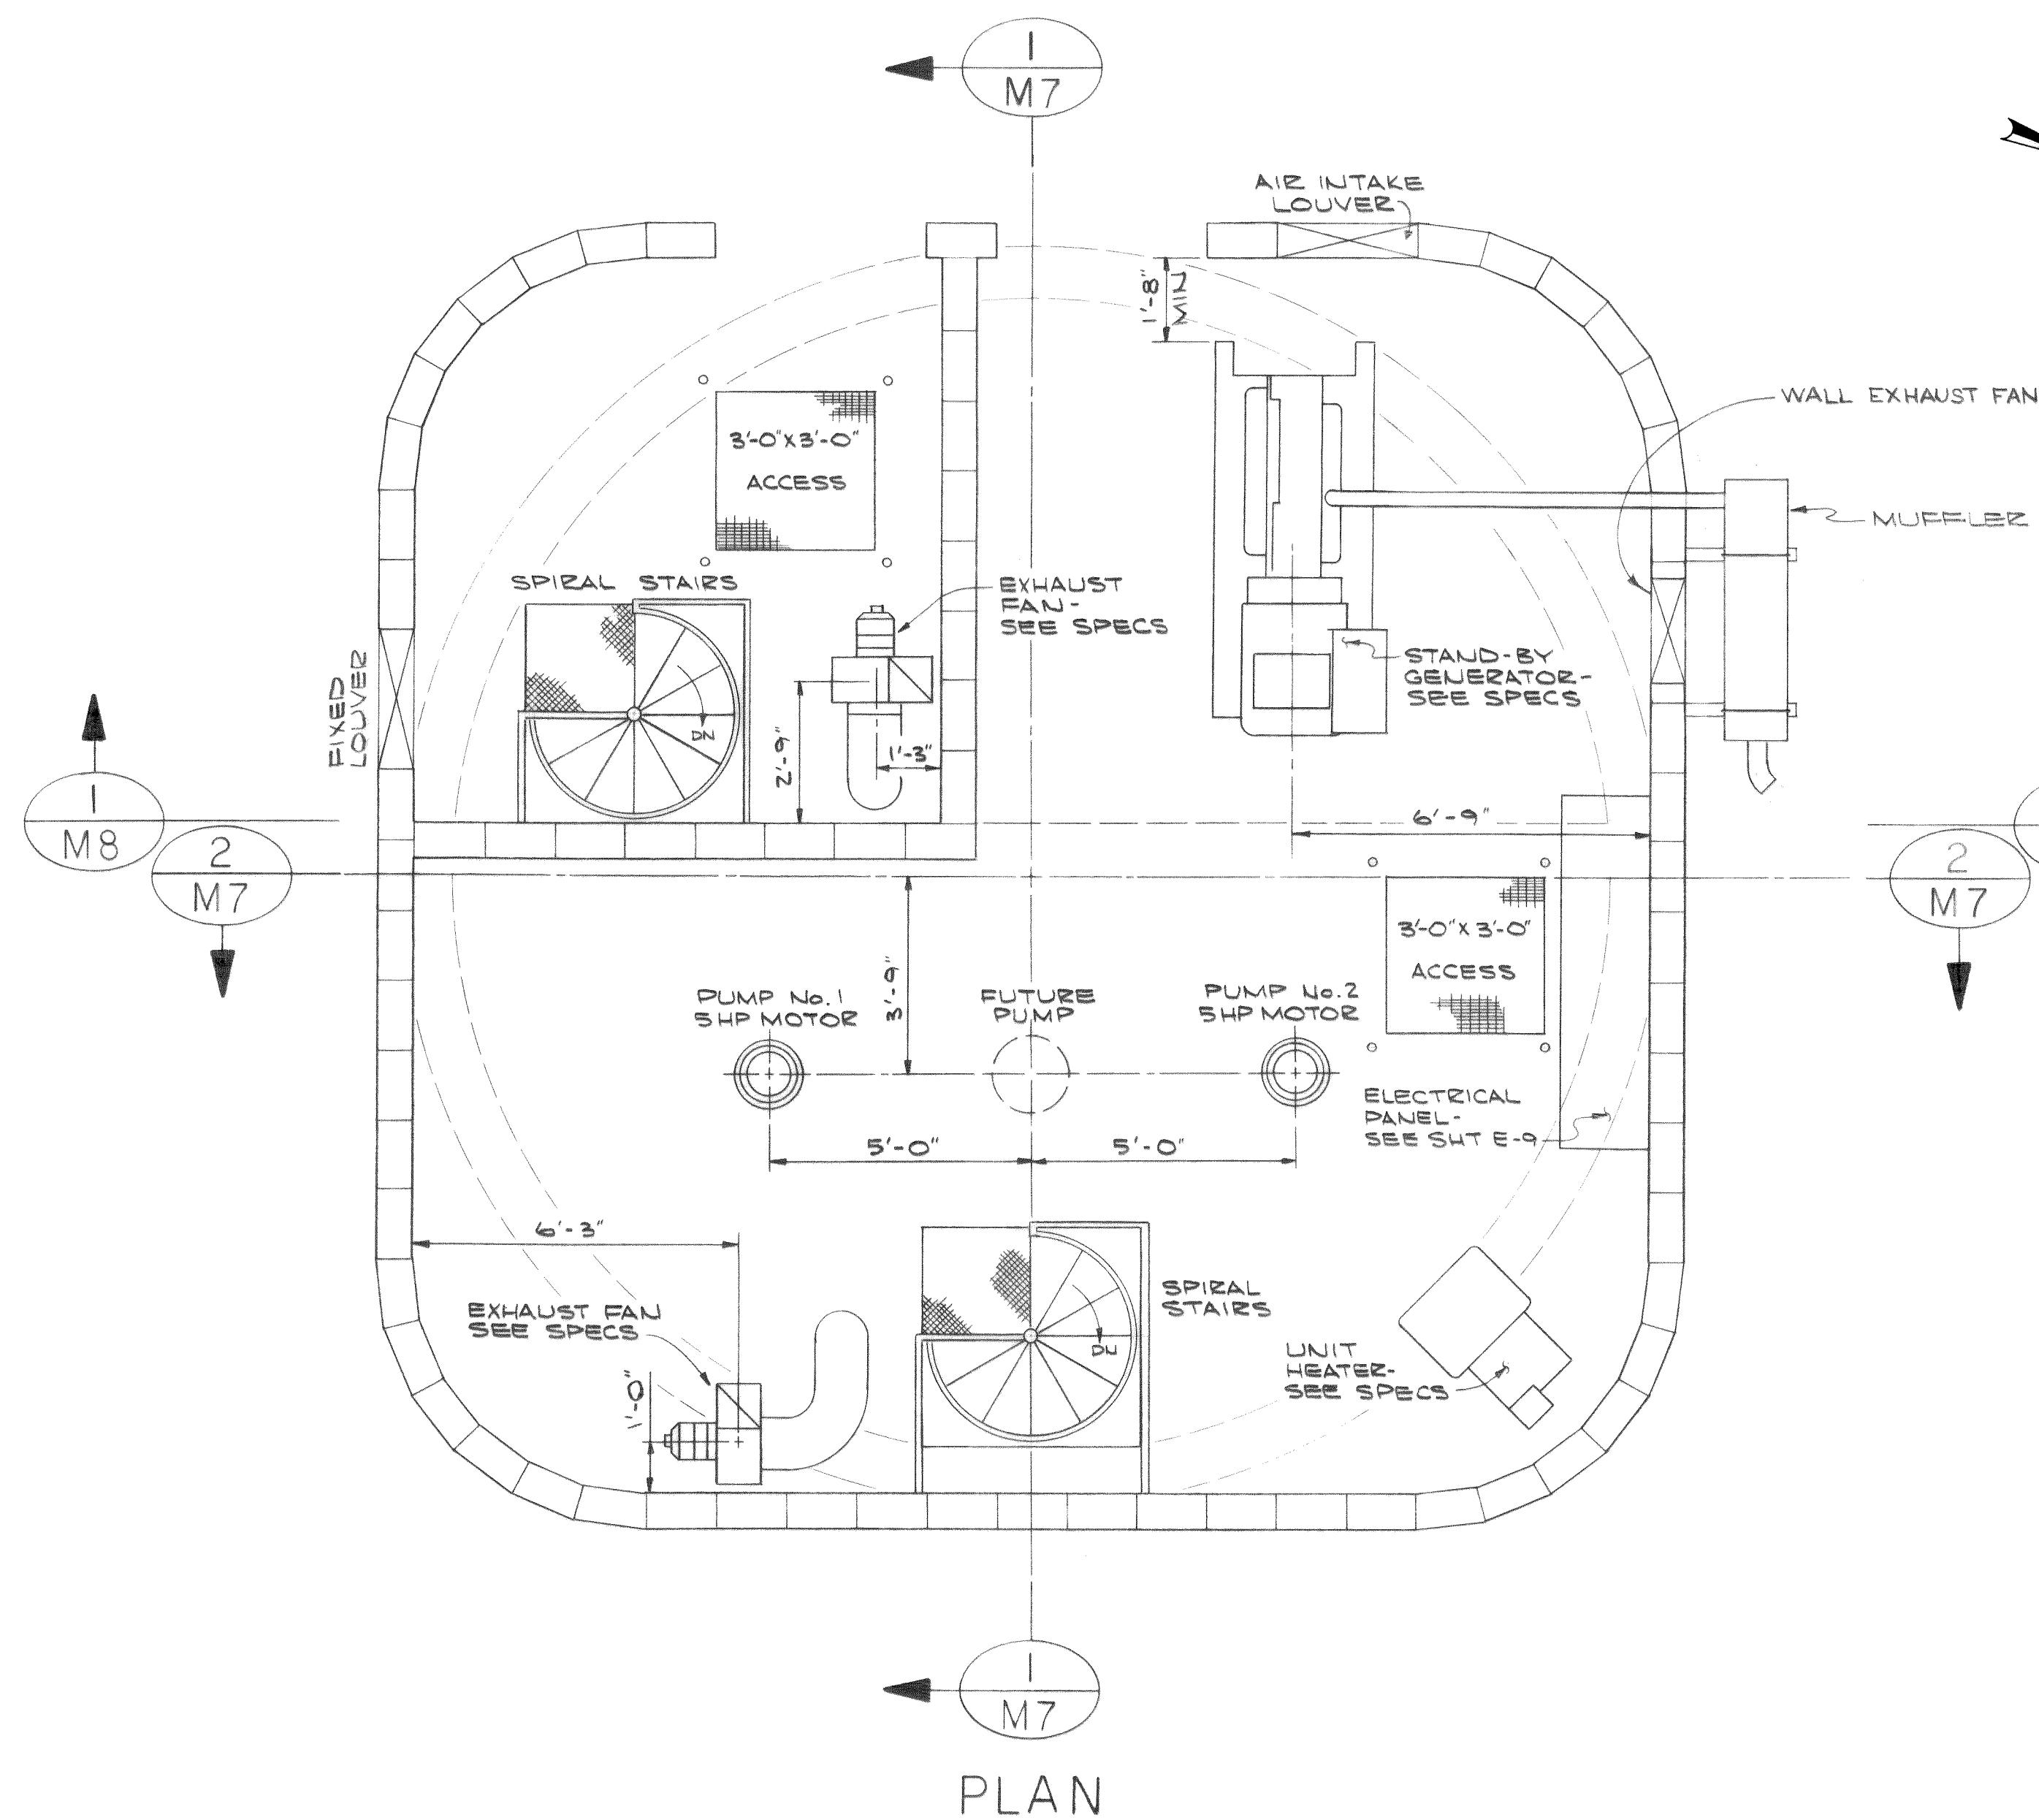

PLAN
MOTOR ROOM FLOOR
SCALE 3/8" = 1'-0"

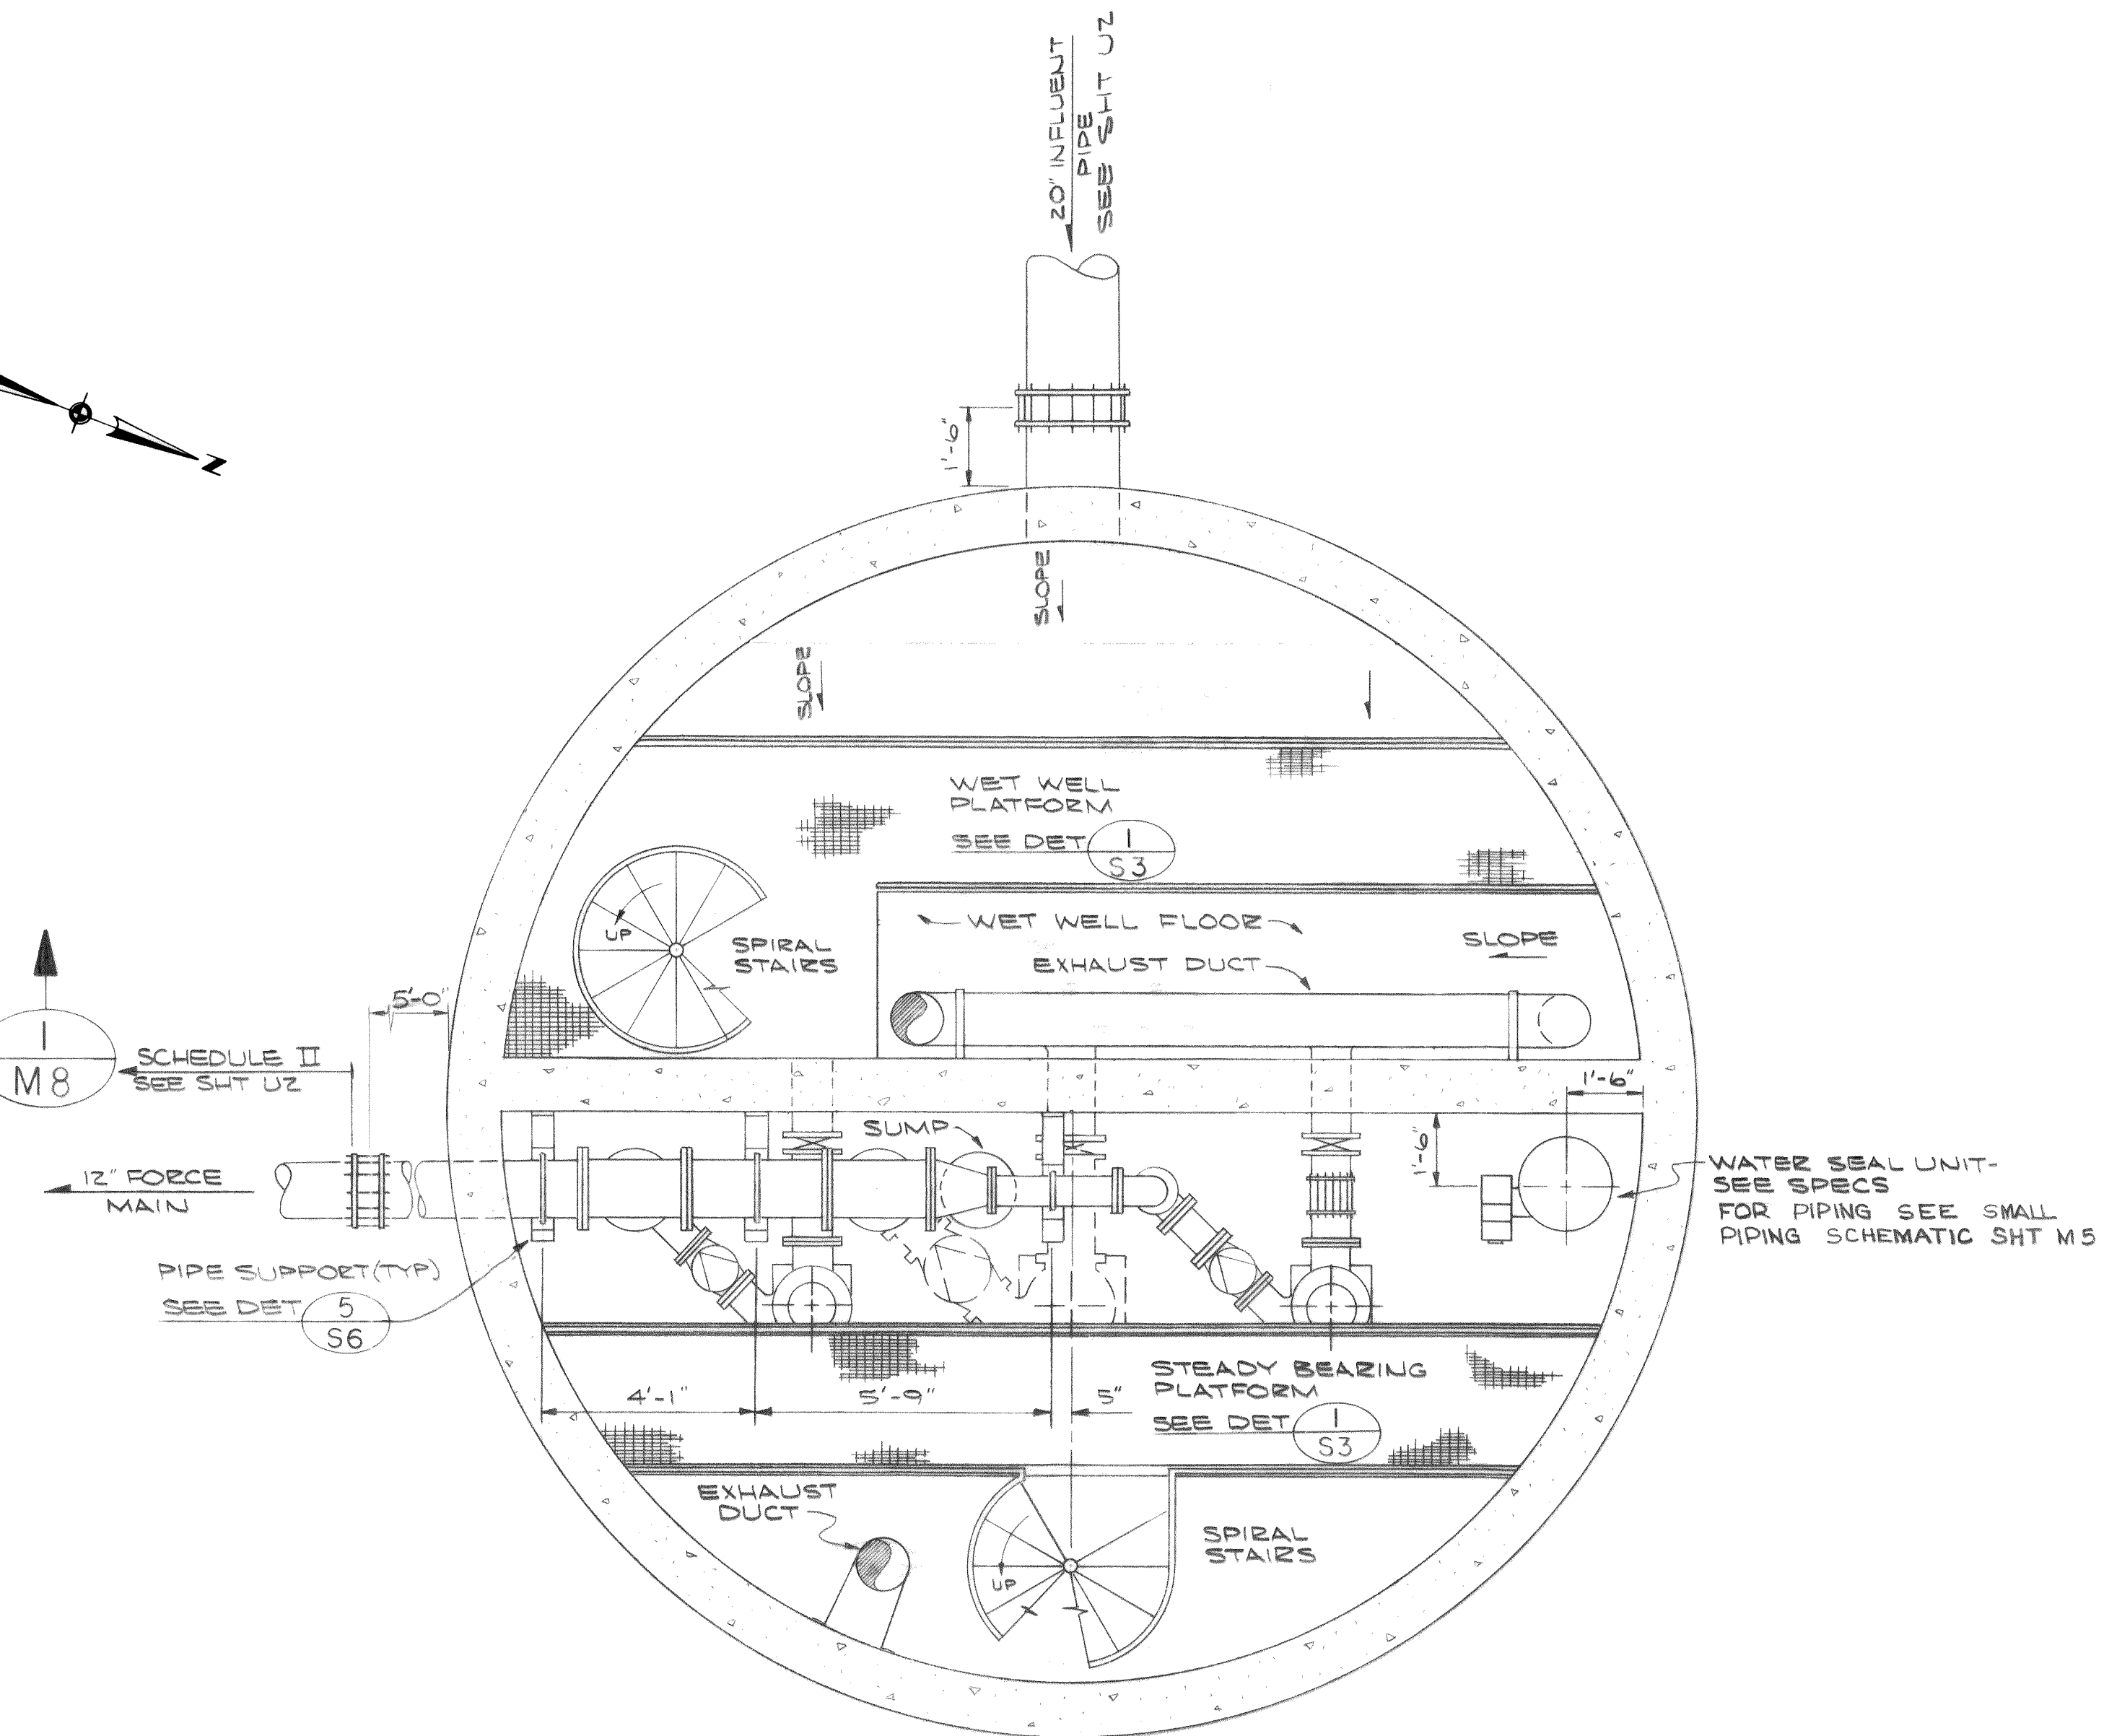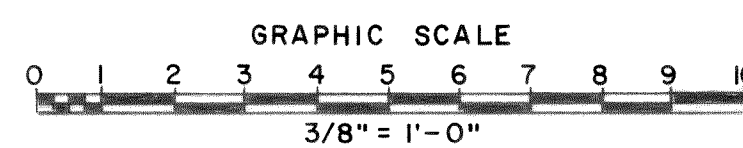

PLAN
PUMP ROOM & WET WELL
SCALE: 3/8" = 1'-0"



DESIGNED	T.S.	APPROVED	<i>Paul Hanna</i>
DRAWN	J.M.H.	SCALE	AS SHOWN
DATE		DATE	JULY, 1972
NO.		FILE	71-S-425.002
REVISION		CHECKED	<i>AB</i>
BY			



Stevens, Thompson & Runyan, Inc.
Engineers/Planners
PORTLAND SEATTLE BOISE


TOWN OF FERDALE, WASHINGTON
AXTON ROAD INTERCEPTOR
SCHEDULE I

PUMP STATION 2
MECHANICAL PLANS


M6
8

MICROFILMED


00210.021 2-7-06 KL

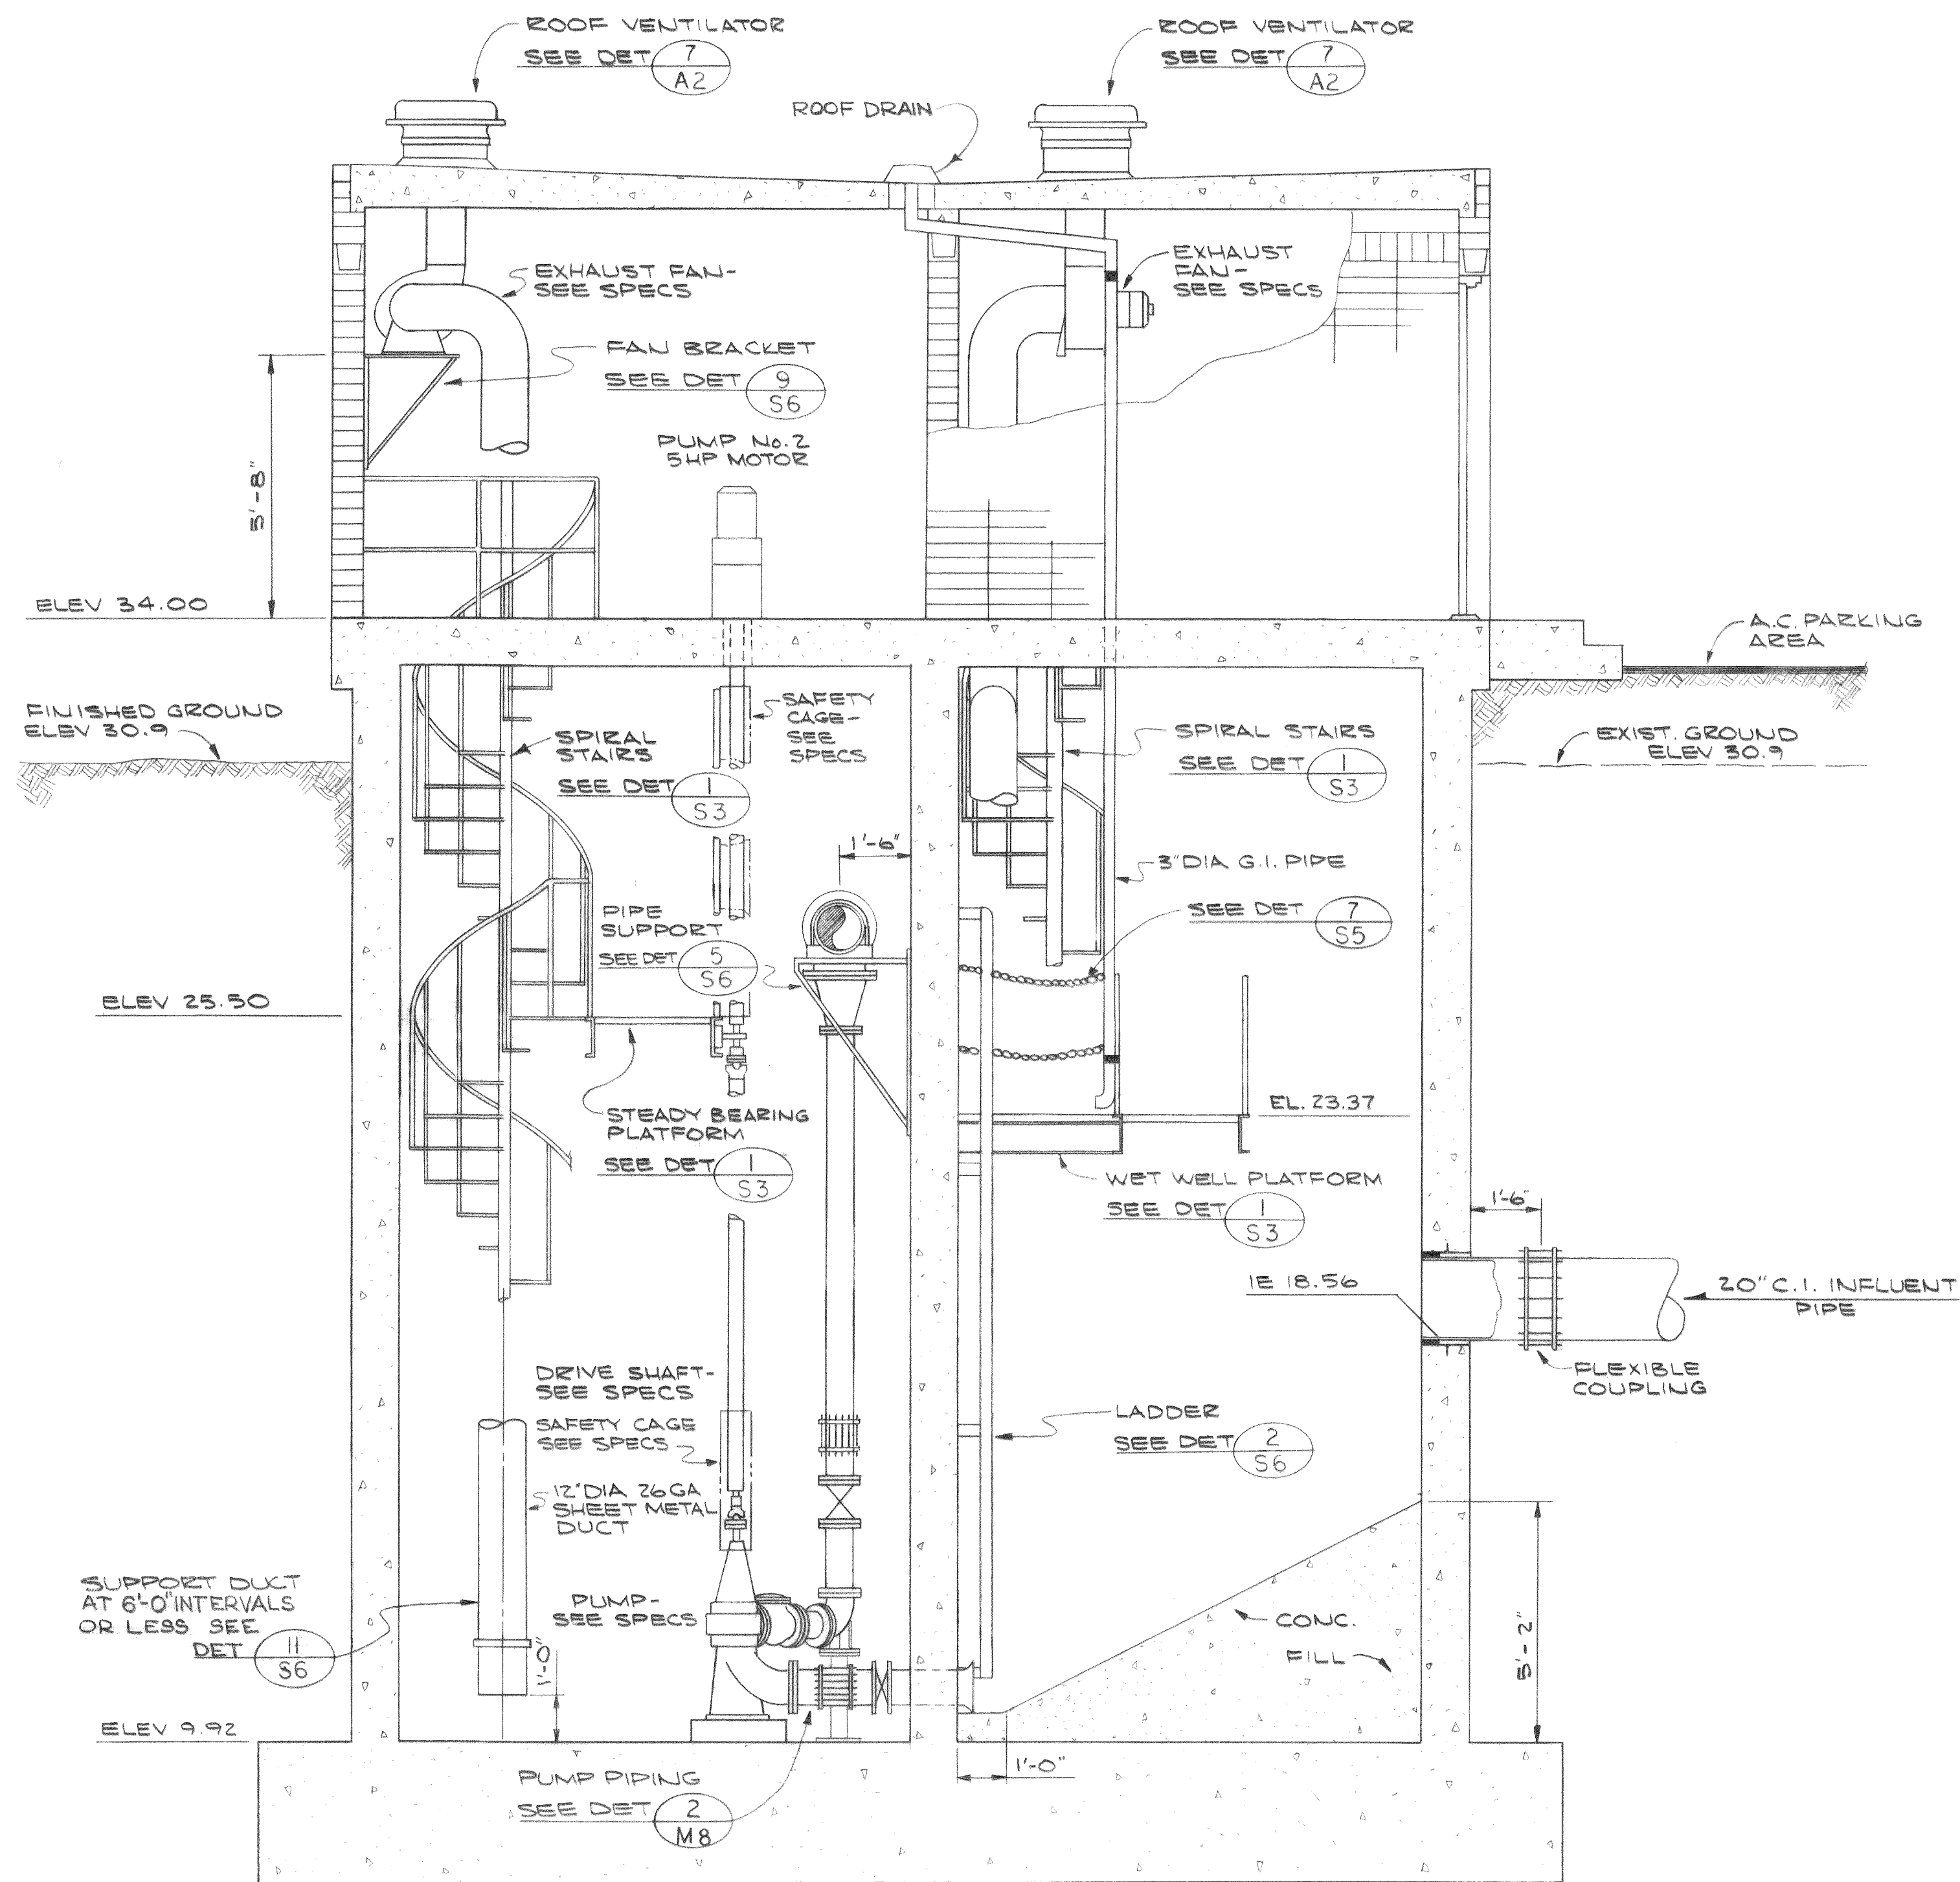

SECTION 1
SCALE: 3/8"=1'-0" M6

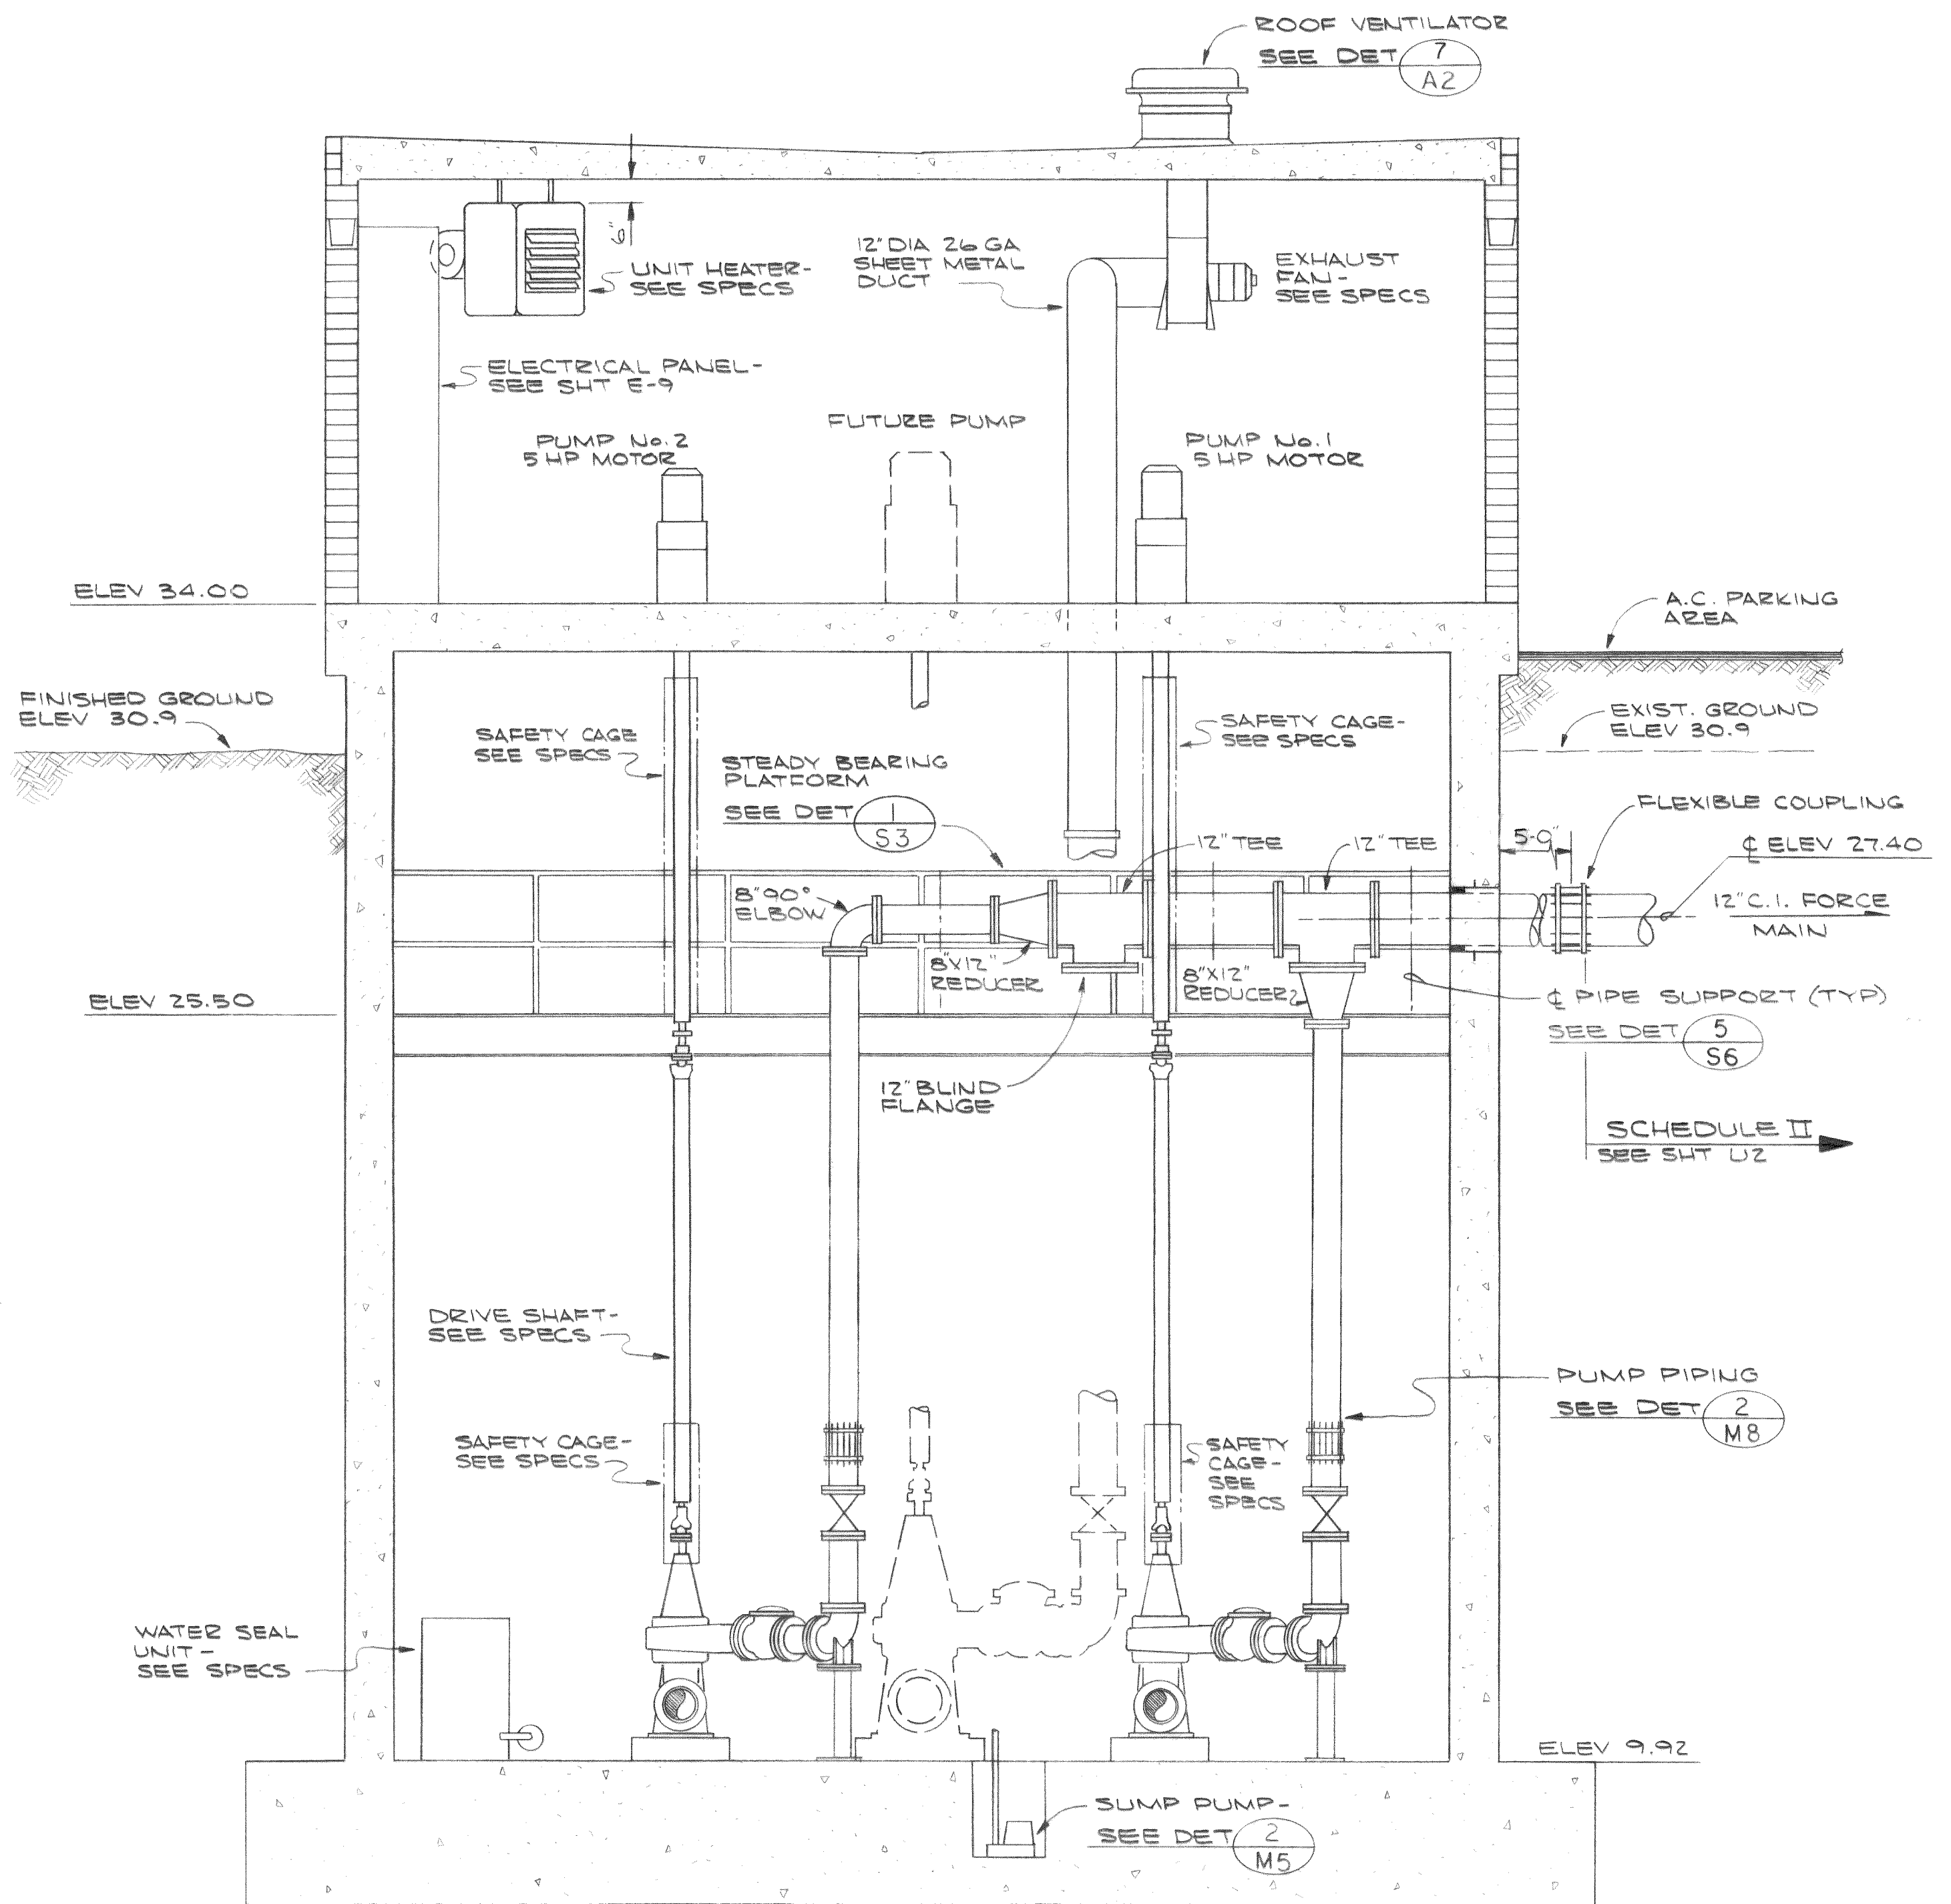

SECTION 2
SCALE: 3/8"=1'-0" M6

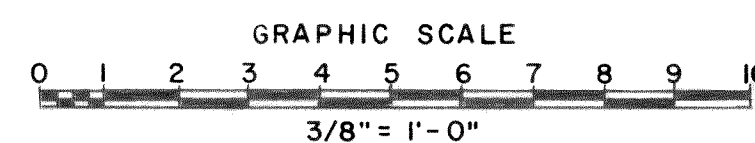

DESIGNED T.S.	APPROVED <i>Ted Stricklin</i>
DRAWN J.M.H.	SCALE AS SHOWN DATE JULY, 1972
CHECKED <i>L.H.</i>	FILE 71-S-425.002



Stevens, Thompson & Runyan, Inc.
Engineers/Planners
PORTLAND SEATTLE BOISE


TOWN OF FERDALE, WASHINGTON
AXTON ROAD INTERCEPTOR
SCHEDULE I

PUMP STATION 2
MECHANICAL SECTIONS


M7
8




MICROFILMED

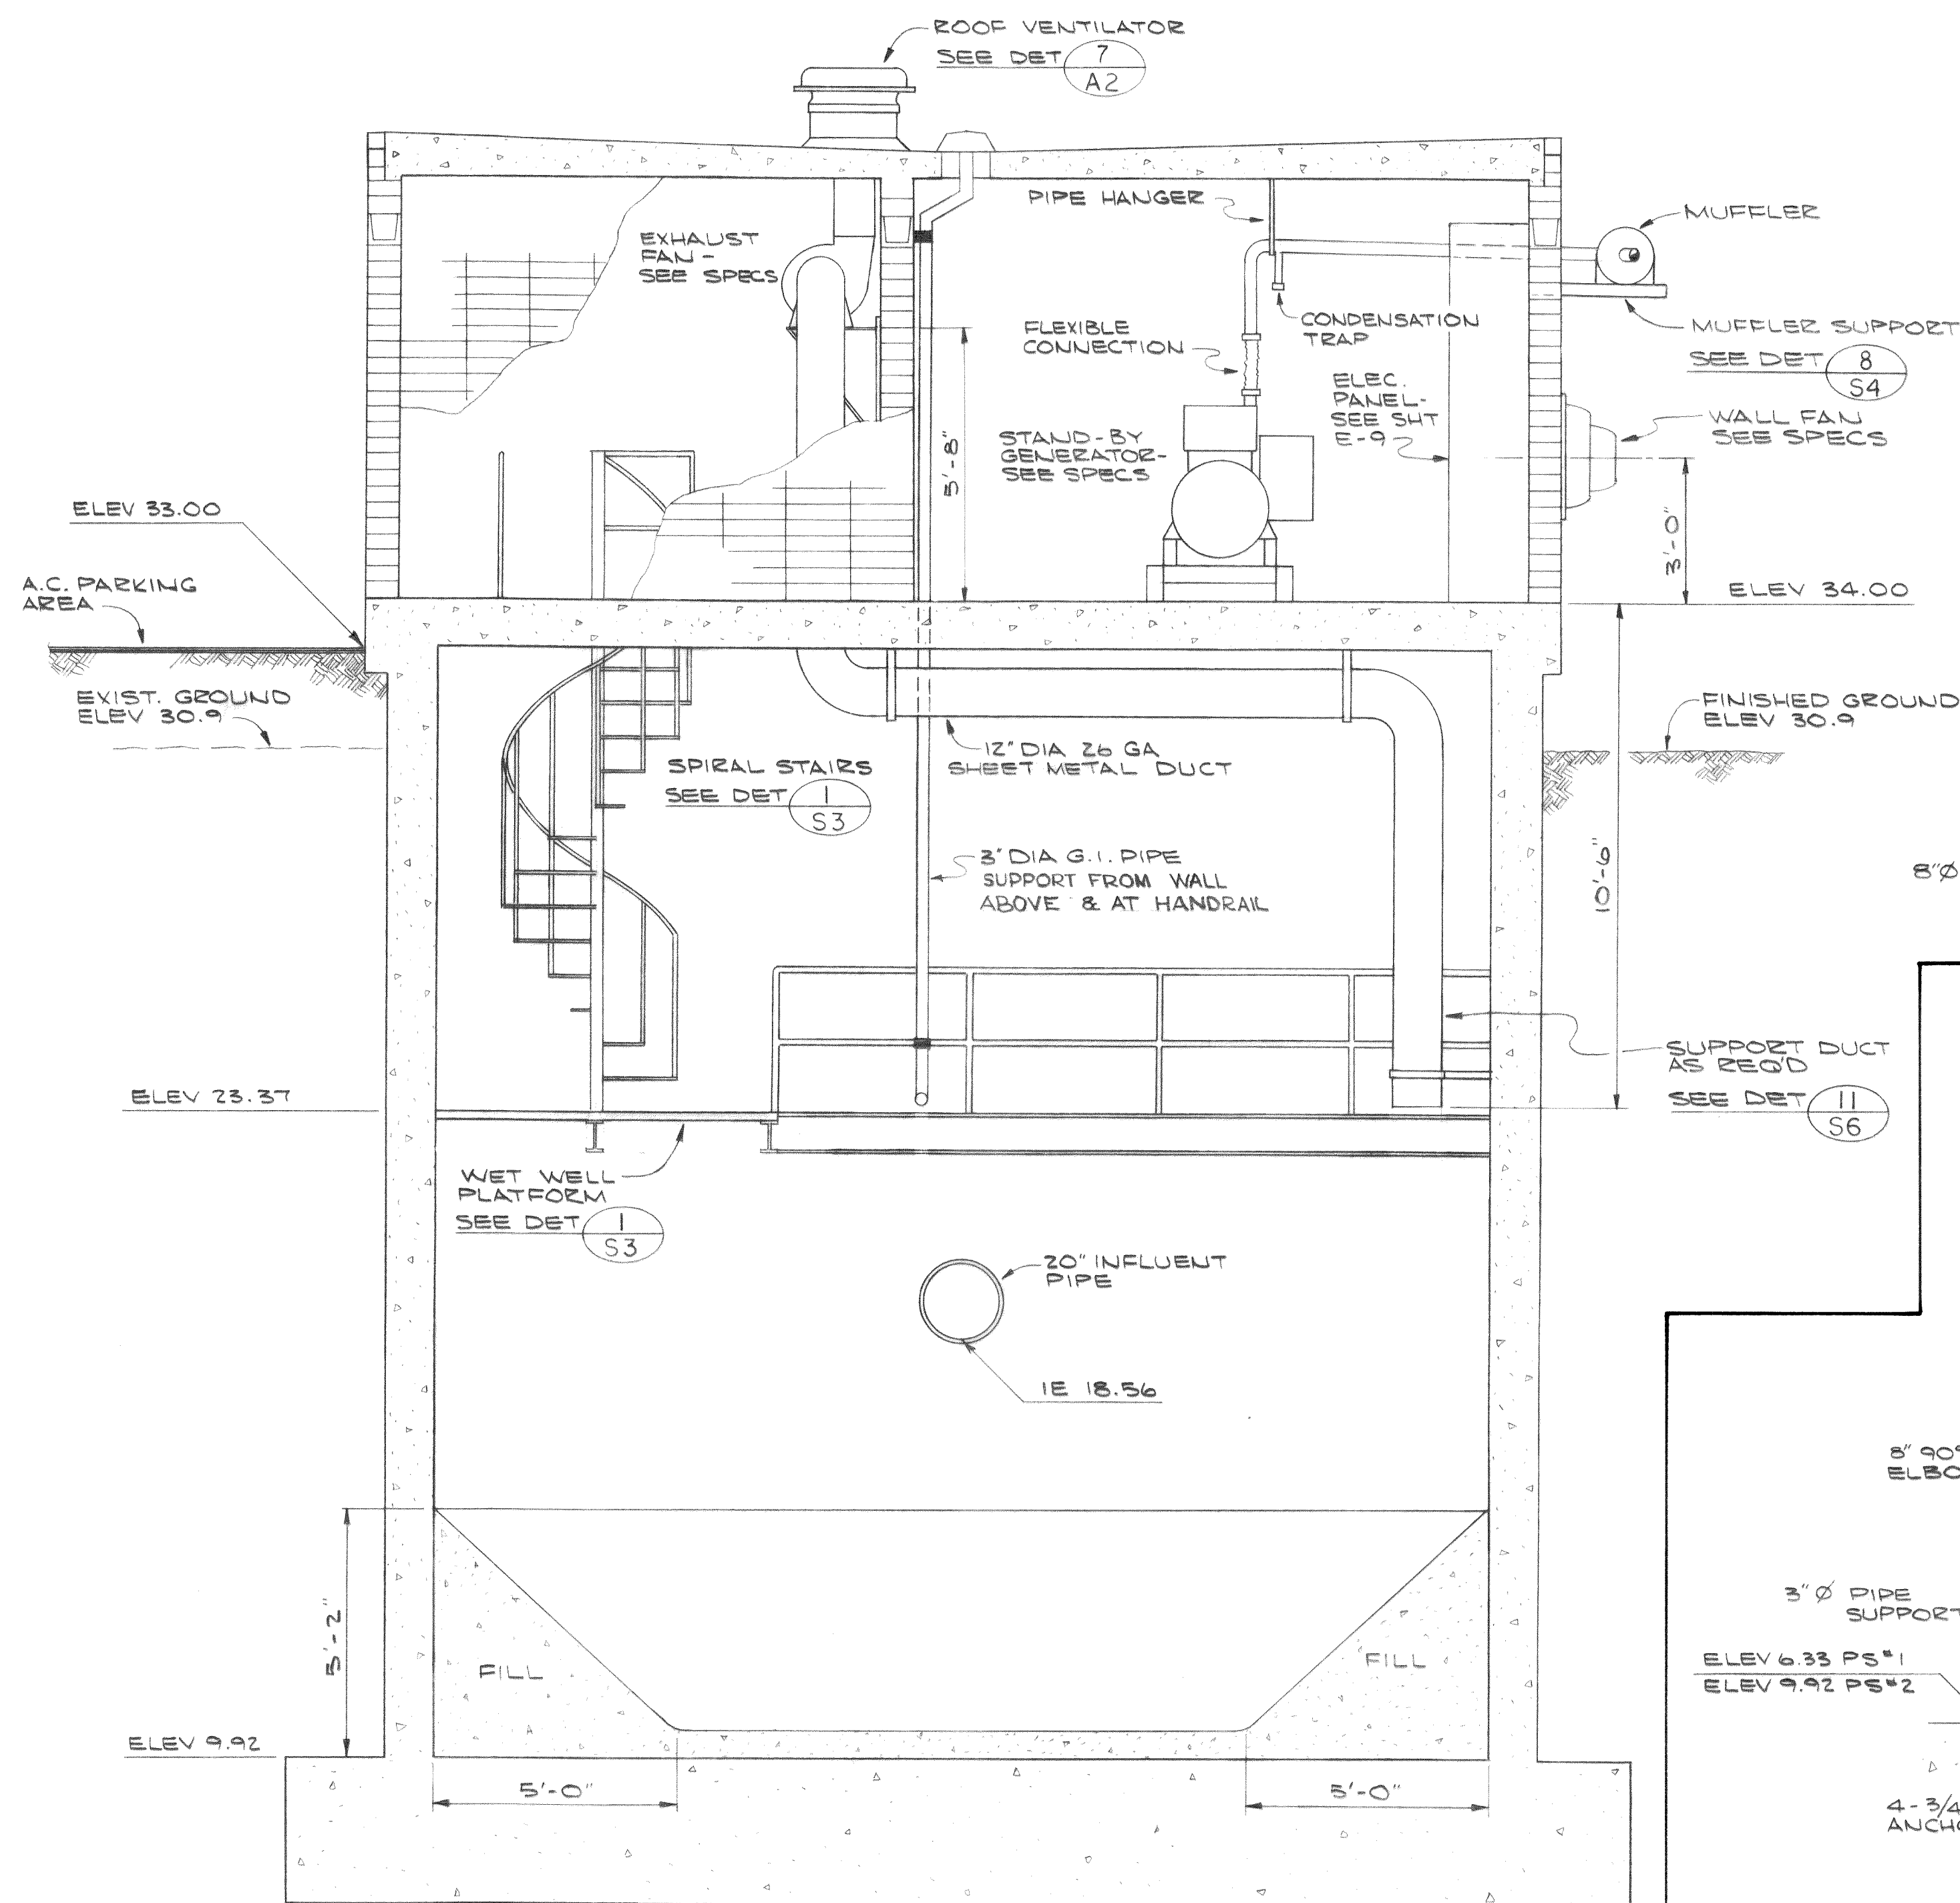



SECTION 1
SCALE: 3/8" = 1'-0"
M6

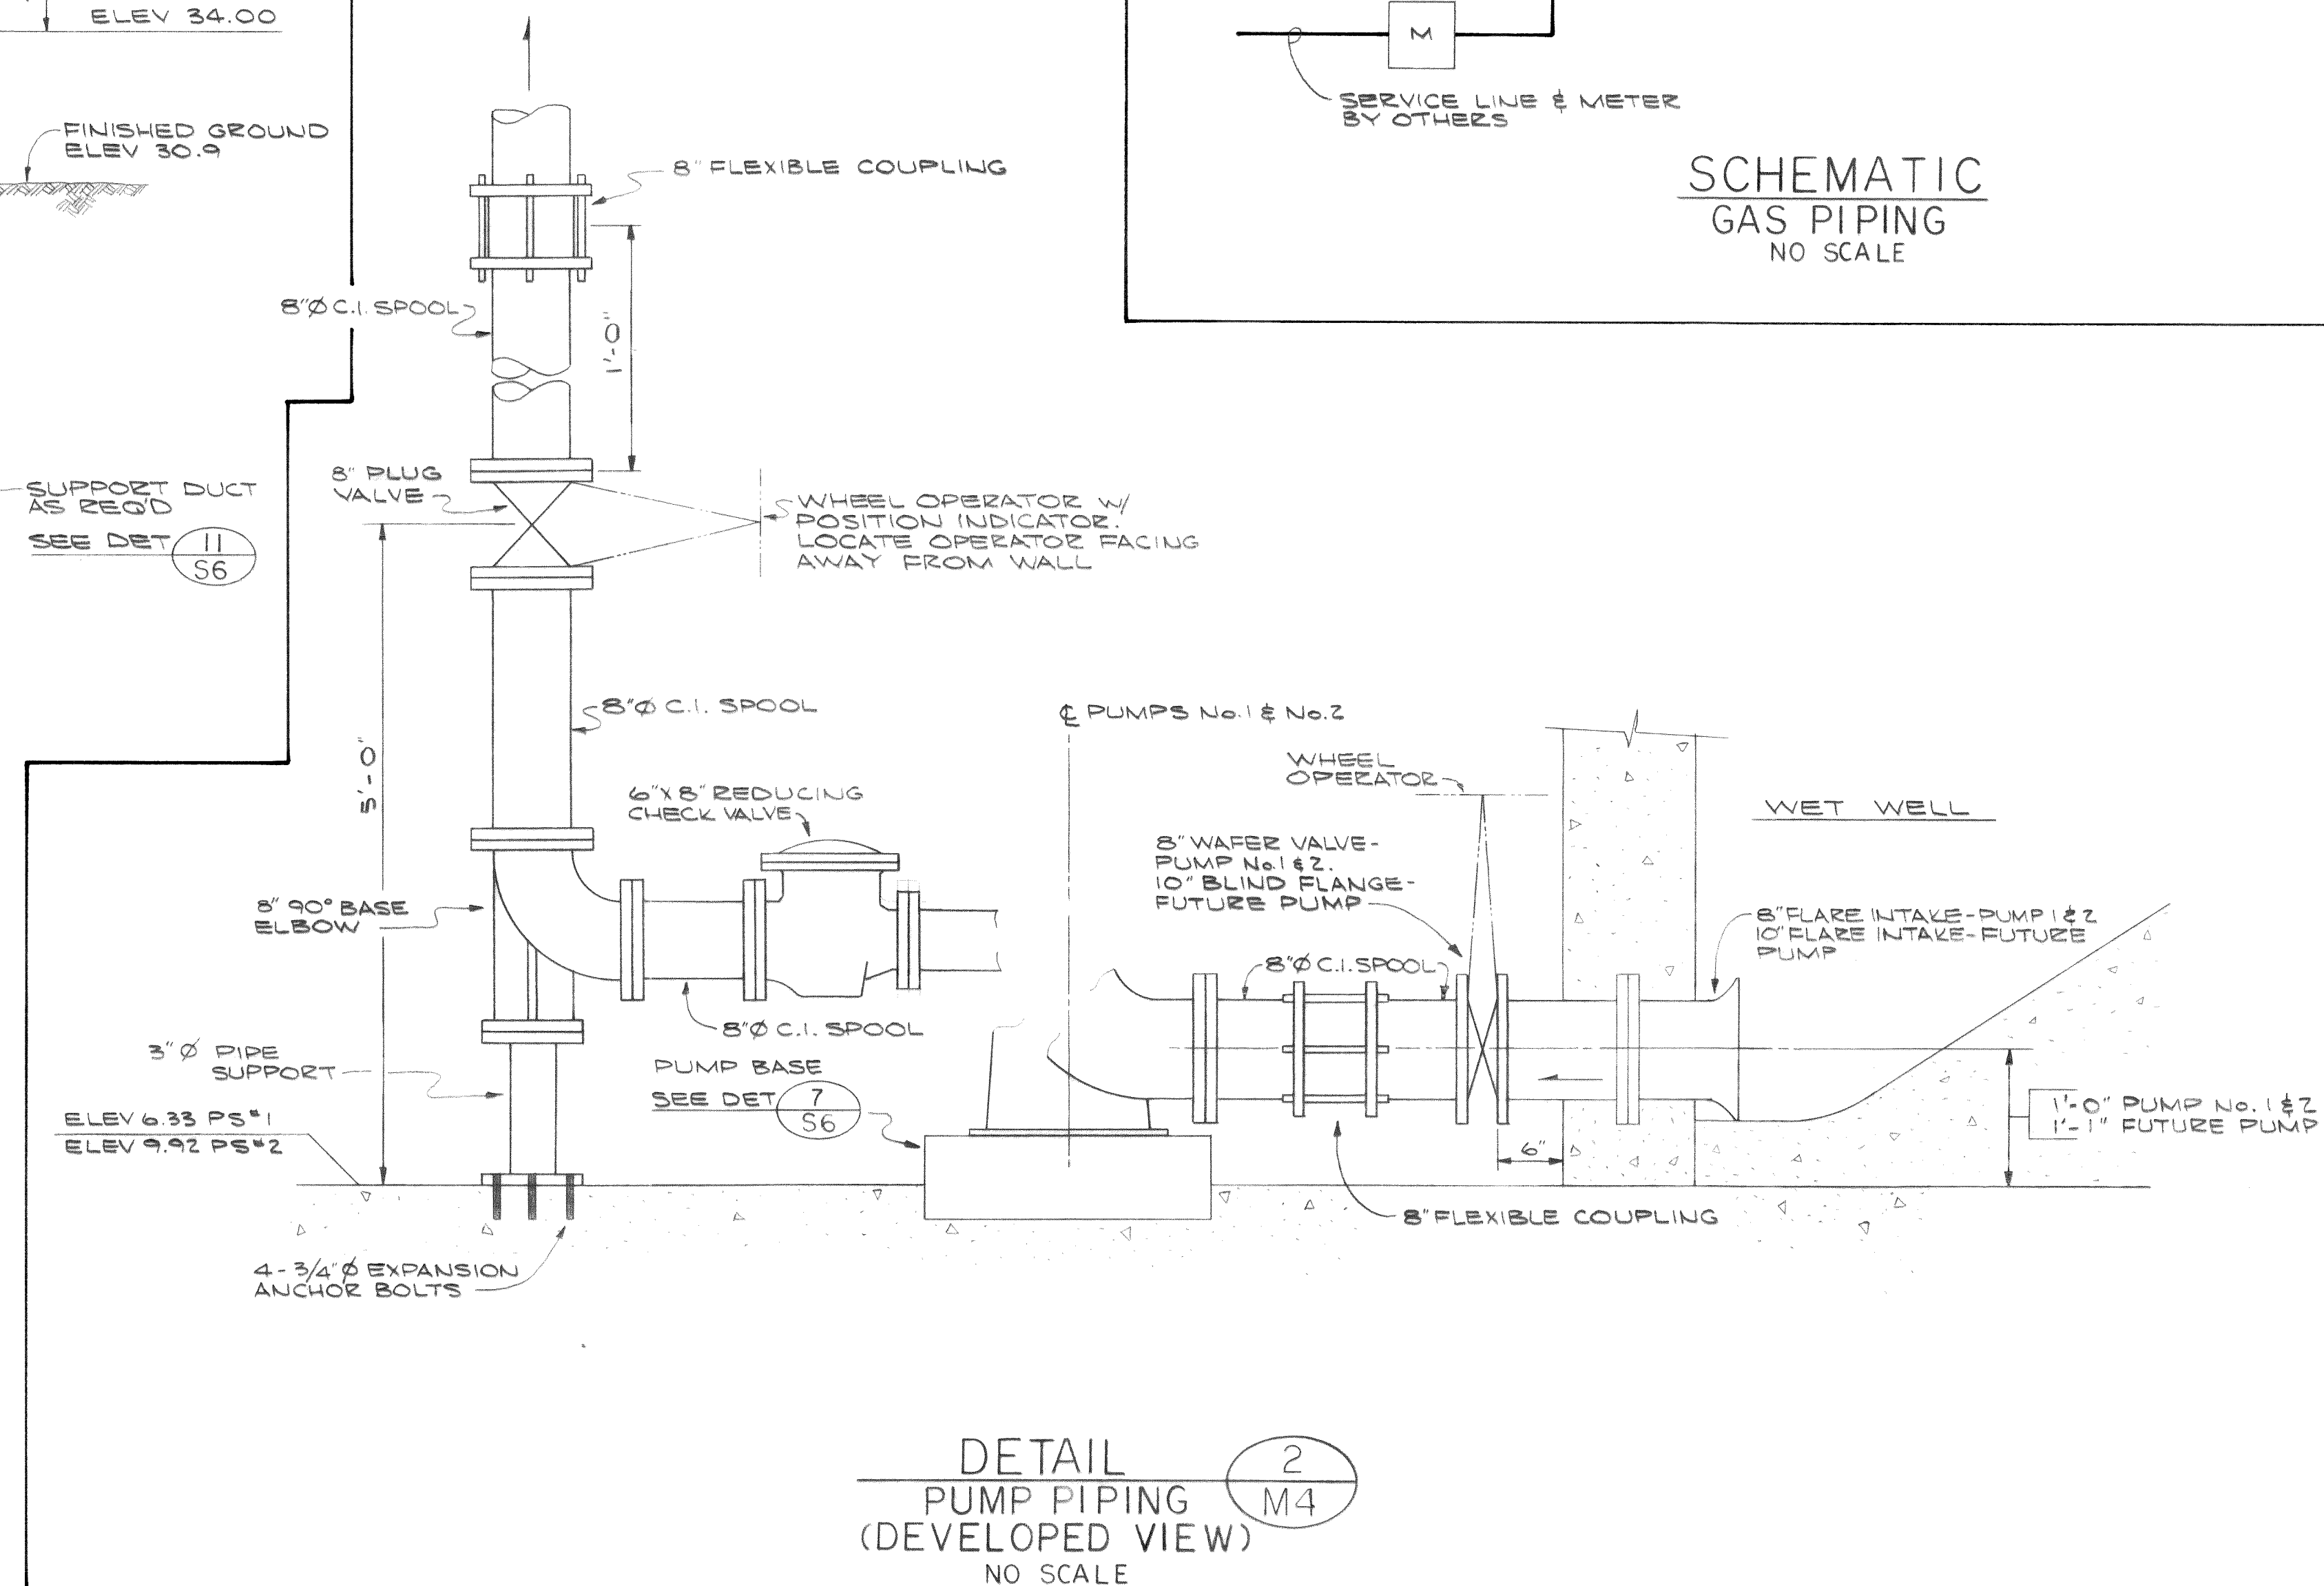

DETAIL 2
PUMP PIPING
(DEVELOPED VIEW)
NO SCALE
M4

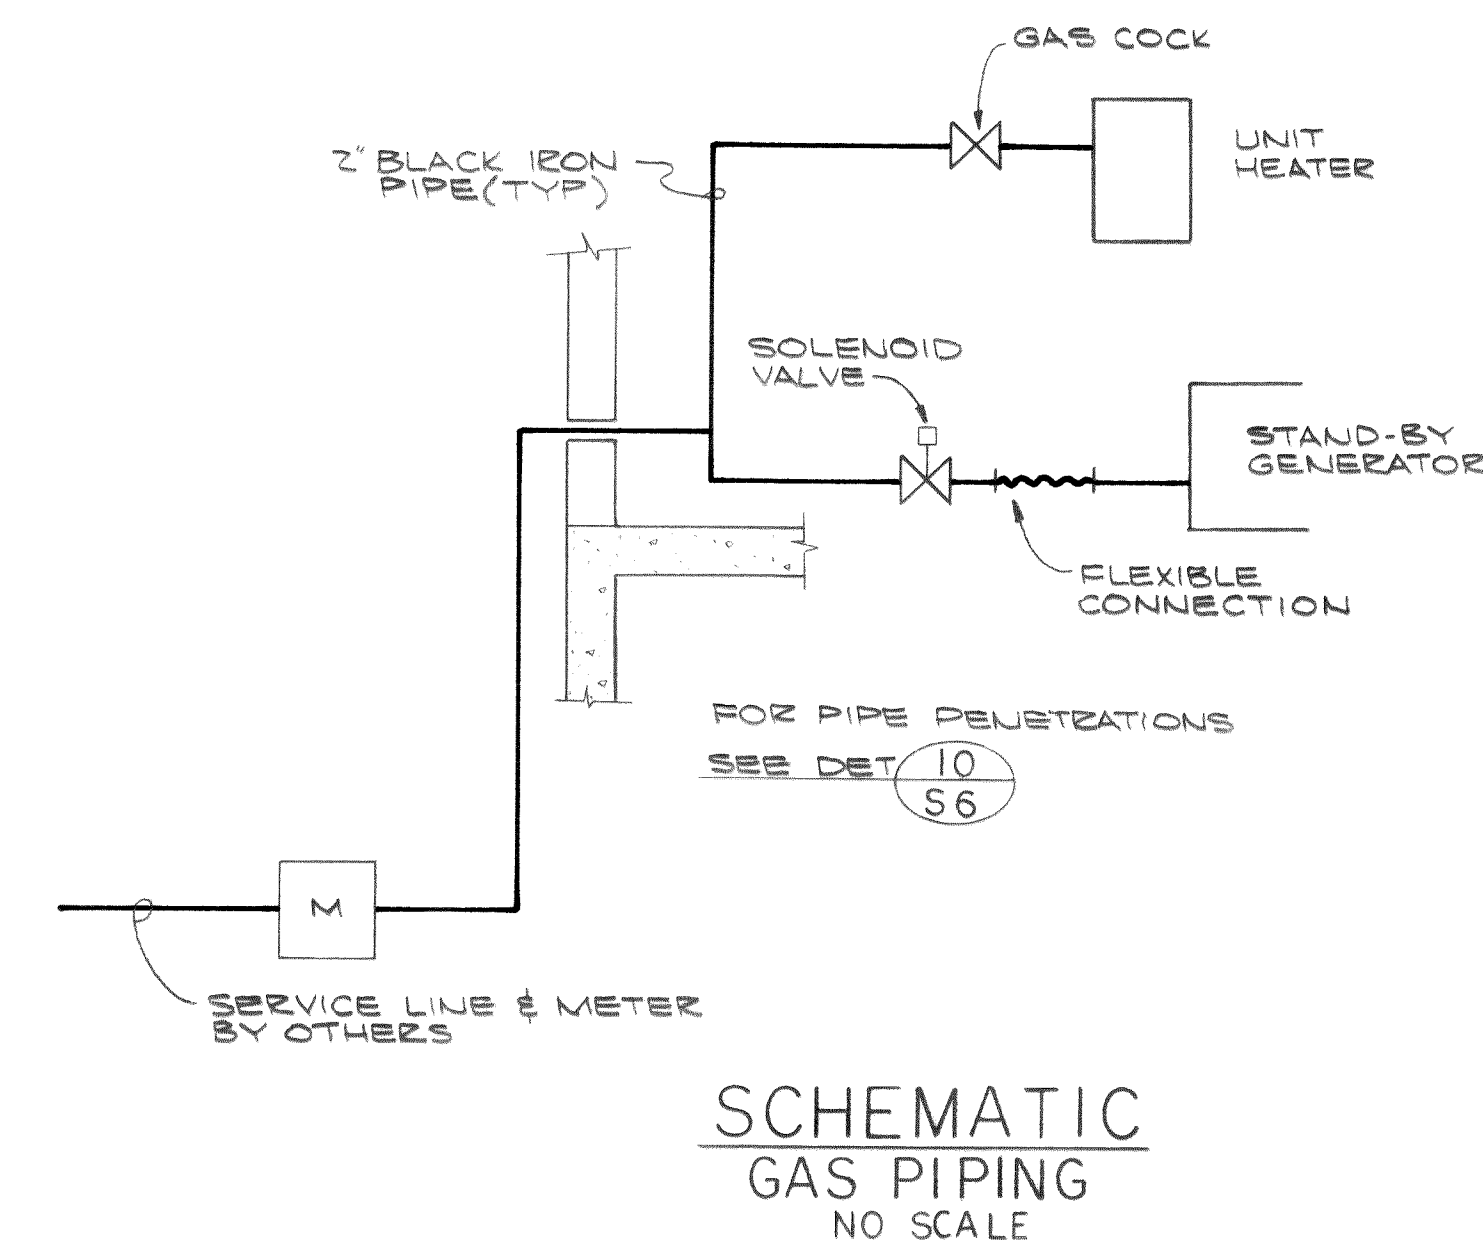

SCHEMATIC
GAS PIPING
NO SCALE

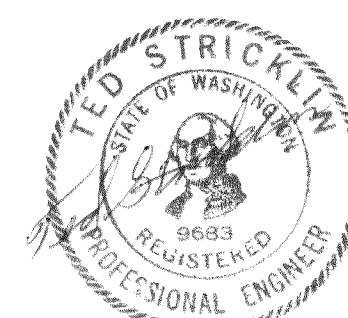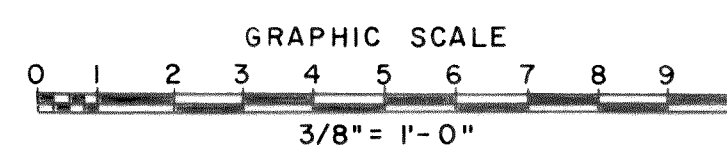

DESIGNED	T.S.	APPROVED	<i>Ted Stricklen</i>
DRAWN	J.M.H.	SCALE	AS SHOWN
DATE		DATE	JULY, 1972
NO.		FILE	71-S-425.002
REVISION		CHECKED	<i>AB</i>
BY			

ST Stevens, Thompson & Runyan, Inc.
Engineers/Planners
PORTLAND SEATTLE BOISE


TOWN OF FERNDAL, WASHINGTON
AXTON ROAD INTERCEPTOR
SCHEDULE I

PUMP STATION 2
MECHANICAL SECTIONS


M8
8

MICROFILMED


00210.022 2-7-06 KR

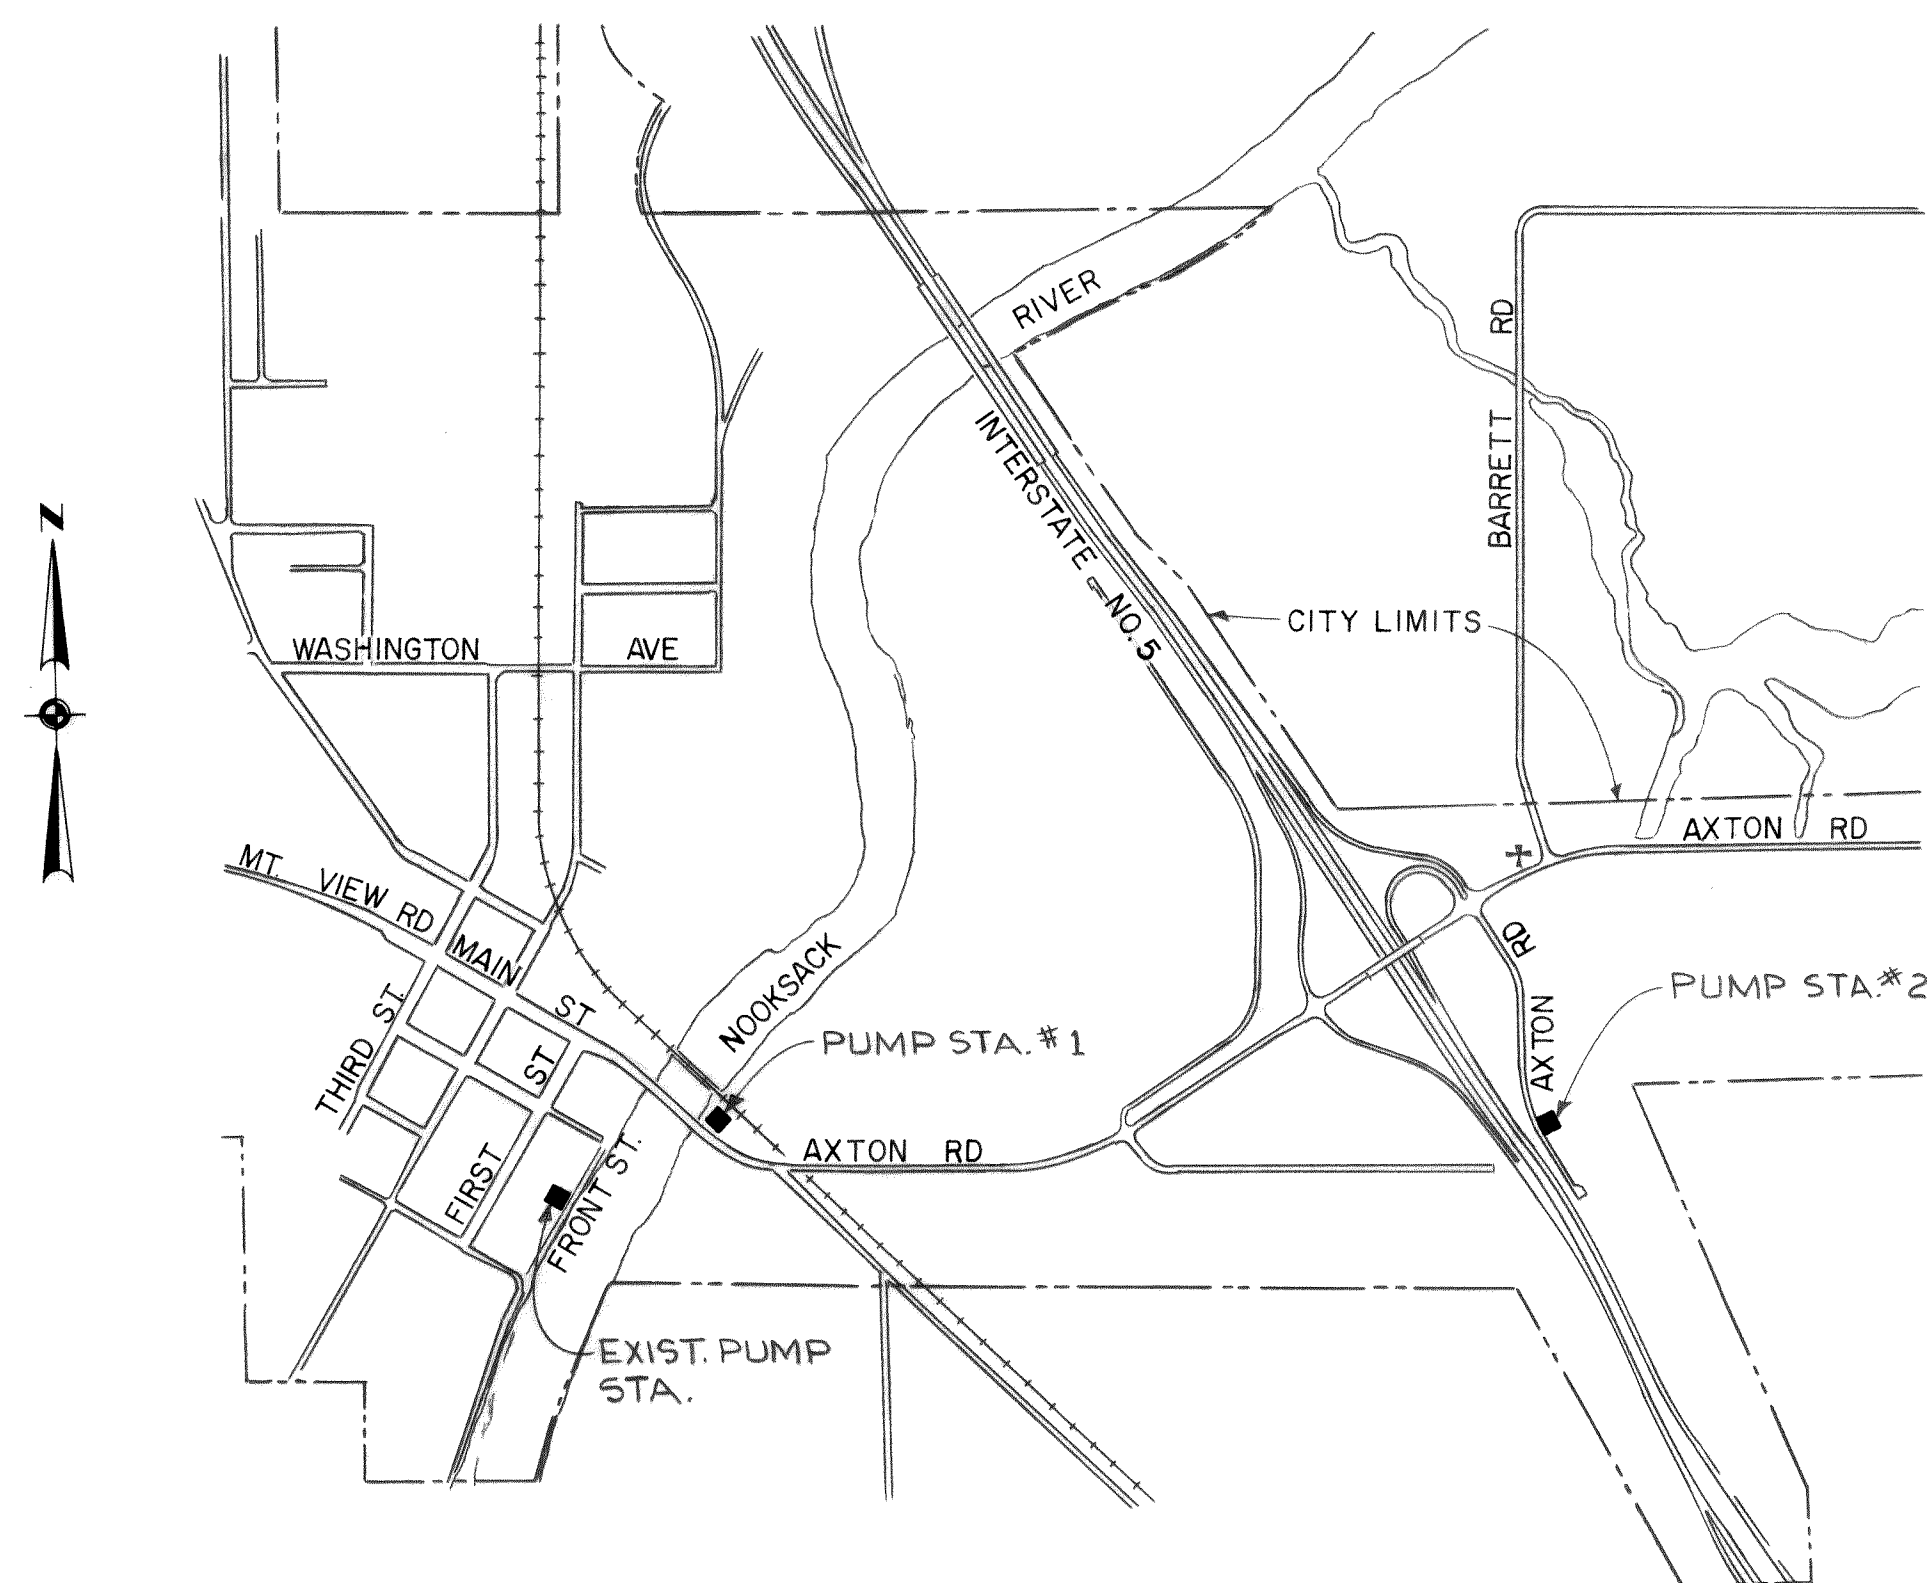


VICINITY MAP
800 400 0 800
GRAPHIC SCALE IN FEET

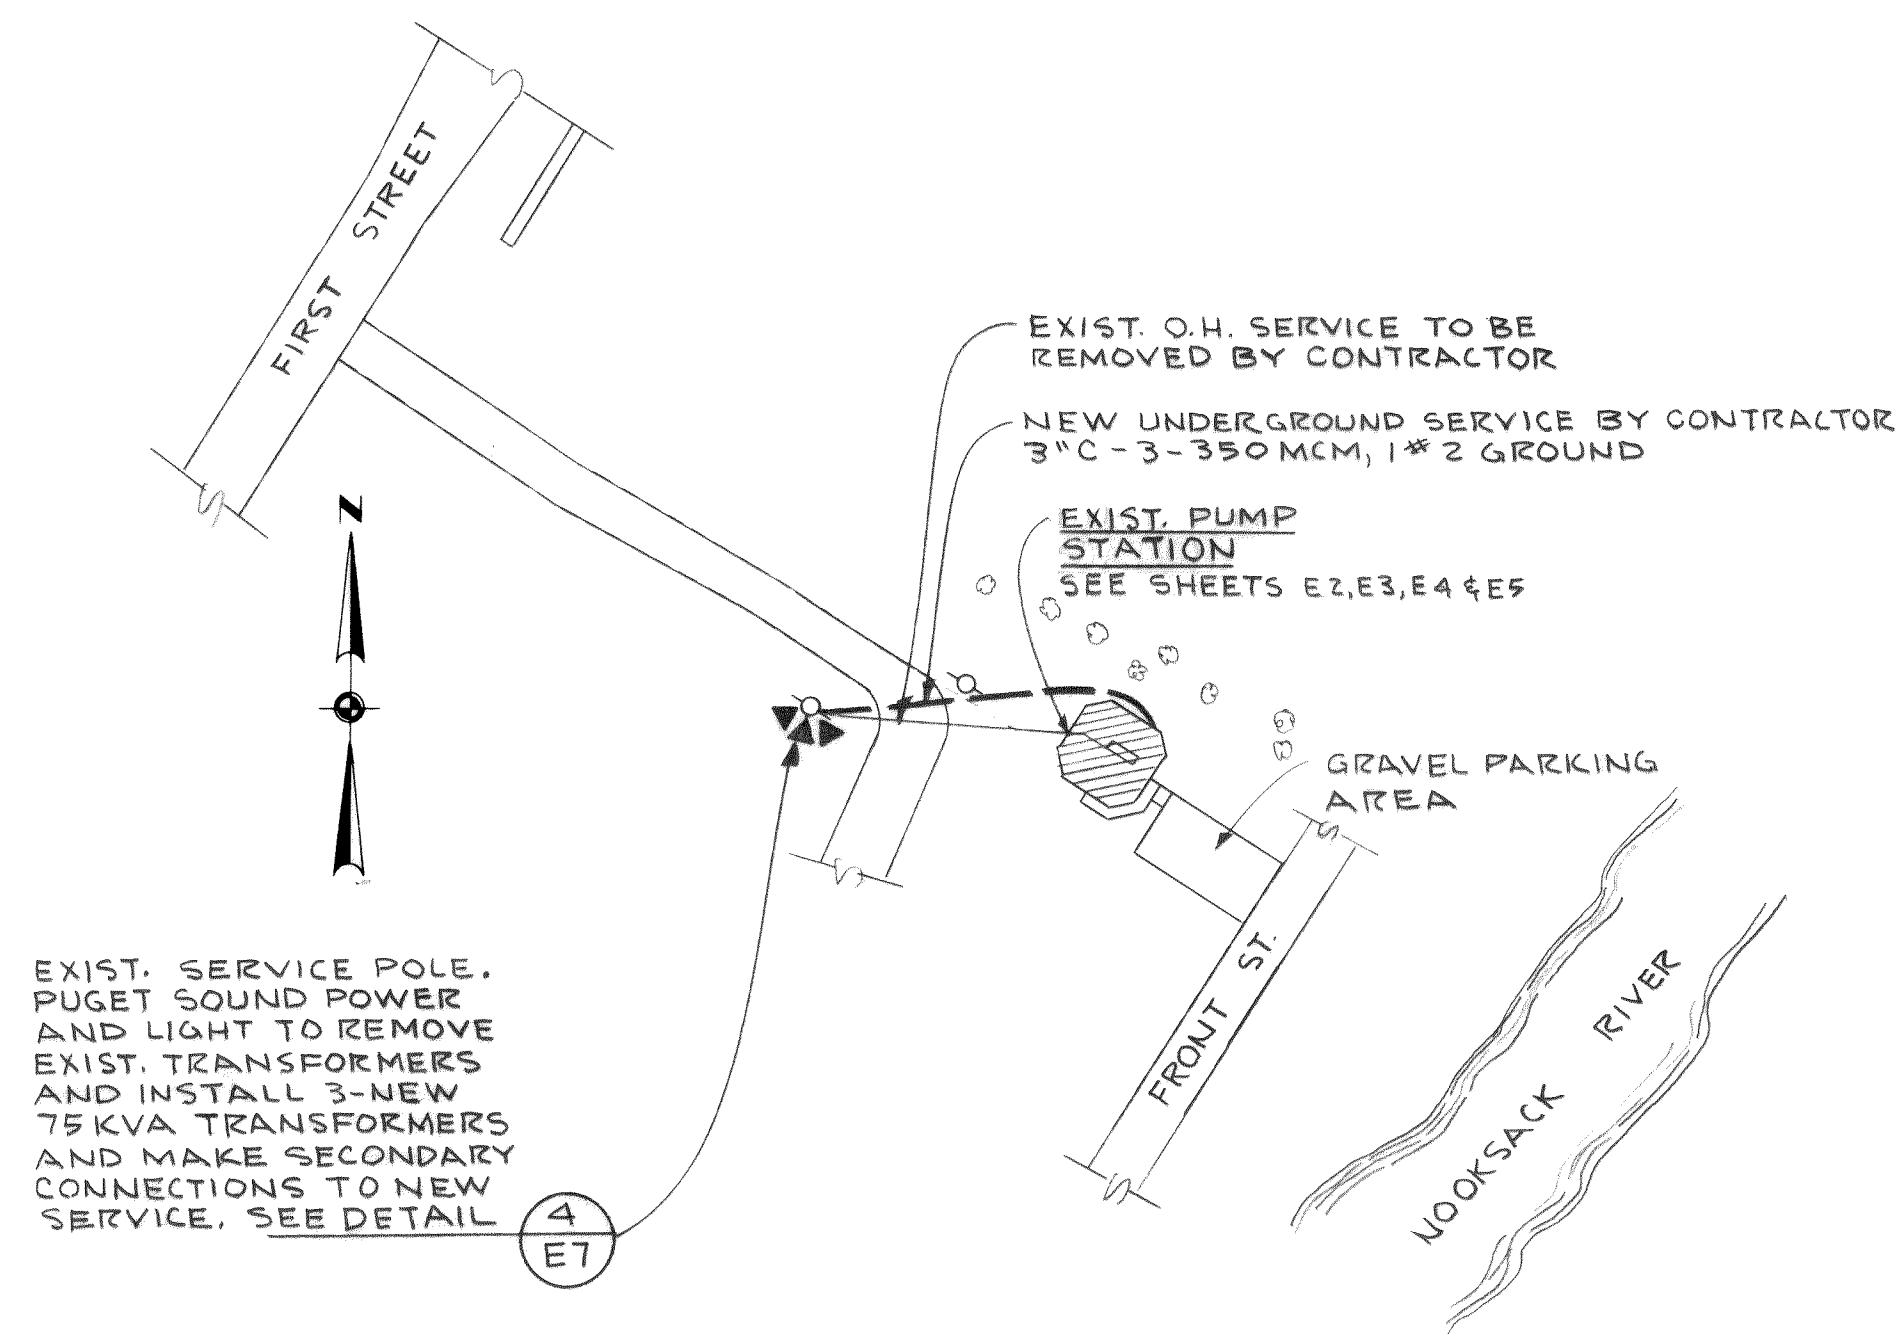

SITE PLAN - EXIST. PUMP STATION
SCALE 1" = 50'

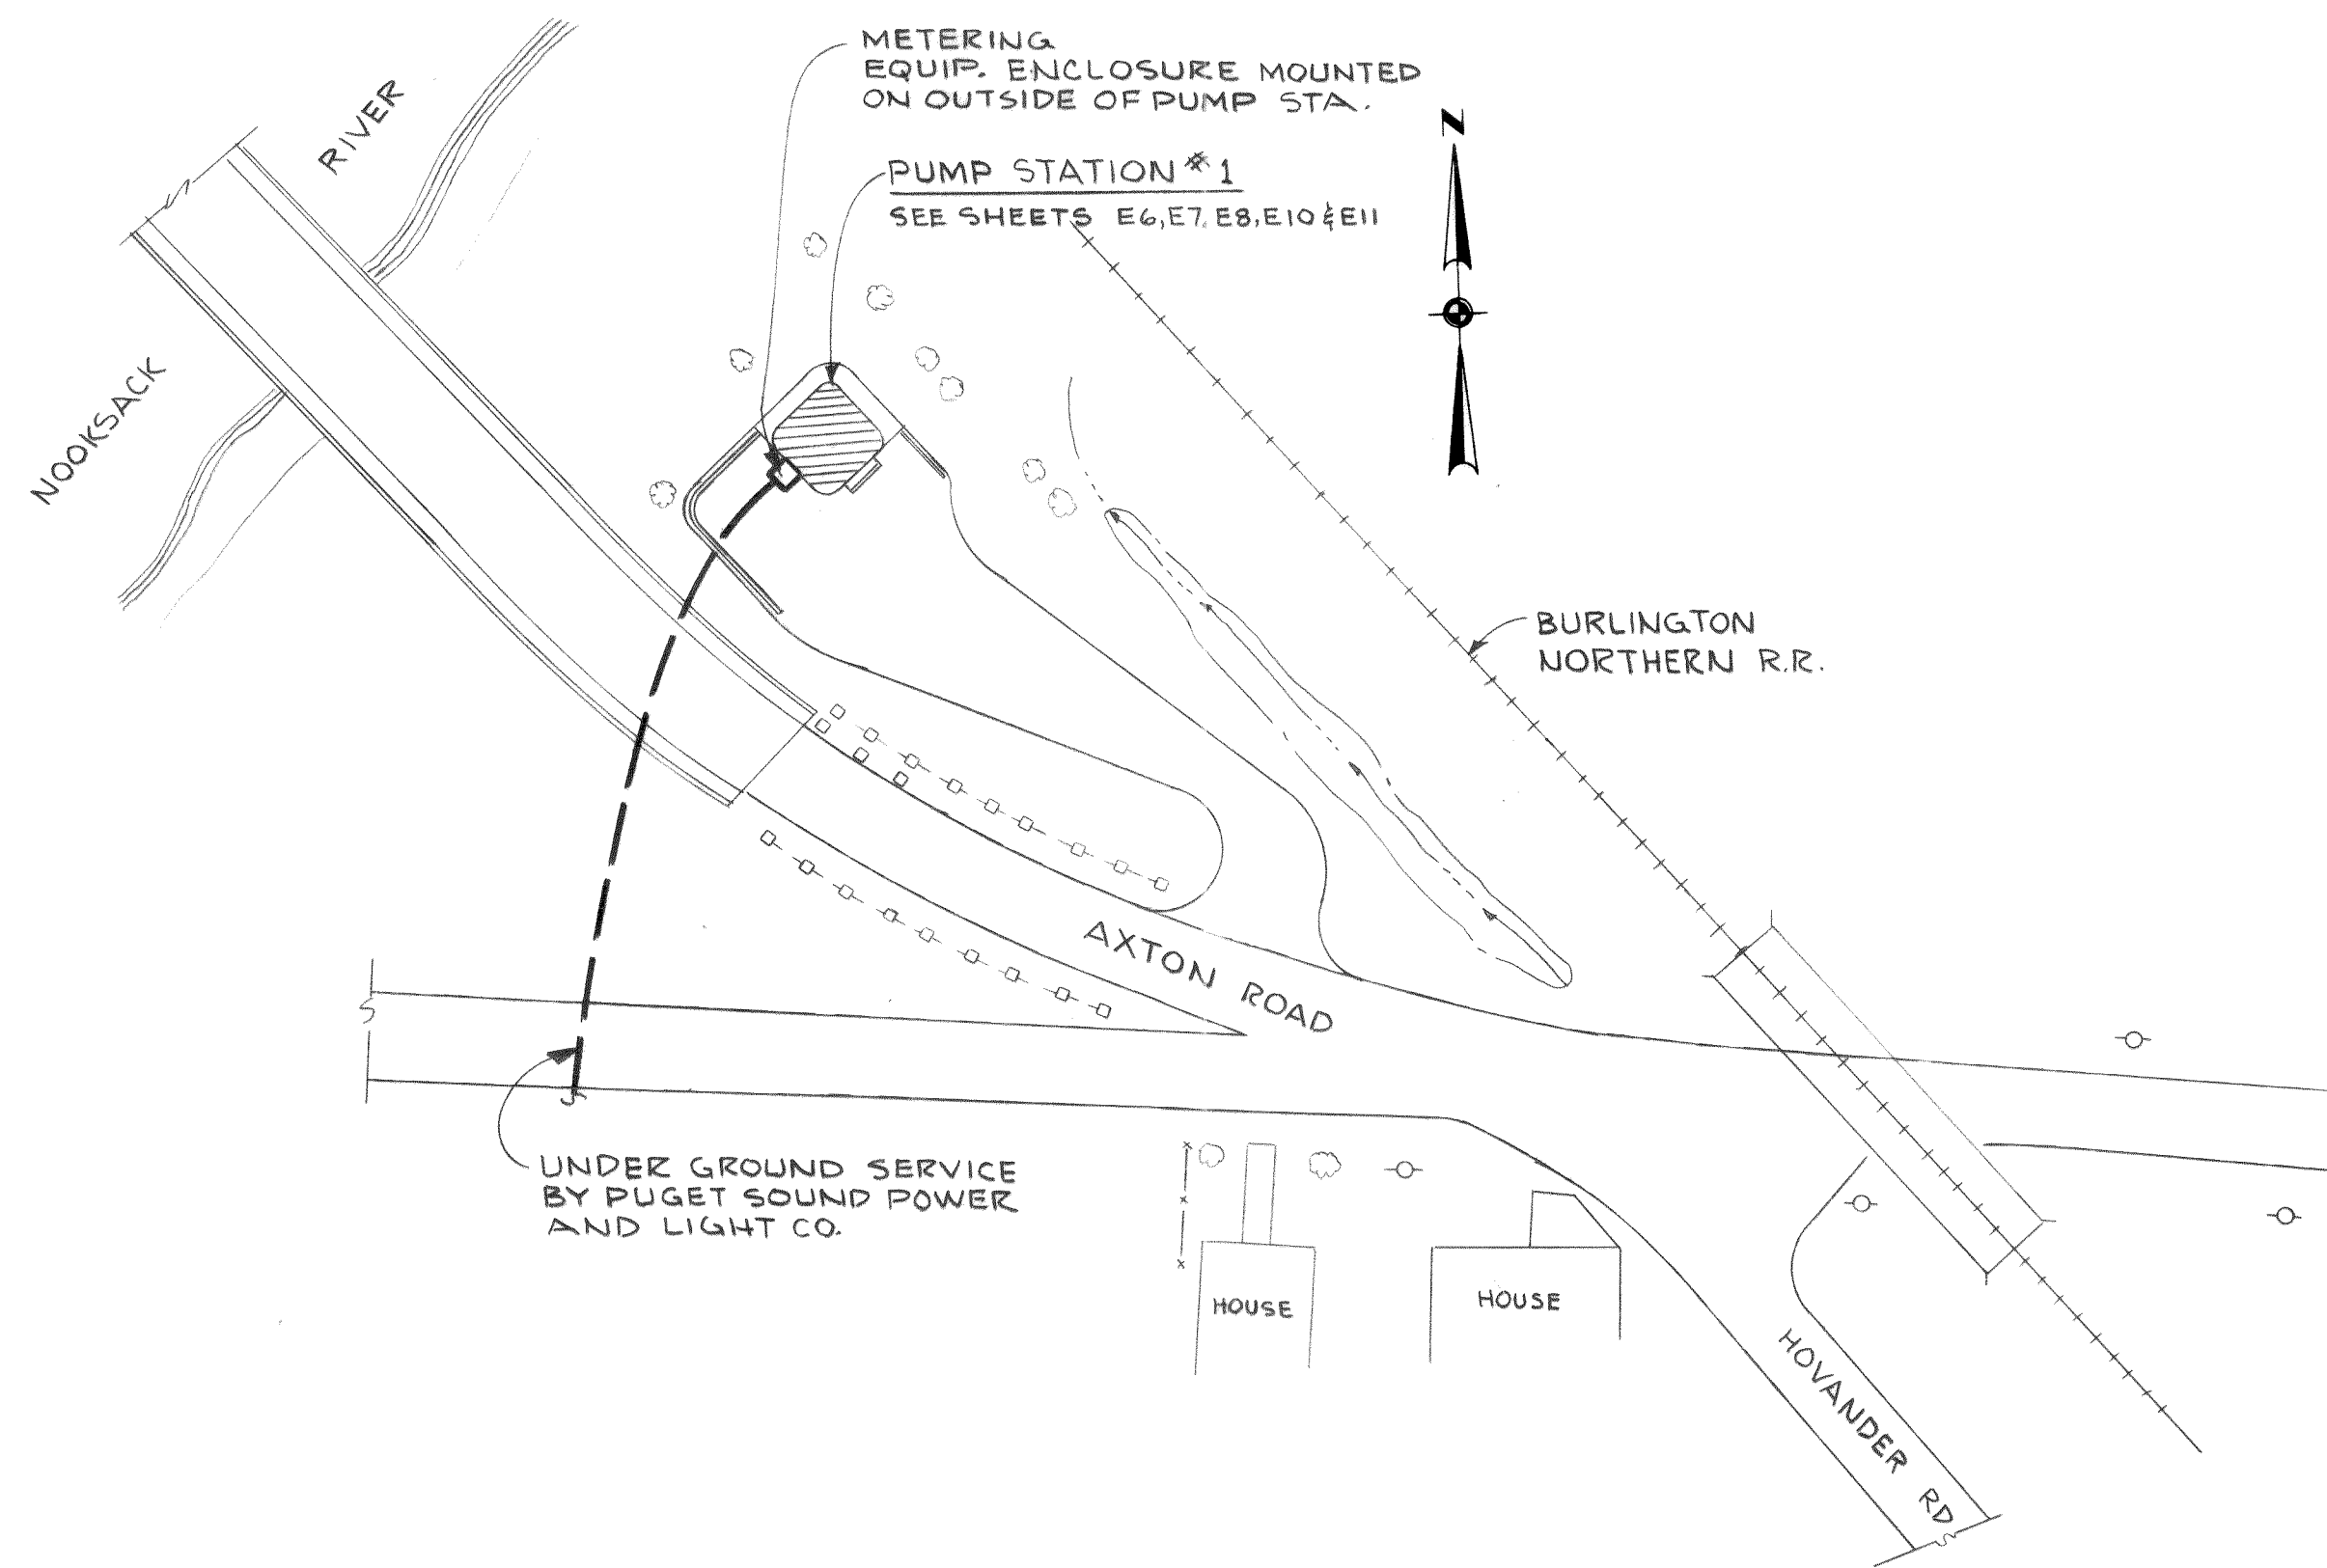

SITE PLAN - PUMP STATION #1
SCALE 1" = 50'

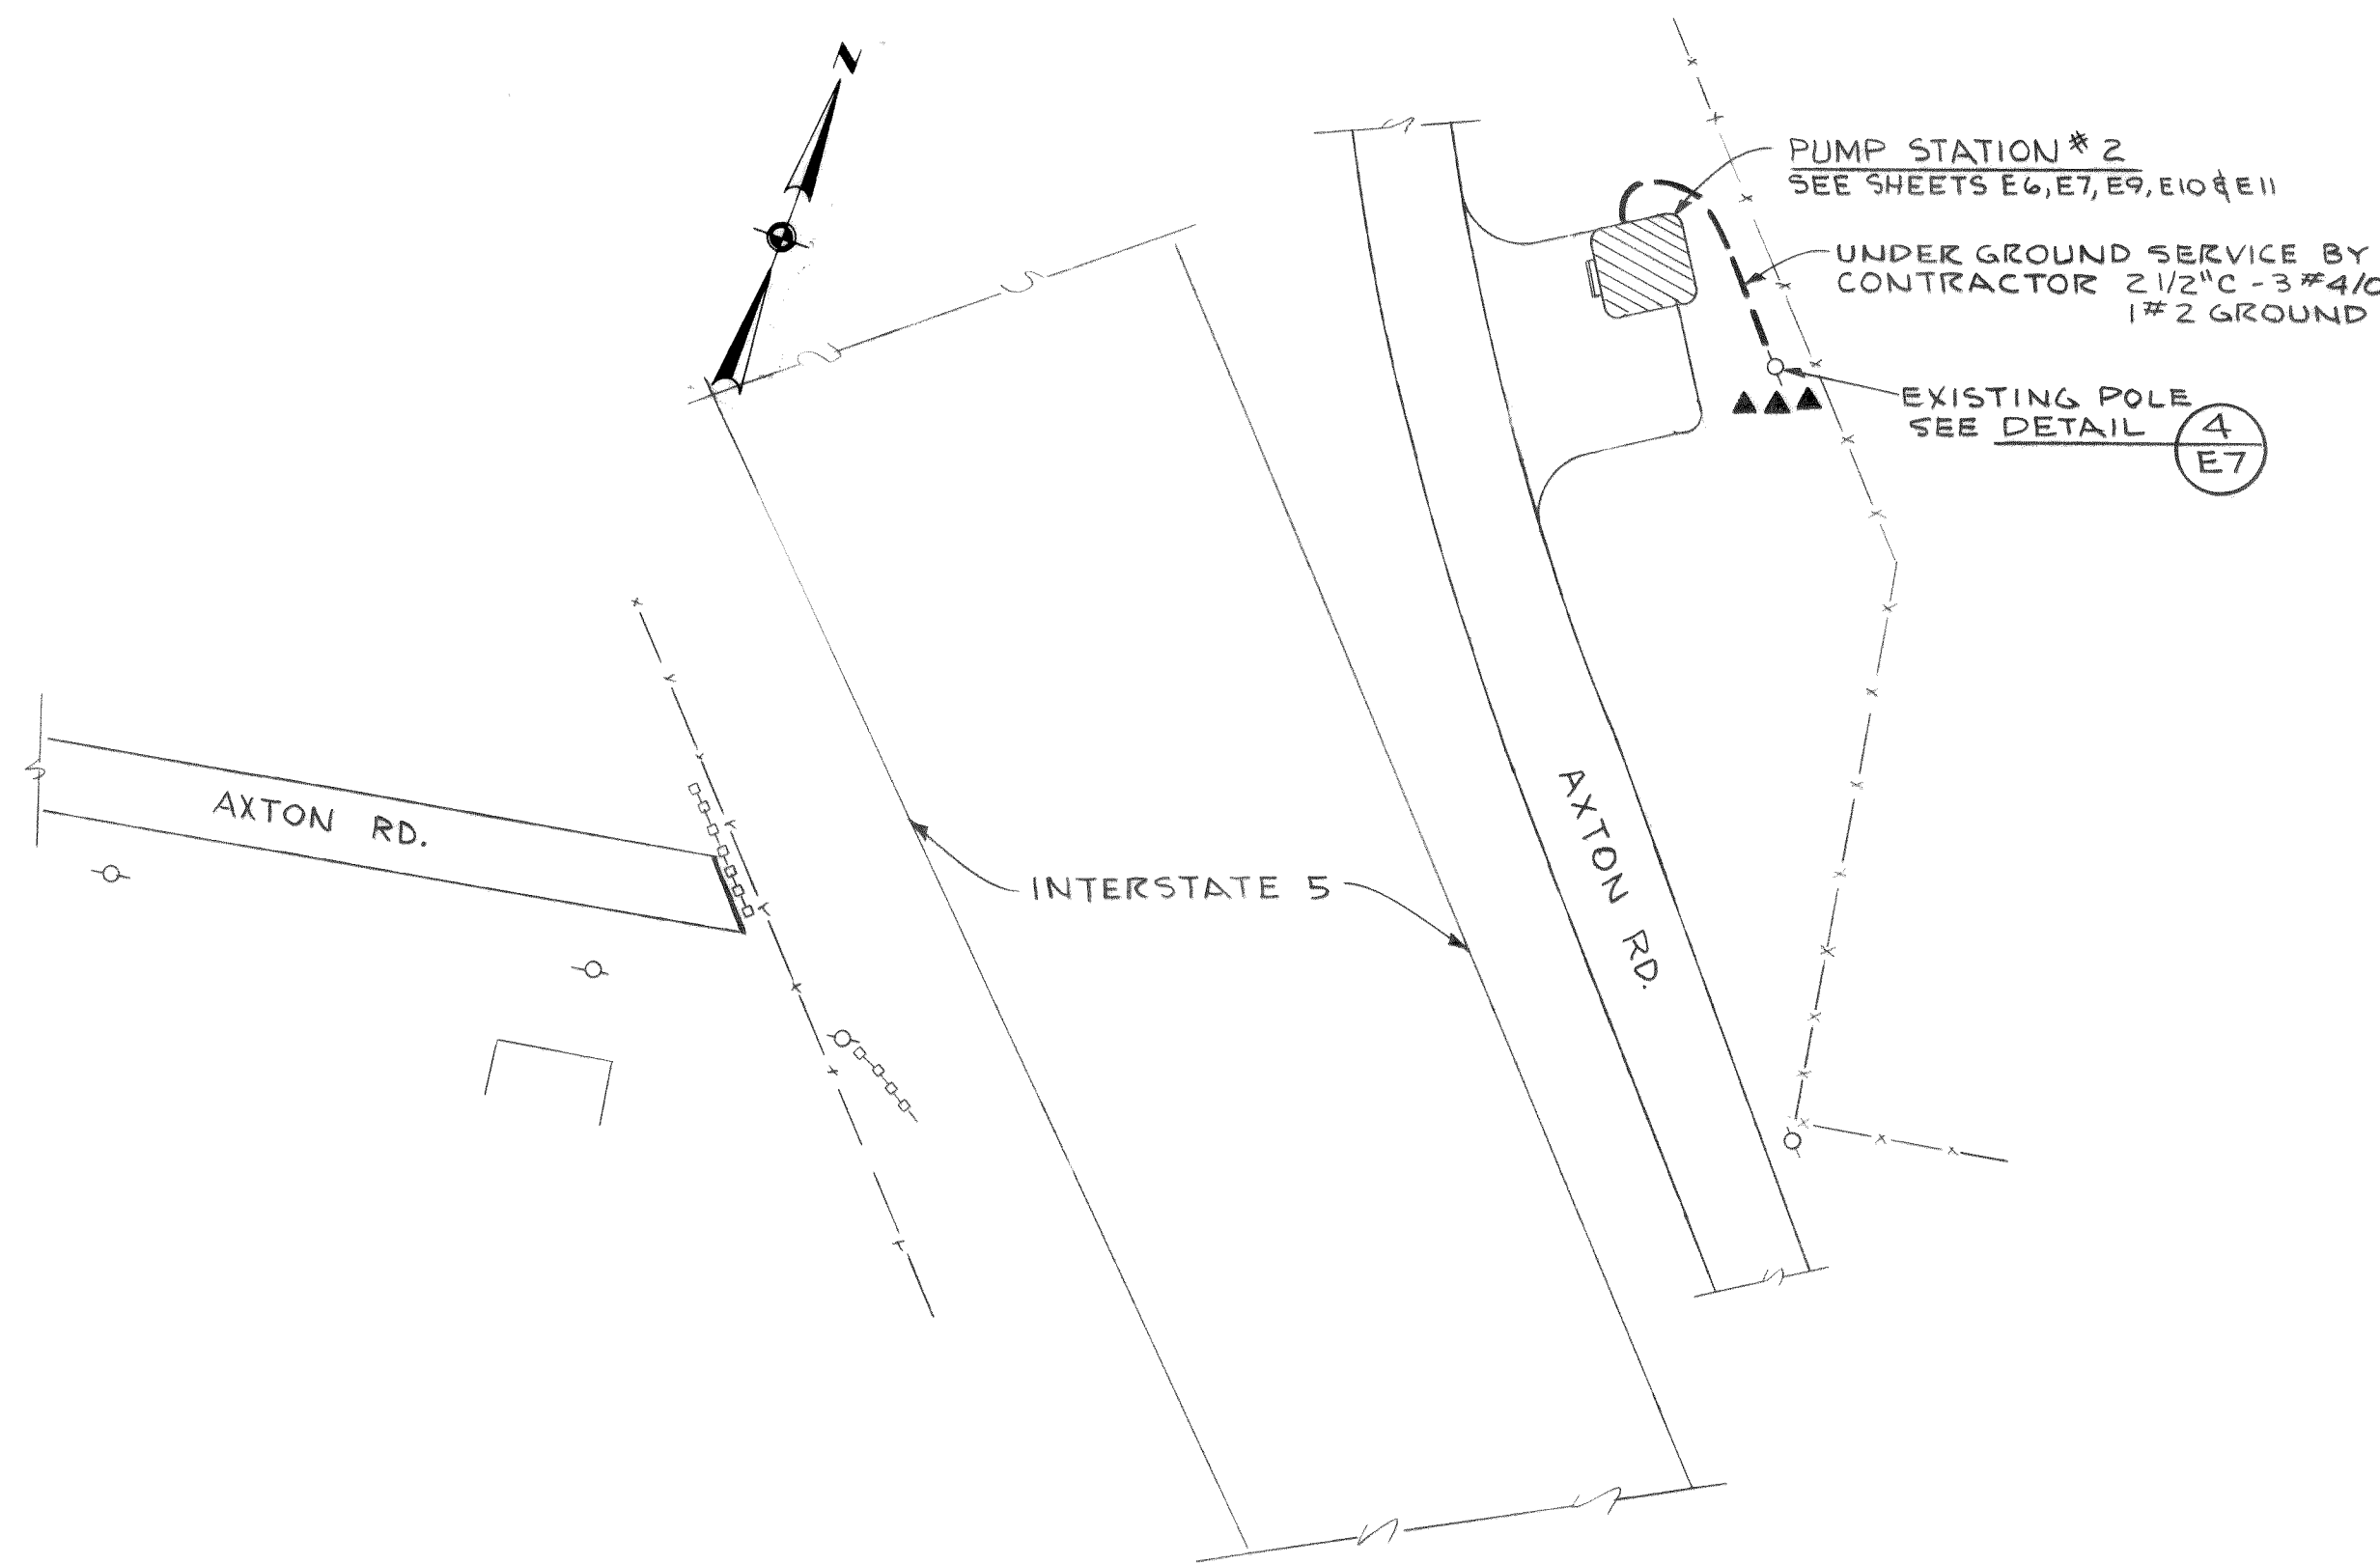

SITE PLAN - PUMP STATION #2
SCALE 1" = 50'

- LEGEND**
- ② CEILING OR PENDANT FIXTURE OUTLET
 - ③ WALL FIXTURE OUTLET
 - ① FLUORESCENT FIXTURE OUTLET
 - ⊕ DUPLEX 15A-125A-2P-3W RECEPT.
 - ⊙ GROUND ROD
 - S SINGLE POLE SWITCH
 - ⓐ JUNCTION BOX, WALL OR CEILING, 4" OCTAGON UNLESS NOTED.
 - LIGHTING AND APPLIANCE PANEL BOARD
 - BRANCH CIRCUIT OR FEEDER EXPOSED W/GENERAL ROUTE INDICATED.
 - - - BRANCH CIRCUIT OR FEEDER IN OR UNDER FLOOR
 - - - BRANCH CIRCUIT OR FEEDER IN WALL OR CEILING
 - /// 8-2,4,6 HOME RUN TO PANEL, W/PANEL LETTER & CIRCUIT NUMBER INDICATED. CROSSBARS DENOTES NO. OF CONDUCTORS NO CROSSBARS INDICATE 2 CONDUCTORS
 - ||||| FLEXIBLE CONDUIT
 - CONDUIT SEAL
 - CONDUIT DOWN
 - CONDUIT UP
 - STO MANUAL MOTOR STARTER WITH THERMAL OVERLOAD.
 - Ⓢ SELECTOR SWITCH
 - ⓈV SOLENOID VALVE
 - ⓐ THERMOSTAT
 - ◀ TELEPHONE OUTLET
 - Ⓜ MOTOR, HP INDICATED
 - ★ SPECIALIZED LEGEND FOR MODIFICATIONS TO EXISTING PUMP STATION IS LOCATED ON THE SHEETS DEPICTING THE WORK.
 - ⊙ TRANSFORMERS MOUNTED ON POLE
- SUBSCRIPT - ADDED TO ANY SYMBOL DENOTES:
EX - EXPLOSION PROOF, CLASS & GROUP AS NOTED
WP - WEATHERPROOF, NEMA 4 OR EQUIV.
+48 - MOUNTING HEIGHT IN INCHES ABOVE FLOOR.
P - PILOT LIGHT

				DESIGNED R.J.C.	APPROVED <i>Rich Runyan</i>
				DRAWN J.M.	SCALE AS SHOWN DATE JULY, 1972
DATE	NO.	REVISION	BY	CHECKED <i>U6</i>	FILE 71-S-425.002



Stevens, Thompson & Runyan, Inc.
Engineers/Planners
PORTLAND SEATTLE BOISE


TOWN OF FERDALE, WASHINGTON
AXTON ROAD INTERCEPTOR
SCHEDULE I

VICINITY MAP AND SITE PLAN
ELECTRICAL

E 1
II

MICROFILMED

00210.024 2-7-66 R.R.

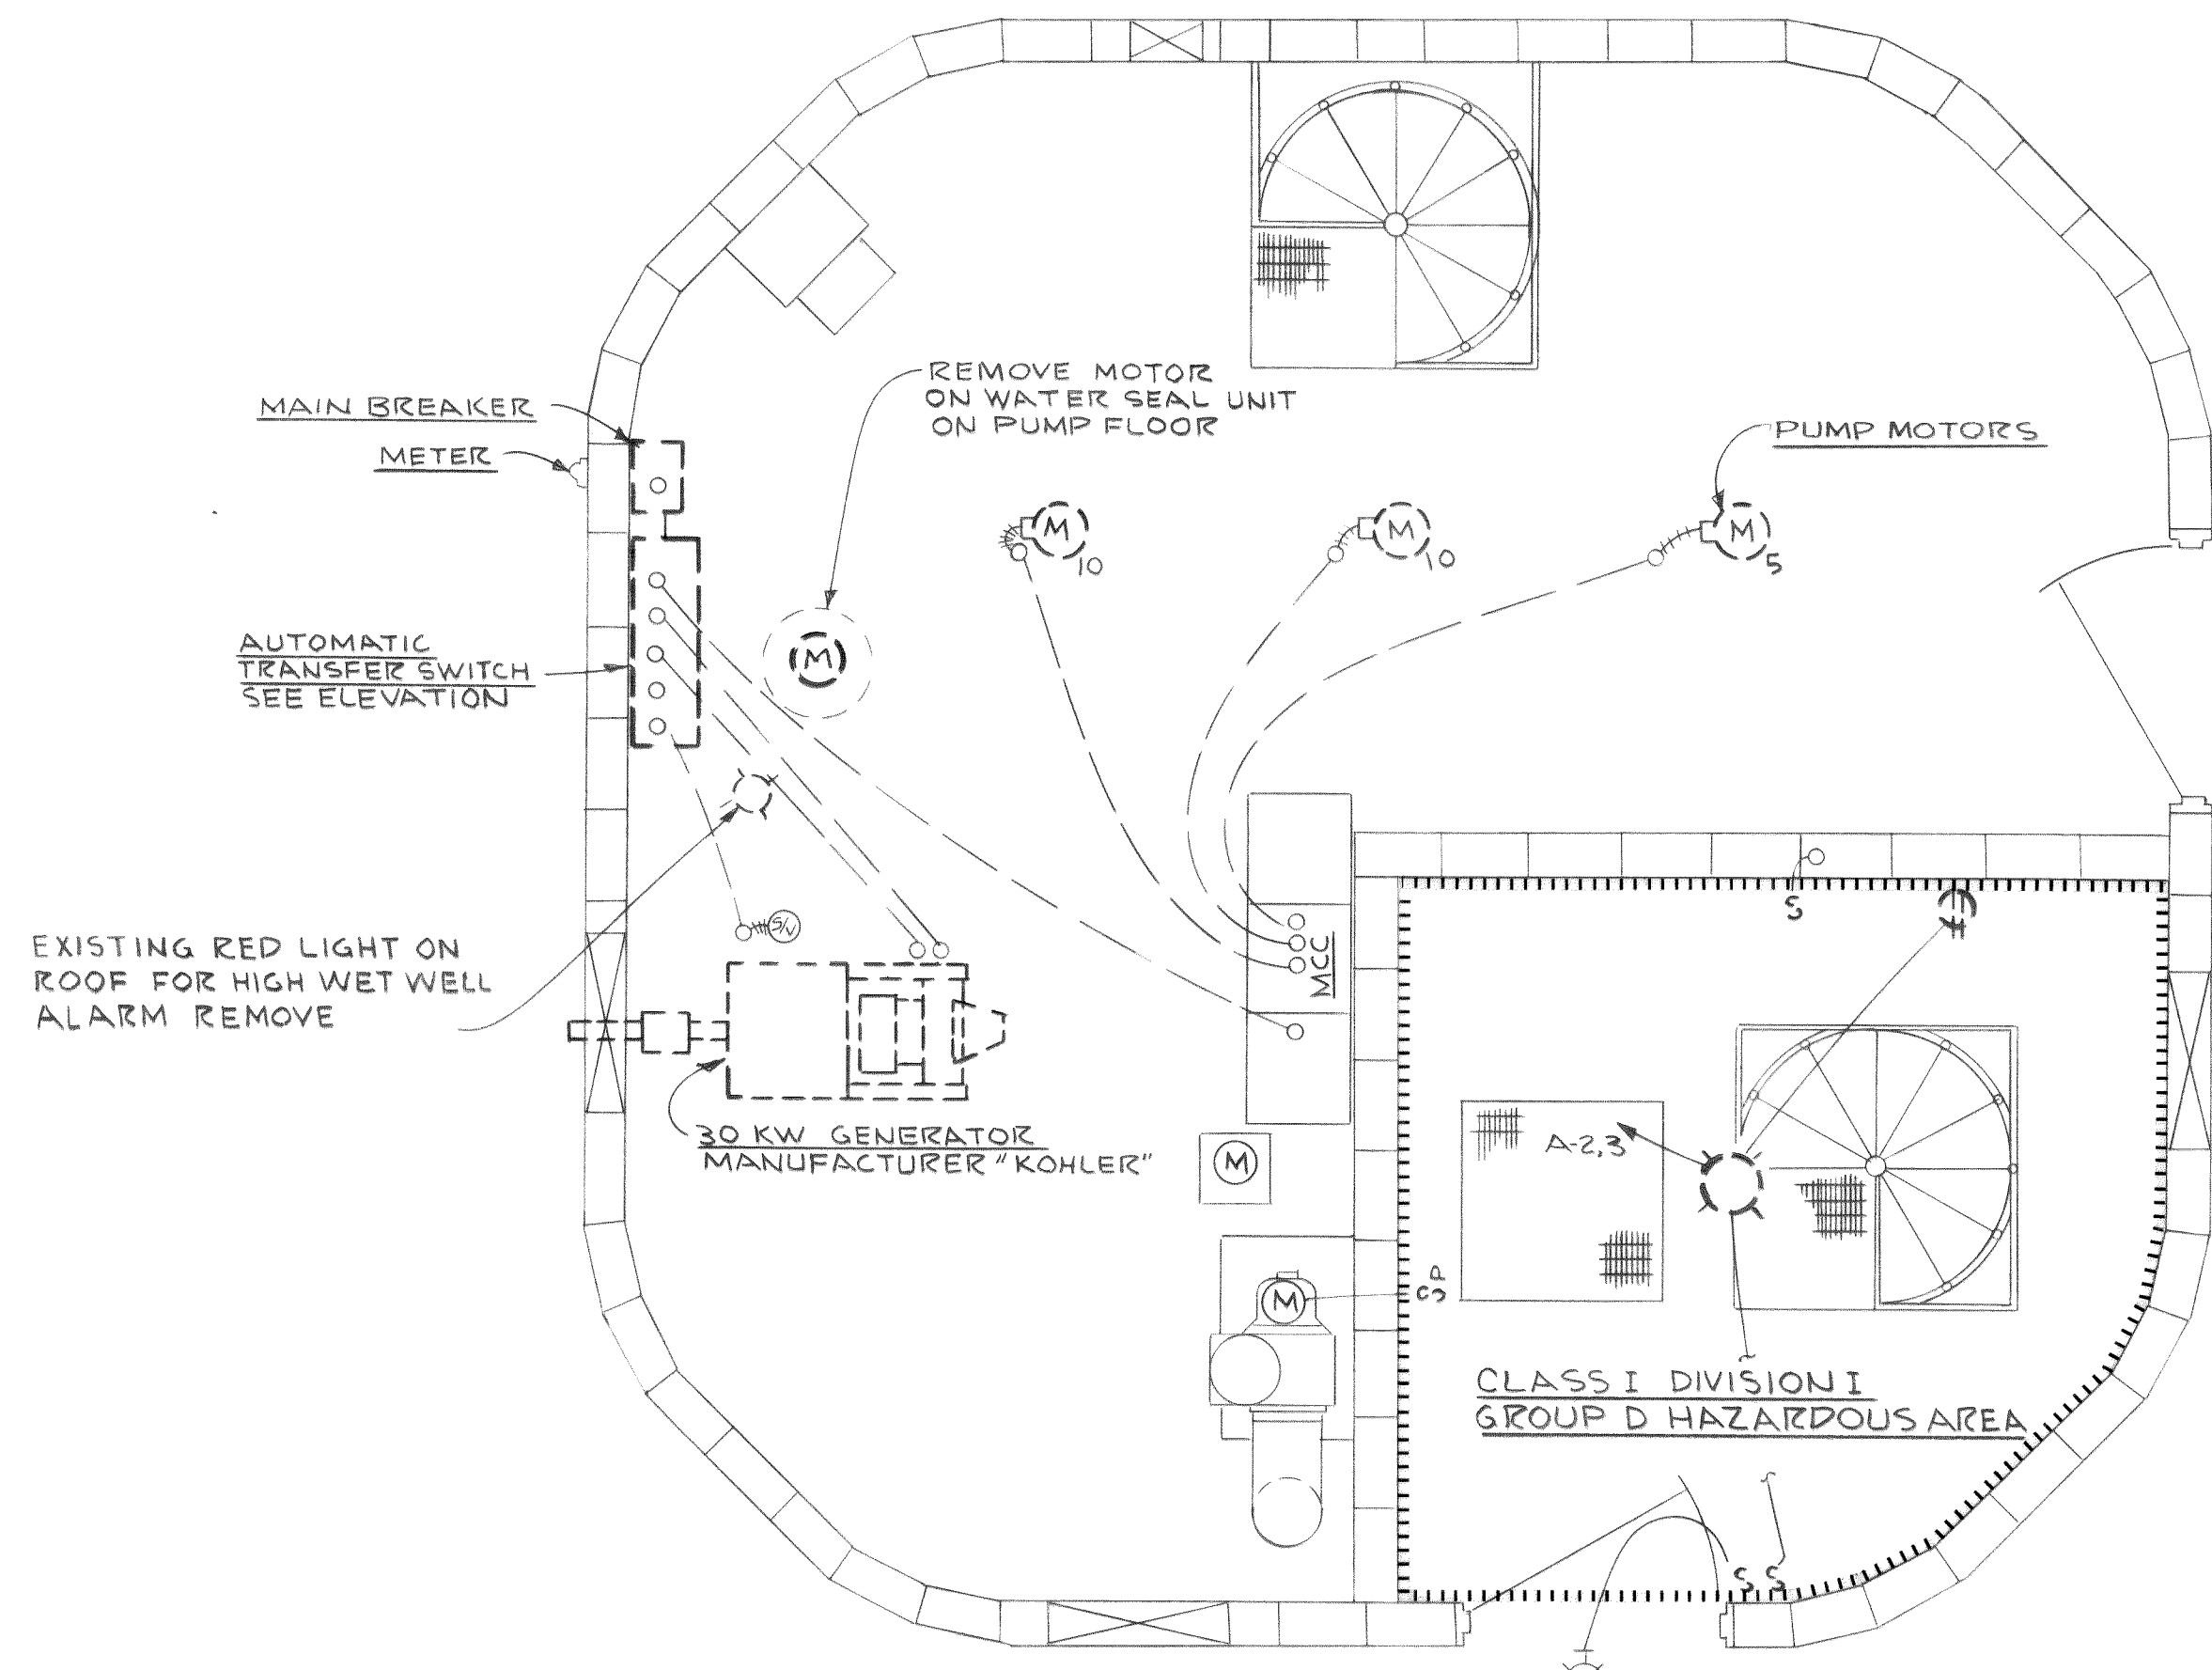


MOTOR FLOOR PLAN
SCALE: 3/8" = 1'-0"
EXISTING PUMP STATION


SECTION 3	SECTION 2	SECTION 1
3A PUMP CONTROL PANEL HIGH WATER ALARM 3B AIR COMPRESSOR	2A PUMP #1 2C PUMP #2 2D PUMP #3 2E COMMUNICATOR 2F SPACE	1A INCOMING LINE 1B LIGHTING PANEL A 1C LIGHTING TRANSF. BREAKER 1D LIGHTING TRANSF. 15 KVA

EXISTING MOTOR CONTROL CENTER
SCALE 3/4" = 1'-0"

NOTE:
RE-USE EXISTING MOTOR CONTROL CENTER WITH THE FOLLOWING MODIFICATIONS:
SECTION 1 RE-USE AS IS
SECTION 2 RE-USE STARTERS AND BREAKERS IN 2C & 2D AS INDICATED ON SHEET E4
SECTION 3 MODIFY CONTROL CIRCUITS AS INDICATED ON SHEET E5

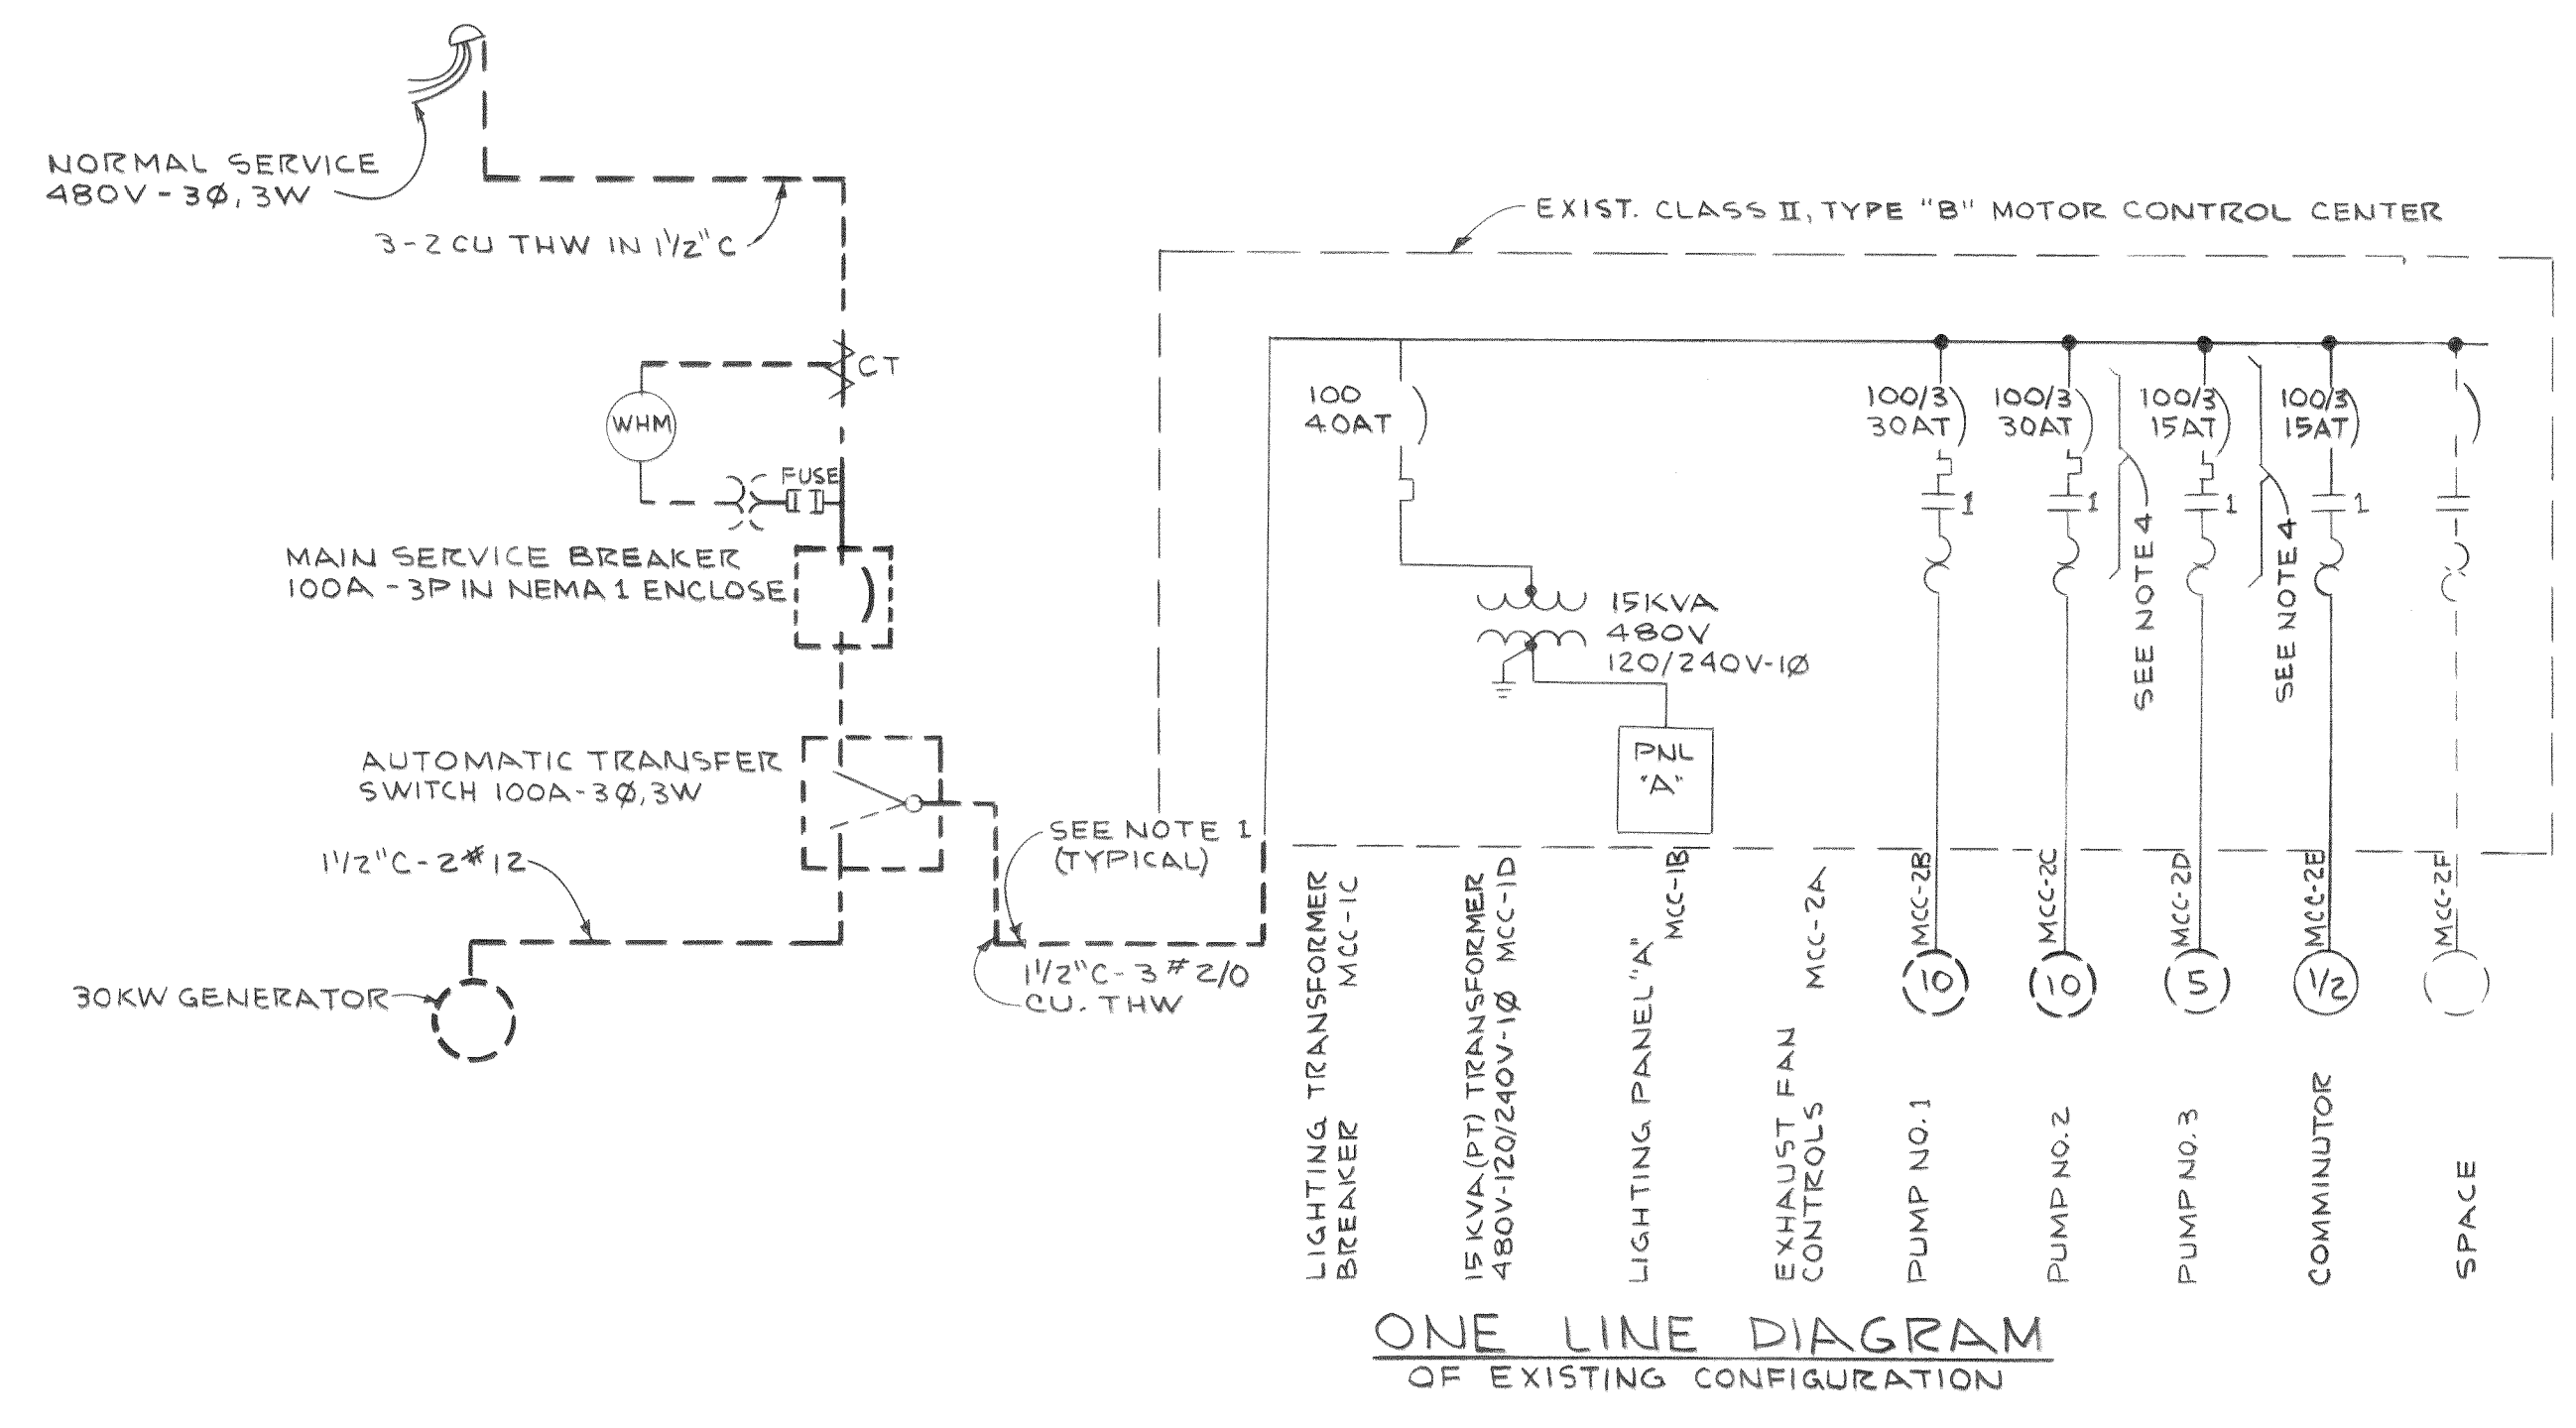

ONE LINE DIAGRAM
OF EXISTING CONFIGURATION

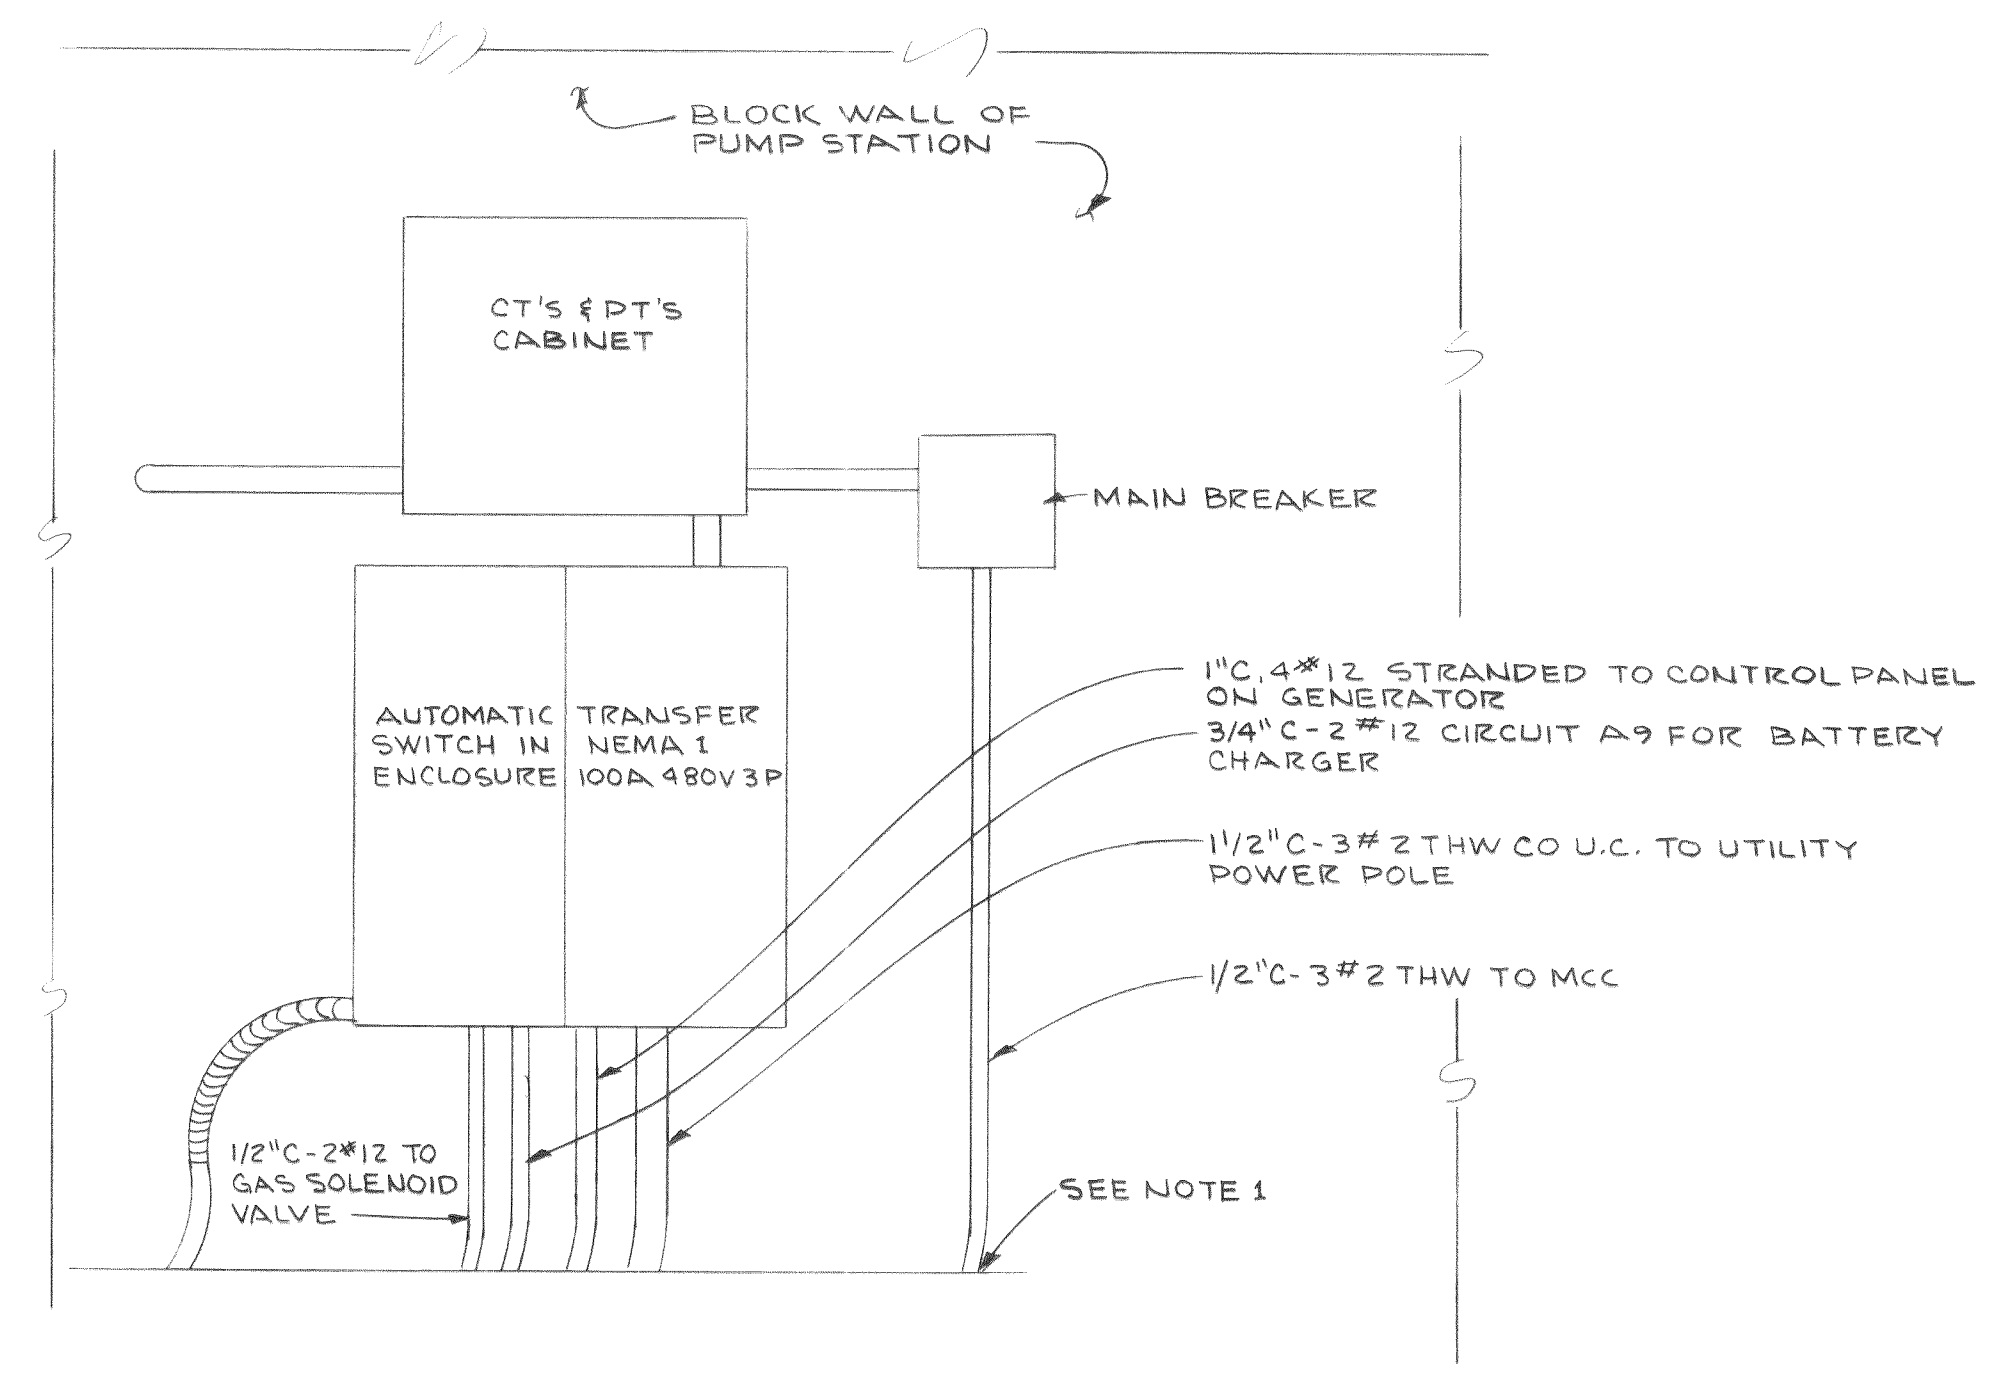

ELEVATION B
NO SCALE

EQUIPMENT TO BE REMOVED
(SEE NOTE 3)

LEGEND
— LIGHT LINE - EXISTING TO REMAIN
--- DASHED LINE - EXISTING EQUIP. TO BE REMOVED
--- EXISTING CIRCUITS CAST IN CONCRETE
SEE NOTE 1

- NOTES:
1. REMOVE CONDUCTORS FROM CONDUITS, WHERE EQUIPMENT HAS BEEN REMOVED. WHERE CONDUIT STUBS UP EXPOSED, CUT OFF FLUSH WITH FLOOR. (TYP.)
 2. EXISTING MOTOR CONTROL CENTER IS AS MANUFACTURED BY SQUARE D.
 3. ALL HOLES IN BLOCK WALLS AND FLOORS LEFT WHEN EQUIPMENT HAS BEEN REMOVED SHALL BE GROUTED IN.
 4. RE-USE EXISTING EQUIPMENT AS INDICATED ON SHEET E4.


MICROFILMED

LEGEND


— LIGHT LINE - EXISTING TO REMAIN
 = SOLID HEAVY LINE - NEW WORK
 --- NEW CONDUIT AND WIRING ROUTED BELOW MOTOR ROOM FLOOR SLAB.

NOTES:


FOR CONDUIT PENETRATION SEE DETAIL 10/56

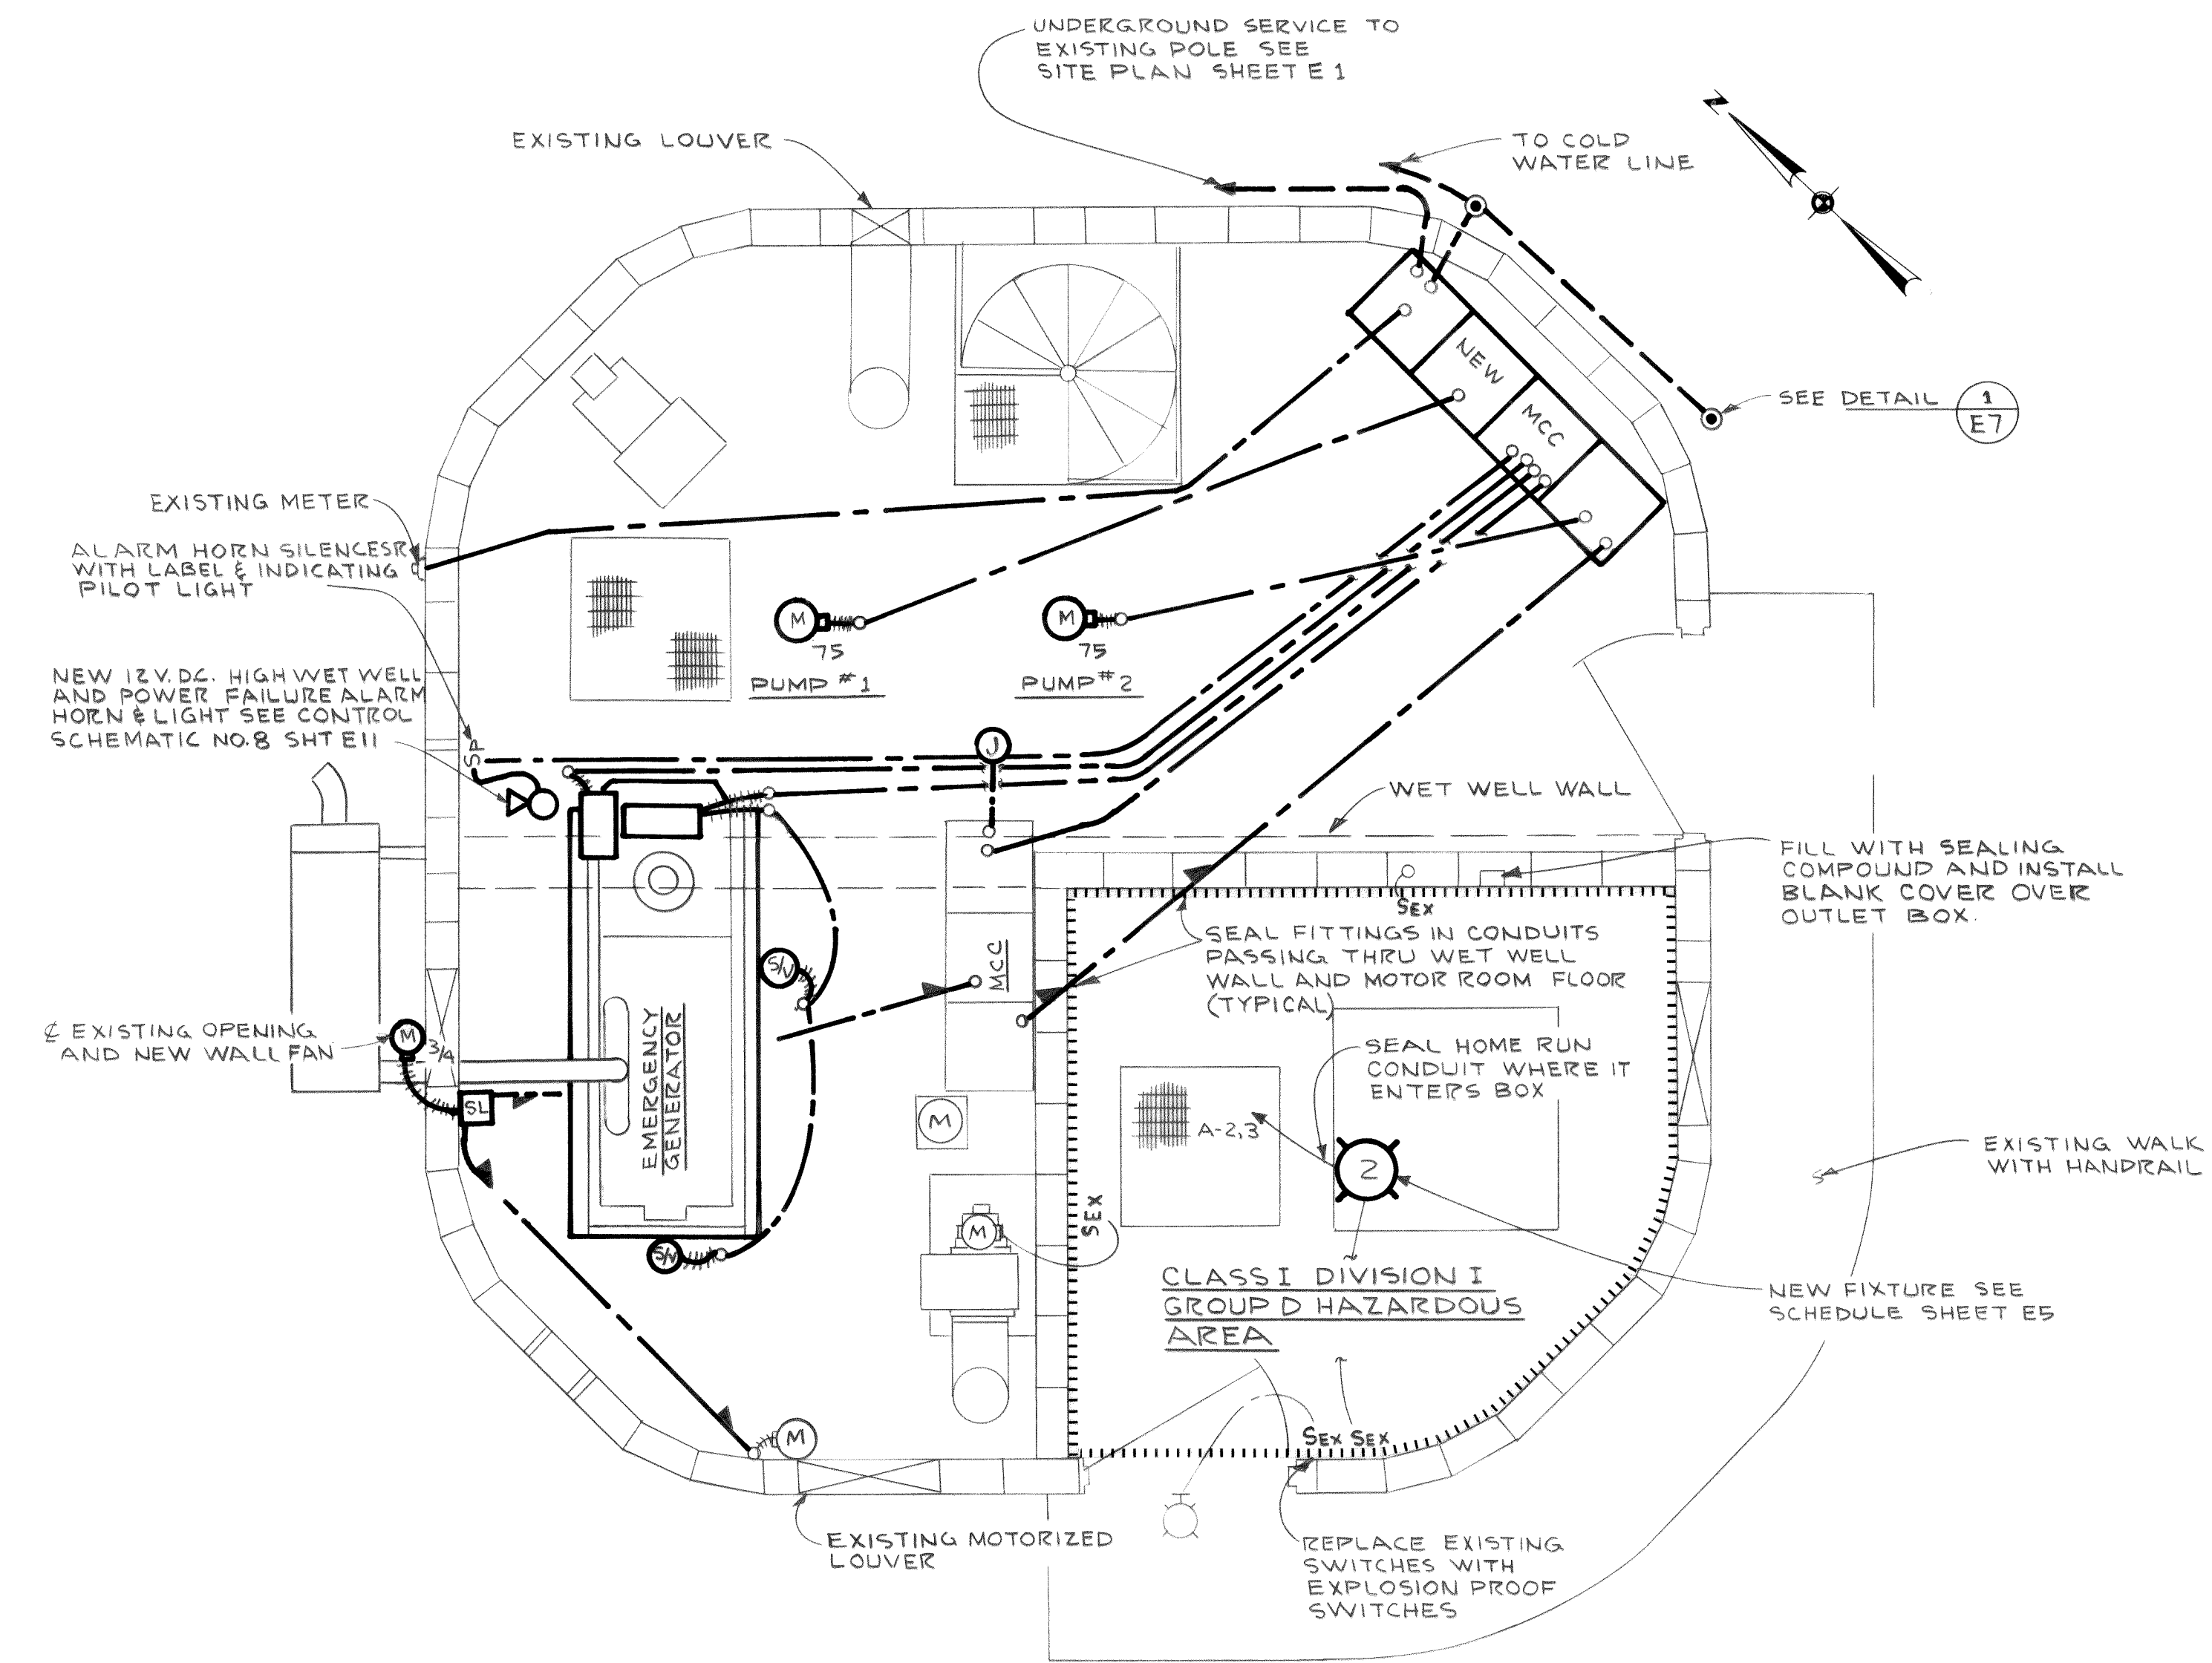


MOTOR FLOOR PLAN
 SCALE 3/8" = 1'-0"

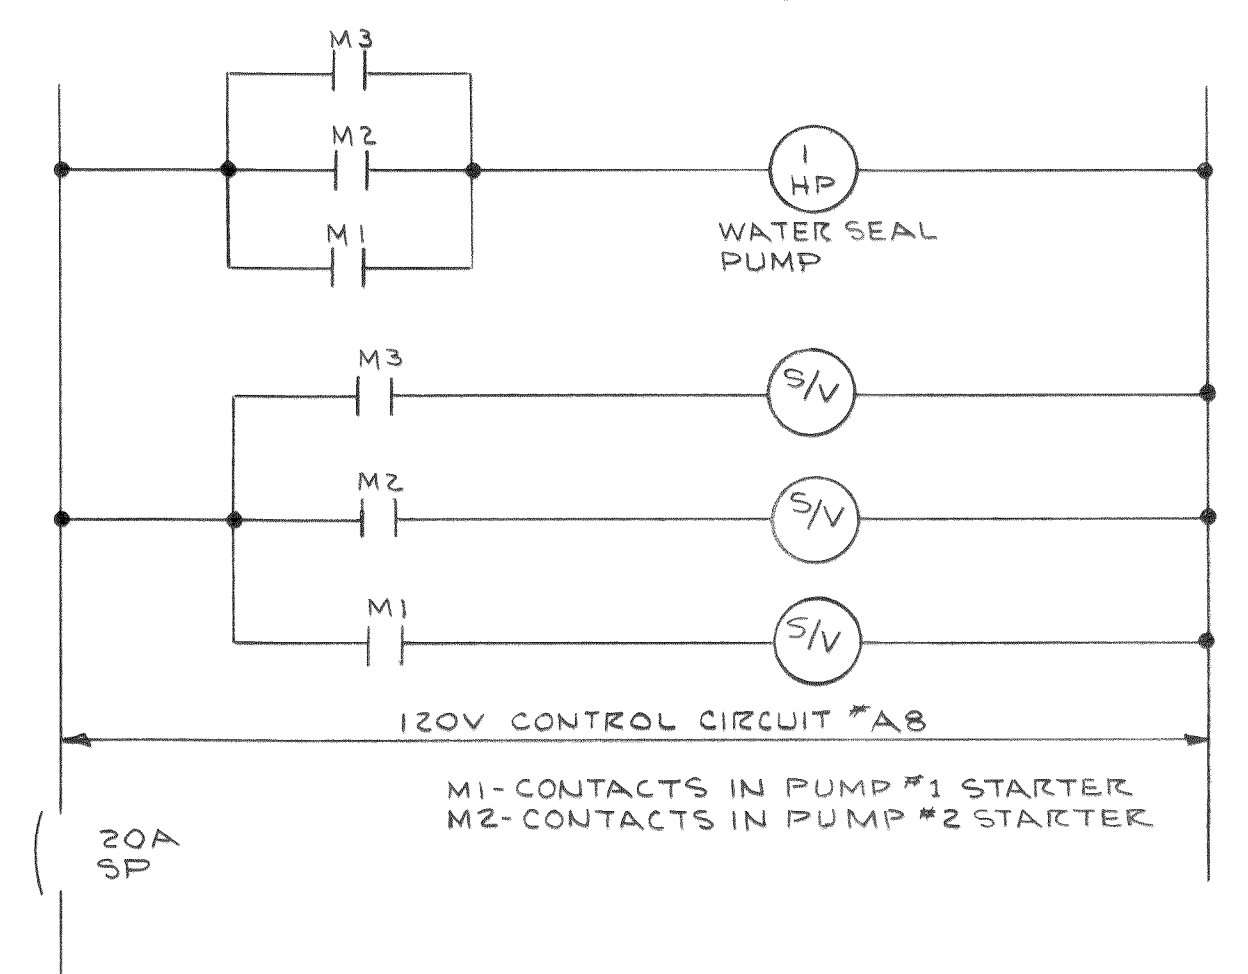

EXISTING WATER SEAL PUMP WIRING
 FOR REFERENCE ONLY

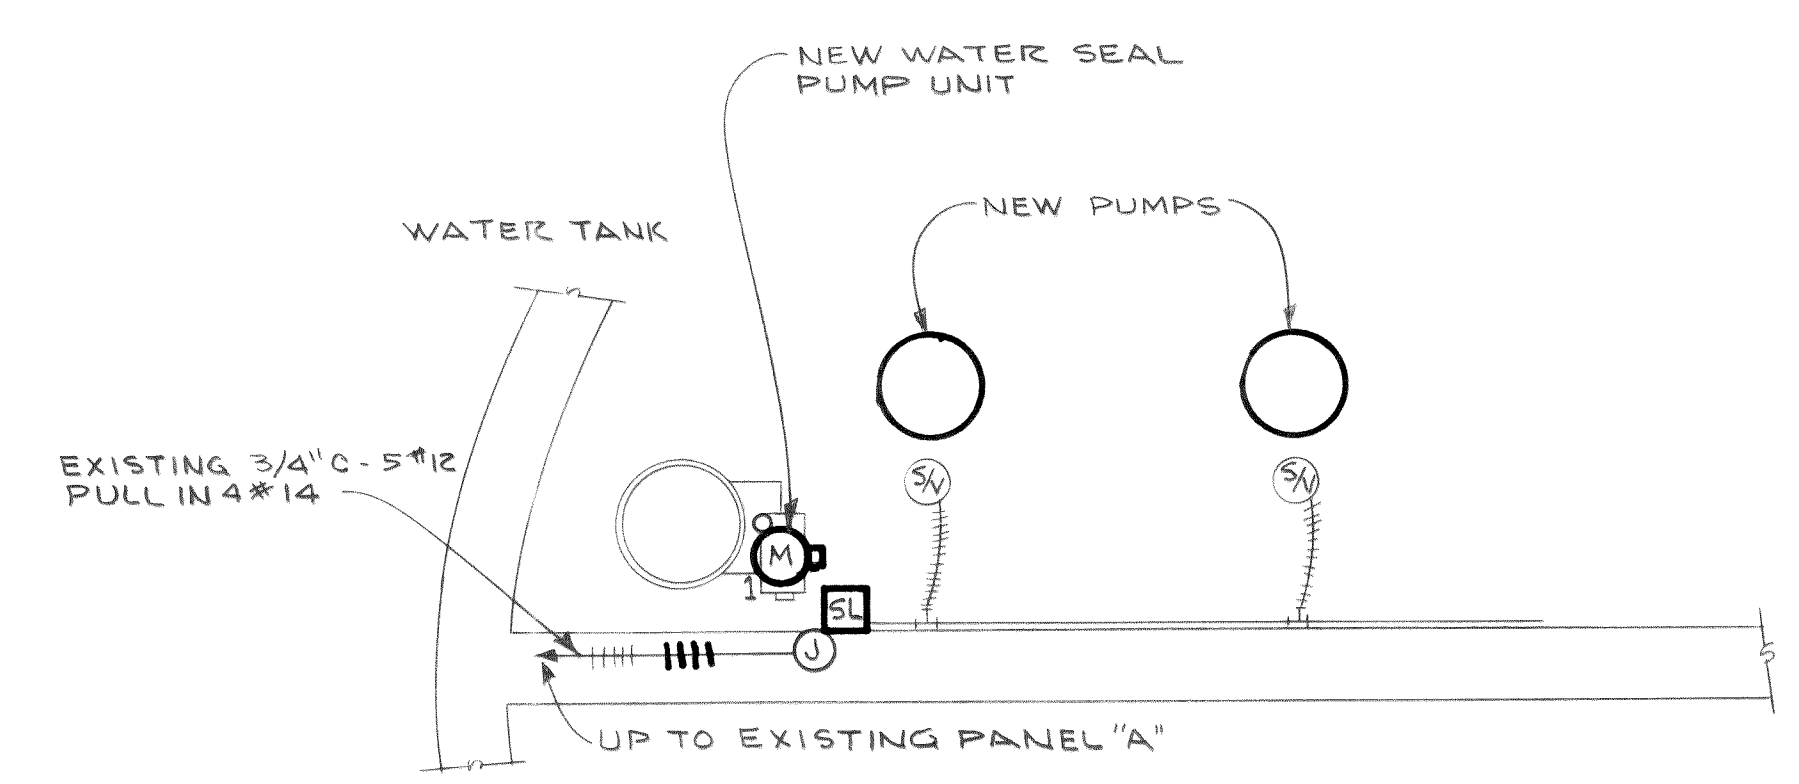


PART PLAN - PUMP FLOOR
 SCALE 3/8" = 1'-0"

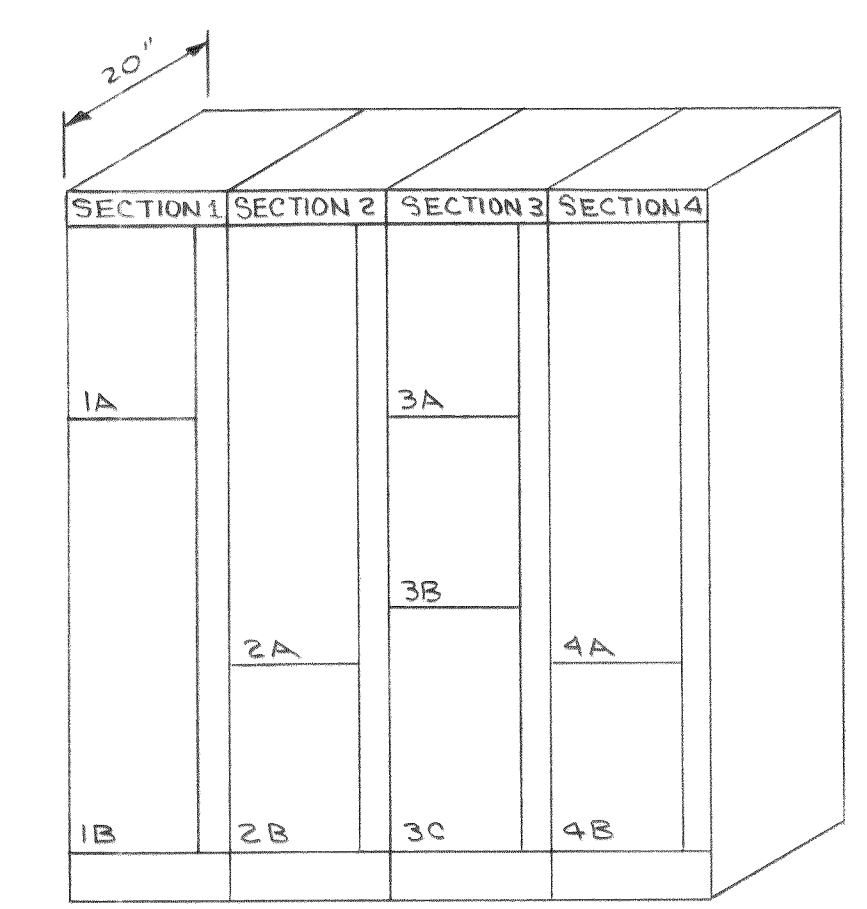

MOTOR CONTROL CENTER
 SCALE 1/2" = 1'-0"

MCC NAMEPLATE ENGRAVING SCHEDULE			
UNIT NO.	NAMEPLATE ENGRAVING SIZE 1' x 2 1/2" 16 CHARACTERS PER LINE MAX		
	FIRST LINE	SECOND LINE	THIRD LINE
1A	MAIN BREAKER		
1B	METERING CT'S & PT'S		
2A	PUMP #1		
2B			
3A	AUTOMATIC	TRANSFER SWITCH	CONTROL PANEL
3B	AUTOMATIC	TRANSFER SWITCH	
3C	GENERATOR	BREAKER	
4A	PUMP #2		
4B	FEEDER TO MOTOR	CONTROL CENTER	


MICROFILMED

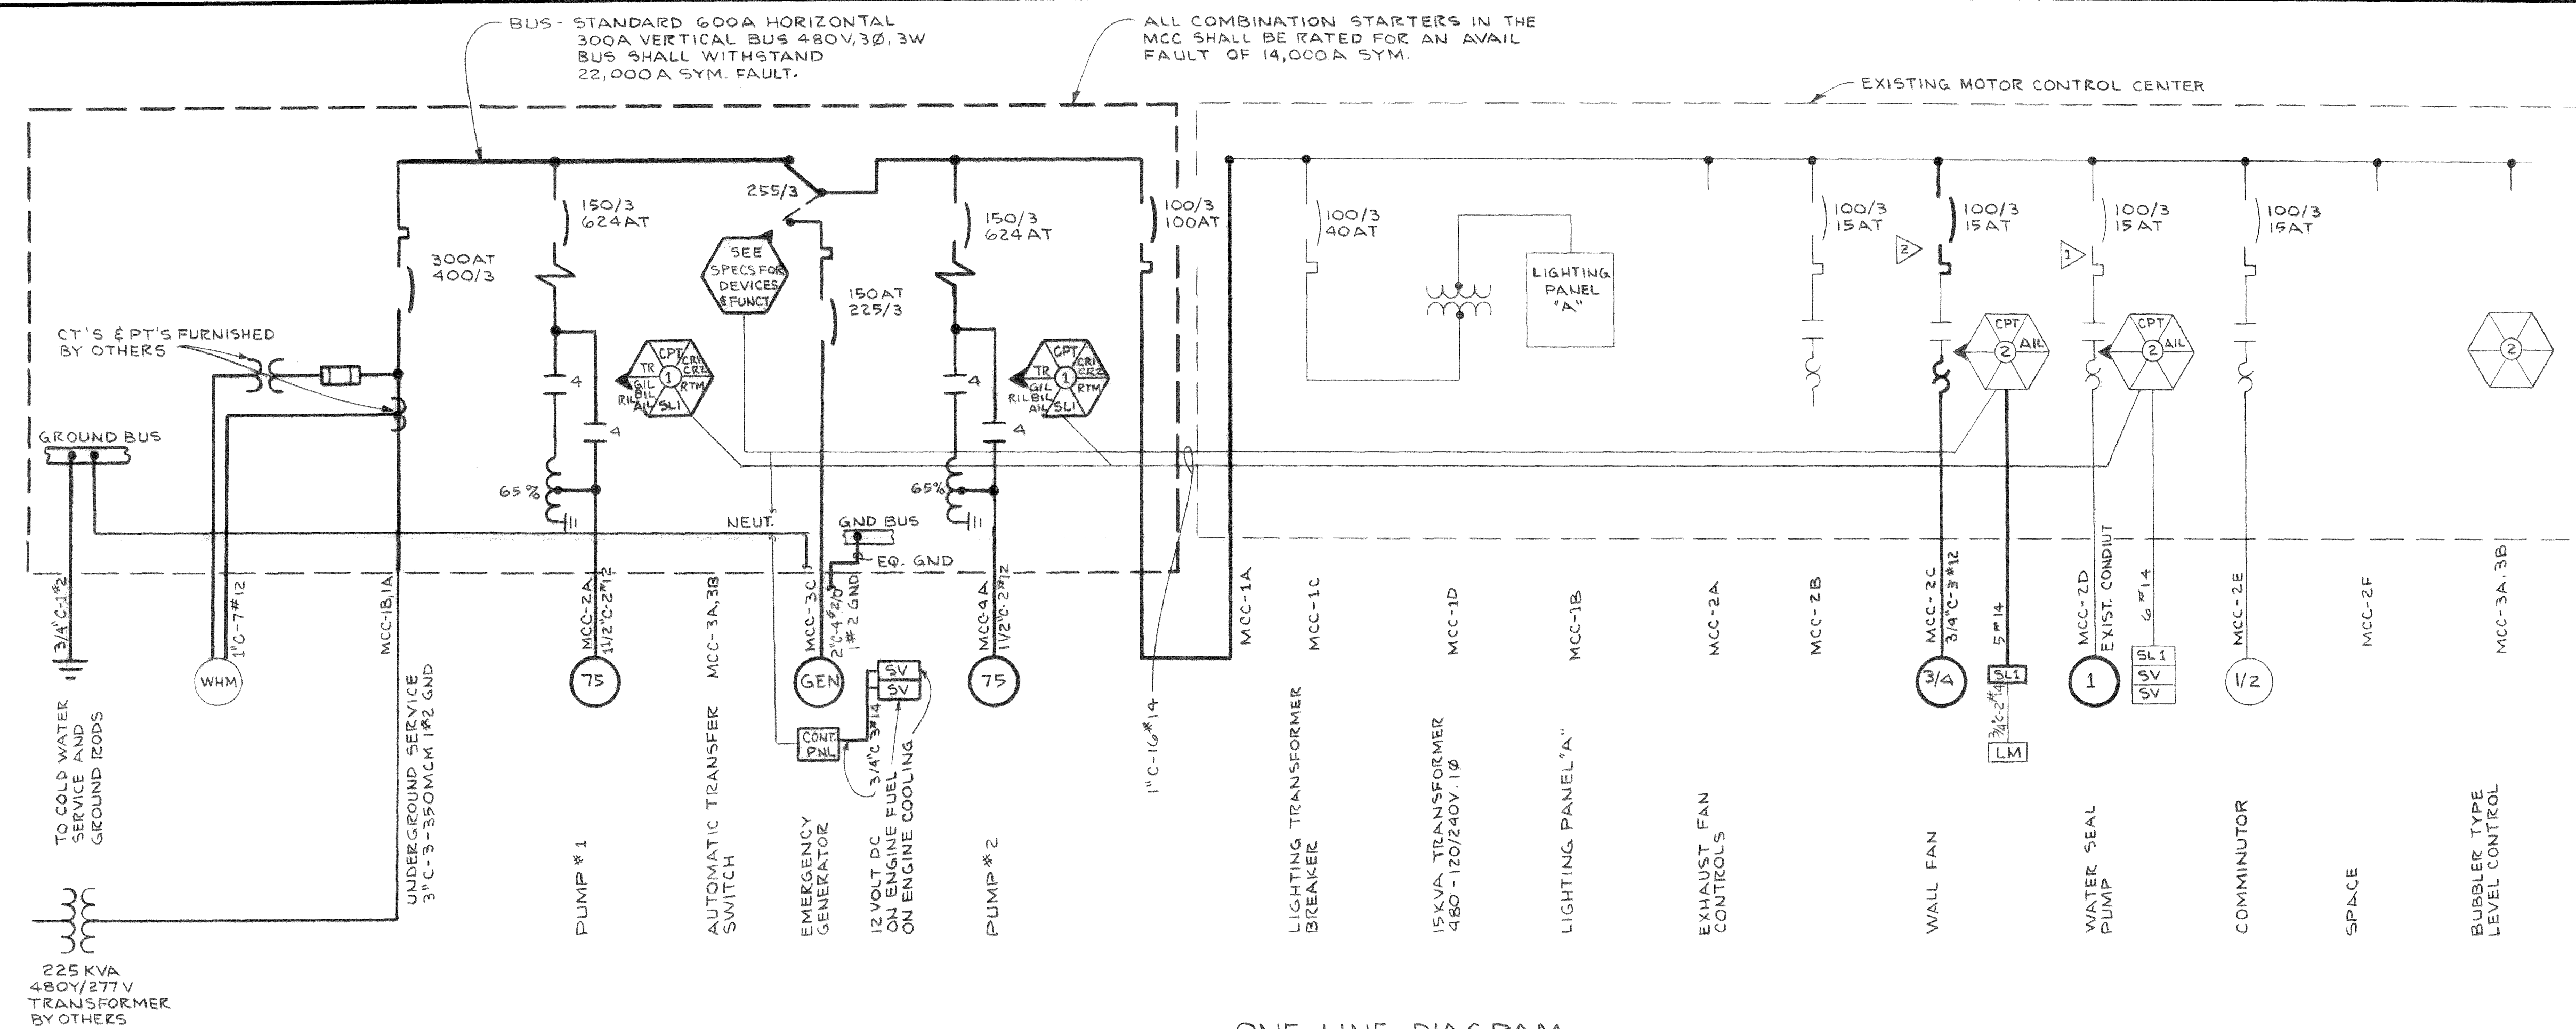

NOTES:

1 REUSE EXIST. PUMP #3 COMBINATION STARTER FOR NEW WATER SEAL UNIT


2 REUSE EXIST. PUMP #2 COMBINATION STARTER FOR THE NEW EXHAUST FAN - REPLACE THE EXIST. 30A BREAKER WITH 15A BREAKER.

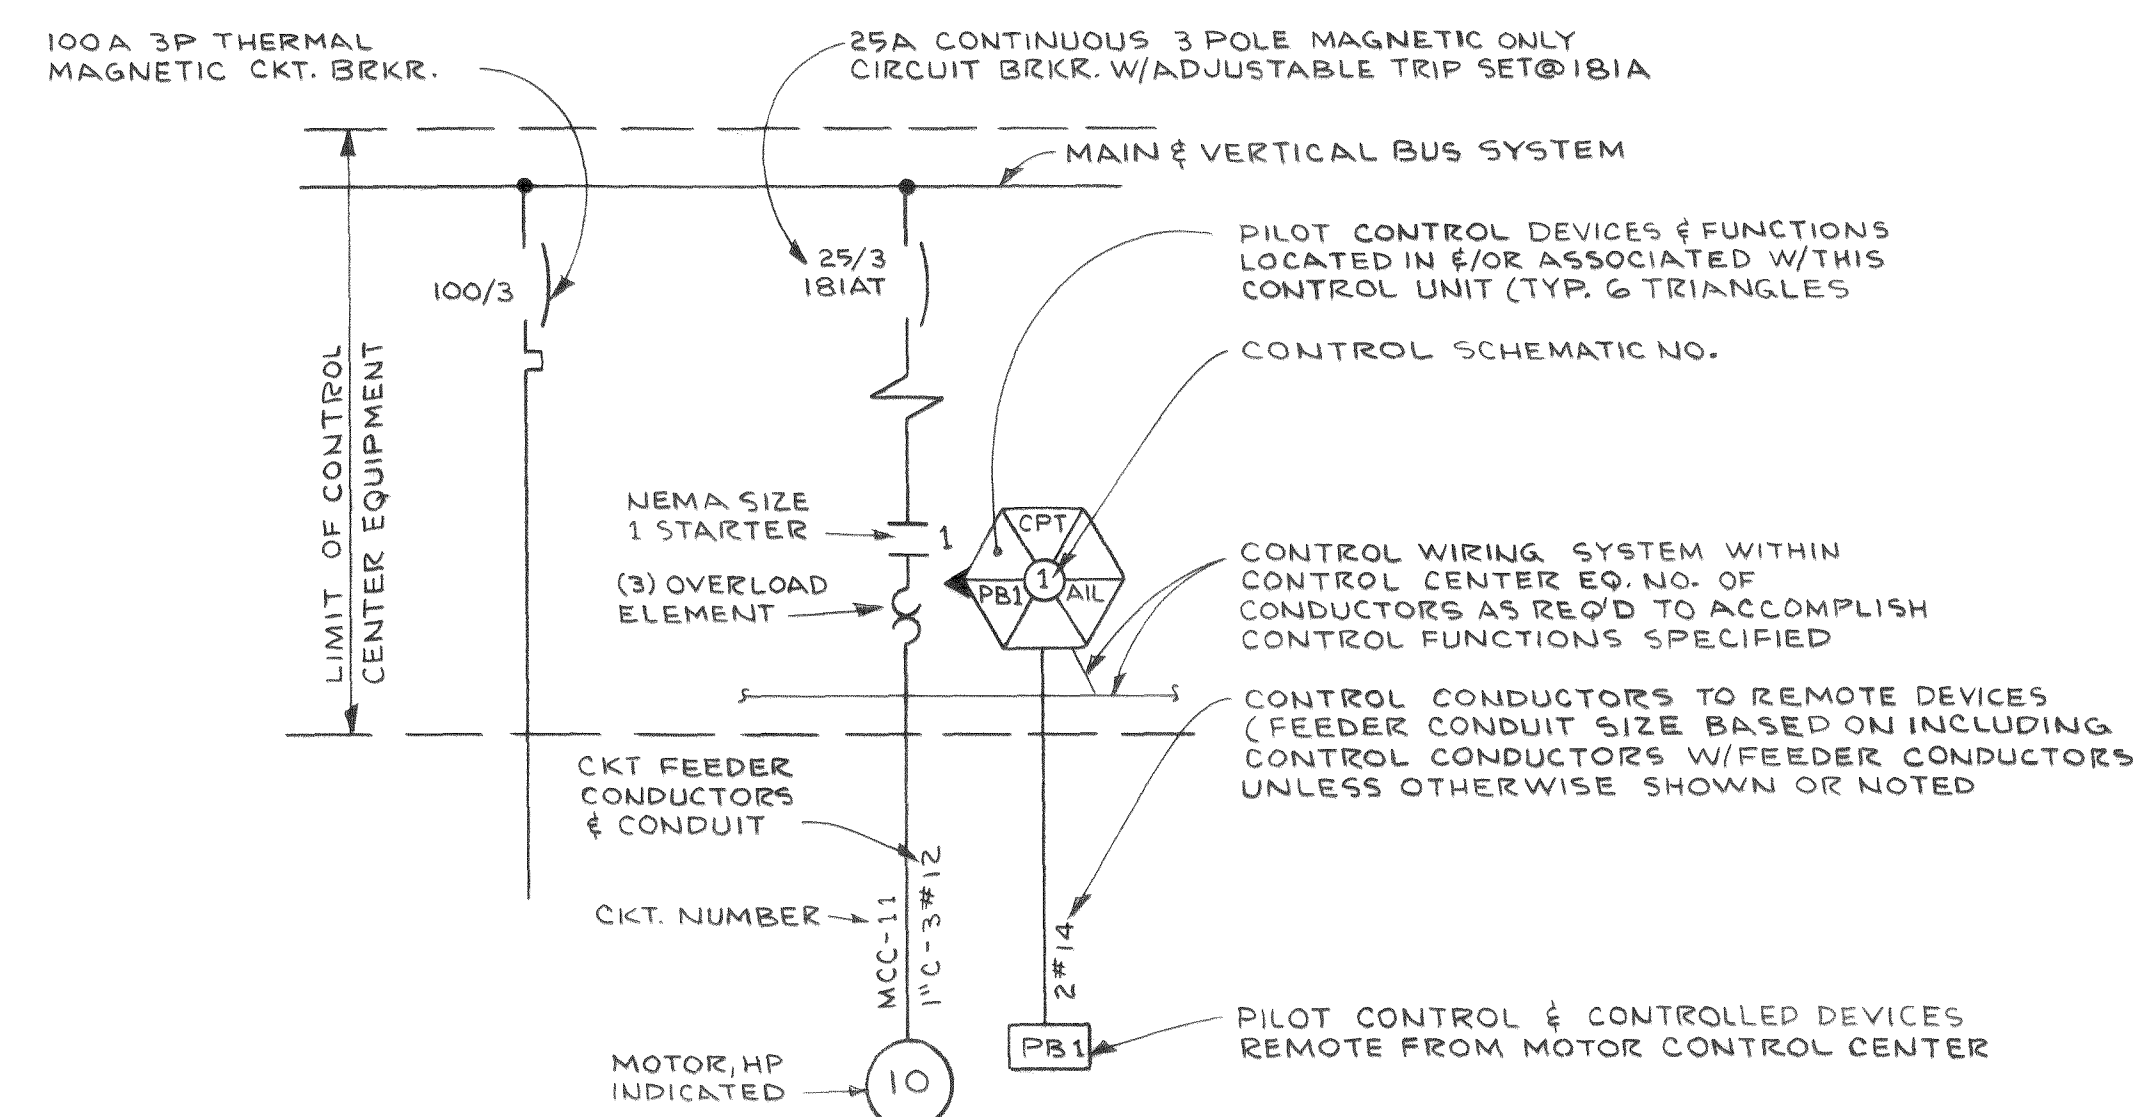


CONTROL KEY


CPT	- CONTROL POWER TRANSFORMER
AIL	- AMBER INDICATING LIGHT
BIL	- BLUE INDICATING LIGHT
GIL	- GREEN INDICATING LIGHT
RIL	- RED INDICATING LIGHT
CR12,ETC.	- CONTROL RELAY FOR FUNCTION DETAILED
RM	- RUNNING HOUR METER
SL1	- LEAD-LAG PUMP SELECTOR SWITCH
TC12	- TIME CLOCK
TR	- TIMING RELAY
ULM	- ULTRASONIC LEVEL MONITOR
ULS	- ULTRASONIC LEVEL SENSOR
ALT	- ALTERNATOR
LM	- LOWVER MOTOR

MICROFILMED

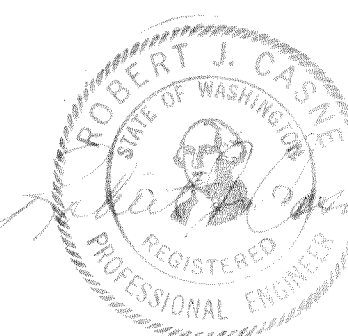


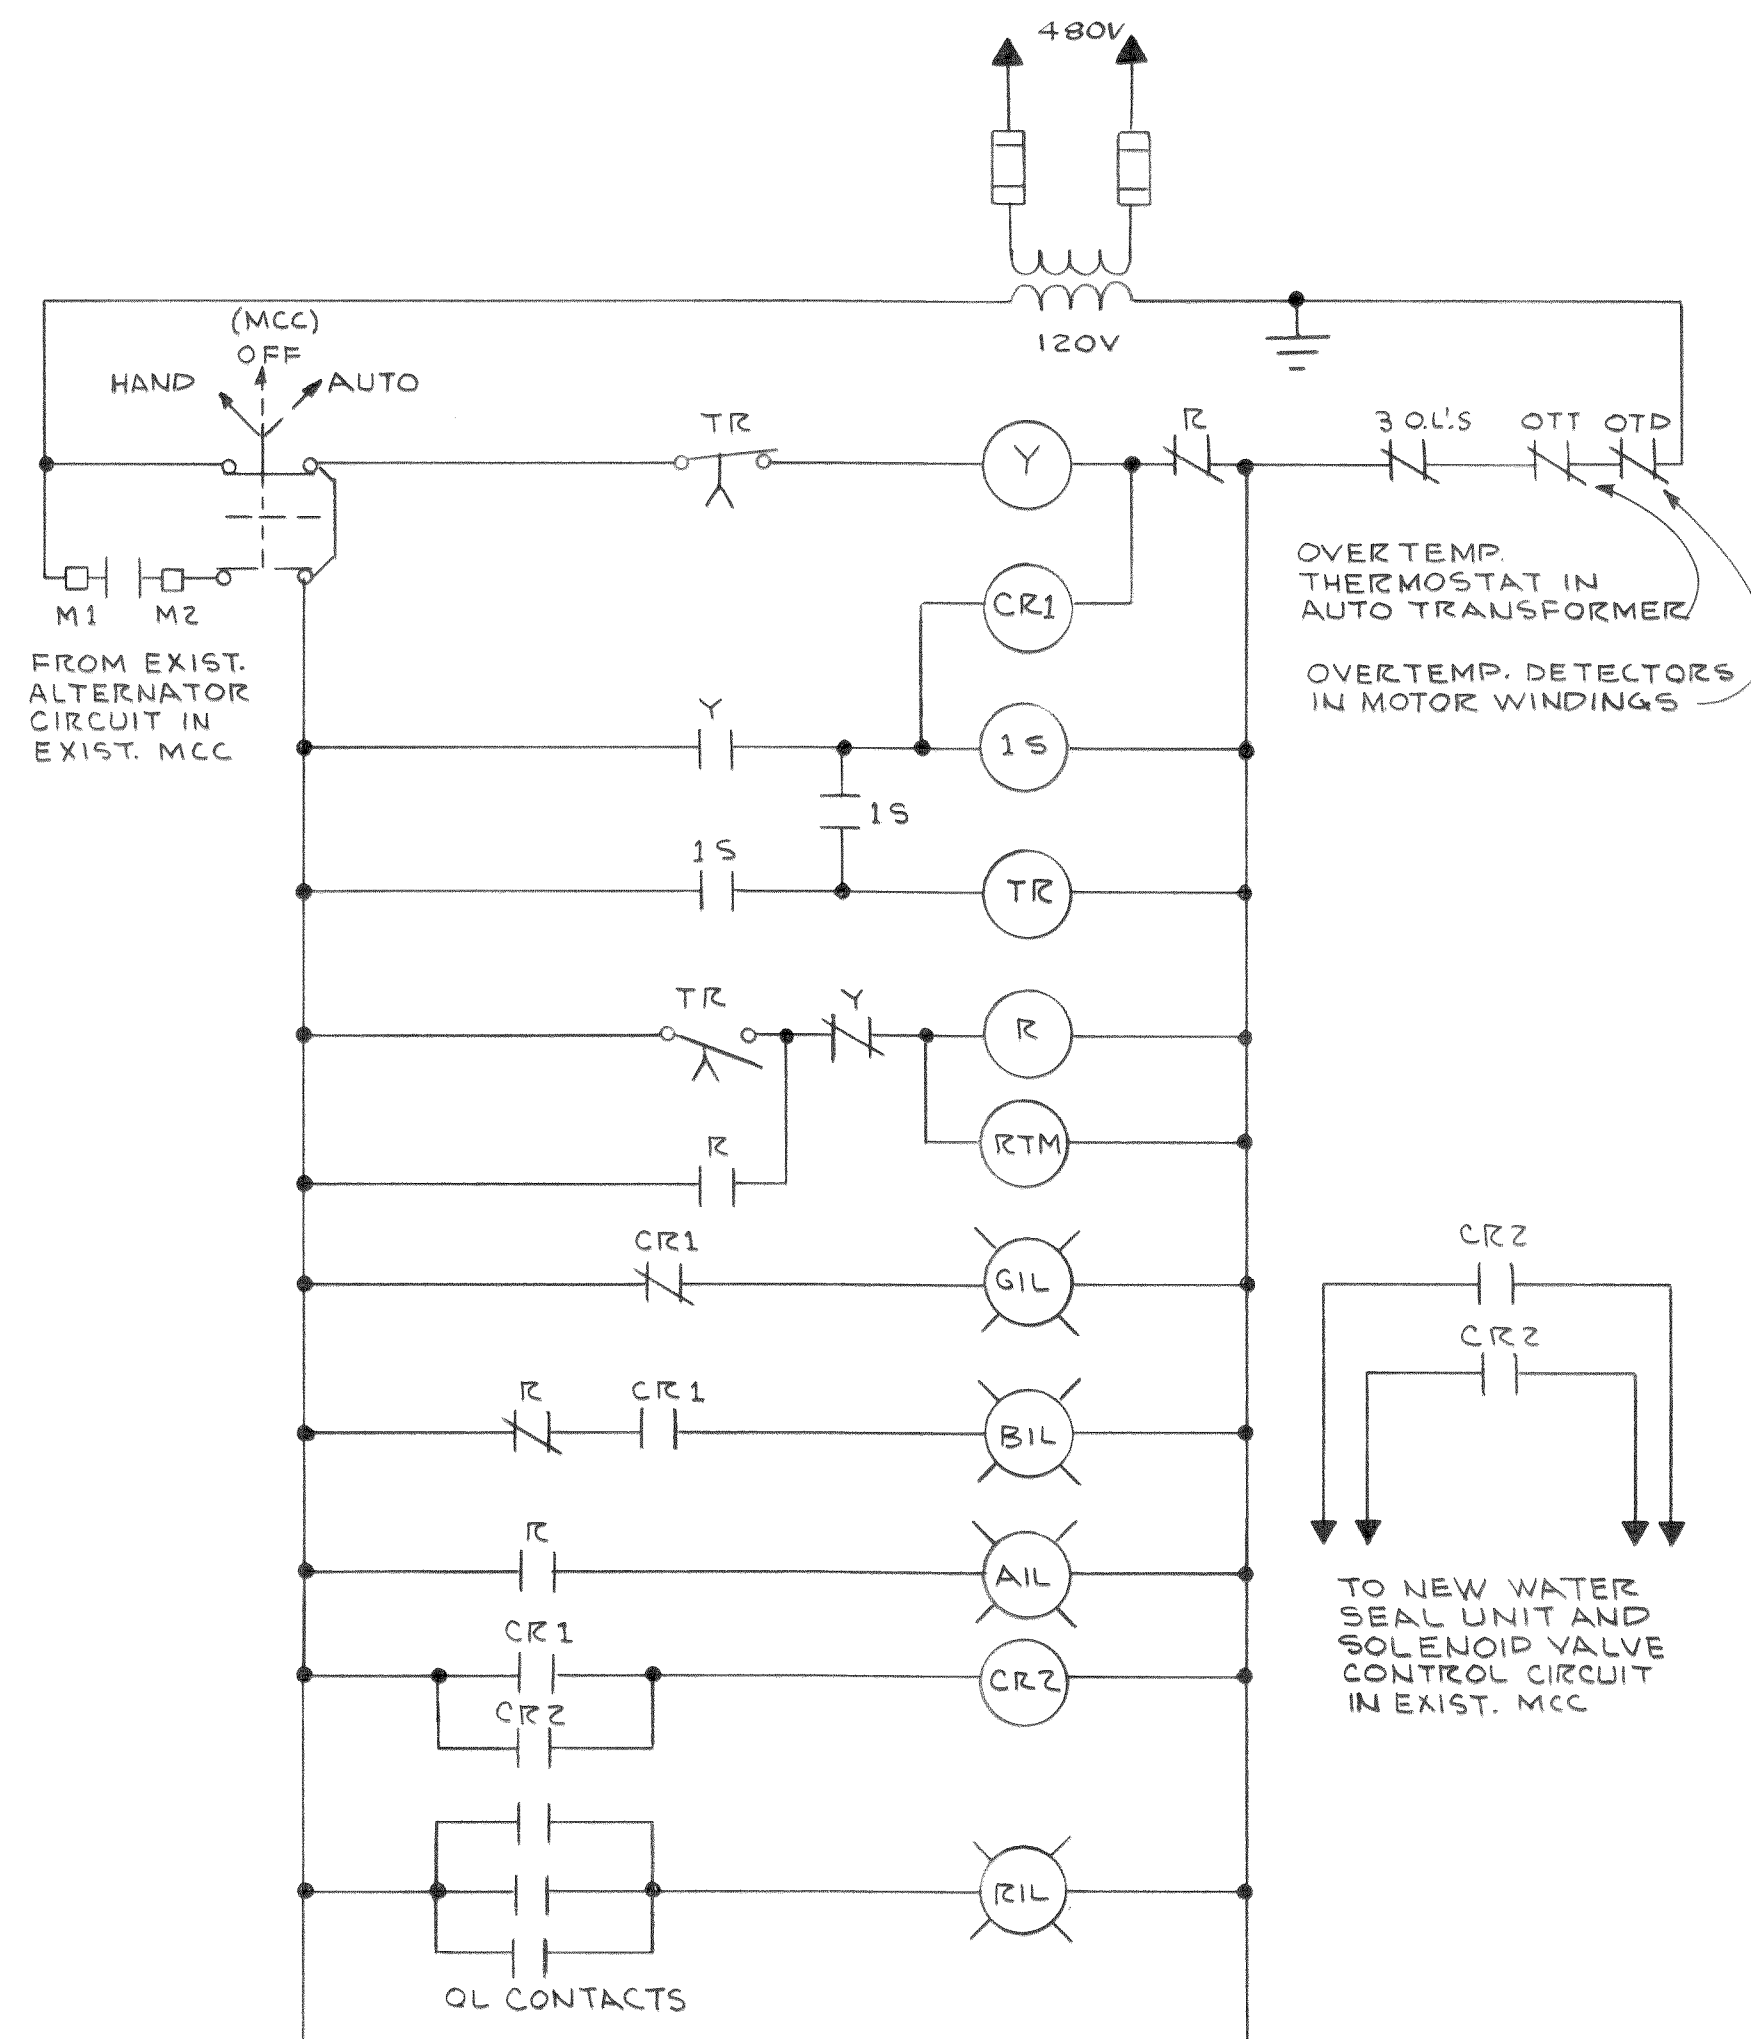

CONTROL SCHEMATIC NO. 1
AUTOTRANSFORMER STARTER

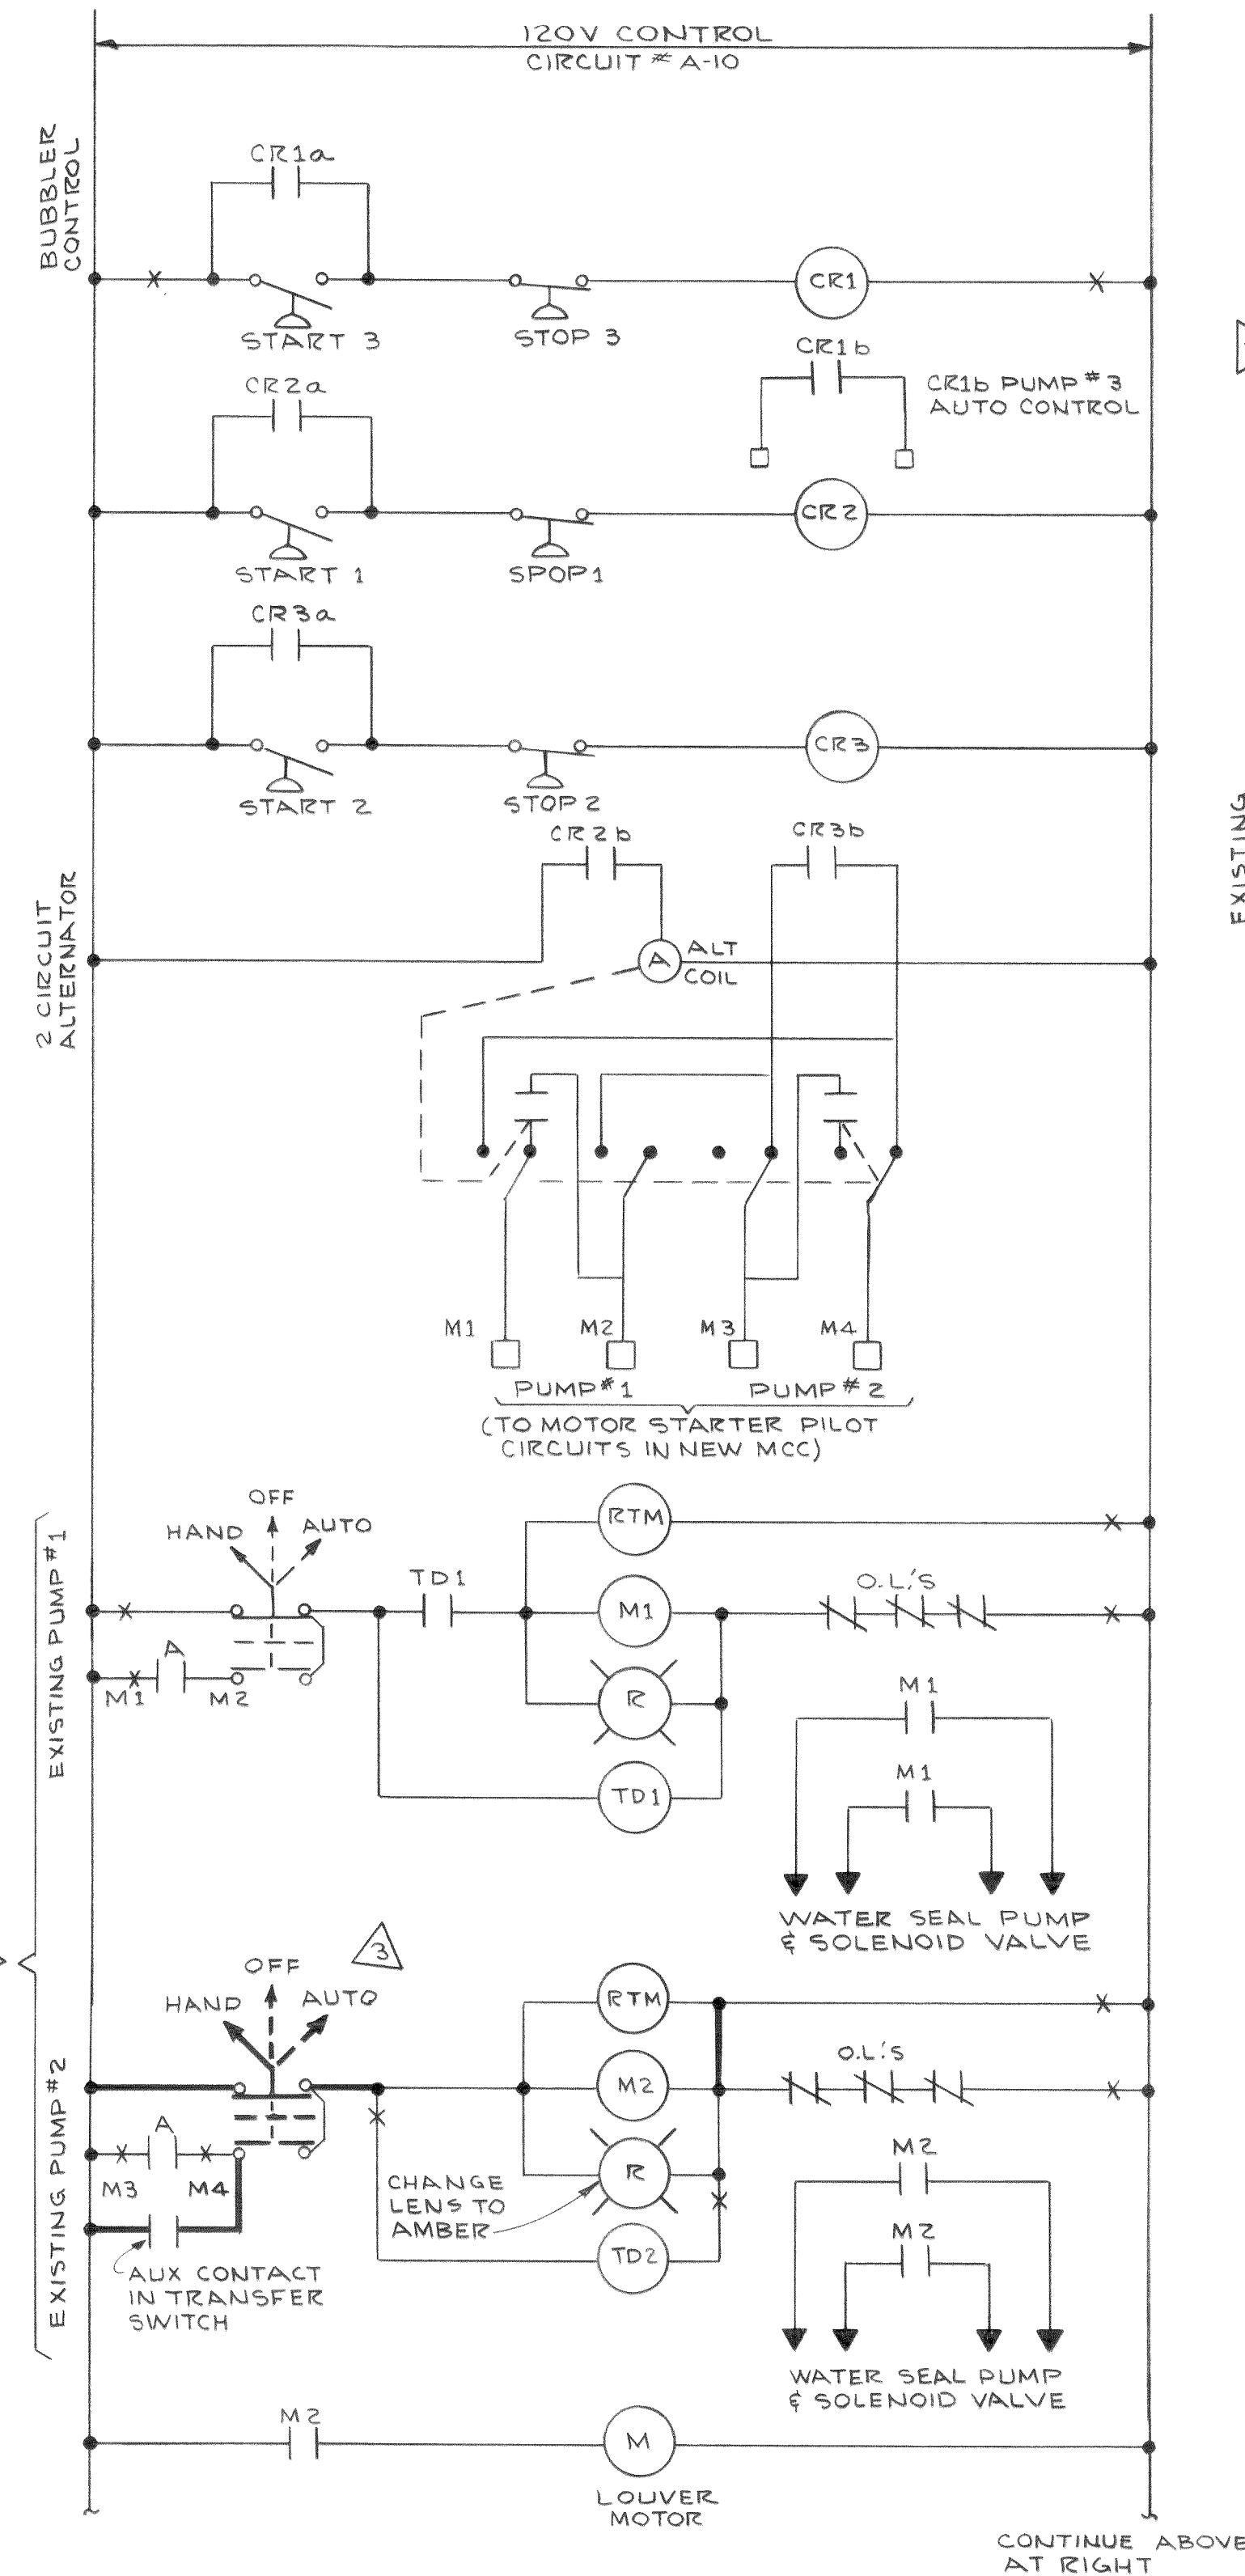

CONTROL SCHEMATIC NO. 2
MODIFICATION OF EXISTING CONTROL SCHEMATIC

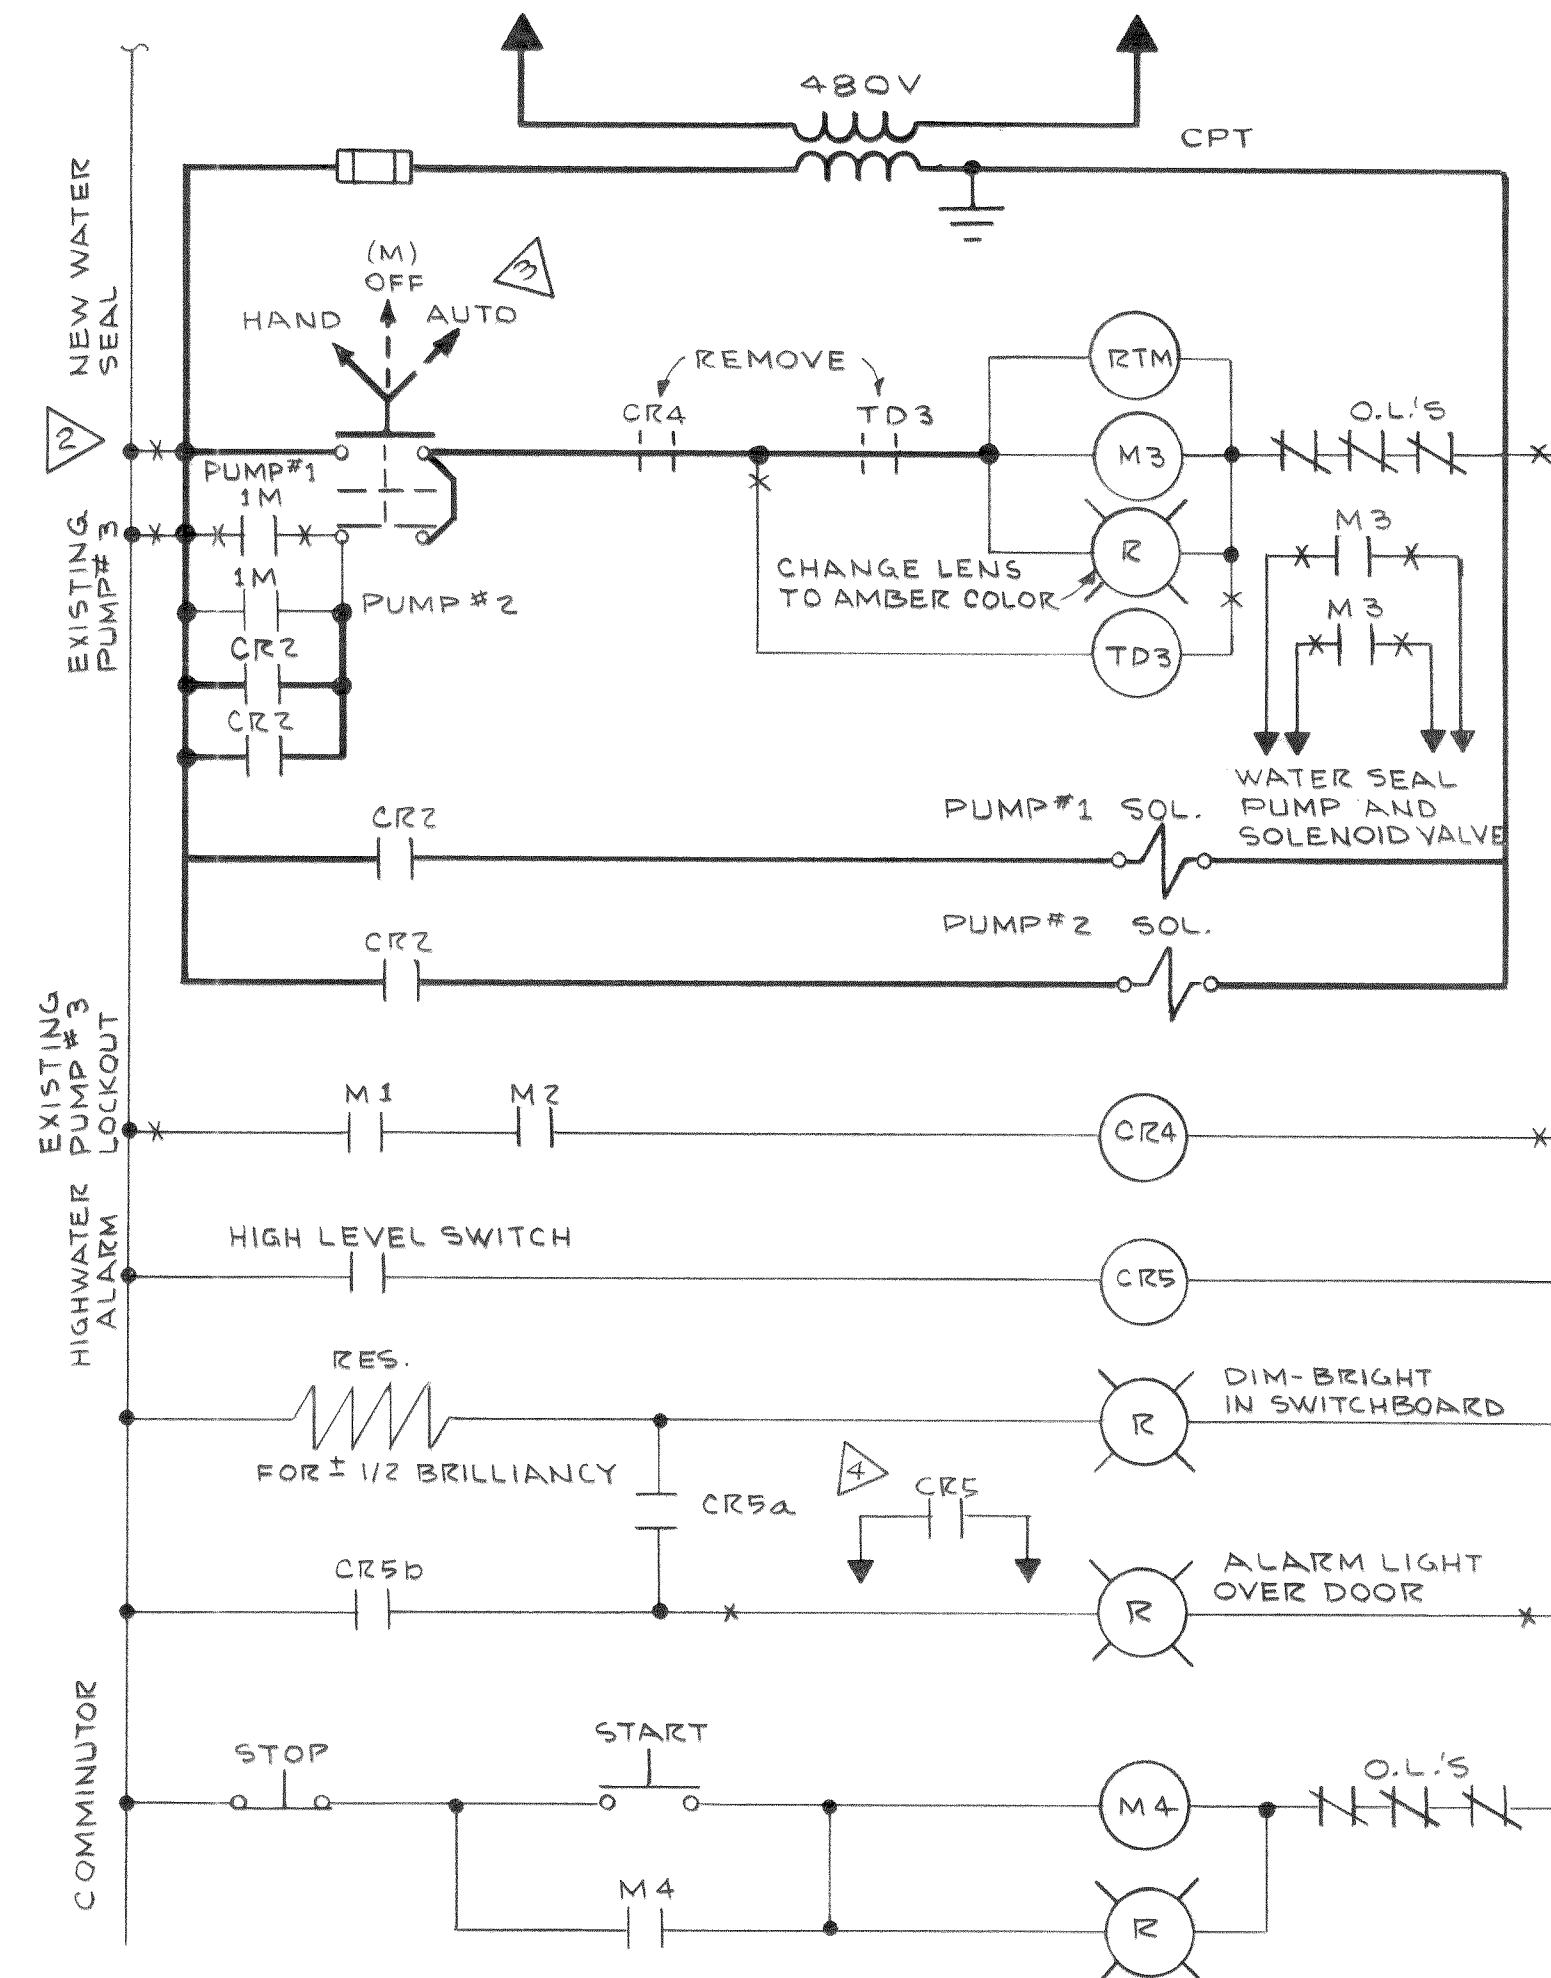

LEGEND
— LIGHT LINE - EXISTING TO REMAIN
— HEAVY SOLID LINE - NEW WORK

- NOTES:
- 1 DISCONNECT EXISTING CONTROLS FOR EXISTING PUMP #1 & #2 AS SHOWN - DISCONNECT WIRE WHERE INDICATED BY X.
 - 2 RE-USE EXISTING PUMP #3 CONTROLS AS MODIFIED FOR THE NEW WATER SEAL UNIT.
 - 3 REMOVE EXISTING SL1 IN MCC AND INSTALL NEW SL1 AT MOTOR.
 - 4 TO ALARM HORN AND LIGHT SEE CONTROL SCHEMATIC NO. 8 SHEET E II


DESIGNED R.J.C.	APPROVED <i>Edith Thomas</i>
DRAWN J.M.	SCALE NONE DATE JULY, 1972
CHECKED <i>LTB</i>	FILE 71-S-425.002

ST Stevens, Thompson & Runyan, Inc.
Engineers/Planners
PORTLAND SEATTLE BOISE

TOWN OF FERNDAL, WASHINGTON
AXTON ROAD INTERCEPTOR
SCHEDULE I


EXISTING PUMP STATION
ELECTRICAL CONTROL SCHEMATICS
E5
II

MICROFILMED

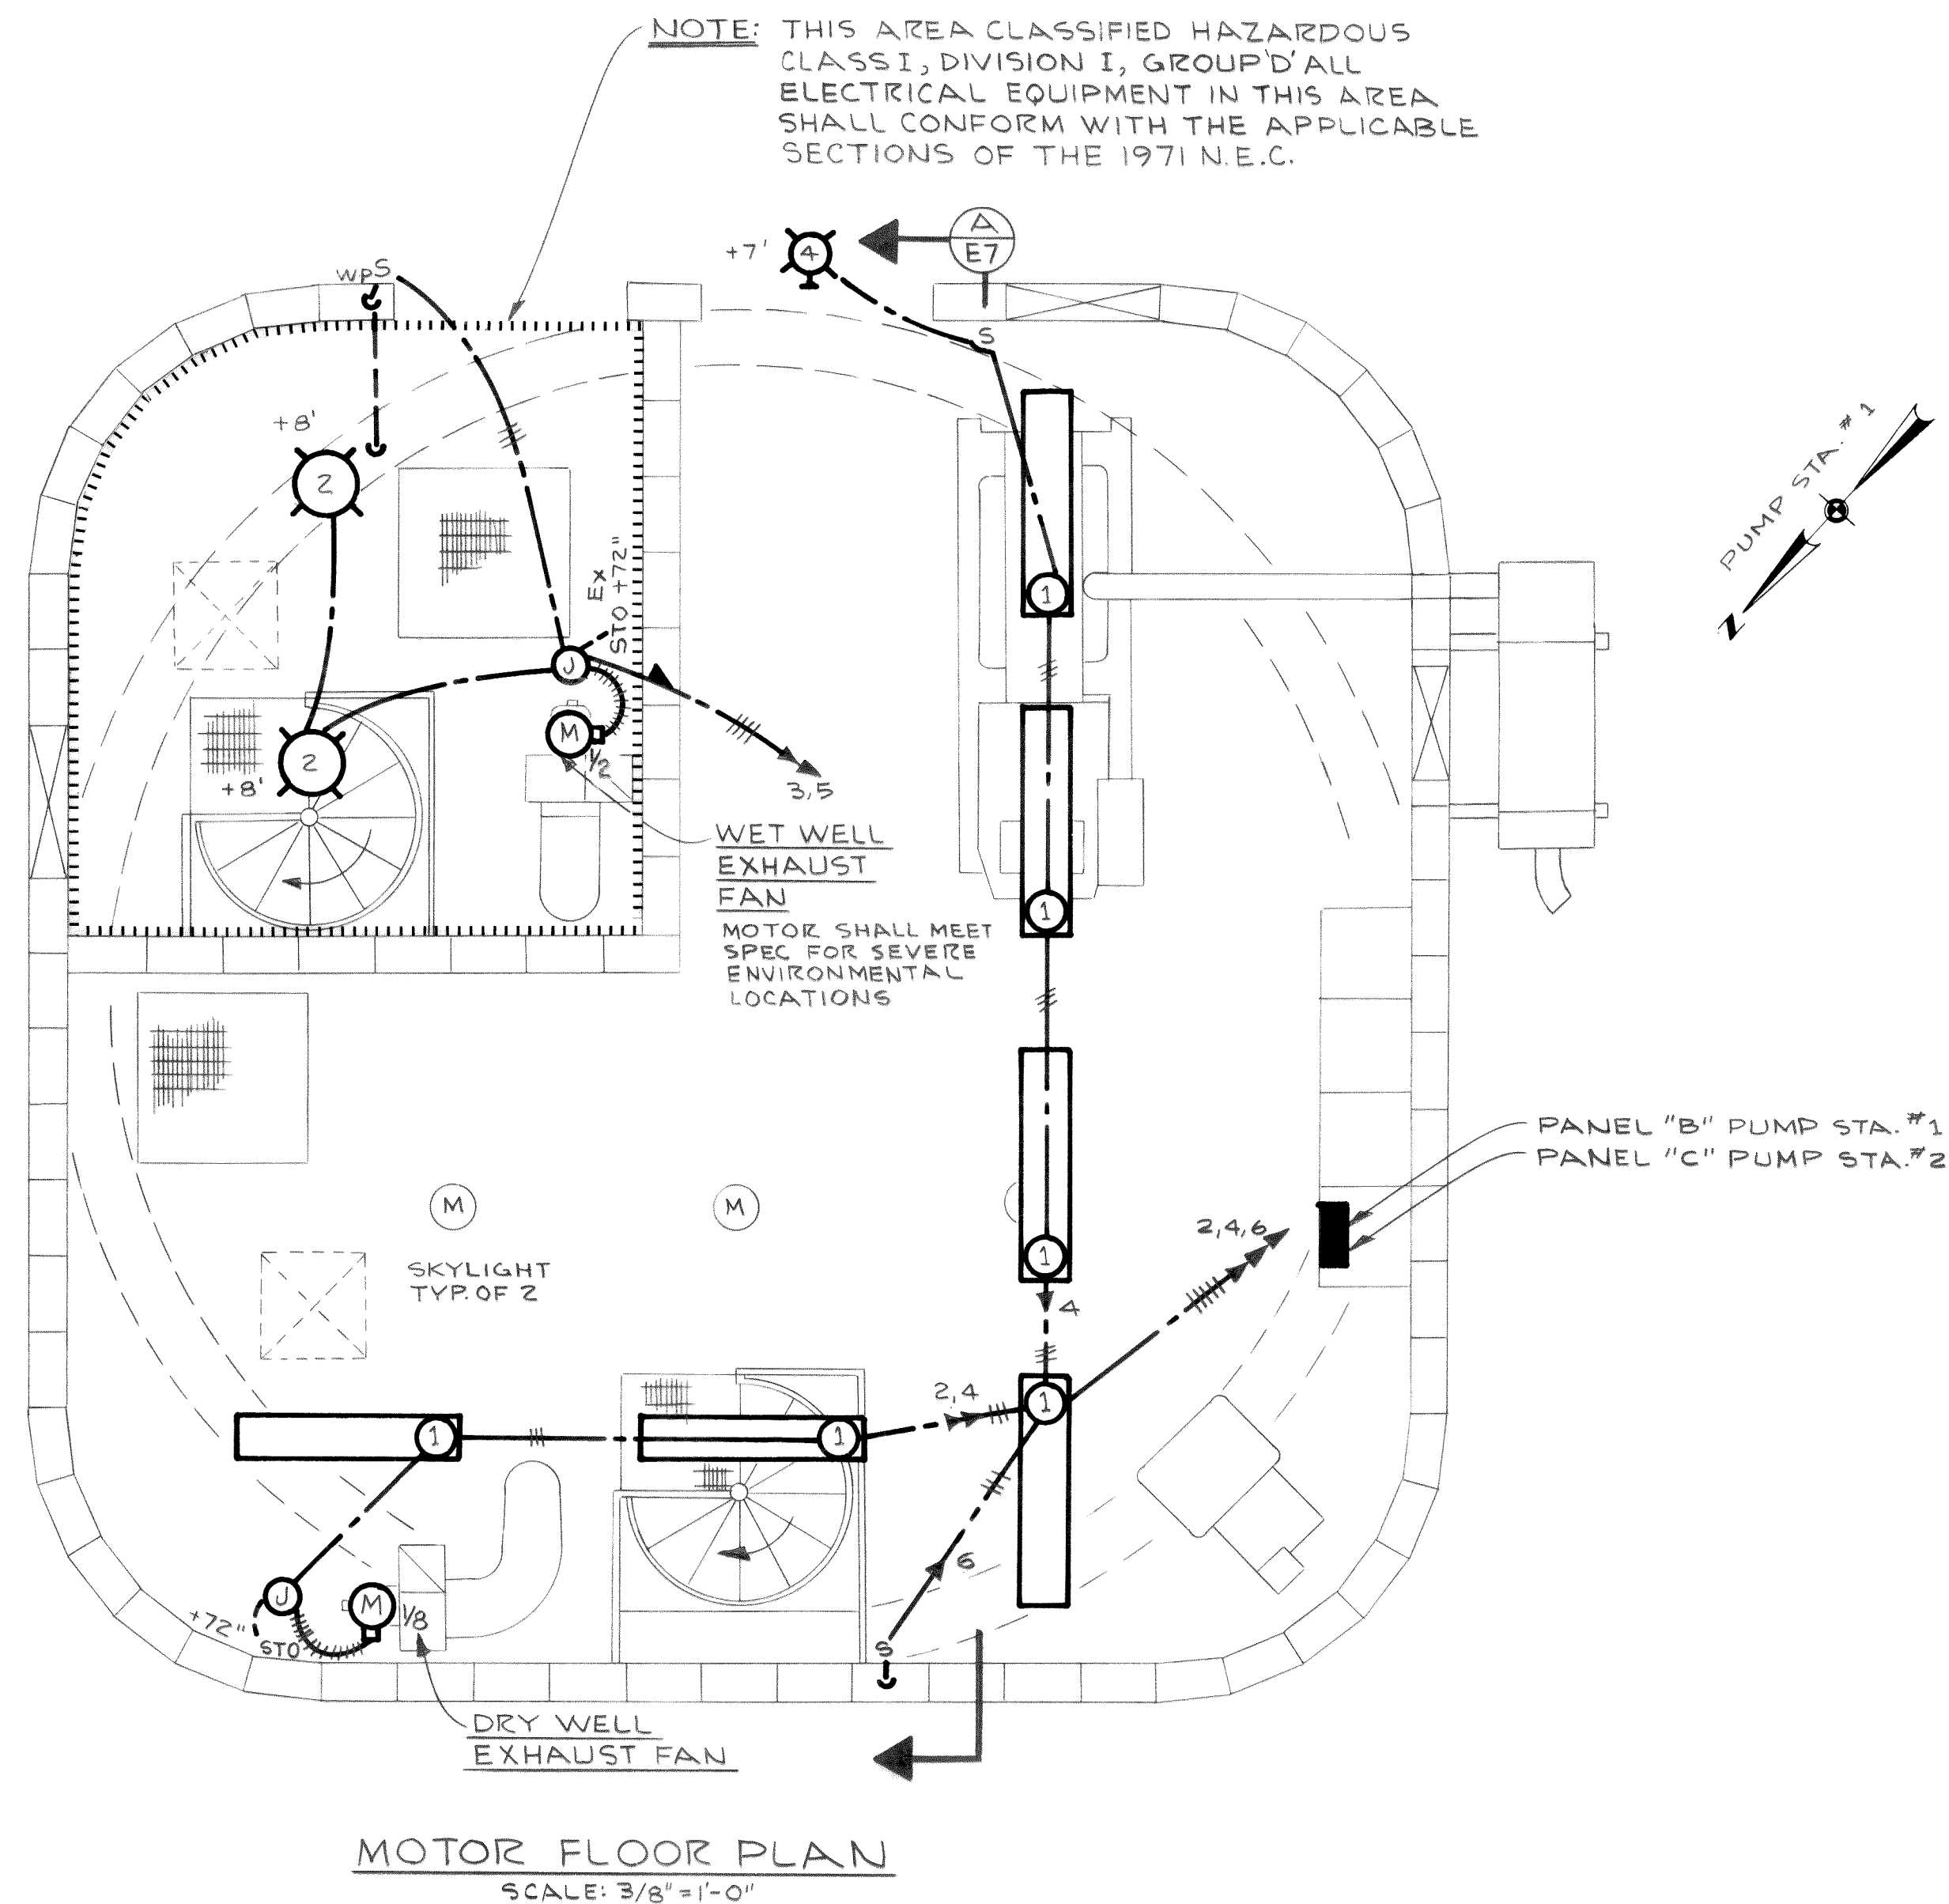


LIGHTING FIXTURE SCHEDULE						
FIXT NO.	MANUFACTURER	CATALOG NUMBER	LAMP QTY	LAMP TYPE	MOUNTING C R W P	REMARKS
1	HOLOPHANE	7200-4-LT-120	2	F40T12/R5	●	
2	CROUSE-HINDS	EVA 2015	1	A-23-200WIF	●	USE EXTENDED SERVICE LAMP
3	HOLOPHANE	904-120	1	H39-22KC/DX	●	
4	HOLOPHANE	412-120-PR	1	H38-4JA/DX	●	

C-CEILING P-PENDANT (MOUNTING HIGHT TO BOTTOM OF FIXTURE)
R-RECESSED W-WALL OR BRACKET (MOUNTING HIGHT SHOWN ON PLAN)

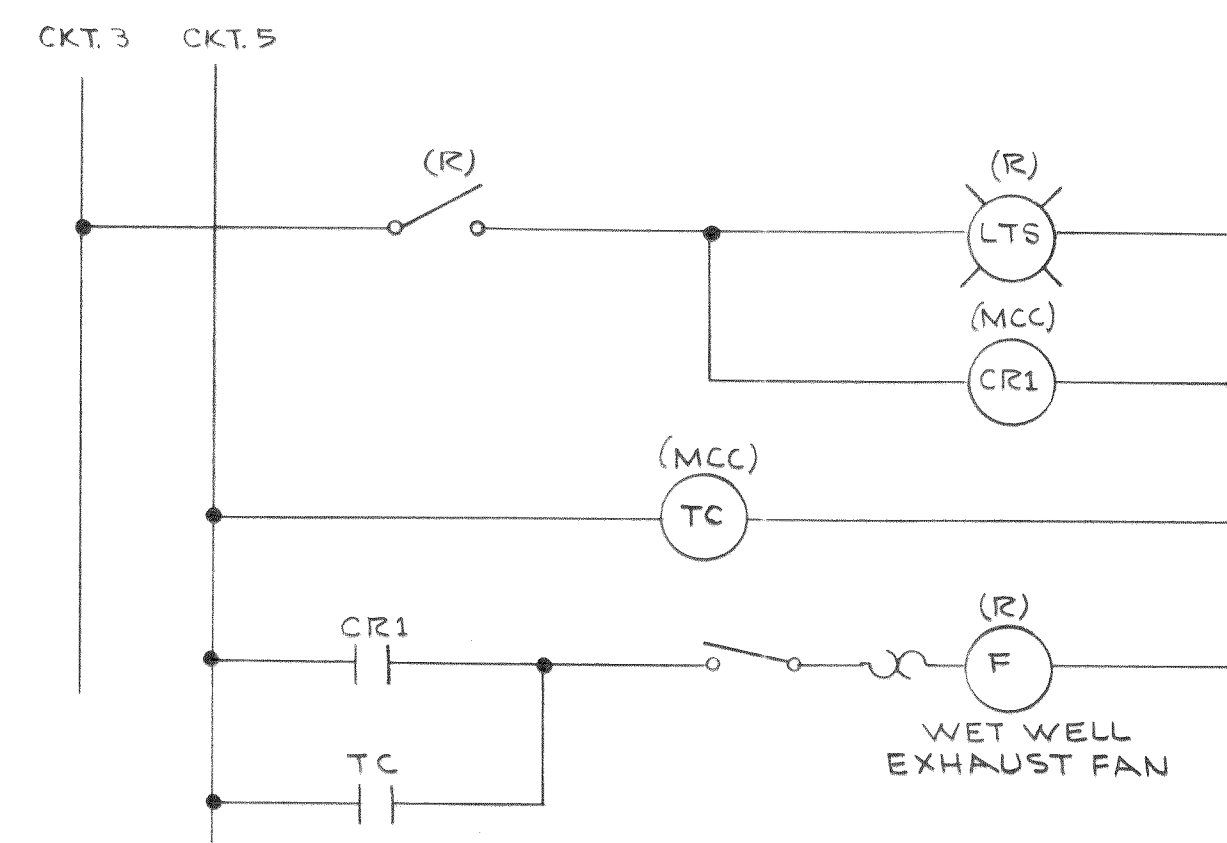

CONTROL SCHEMATIC NO. 7
LIGHTING & EXHAUST FAN WIRING DIAGRAM

NOTE: SHOWN FOR WET WELL EXHAUST FAN. DRY WELL EXHAUST FAN SHALL BE SIMILAR.

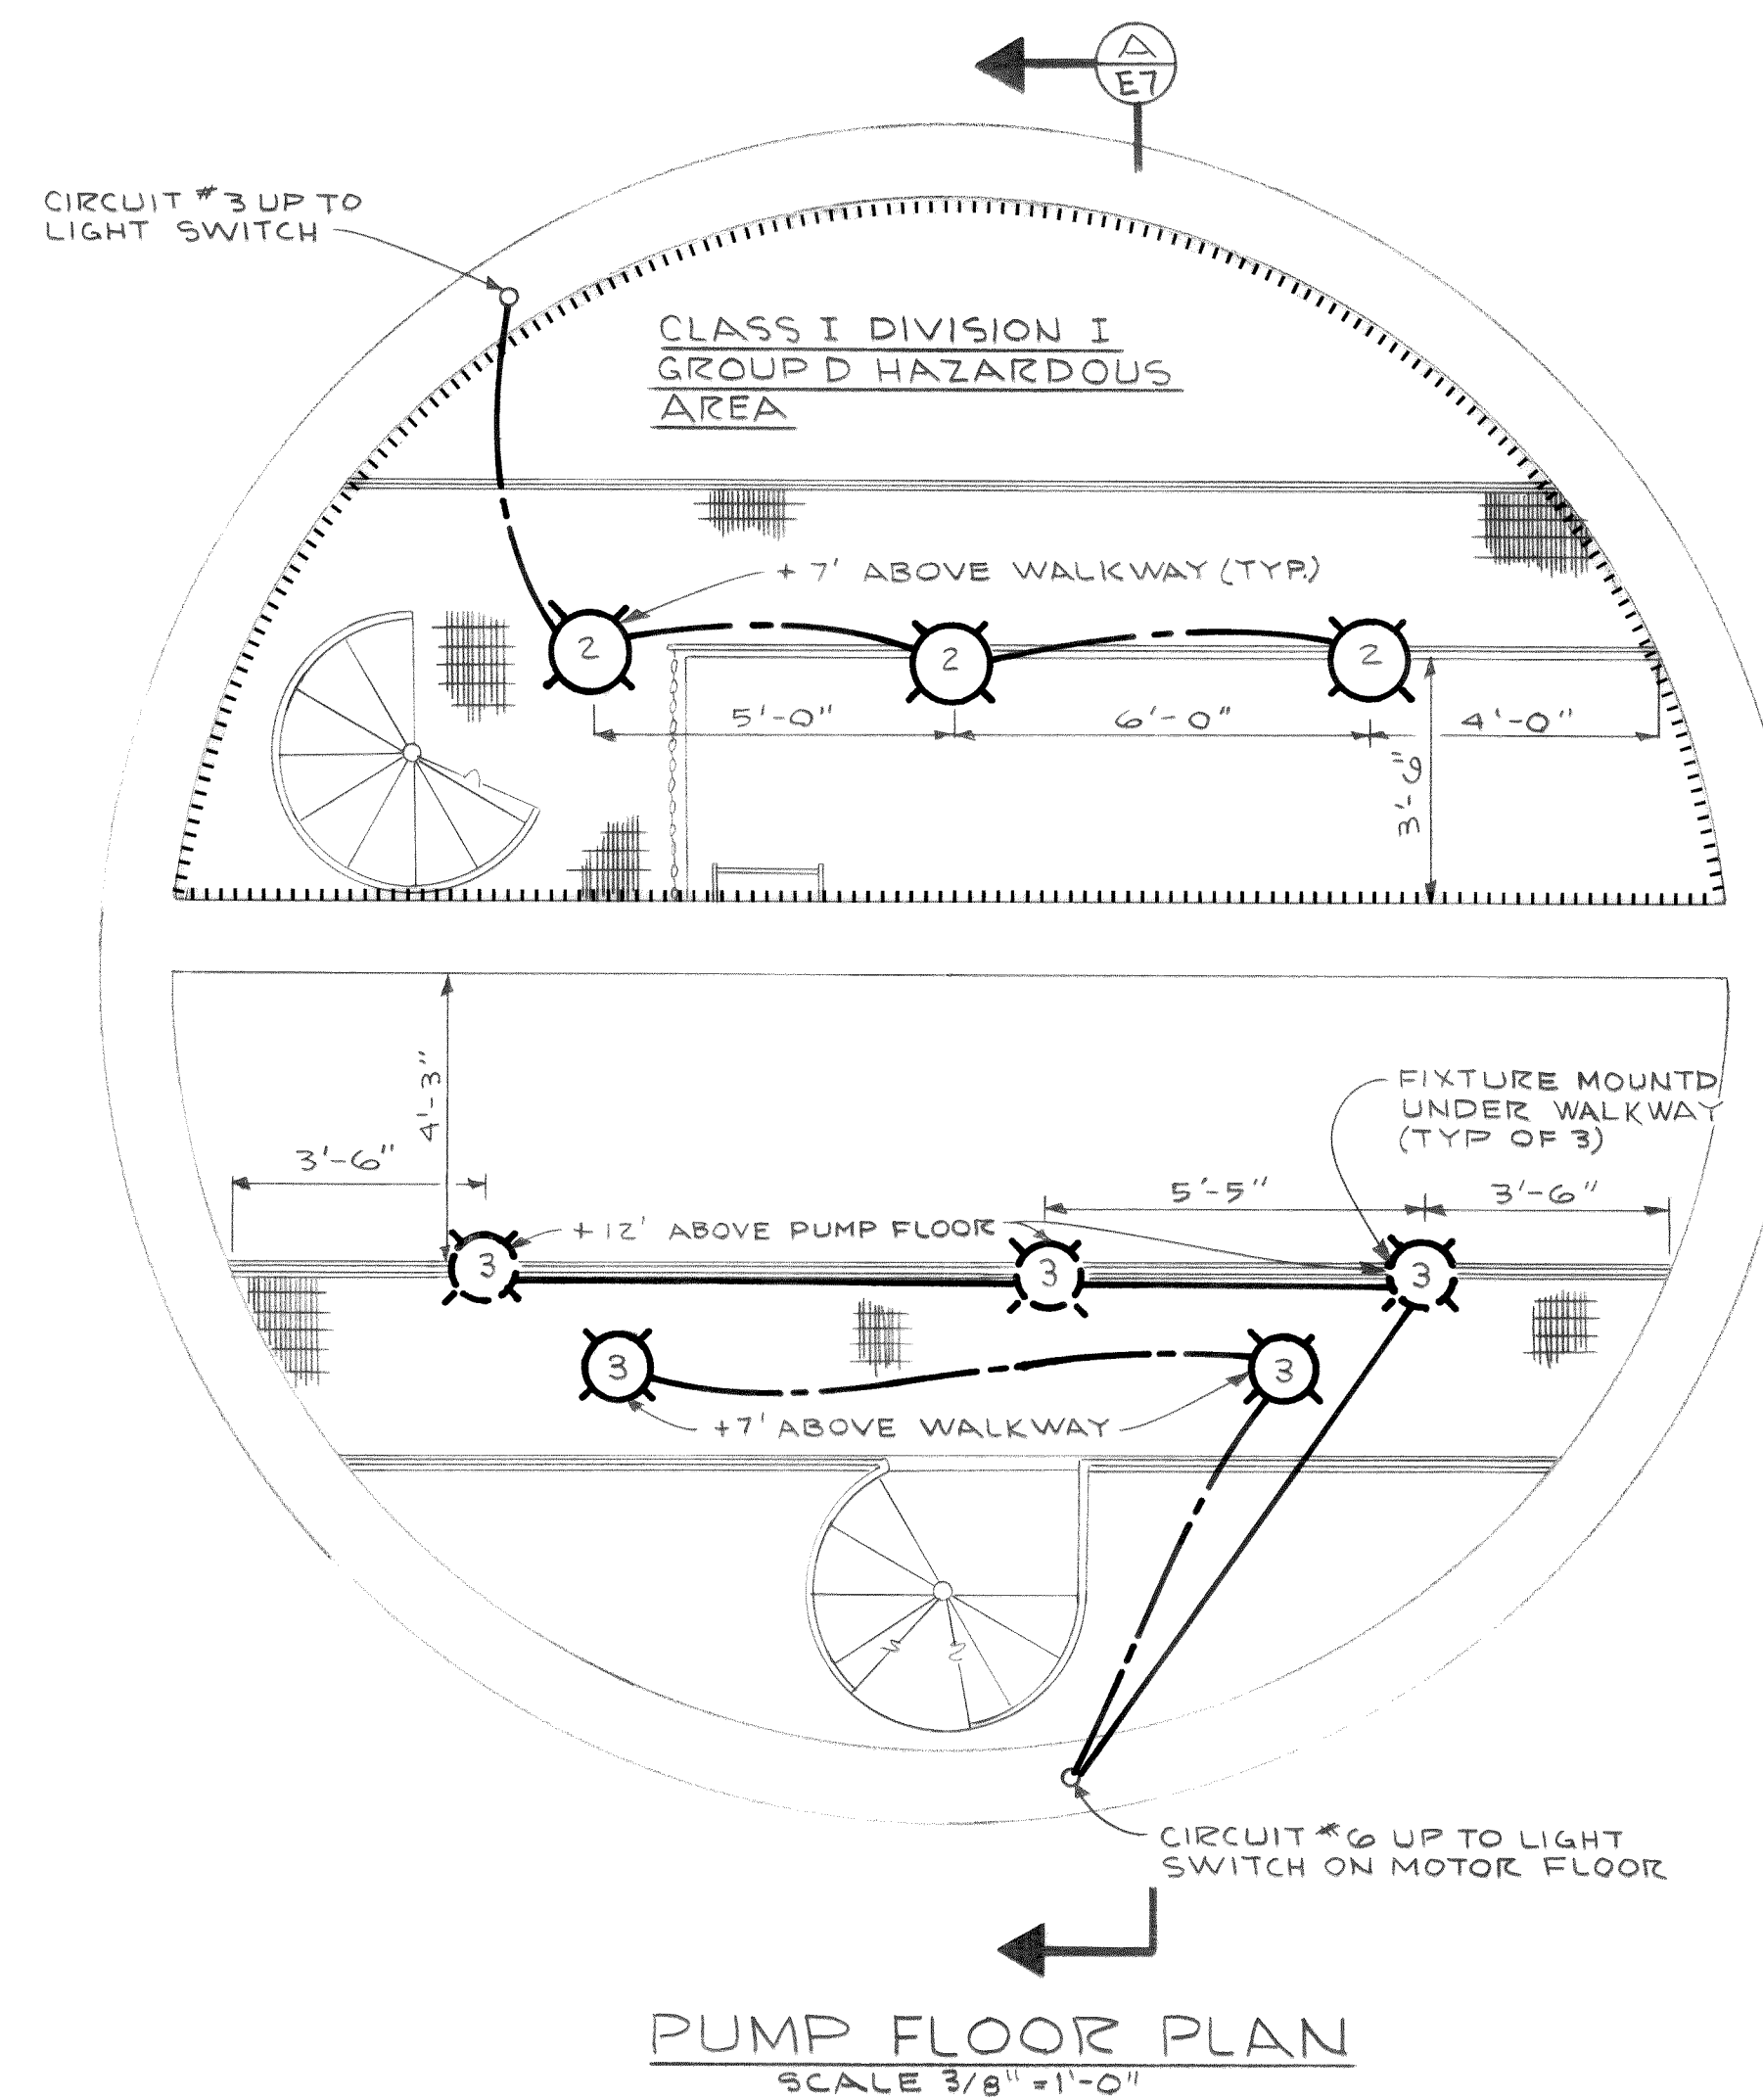

PANEL SCHEDULE								
PANEL	VOLTS	MAIN LUG RATING	MOUNTING	CKT. NO.	BRANCH CKT BRKR RATING	NO. OF ACTIVE CKTS	NO. OF SPARE CKTS	REMARKS
B	208Y/120V 3Ø, 4W	50	IN MCC	1-3, 6, 10	15/1	5	0	
C	208Y/120V 3Ø, 4W	50	IN MCC	4, 5, 7, 8, 9, 11-15	20/1	6	4	
				1-3, 6, 10	15/1	5	0	
				4, 5, 7, 8, 9, 11-15	20/1	6	4	

DESIGNED R.J.C.	APPROVED <i>Paul Hume</i>
DRAWN J.M.	SCALE AS SHOWN DATE JULY, 1972
DATE NO. REVISION	BY CHECKED <i>AB</i> FILE 71-S-425.002

ST Stevens, Thompson & Runyan, Inc.
Engineers/Planners
PORTLAND SEATTLE BOISE


TOWN OF FERNDAL, WASHINGTON
AXTON ROAD INTERCEPTOR
SCHEDULE 1

PUMP STATION 1 AND 2
ELECTRICAL LIGHTING PLAN


E6
11

MICROFILMED

00210.028 2-7-06 PC

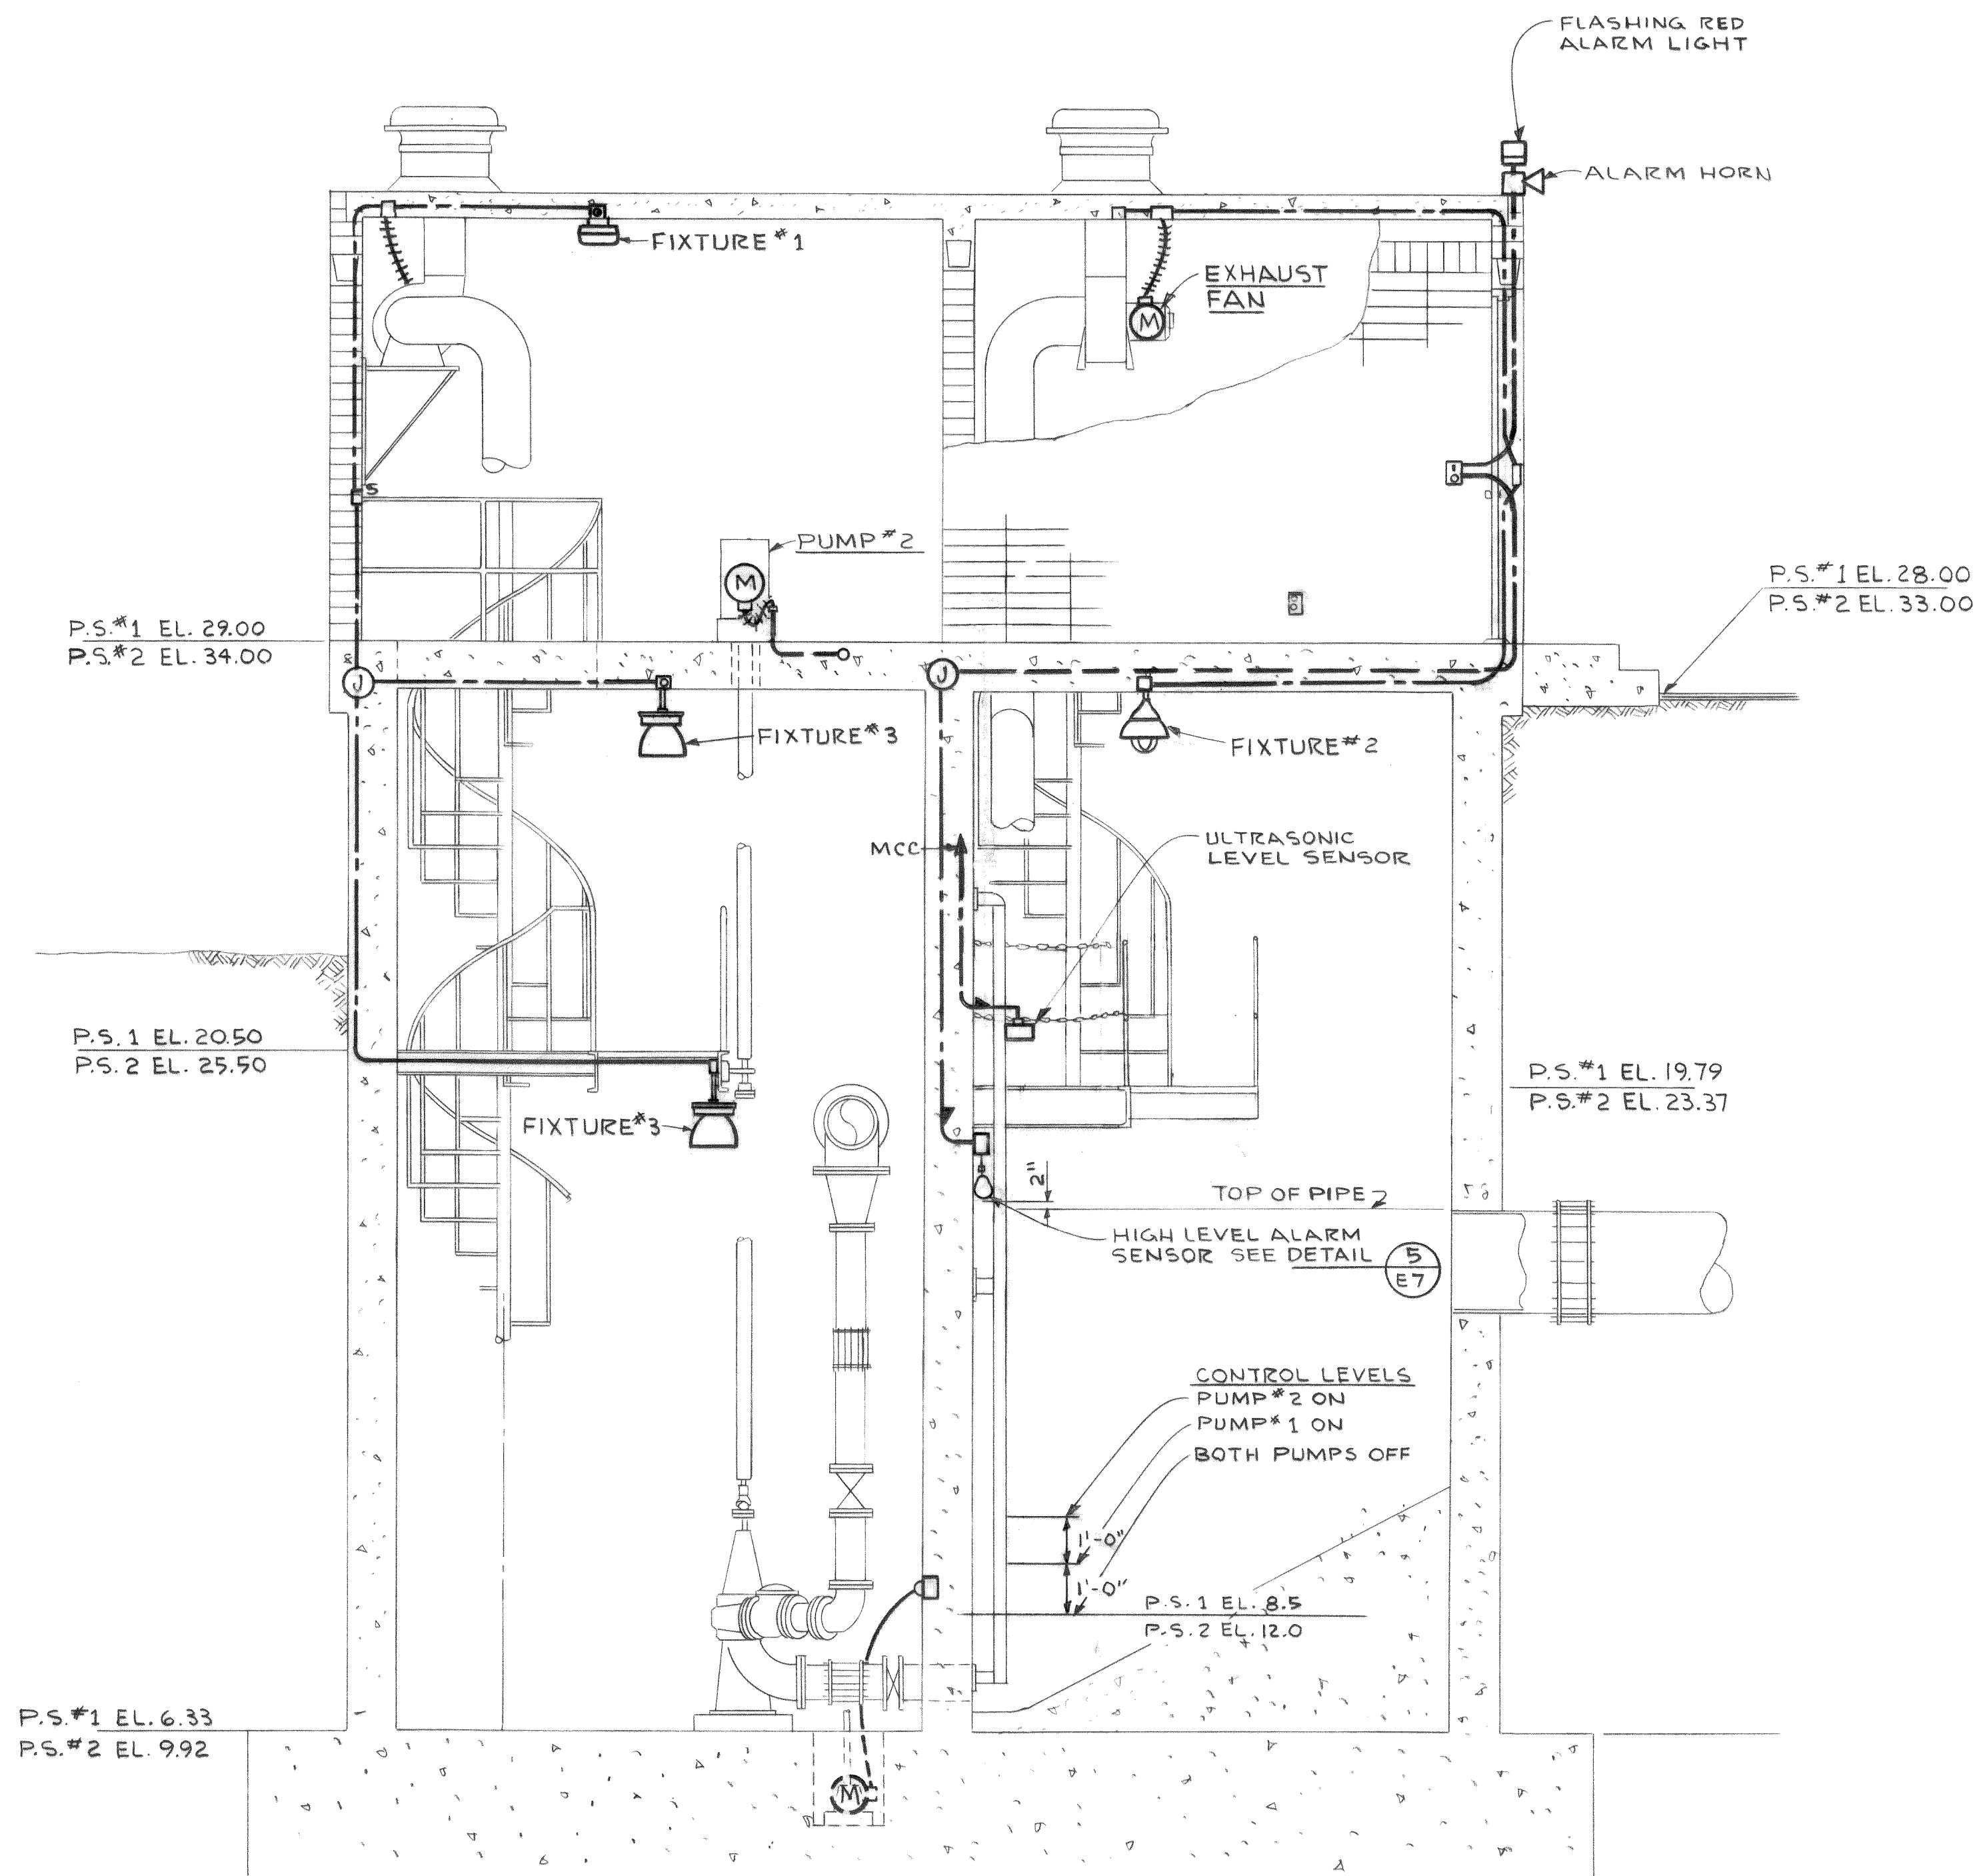


SECTION A
SCALE 3/8"=1'-0" E6

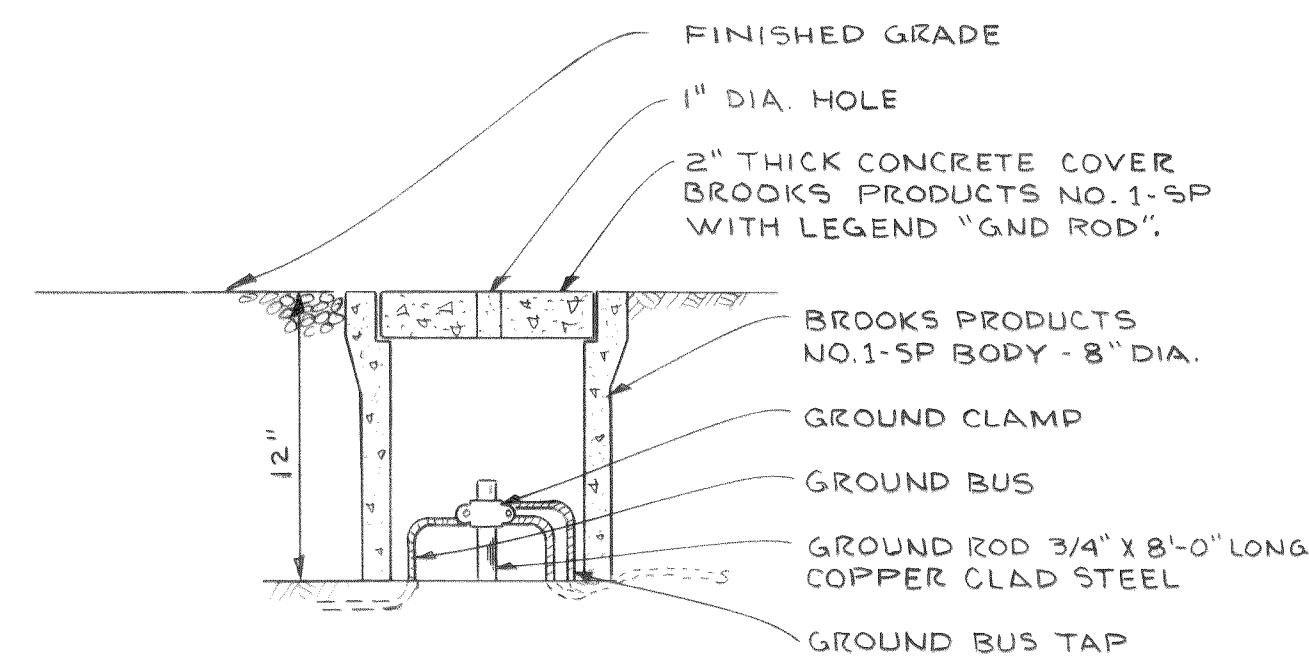


GROUND ROD INSTALLATION

DETAIL 1
SCALE 1 1/2"=1'-0" E3

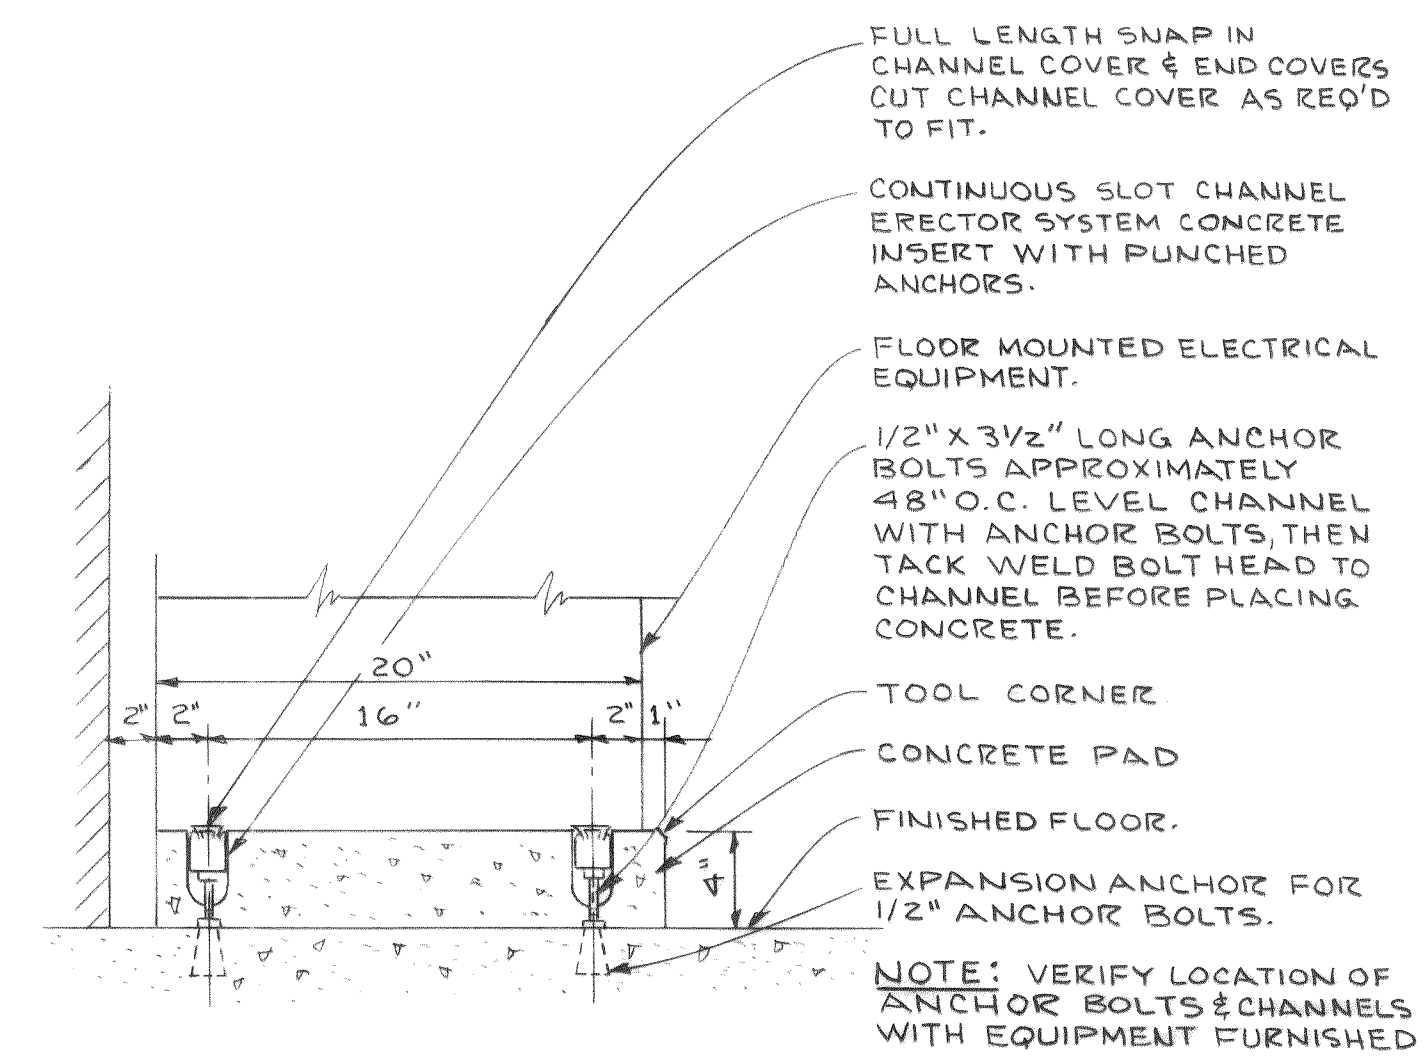


MOTOR CONTROL CENTER PAD

DETAIL 2
NO SCALE E3

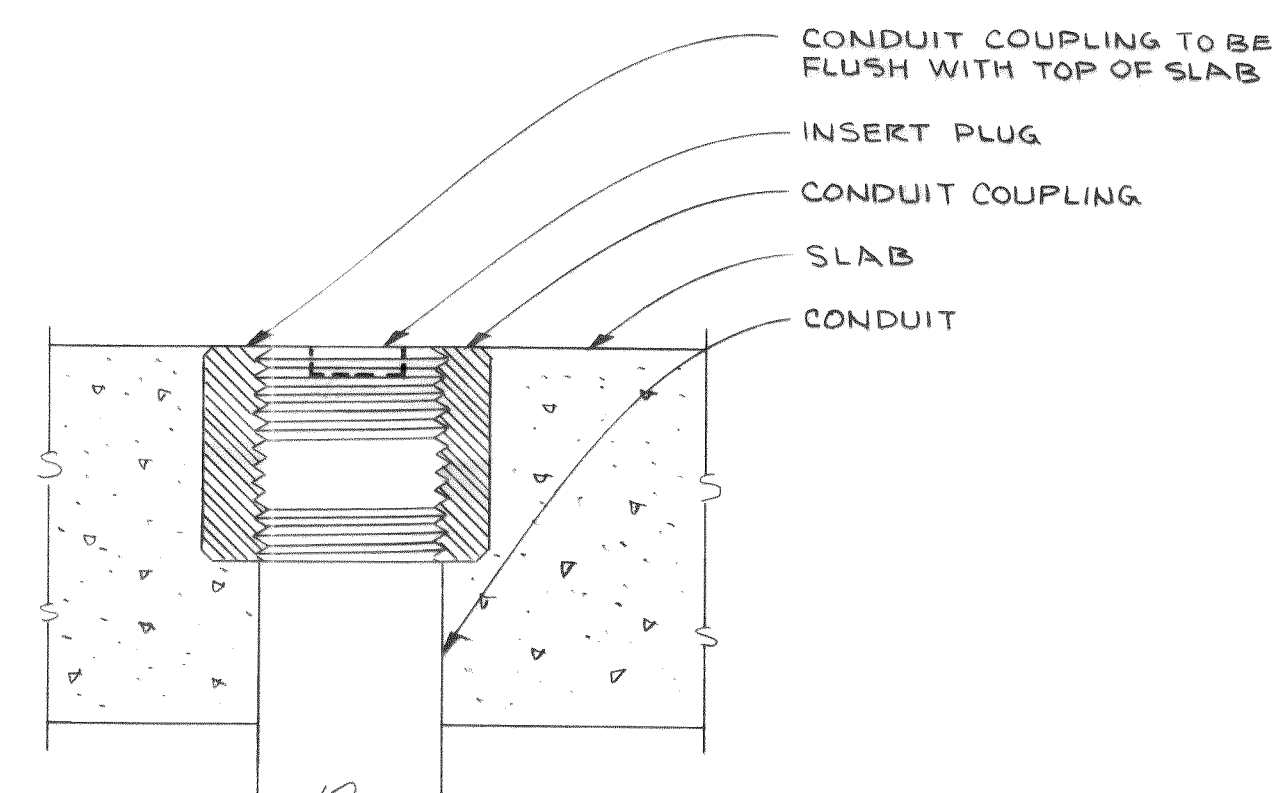


FUTURE CONDUIT TERMINATION


DETAIL 3
NO SCALE E8

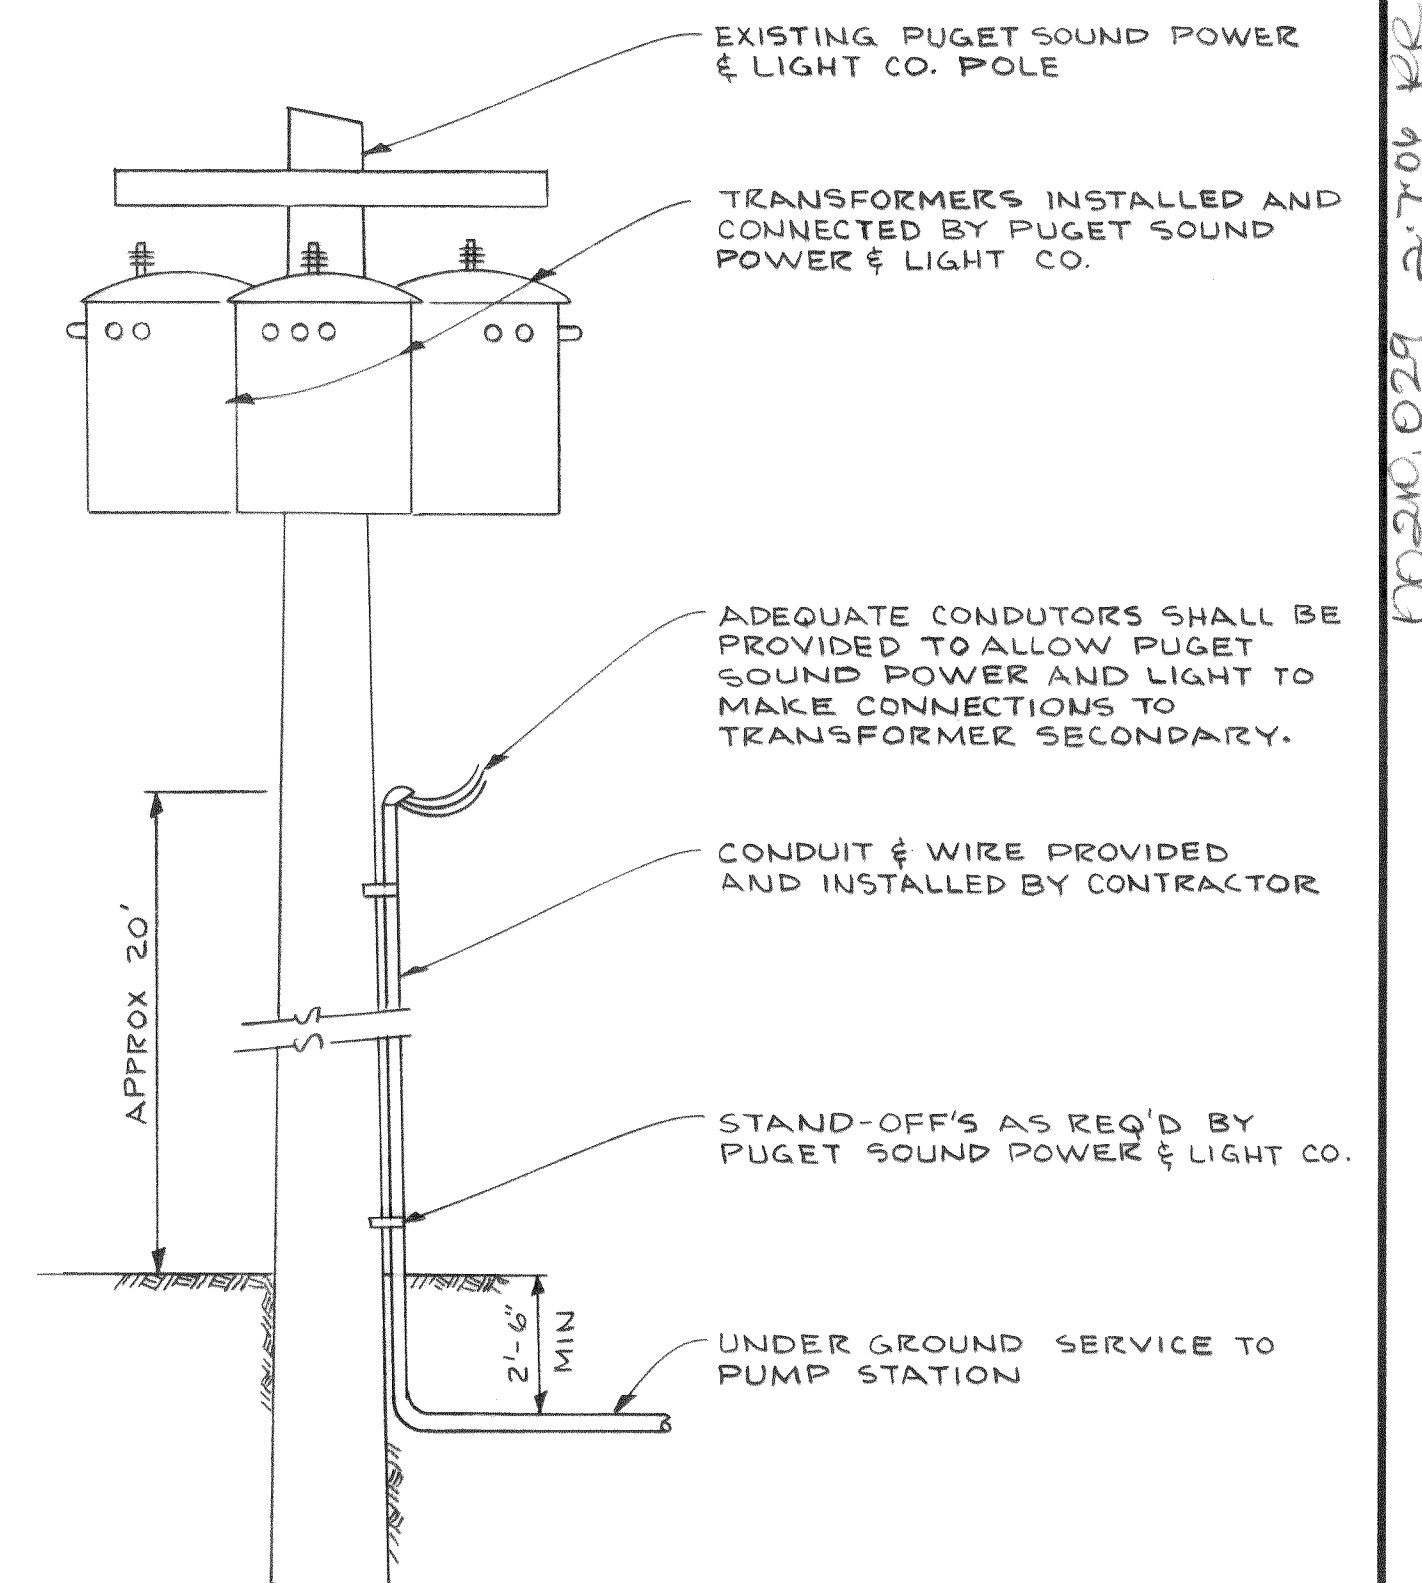

DETAIL 4
NO SCALE E1

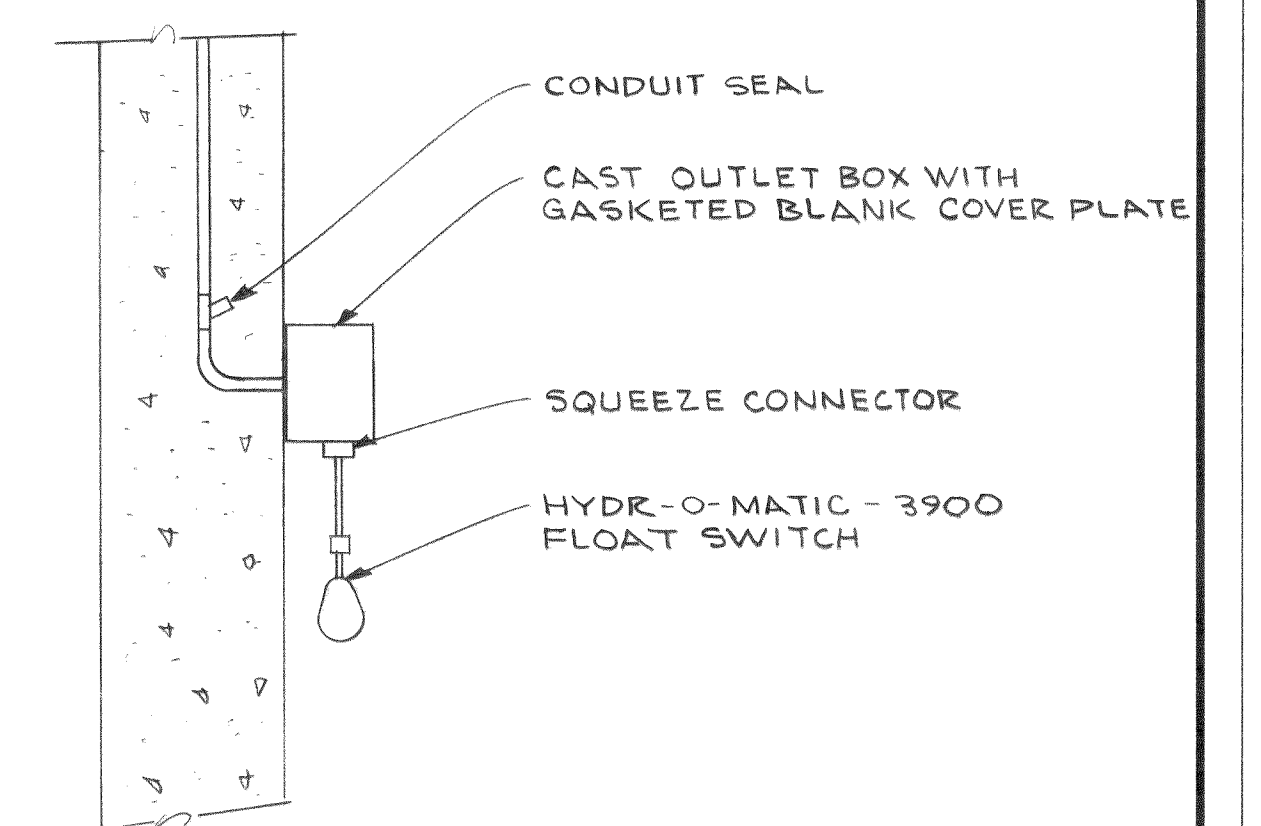

DETAIL 5
NO SCALE E7

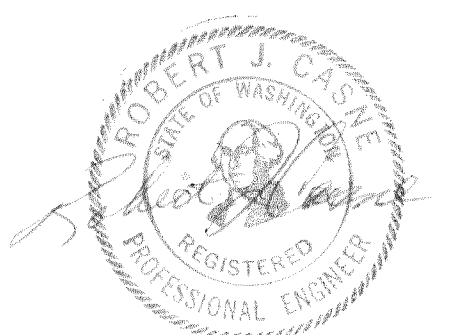

DESIGNED BY	R.J.C.	APPROVED	<i>Rich Casie</i>
DRAWN BY	J.M.	SCALE	AS SHOWN
DATE		DATE	JULY, 1972
REVISION		FILE	71-S-425.002



Stevens, Thompson & Runyan, Inc.
Engineers/Planners
PORTLAND SEATTLE BOISE




TOWN OF FERNDAL, WASHINGTON
AXTON ROAD INTERCEPTOR
SCHEDULE I

PUMP STATIONS 1 AND 2
ELECTRICAL SECTIONS & DETAILS

E7
11

MICROFILMED

00210.020 2-7-06 KE

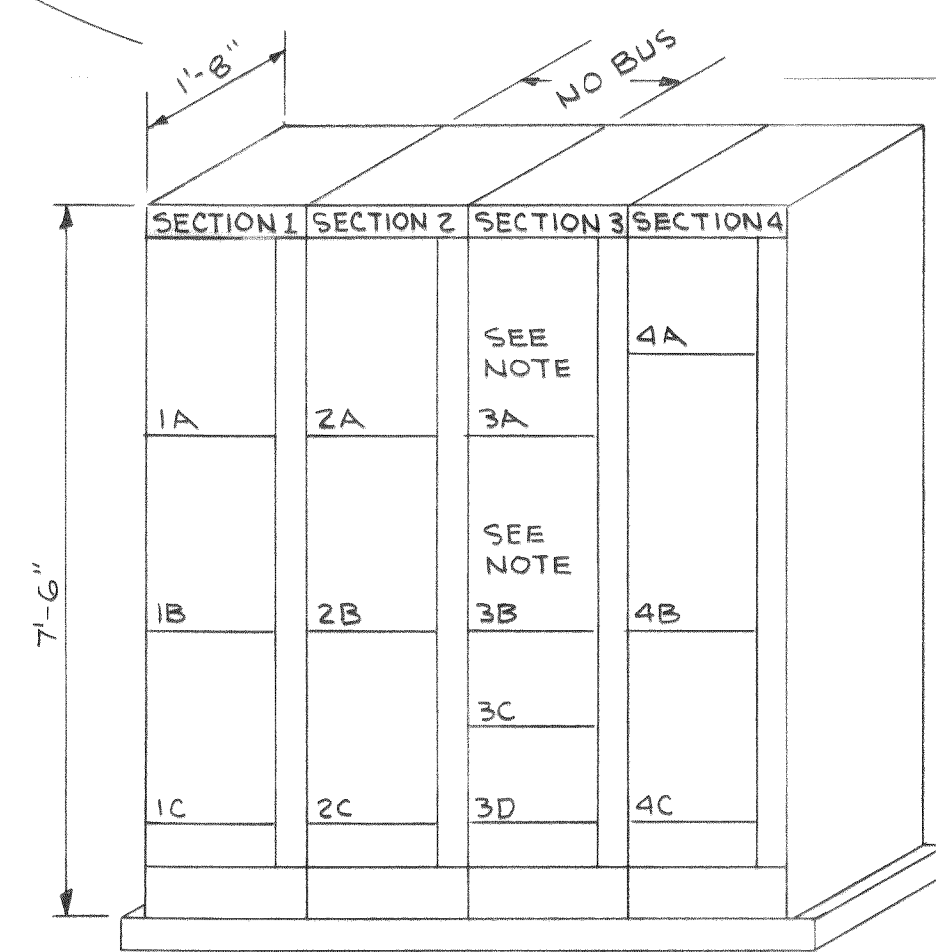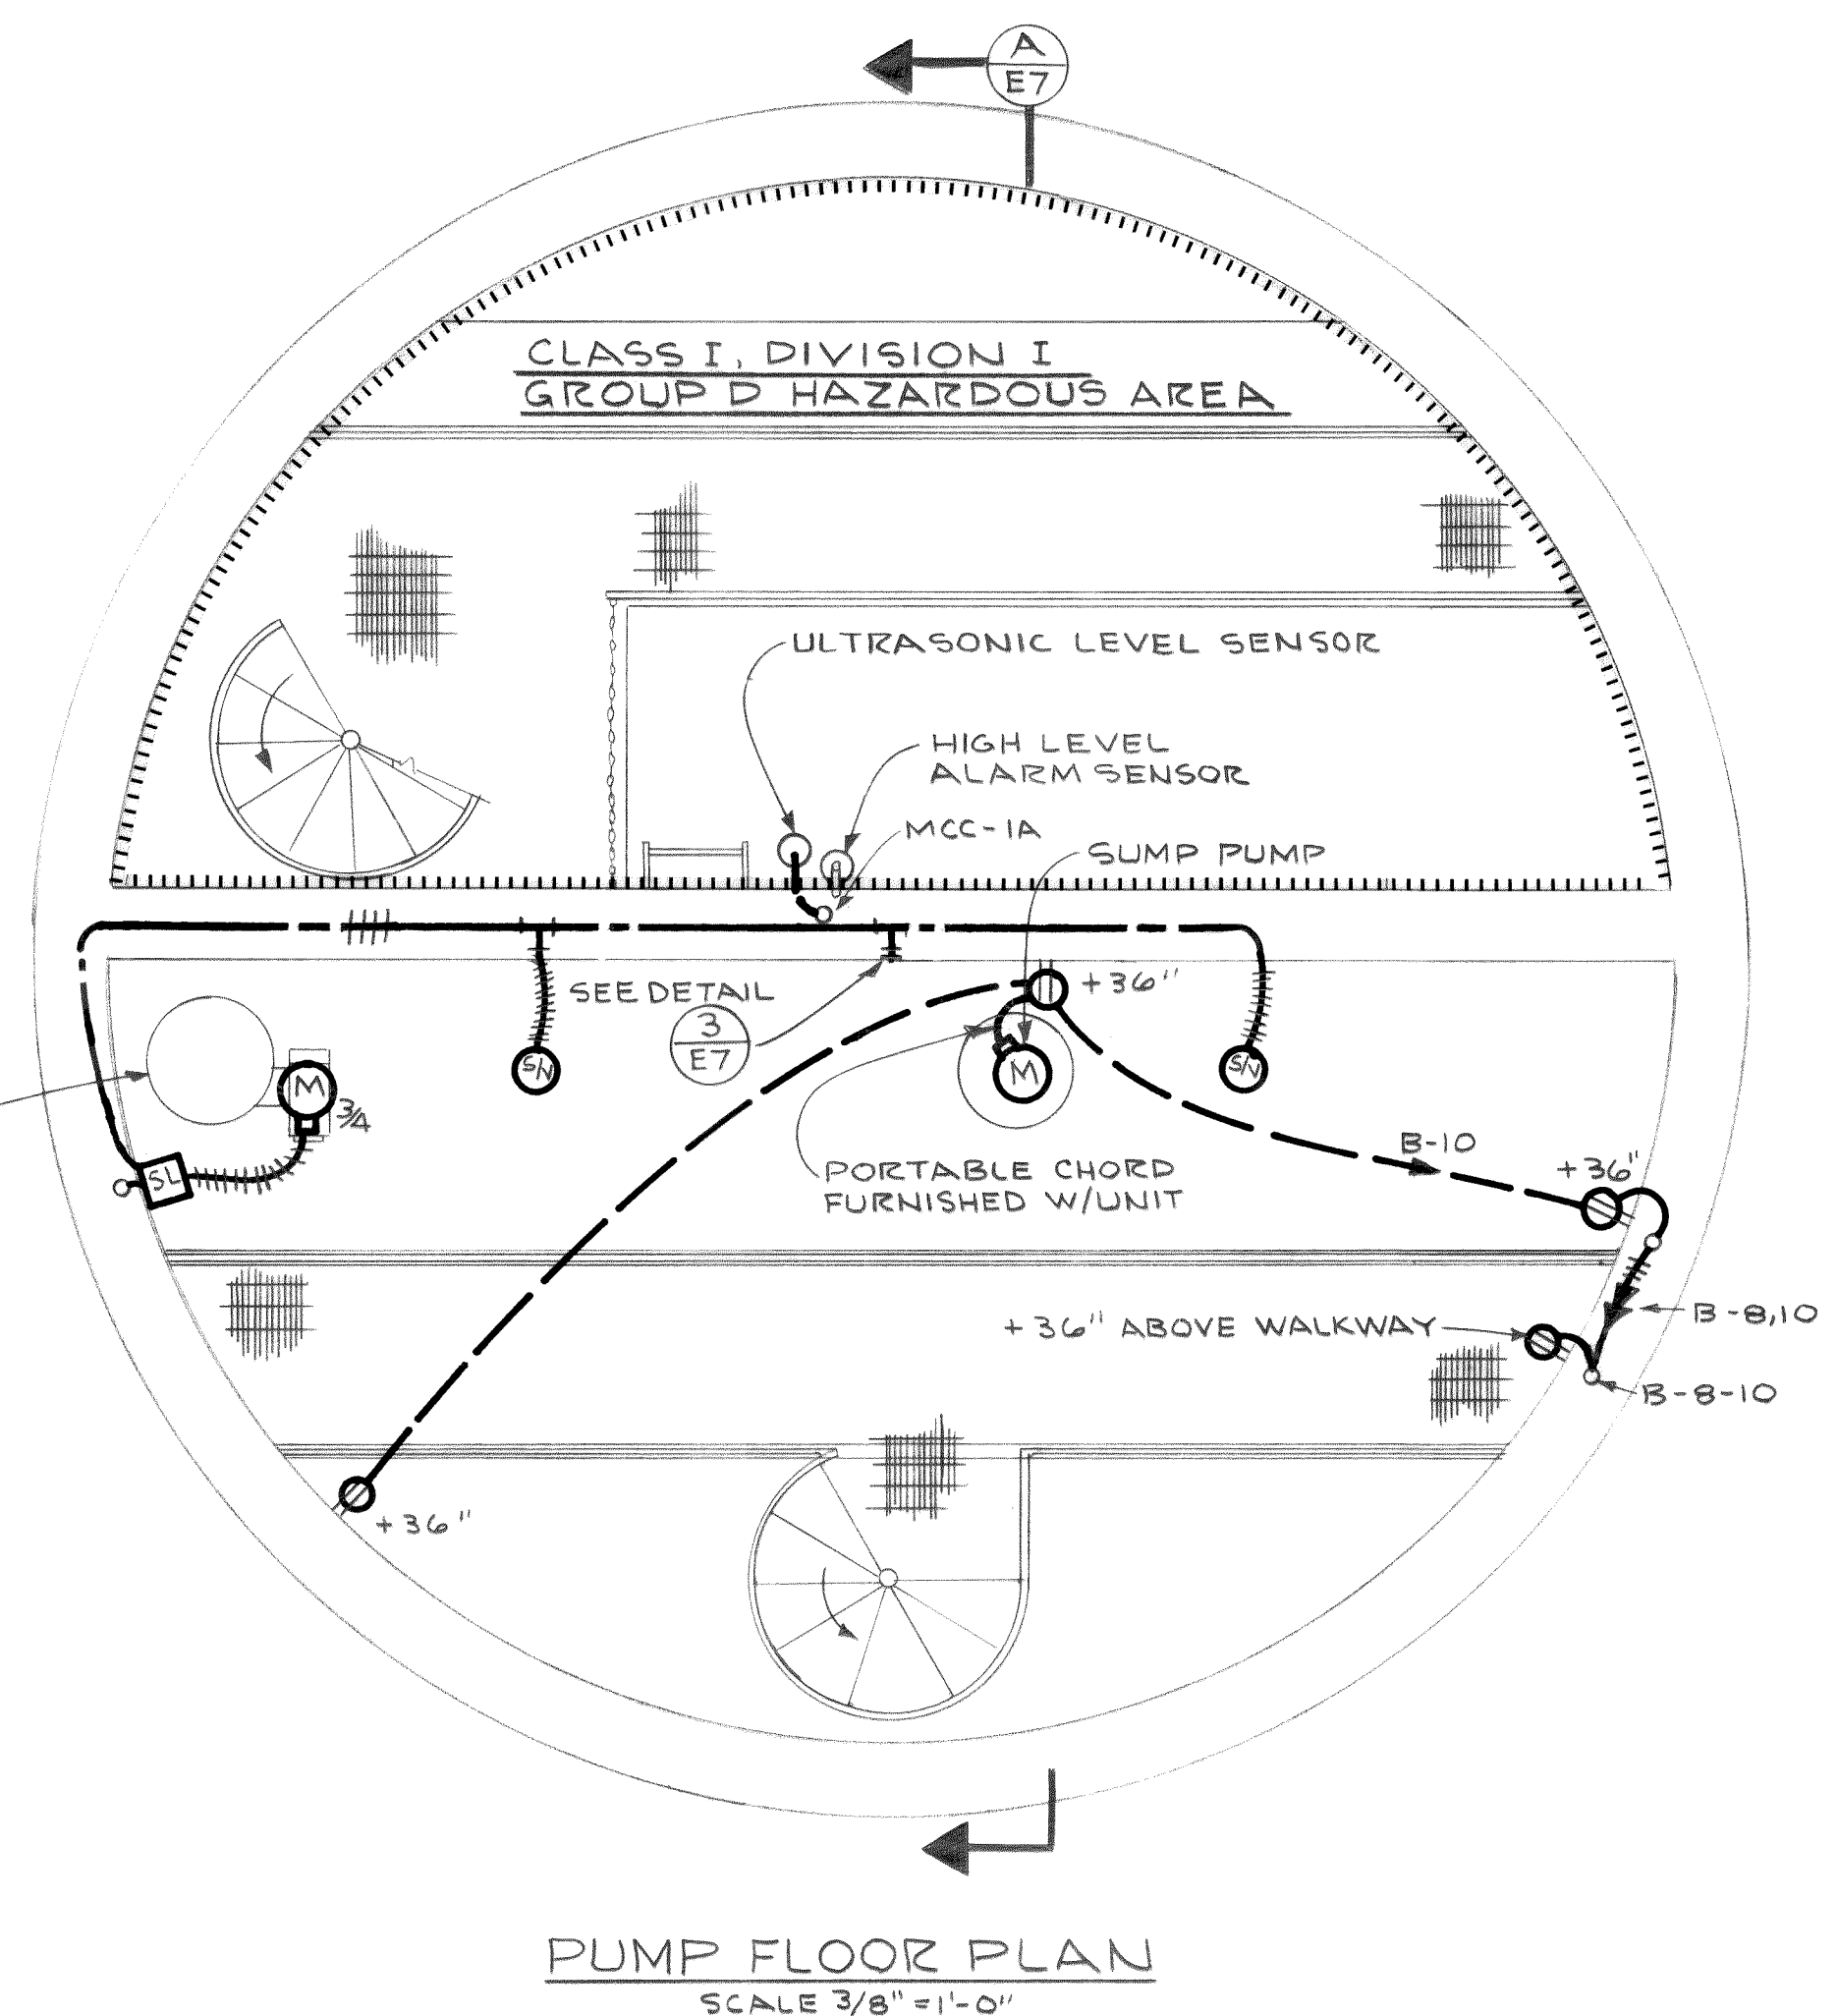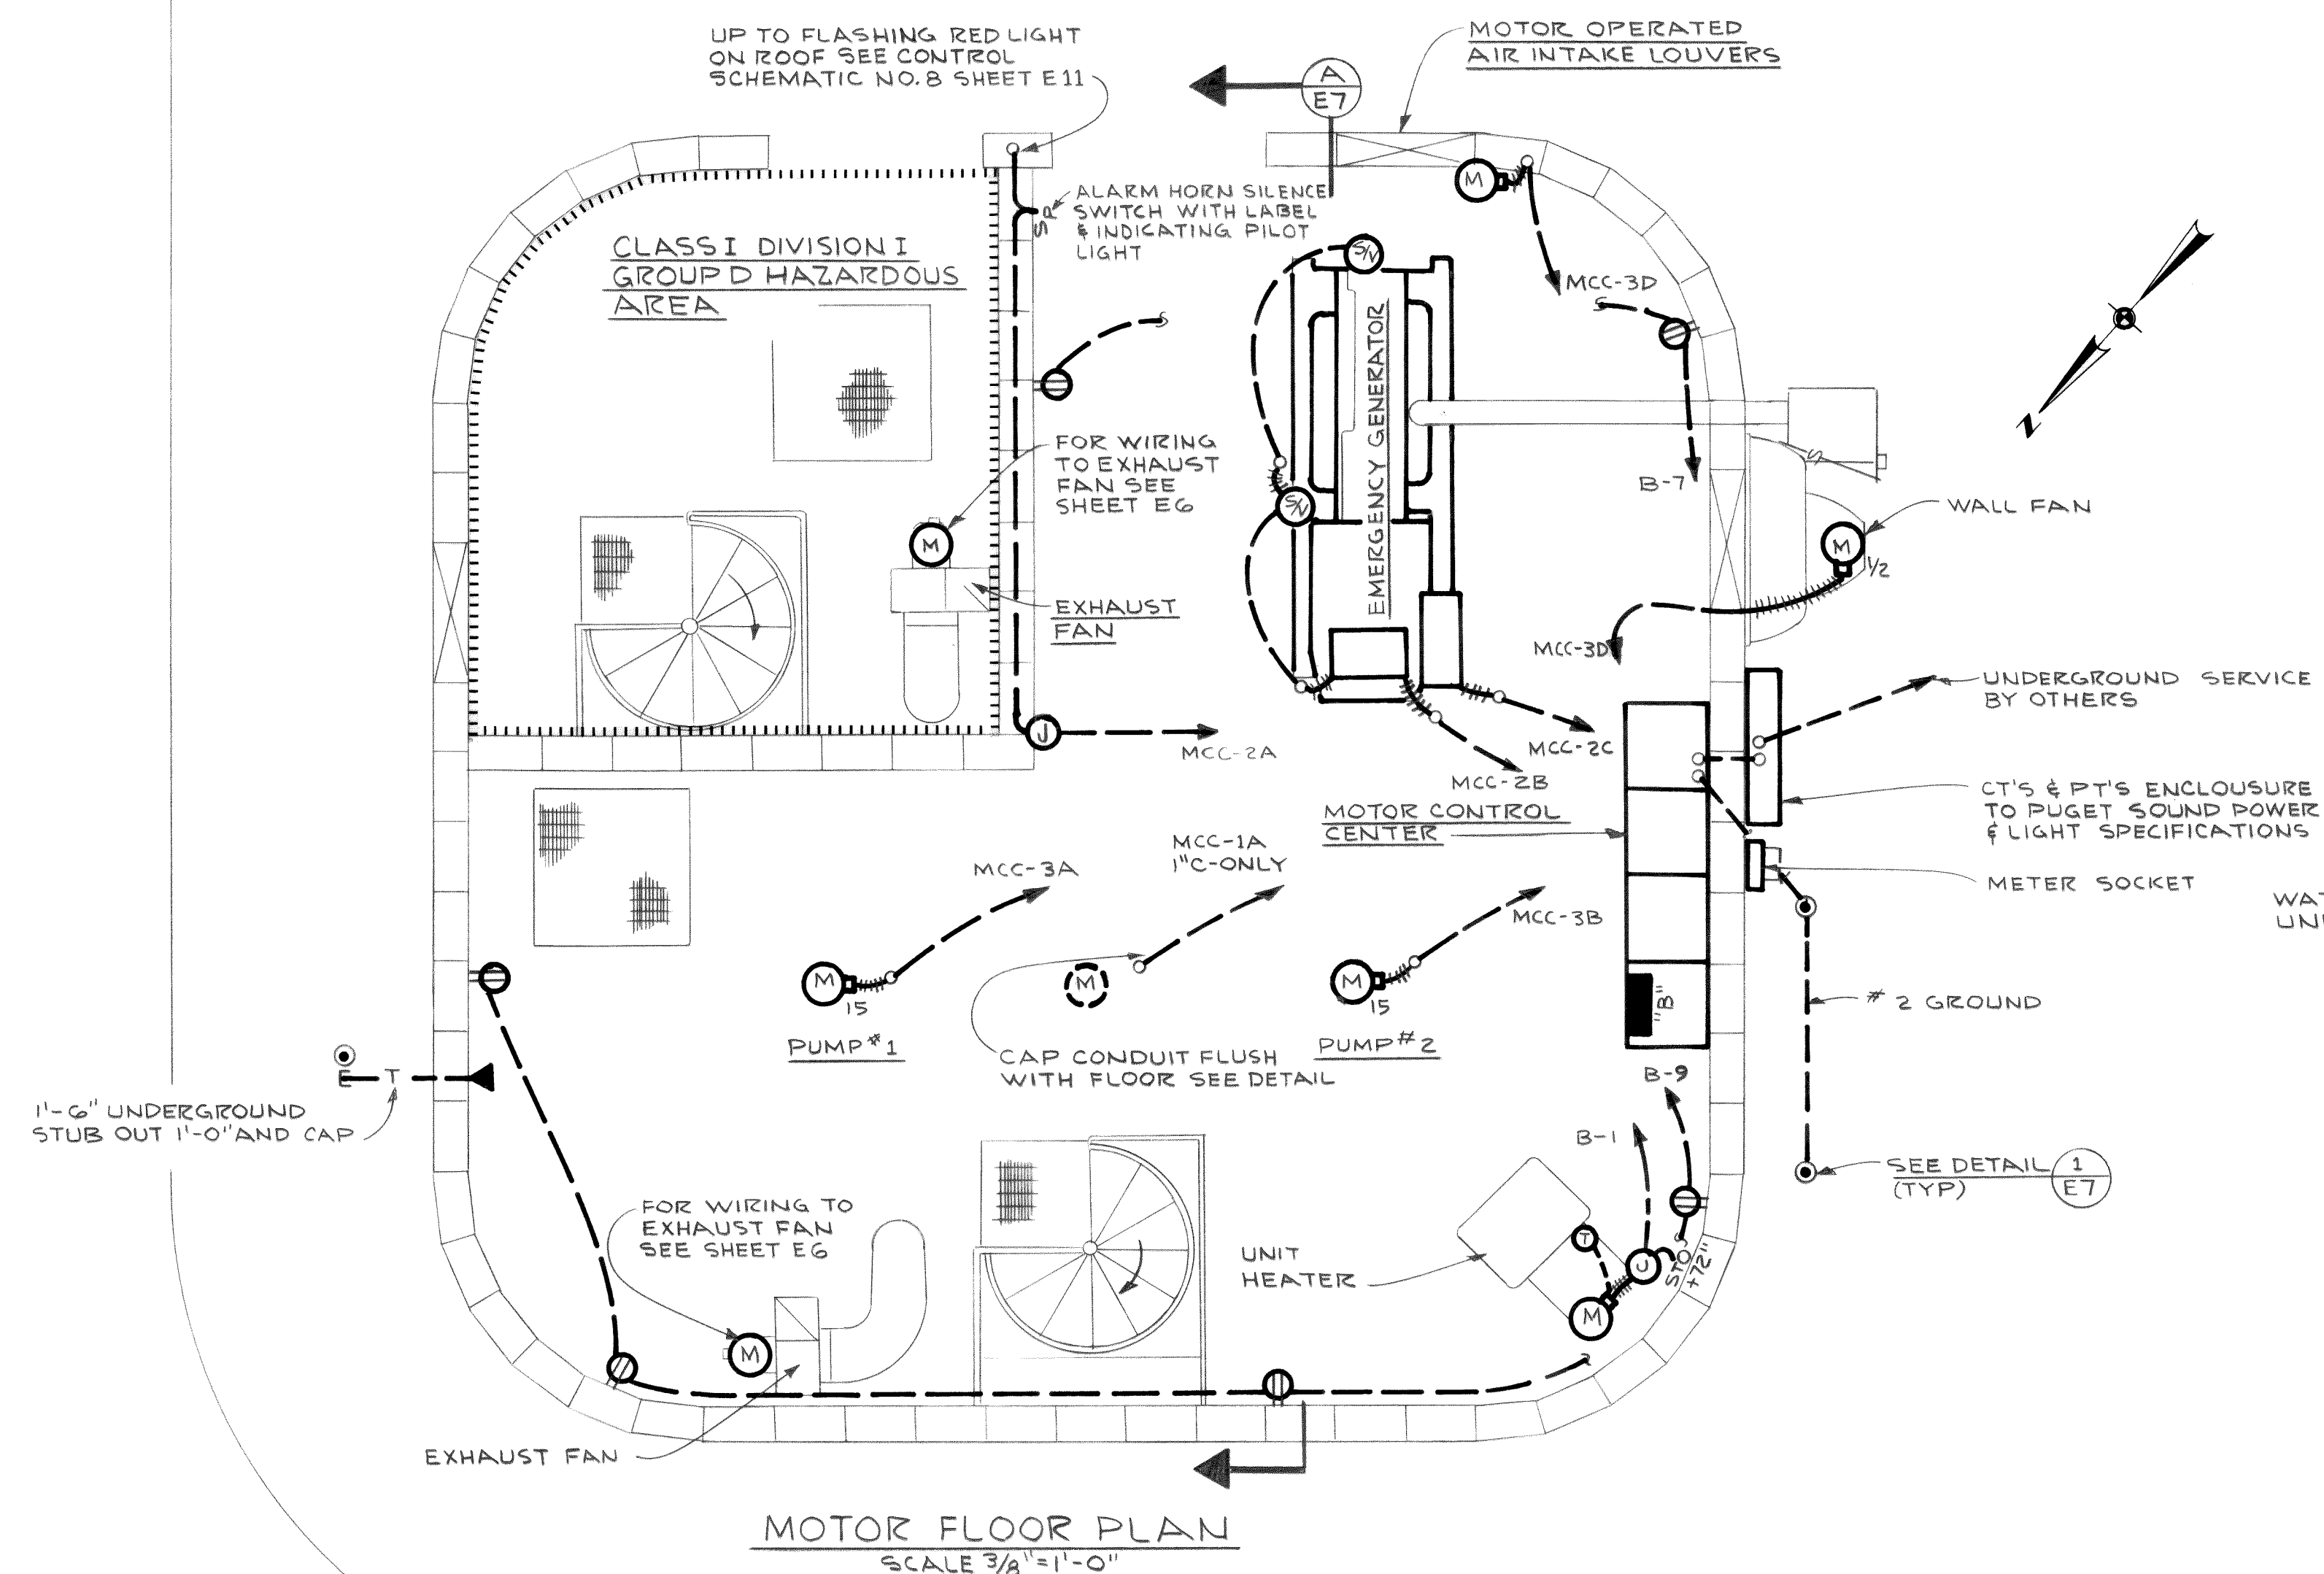

NOTE:
ADEQUATE SPACE SHALL BE ALLOWED IN MCC SO THAT 1/2 HP COMBINATION STARTERS MAY BE REPLACED WITH 40 HP COMBINATION STARTERS IN THE FUTURE.

SEE DETAIL 2 E7
FOR BASE


M.C.C. NAMEPLATE ENGRAVING SCHEDULE			
UNIT NO.	NAMEPLATE ENGRAVING SIZE 1" X 2 1/2" 16 CHARACTERS PER LINE MAX		
	FIRST LINE	SECOND LINE	THIRD LINE
1A	PUMP LEVEL	CONTROL	
1B			
1C	MAIN BREAKER		
2A	AUTOMATIC	TRANSFER SWITCH	CONTROL PANEL
2B	AUTOMATIC	TRANSFER SWITCH	
2C	GENERATOR	BREAKER	
3A	PUMP #1		
3B	PUMP #2		
3C	WATER SEAL PUMP		
3D	WALL FAN		
4A	LIGHTING	TRANSFORMER	BREAKER
4B	LIGHTING	PANEL "B"	
4C	LIGHTING	TRANSFORMER	208Y/120V, 3Ø, 4W

DESIGNED	R.J.C.	APPROVED	<i>Robert J. Cavan</i>
DRAWN	J.M.	SCALE	AS SHOWN
DATE		DATE	JULY, 1972
NO.		FILE	71-S-425.002
REVISION			

 **Stevens, Thompson & Runyan, Inc.**
Engineers/Planners
PORTLAND SEATTLE BOISE


TOWN OF FERNDAL, WASHINGTON
AXTON ROAD INTERCEPTOR
SCHEDULE I

PUMP STATION I
ELECTRICAL POWER PLAN

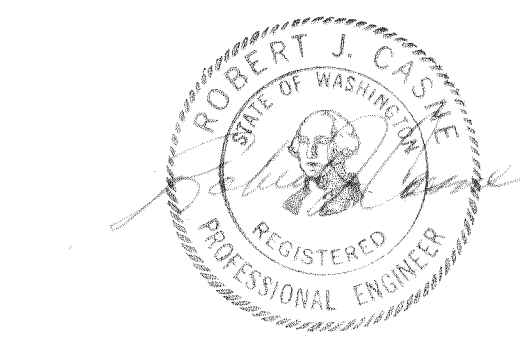


MICROFILMED


00210.031 2-7-06 K4

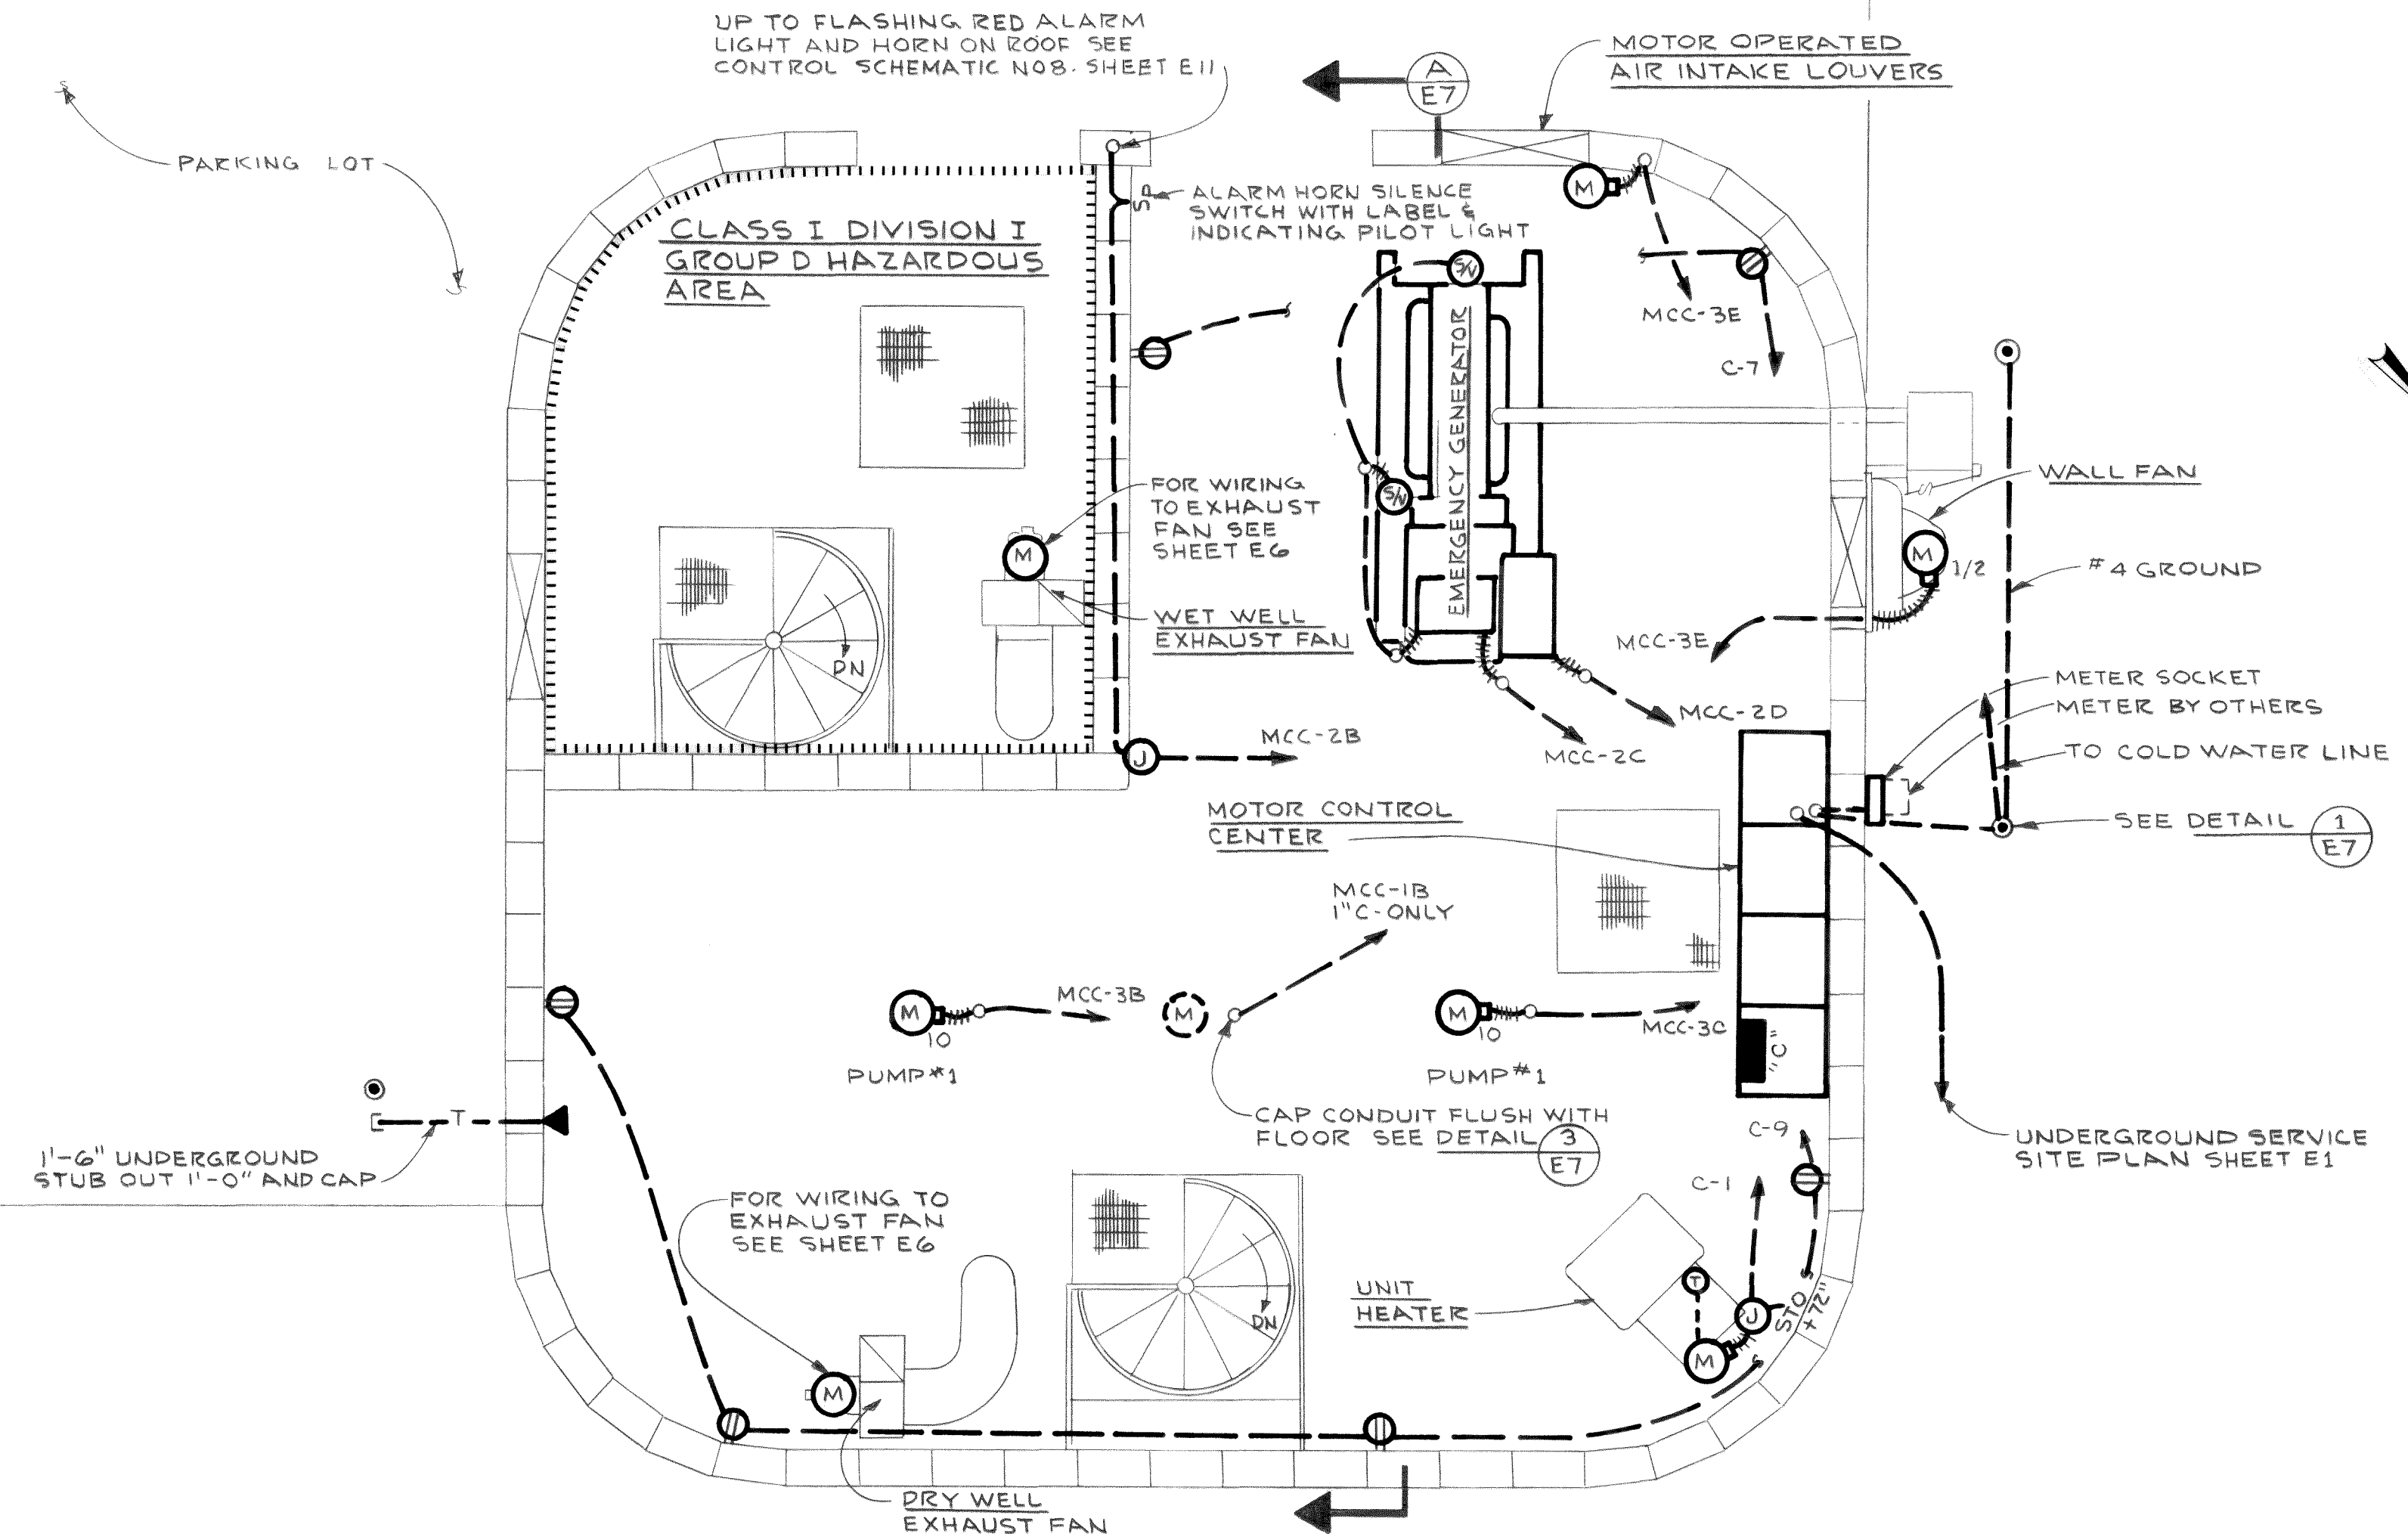

MOTOR ROOM FLOOR
SCALE 3/8" = 1'-0"

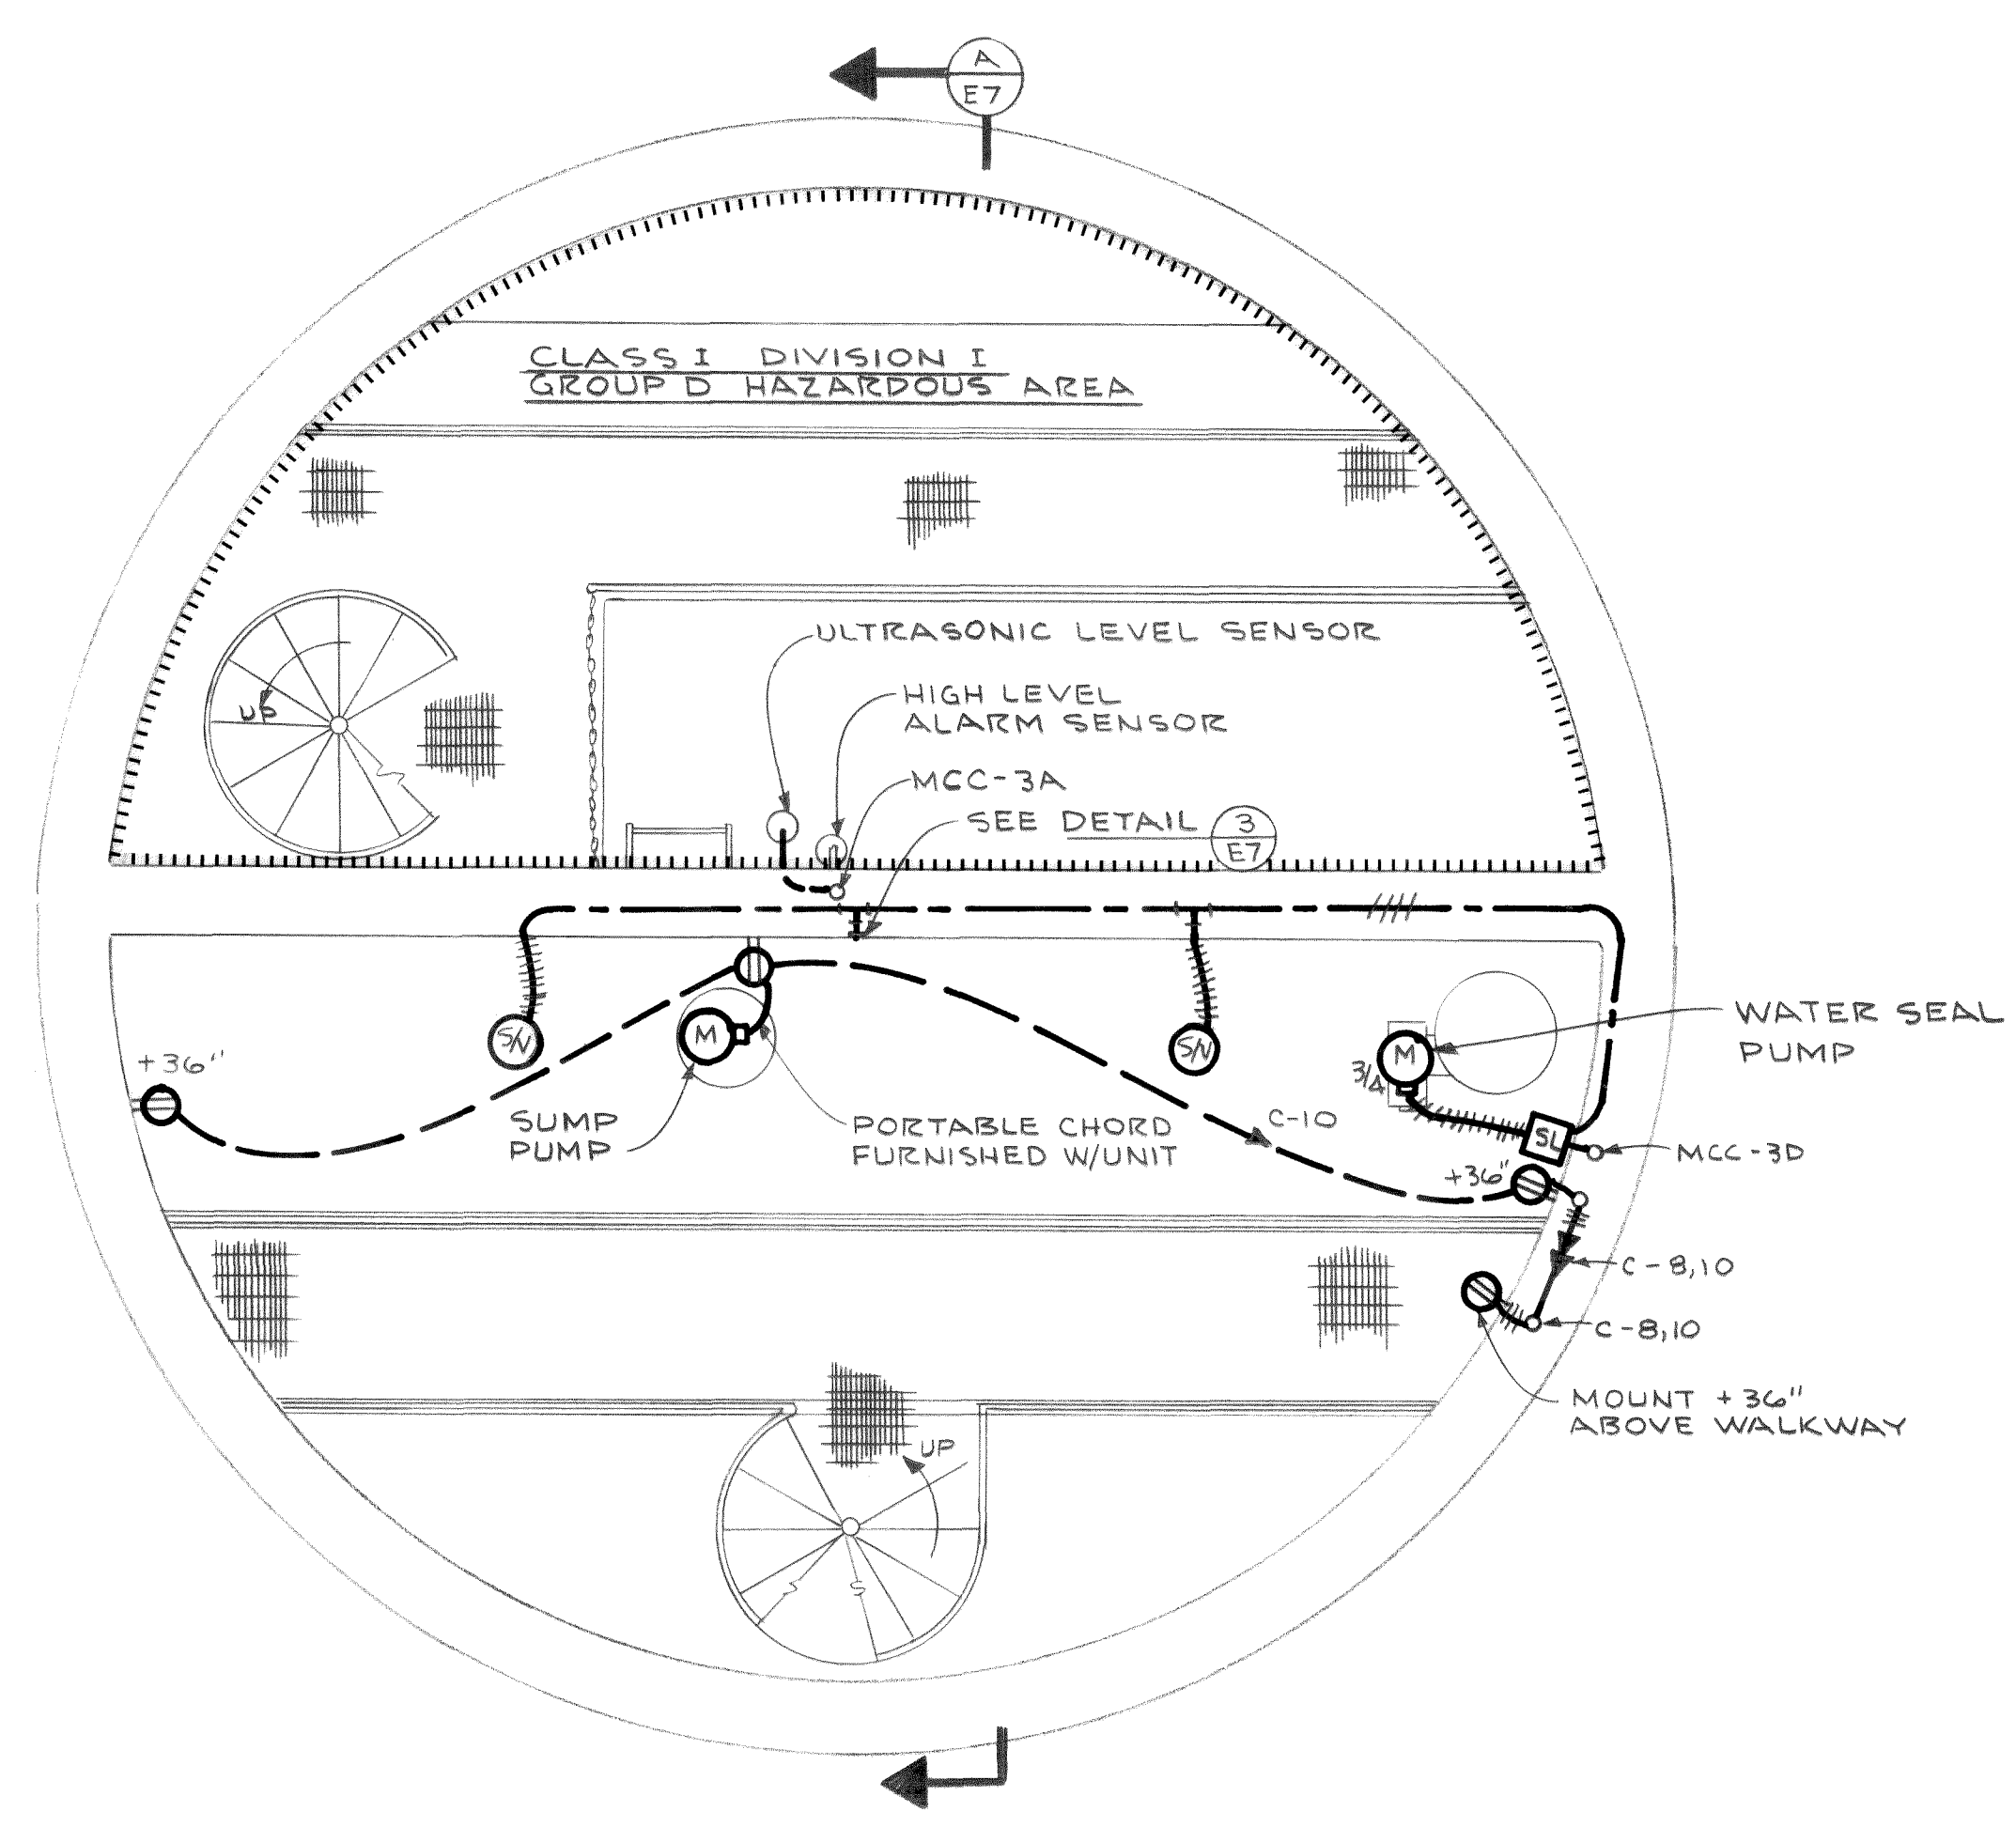


PUMP ROOM FLOOR
SCALE 3/8" = 1'-0"

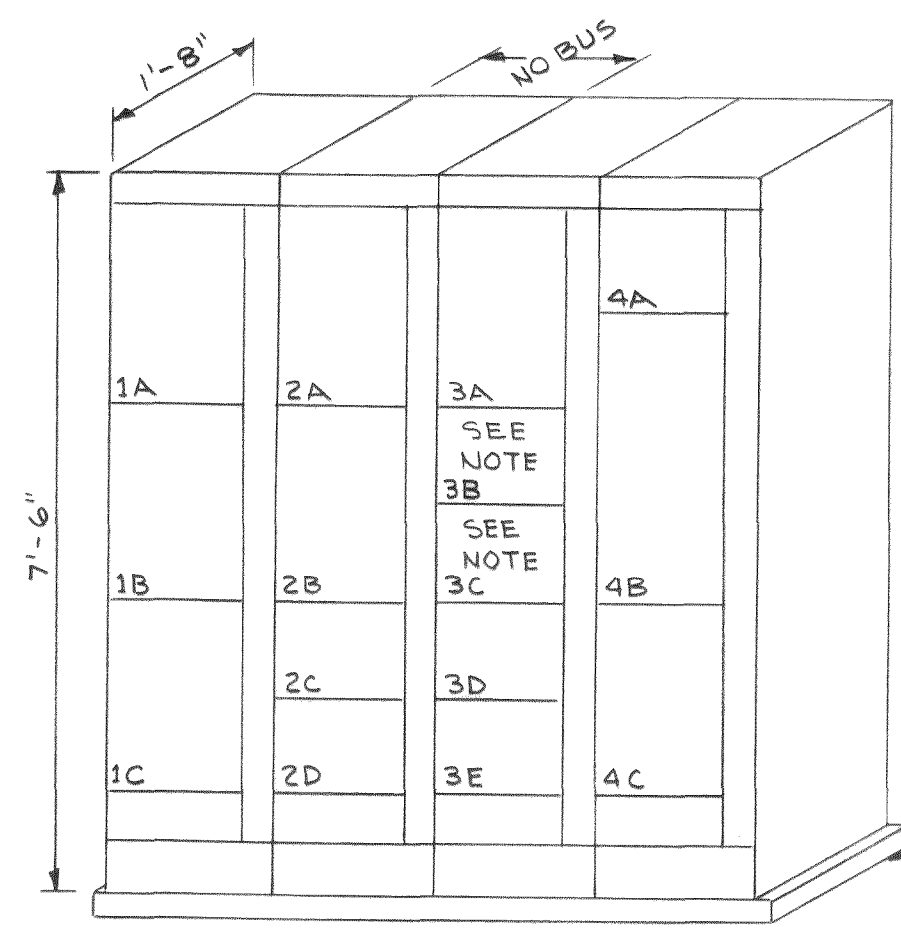

MOTOR CONTROL CENTER
SCALE 3/8" = 1'-0"

NOTE:
ADEQUATE SPACE SHALL BE ALLOWED IN MCC SO THAT 10HP COMBINATION STARTERS MAY BE REPLACED WITH 20HP COMBINATION STARTERS IN THE FUTURE.

M.C.C. NAMEPLATE ENGRAVING SCHEDULE			
UNIT NO.	NAMEPLATE ENGRAVING SIZE 1" X 2 1/2" 16 CHARACTERS PER LINE MAX.		
	FIRST LINE	SECOND LINE	THIRD LINE
1A			
1B	MAIN BREAKER		
1C	METERING CT'S & PT'S		
2A	EXHAUST FAN	CONTROLS	
2B	AUTOMATIC	TRANSFER SWITCH	CONTROL PANEL
2C	AUTOMATIC	TRANSFER SWITCH	
2D	GENERATOR	BREAKER	
3A	PUMP LEVEL	CONTROL	
3B	PUMP #1		
3C	PUMP #2		
3D	WATER SEAL PUMP		
3E	EXHAUST FAN		
4A	LIGHTING	TRANSFORMER	BREAKER
4B	LIGHTING PANEL "C"		
4C	LIGHTING	TRANSFORMER	208Y/120V, 3Ø, 4W

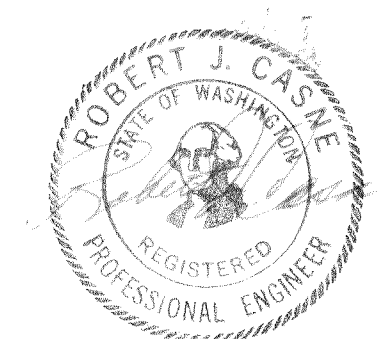


DESIGNED	R.J.C.	APPROVED	<i>Robert J. Casne</i>
DRAWN	J.M.	SCALE	AS SHOWN
CHECKED	<i>DL</i>	DATE	JULY, 1972
FILE	71-S-425.002		

ST **Stevens, Thompson & Runyan, Inc.**
Engineers/Planners
PORTLAND SEATTLE BOISE


TOWN OF FERNDAL, WASHINGTON
AXTON ROAD INTERCEPTOR
SCHEDULE I

PUMP STATION 2
ELECTRICAL POWER PLAN

MICROFILMED

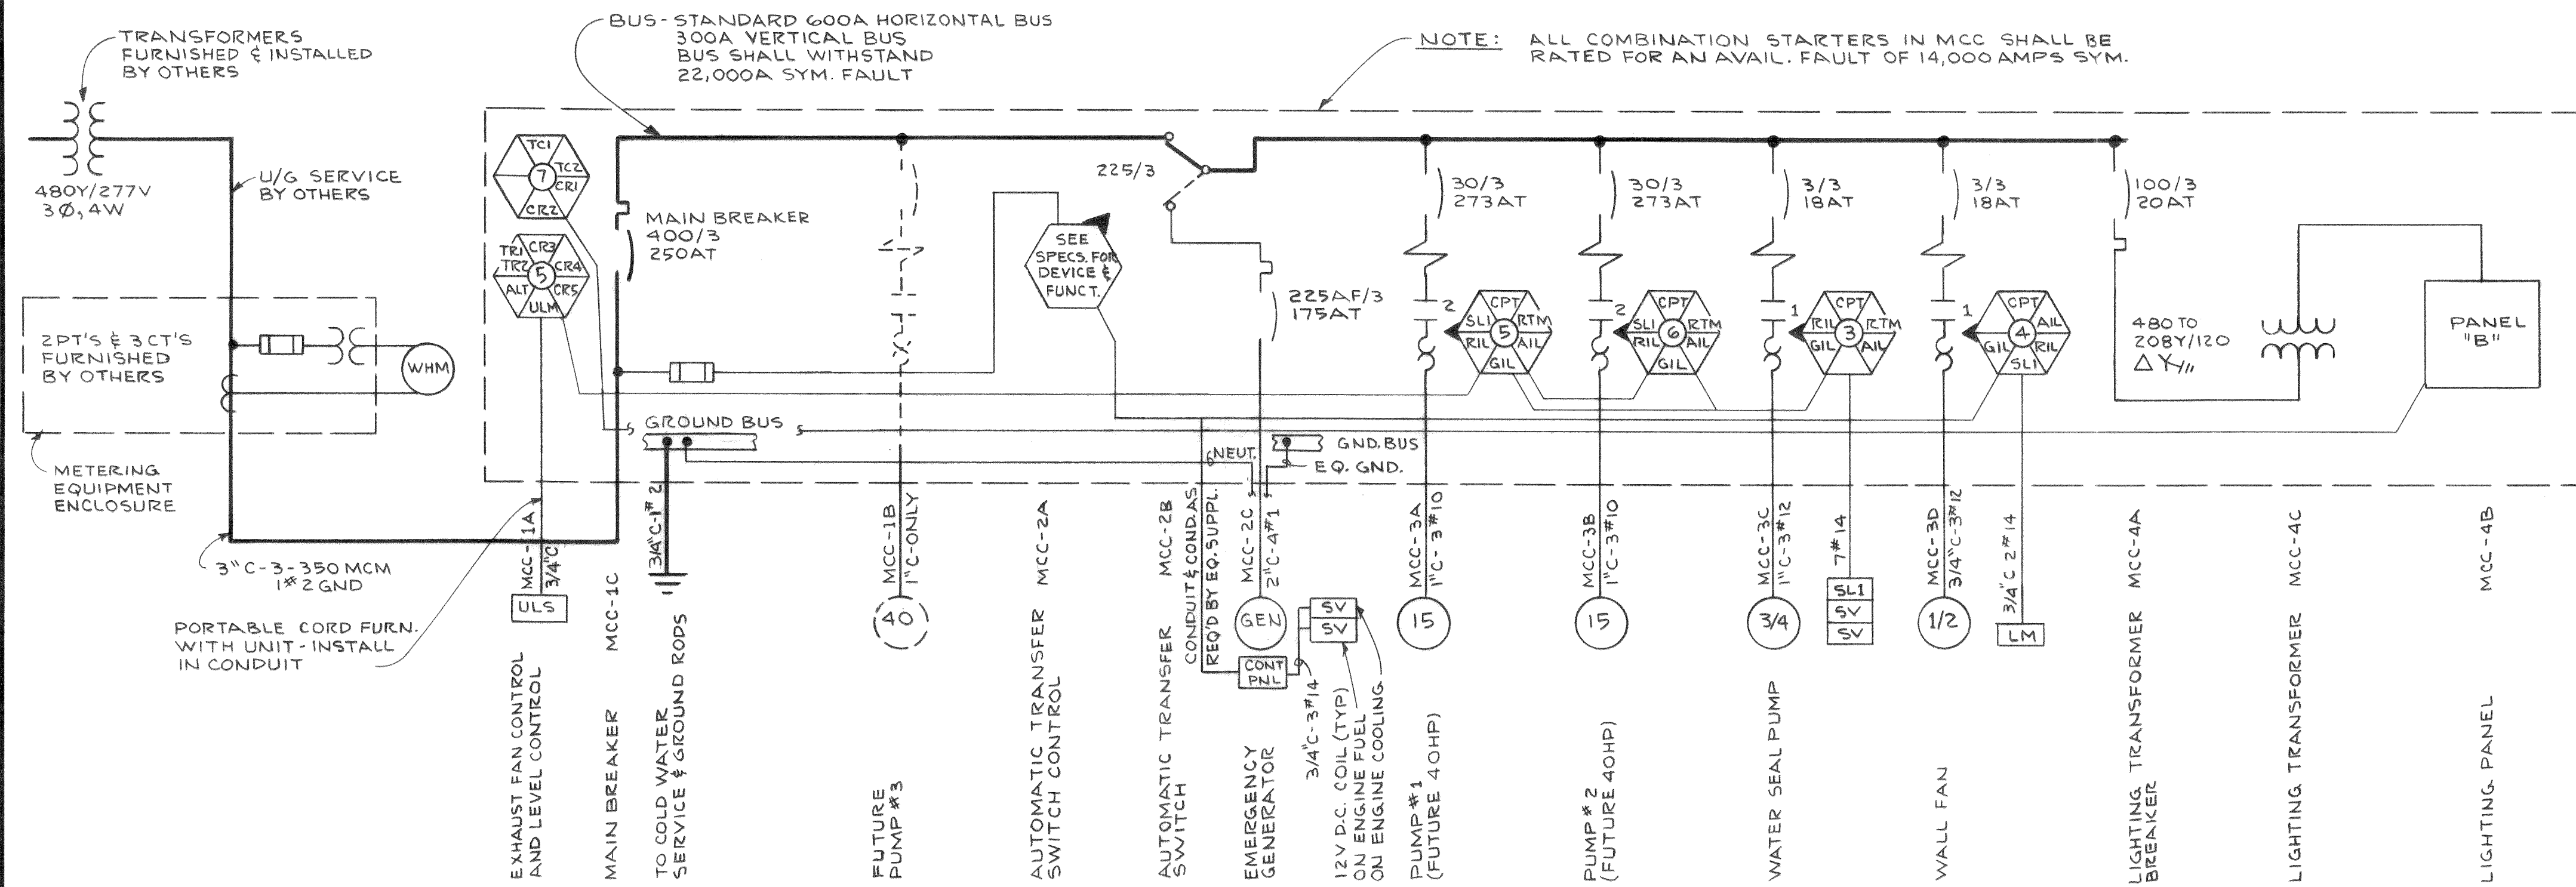

ONE LINE DIAGRAM
PUMP STATION 1

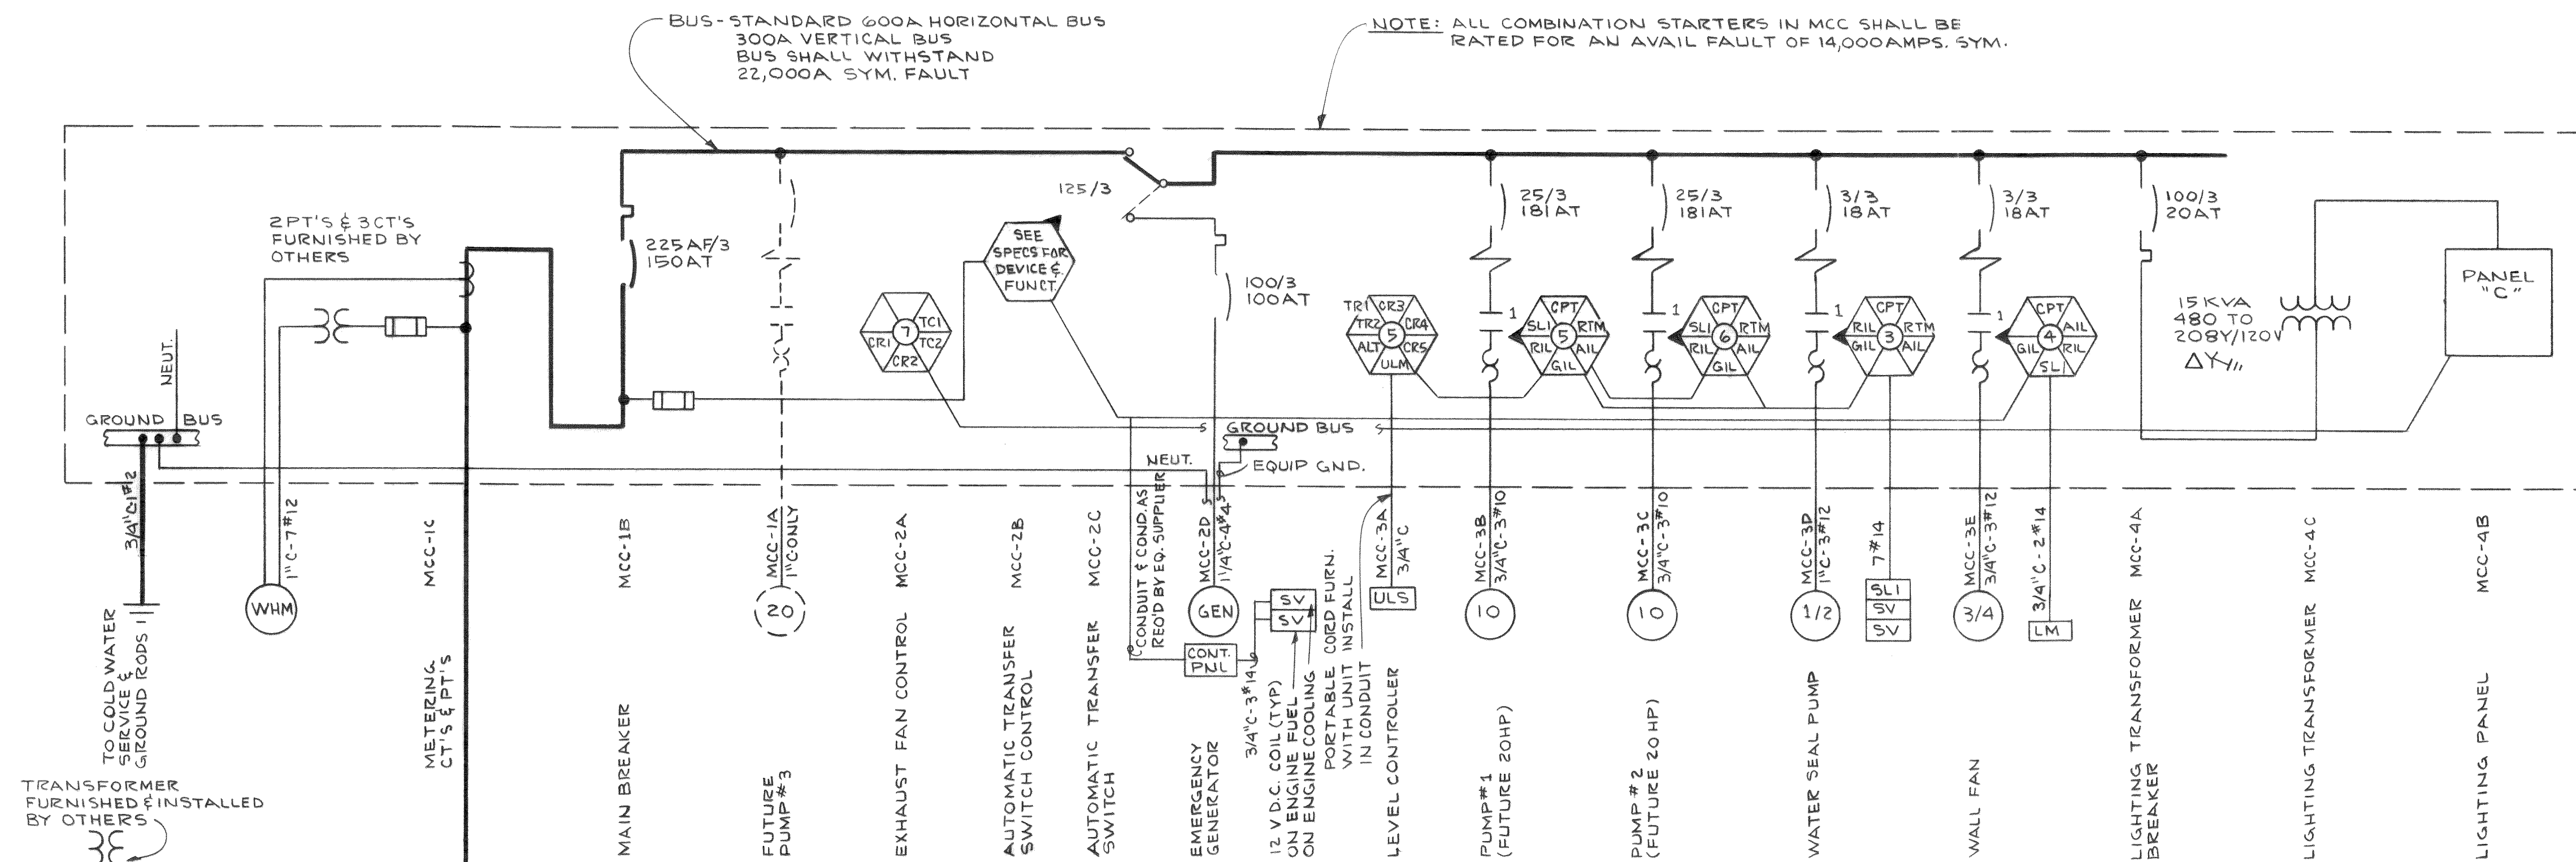

ONE LINE DIAGRAM
PUMP STATION* 2

NOTES:
1. FOR ONE LINE DIAGRAM SYMBOLS AND CONTROL KEY SEE SHEET E4.

DESIGNED	R.J.C.	APPROVED	<i>Robert J. Casne</i>
DRAWN	J.M.	SCALE	NONE
CHECKED	<i>ATC</i>	DATE	JULY, 1972
FILE	71-S-425.002		

Stevens, Thompson & Runyan, Inc.
Engineers/Planners
PORTLAND SEATTLE BOISE


TOWN OF FERNDAL, WASHINGTON
AXTON ROAD INTERCEPTOR
SCHEDULE I

PUMP STATIONS I AND 2
ELECTRICAL ONE LINE DIAGRAM


EIO
II

MICROFILMED


00210.032 27.00

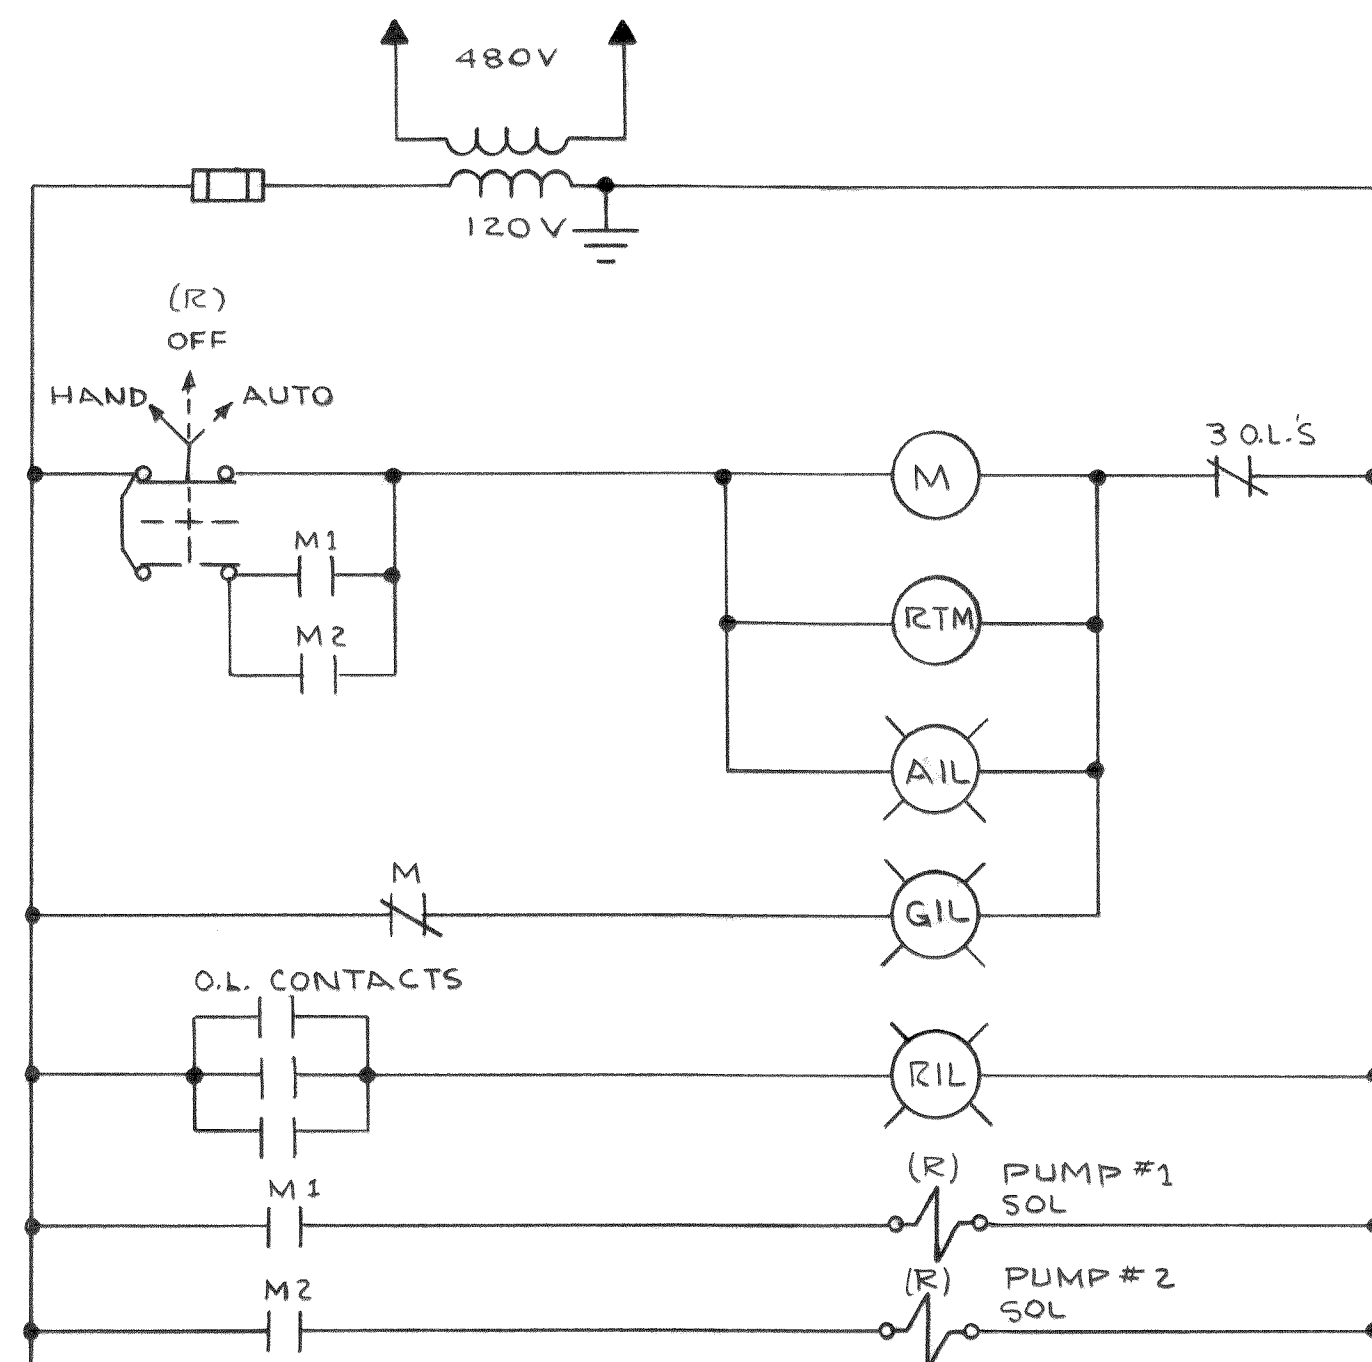


CONTROL SCHEMATIC NO. 3
WATER SEAL PUMP

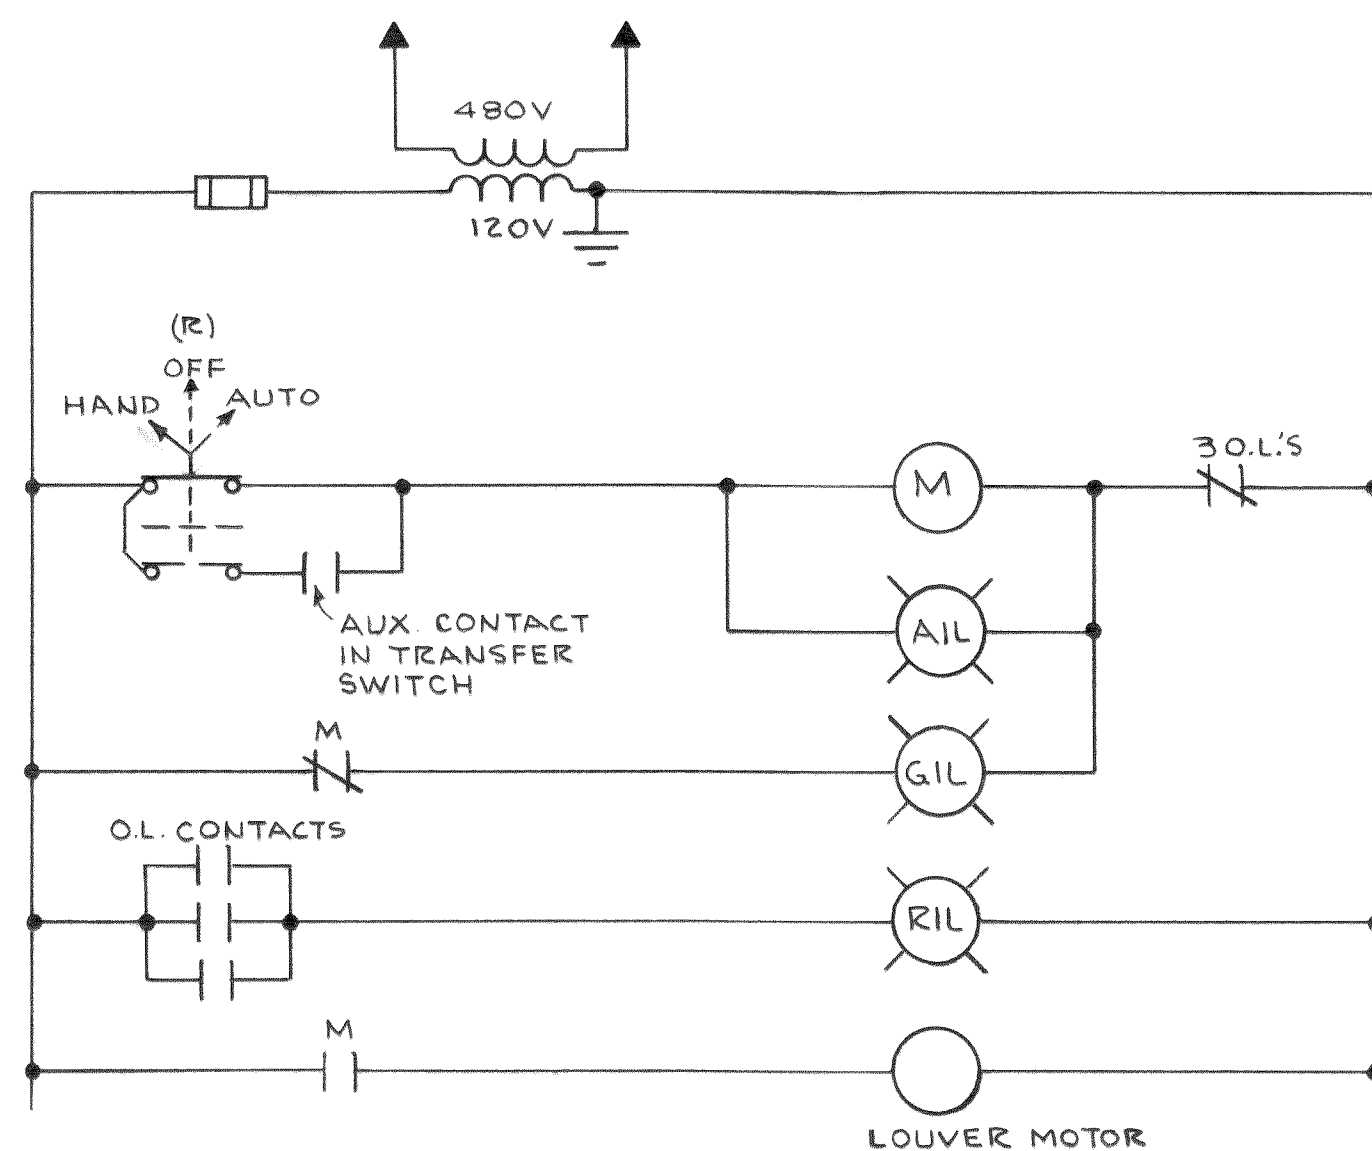


CONTROL SCHEMATIC NO. 4
WALL FAN

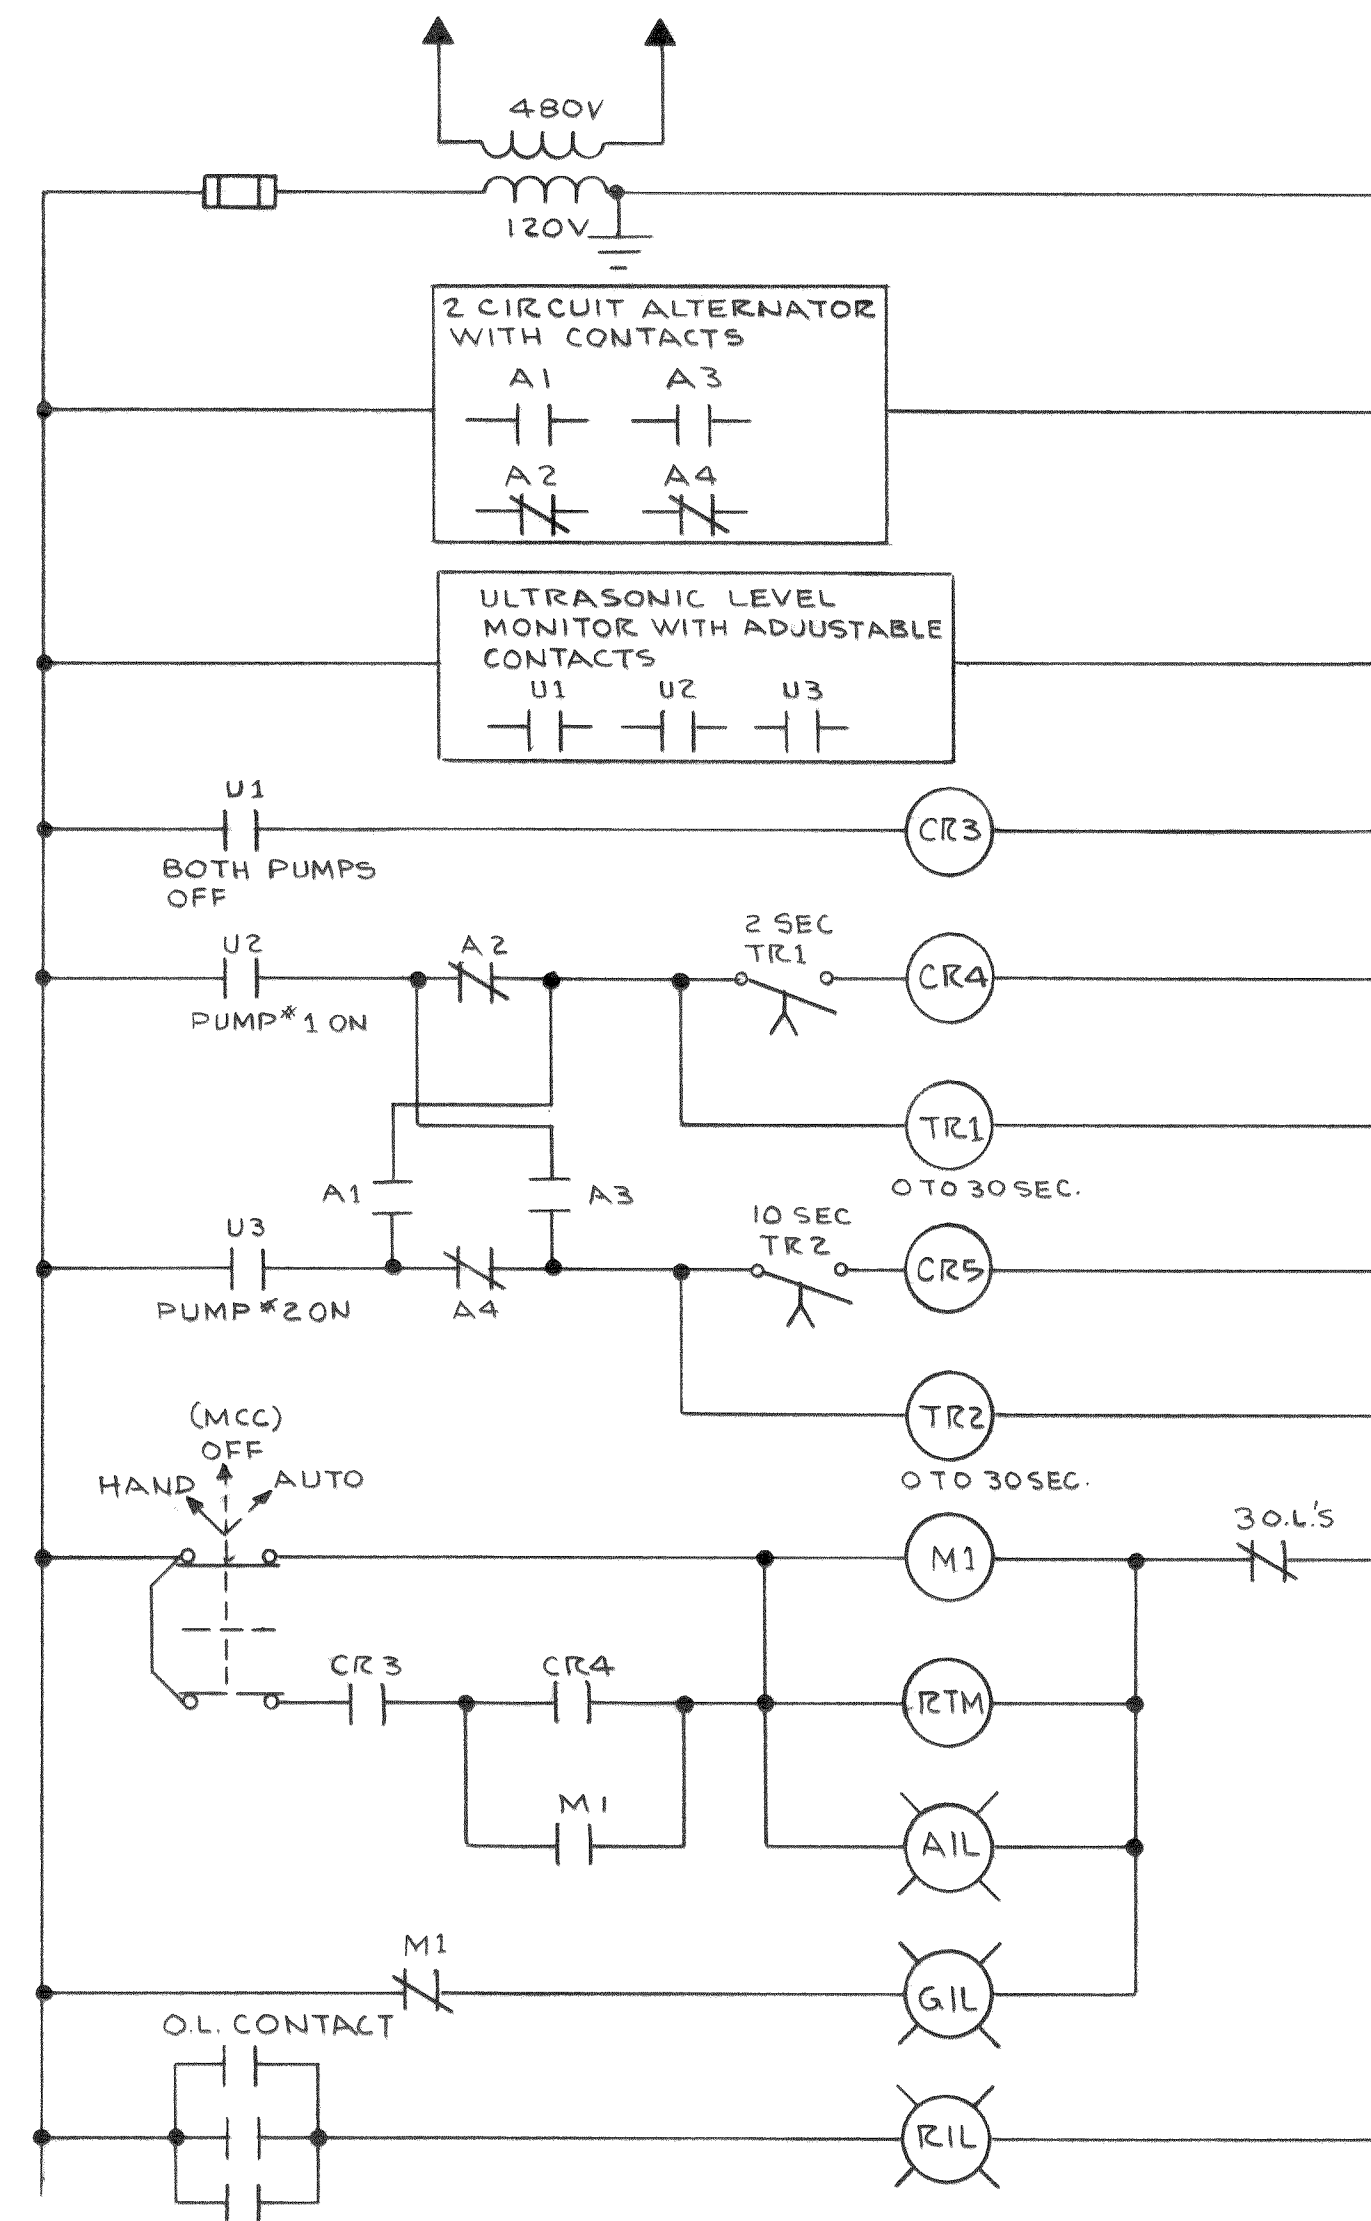

CONTROL SCHEMATIC NO. 5
PUMP NO. 1

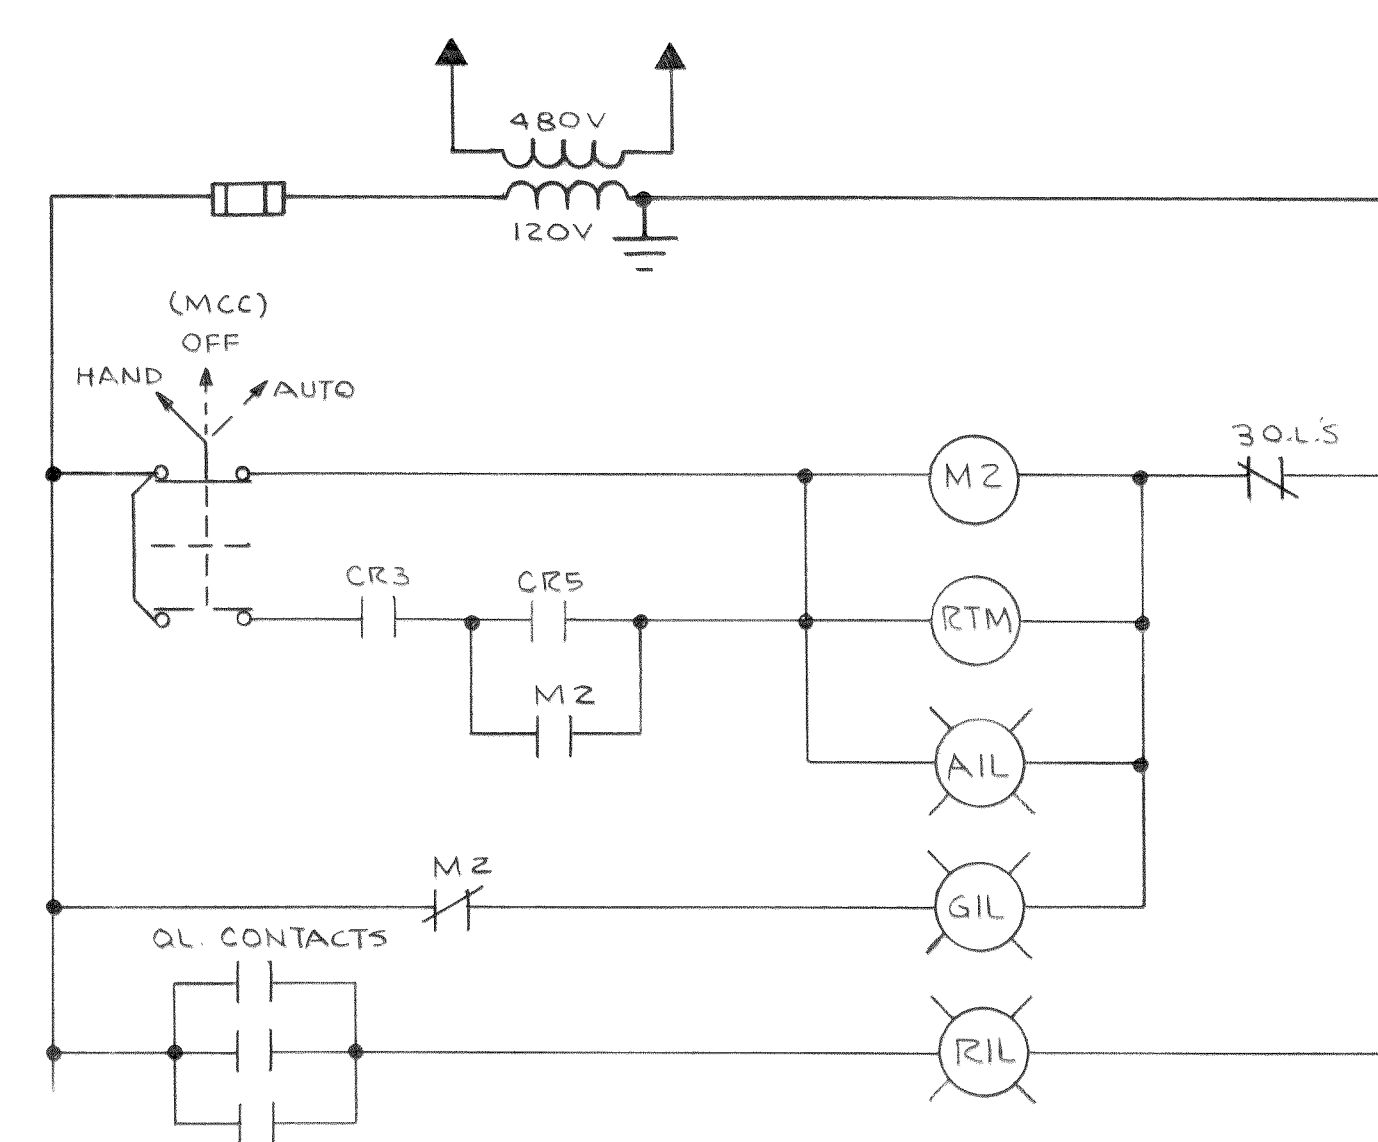

CONTROL SCHEMATIC NO. 6
PUMP NO. 2

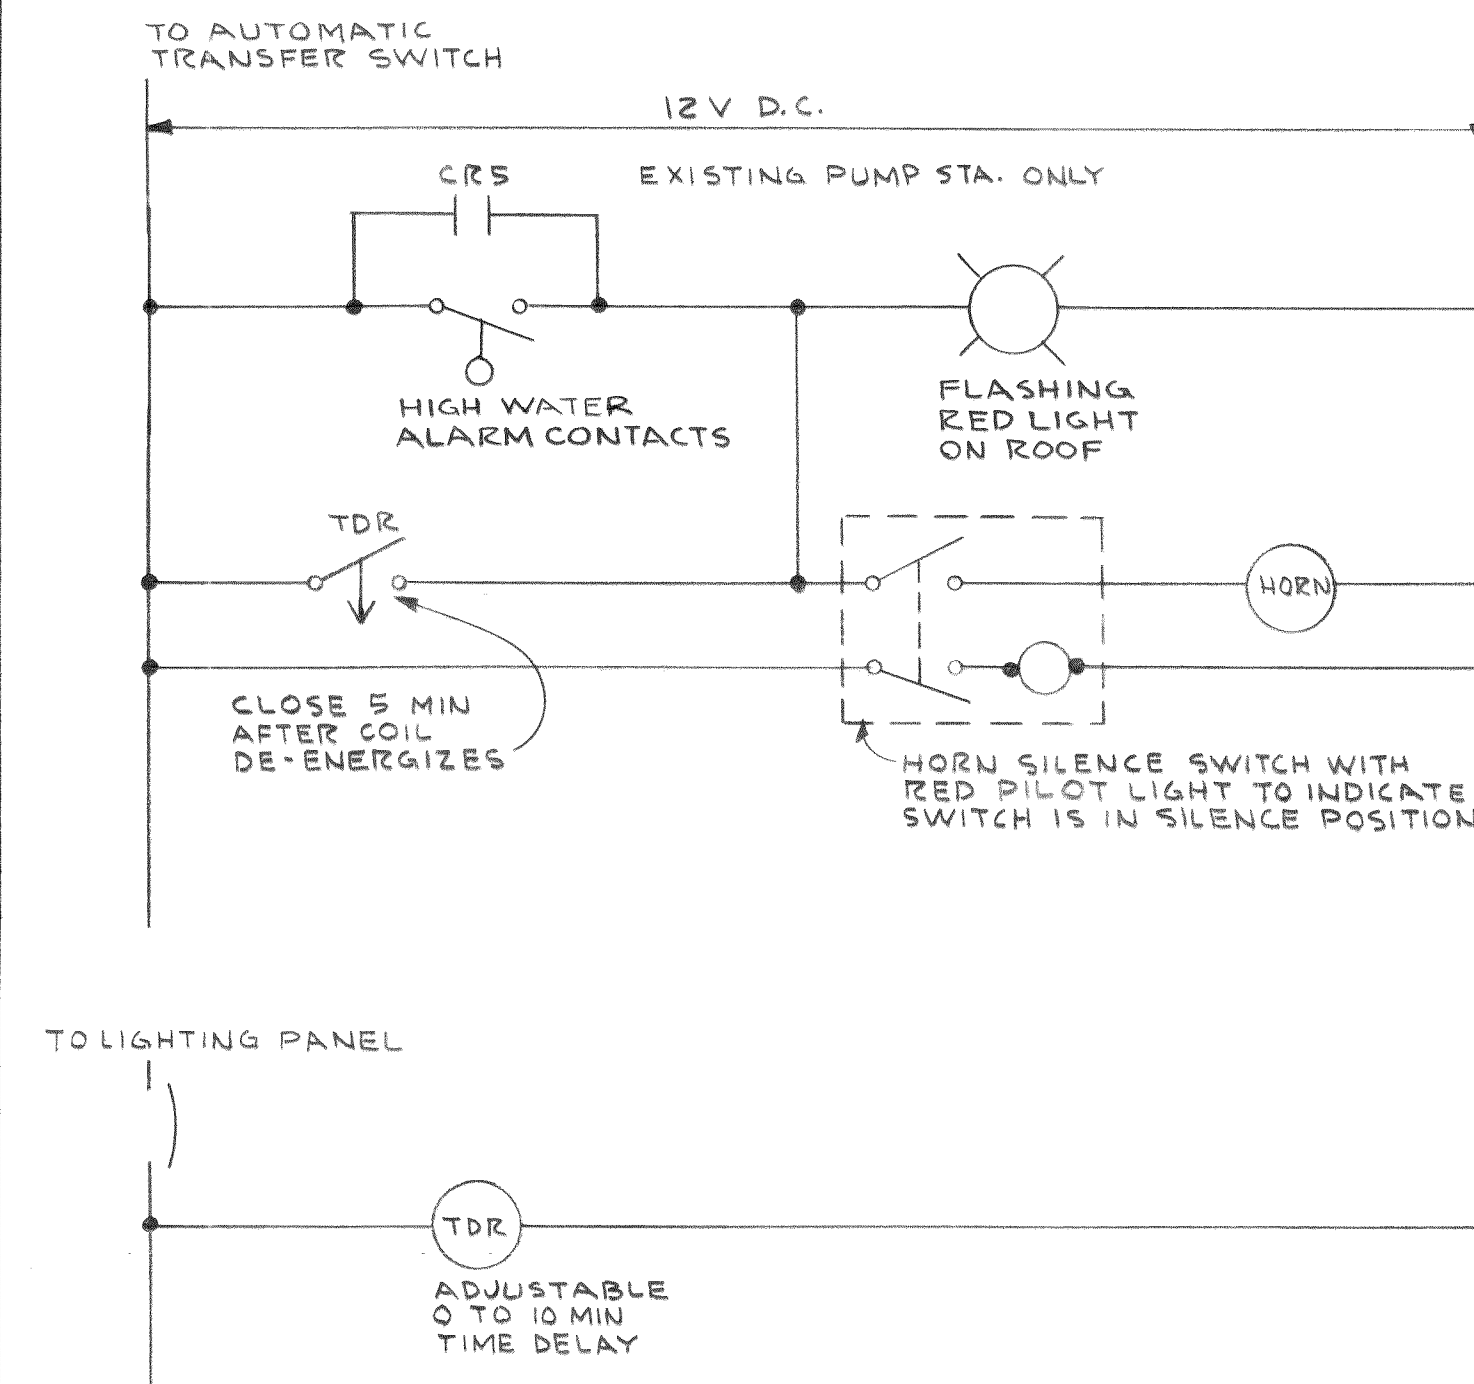

CONTROL SCHEMATIC NO. 8
POWER FAIL & HIGH WATER ALARM


DESIGNED R.J.C.	APPROVED <i>Robert J. Casne</i>
DRAWN J.M.	SCALE NONE DATE JULY, 1972
CHECKED <i>Sto</i>	FILE 71-S-425.002

STYR Stevens, Thompson & Runyan, Inc.
Engineers/Planners
PORTLAND SEATTLE BOISE



TOWN OF FERNDAL, WASHINGTON
AXTON ROAD INTERCEPTOR
SCHEDULE I



PUMP STATIONS 1 AND 2
ELECTRICAL CONTROL SCHEMATICS

E11
11

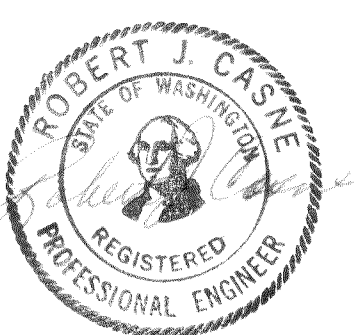

MICROFILMED

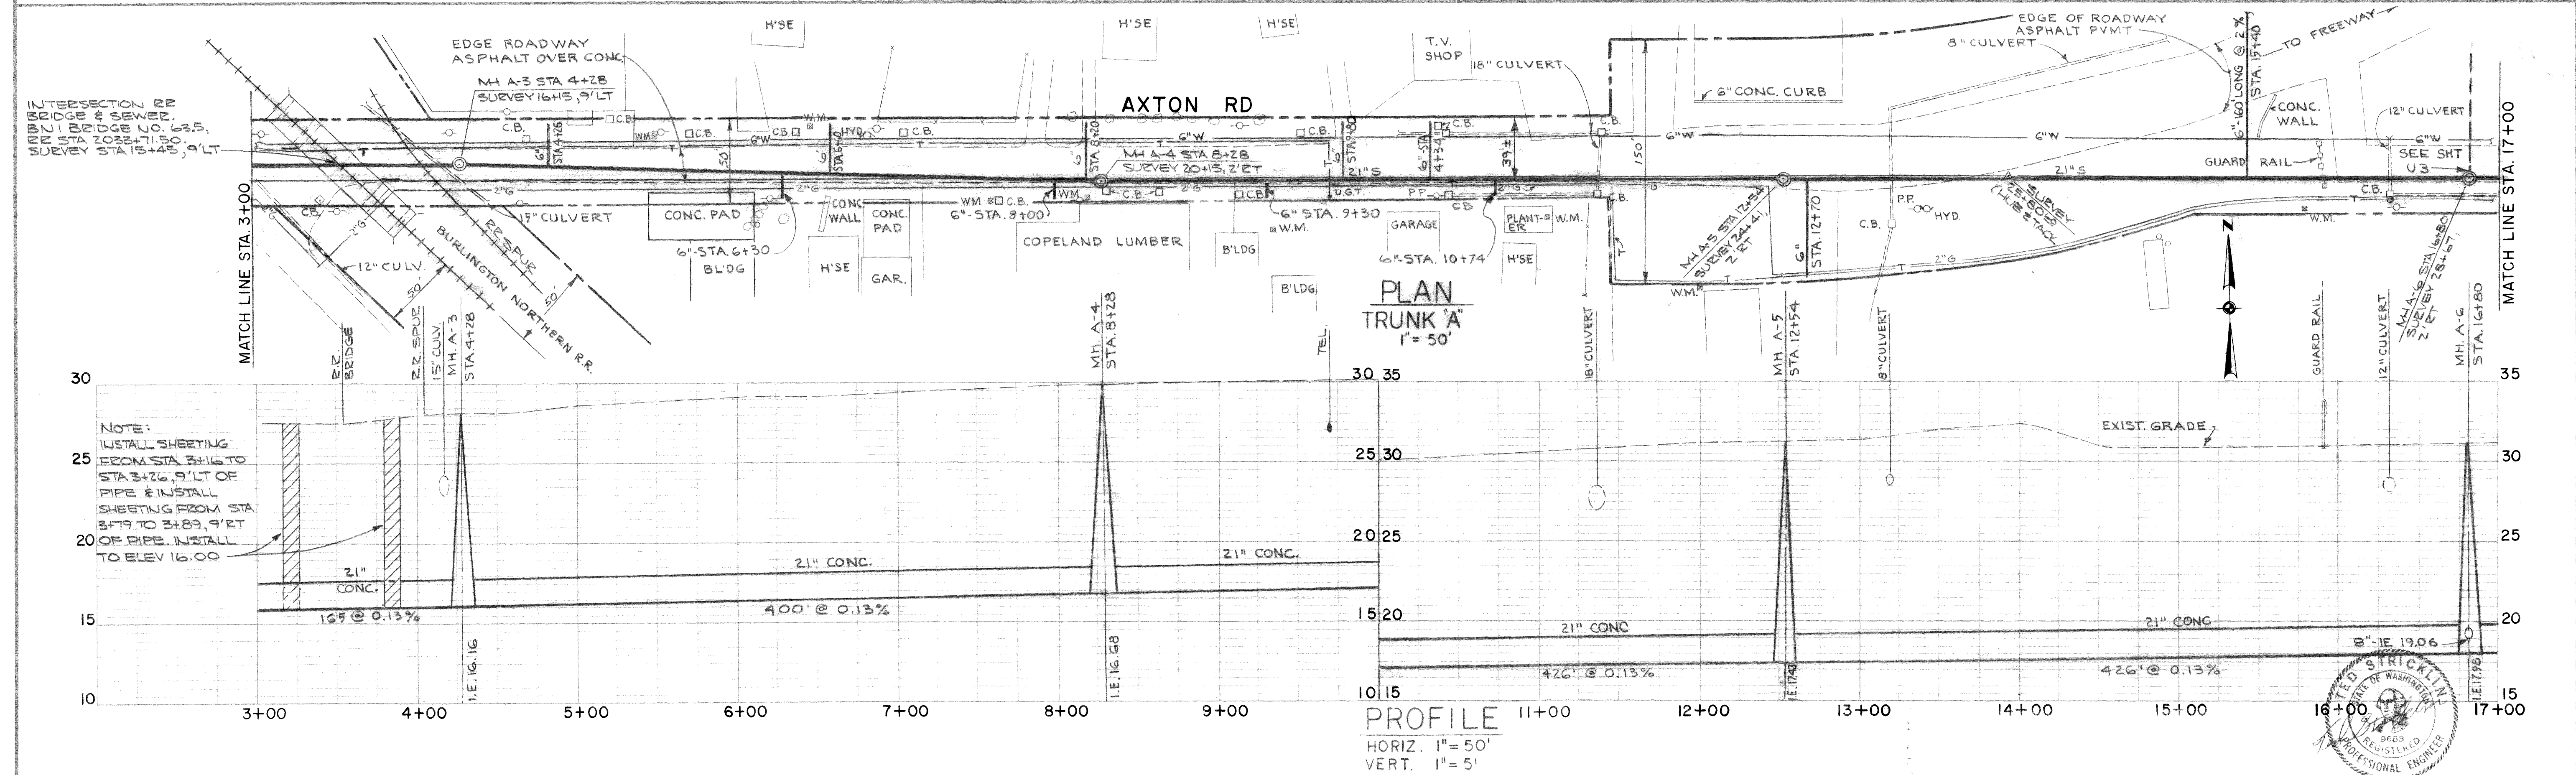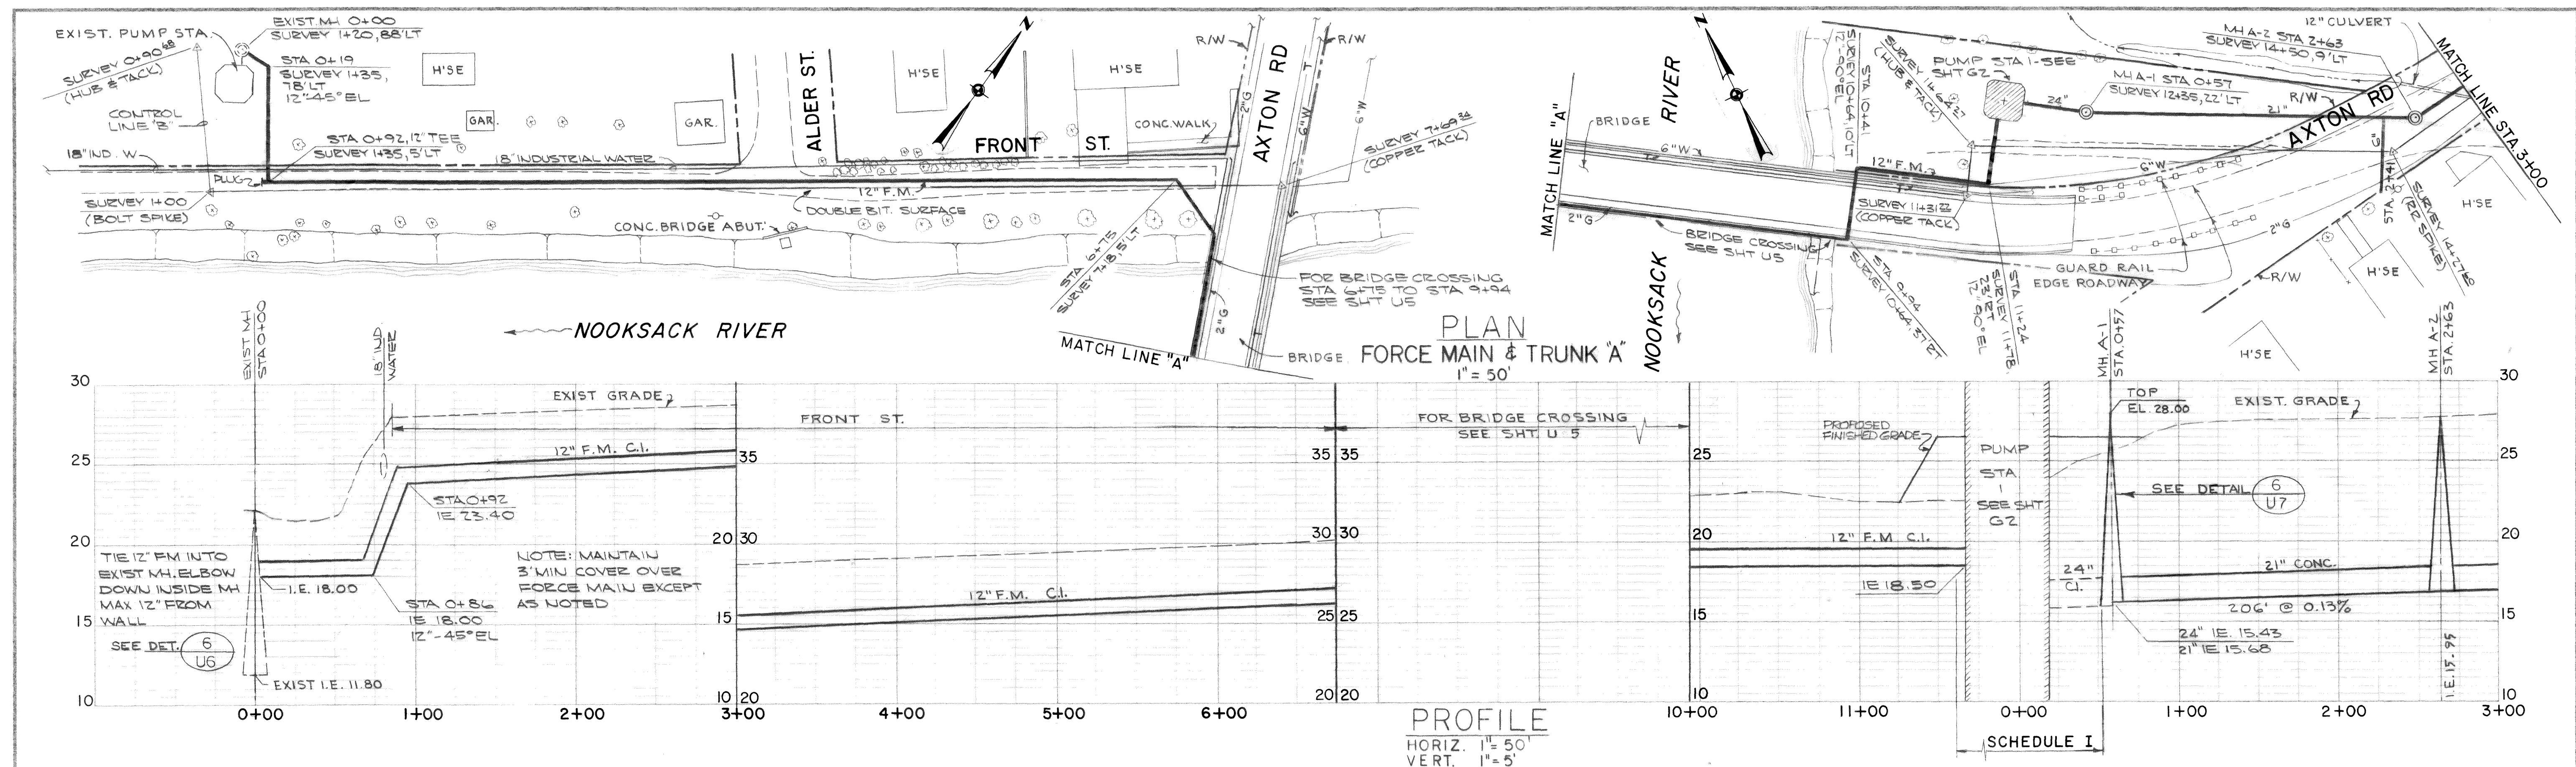

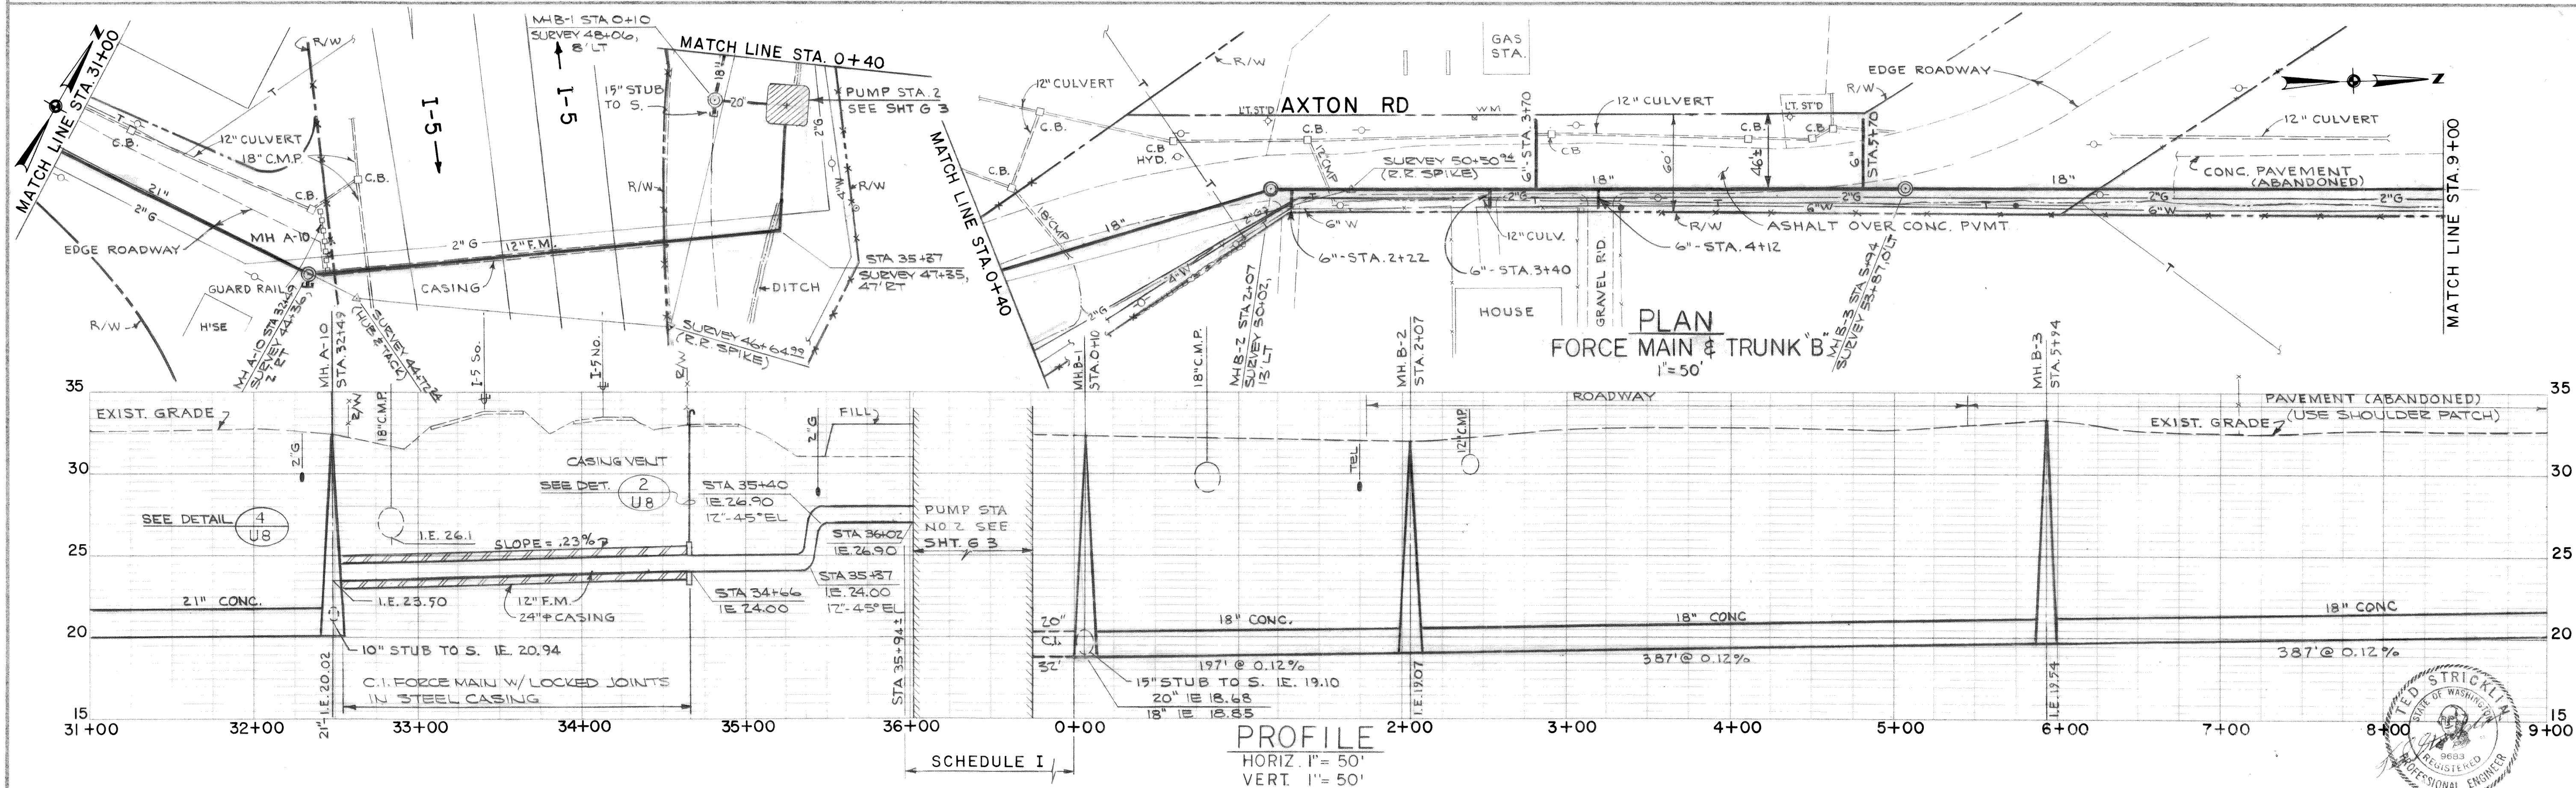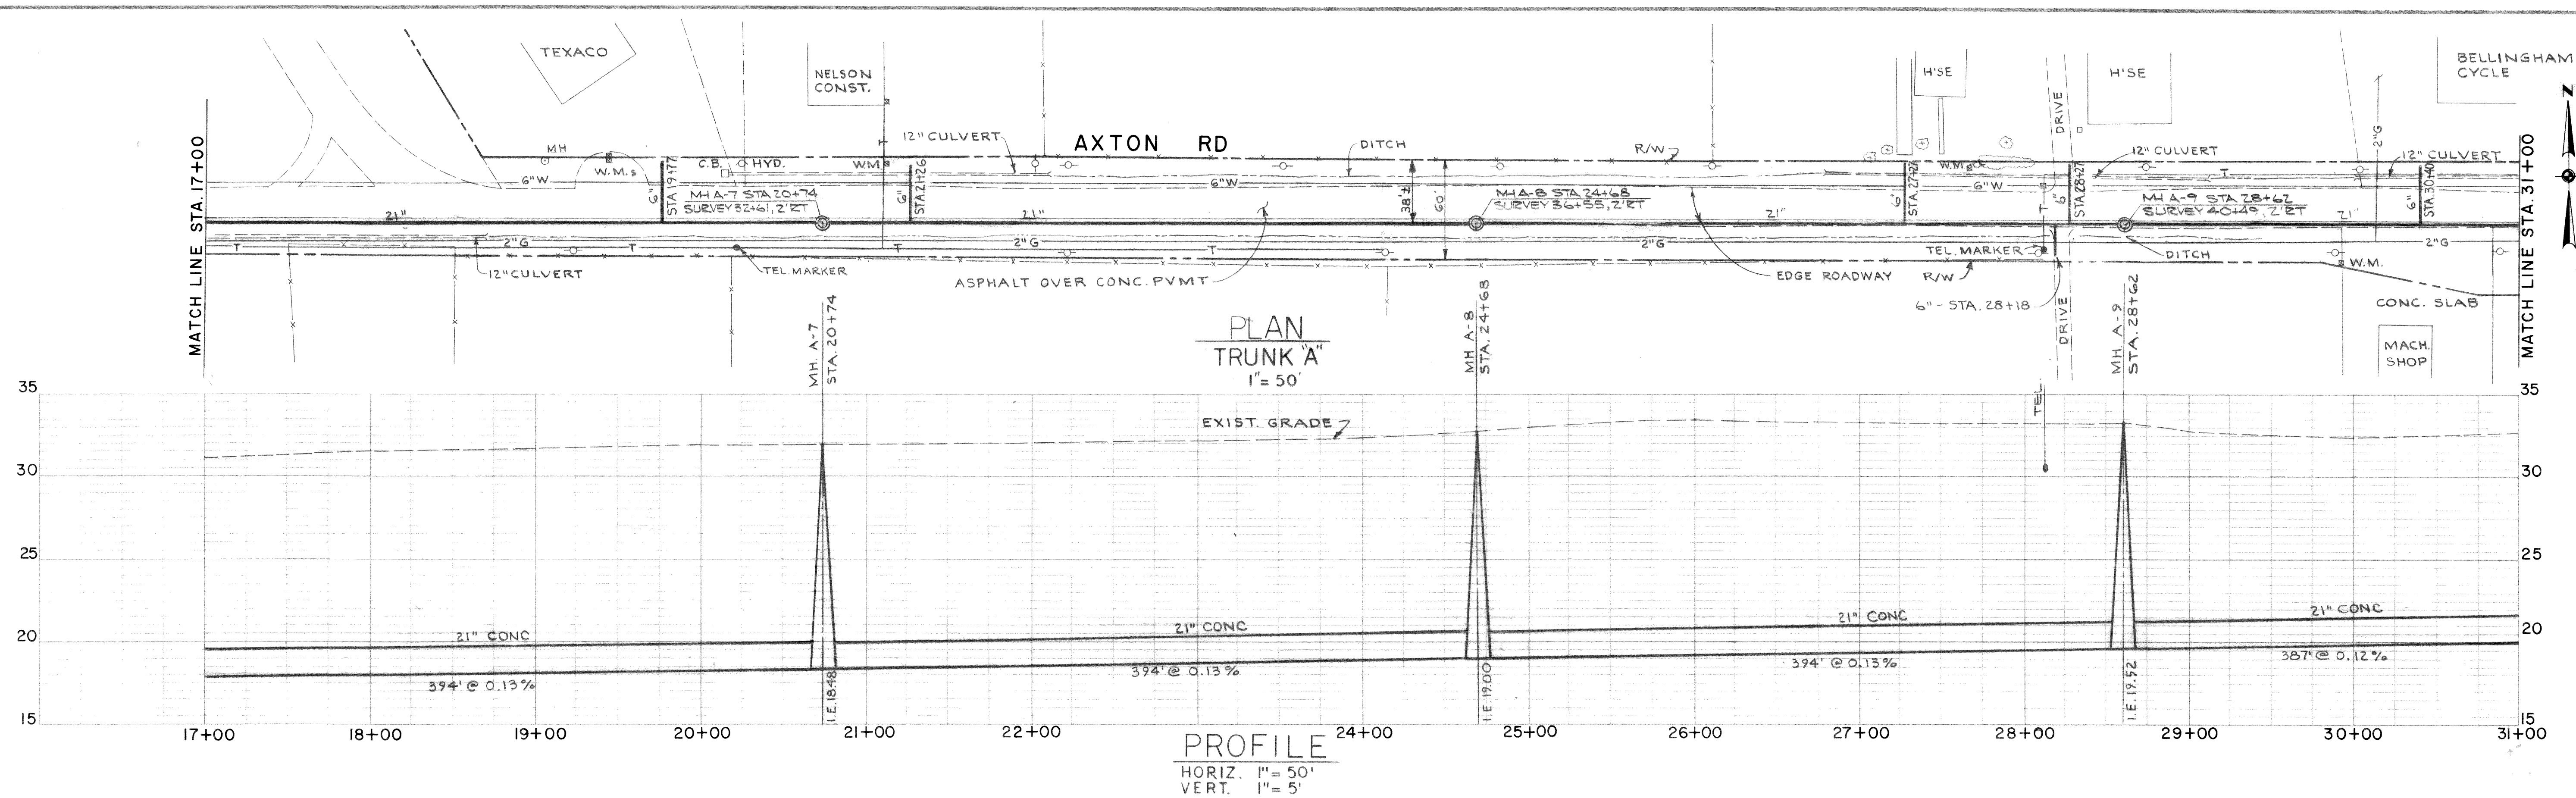

NOV. 72	1	ADDENDUM NO. 2	DESIGNED T.S.	APPROVED <i>Paul W. Runyan</i>
DATE	NO.	REVISION	DRAWN E.J.	SCALE AS SHOWN DATE JULY, 1972
			CHECKED <i>L.H.</i>	FILE 71-S-425.002



ST Stevens, Thompson & Runyan, Inc.
Engineers / Planners
PORTLAND • SEATTLE • BOISE • ANCHORAGE

TOWN OF FERNDAL, WASHINGTON
AXTON ROAD INTERCEPTOR
SCHEDULE II


AXTON ROAD
PLAN & PROFILE

U2
8


MICROFILMED

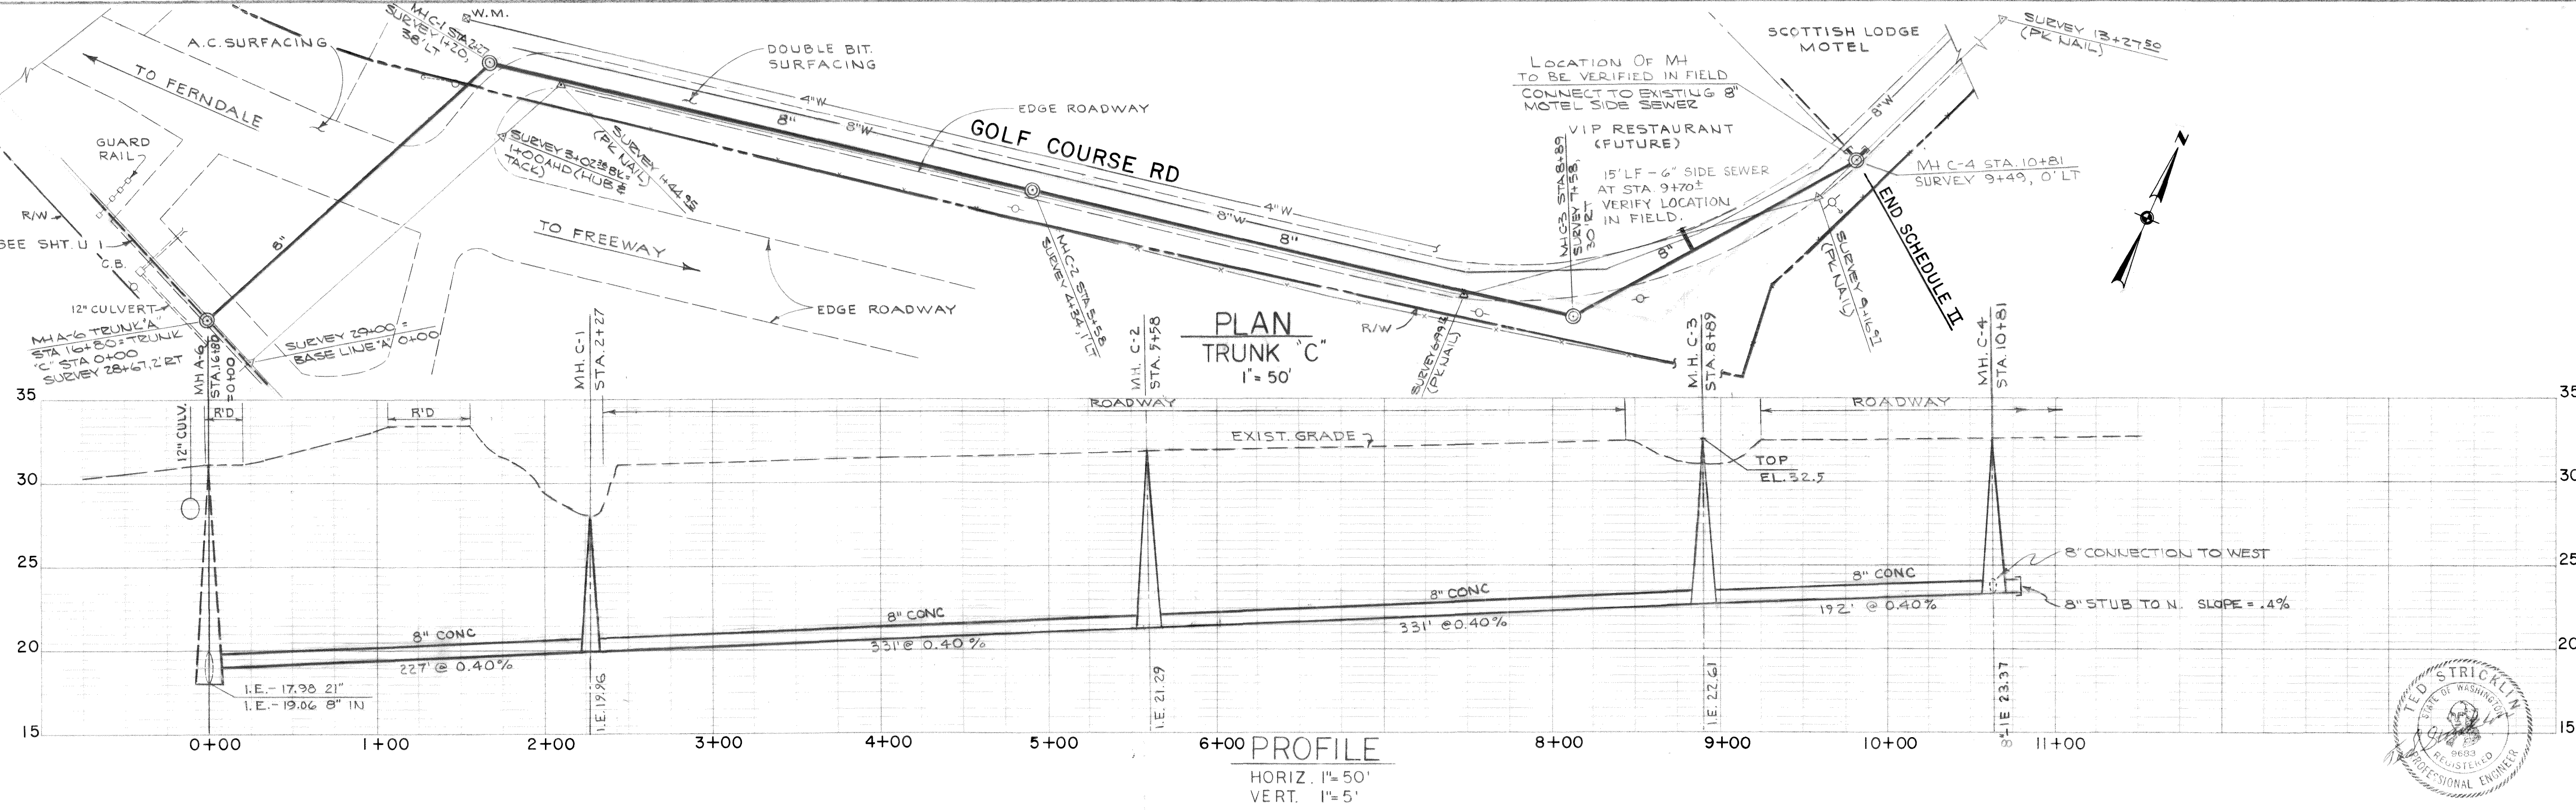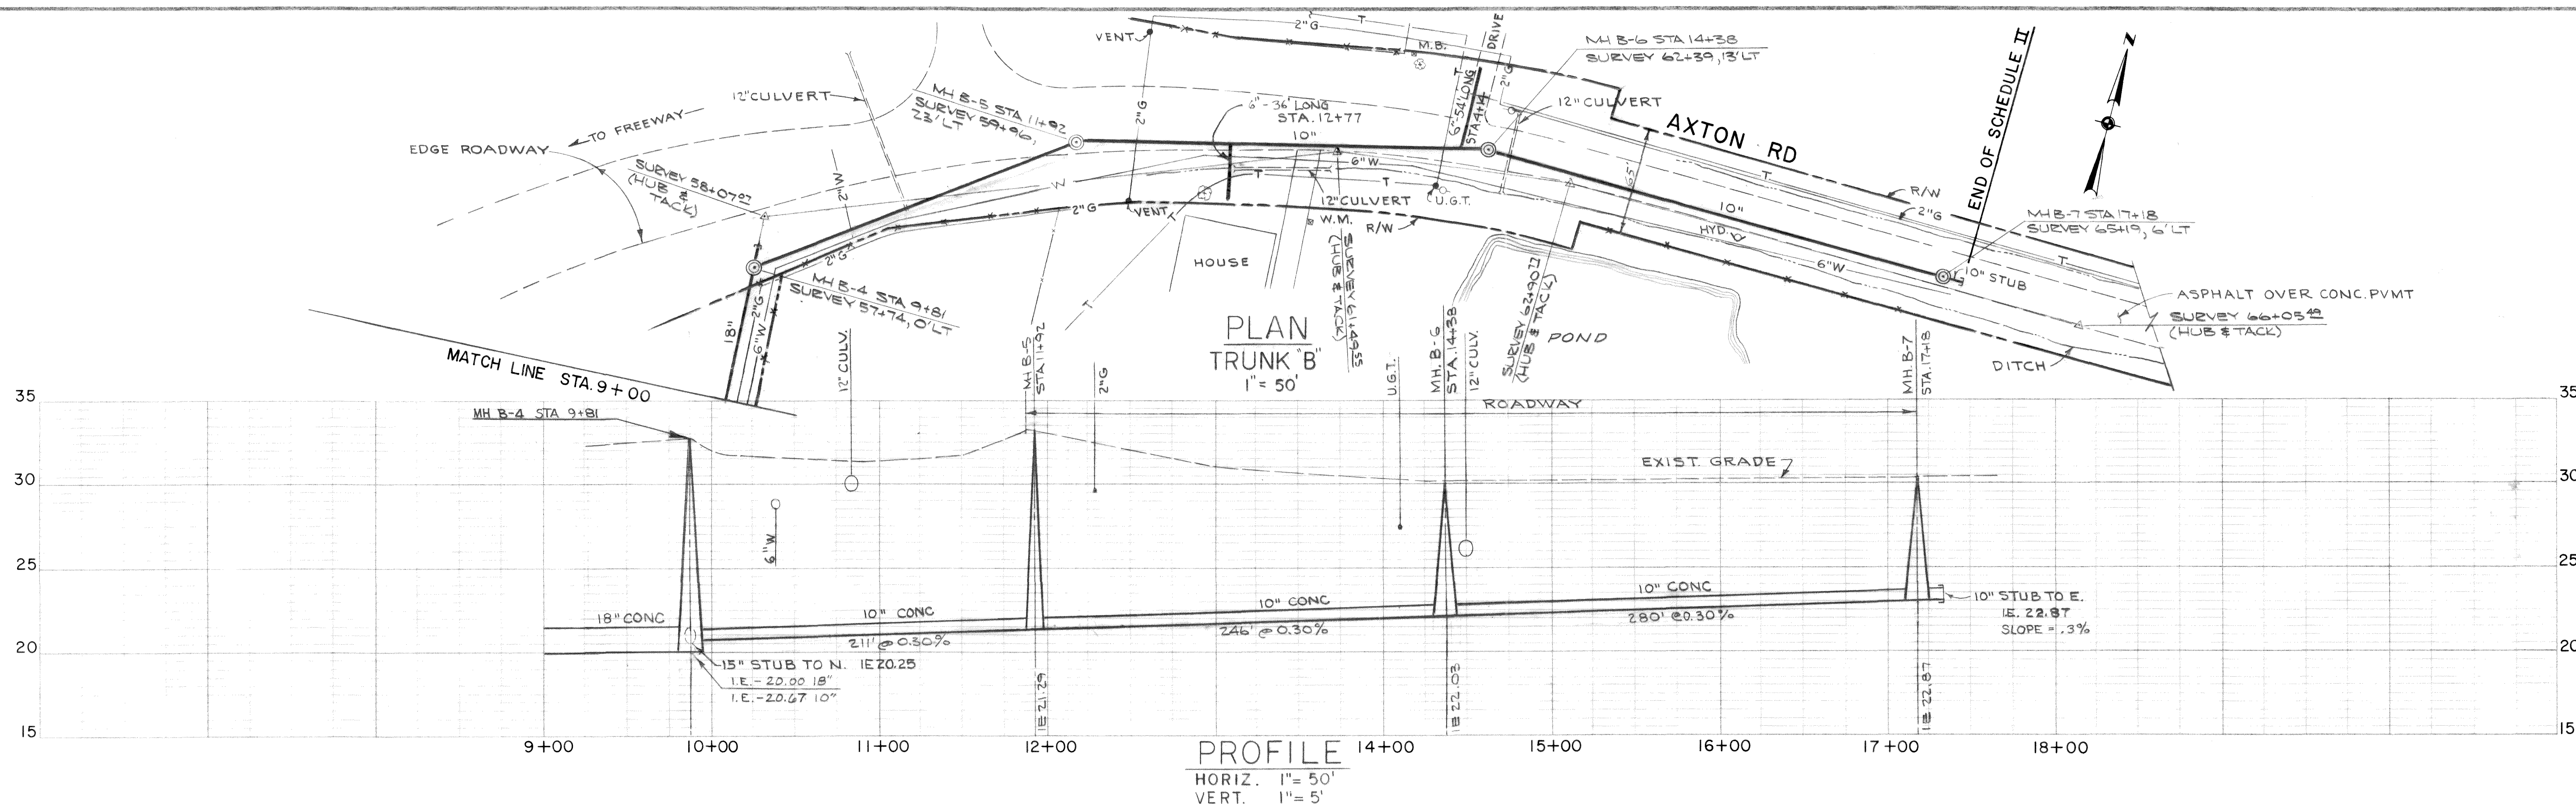


DESIGNED T.S. DRAWN E.J. CHECKED <i>[Signature]</i>		APPROVED <i>[Signature]</i> SCALE AS SHOWN DATE JULY, 1972 FILE 71-S-425.002		 Stevens, Thompson & Runyan, Inc. Engineers / Planners PORTLAND • SEATTLE • BOISE • ANCHORAGE		TOWN OF FERDALE, WASHINGTON AXTON ROAD INTERCEPTOR SCHEDULE II		AXTON RD & GOLF COURSE RD PLAN & PROFILE		U3 8
---	--	--	--	--	--	--	--	---	--	---------


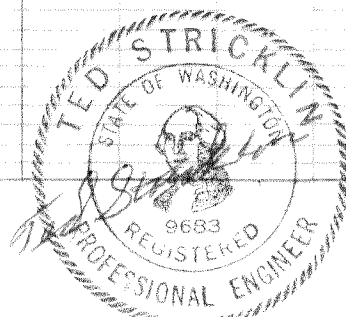


MICROFILMED


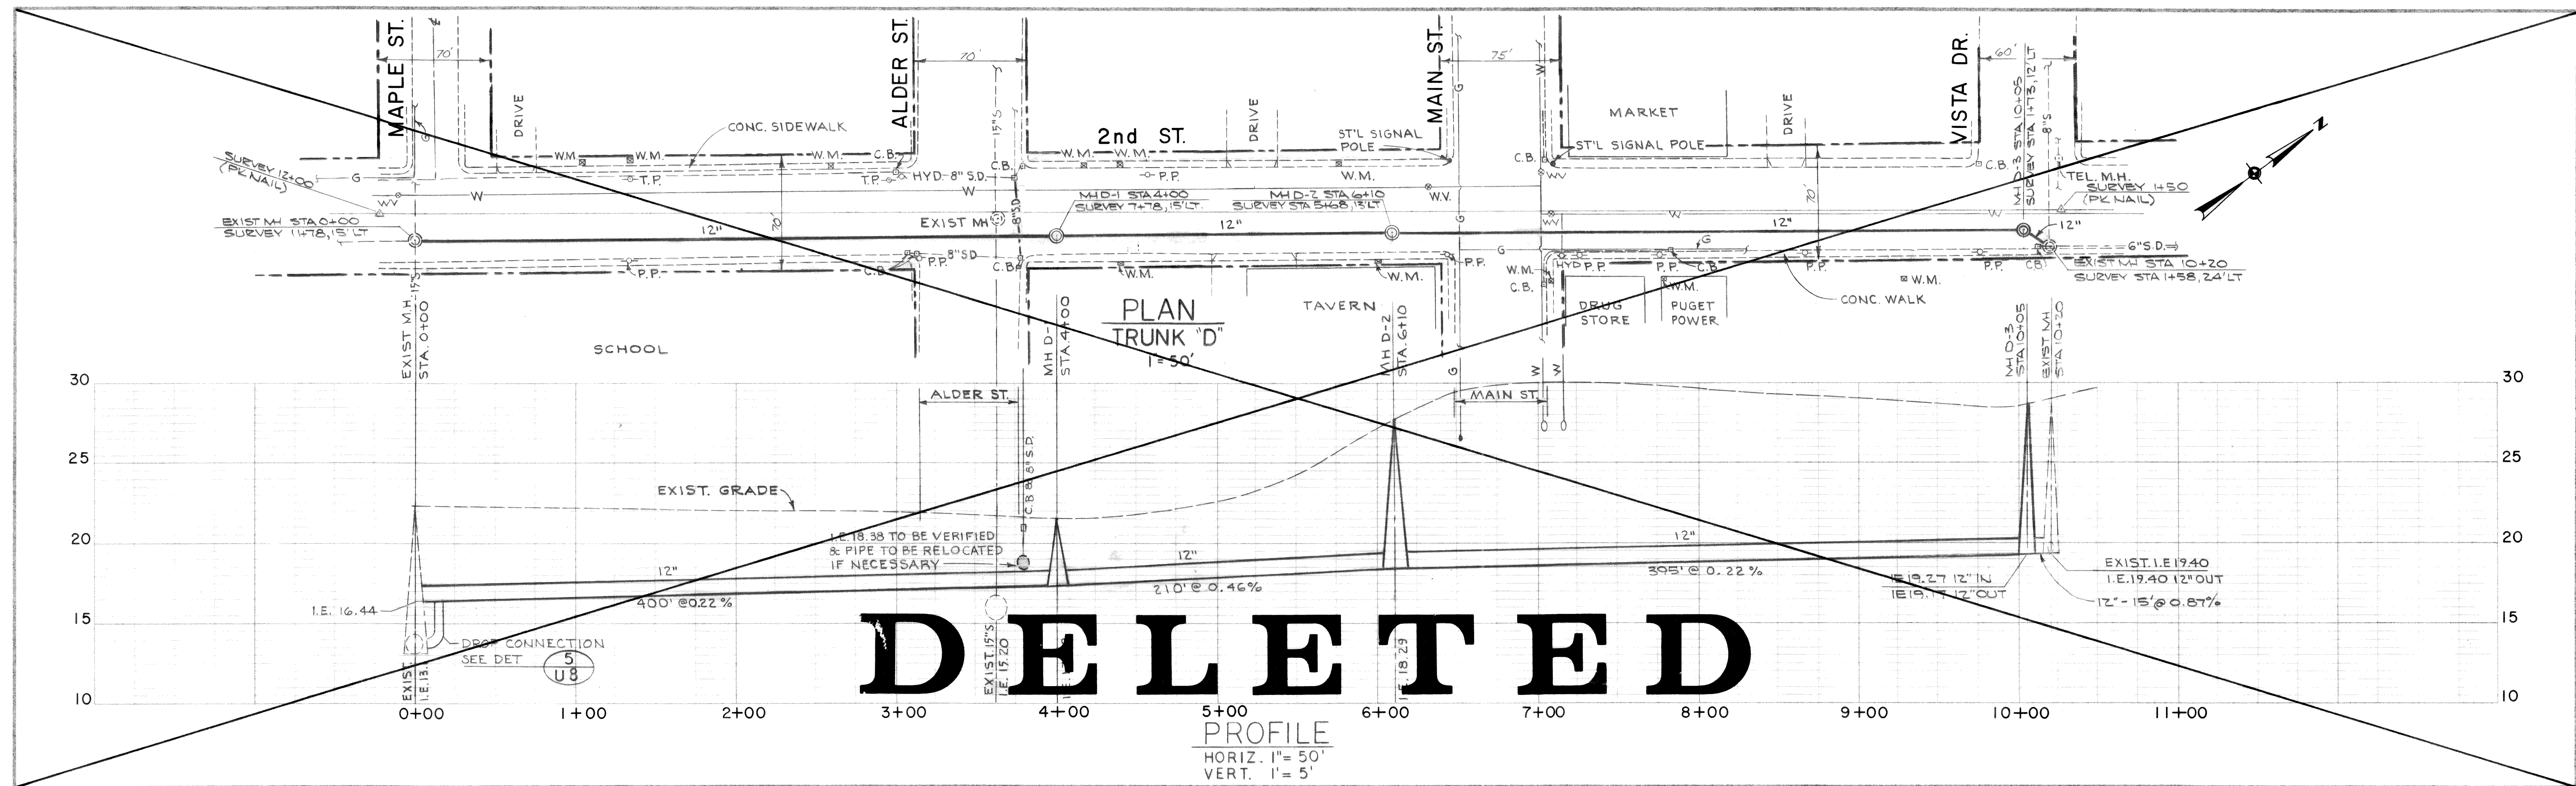


00210.037 2.7.06 PK

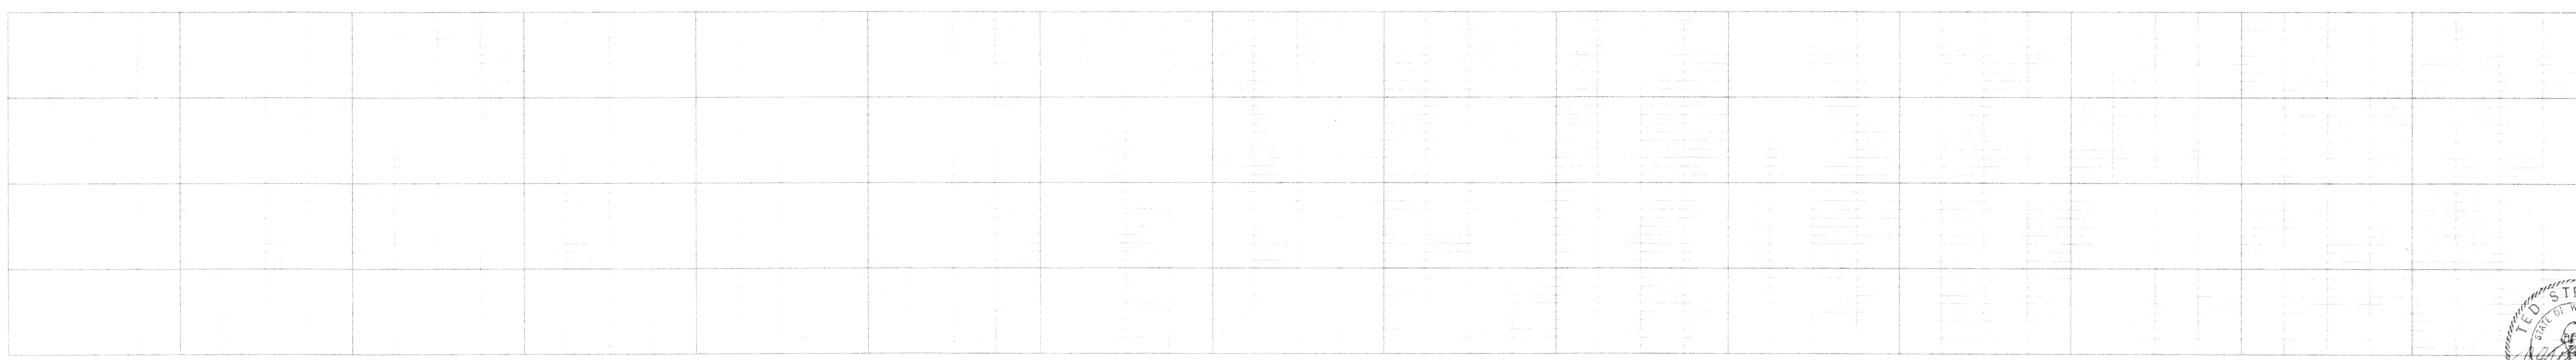


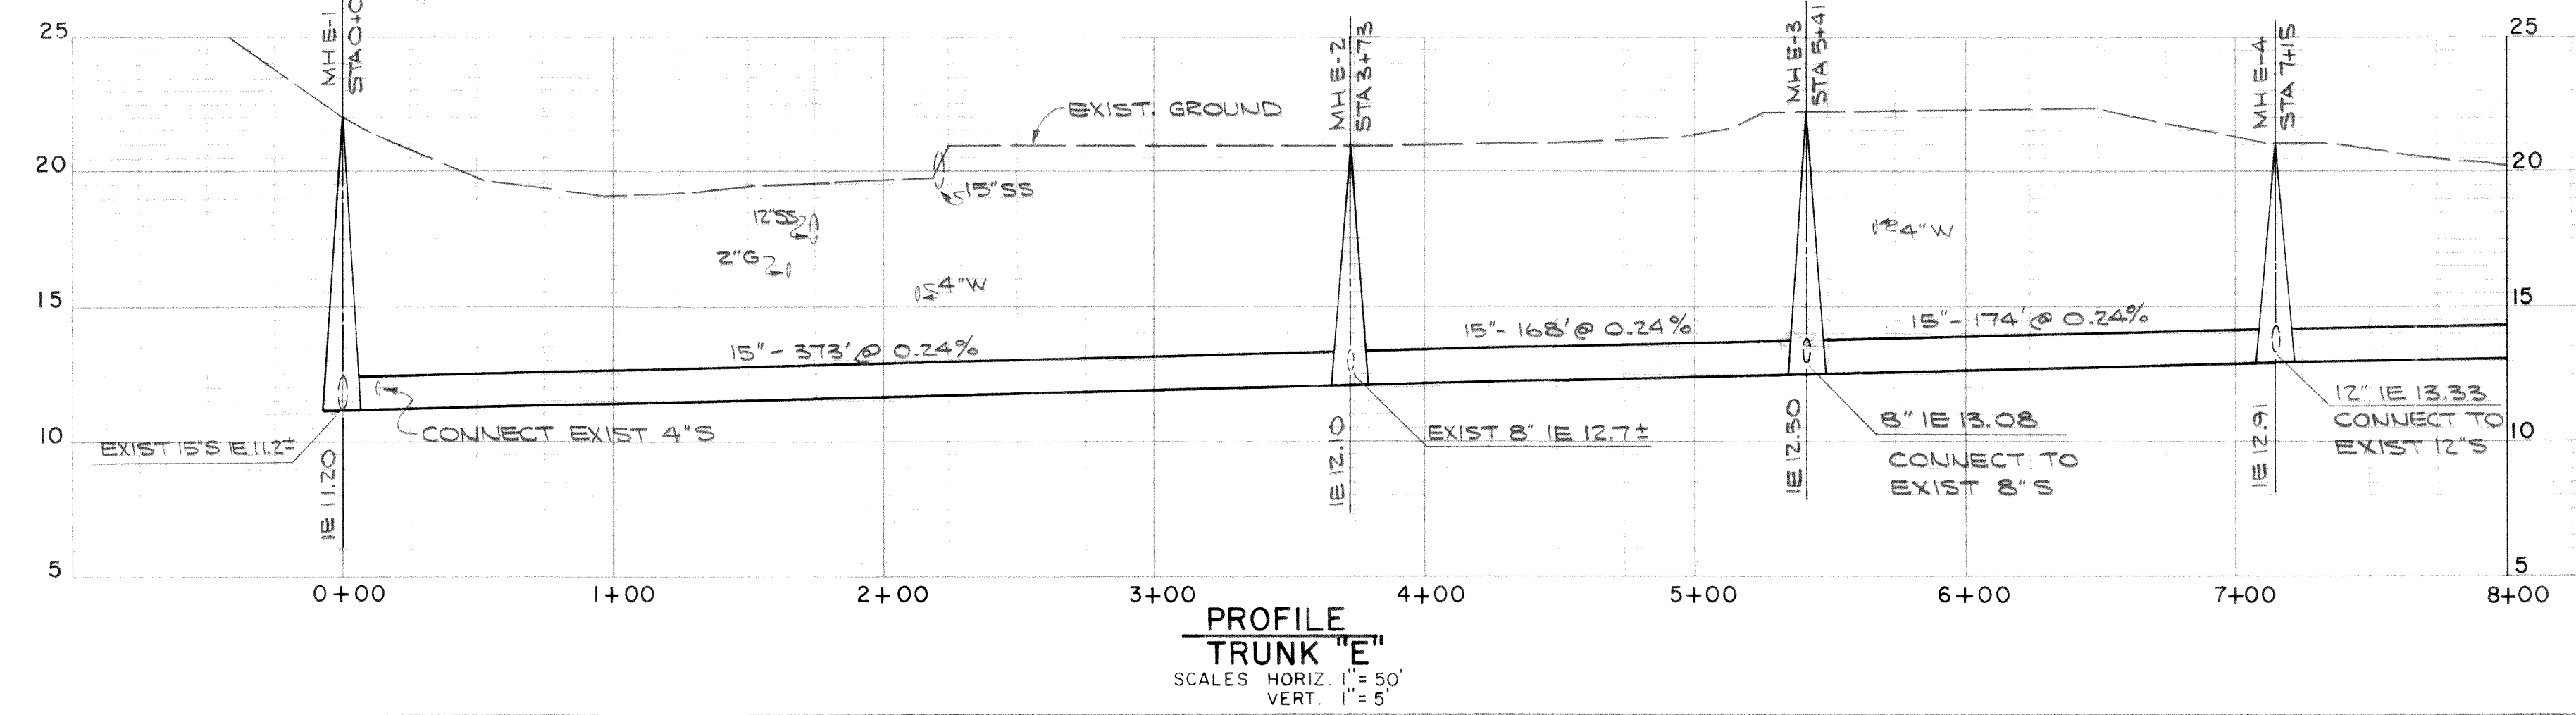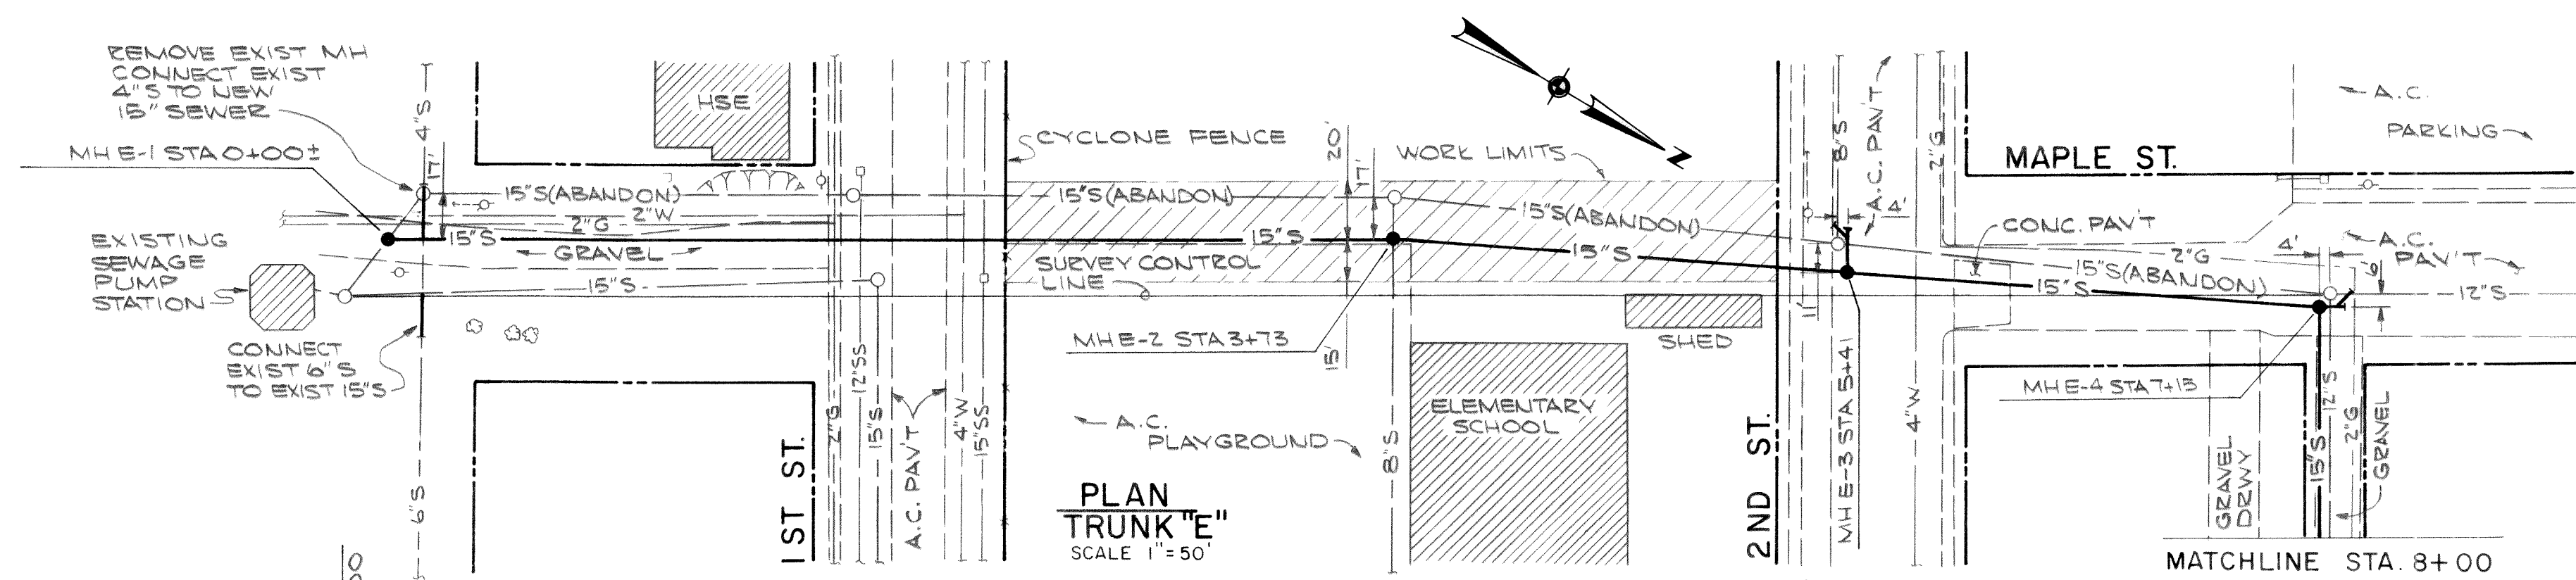


- NOTES**
- MH E-3, E-4, E-5 & E-7. CONNECT EXISTING SANITARY SEWER TO NEW M.H. PER DETAIL 1 U9
 - MH E-1. INSTALL NEW M.H. OVER EXISTING SANITARY SEWER PER DETAIL 2 U9
 - MH E-2. INSTALL NEW M.H. OVER EXISTING SANITARY SEWER PER DETAIL 3 U9
 - CONNECT EXISTING SIDE SEWERS WHICH ARE IN USE TO NEW SANITARY SEWER PER DETAIL 4 U9
 - ABANDON EXISTING SANITARY SEWER. SEE SPECIFICATIONS.
 - EXISTING SIDE SEWERS NOT SHOWN. LOCATE IN FIELD.

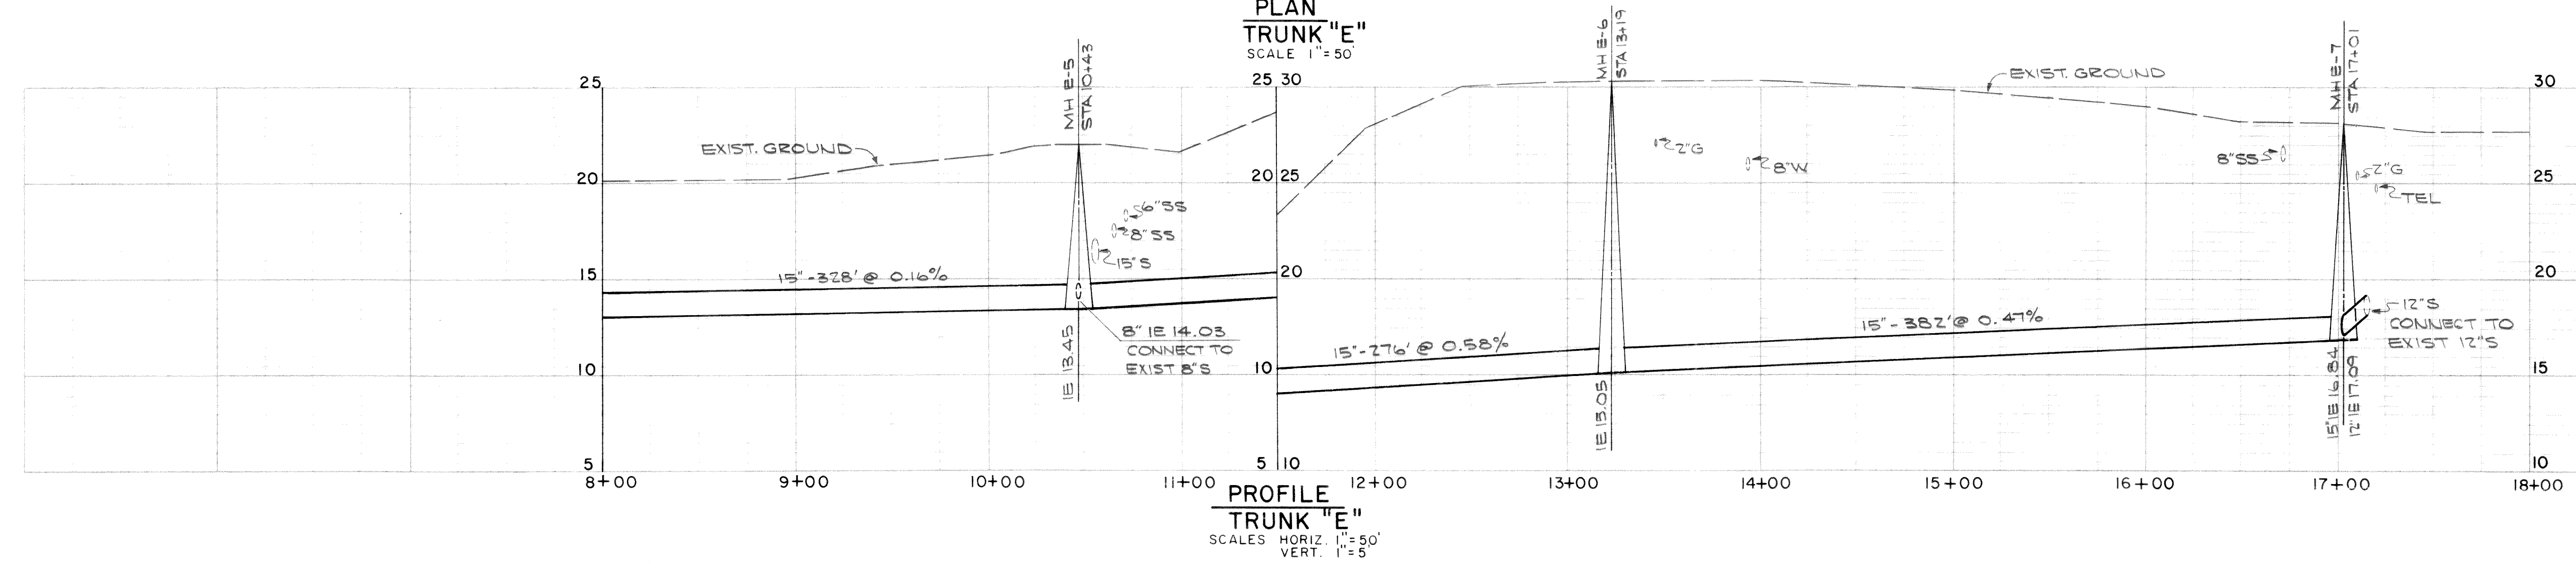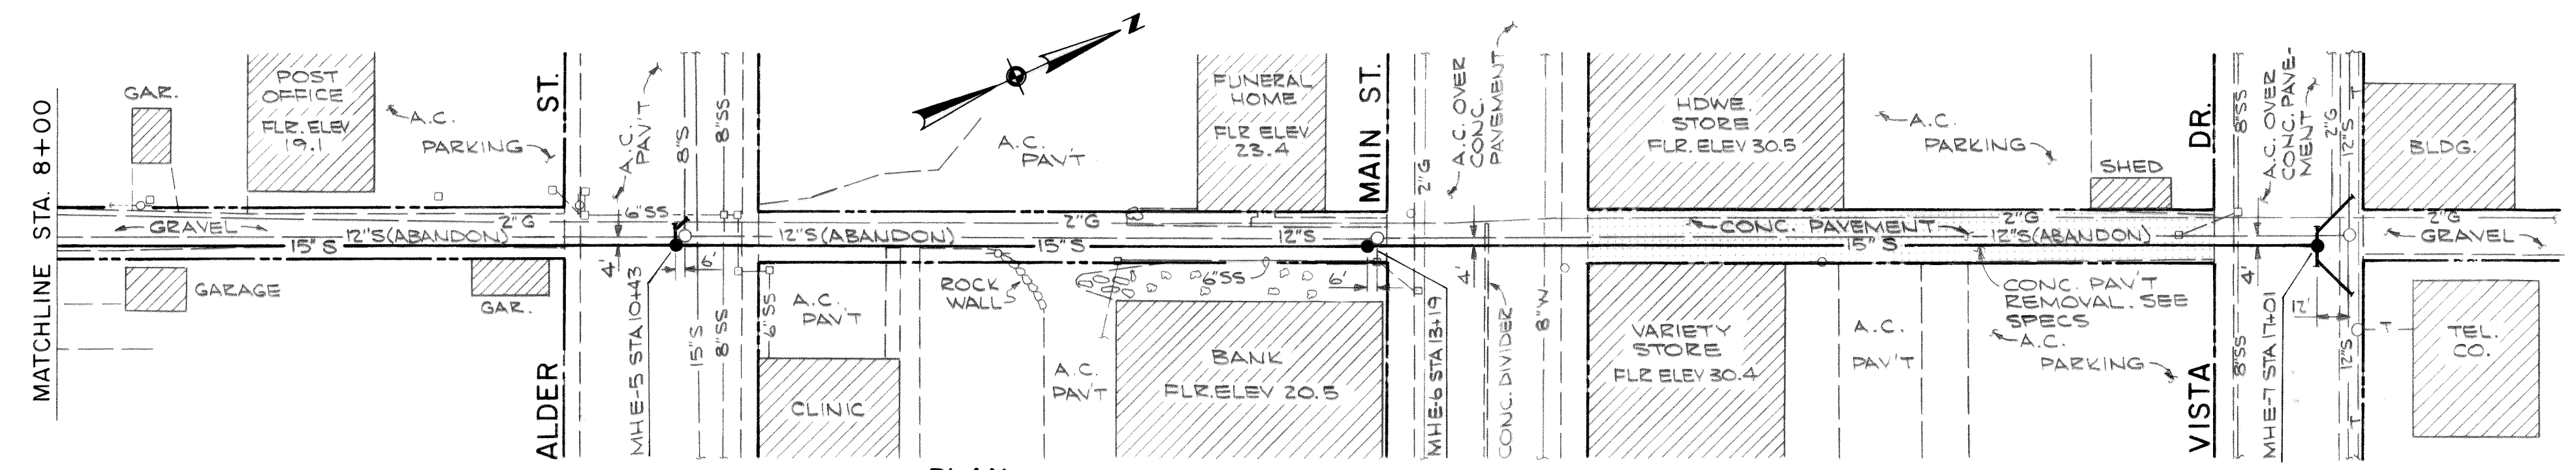

MICROFILMED

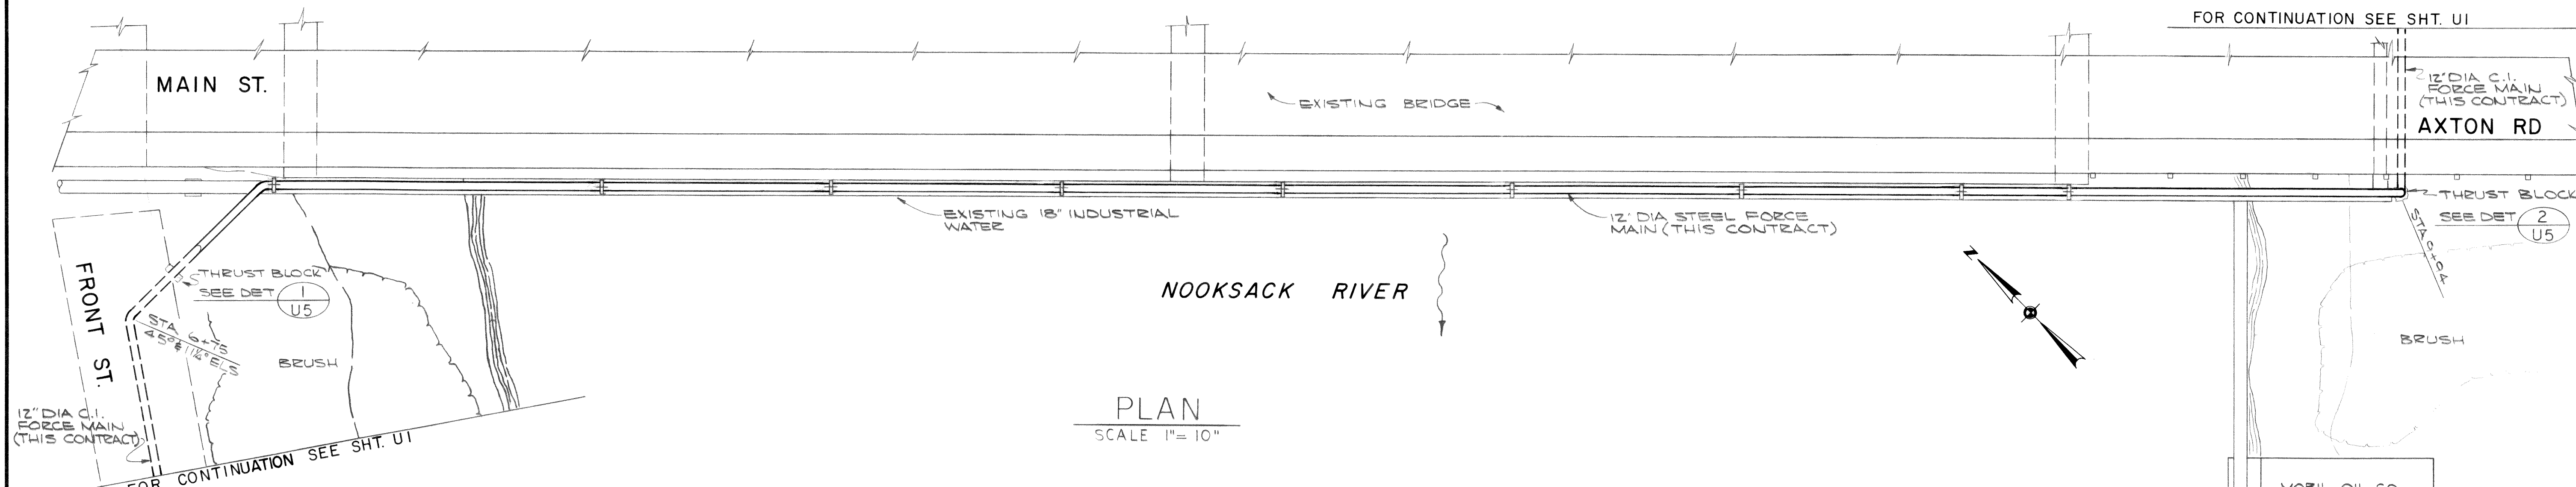


PLAN
SCALE 1" = 10'

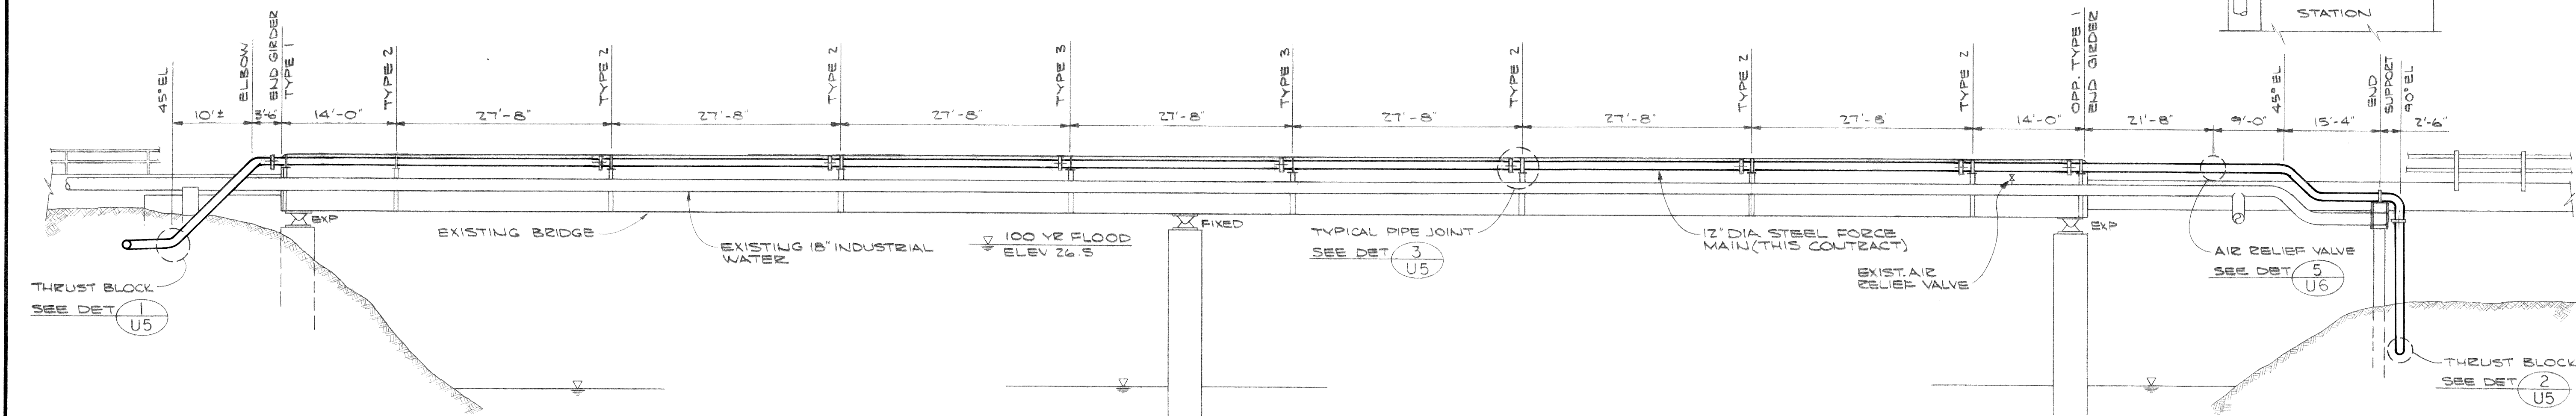


ELEVATION
SCALE 1" = 10'

NOTES:


1. Caution: Do not disturb existing 18-inch water line when installing new support bracket at each end of bridge. This line must remain in operation at all times. Temporary shoring of pipe subject to approval of engineer.
2. All location dimensions are approximate only and must be verified by contractor. Verify configuration of pipe support attachment.
3. Locate pipe support to clear rivets in existing angles. Use one-eighth inch shims under pipe roll stand as necessary. Maximum shim thickness one-half inch.
4. Type 1, 2 and 3 pipe supports similar. See Sheet U6 for list of applicable details.
5. See specifications for cleaning, welding and painting.
6. Provide one-inch thick insulation with protective .016 thick aluminum jacket full length of exposed pipe. Extend into ground 2 feet.
7. Install two-inch wide aluminum bands at 1 foot 6 inches center to center. Minimum distance between joint in jacket and joint in insulation shall be 6 inches.
8. Overlap insulation and jacket at each flexible coupling as shown. Apply aluminum mastic in area shown. Install 2-inch wide aluminum bands at overlap.

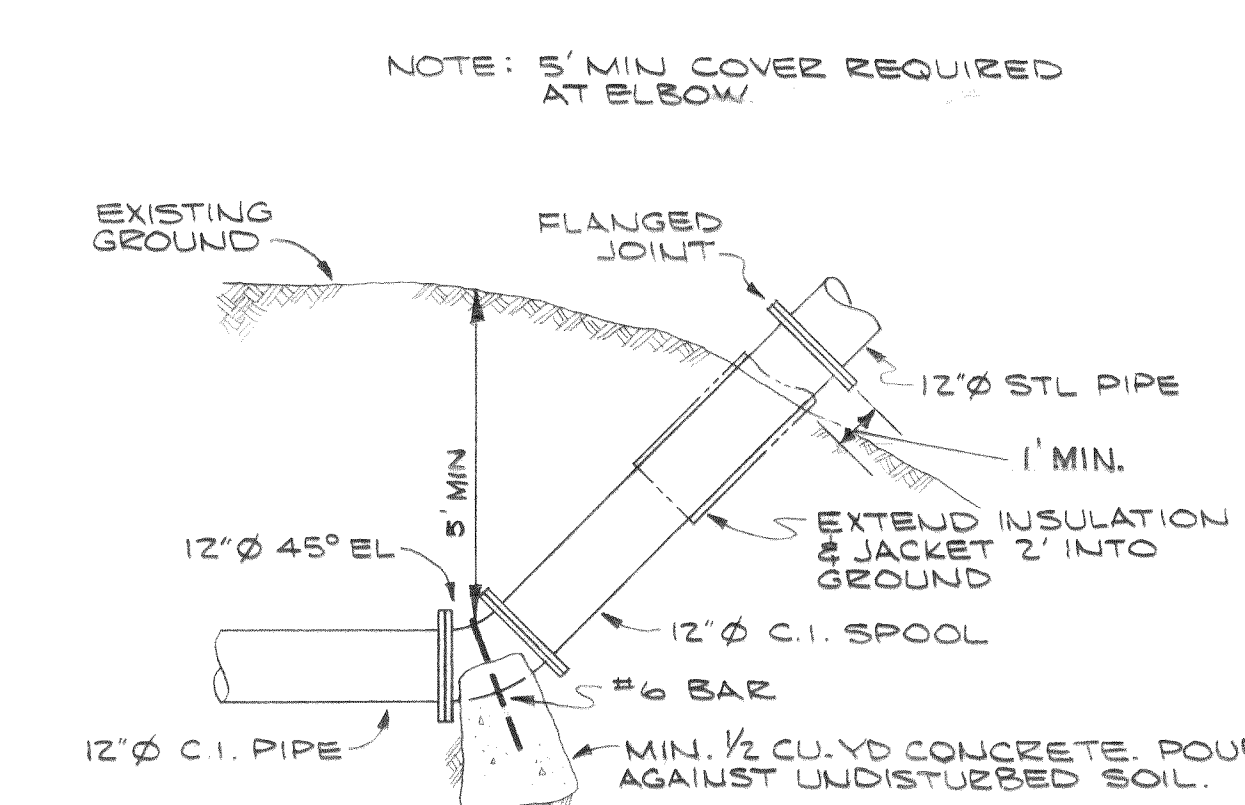


DETAIL 1
THRUST BLOCK
SCALE 3/8" = 1'-0"

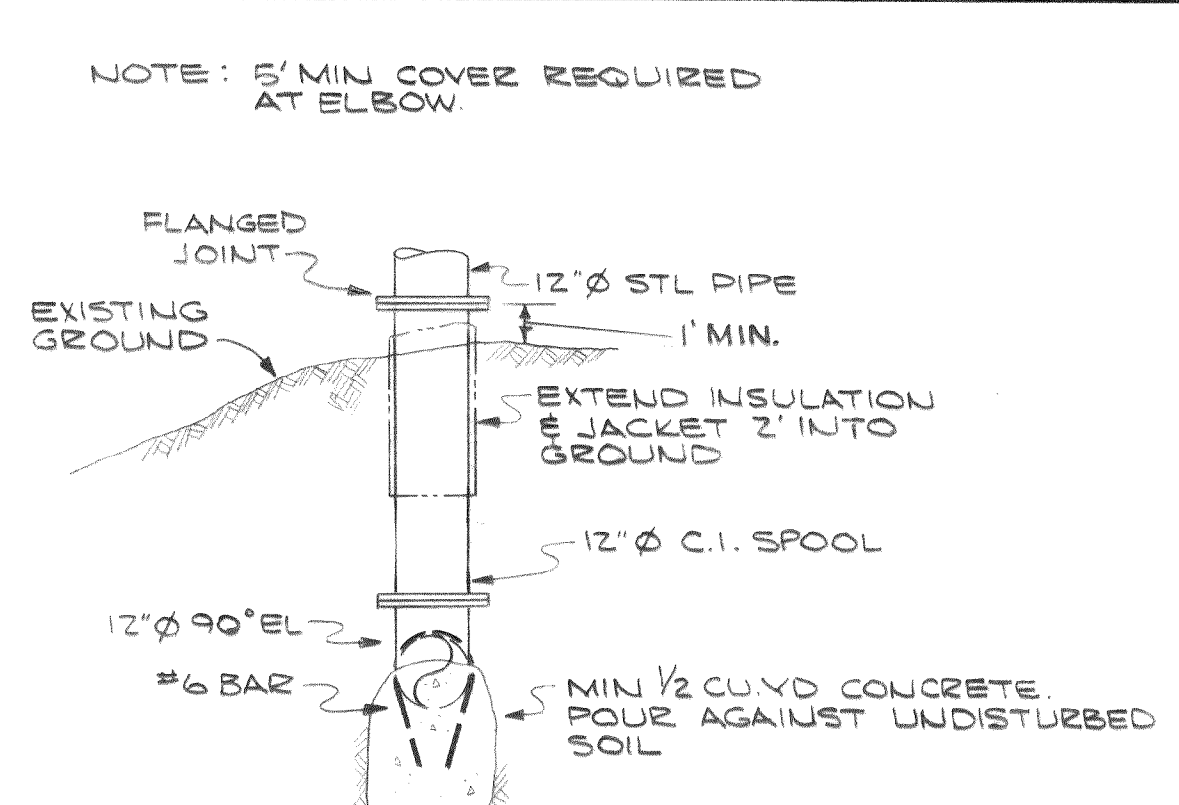

DETAIL 2
THRUST BLOCK
SCALE 3/8" = 1'-0"

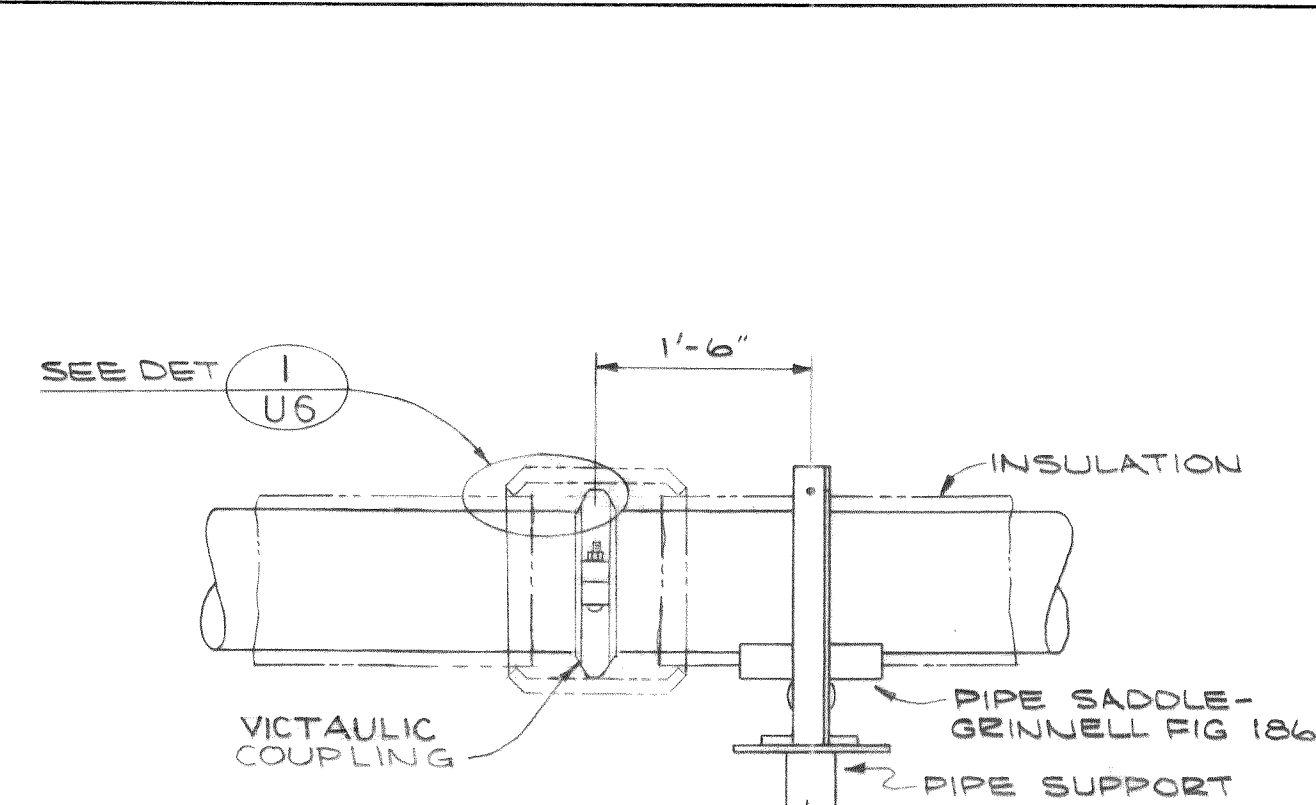

DETAIL 3
TYPICAL PIPE JOINT
SCALE 3/8" = 1'-0"

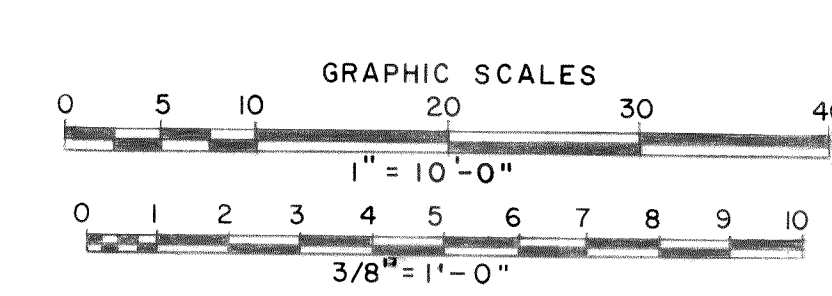

DESIGNED	RDU	APPROVED	<i>[Signature]</i>
DRAWN	J.M.H.	SCALE	AS SHOWN
DATE		DATE	JULY, 1972
NO.		FILE	71-S-425.002
REVISION			













Stevens, Thompson & Runyan, Inc.
Engineers/Planners
PORTLAND SEATTLE BOISE

TOWN OF FERNDAL, WASHINGTON
AXTON ROAD INTERCEPTOR
SCHEDULE II

NOOKSACK RIVER
BRIDGE CROSSING


U5
8

MICROFILMED

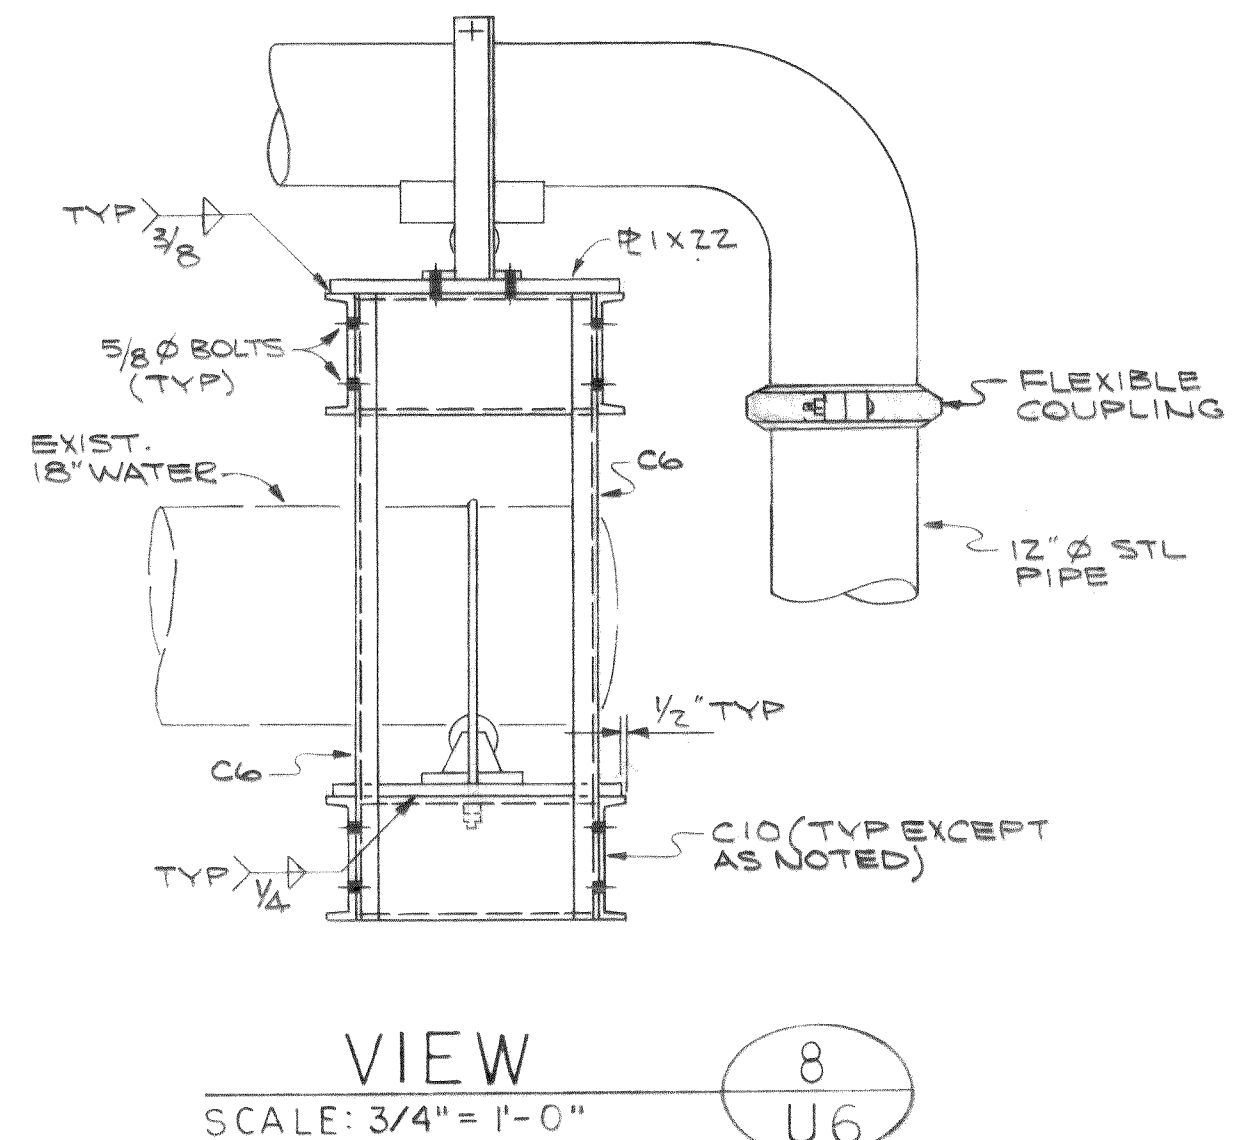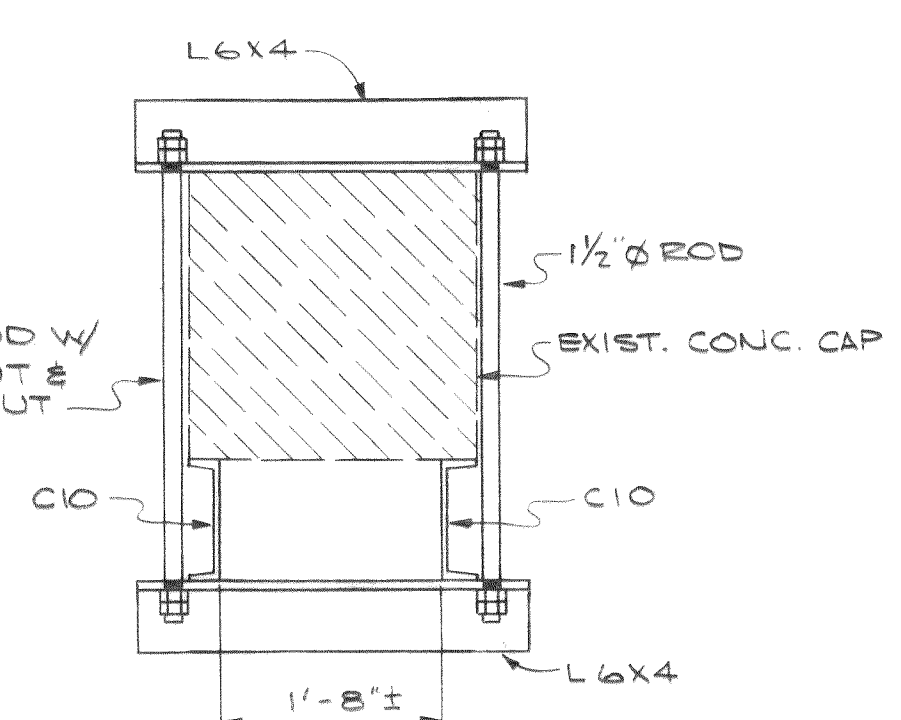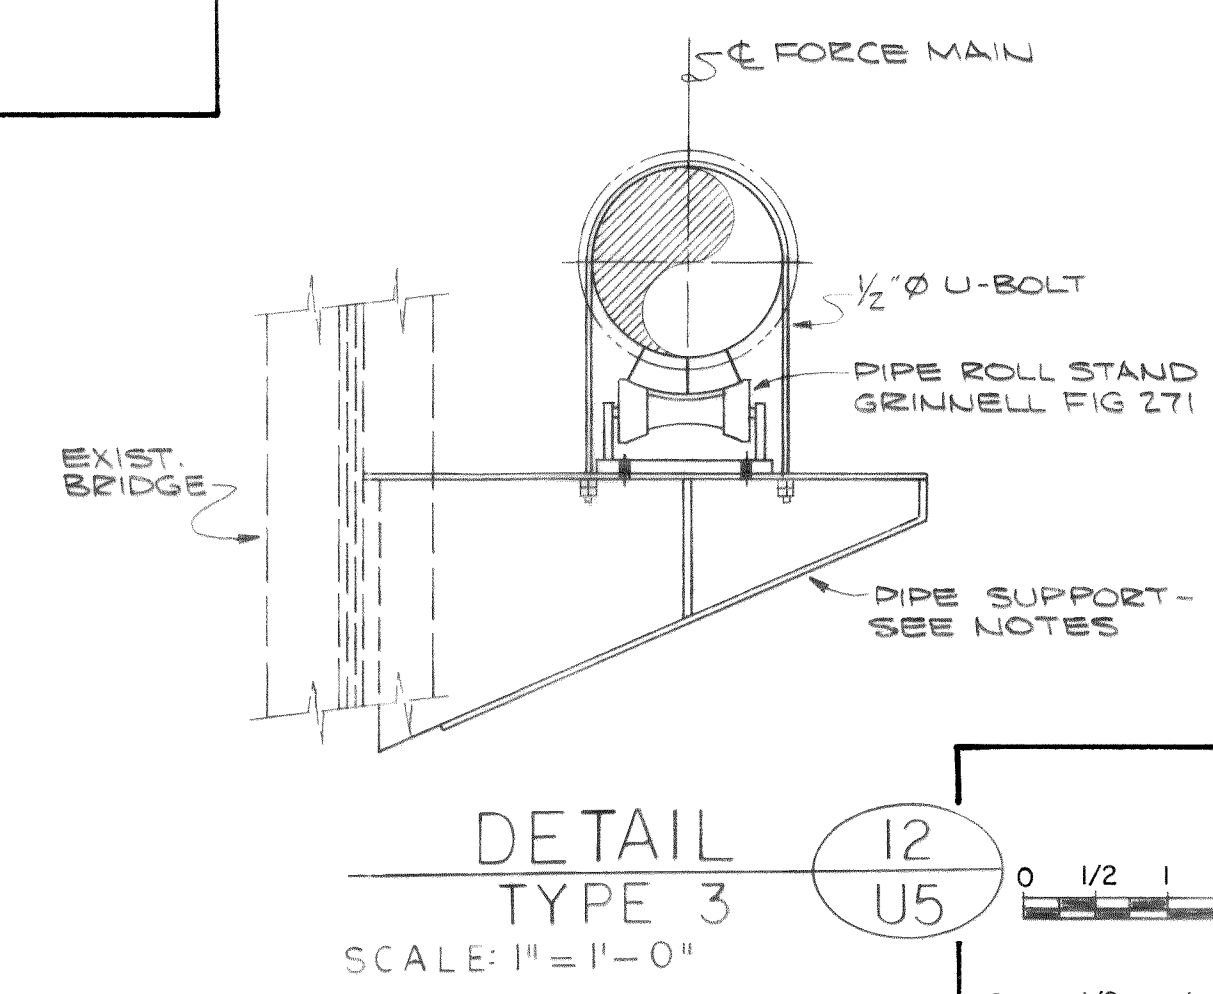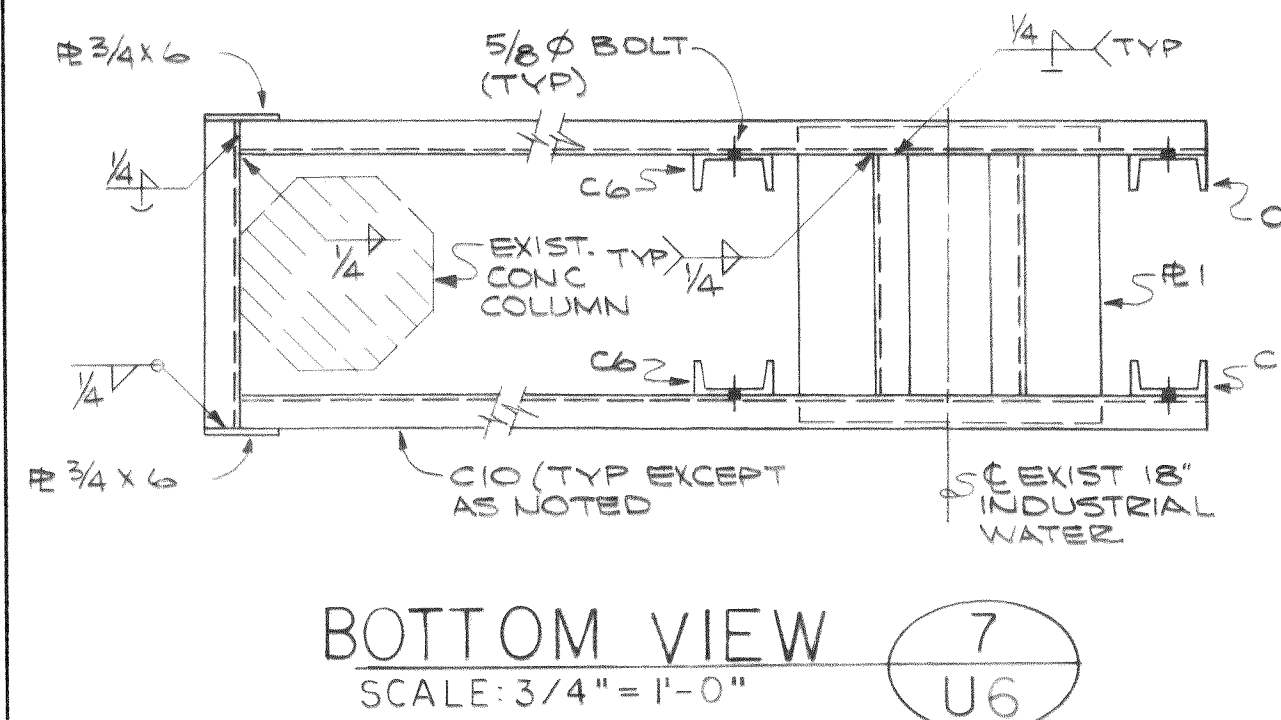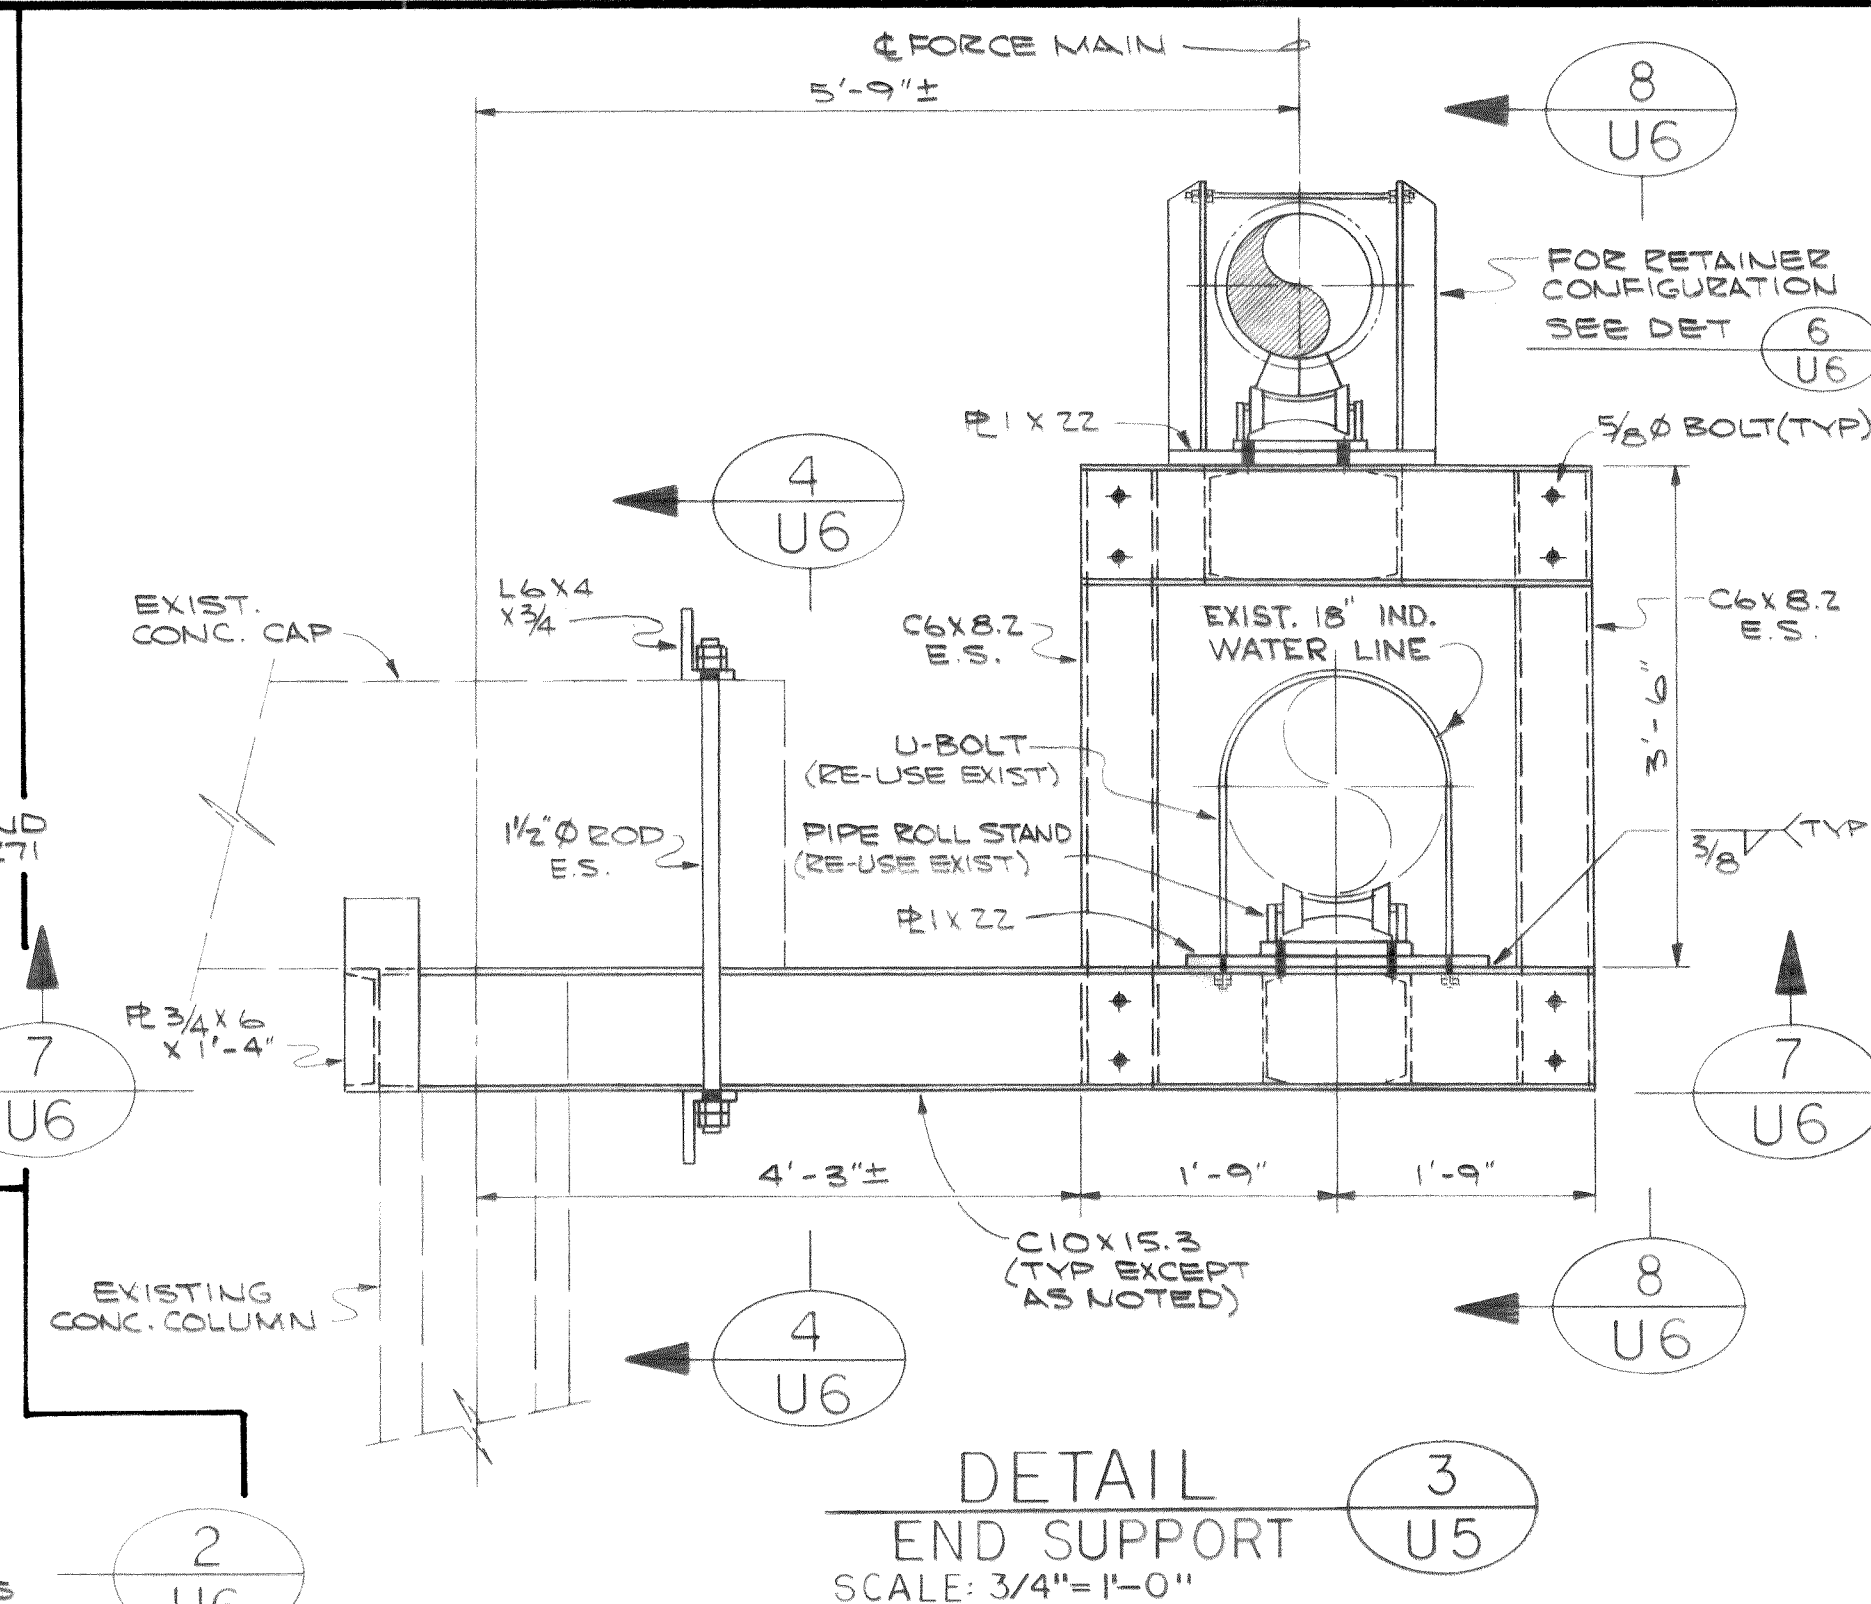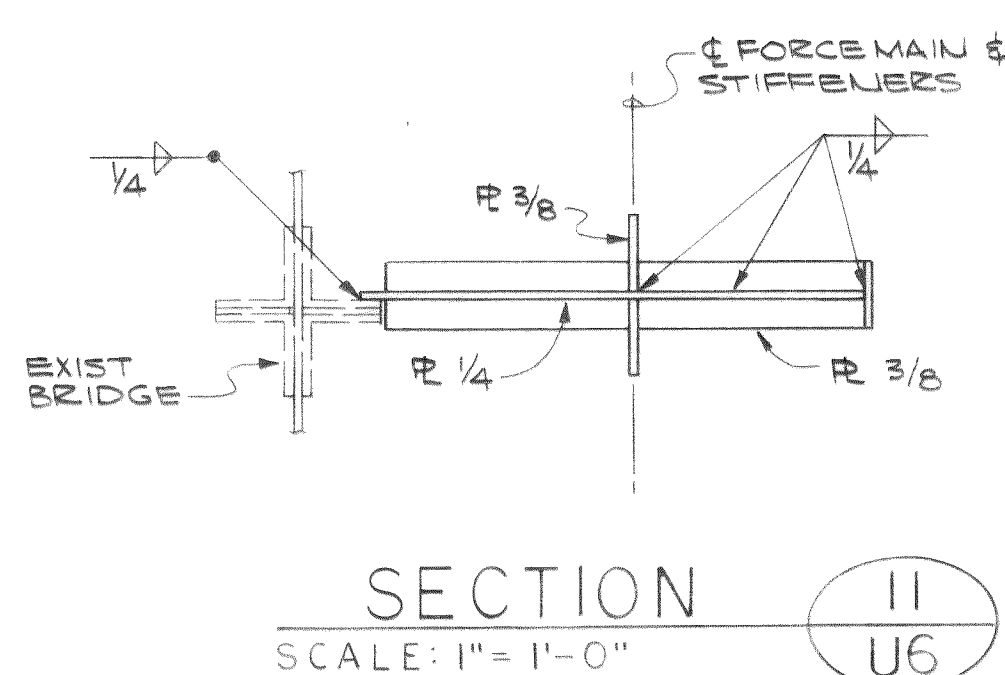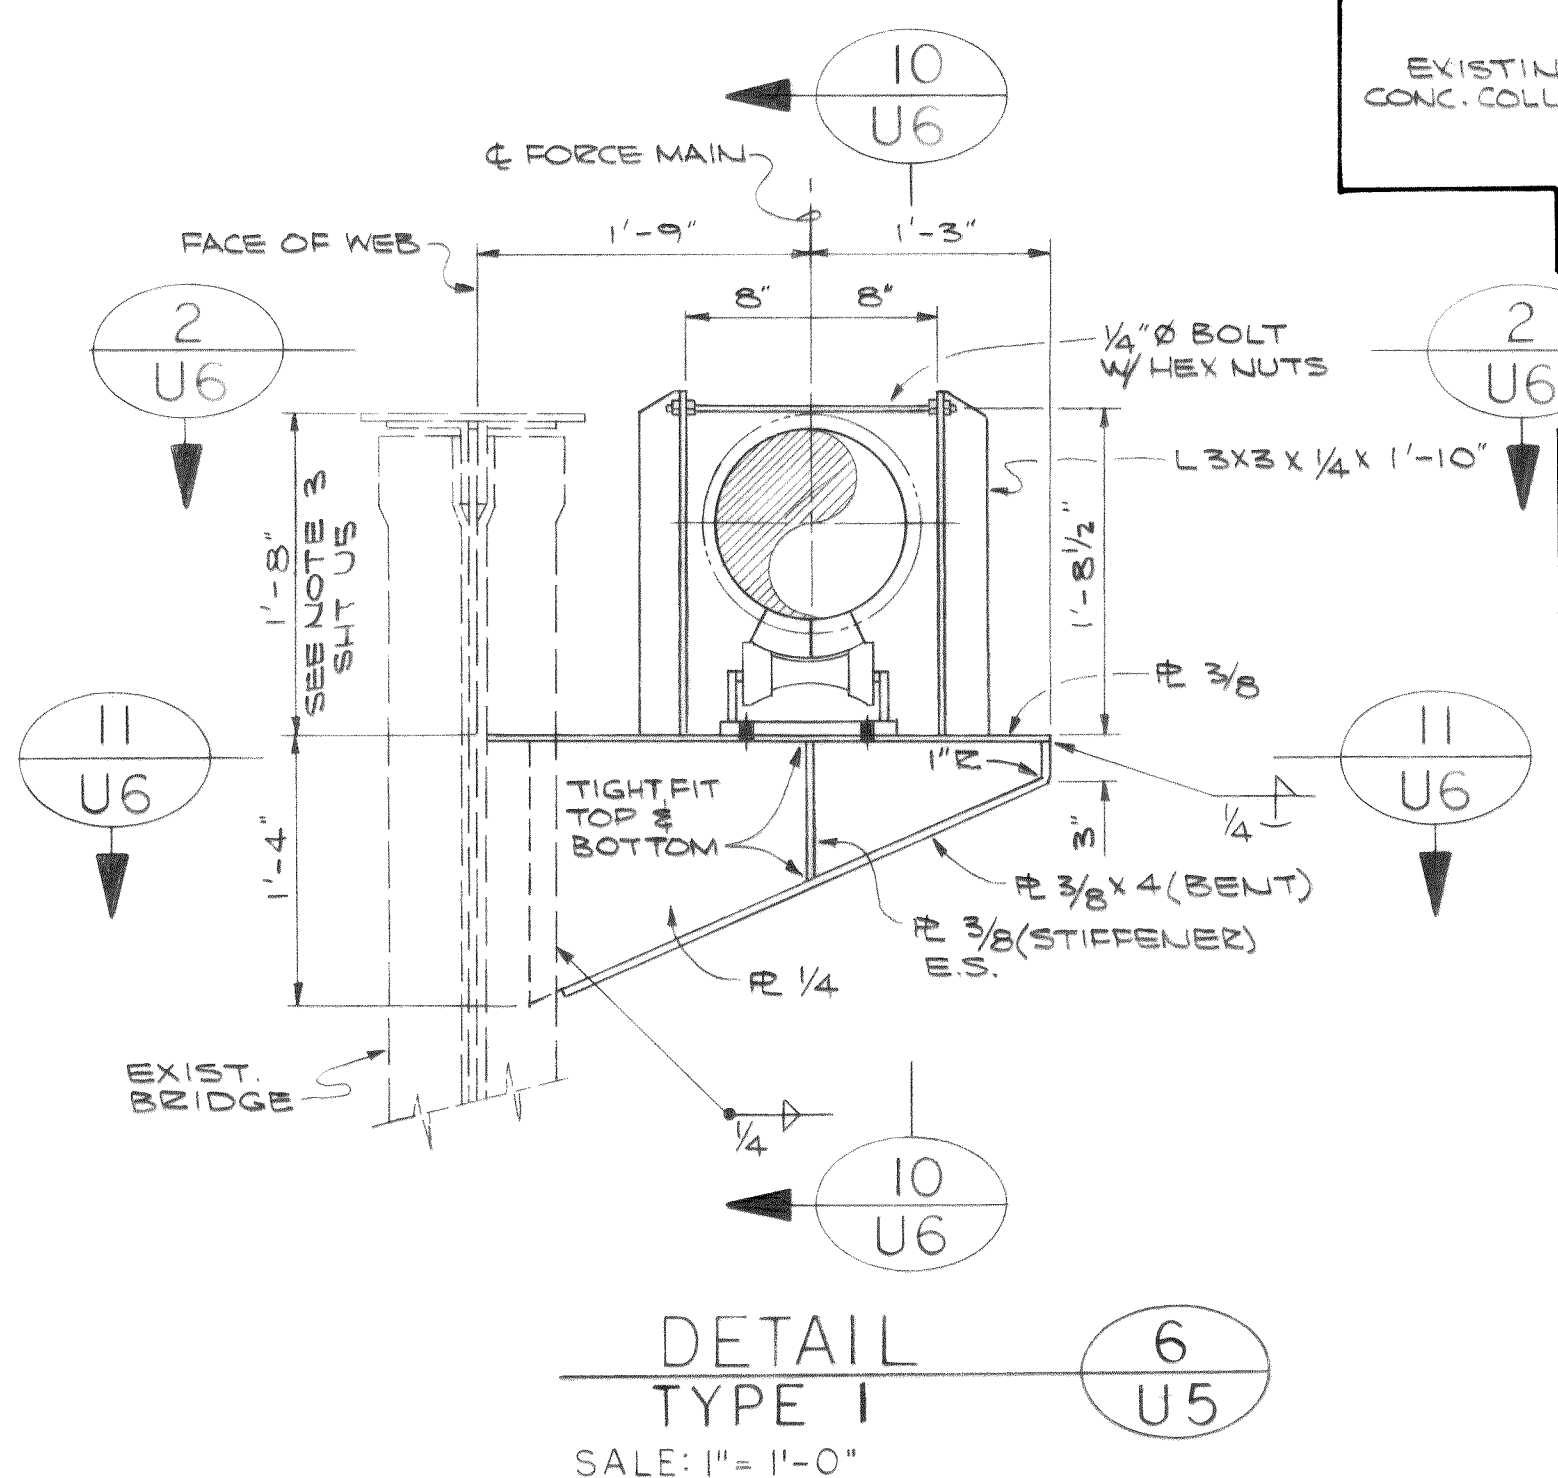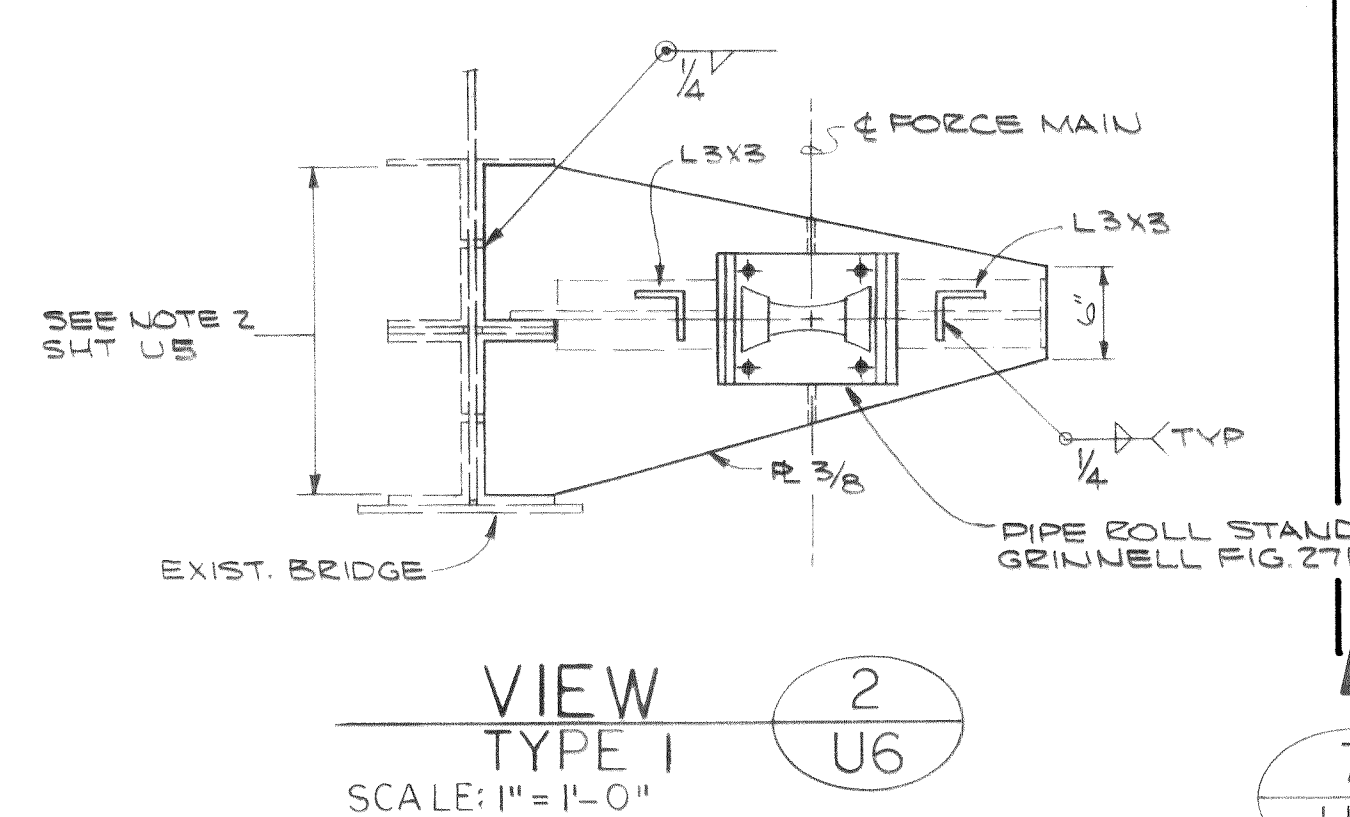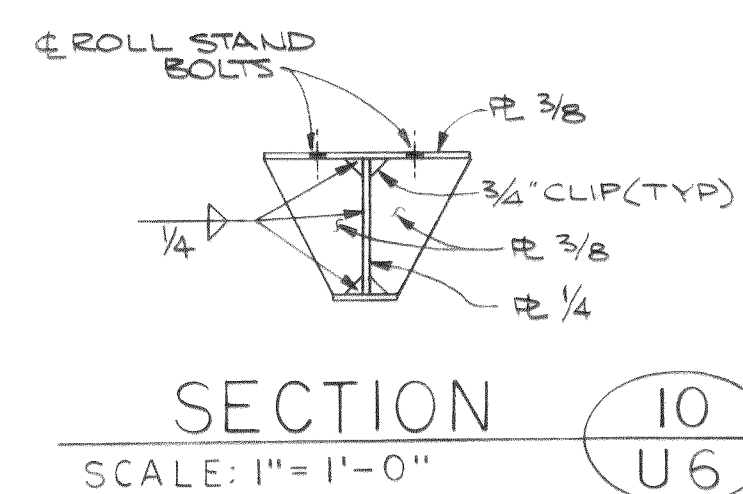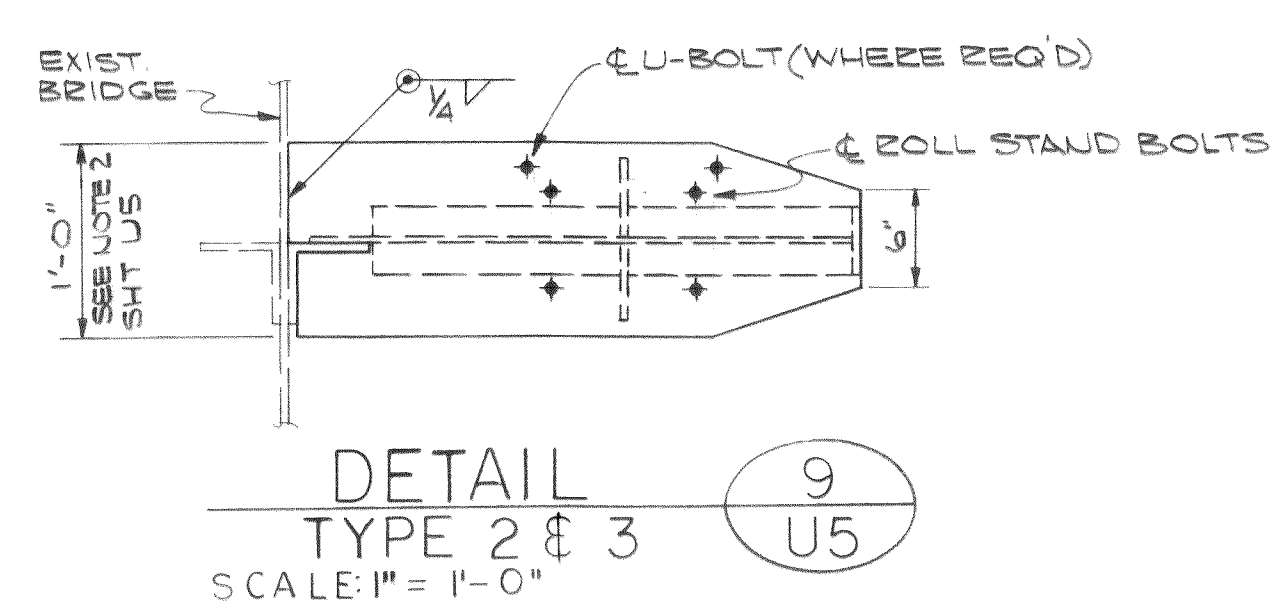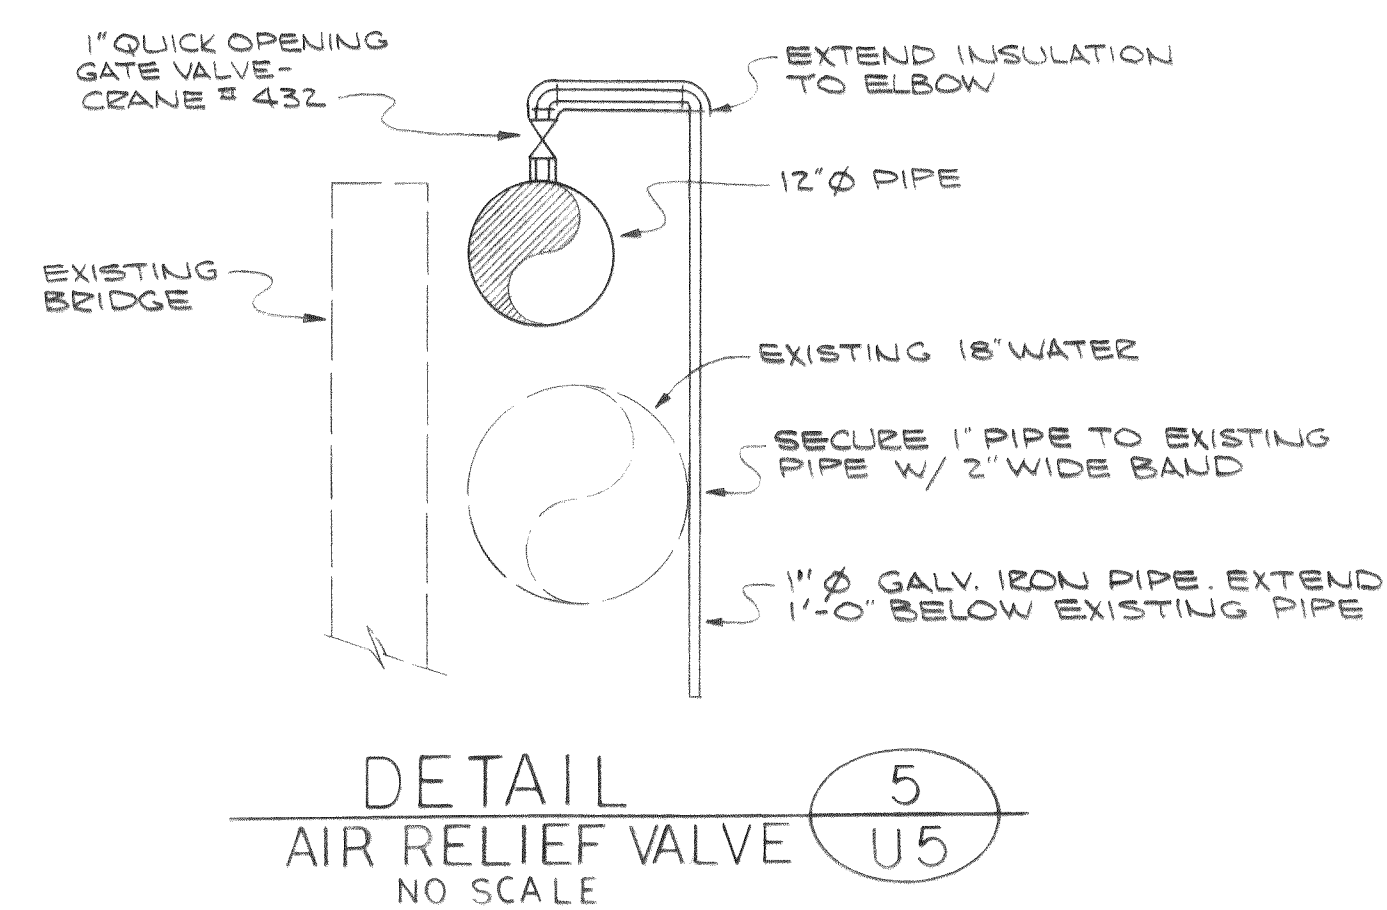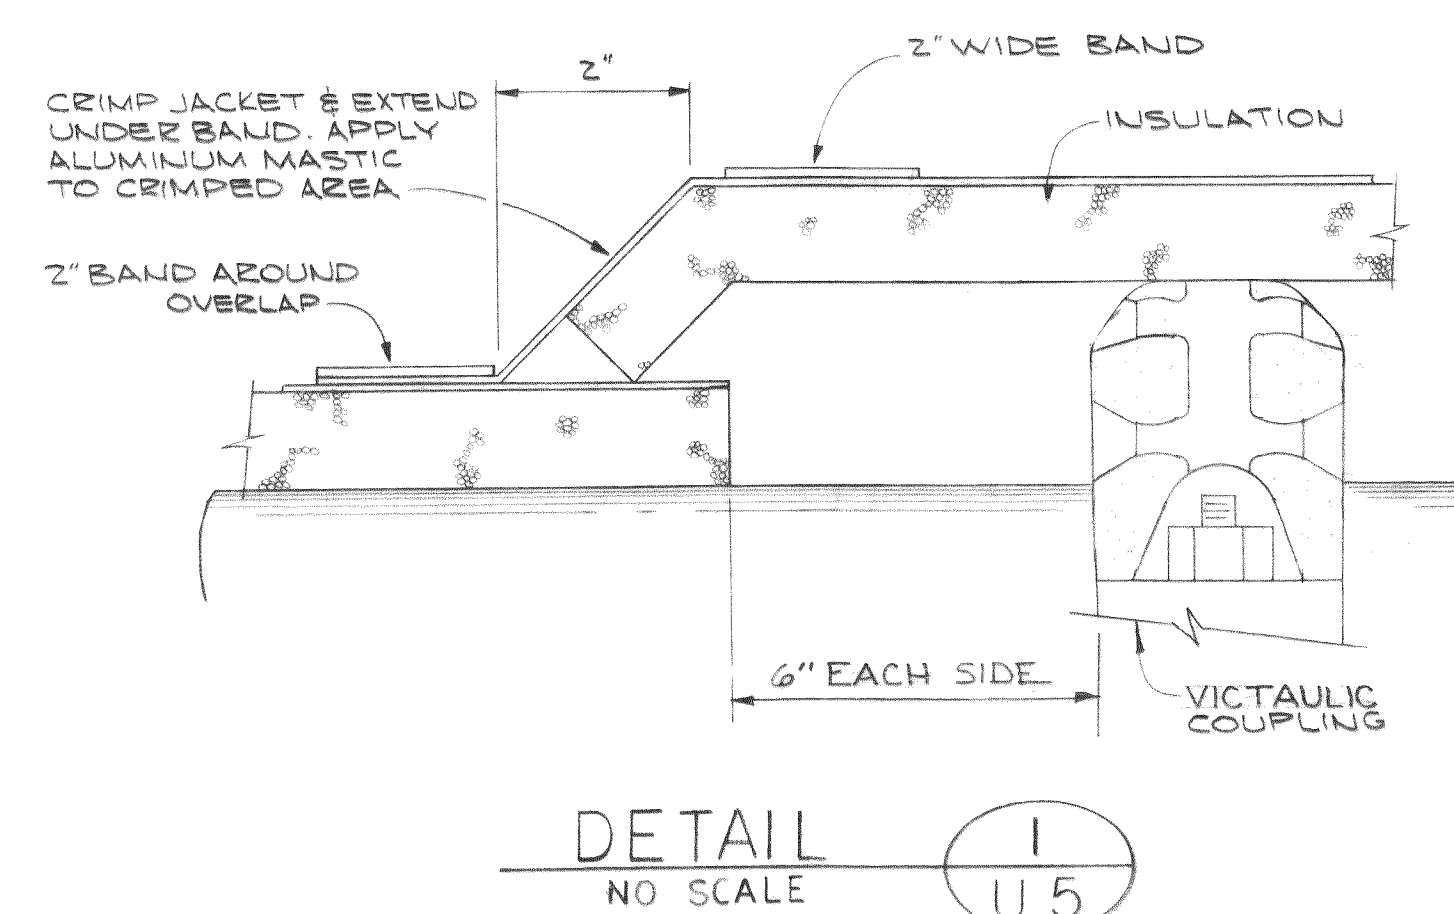


- NOTES:

- 5
- | | |
|-----------------|-------------------------------|
| Type 1 Support: | |
| Plan | See View 2 |
| Elev. | See Detail 6 |
| Sections | See Sections 10 & 11 |
| Type 2 Support: | |
| Plan | See Detail 9 |
| Elev. | See Detail 6 |
| Sections | See Sections 10 & 11 |
| Type 3 Support: | |
| Plan | See Detail 9 |
| Elev. | (Support Only) See Detail 6 |
| Elev. | (Retainer Only) See Detail 12 |
| Sections | See Sections 10 & 11 |

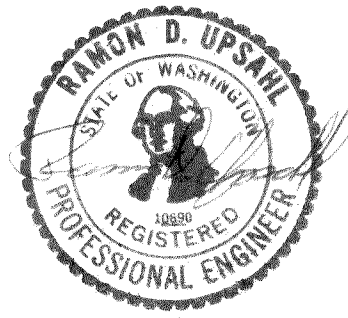


00210.041.2-7.66 KR

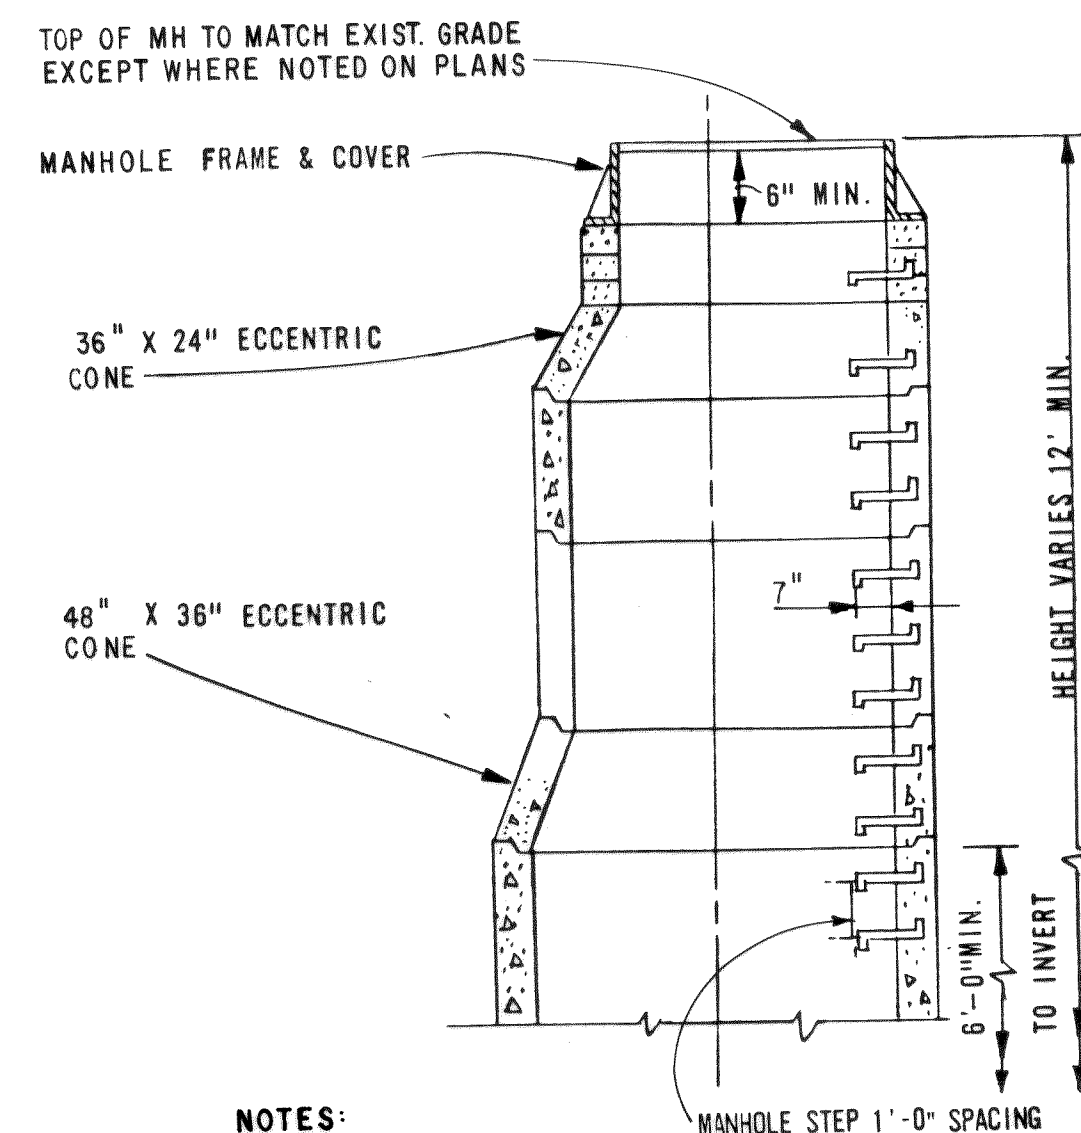


- NOTES:
- 1) ALTERNATE FOR MANHOLES OVER 12' IN HEIGHT
 - 2) SEE STANDARD MANHOLE (THIS SHEET) FOR CONSTRUCTION DETAILS.


TAPERED MANHOLE 1
NO SCALE UI-U4

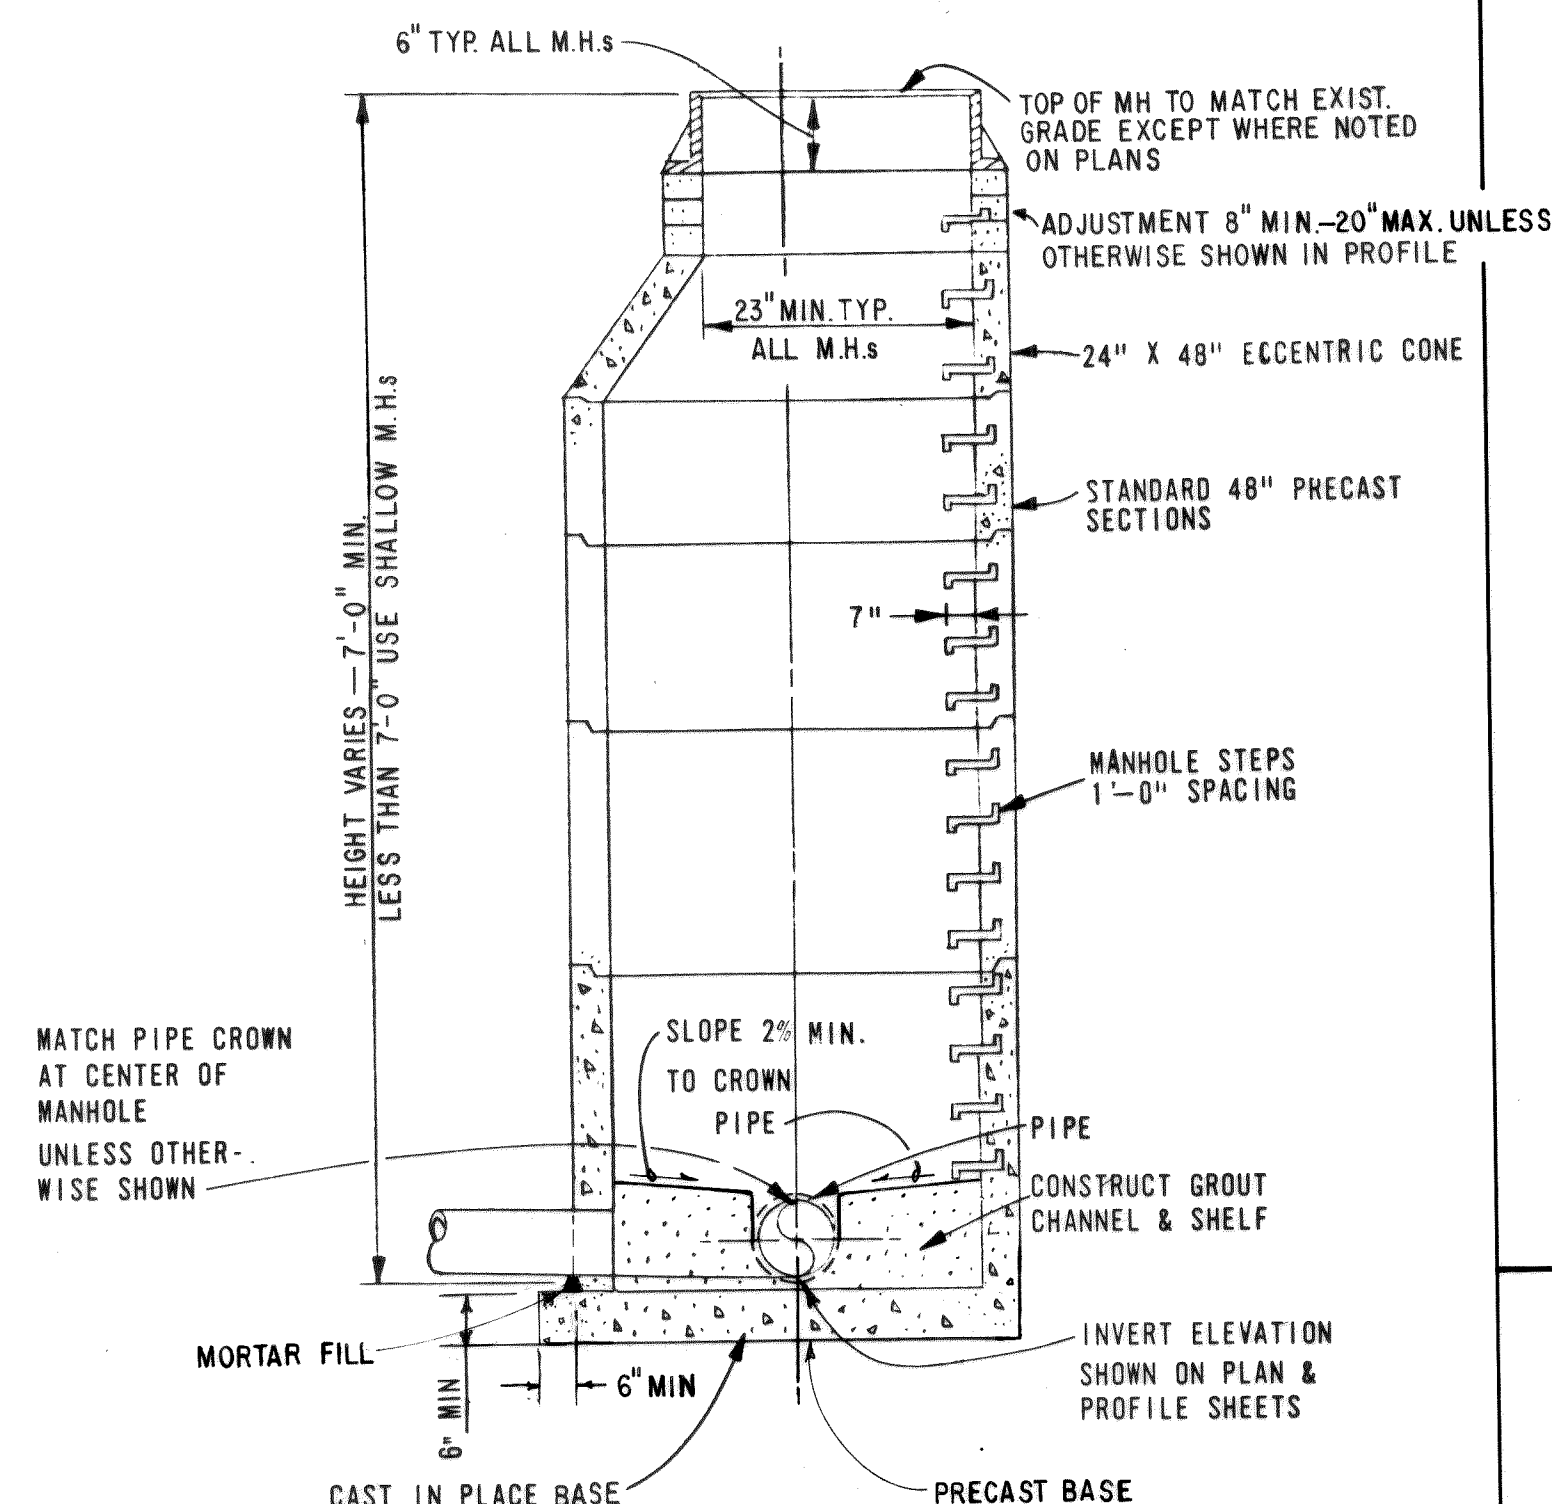


STANDARD MANHOLE 2
PIPE SIZE 21" & SMALLER UI-U4
NO SCALE

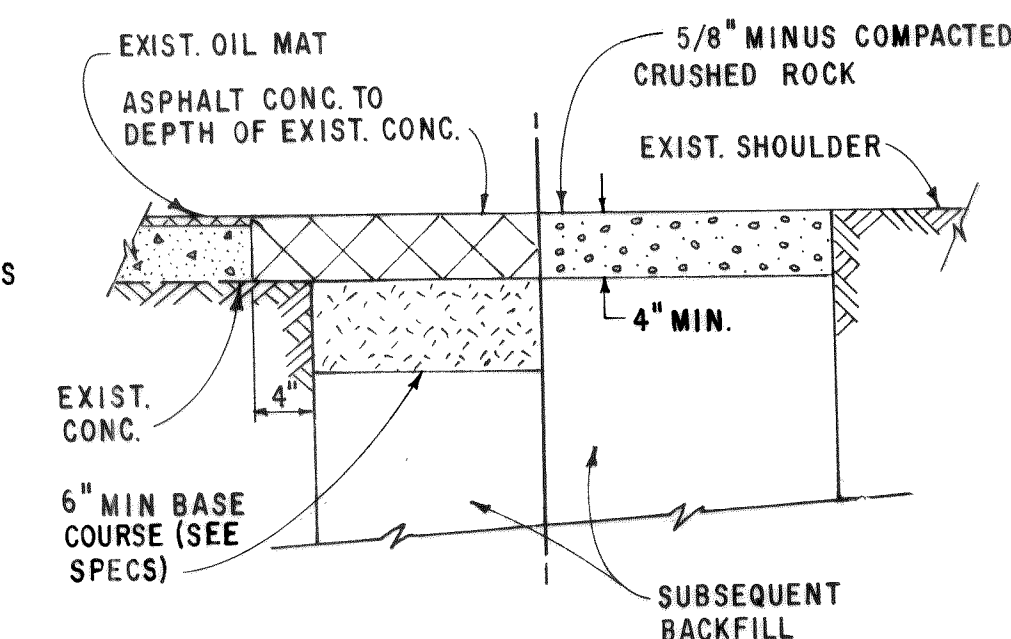


SURFACE RESTORATION 3
NO SCALE UI-U5

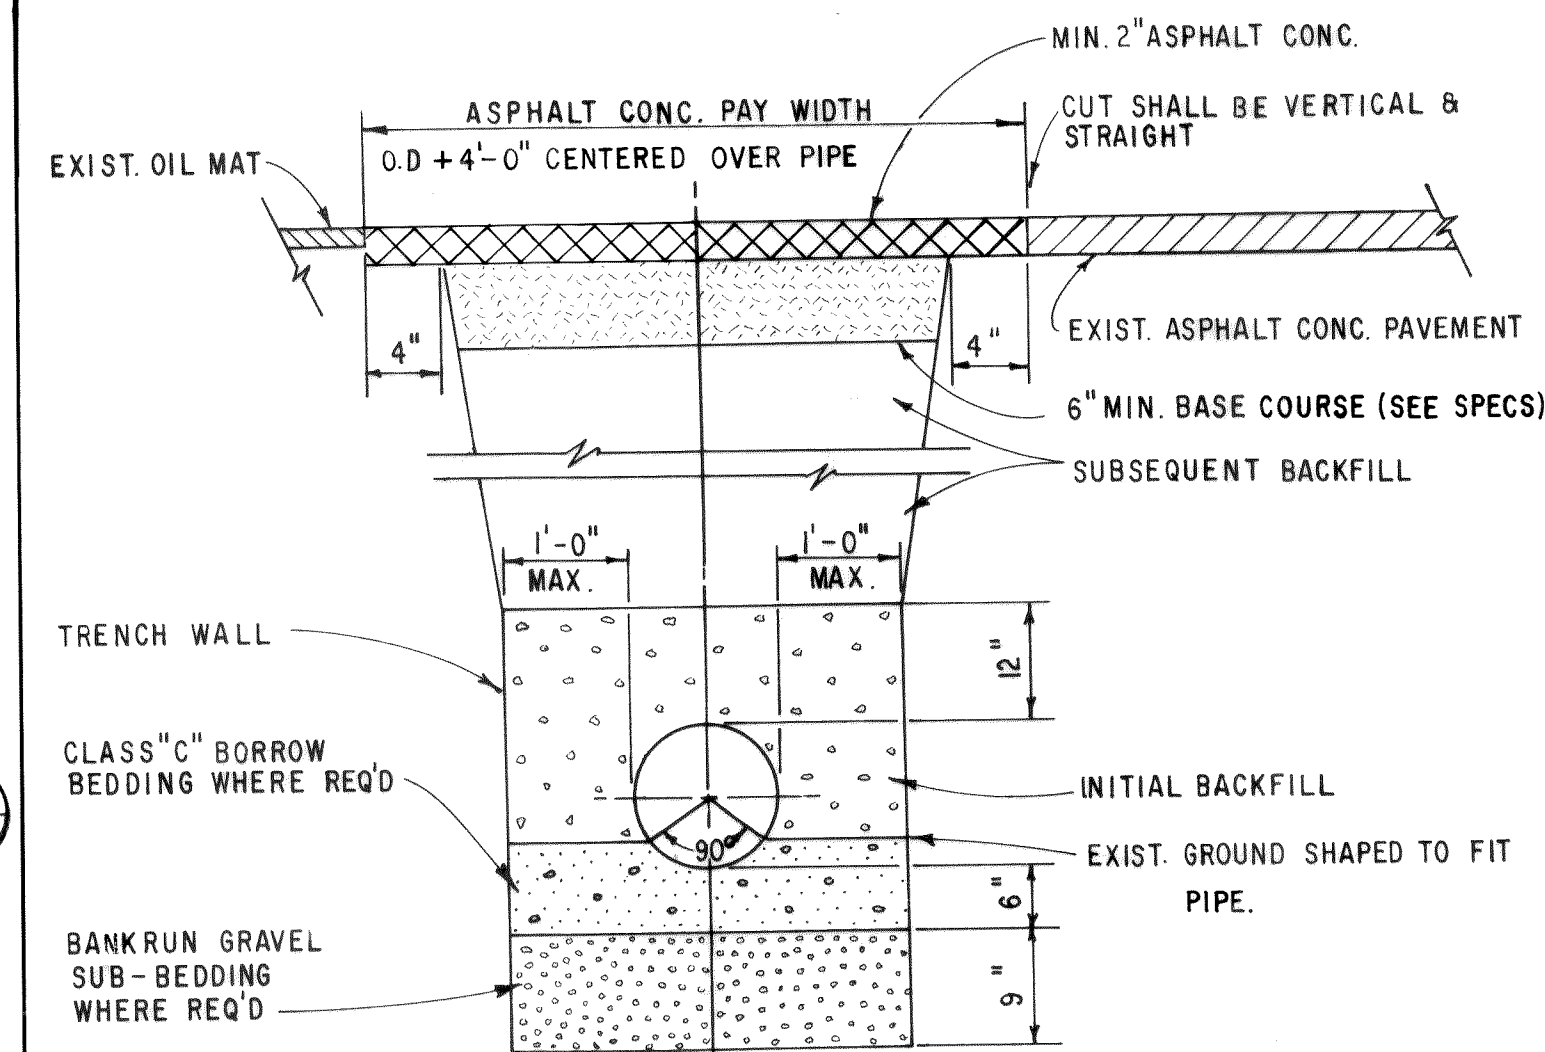


TYPICAL TRENCH 4
NO SCALE UI-U5

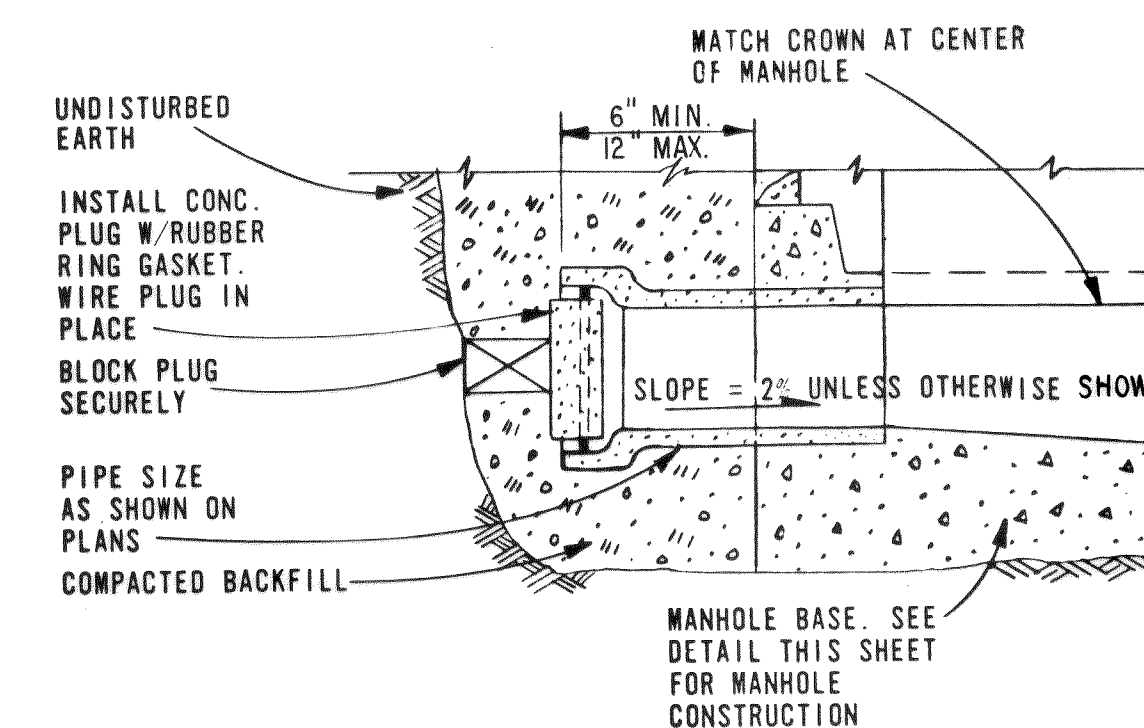


TYPICAL STUB 8
NO SCALE UI-U3

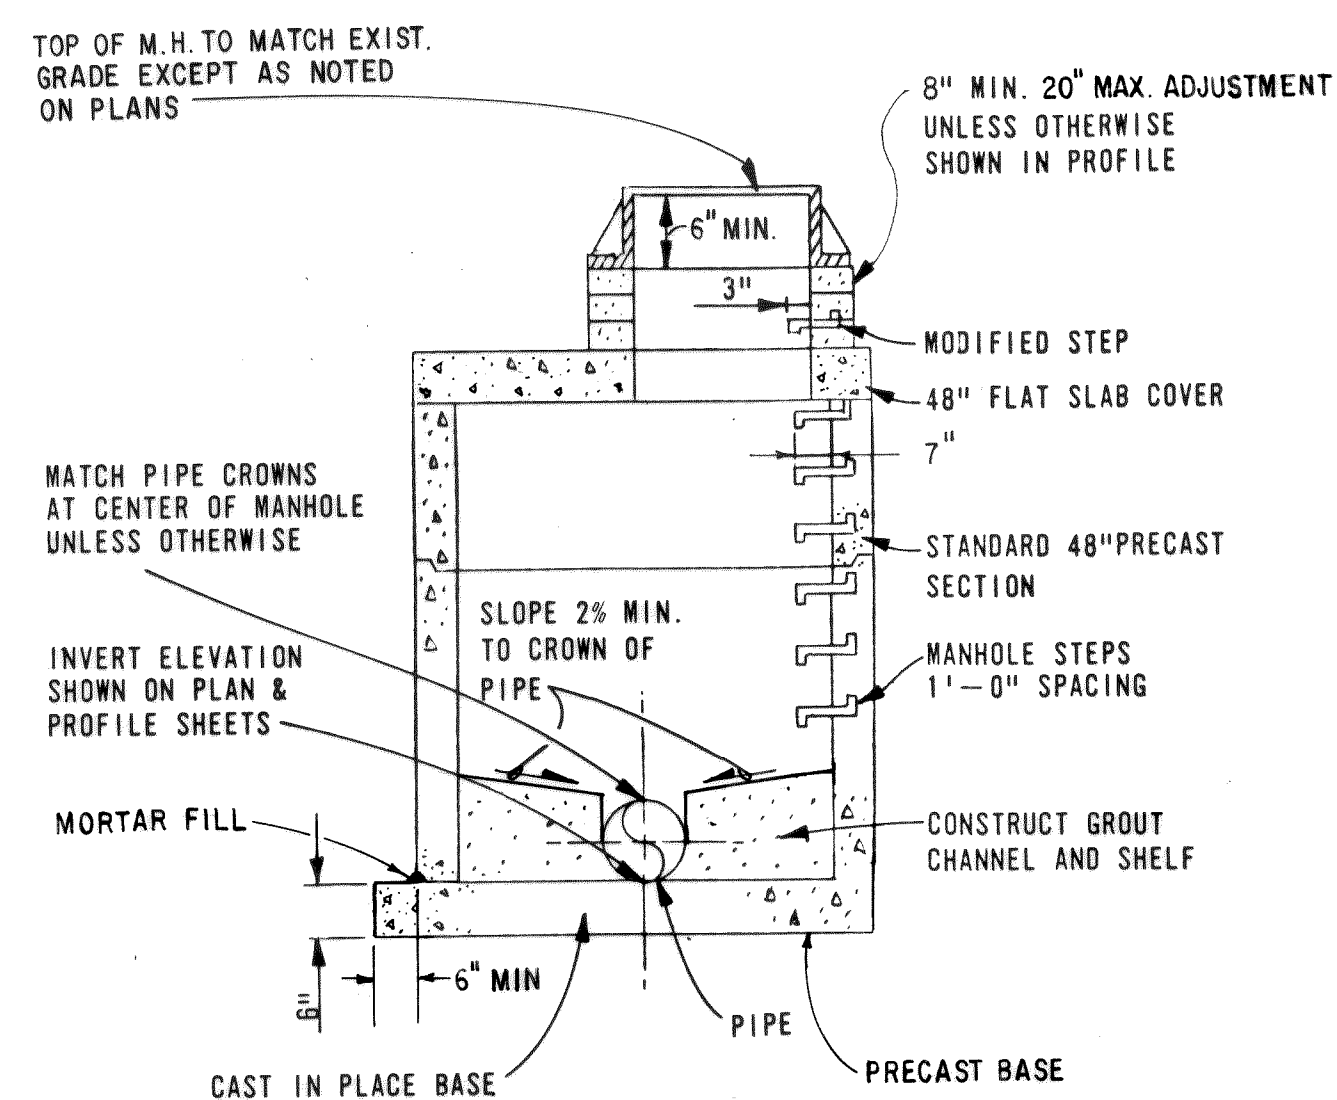


SHALLOW MANHOLE 5
PIPE SIZE 21" UI-U4
NO SCALE

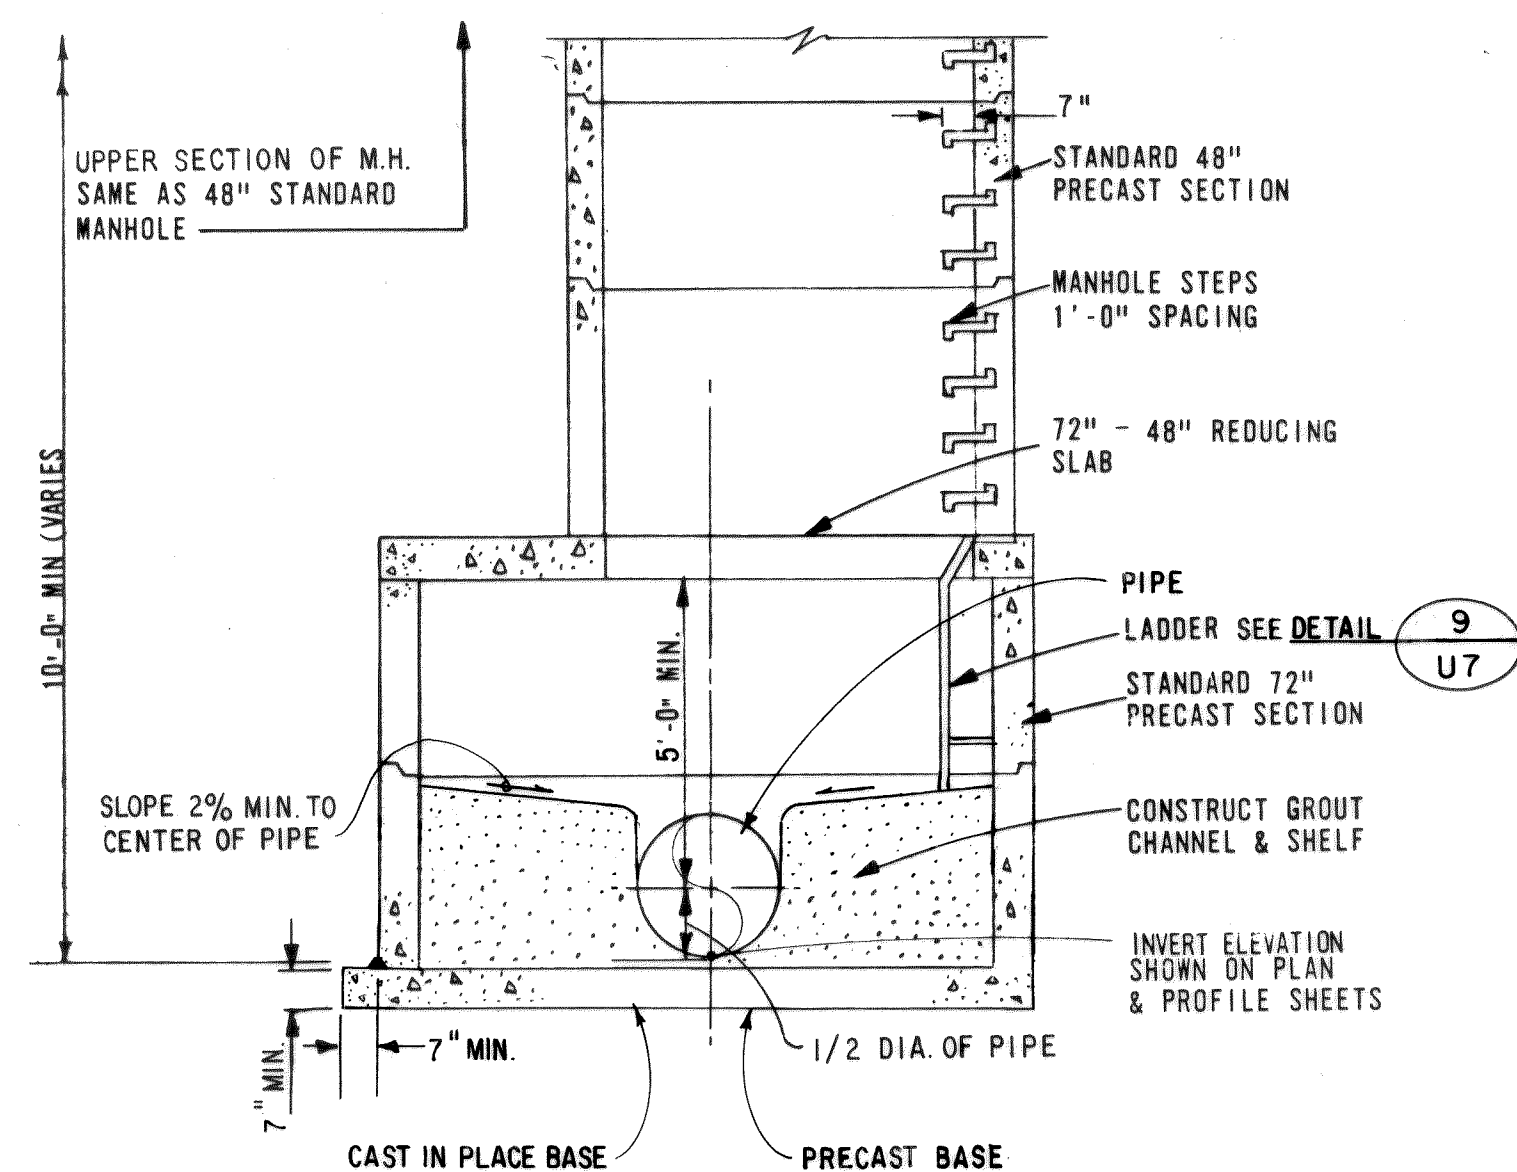


STANDARD MANHOLE 6
PIPE SIZE 24" UI
NO SCALE

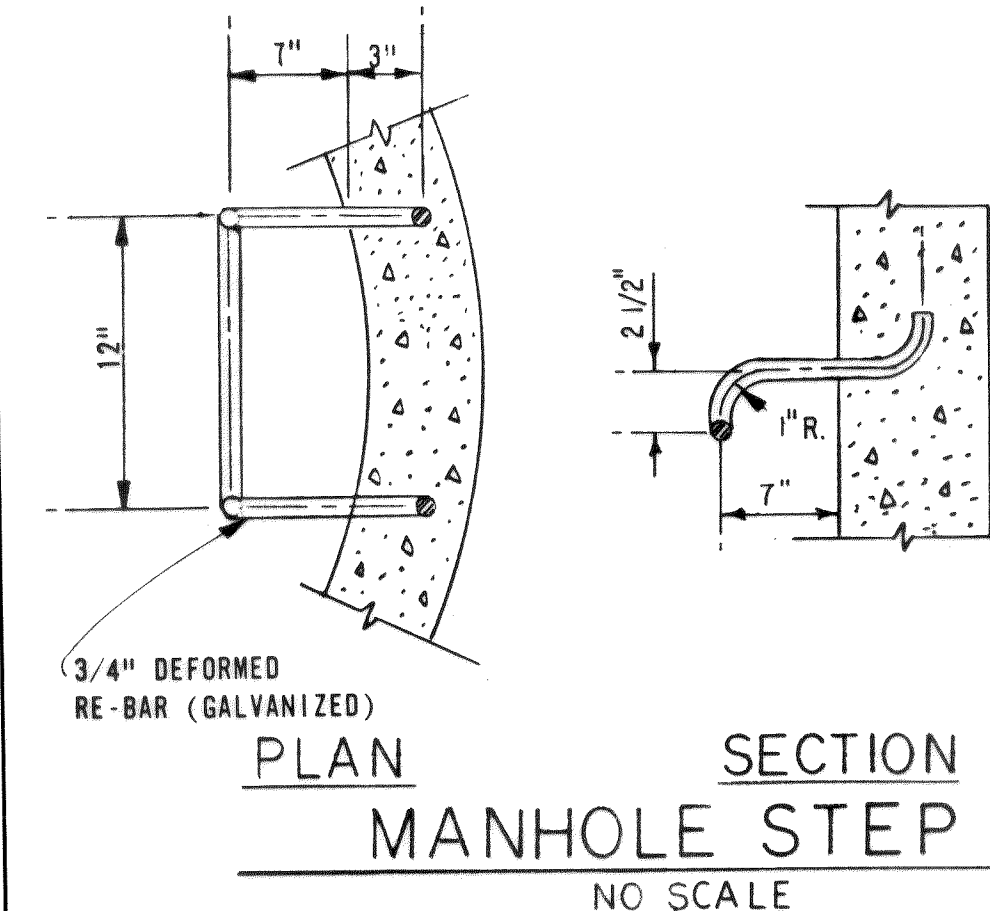

MANHOLE STEP 7
NO SCALE UI-U4

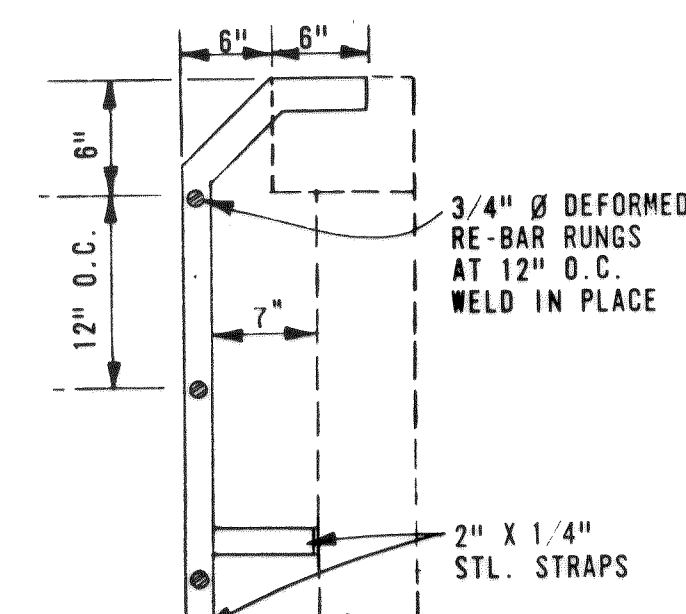

MANHOLE LADDER 9
NO SCALE U7

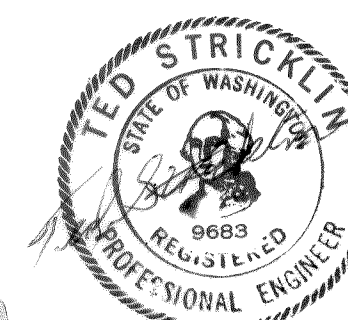

MICROFILMED

DESIGNED	T.S.	APPROVED	<i>T.D. Stricklin</i>
DRAWN	E.J.	SCALE	NONE
CHECKED	<i>L.H.</i>	DATE	JULY, 1972
FILE	71-S-425,002		



Stevens, Thompson & Runyan, Inc.
Engineers / Planners
PORTLAND SEATTLE BOISE


TOWN OF FERNDAL, WASHINGTON
AXTON ROAD INTERCEPTOR
SCHEDULE II

SEWER DETAILS


U7
8

MICROFILMED


SIDE SEWER 1
NO SCALE U1-U3

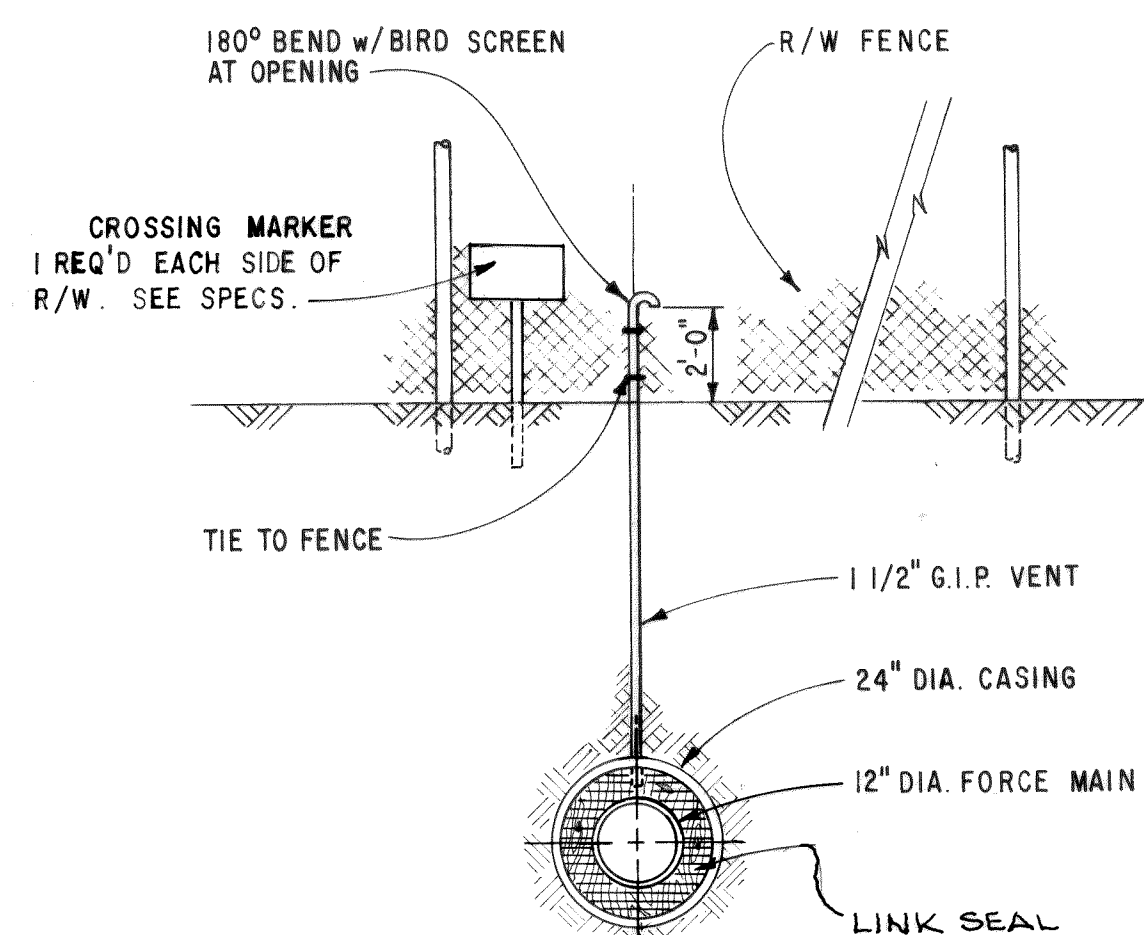


CASING VENT PIPE 2
NO SCALE U2

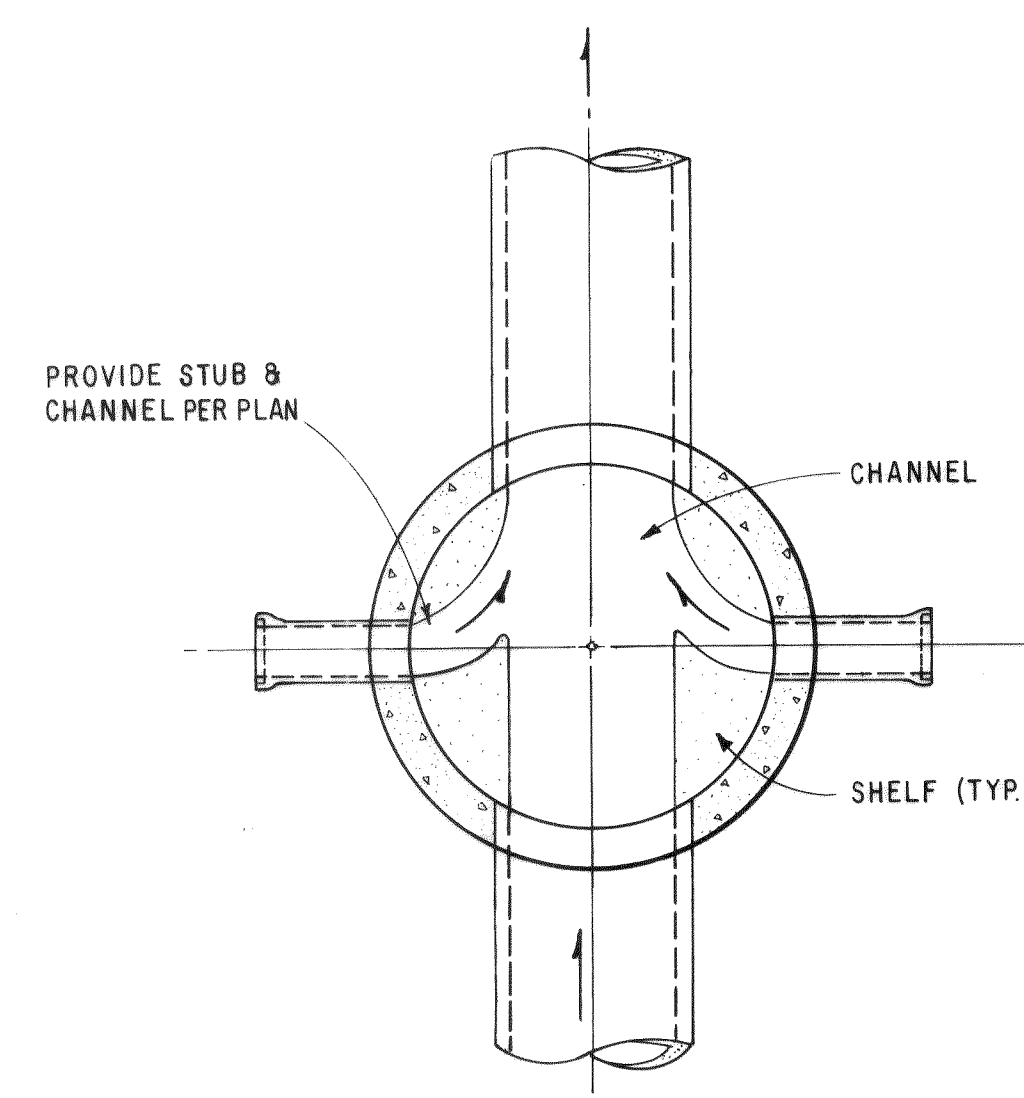


TYPICAL CHANNEL 3
NO SCALE UI-U4

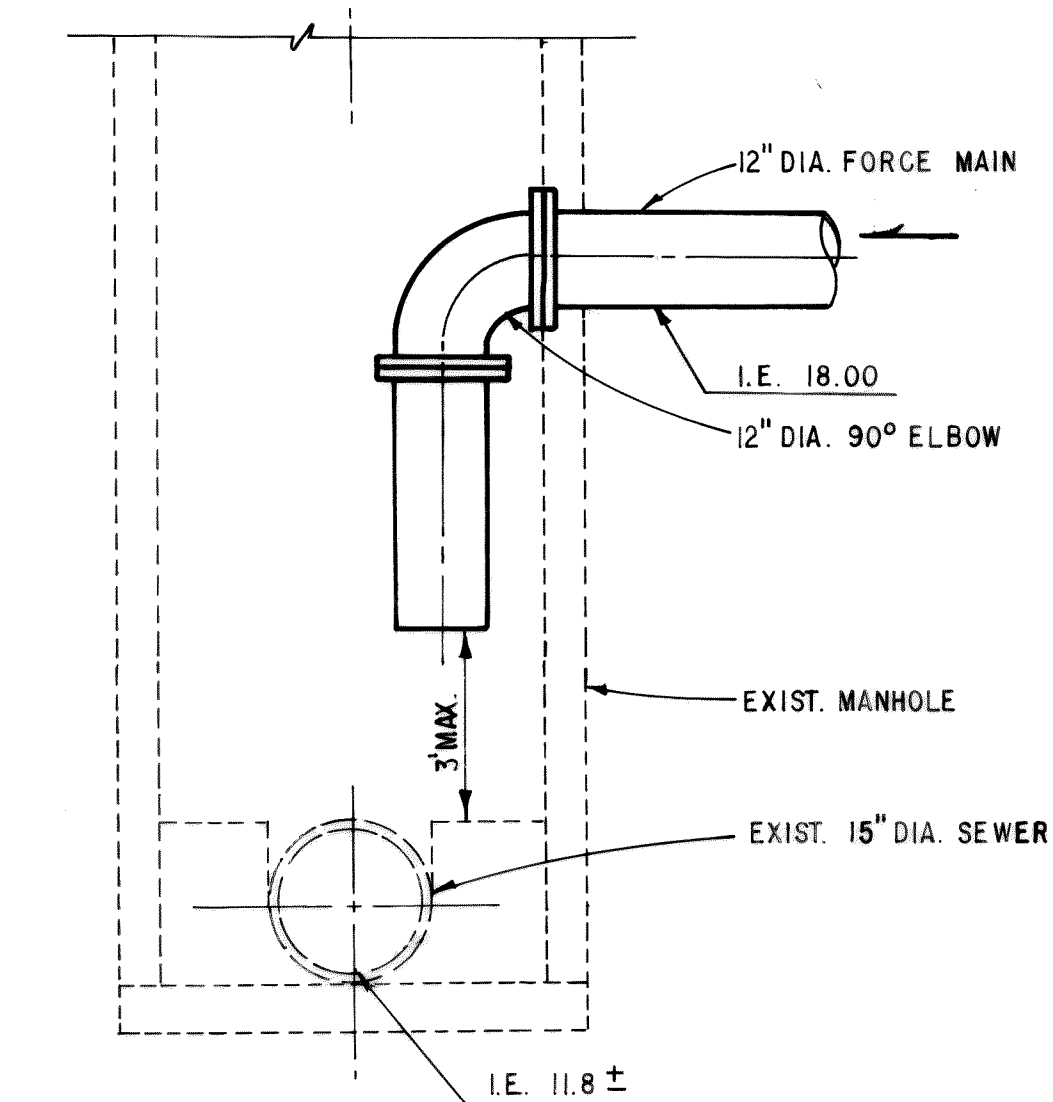

FORCE MAIN CONNECTION TO
EXISTING MANHOLE

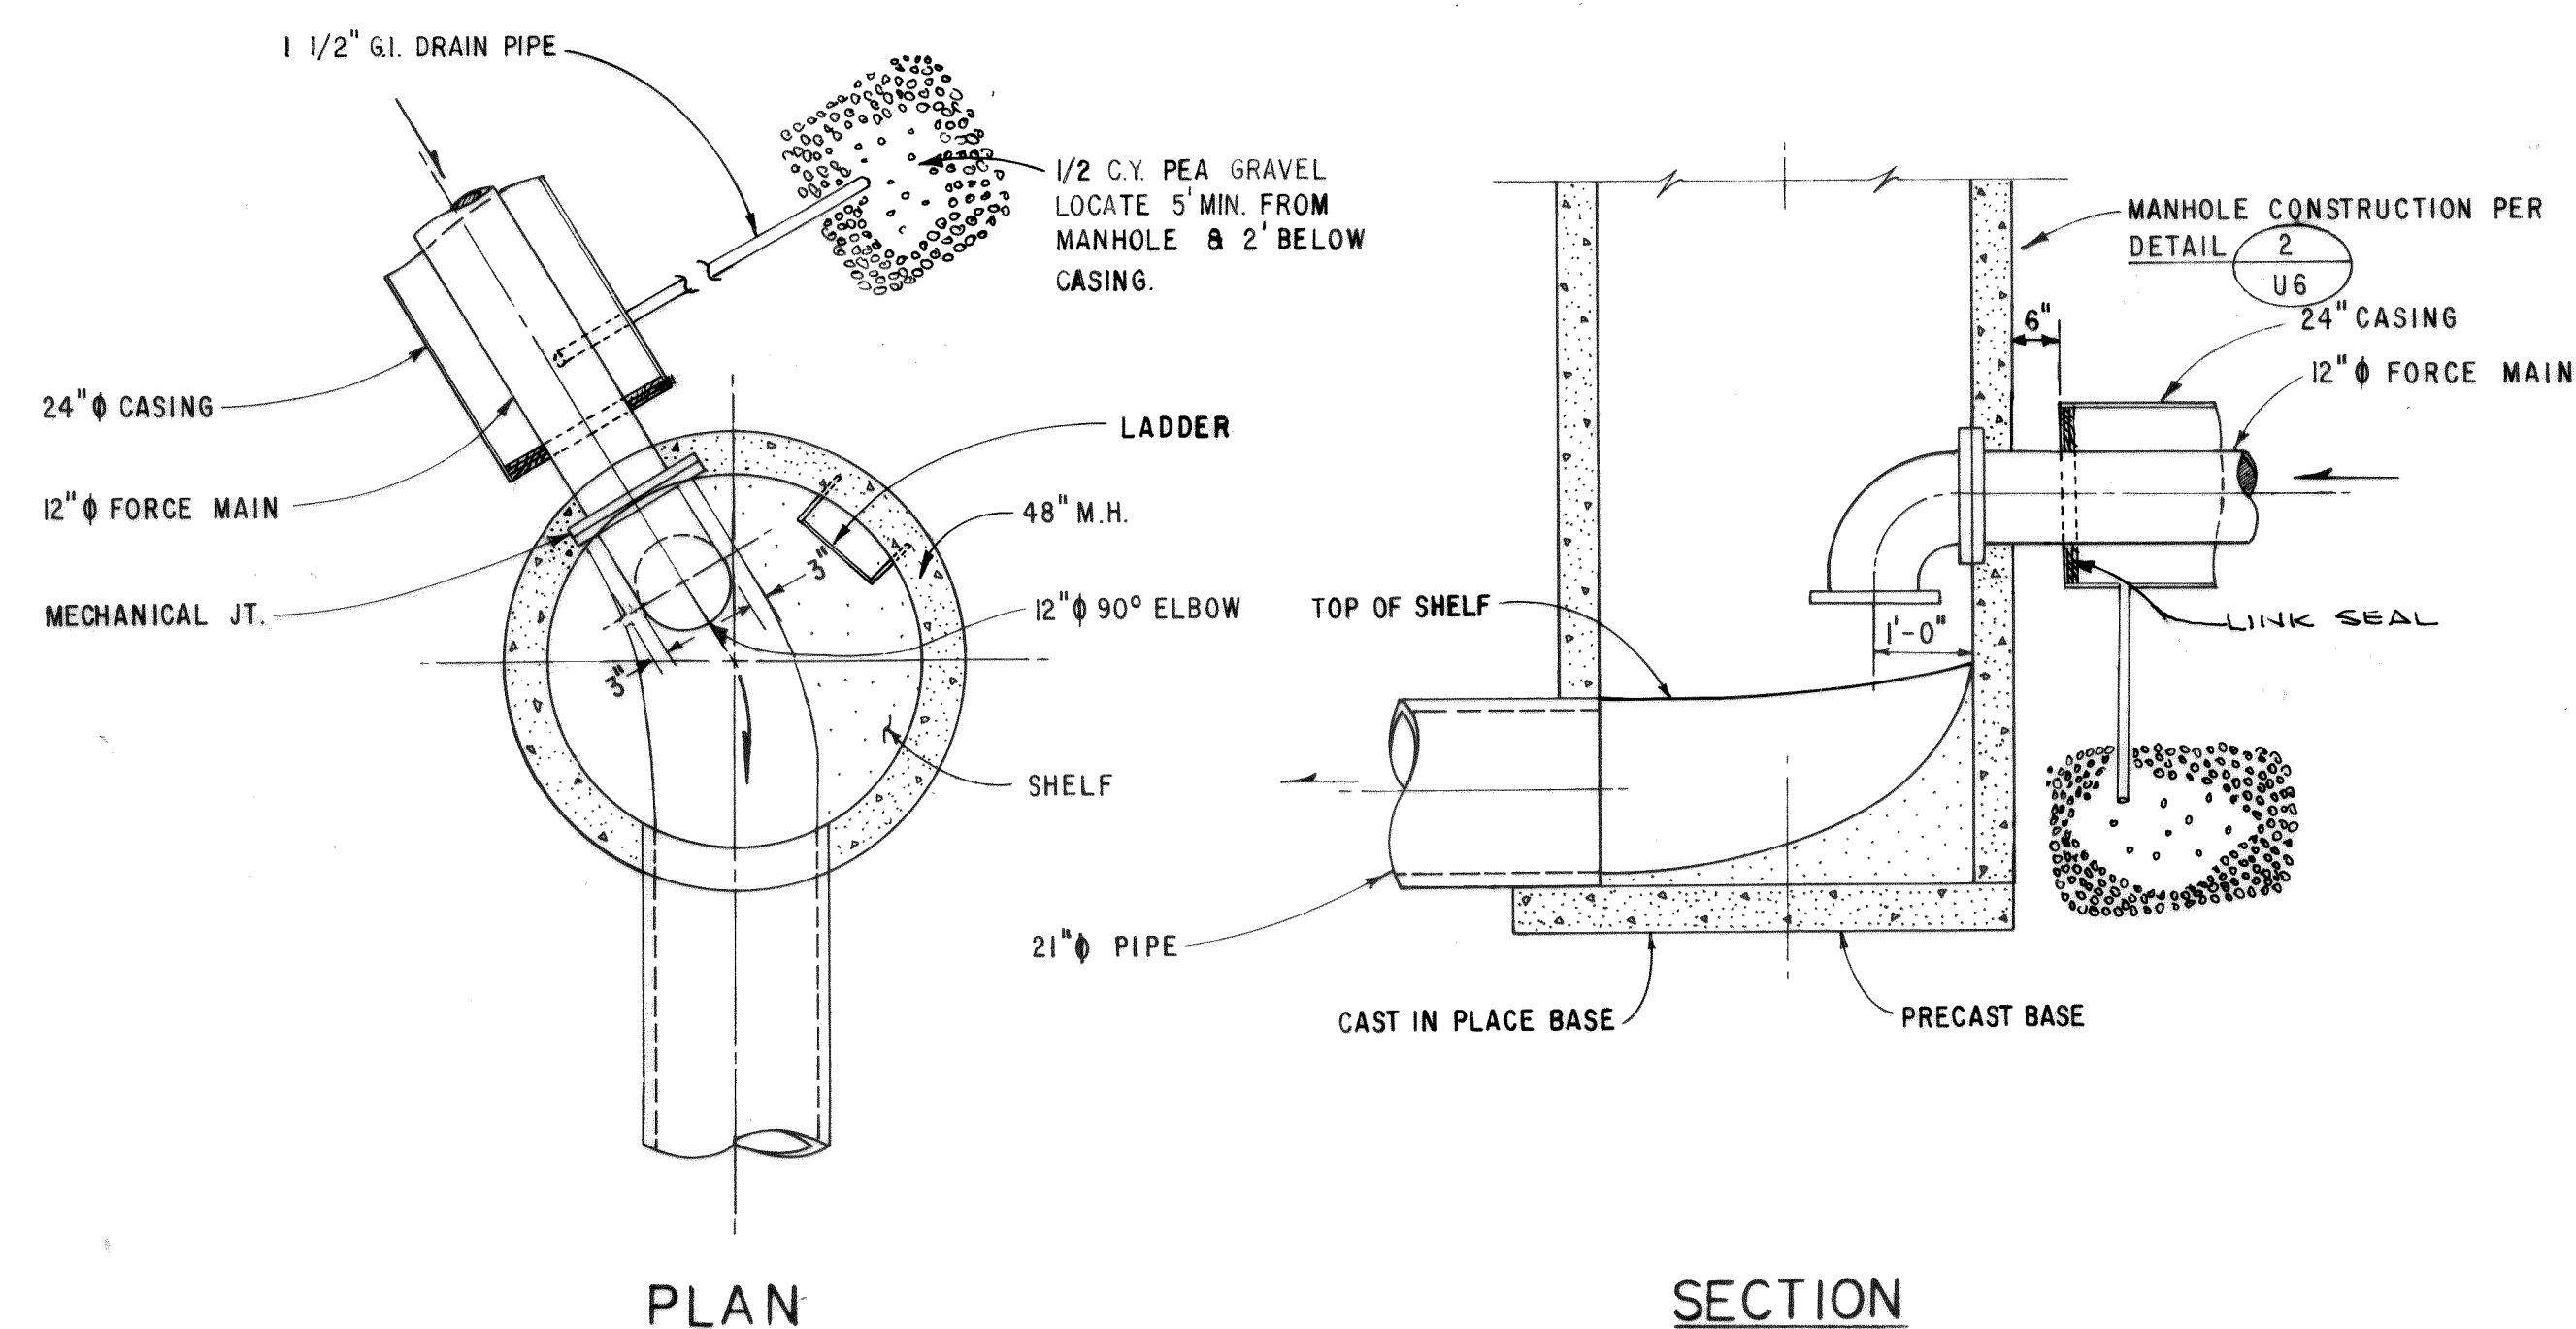

MANHOLE A-10 4
NO SCALE U2

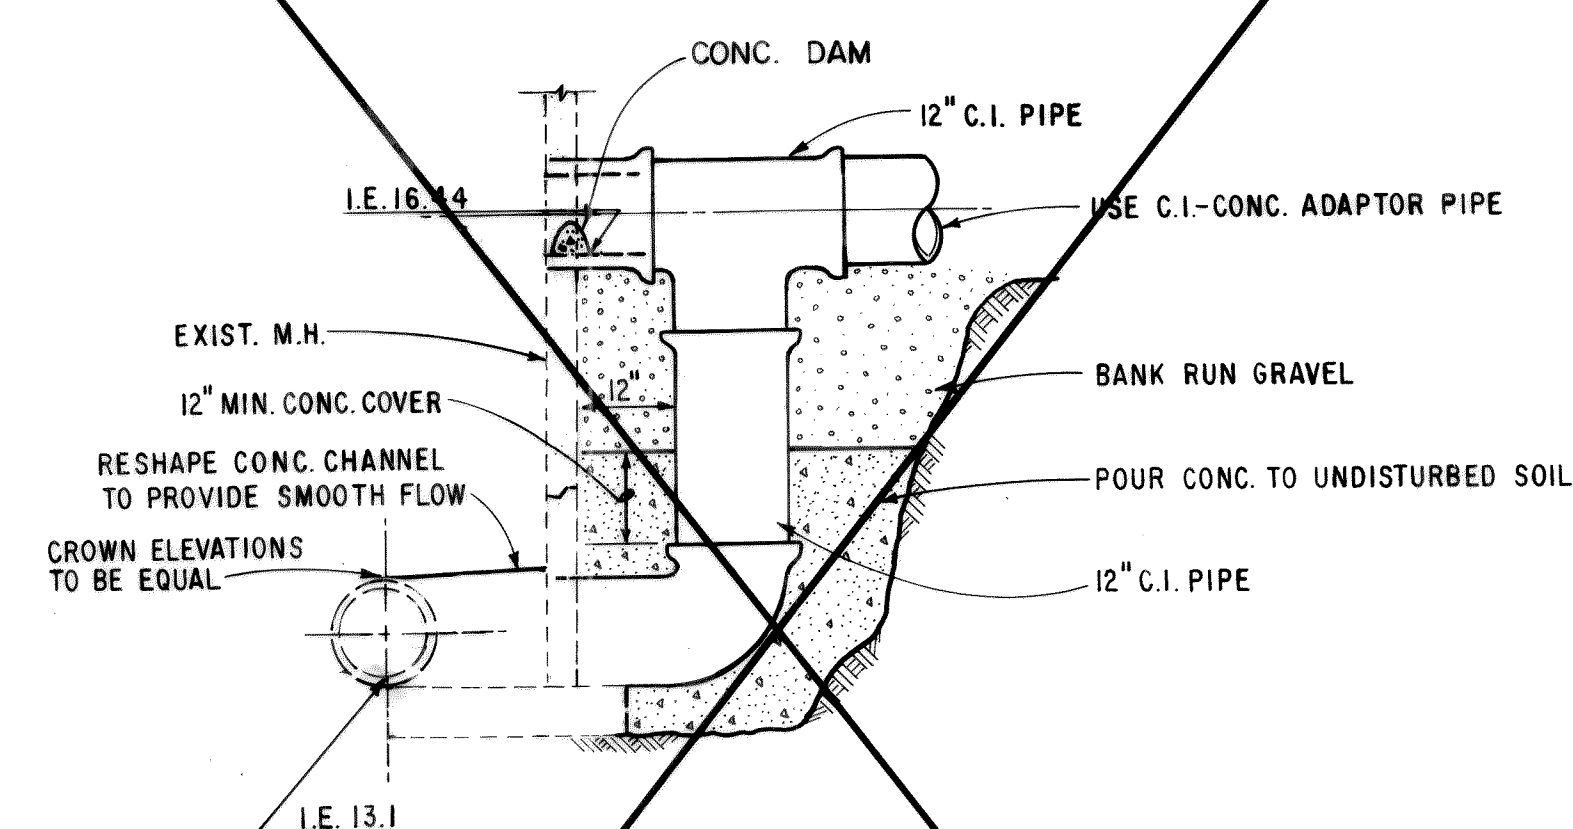

~~DROP CONNECTION~~ 5
~~EXISTING MANHOLE~~ U4

DELETED



MICROFILMED

				DESIGNED T. S.	APPROVED <i>Edith Horner</i>
				DRAWN E. J.	SCALE NONE DATE JULY, 1972
DATE	NO.	REVISION	BY	CHECKED <i>EP</i>	FILE 71-S-425.002



Stevens, Thompson & Runyan, Inc.
Engineers/Planners
PORTLAND SEATTLE BOISE

TOWN OF FERNDALE, WASHINGTON
AXTON ROAD INTERCEPTOR
SCHEDULE II

SEWER DETAILS 154.104.104.104

U8

1. PLAN SHOWN FOR M.H. E-3, E-4, E-5 & E-7 SIMILAR
2. FOR NEW M.H. DETAILS SEE NOTE 3, SHT. G1
3. ABANDON EXISTING SEWER & MANHOLES. SEE SPECS.


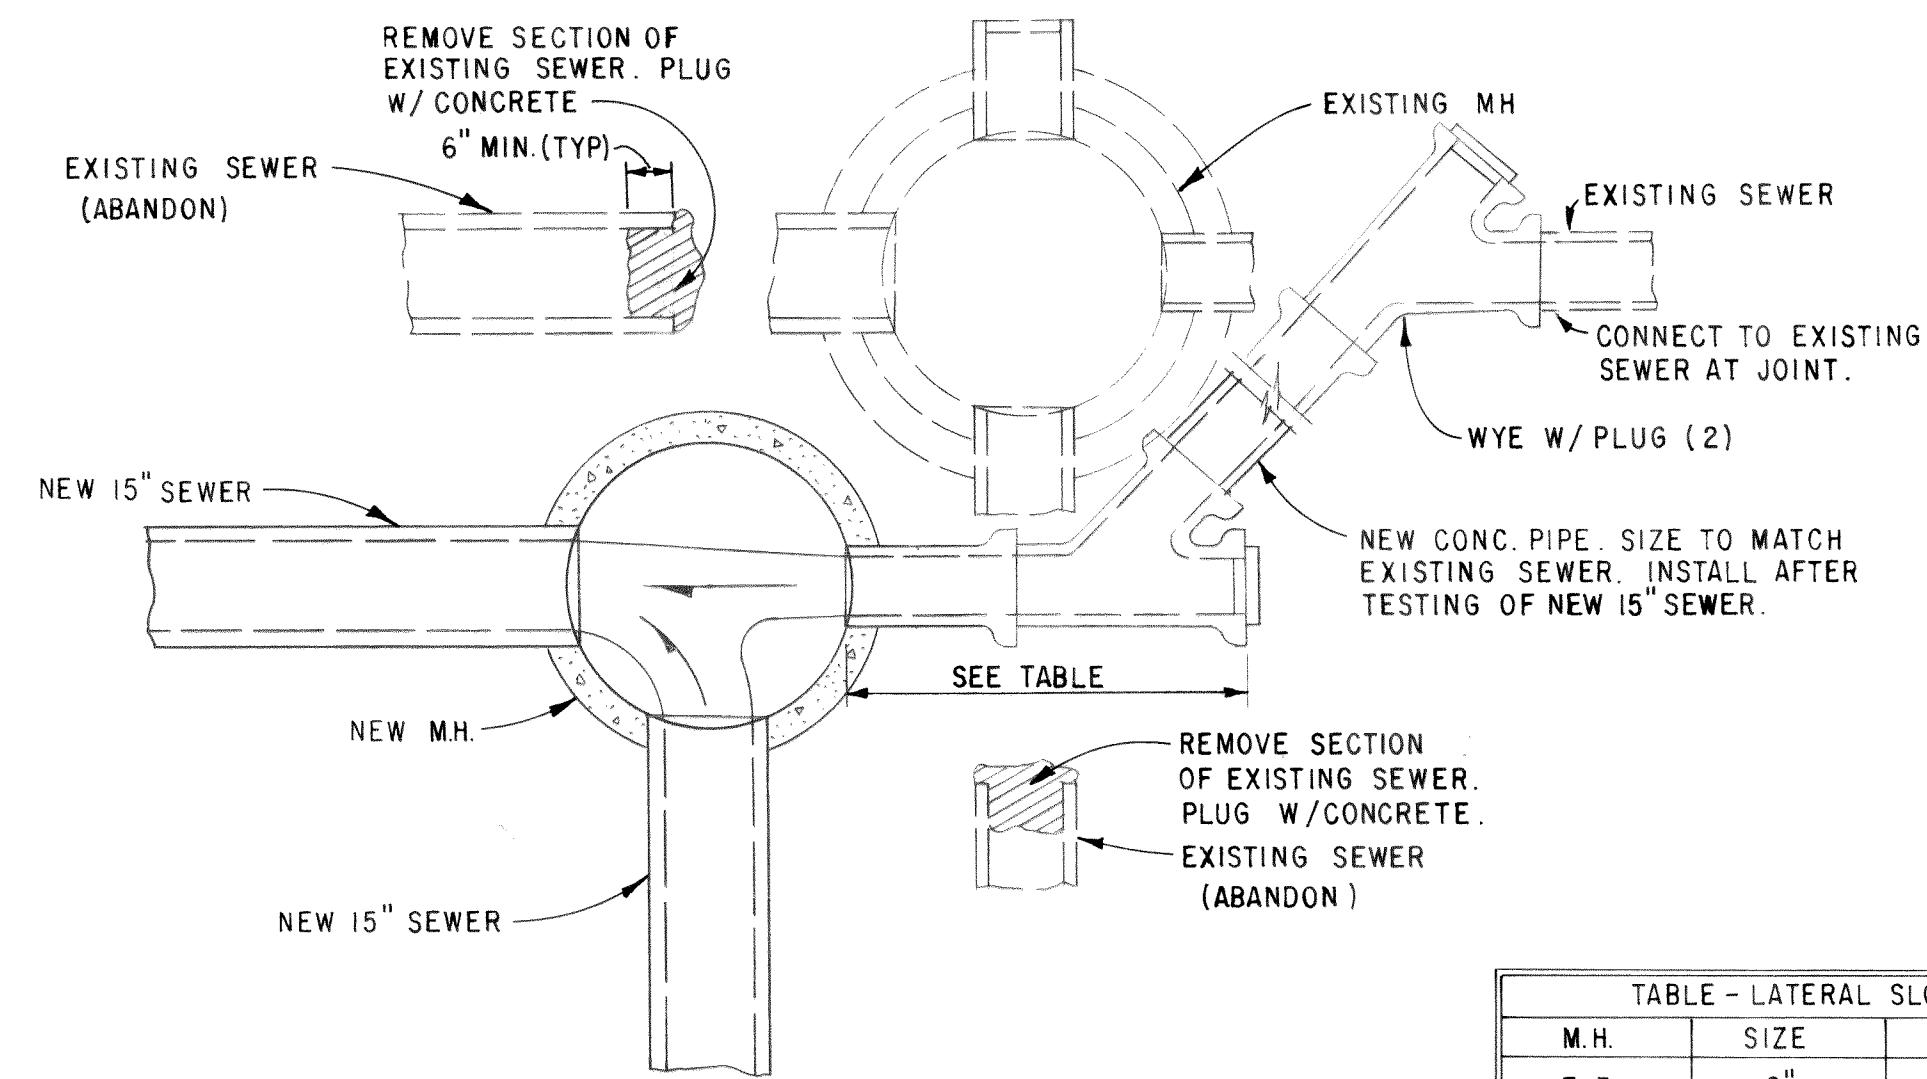


TABLE - LATERAL SLOPES		
M.H.	SIZE	SLOPE
E-3	8"	0.40 %
E-4	12"	0.90 %
E-5	8"	0.65 %
E-7	12"	0.43 %

NEW MANHOLE CONNECTION
TO EXISTING SEWER DETAIL

1
U4A


1. INSTALL NEW M.H. OVER EXISTING 8" SEWER WITHOUT DISRUPTING SERVICE.
2. ABANDON EXISTING SEWER AND PLUG W/ CONCRETE AFTER TESTING OF NEW 15" SEWER.
3. FOR NEW M.H. DETAILS SEE NOTE 3, SHT. G1

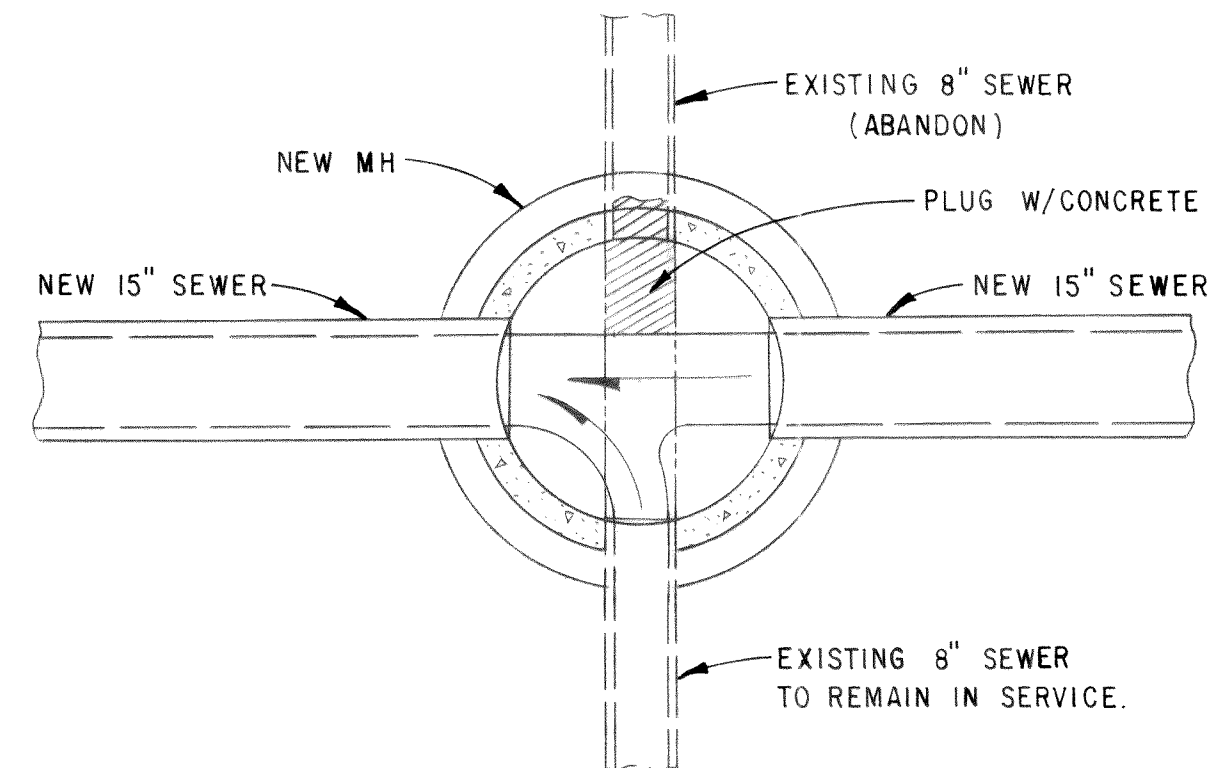

MANHOLE E-2
NOT TO SCALE


3
U4A

1. INSTALL NEW M.H. OVER EXISTING 15" SEWER WITHOUT DISRUPTING SERVICE.
2. ABANDON EXISTING SEWER AND PLUG W/ CONCRETE AFTER TESTING OF NEW 15" SEWER.
3. FOR NEW M.H. DETAILS SEE NOTE 3, SHT. G1 EXCEPT USE CAST IN PLACE BASE.

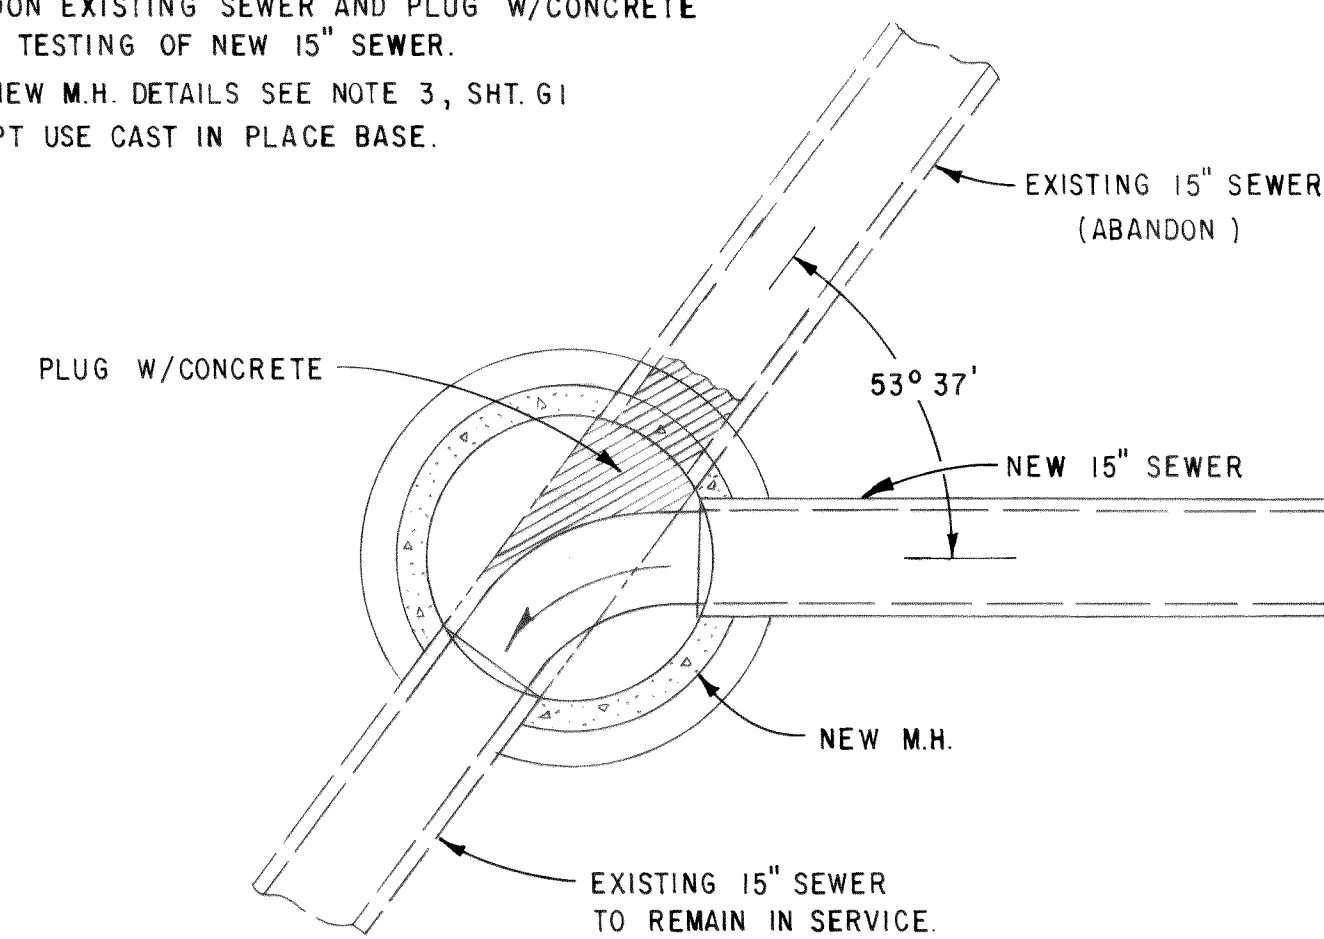


MANHOLE E-1
NOT TO SCALE

2
U4A

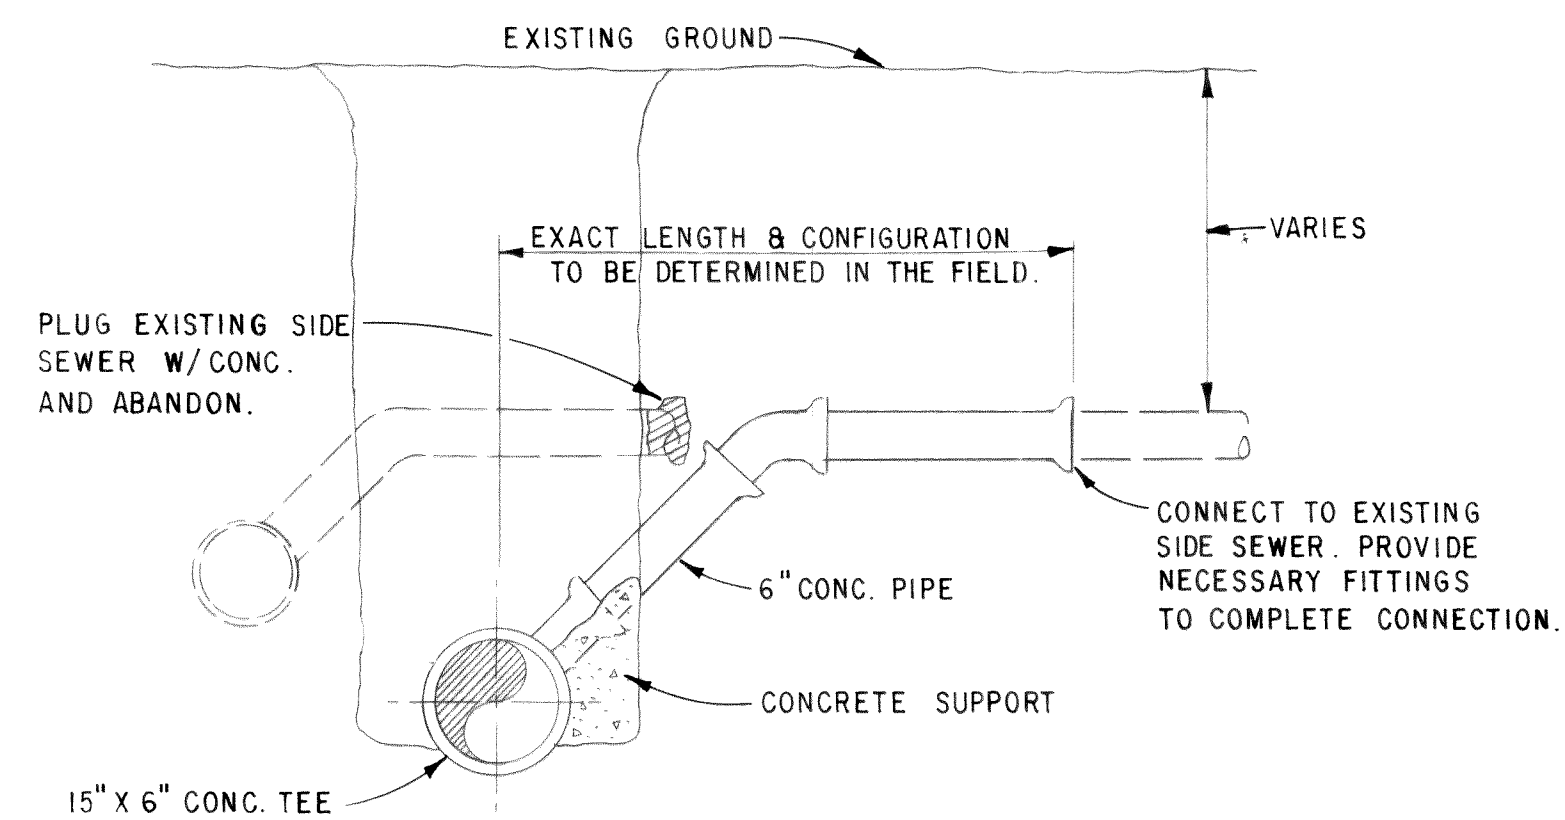

SIDE SEWER RECONNECTION
NOT TO SCALE

4
U4A

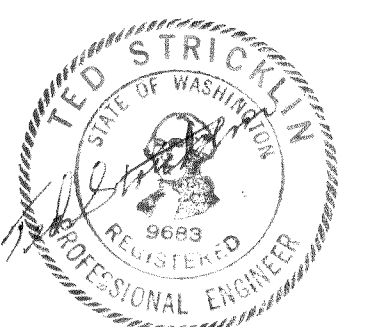

DESIGNED	T.S.	APPROVED	<i>Donna M. Piche</i>
DRAWN	J.M.H.	SCALE	AS SHOWN
DATE	NOV. 72	DATE	NOV. 1972
NO.	1	FILE	71-S-425.022
REVISION	ADDENDUM I		
BY	CHECKED		
	<i>RVH</i>		



Stevens, Thompson & Runyan, Inc.
Engineers/Planners
PORTLAND SEATTLE BOISE

TOWN OF FERNDAL, WASHINGTON
AXTON ROAD INTERCEPTOR
SCHEDULE II

SEWER DETAILS

MICROFILMED

U9
9

00210-046 2-7-06 RR