

CITY OF FERNDALE
U.L.I.D. NO. 7
RECORD DRAWINGS FOR SANITARY SEWER IMPROVEMENTS
FERNDALE, WASHINGTON
SECTIONS 20, 17 & 8, T 39 N, R 2 E

CONSULTING ENGINEERS:

WEDEN ENGINEERING, INC. 119 GRAND AVE., STE. D, BELLINGHAM, WA 98225 671-8200

OWNER:

CITY OF FERNDALE

CONTACT PERSON:

JOHN F. ELEY, DIRECTOR OF PUBLIC WORKS
STAN STREBEL, CITY MANAGER

DRAWING INDEX

SHEET NO. TITLE

- COVER SHEET - VICINITY, NOTES, LEGEND
- SANITARY SEWER IMPROVEMENTS - KEY SHEET
- PLAN AND PROFILE - STA 0+00 TO STA 14+00
- PLAN AND PROFILE - STA 14+00 TO STA 28+00
- FORCE MAIN ALONG PORTAL WAY
- PLAN AND PROFILE - STA 28+00 TO STA 42+00
- PLAN AND PROFILE - STA 42+00 TO STA 56+00
- PLAN AND PROFILE - STA 56+00 TO STA 70+00
- PLAN AND PROFILE - STA 70+00 TO STA 74+40
- PLAN AND PROFILE - STA 0+00A TO STA 6+90A
- PLAN AND PROFILE - FORCE MAIN ALONG PORTAL WAY
STA 0+00B TO STA 15+00B
- PLAN AND PROFILE - FORCE MAIN ALONG PORTAL WAY
STA 15+00B TO STA 30+00B
- PLAN AND PROFILE - FORCE MAIN ALONG PORTAL WAY
STA 30+00B TO STA 44+42B
- DETAILS AND LIFT STATION SITE PLAN
- DETAILS
- LIFT STATION DETAILS
- LIFT STATION DETAILS
- LIFT STATION ELECTRICAL DETAILS
- LIFT STATION ELECTRICAL DETAILS

GENERAL NOTES

- THE LOCATION AND SIZE OF EXISTING UTILITIES SHOWN IS APPROXIMATE. IT IS THE RESPONSIBILITY OF THE CONTRACTOR TO FIELD VERIFY THESE LOCATIONS PRIOR TO CONSTRUCTION.
- ALL WORK SHALL CONFORM TO THE STANDARD PLANS AND SPECIFICATIONS OF THE WASHINGTON STATE DEPARTMENT OF TRANSPORTATION (WSDOT), 1991, AND CITY OF FERNDALE STANDARDS UNLESS INDICATED OTHERWISE BY THE CONTRACT DOCUMENTS. IN CASE OF A CONFLICT BETWEEN THE REGULATORY STANDARDS OR SPECIFICATIONS, THE MORE STRINGENT REQUIREMENT WILL PREVAIL.
- UNDERGROUND UTILITIES ARE KNOWN TO EXIST IN THE AREA OF CONSTRUCTION. IT IS THE RESPONSIBILITY OF THE CONTRACTOR TO CONTACT THE UTILITY OWNERS FOR LOCATIONS AND TO NOTIFY THE ENGINEER PROMPTLY OF ANY CONFLICT.
- THE CONTRACTOR SHALL BE RESPONSIBLE FOR MAINTAINING THE INTEGRITY OF ADJACENT UTILITIES WHICH INCLUDE, BUT ARE NOT LIMITED TO, WATER, SEWER, STORM SEWER, POWER, TELEPHONE, CABLE TV, NATURAL GAS, IRRIGATION, AND STREET LIGHTING.
- THE CONTRACTOR SHALL BE RESPONSIBLE FOR MAINTAINING ALL EROSION CONTROL MEASURES THROUGHOUT THE DURATION OF THE PROJECT.
- ELEVATION REFERS TO U.S.C. & G.S. DATUM; SEE KNOWN BENCH MARK LOCATED EACH SHEET.
- X,Y PARCEL NUMBERS ARE FROM THE WHATCOM COUNTY ASSESSORS OFFICE. OWNERSHIPS OF THESE PARCELS ARE ON RECORD WITH THE ABOVE REFERENCED OFFICE.
- THE COORDINATES ON THIS PLAN ARE BASED ON AN ASSUMED COORDINATE BASE.
- CONTRACTOR TO COORDINATE ALL UTILITY RESTORATION WITH UTILITY COMPANIES. UNDERGROUND TELECOMMUNICATION, TV, POWER, WATER AND GAS SHALL BE INCIDENTAL TO CONTRACT.


LEGEND

EXISTING	PLAN	PROPOSED
	CATCH BASIN	
	CULVERT	
	DETAIL NUMBER SHEET FOUND	
	WATER LINE	
	STRAW BALE DAM	
	GATE VALVE	
	HYDRANT	
	THRUST BLOCK	
	CURB CUT	
	EASEMENT	
	LIGHTING	
	LIGHTING TRENCH	
	GAS	
	TELEPHONE	
	UNDERGROUND TELEPHONE	
	STORM DRAIN	
	ELECTRICAL	
	UNDERGROUND ELECTRICAL	
	SANITARY SEWER	
	FORCE MAIN	
	DITCH	
	SILT FENCE	
	ELEVATION CONTOUR	
	APPROXIMATE PROPERTY LINE	
	RIGHT OF WAY	
	EDGE OF PAVING	


PROFILE

	EXISTING GROUND	
	MANHOLE / SANITARY SEWER	
	FORCE MAIN	
	CATCH BASIN / STORM PIPE	
	EXISTING PIPING	

PROJECT
SITE

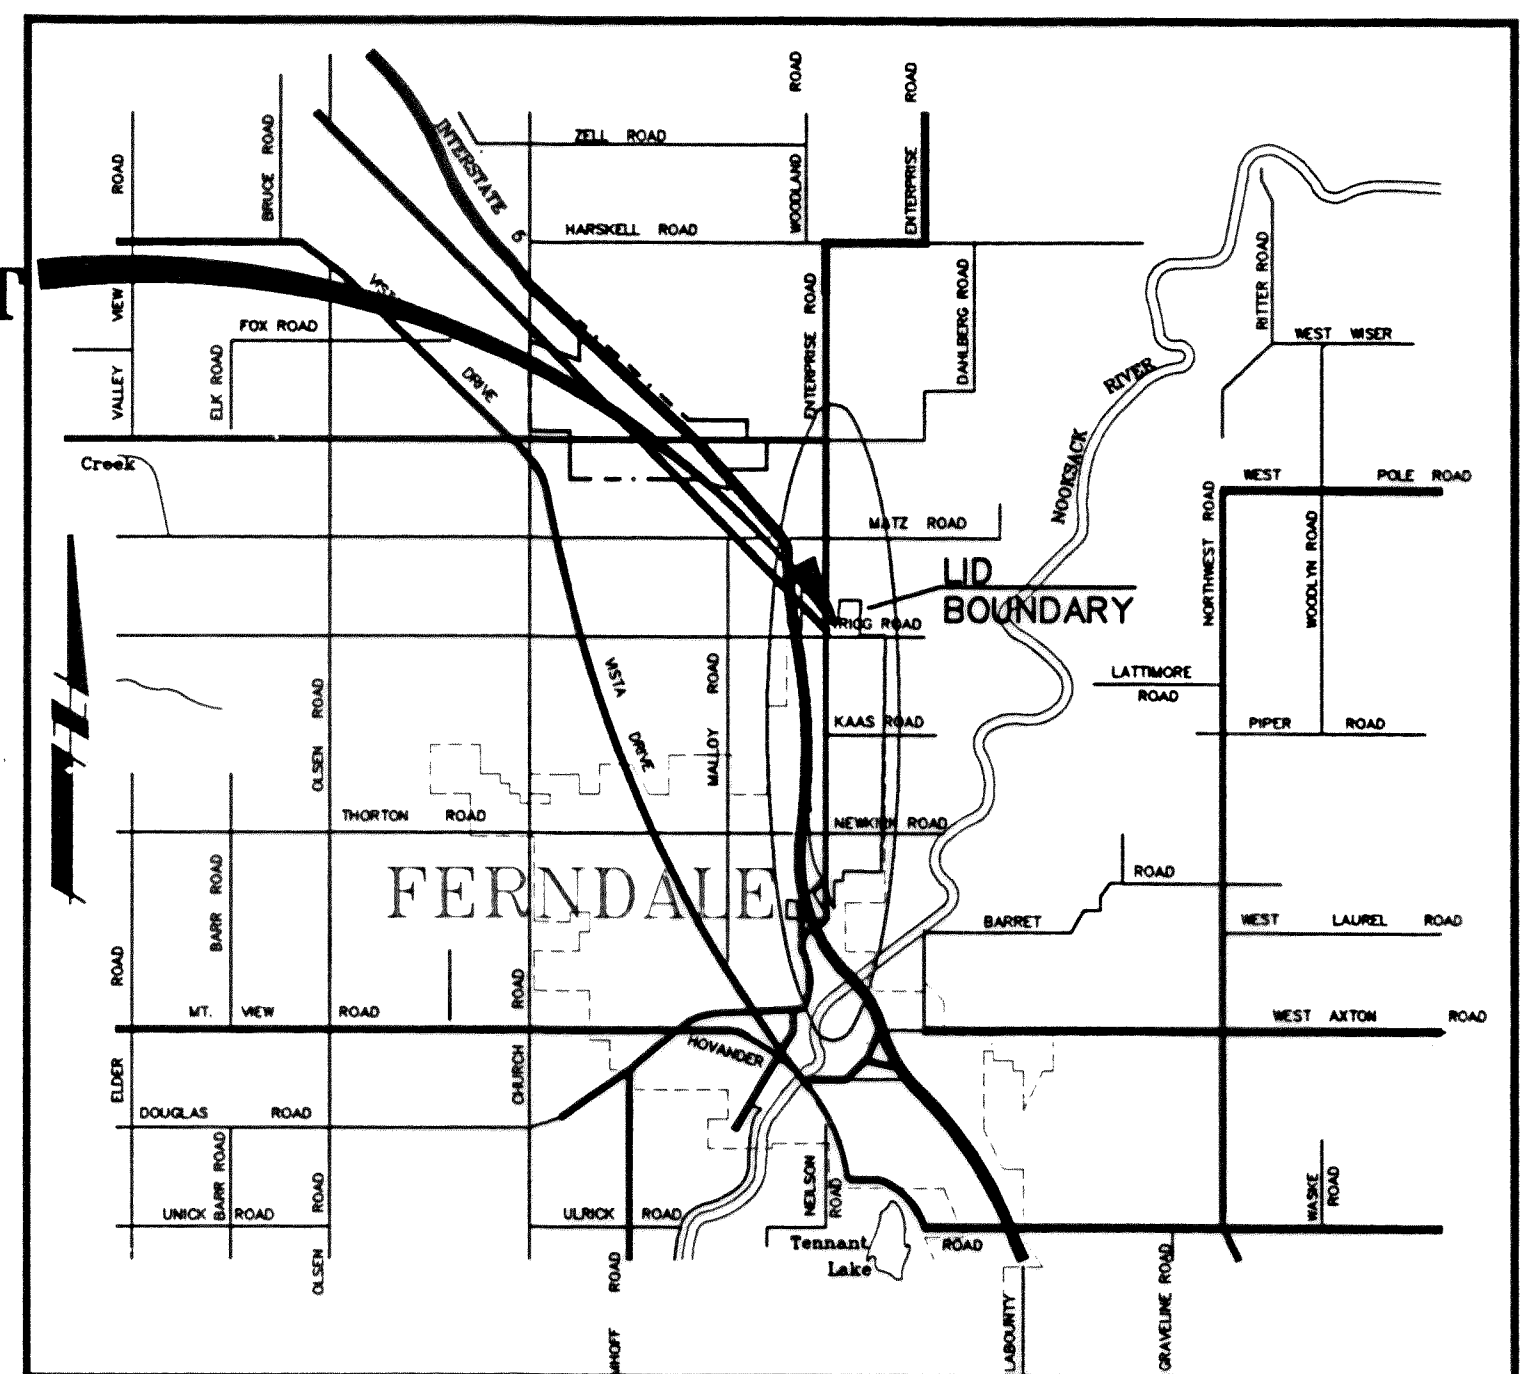

WARNING!
UTILITIES IN AREA
CALL UTILITY LOCATORS
PRIOR TO ANY EXCAVATION.

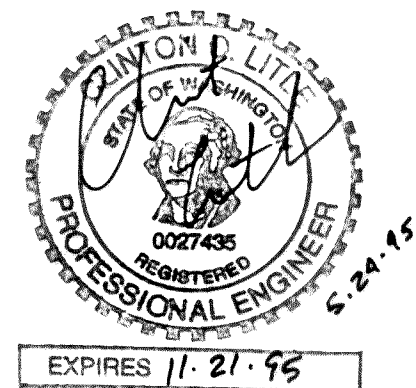

RECORD DRAWING

				WEDEN ENGINEERING, INC. 119 GRAND AVENUE, SUITE D, BELLINGHAM, WA. 98225 671-8200		DESIGNED BY		CITY OF FERNDALE U.L.I.D. NO. 7 PORTAL WAY SANITARY SEWER EXTENSION TITLE, VICINITY MAP, LEGEND, NOTES, AND SHEET INDEX		DATE		SHEET	
						DRAWN BY				09/22/94		1	
						CHECKED BY				SCALE		OF	
NO. REVISIONS BY DATE										AS NOTED		16	
										REC. NO.			
										92096			



C:\DWG\92096\2096RD1A 11/09/94 13:25

00105-001 2-7-00 KR


SECTION 8, T. 39N., R. 2E.



				 WEDEN ENGINEERING, INC. 119 GRAND AVENUE, SUITE D, BELLINGHAM, WA. 98225 671-8200	ONE INCH AT FULL SCALE  IF NOT ONE INCH SCALE ACCORDINGLY		DESIGNED BY		CITY OF FERNDAL U.L.I.D. NO. 7 PORTAL WAY SANITARY SEWER EXTENSION INDEX MAP				DATE 09/22/94		SHEET 2		
							DRAWN BY						OF 16				
							CHECKED BY										
NO.		REVISIONS		BY		DATE								REC. NO. 92096			

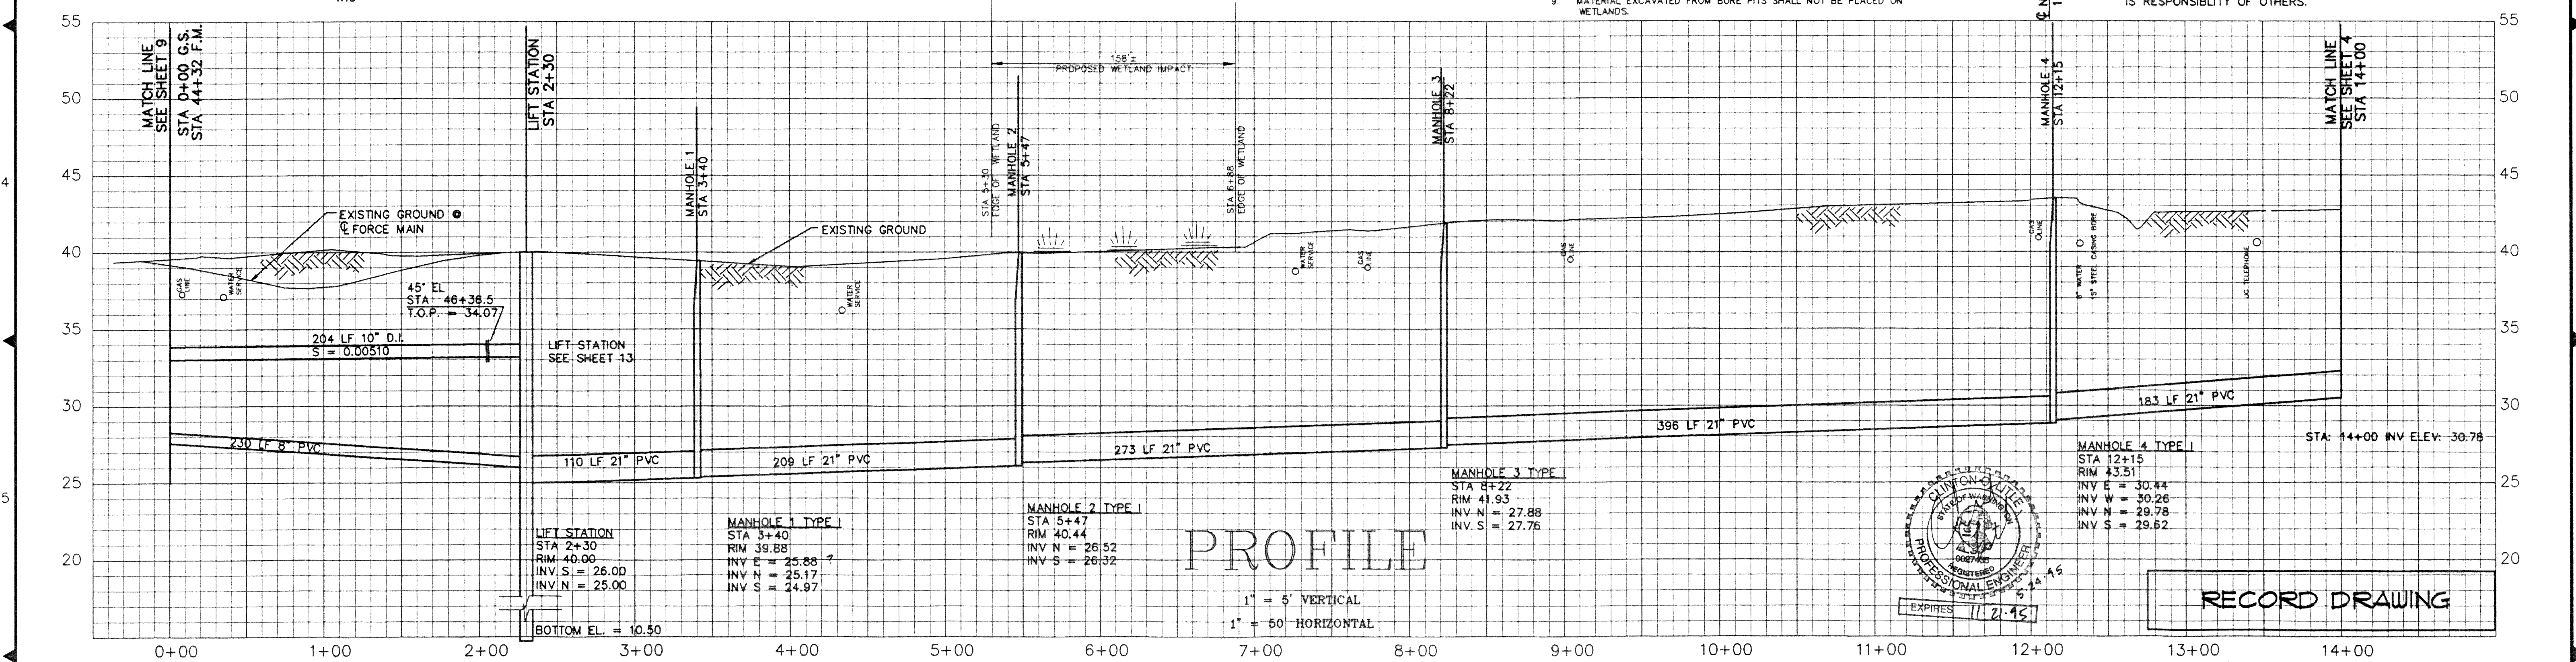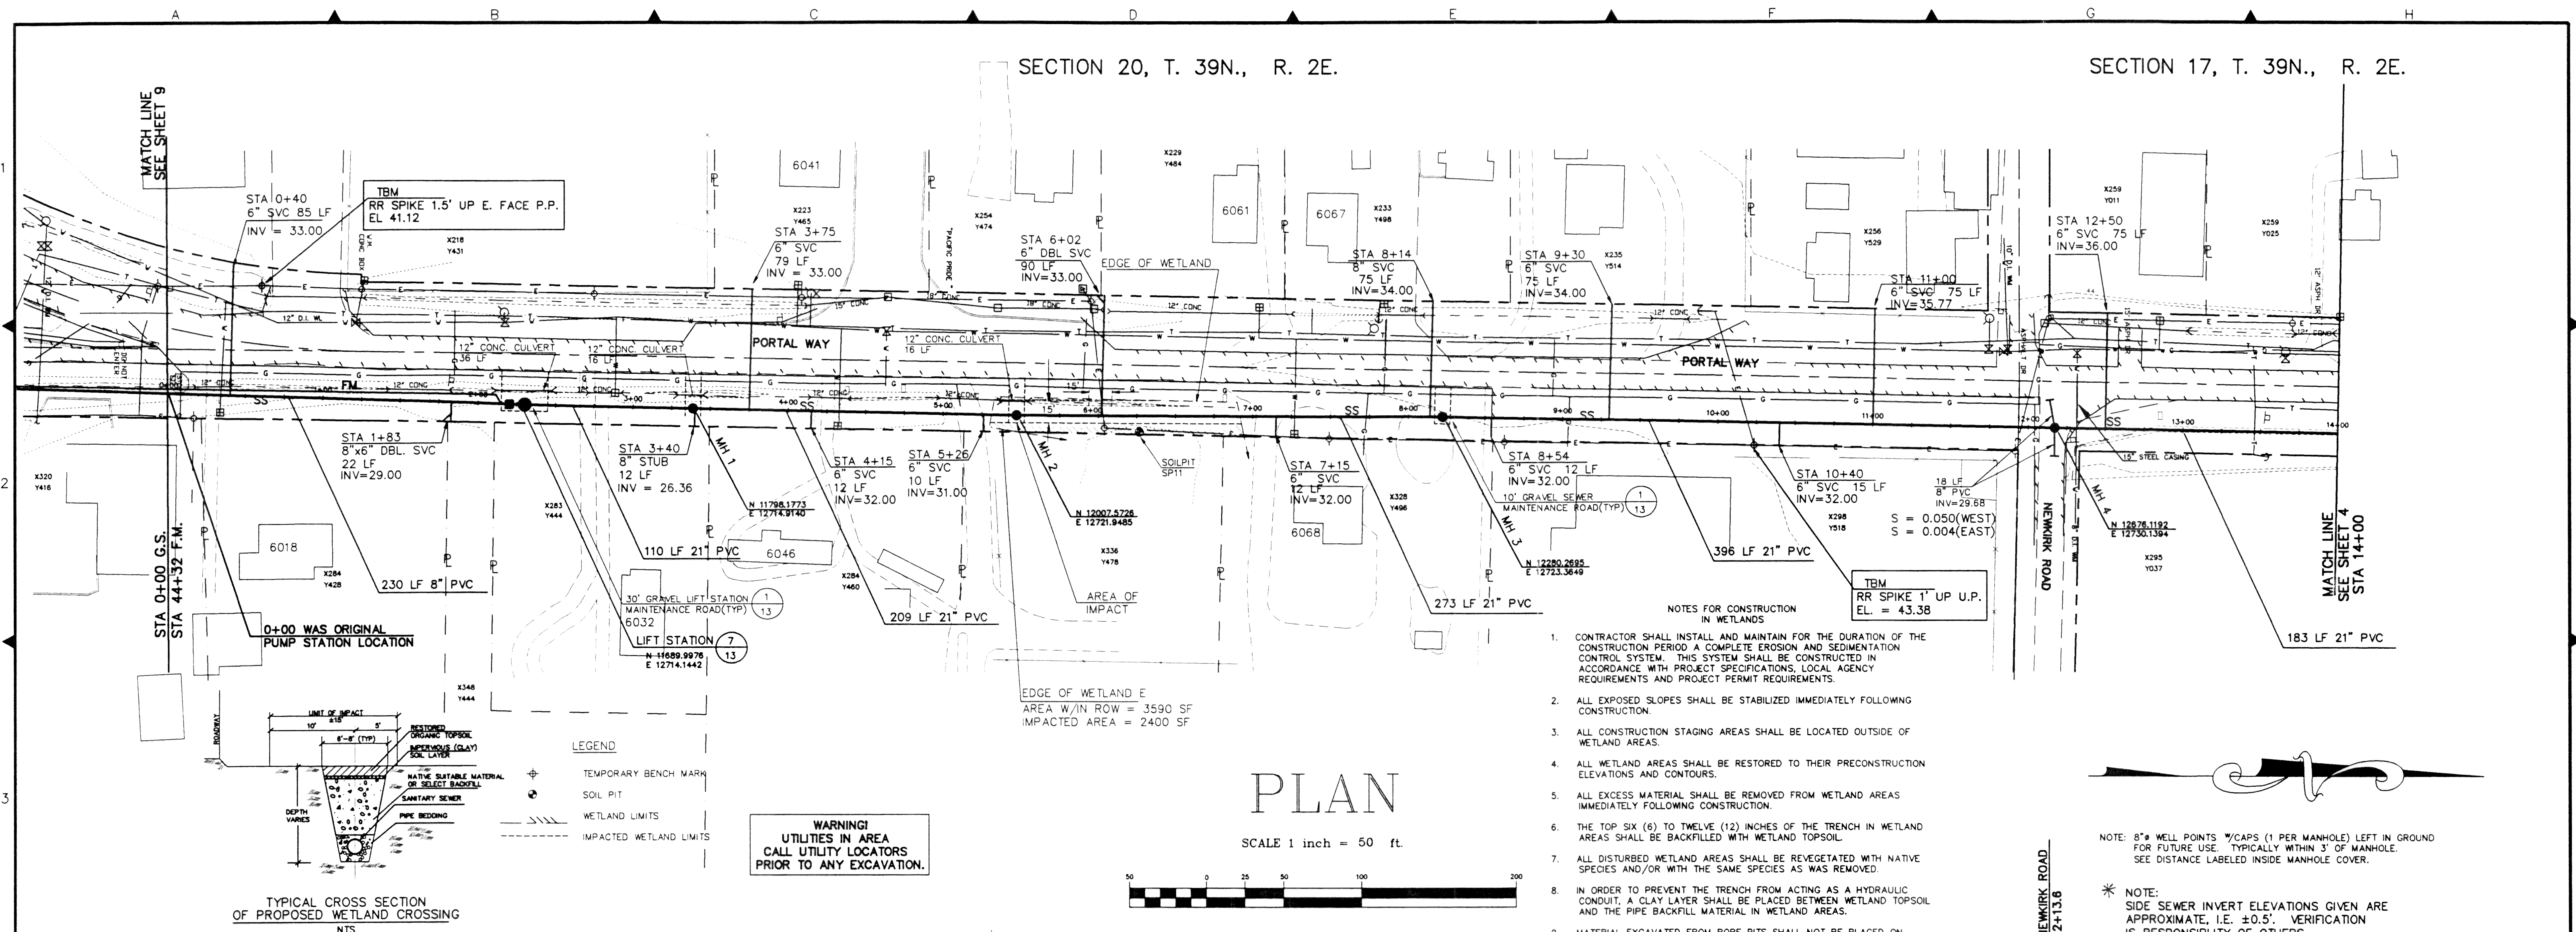

SECTION 17, T. 39N., R. 2E.

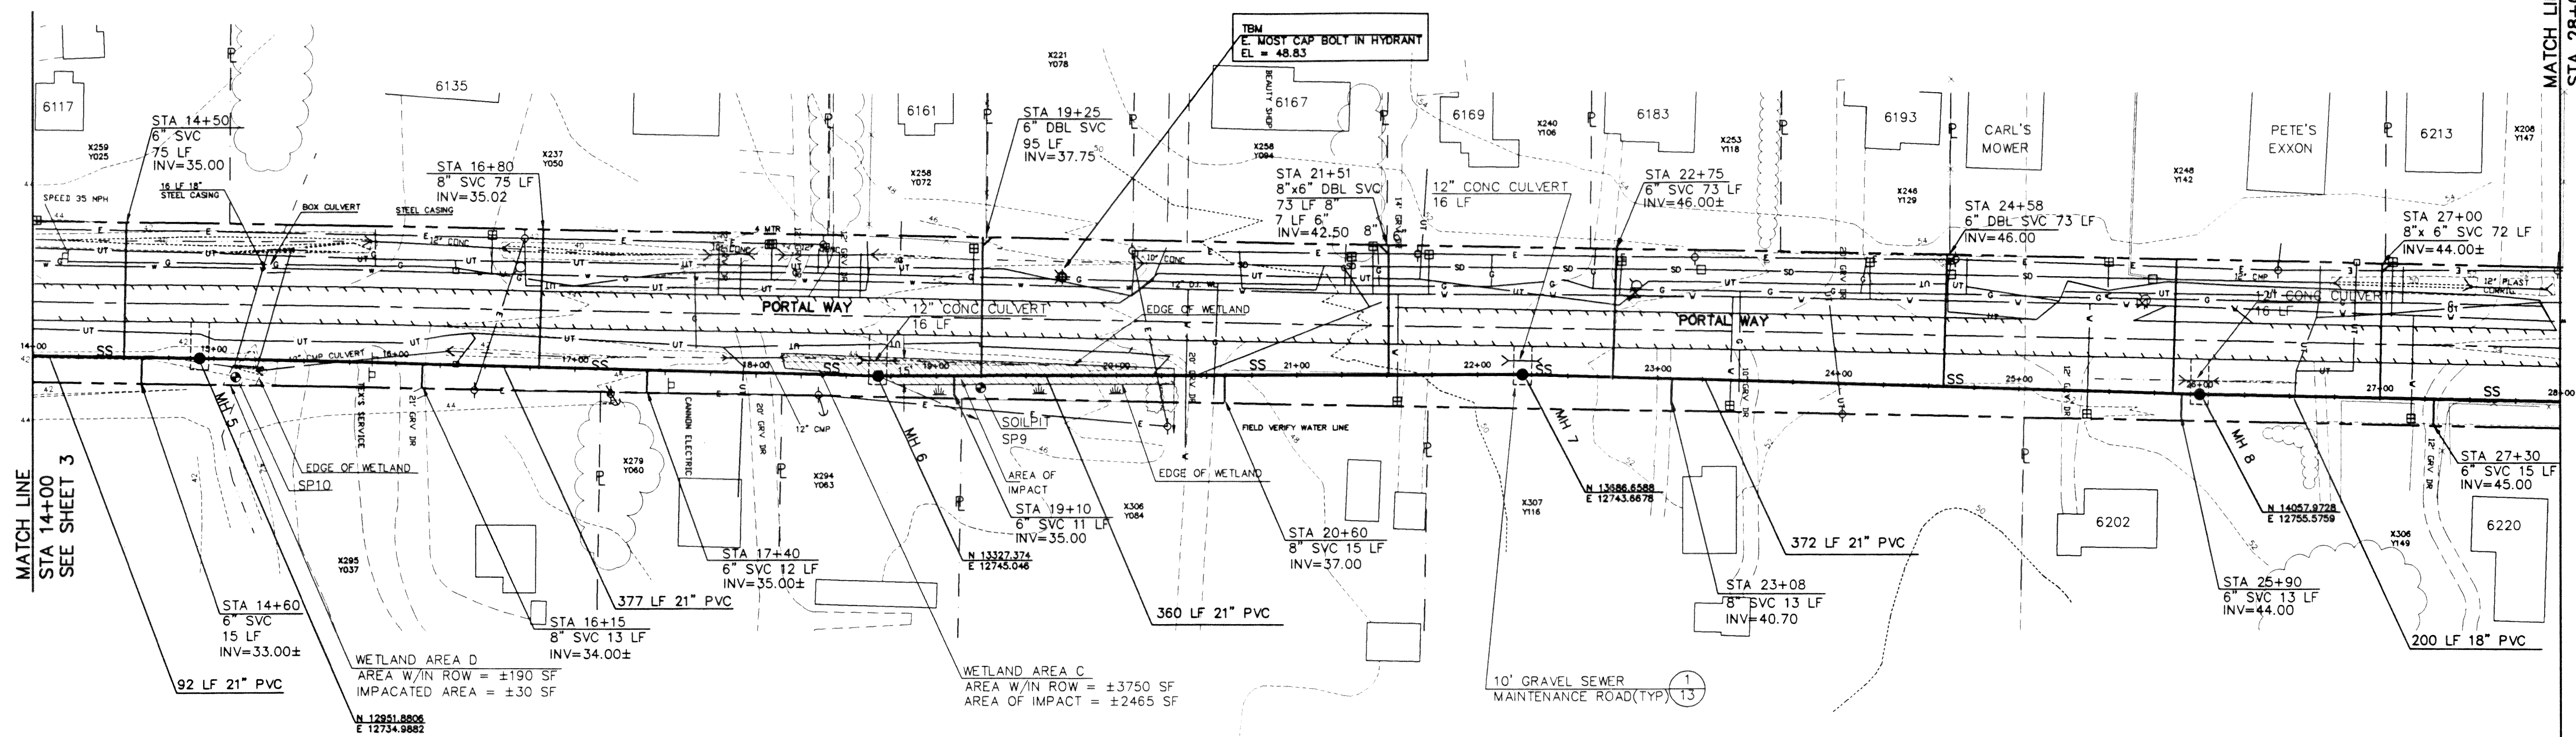

* NOTE:
SIDE SEWER INVERT ELEVATIONS GIVEN ARE
APPROXIMATE, I.E. $\pm 0.5'$. VERIFICATION
IS RESPONSIBILITY OF OTHERS.

WARNING!
UTILITIES IN AREA
CALL UTILITY LOCATORS
PRIOR TO ANY EXCAVATION.

PLAN


SCALE 1 inch = 50 ft.



WETLAND AREAS		
W/1 RIGHT OF WAY	IMPACTED AREA	SHEET NO.
A	0	8
B	3675 SF	5
C	3750 SF	4
D	190 SF	4
E	3590 SF	3
F	N/A	12
G	1365 SF	11
TOTAL	12560 SF	
SWALE	1816 SF	12

NOTE:
WETLAND DELINEATION PROVIDED BY
JOHN WONG, ENVIRONMENTAL CONSULTANT



NOTE: 8" WELL POINTS /CAPS (1 PER MANHOLE) LEFT IN GROUND
FOR FUTURE USE. TYPICALLY WITHIN 3' OF MANHOLE.

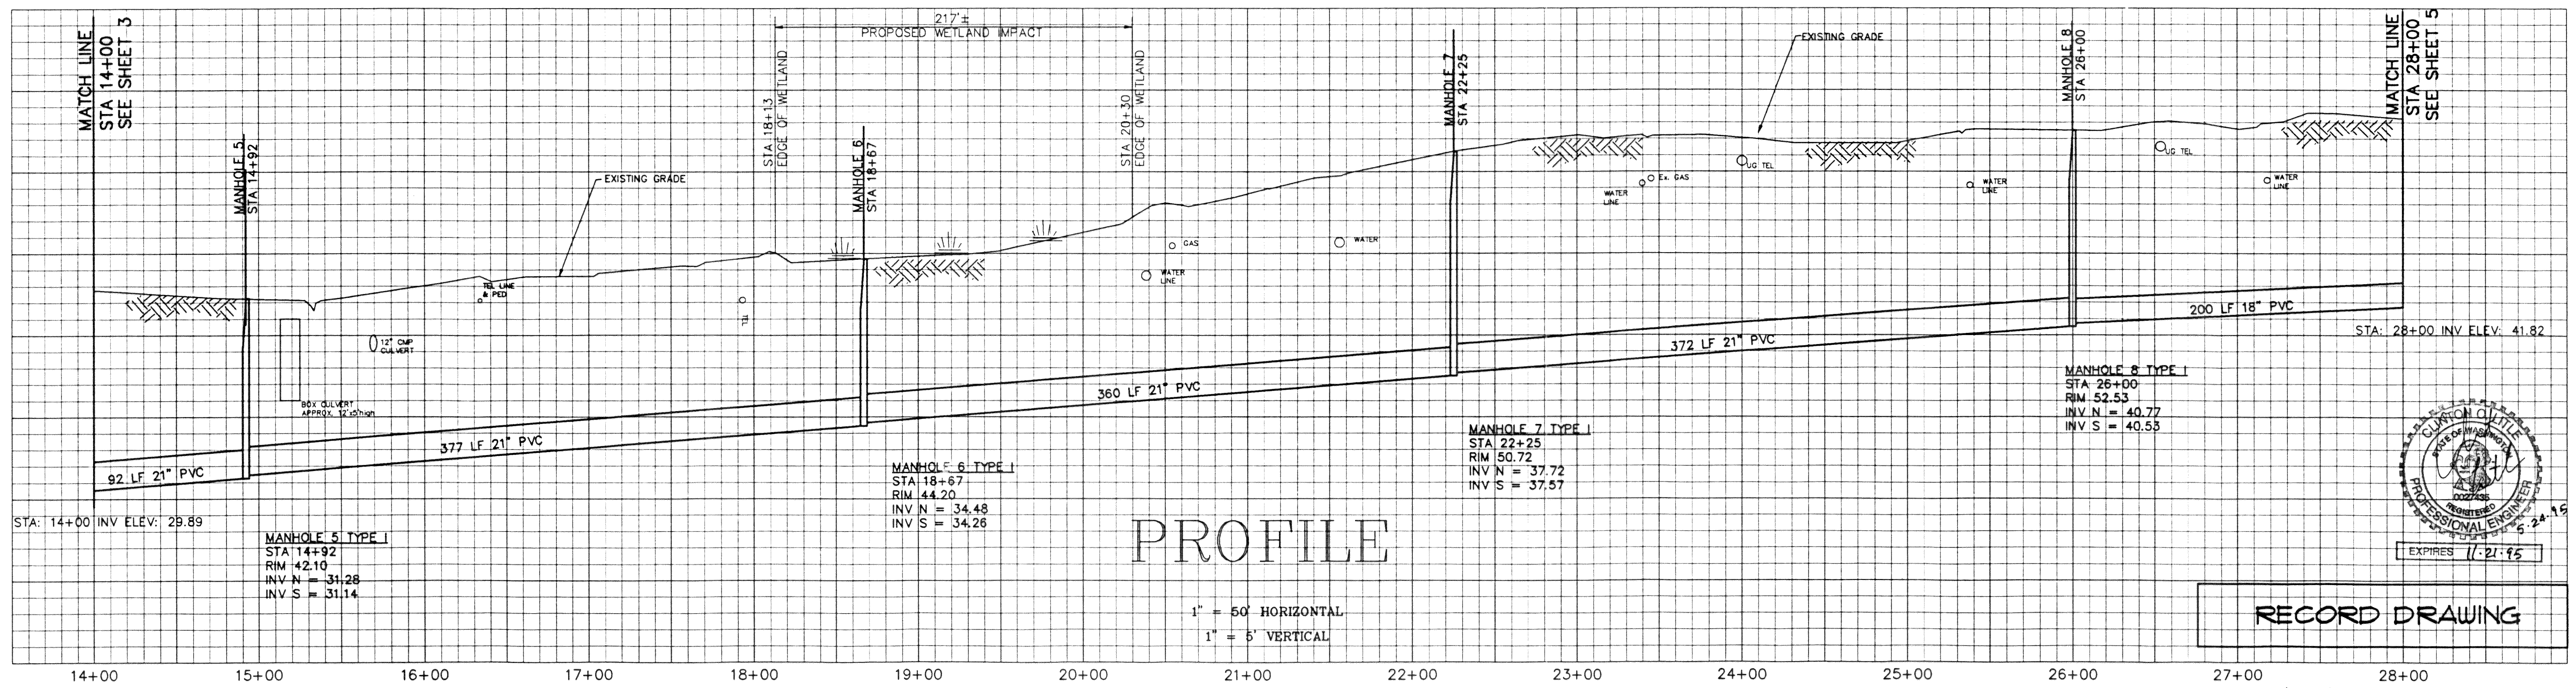

PROFILE

1" = 50' HORIZONTAL
1" = 5' VERTICAL

RECORD DRAWING

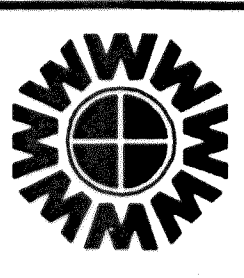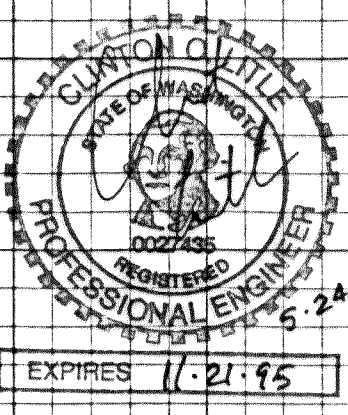


WEDEN ENGINEERING, INC.
119 GRAND AVENUE, SUITE D,
BELLINGHAM, WA. 98225 671-8200

ONE INCH AT FULL SCALE
IF NOT ONE INCH
SCALE ACCORDINGLY

DESIGNED BY
DRAWN BY
CHECKED BY
JLW

CITY OF FERDALE U.L.I.D. NO. 7
PORTAL WAY
SANITARY SEWER EXTENSION
PLAN PROFILE STA 14+00 TO STA 28+00

DATE
09/22/94
SCALE
1"=50'H
1"=5'V
REC. NO.
92096
SHEET
4
OF
16

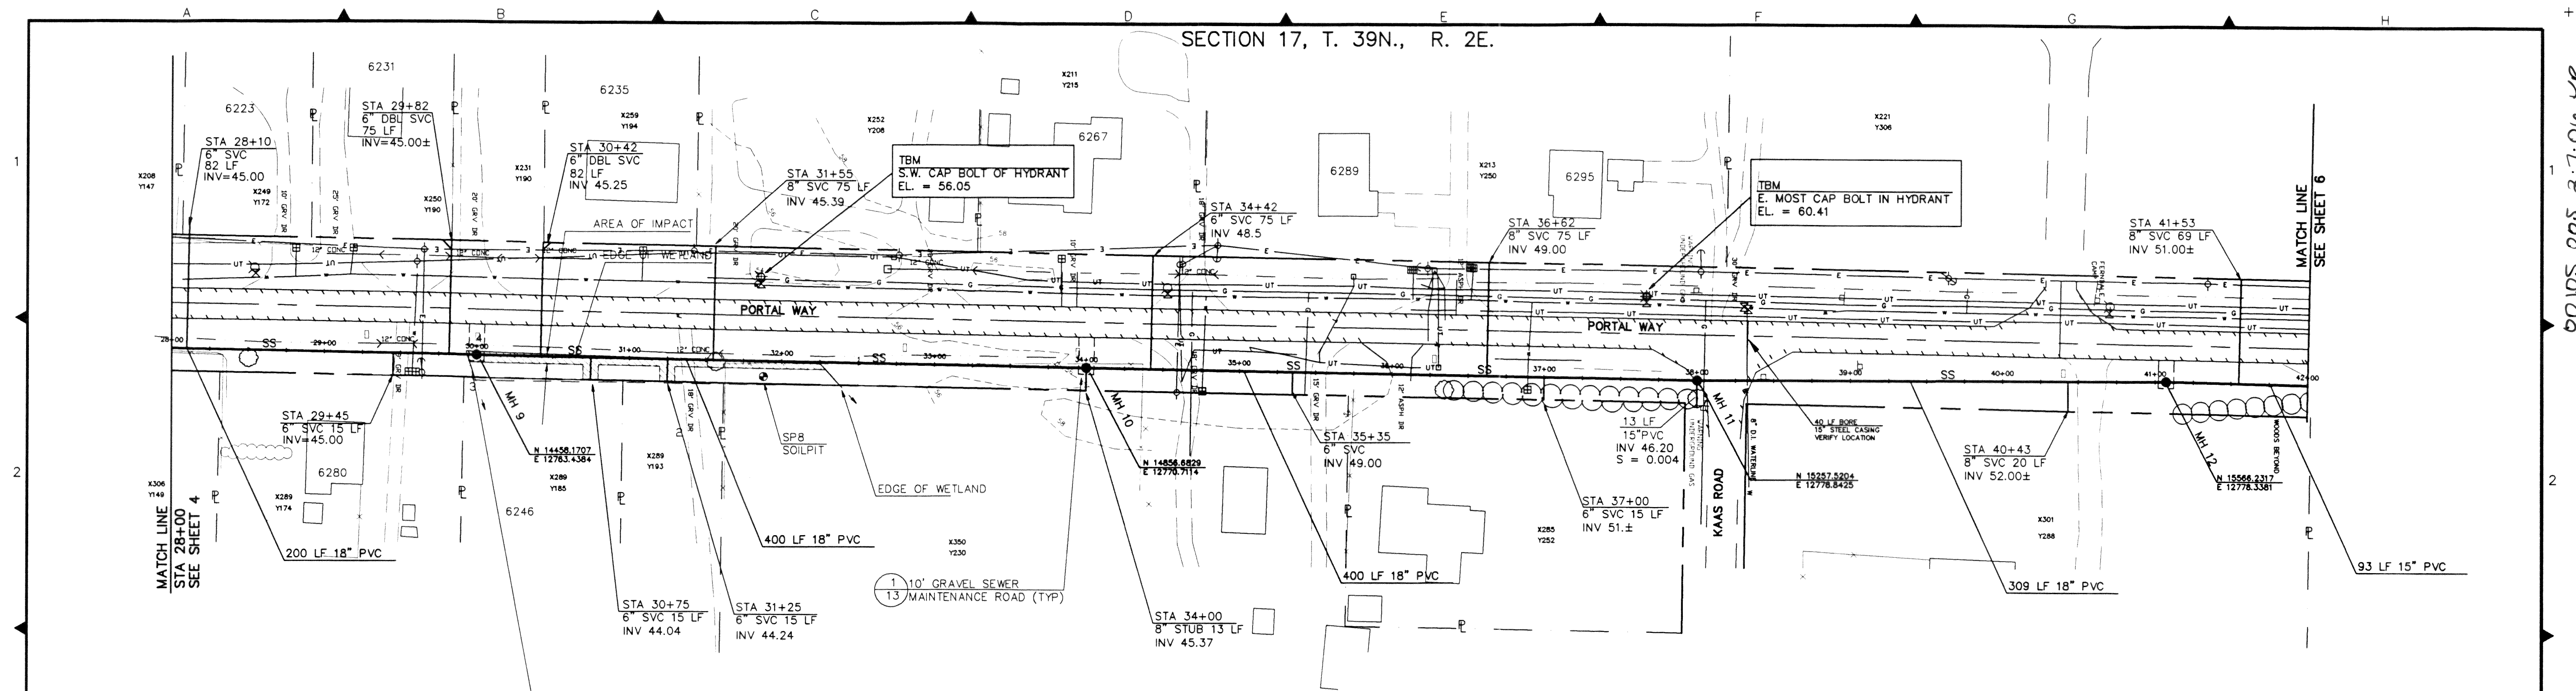

PLAN

SCALE 1 inch = 50 ft.




CONTRACTOR TO COORDINATE ALL UTILITY RESTORATION WITH UTILITY COMPANIES. UNDERGROUND TELECOMMUNICATIONS, TV, POWER AND GAS UTILITY RESTORATION SHALL BE INCIDENTAL TO CONTRACT (TYPICAL)

WARNING! UTILITIES IN AREA CALL UTILITY LOCATORS PRIOR TO ANY EXCAVATION.

* NOTE: SIDE SEWER INVERT ELEVATIONS GIVEN ARE APPROXIMATE, I.E. $\pm 0.5'$. VERIFICATION IS RESPONSIBILITY OF OTHERS.


NOTE: 8" WELL POINTS /CAPS (1 PER MANHOLE) LEFT IN GROUND FOR FUTURE USE. TYPICALLY WITHIN 3' OF MANHOLE.

LIMITS OF WETLAND AREA B
AREA W/IN ROW = 3675 SF
AREA IMPACTED = 1510 SF

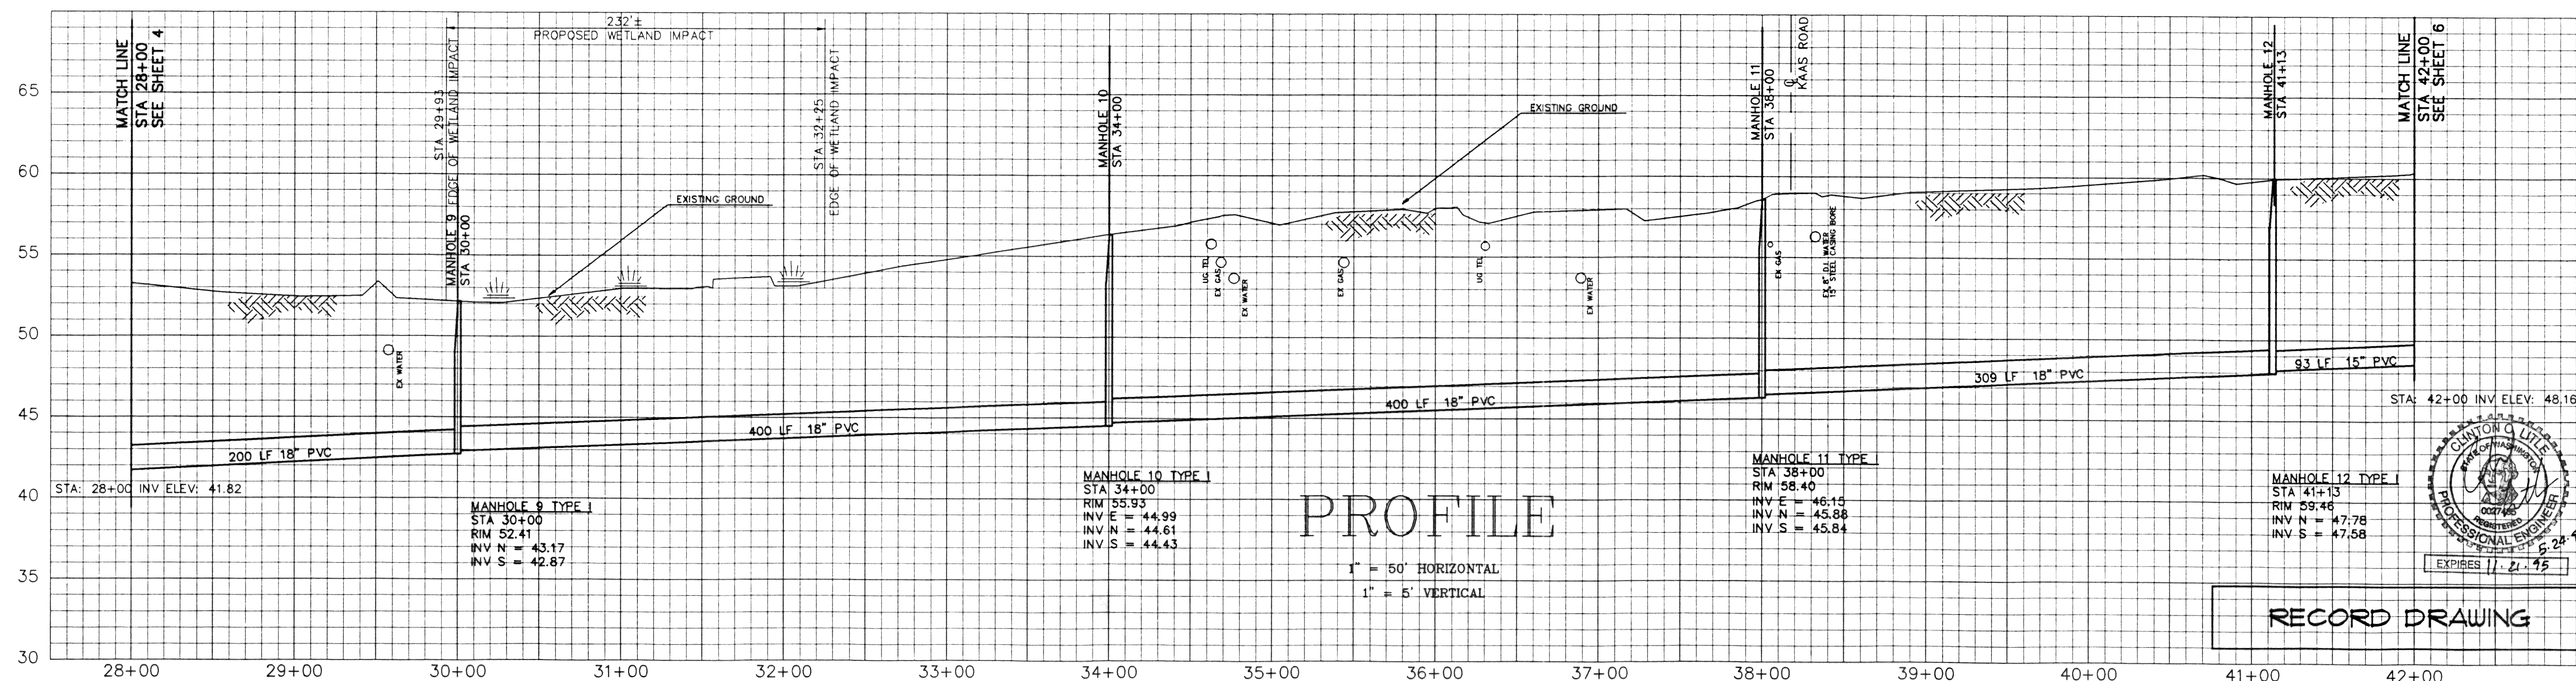


PROFILE

1" = 50' HORIZONTAL
1" = 5' VERTICAL

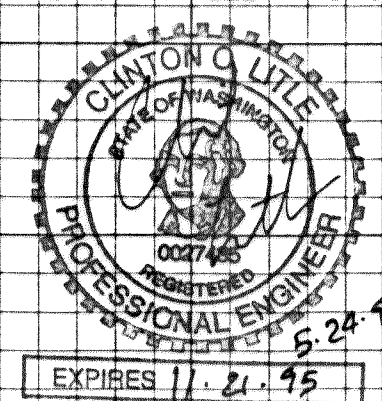

RECORD DRAWING

NO.	REVISIONS	BY	DATE

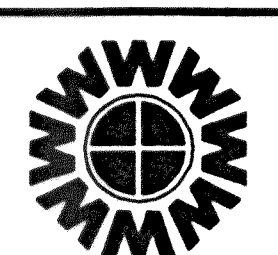

WEDEN ENGINEERING, INC.
119 GRAND AVENUE, SUITE D,
BELLINGHAM, WA. 98225 671-8200

ONE INCH AT FULL SCALE
IF NOT ONE INCH SCALE ACCORDINGLY


DESIGNED BY
DRAWN BY
CHECKED BY

CITY OF FERNDAL U.L.I.D. NO. 7
PORTAL WAY
SANITARY SEWER EXTENSION
PLAN PROFILE STA 28+00 TO STA 42+00

DATE
09/22/94
SCALE
1"=50'H
1"=5'V
REC. NO.
92096

SHEET
5
OF
16

SECTION 17, T. 39N., R. 2E.

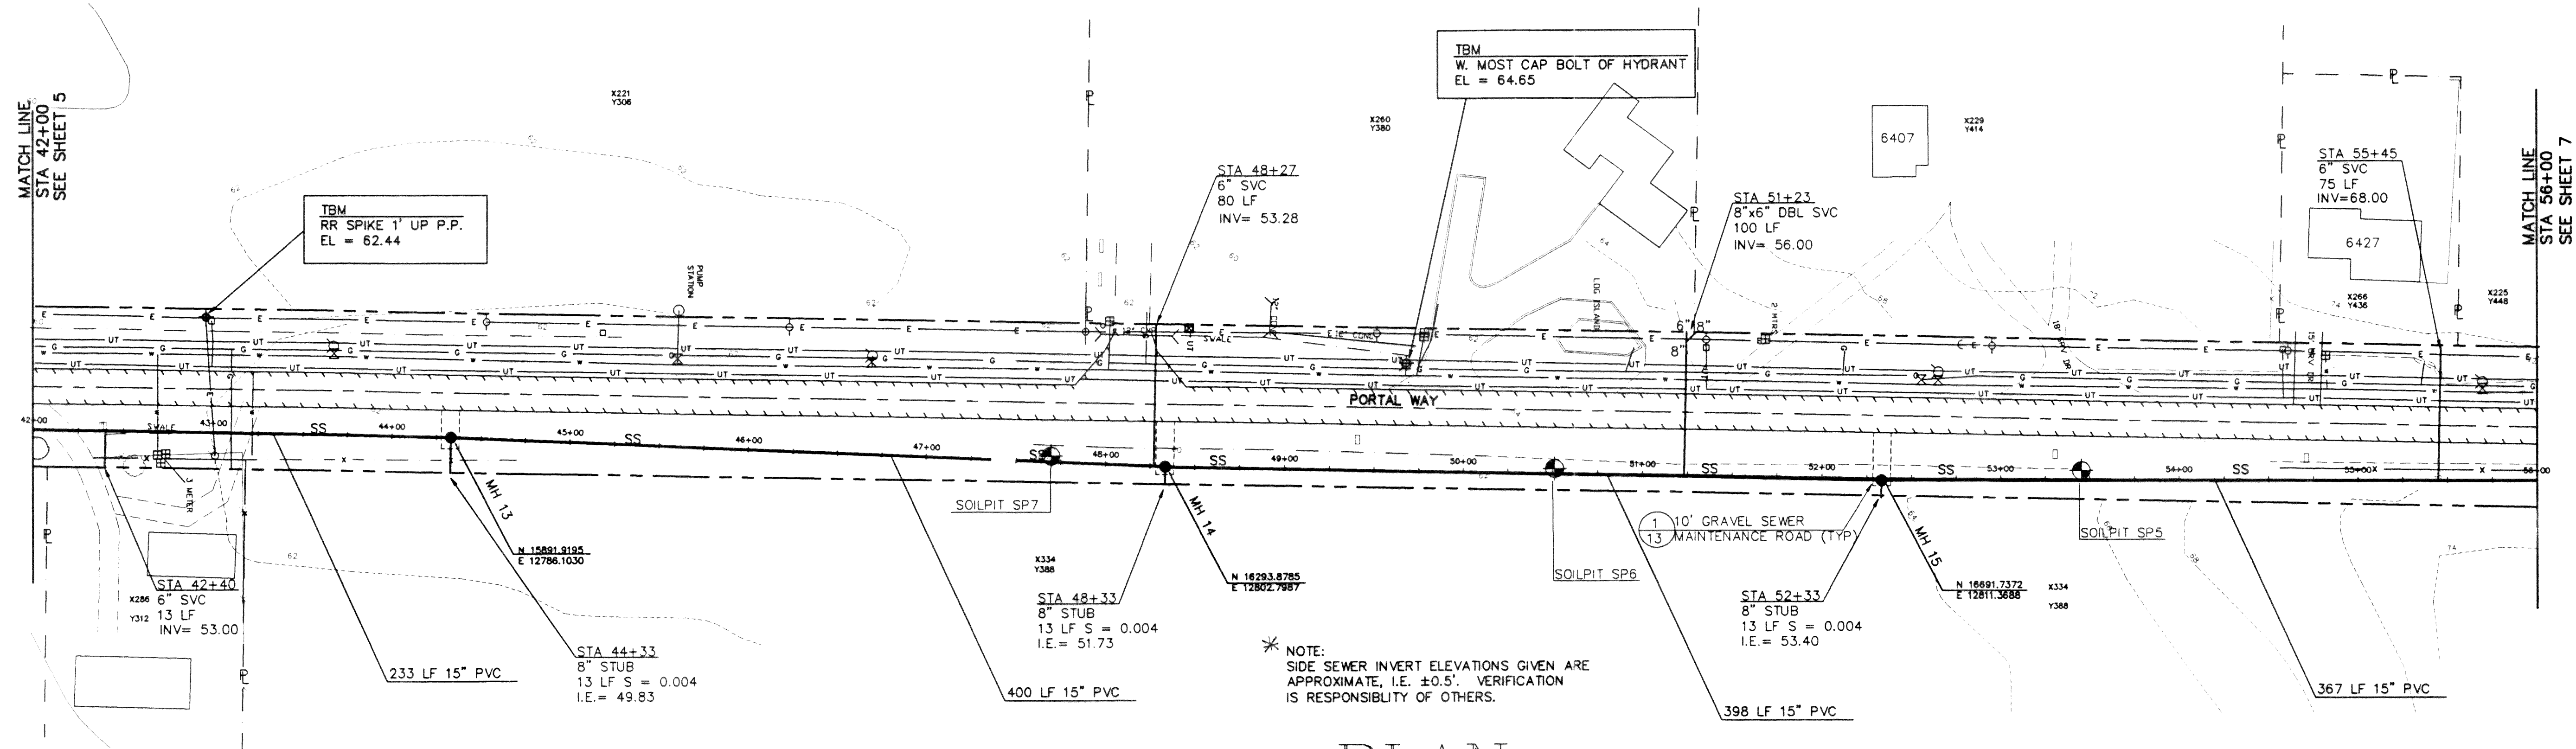



PLAN

SCALE 1 inch = 50 ft.




NOTE: 8\"/>

WARNING!
UTILITIES IN AREA
CALL UTILITY LOCATORS
PRIOR TO ANY EXCAVATION.

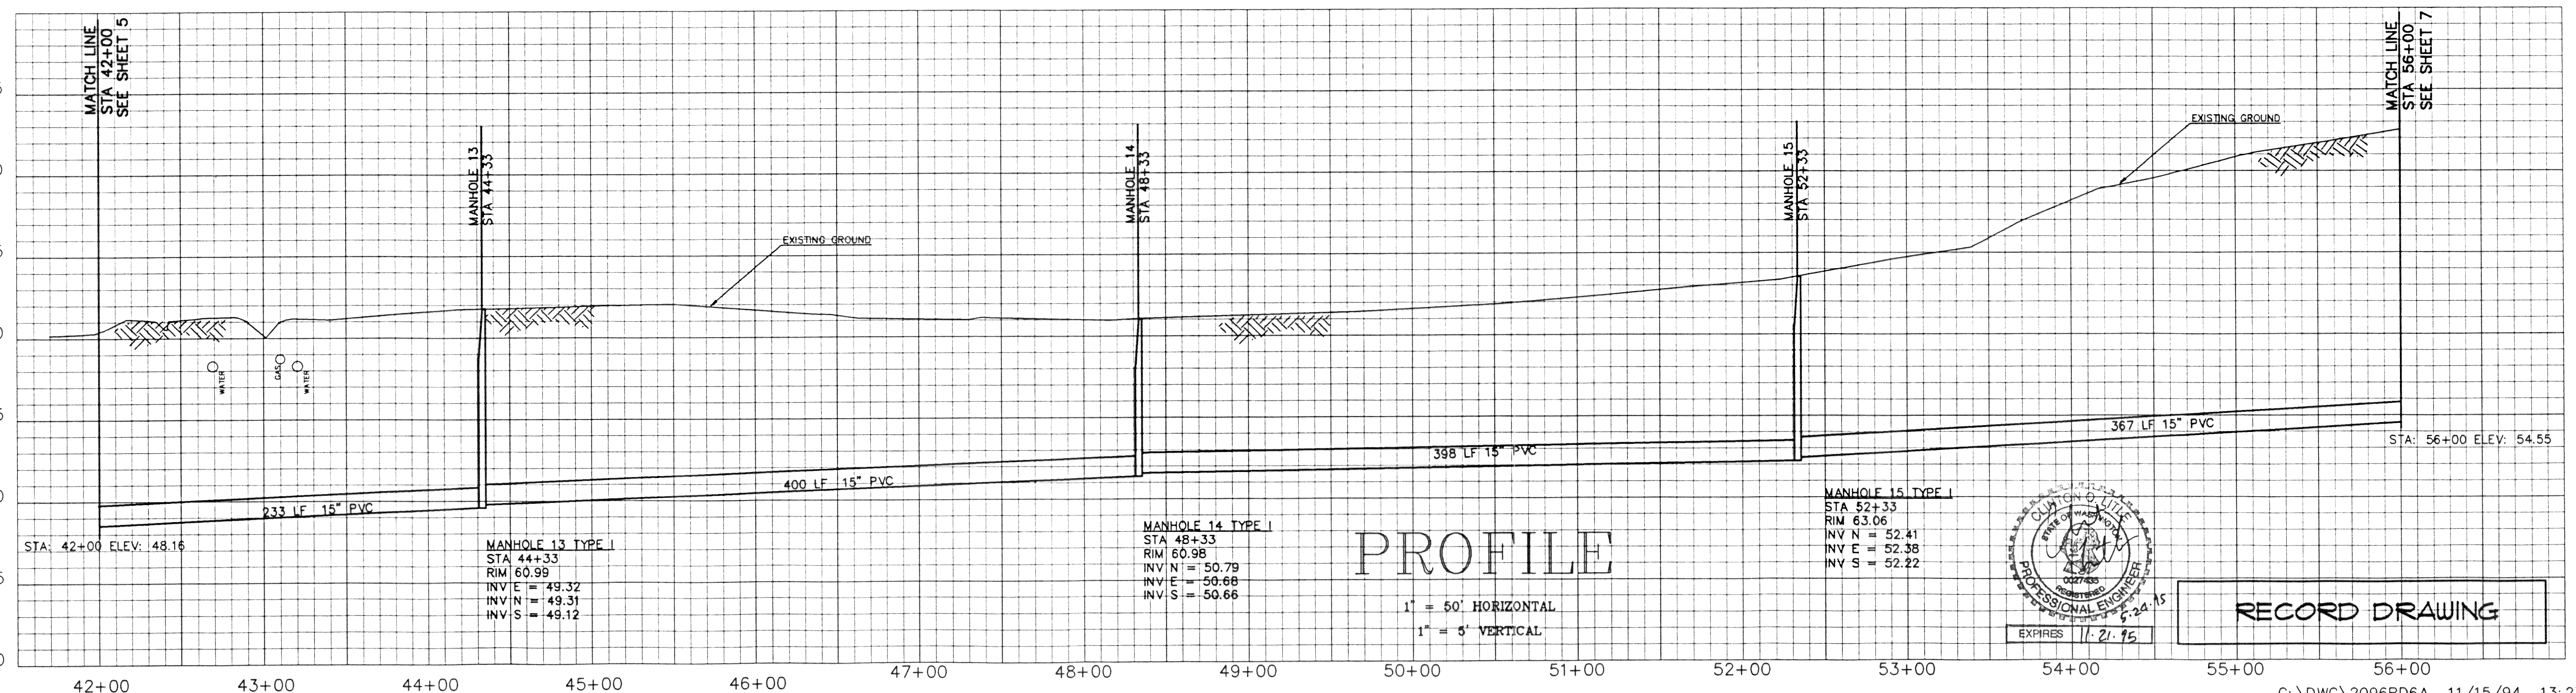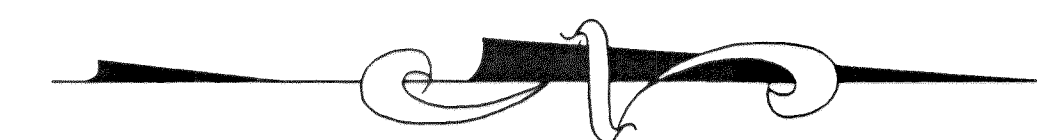


PROFILE

1\"/>

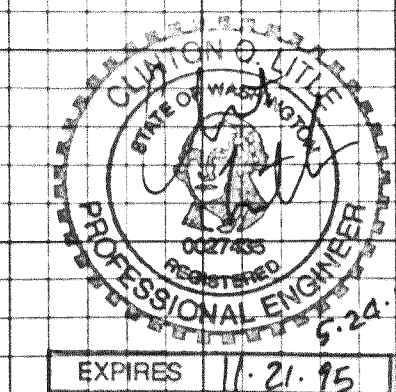

RECORD DRAWING

NO.	REVISIONS	BY	DATE

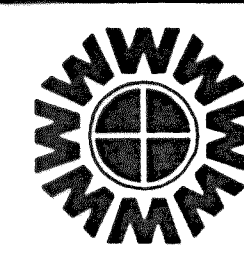

WEDEN ENGINEERING, INC.
119 GRAND AVENUE, SUITE D,
BELLINGHAM, WA. 98225 671-8200


ONE INCH AT FULL SCALE
IF NOT ONE INCH
SCALE ACCORDINGLY

DESIGNED BY
DRAWN BY
CHECKED BY

CITY OF FERNDAL U.L.I.D. NO. 7
PORTAL WAY
SANITARY SEWER EXTENSION
PLAN PROFILE STA 42+00 TO STA 56+00


DATE
09/22/94
SCALE
1\"/>

00105.006 2.7.06 KR

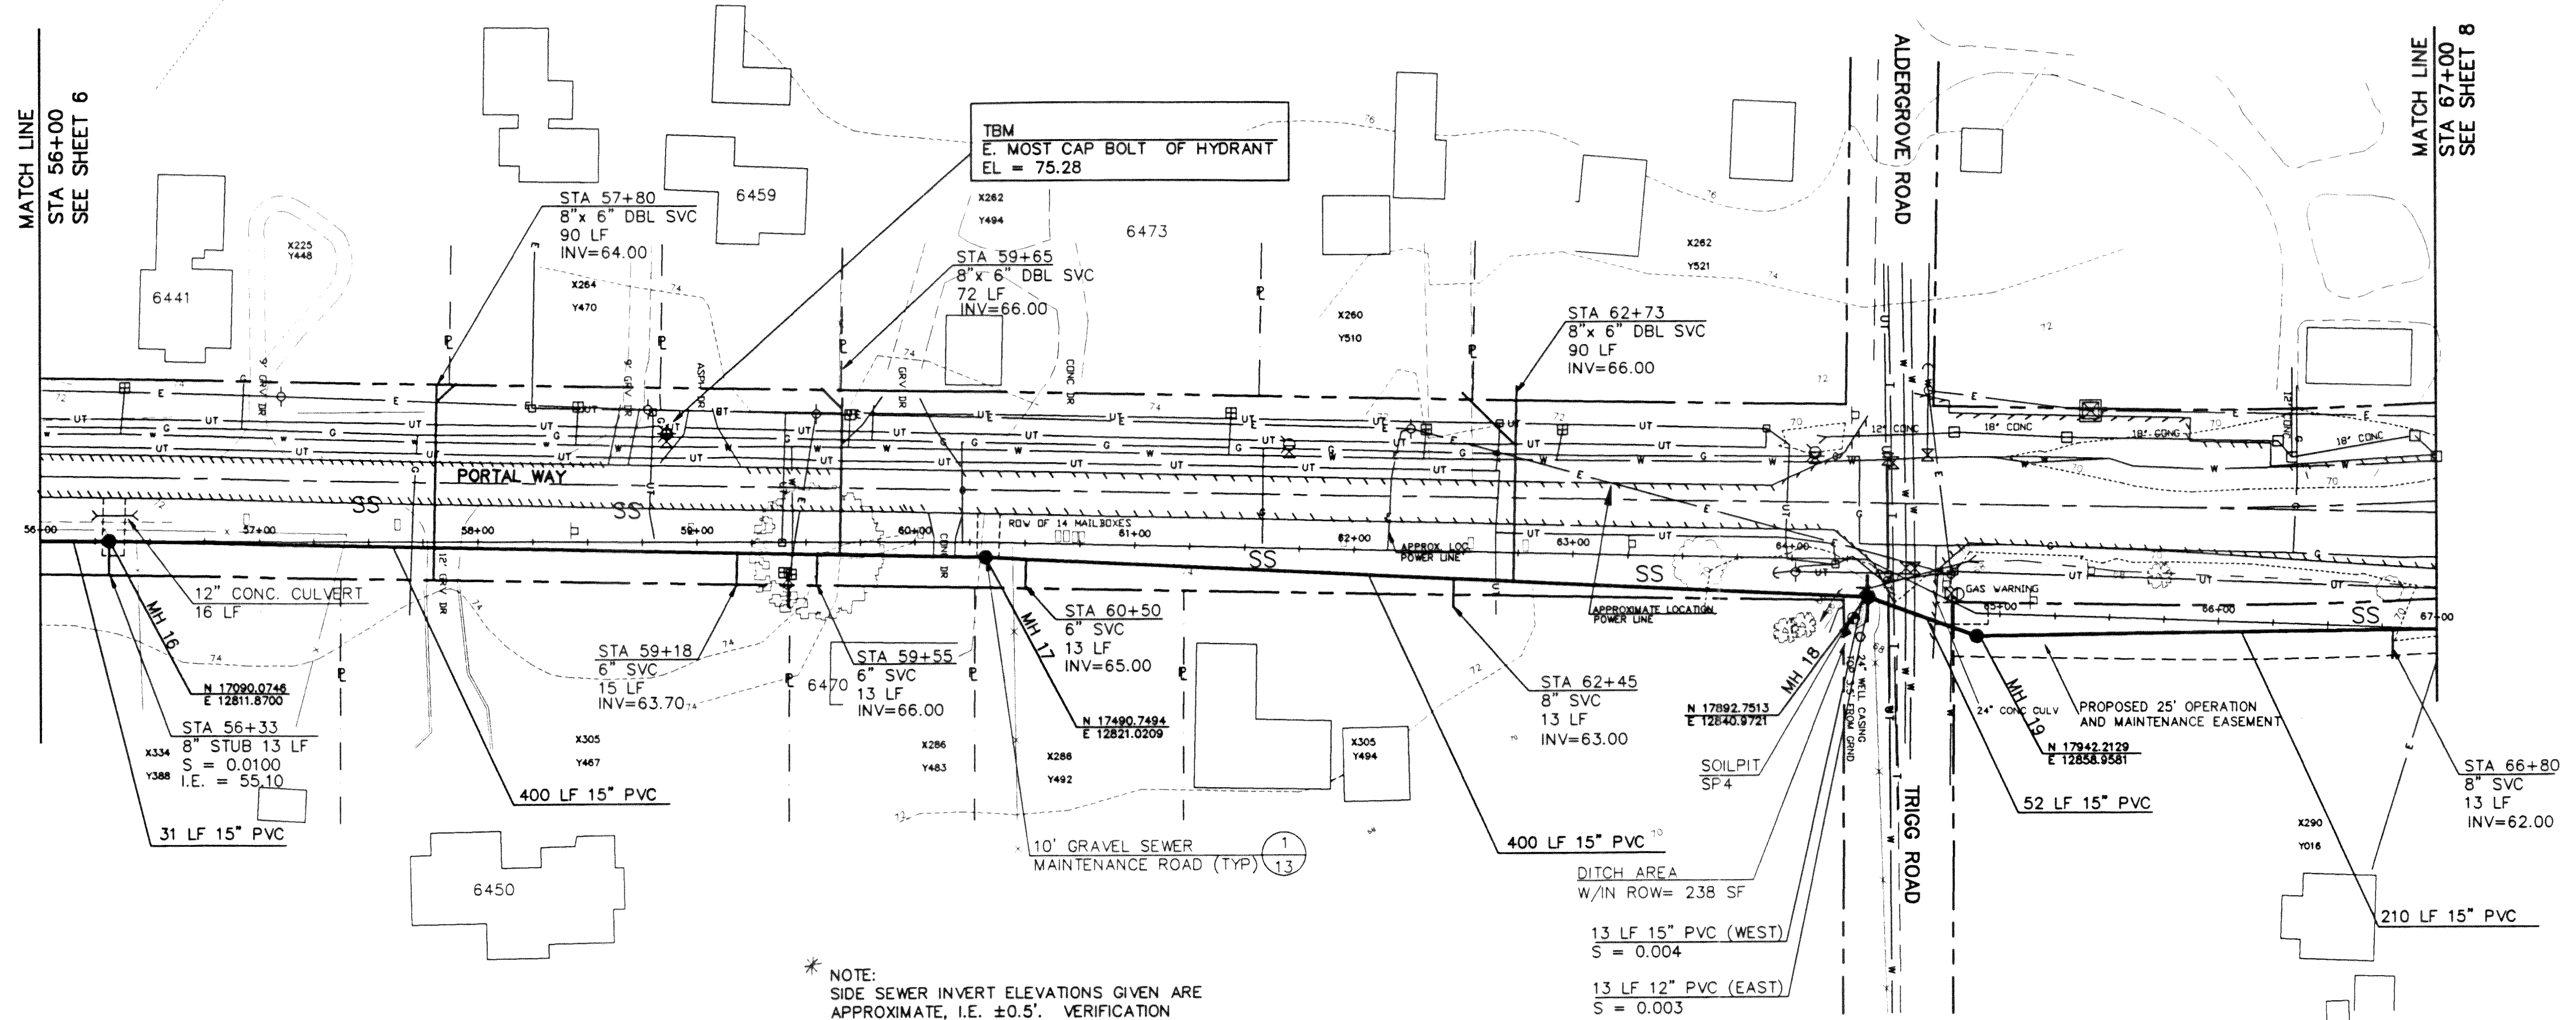


PLAN

SCALE 1 inch = 50 ft.

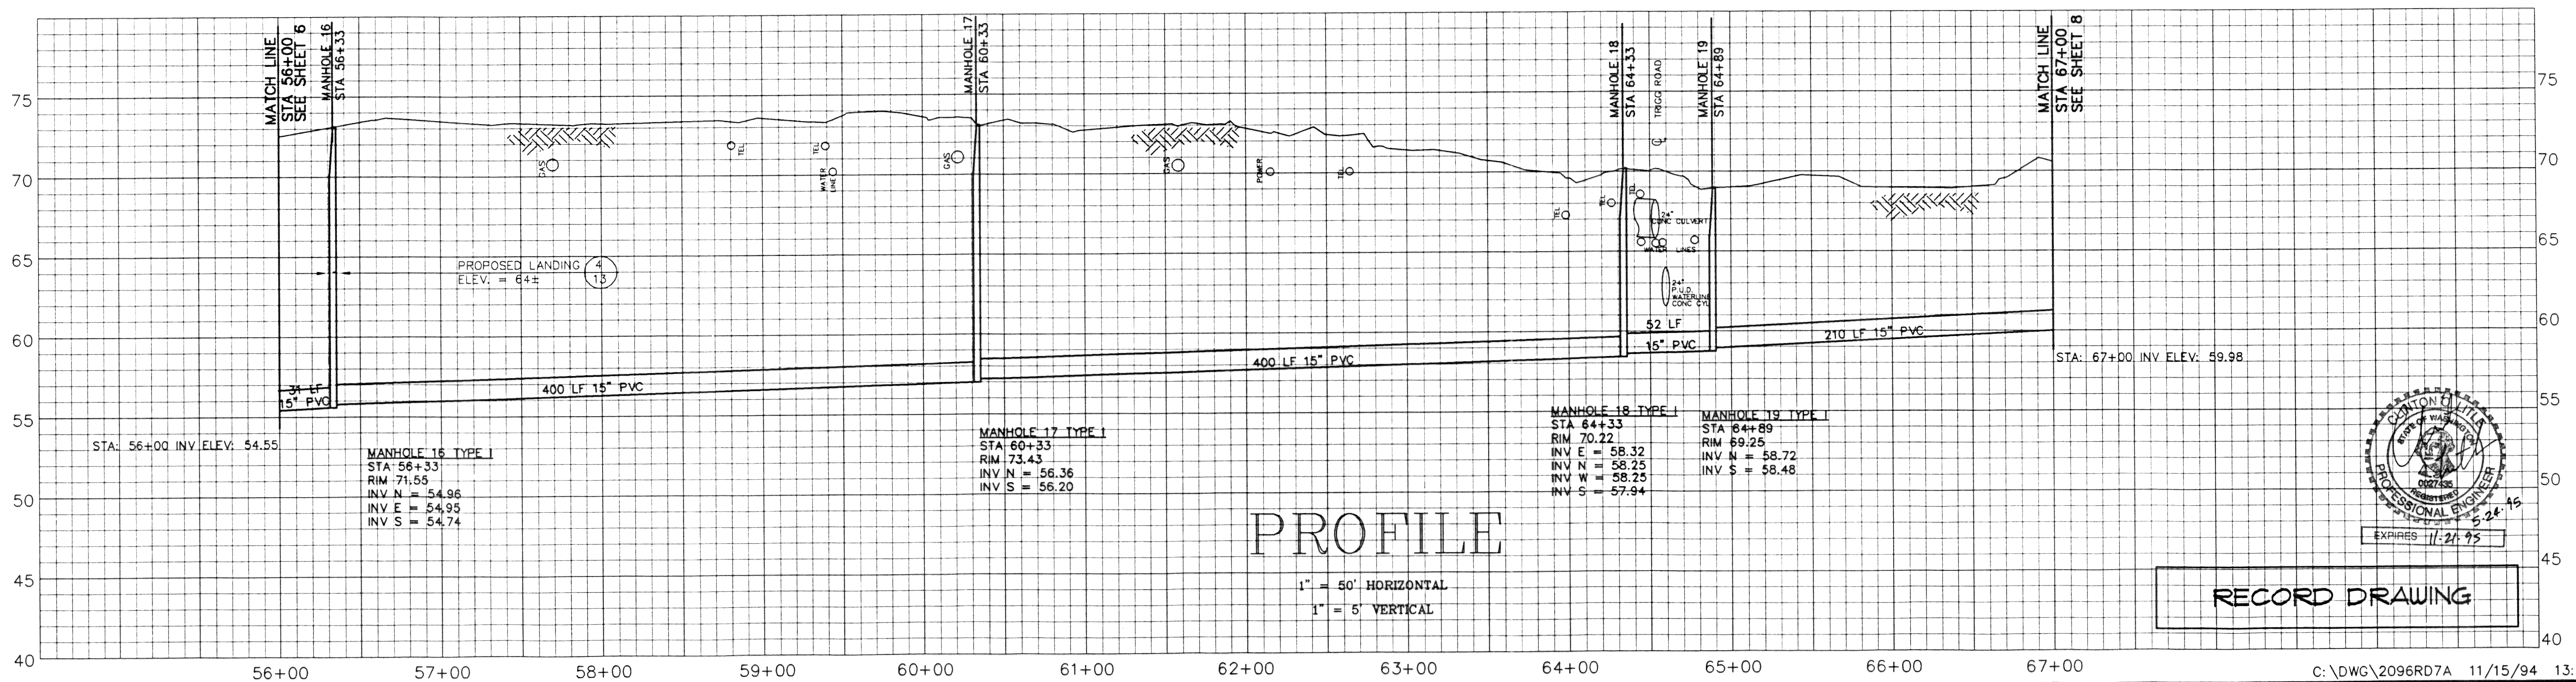


PROFILE

1" = 50' HORIZONTAL
1" = 5' VERTICAL

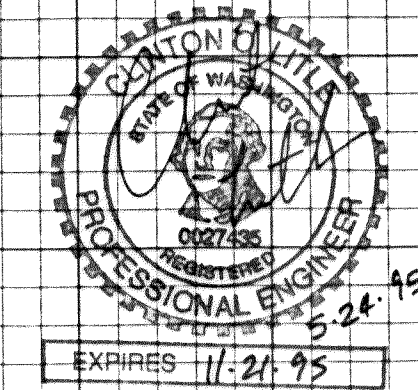

RECORD DRAWING

NO.	REVISIONS	BY	DATE

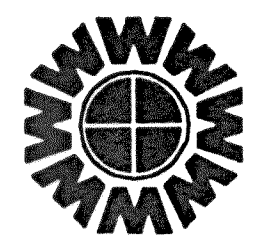


WEDEN ENGINEERING, INC.
119 GRAND AVENUE, SUITE D,
BELLINGHAM, WA. 98225 671-8200

ONE INCH AT FULL SCALE
IF NOT ONE INCH
SCALE ACCORDINGLY

DESIGNED BY
DRAWN BY
CHECKED BY JLW

CITY OF FERDALE U.I.D. NO. 7
PORTAL WAY
SANITARY SEWER EXTENSION
PLAN PROFILE STA 56+00 TO STA 67+00

DATE 09/22/94	SHEET 7
SCALE 1"=50'H 1"=5'V	OF
REC. NO. 92096	16

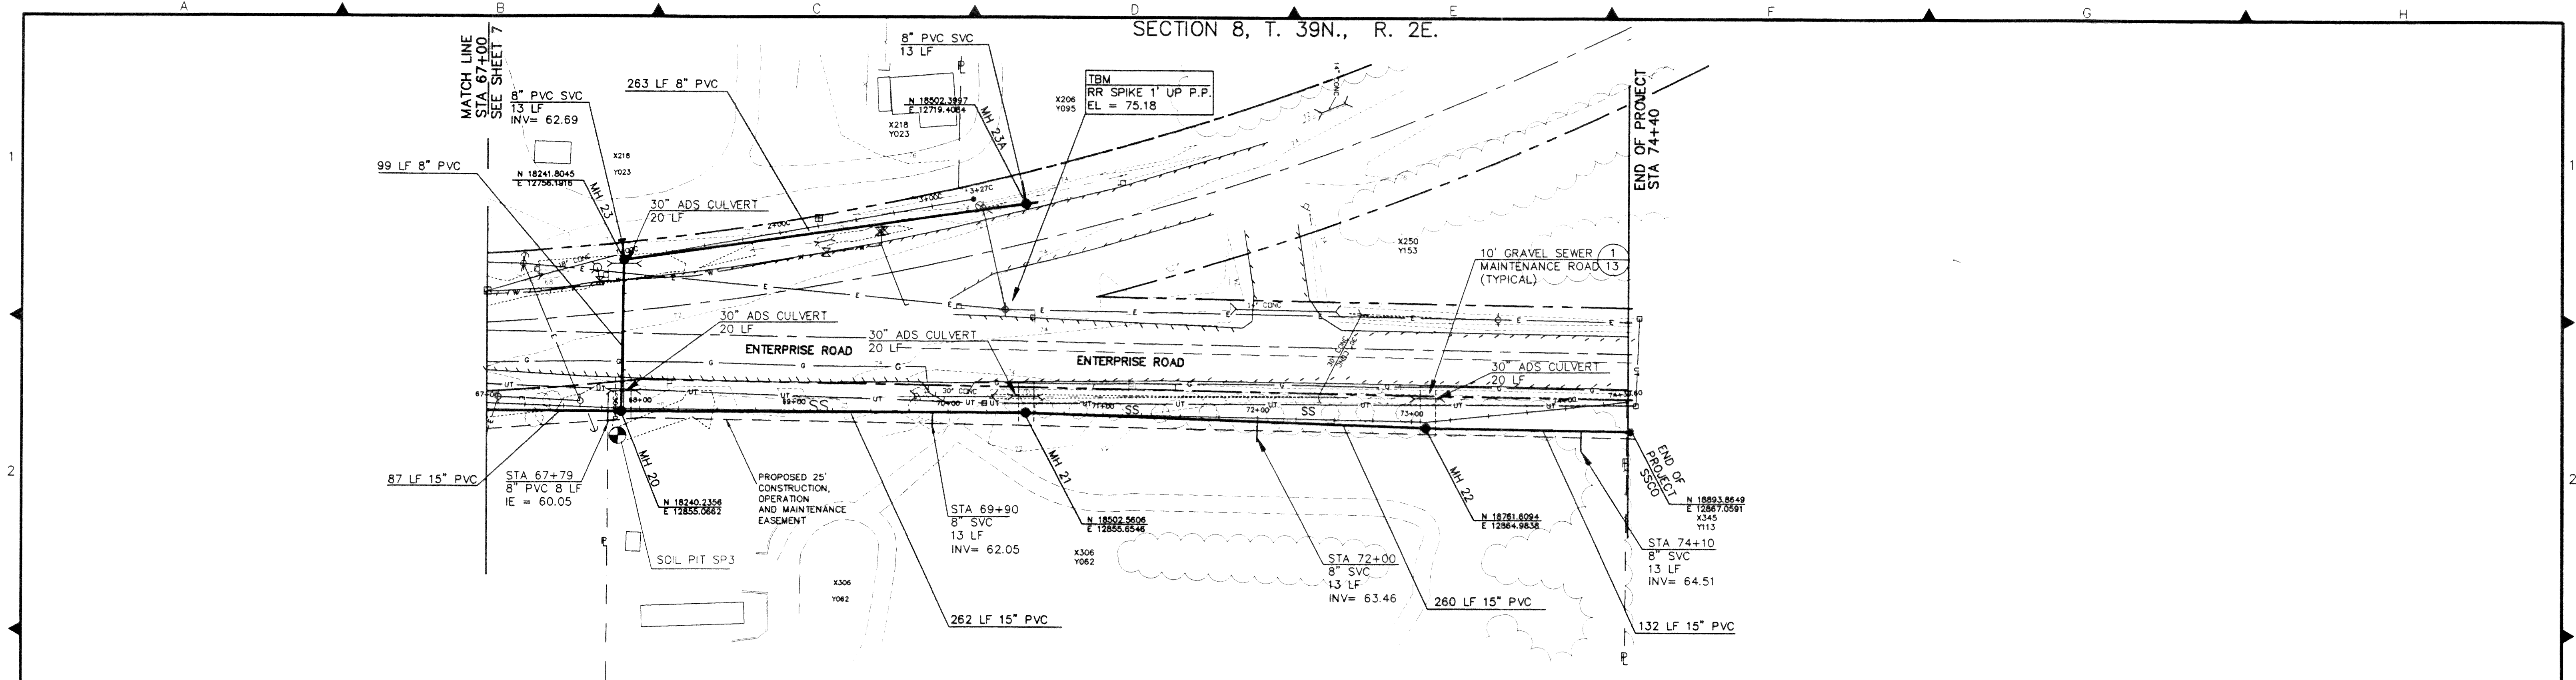


* NOTE:
SIDE SEWER INVERT ELEVATIONS GIVEN ARE
APPROXIMATE, I.E. $\pm 0.5'$. VERIFICATION
IS RESPONSIBILITY OF OTHERS.

PLAN

SCALE 1 inch = 50 ft.




WARNING!
UTILITIES IN AREA
CALL UTILITY LOCATORS
PRIOR TO ANY EXCAVATION.

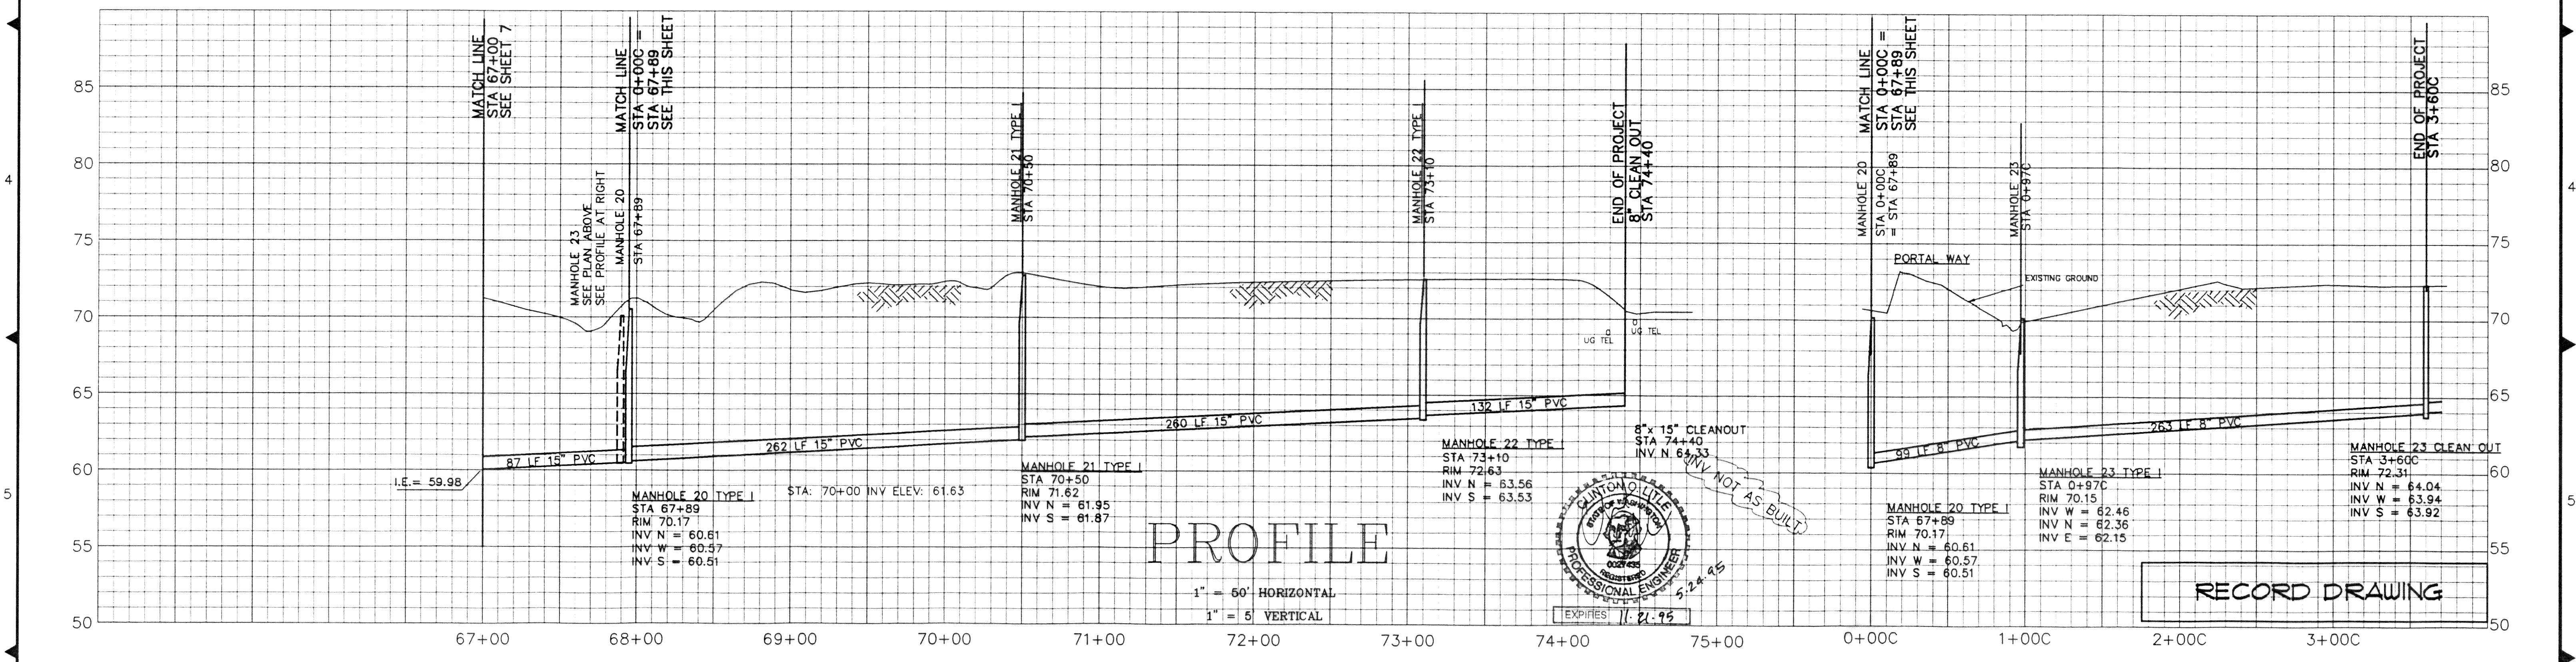


PROFILE

1" = 60' HORIZONTAL
1" = 5' VERTICAL

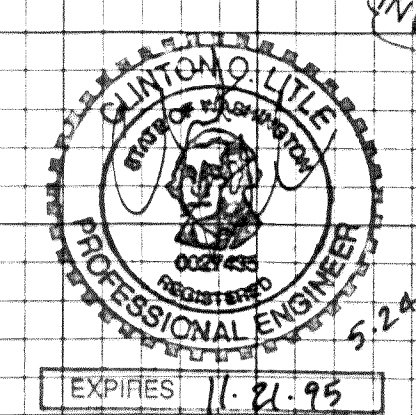

RECORD DRAWING

NO.	REVISIONS	BY	DATE

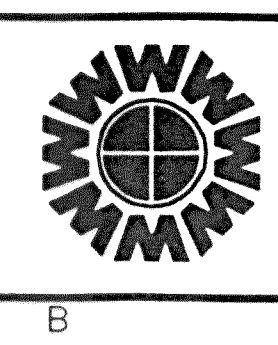


WEDEN ENGINEERING, INC.
119 GRAND AVENUE, SUITE D,
BELLINGHAM, WA. 98225 671-8200

DESIGNED BY	
DRAWN BY	
CHECKED BY	JLW

CITY OF FERNDAL U.L.I.D. NO. 7
PORTAL WAY
SANITARY SEWER EXTENSION
PLAN PROFILE STA 67+00 TO STA 74+40, STA 0+00C TO STA 3+27C

DATE	SHEET
09/22/94	8
SCALE	OF
1"=50'H	16
1"=5'V	
REC. NO.	
92096	

SECTION 20, T. 39N., R. 2E.

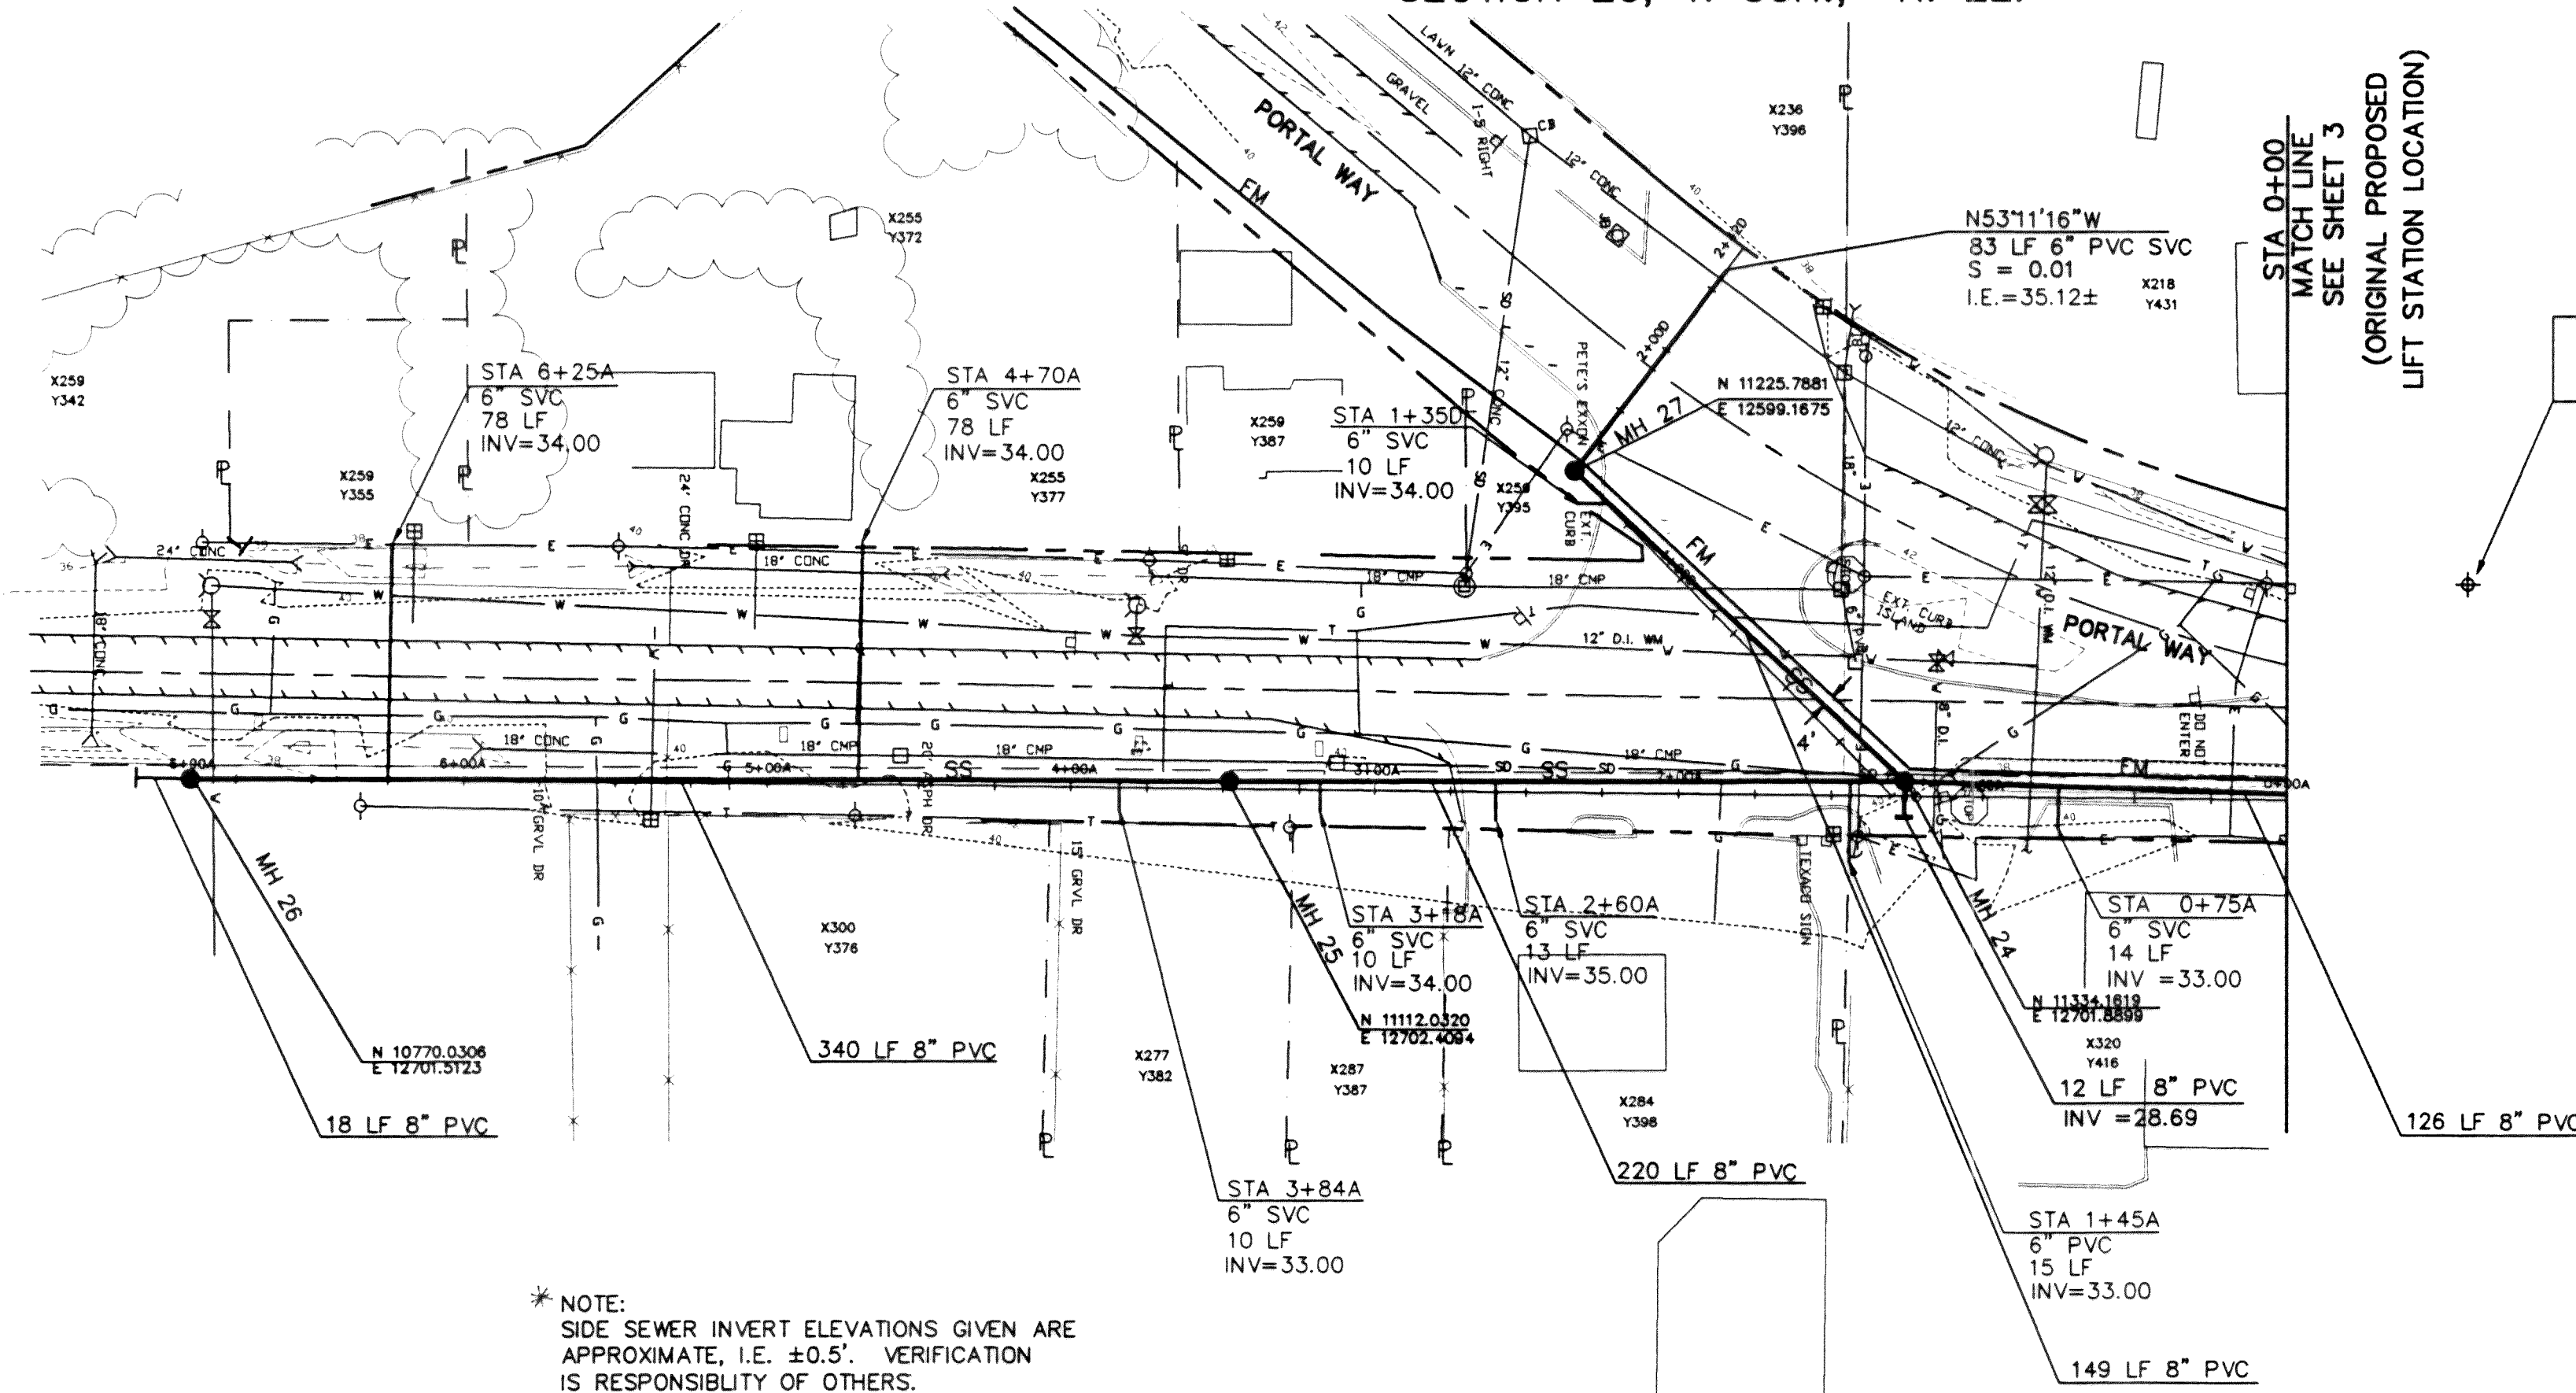

* NOTE:
SIDE SEWER INVERT ELEVATIONS GIVEN ARE
APPROXIMATE, I.E. $\pm 0.5'$. VERIFICATION
IS RESPONSIBILITY OF OTHERS.

PLAN

SCALE 1 inch = 50 ft.




WARNING!
UTILITIES IN AREA
CALL UTILITY LOCATORS
PRIOR TO ANY EXCAVATION.

STA 0+00
MATCH LINE
SEE SHEET 3
(ORIGINAL PROPOSED
LIFT STATION LOCATION)


TBM
RR SPIKE 1.5' UP E. FACE P.P.
EL. = 41.12

STA 0+00 IS
ORIGINAL PROPOSED
LIFT STATION LOCATION

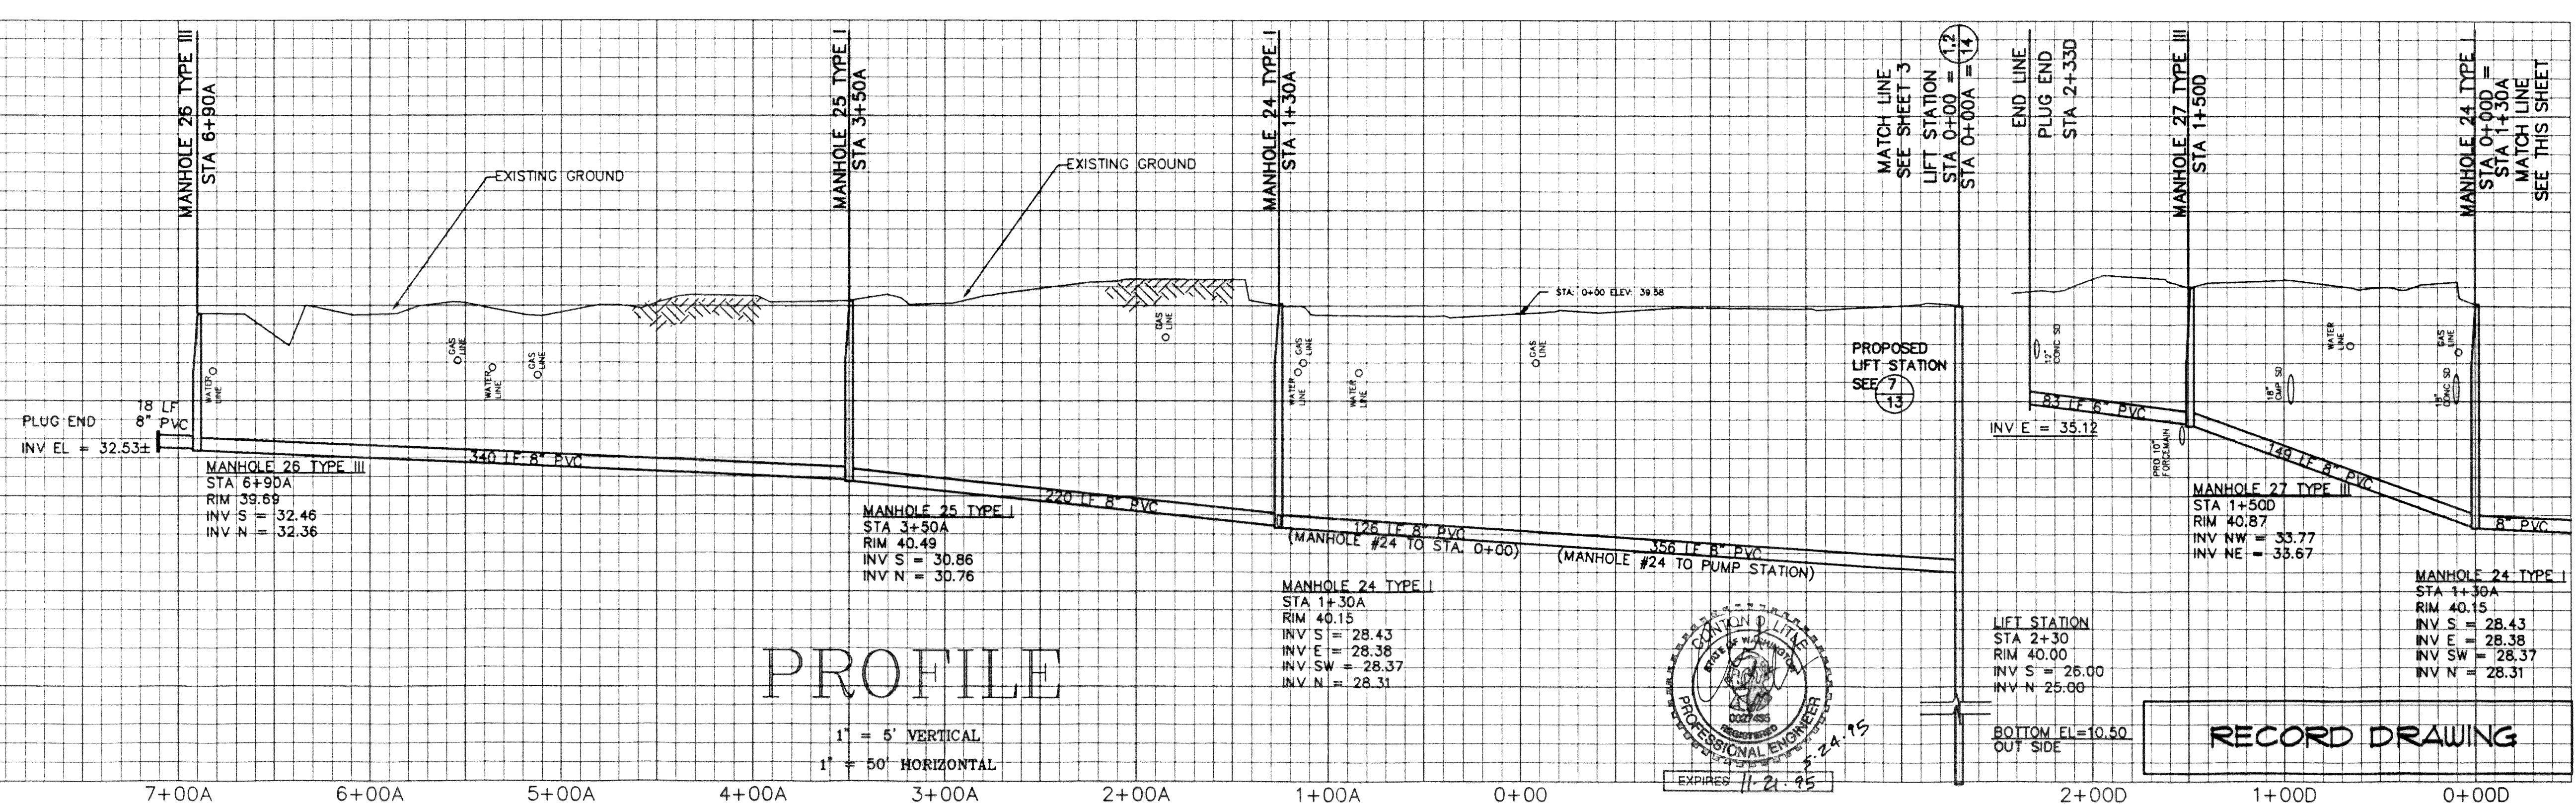


PROFILE

1" = 5' VERTICAL
1" = 50' HORIZONTAL

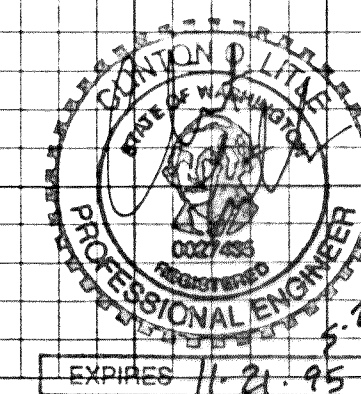

RECORD DRAWING

NO.	REVISIONS	BY	DATE

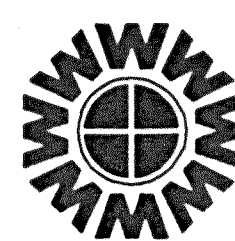

WEDEN ENGINEERING, INC.
119 GRAND AVENUE, SUITE D,
BELLINGHAM, WA. 98225 671-8200



ONE INCH AT FULL SCALE
IF NOT ONE INCH
SCALE ACCORDINGLY

DESIGNED BY
DRAWN BY
CHECKED BY
J

CITY OF FERNDALE U.L.I.D. NO. 7
PORTAL WAY
SANITARY SEWER EXTENSION
PLAN PROFILE STA 0+00A TO STA 6+90A, STA 0+00D TO STA 2+42D

DATE
09/22/94
SCALE
1"=50'H
1"=5'V
REC. NO.
92096
SHEET
9
OF
16

C:\DWG\2096RD9A 11/15/94 13:33

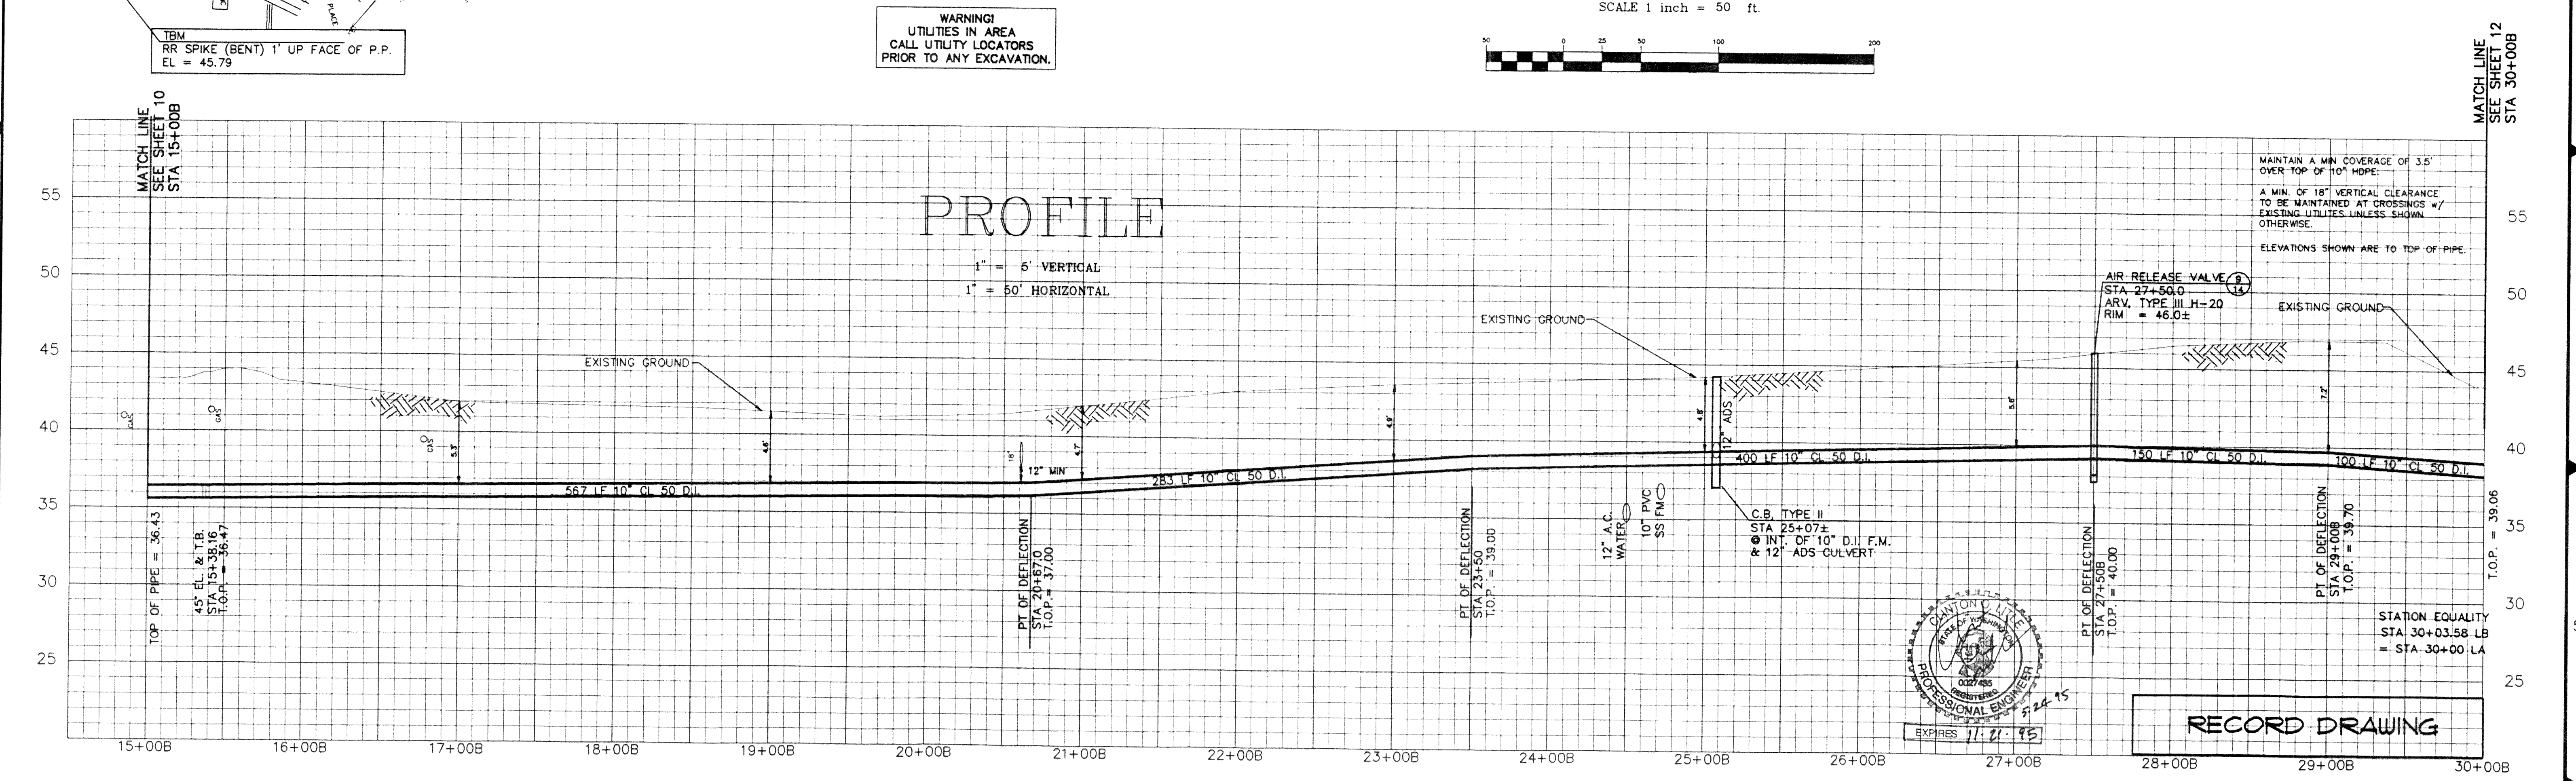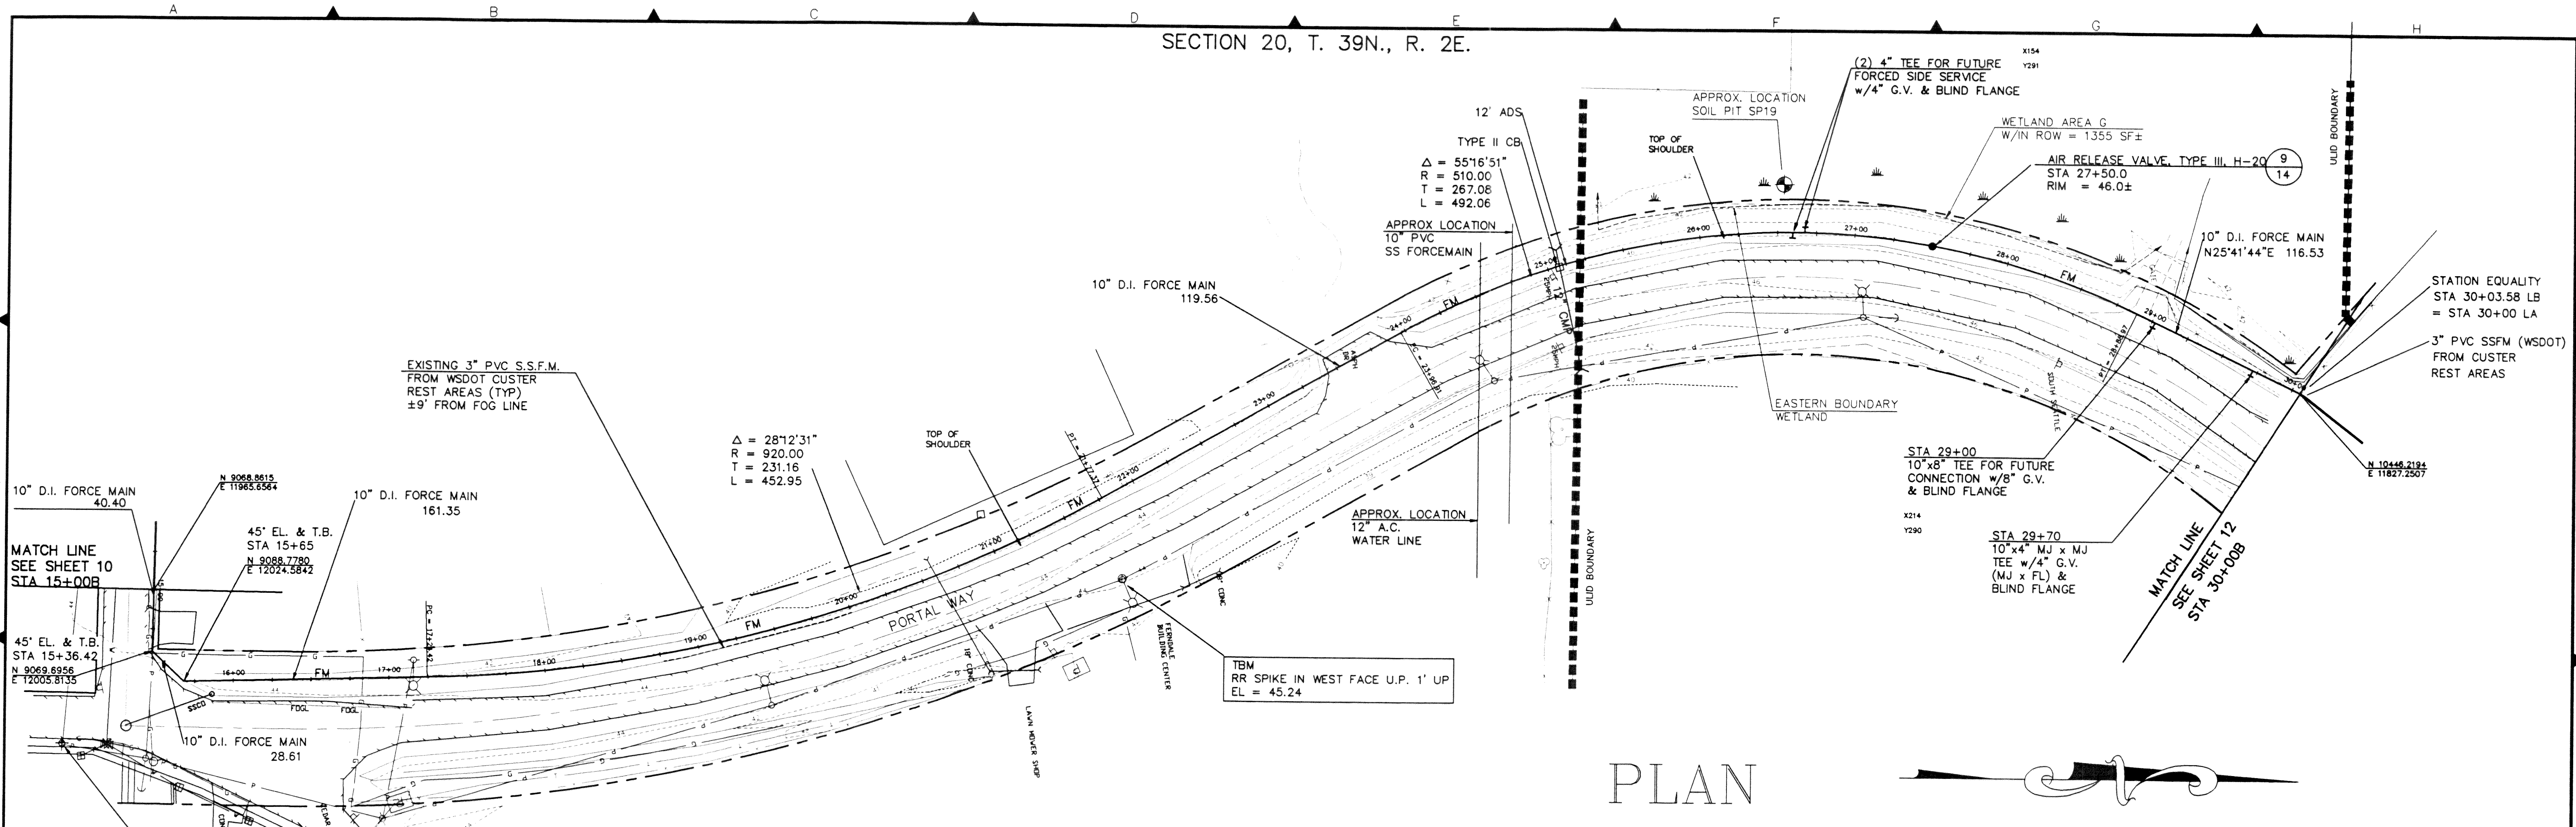

NO.	REVISIONS	BY	DATE

WEDEN ENGINEERING, INC.
119 GRAND AVENUE, SUITE D,
BELLINGHAM, WA. 98225 671-8200

ONE INCH AT FULL SCALE

IF NOT ONE INCH SCALE ACCORDINGLY

DESIGNED BY

DRAWN BY



CHECKED BY

















JLW

CITY OF FERNDALE U.L.I.D. NO. 7
PORTAL WAY
SANITARY SEWER EXTENSION
PLAN PROFILE FORCE MAIN STA 15+00 TO STA 30+00


DATE	SHEET
09/22/94	11
11/09/94	16

SECTION 20, T. 39N., R. 2E.

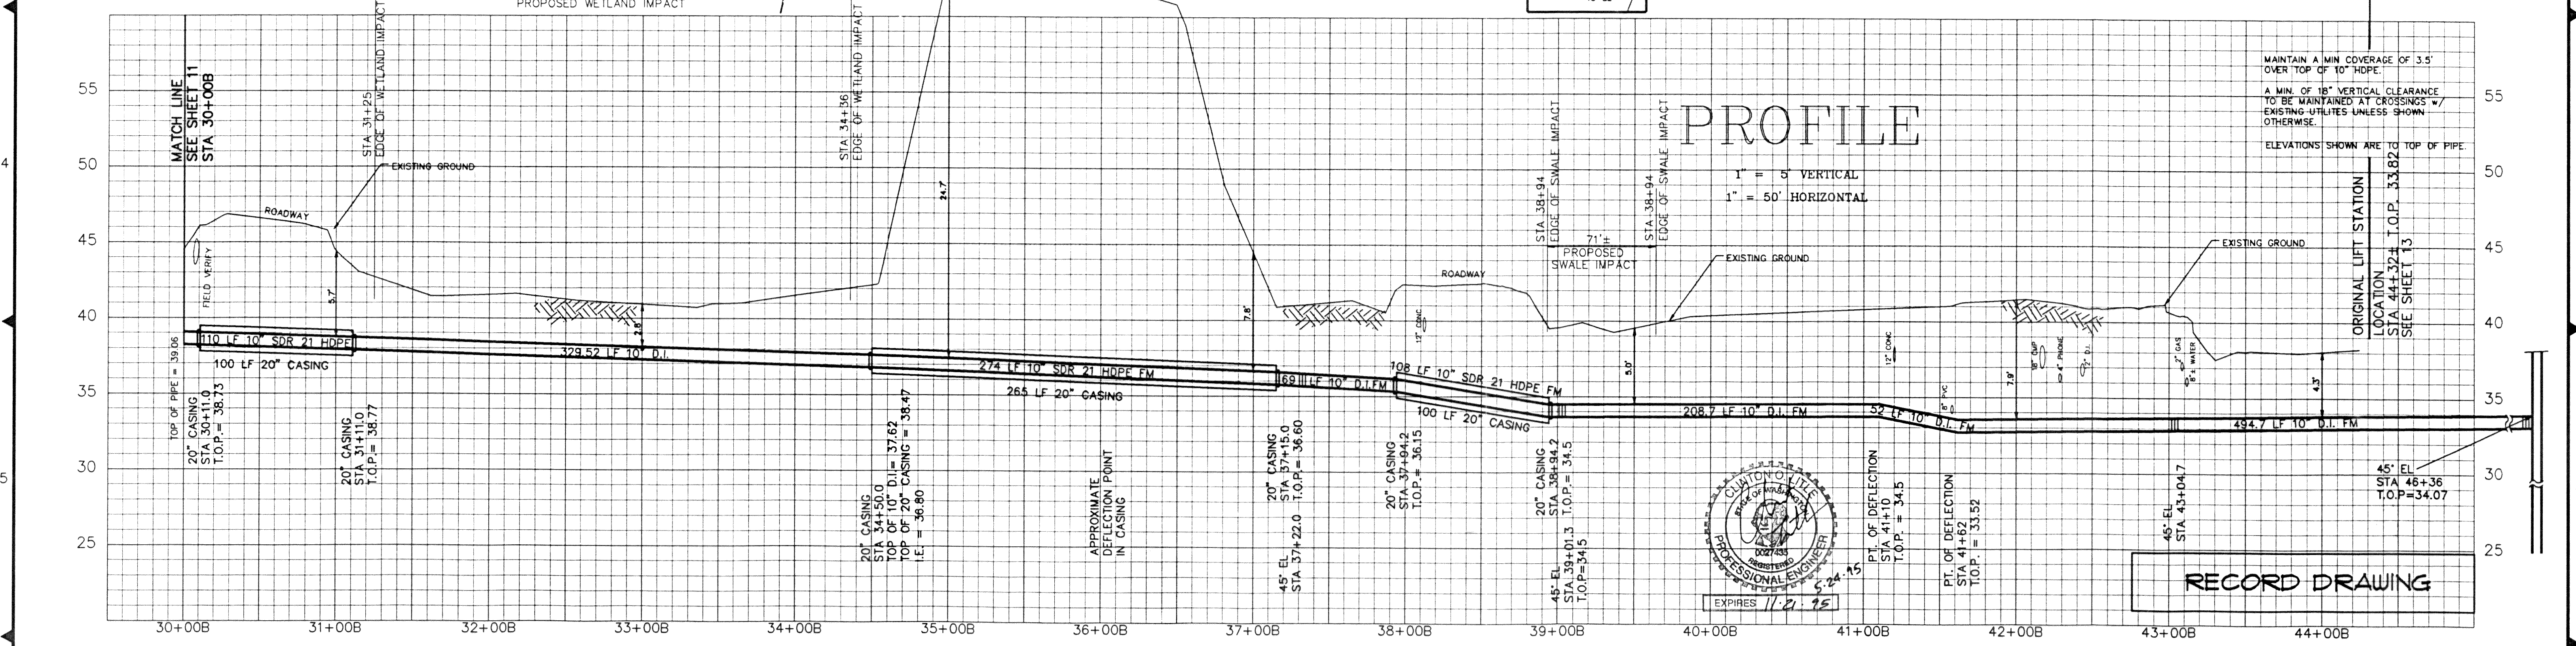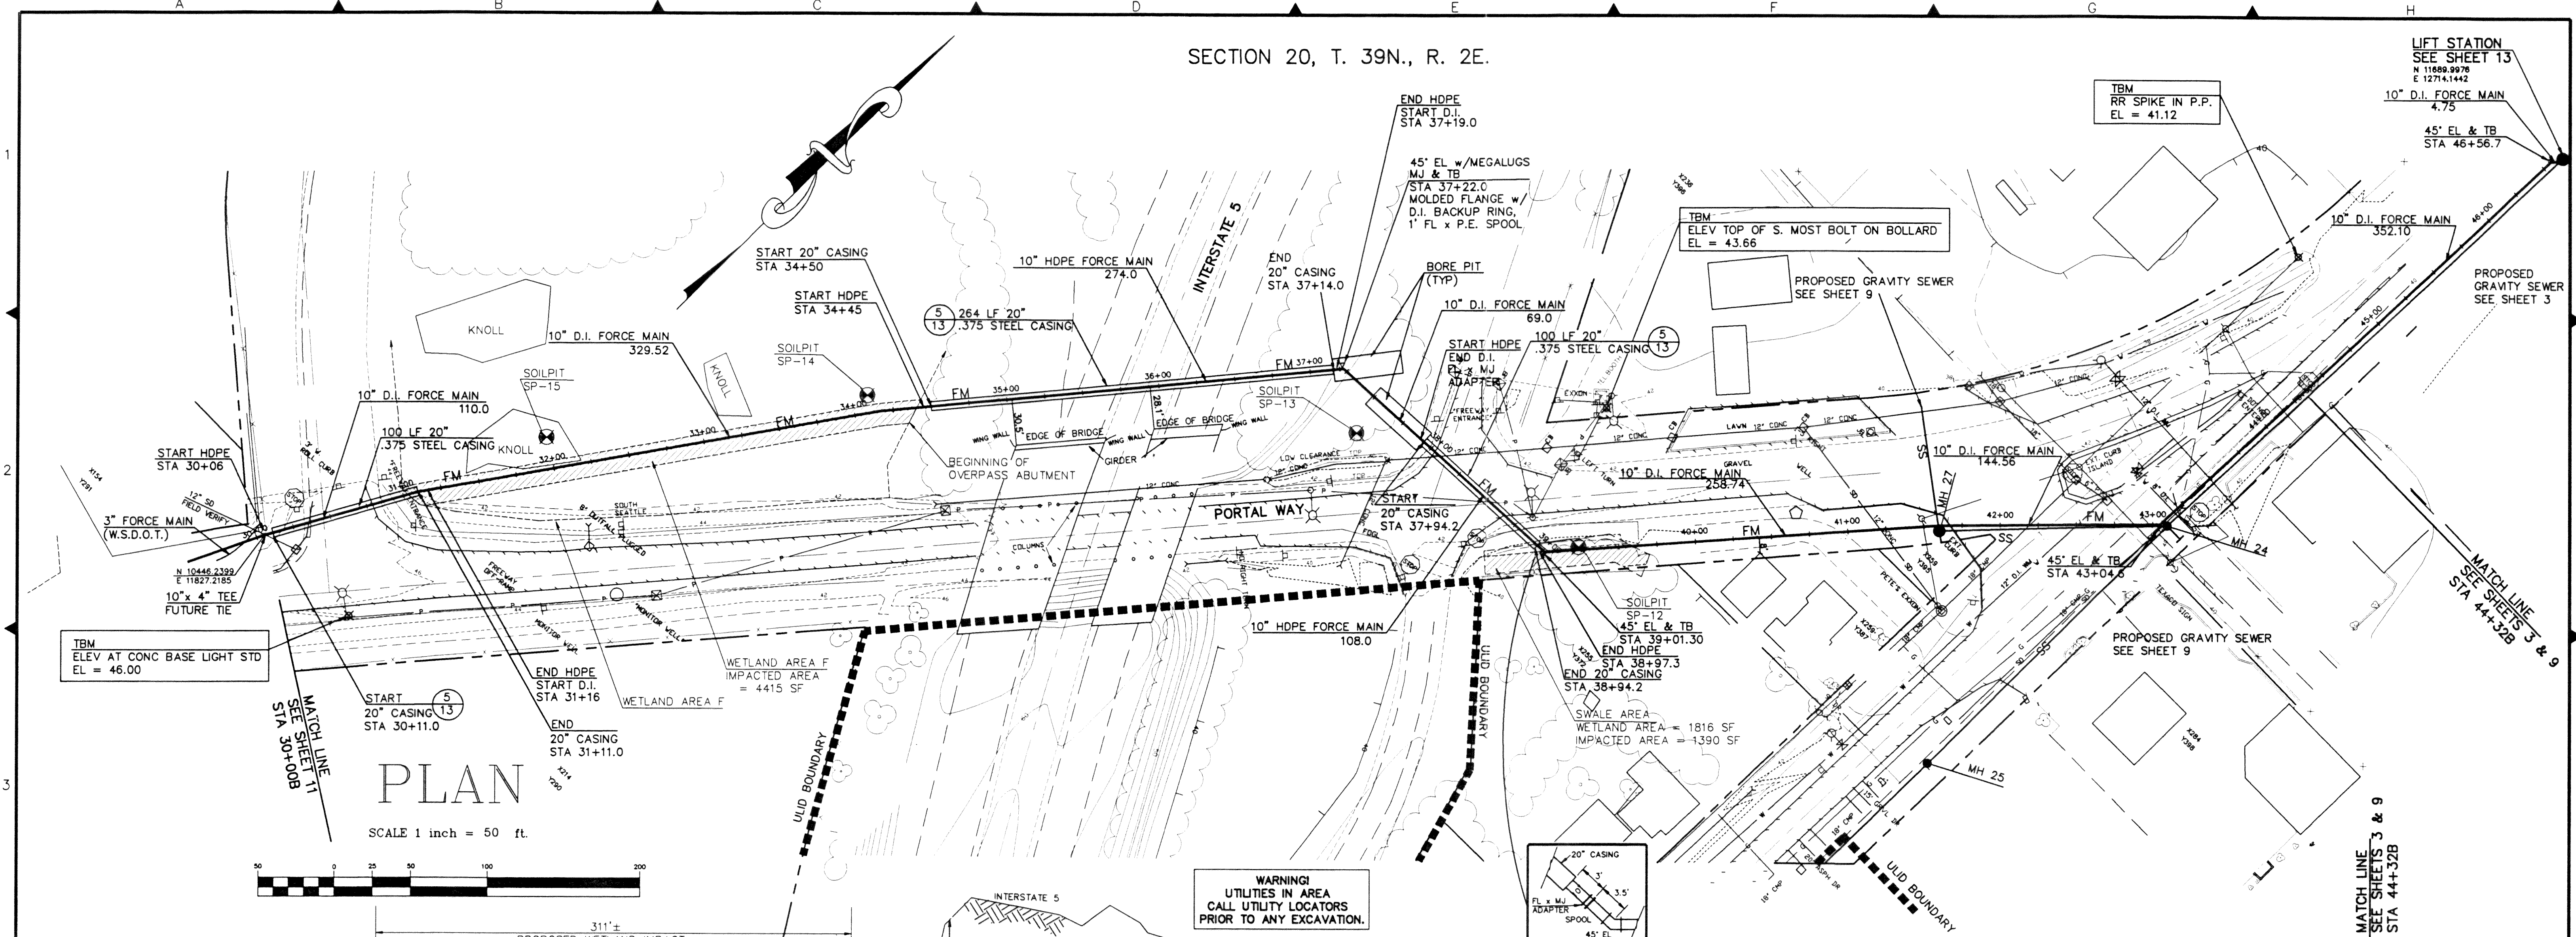

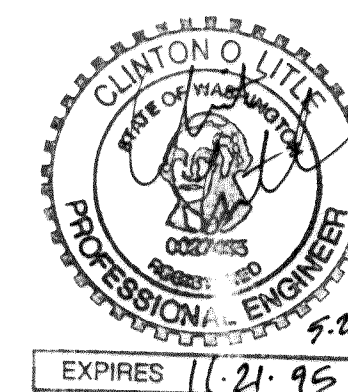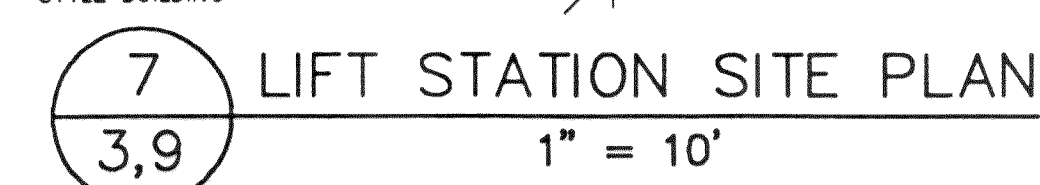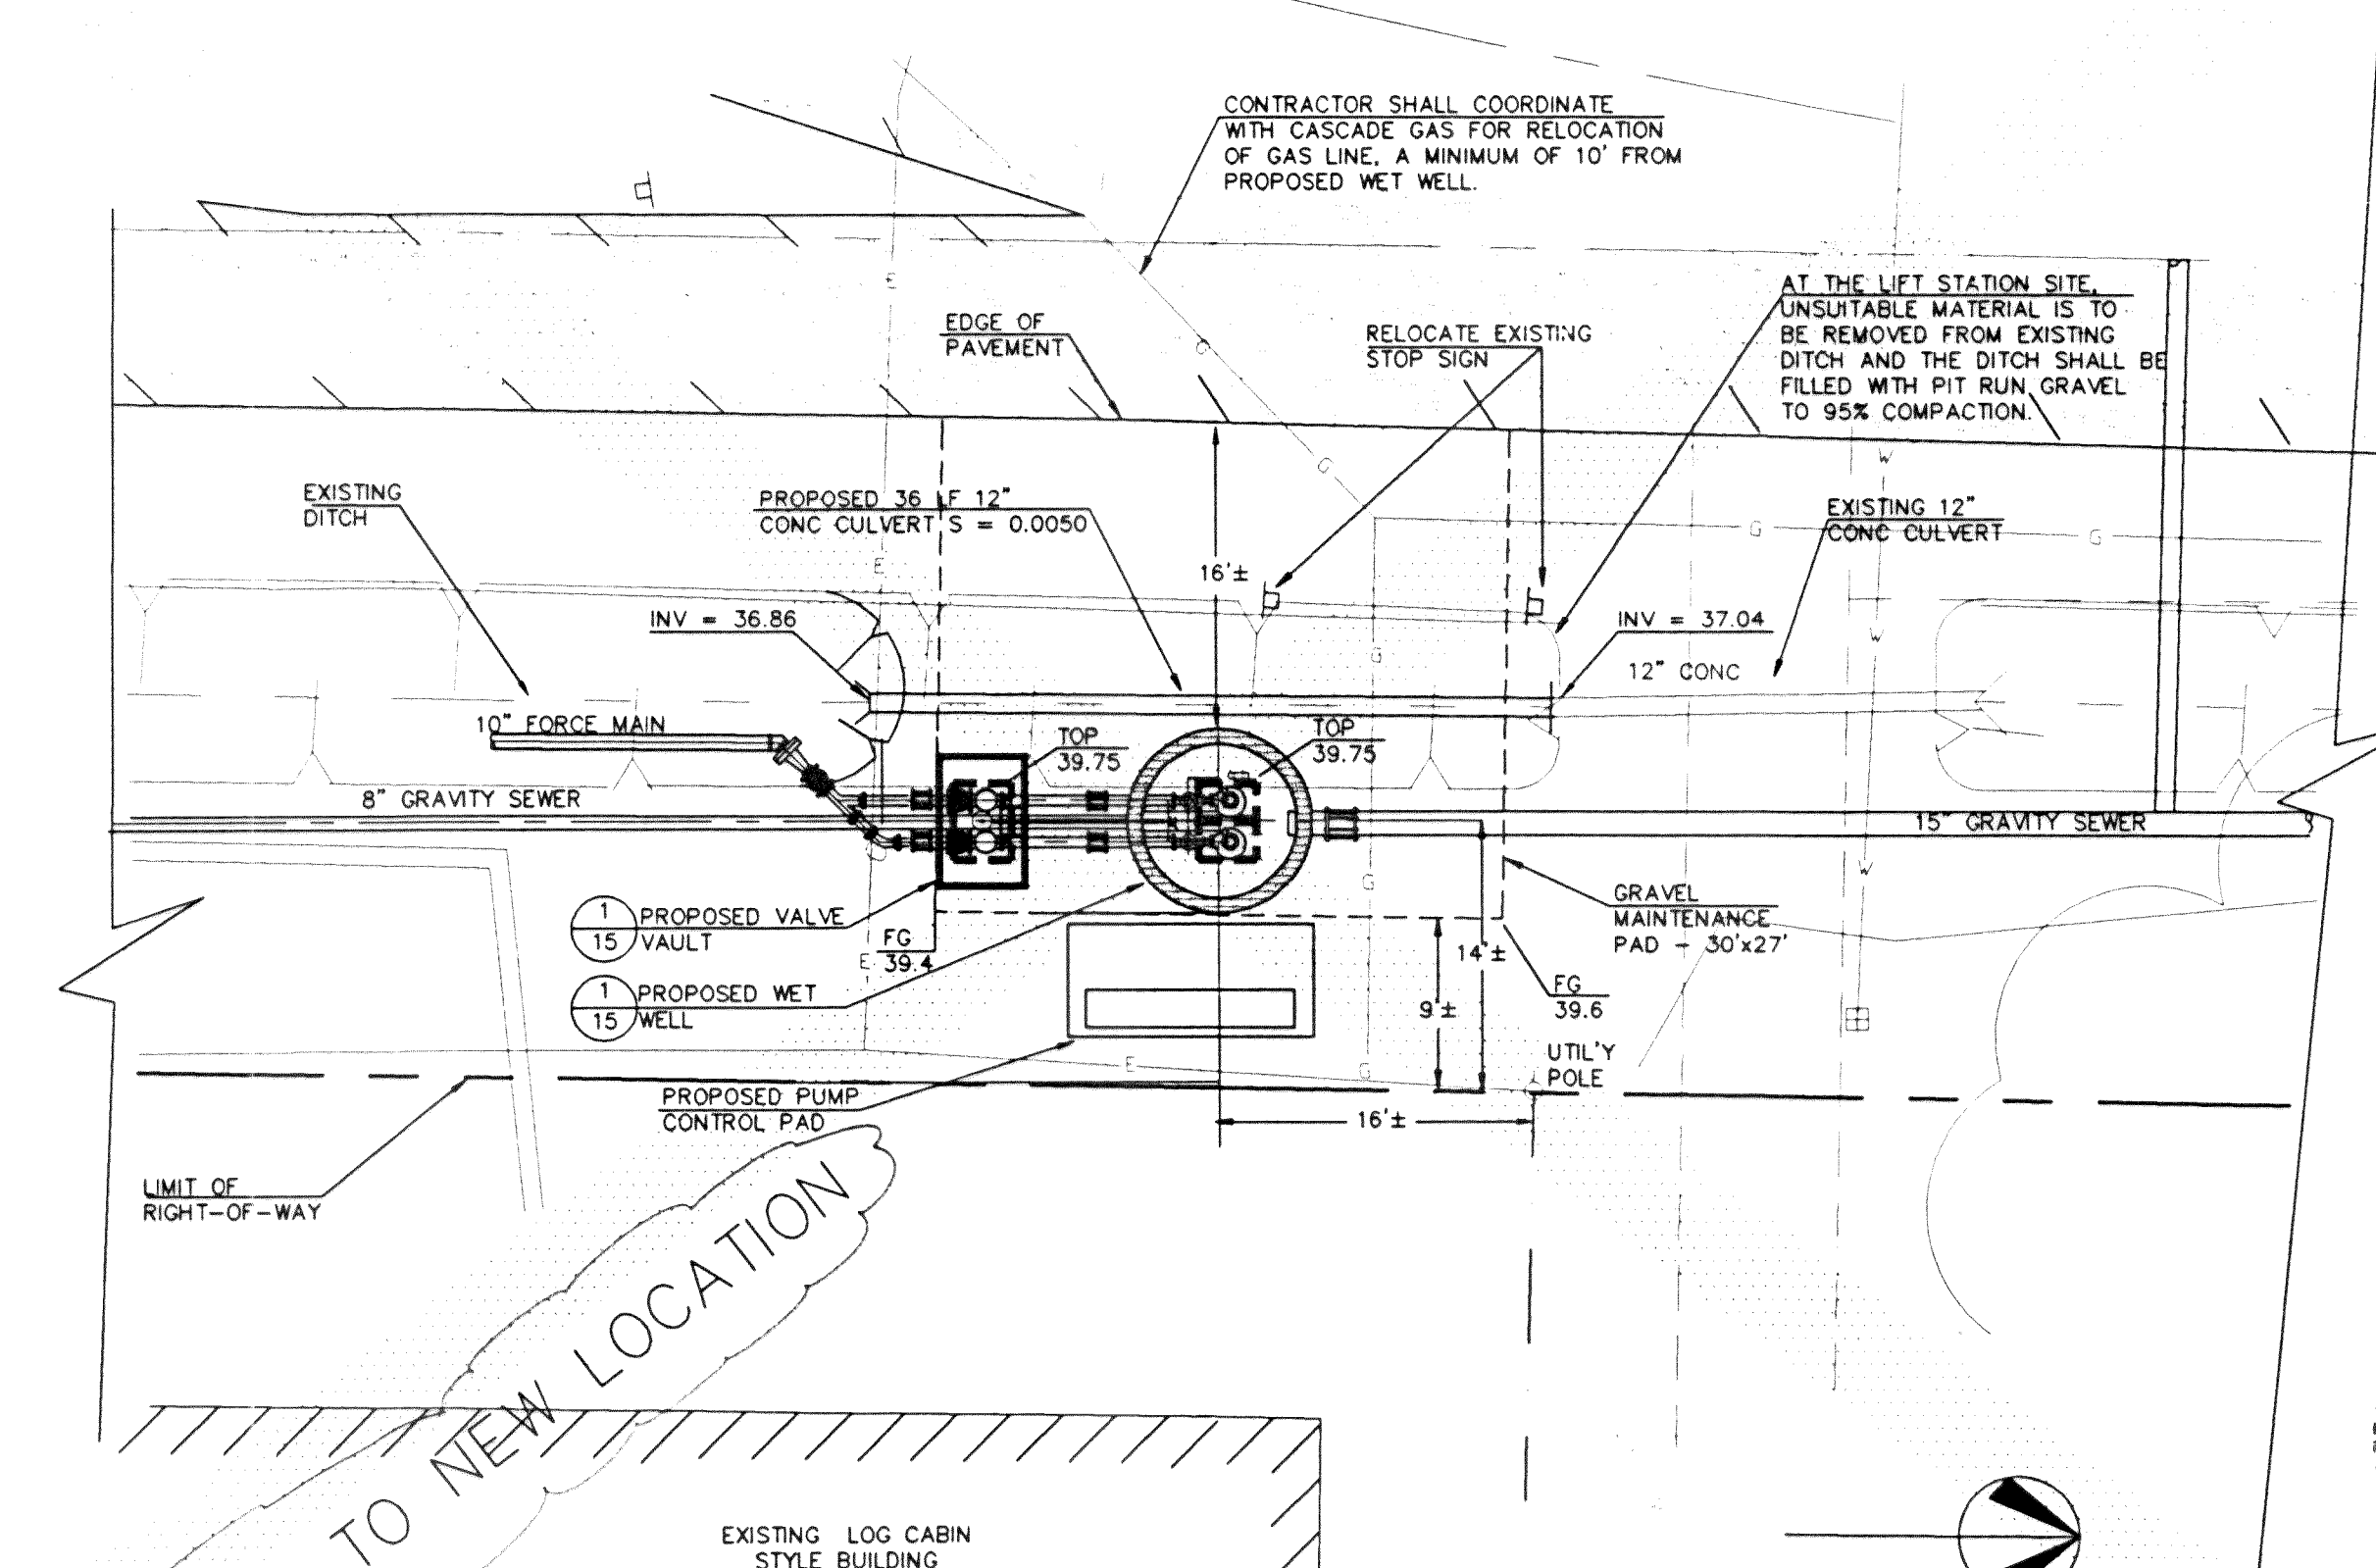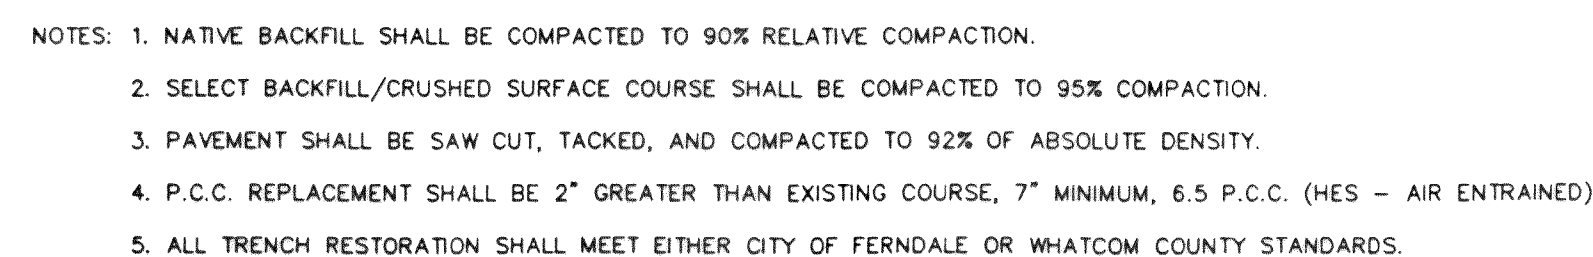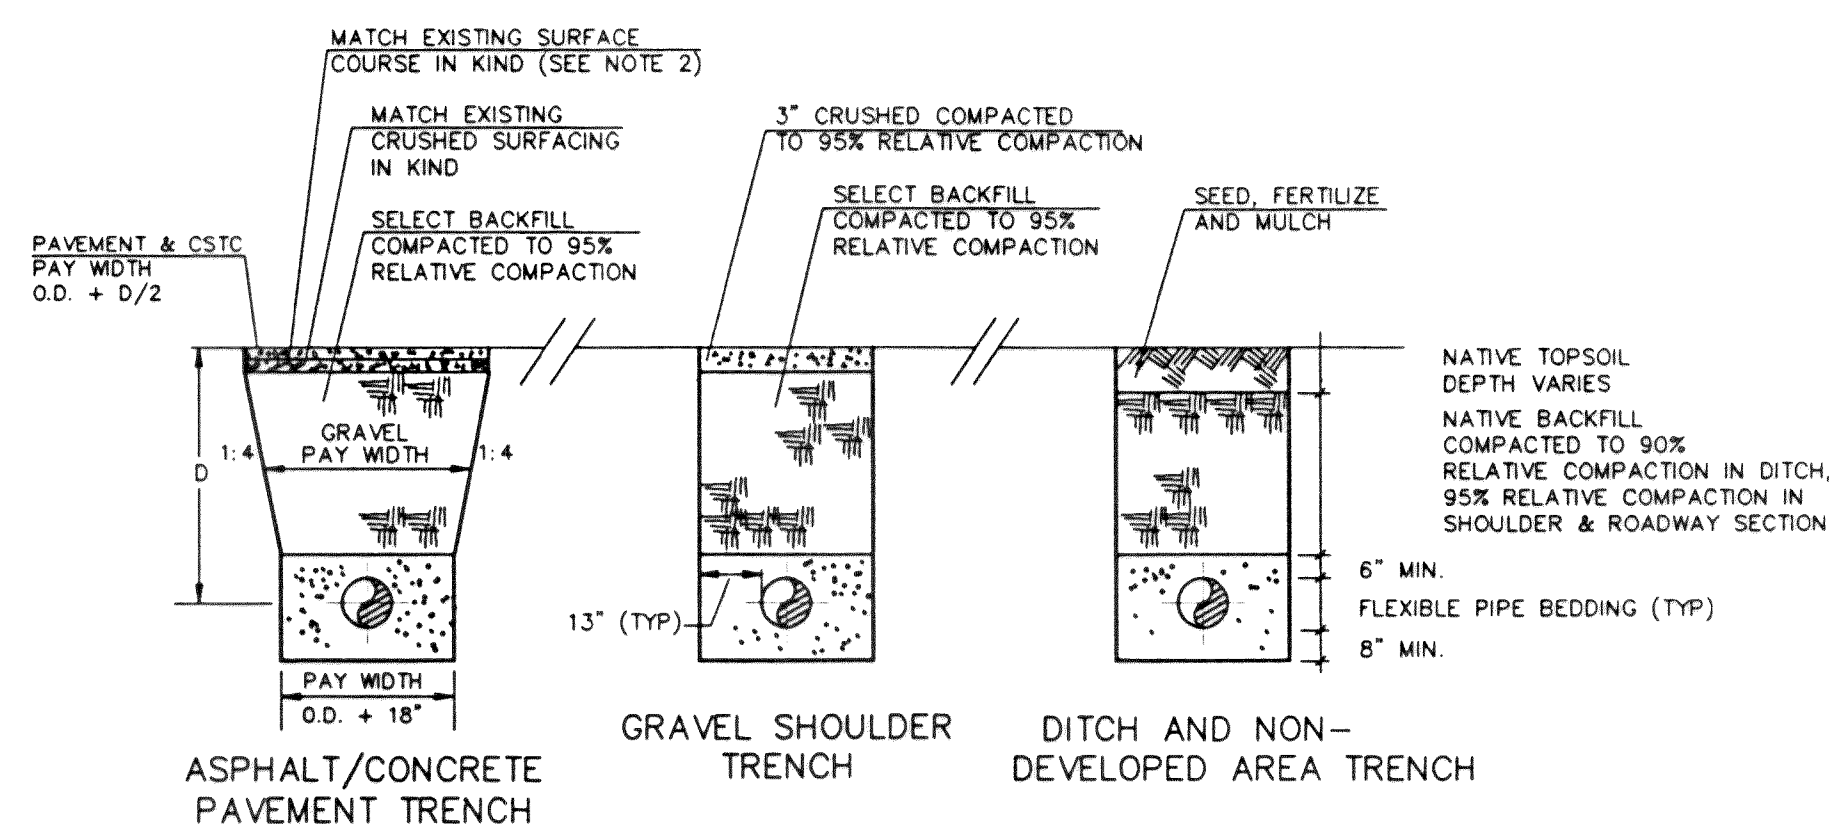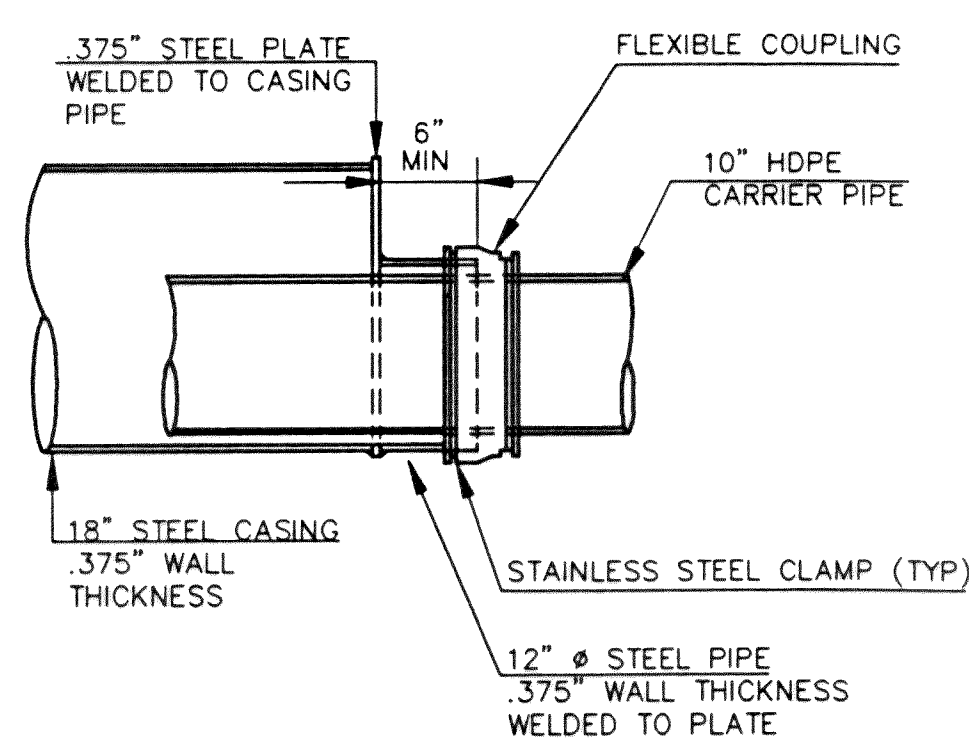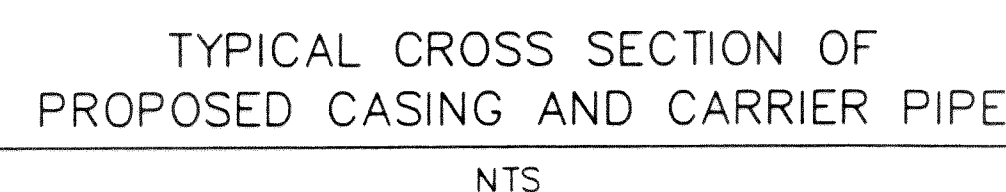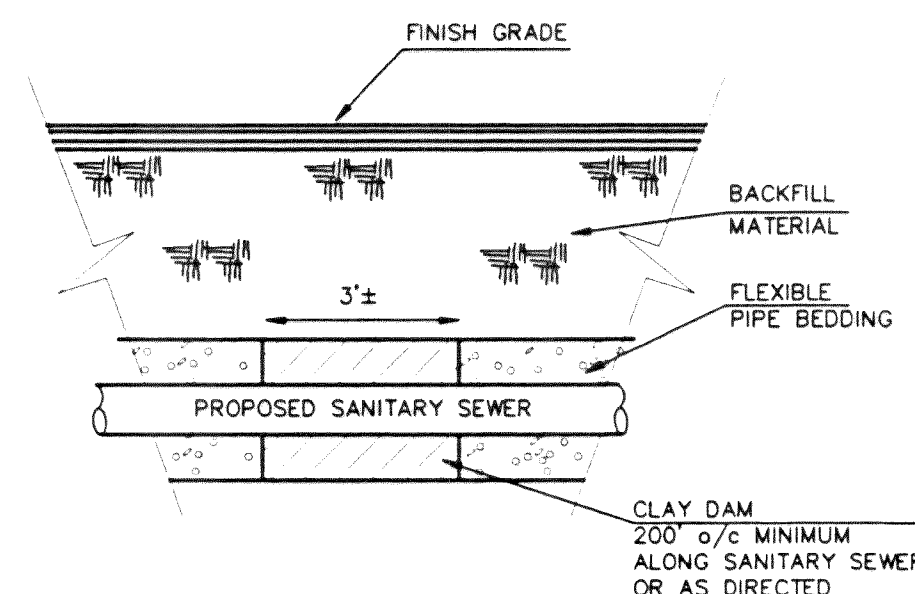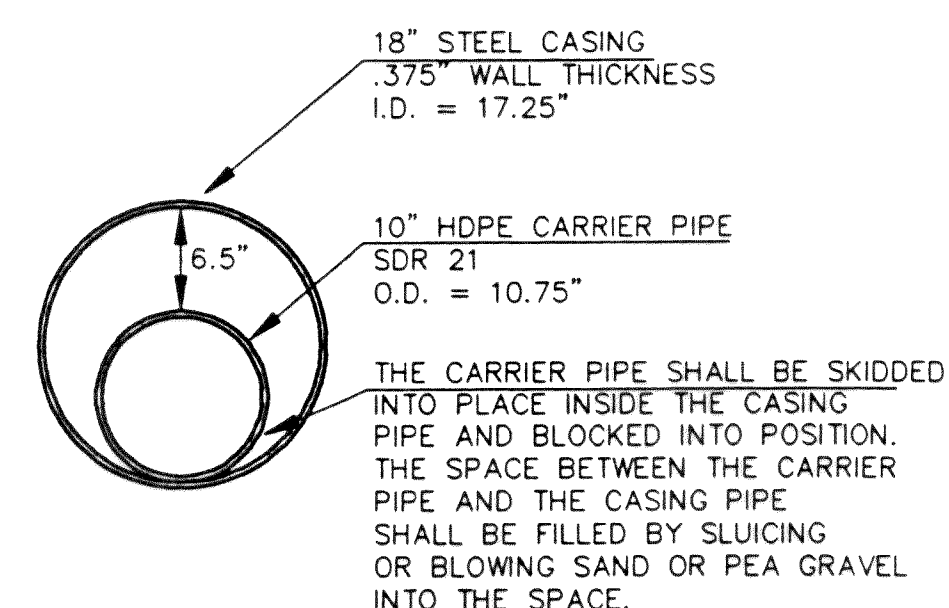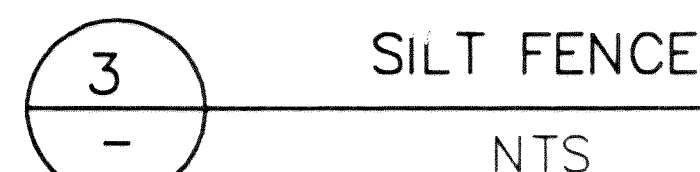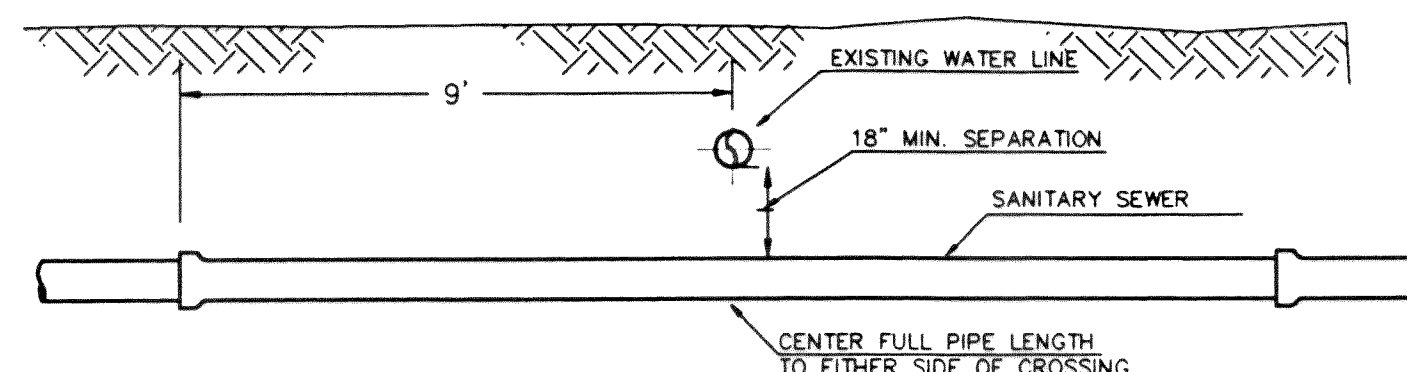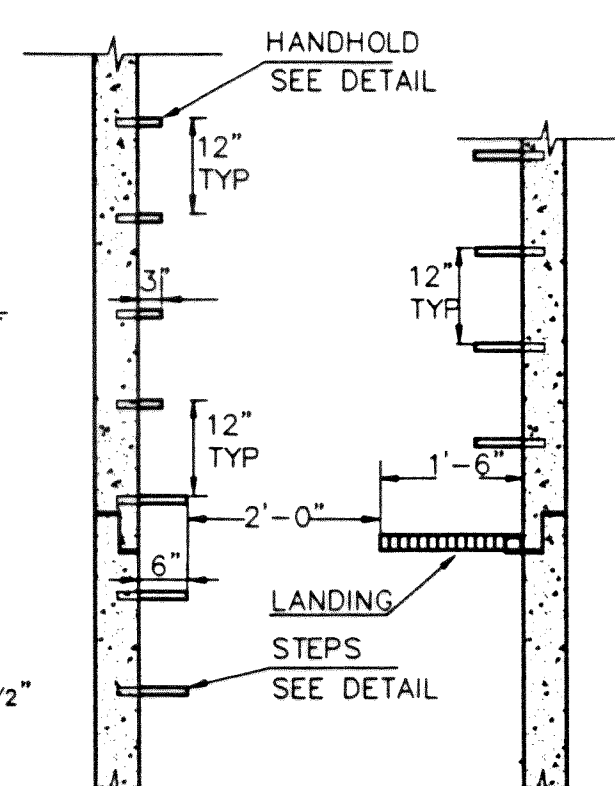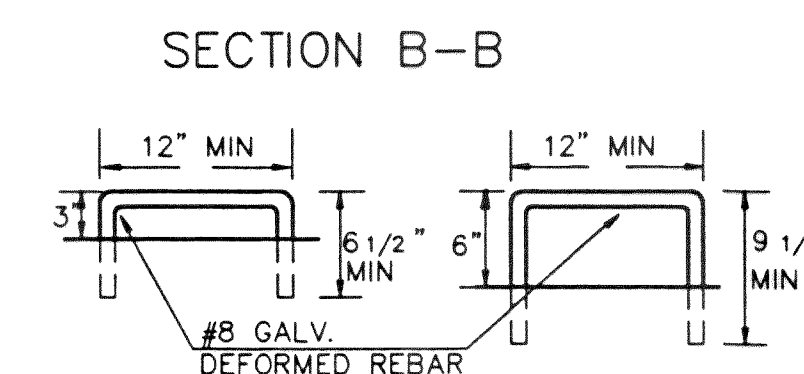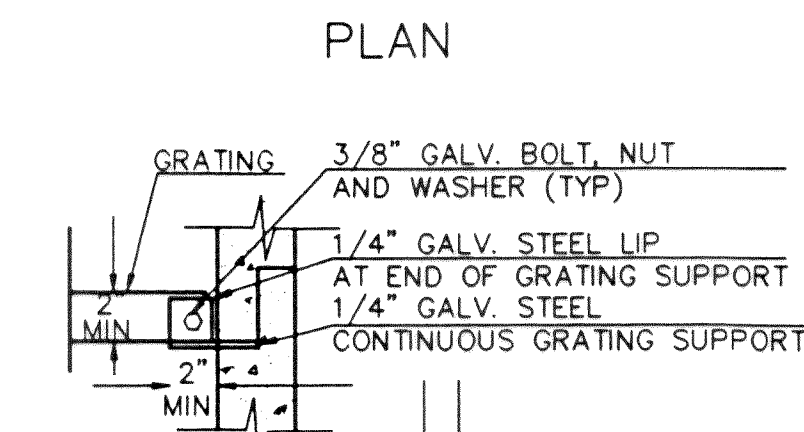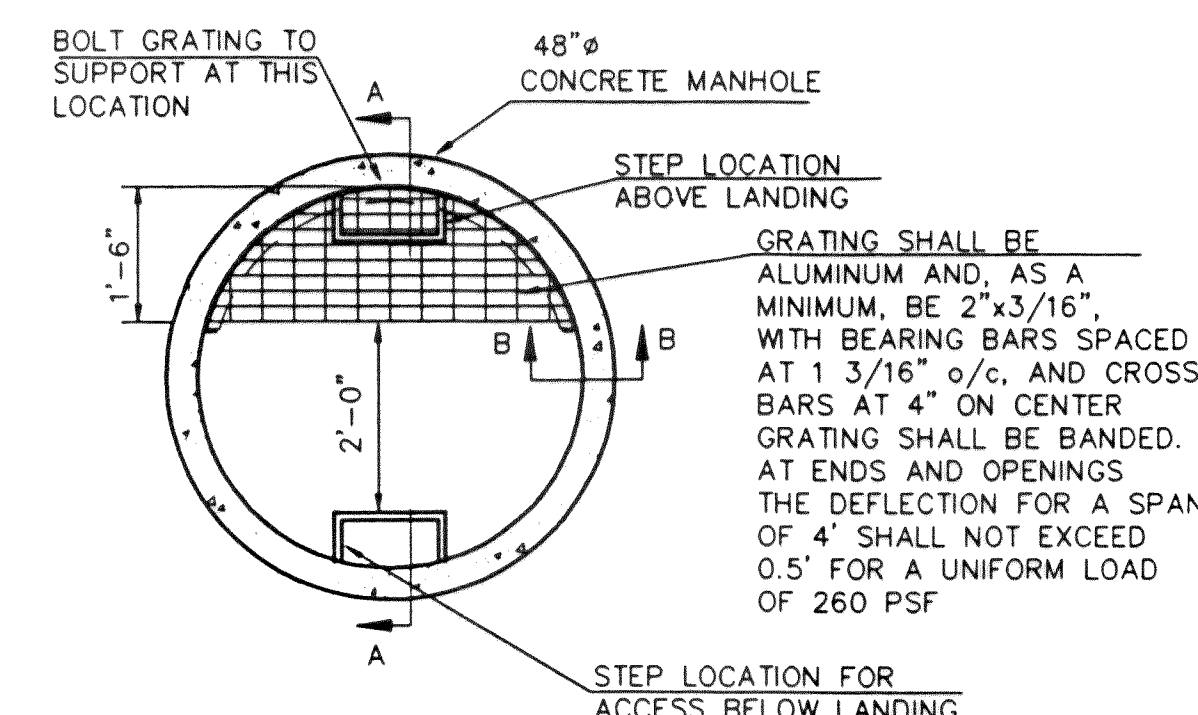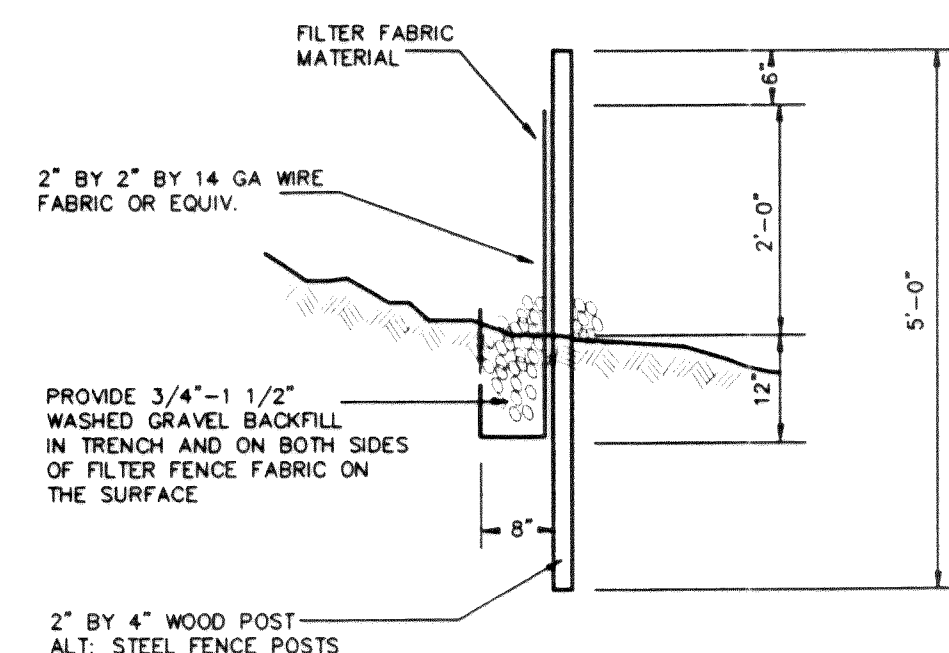

RECORD DRAWING

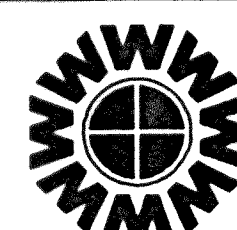

WEDEN ENGINEERING, INC.
119 GRAND AVENUE, SUITE D,
BELLINGHAM, WA. 98225 671-8200

ONE INCH AT FULL SCALE



IF NOT ONE INCH
SCALE ACCORDINGLY

DESIGNED BY _____


DRAWN BY _____

CHECKED BY _____


CITY OF FERNDALE U.L.I.D. NO. 7 SANITARY SEWER EXTENSION

DETAILS AND LIFT STATION SITE PLAN


C:\DWG\2096RD13		10/07/94	14:52
	DATE	SHEET	
	09/22/94	13	
	SCALE	OF	
	AS SHOWN	16	
	REC. NO.		
	92096		

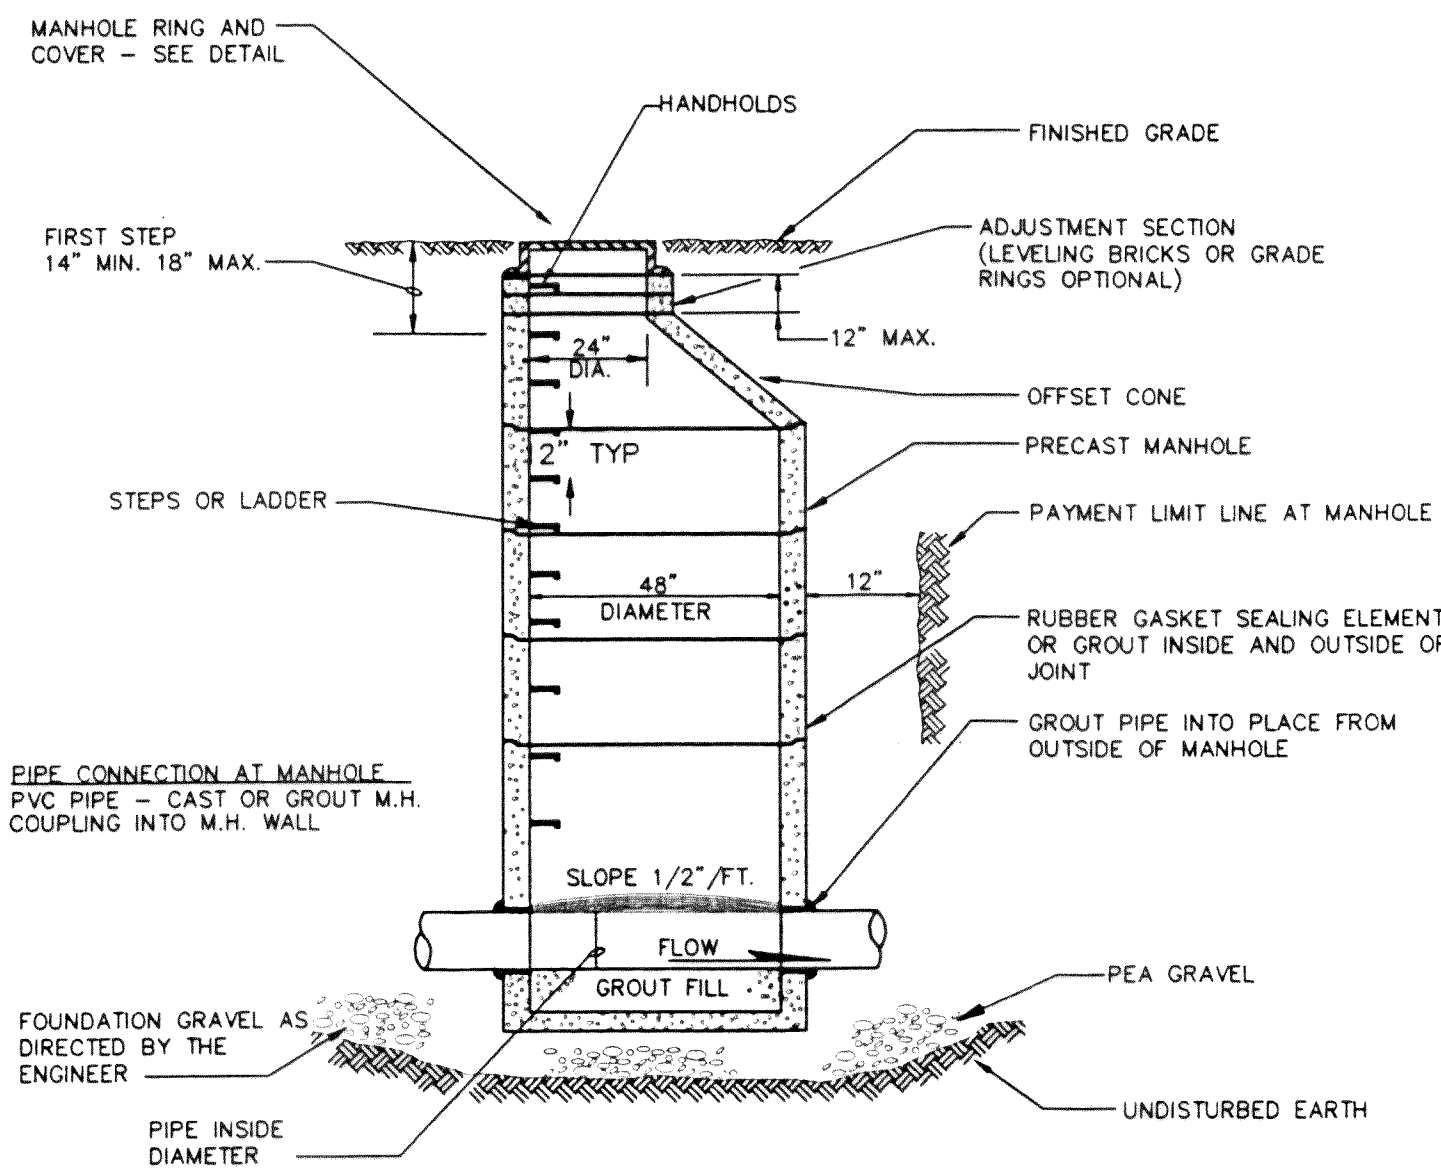


1 PRECAST MANHOLE - TYPE I
NTS

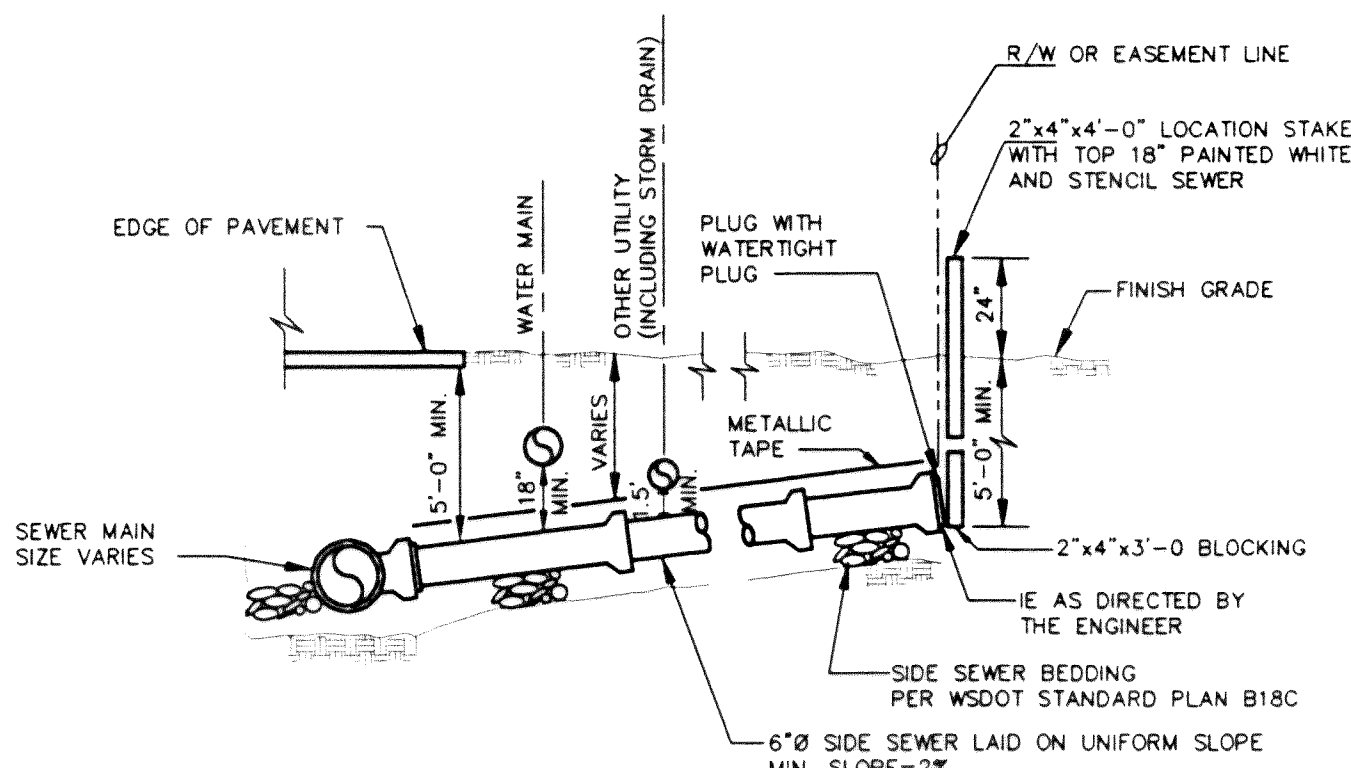


3 SIDE SERVICES SHALLOW INSTALLATION
15" AND SMALLER MAINS
NTS

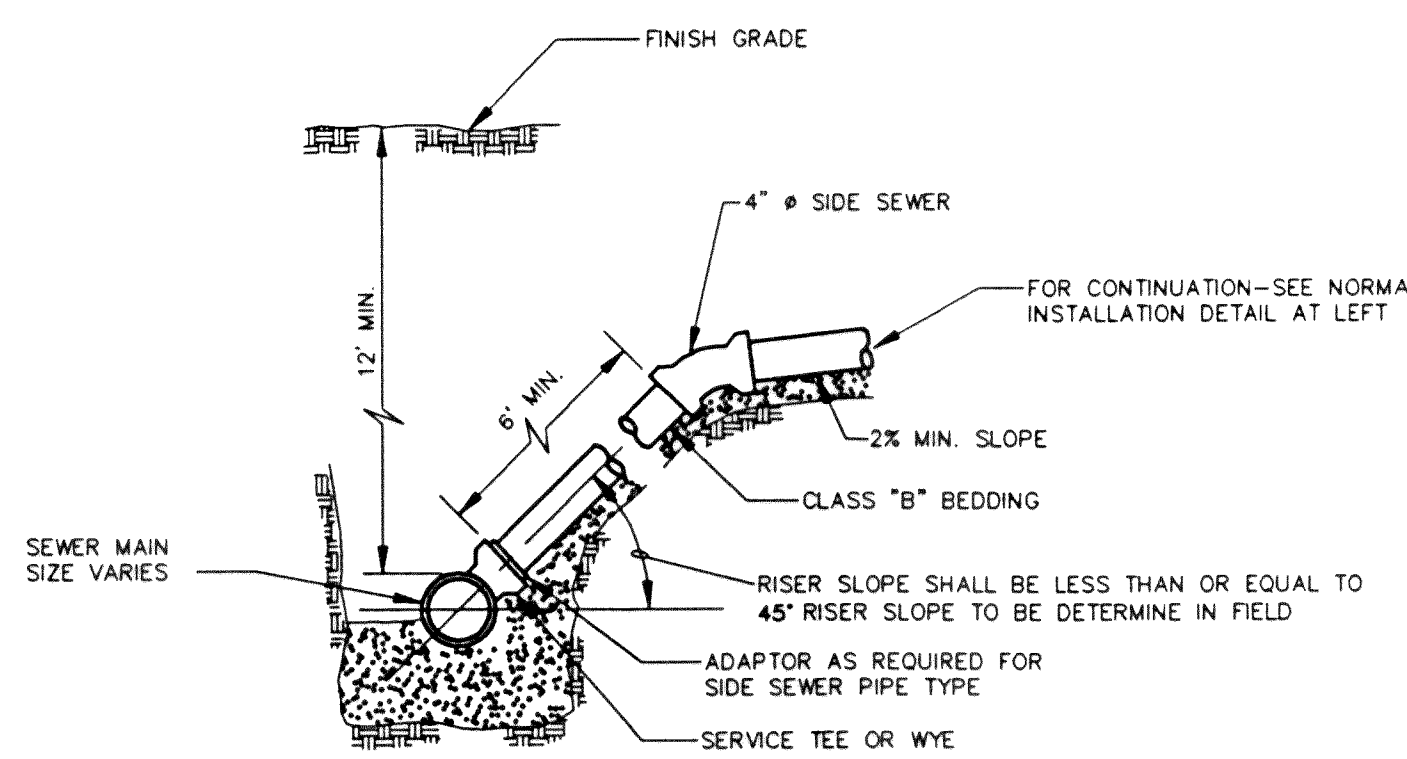

5 SIDE SERVICES DEEP INSTALLATION
NTS

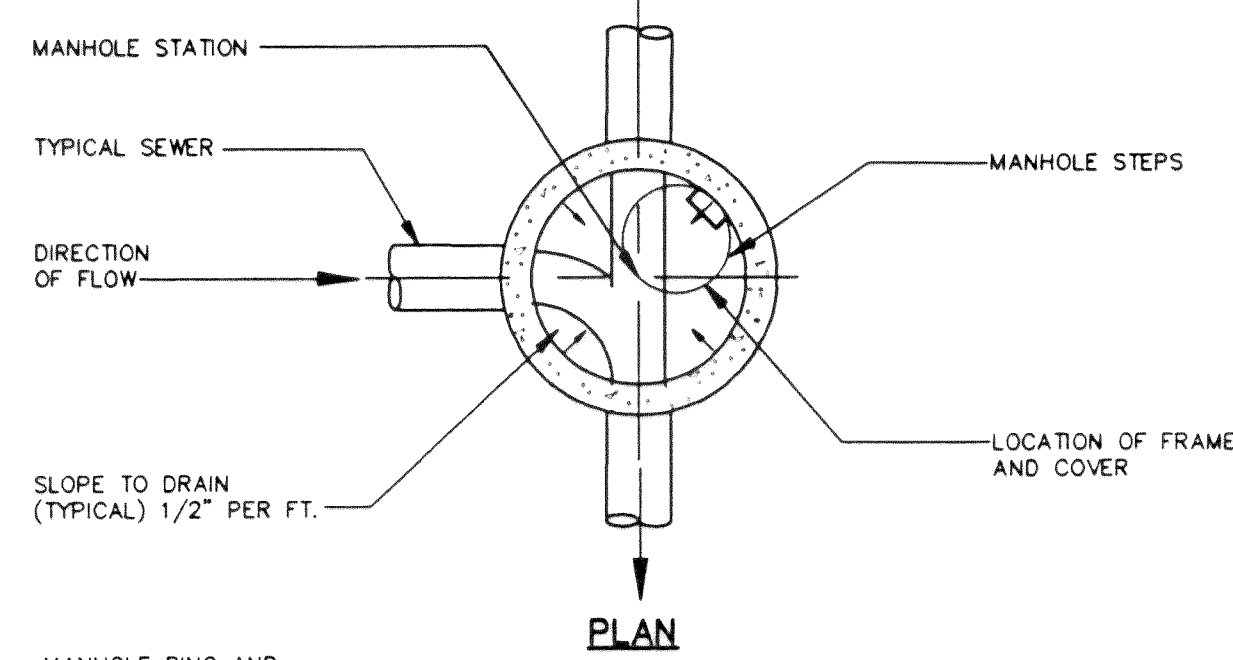


2 PRECAST MANHOLE - TYPE III
NOT TO SCALE

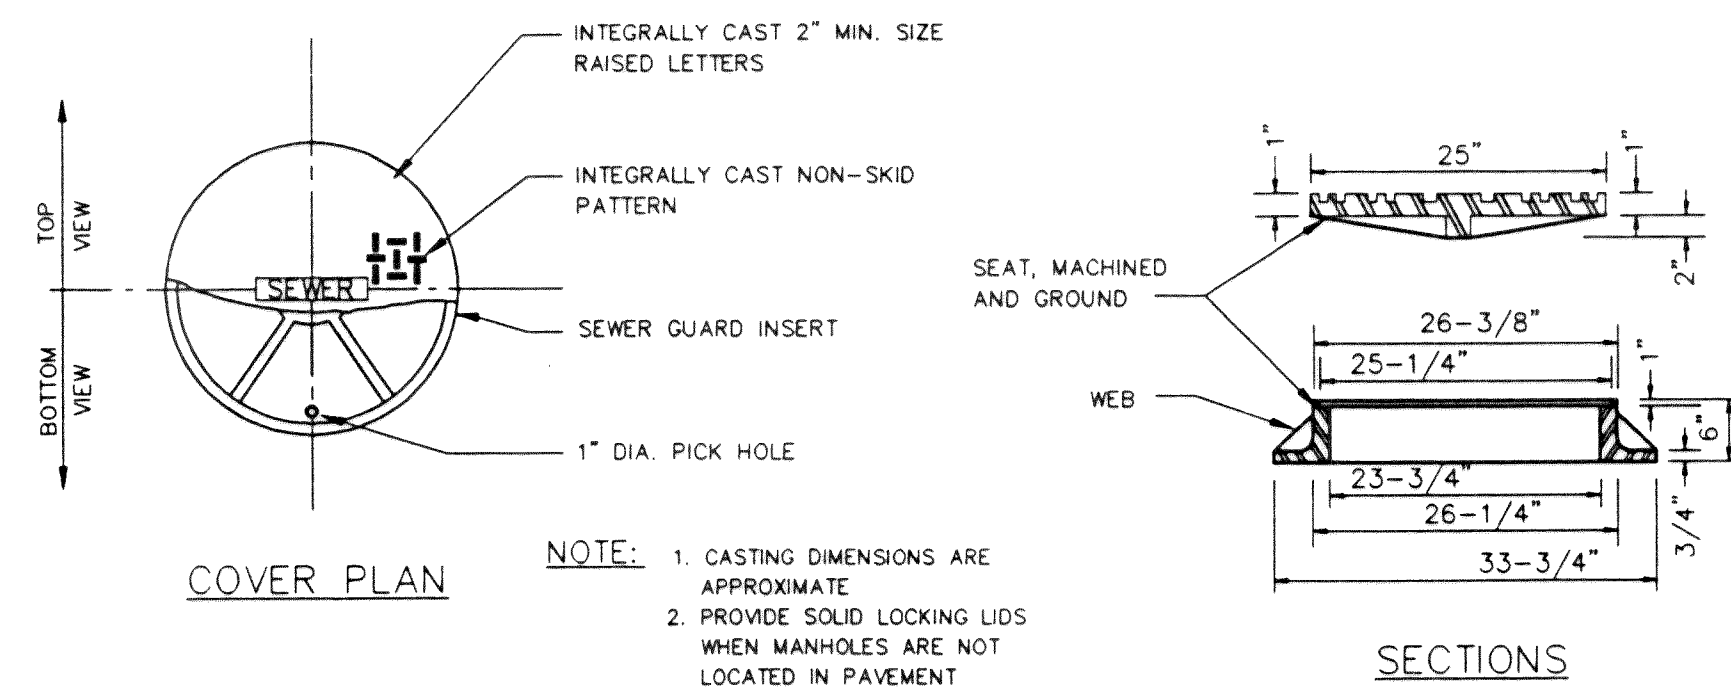


4 MANHOLE FRAME AND COVER
NTS

2" SQUARE CONCRETE BLOCK TO ENCASE CLEAN-OUT. IN AREAS WHERE CLEAN-OUT OCCURS IN ASPHALT, THIS BLOCK IS TO BE LEFT APPROX. 1 1/2" LOW TO ALLOW FOR AN ASPHALT TOPPING OF LIKE MIXTURE AS THE SURROUNDING AREA. IF CLEAN-OUT OCCURS IN CONCRETE OR IN SOME TYPE OF SOIL, THE BLOCK IS TO BE MADE THE FULL 1' DEPTH AND FLUSH WITH THE SURROUNDING SURFACE.

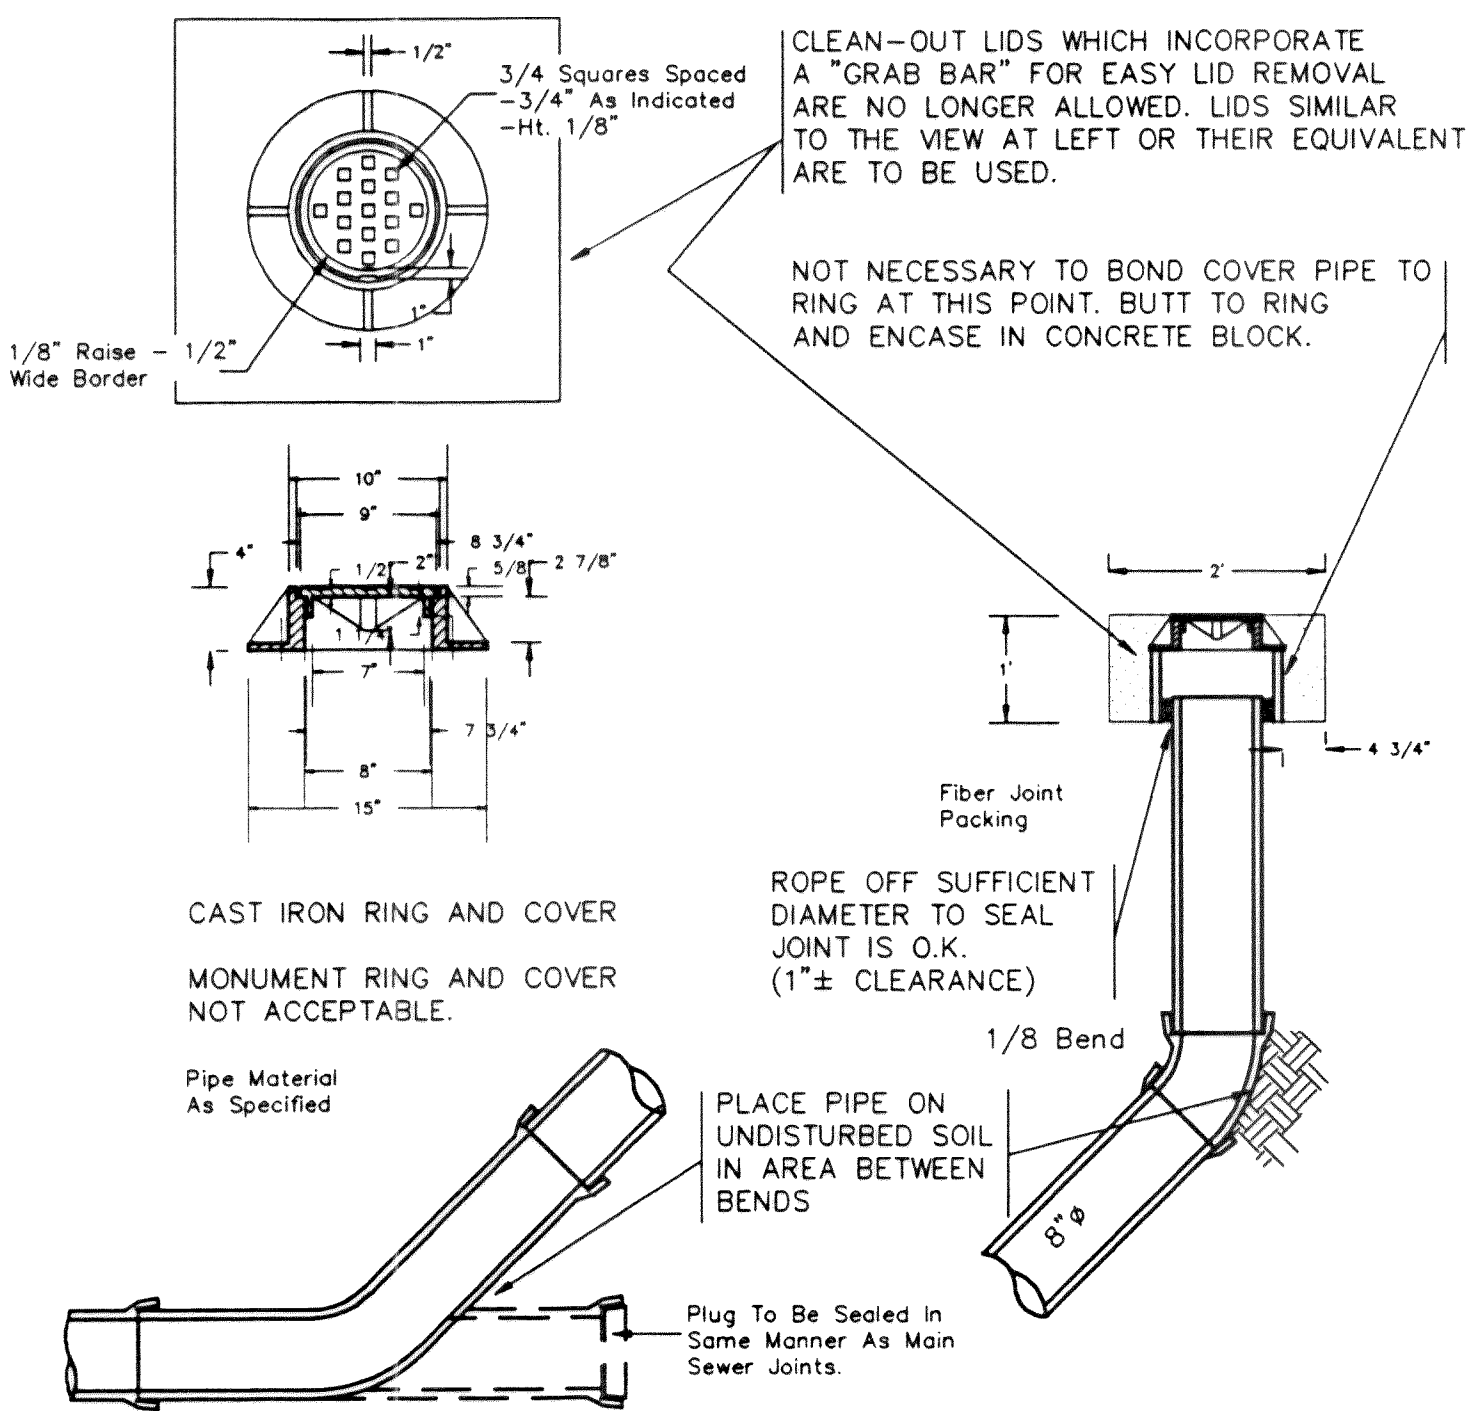

6 SANITARY SEWER CLEANOUT
NOT TO SCALE

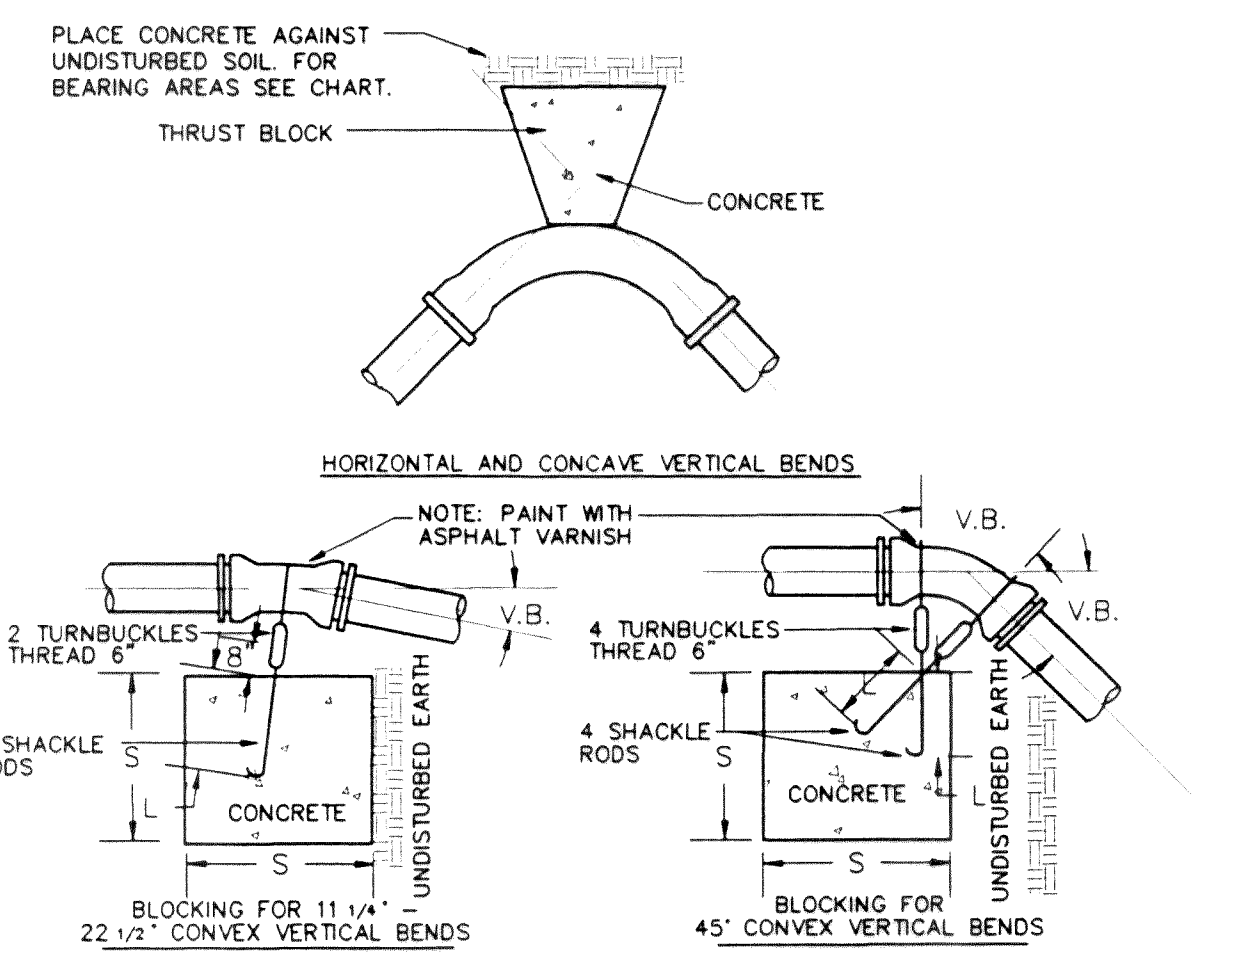

7 THRUST BLOCK DETAILS - FORCE MAIN
NTS


HORIZONTAL AND CONCAVE VERTICAL THRUST BLOCKS

THRUST BLOCK BEARING AREA	90°	45°	22 1/2°	11 1/4°
10"	9.0	5.1	2.7	2.7


CONVEX VERTICAL THRUST BLOCKS

PIPE SIZE INCHES	VERTICAL BEND DEGREES V.B. =	VOLUME OF BLOCKING CU. FT. - S -	SIDE OF CUBE FEET - S -	SHACKLE ROD DIAMETER - V.B. -	DEPTH OF ROD IN CONC. FEET - L -
10"	11 1/4	32	3.2	5/8	2.0
	22 1/2	88	4.5	7/8	3.0
	45	232	6.1	7/8	3.0


BASED ON TEST PRESSURE OF 50 PSI AND SOIL BEARING PRESSURE OF 1000 PSF

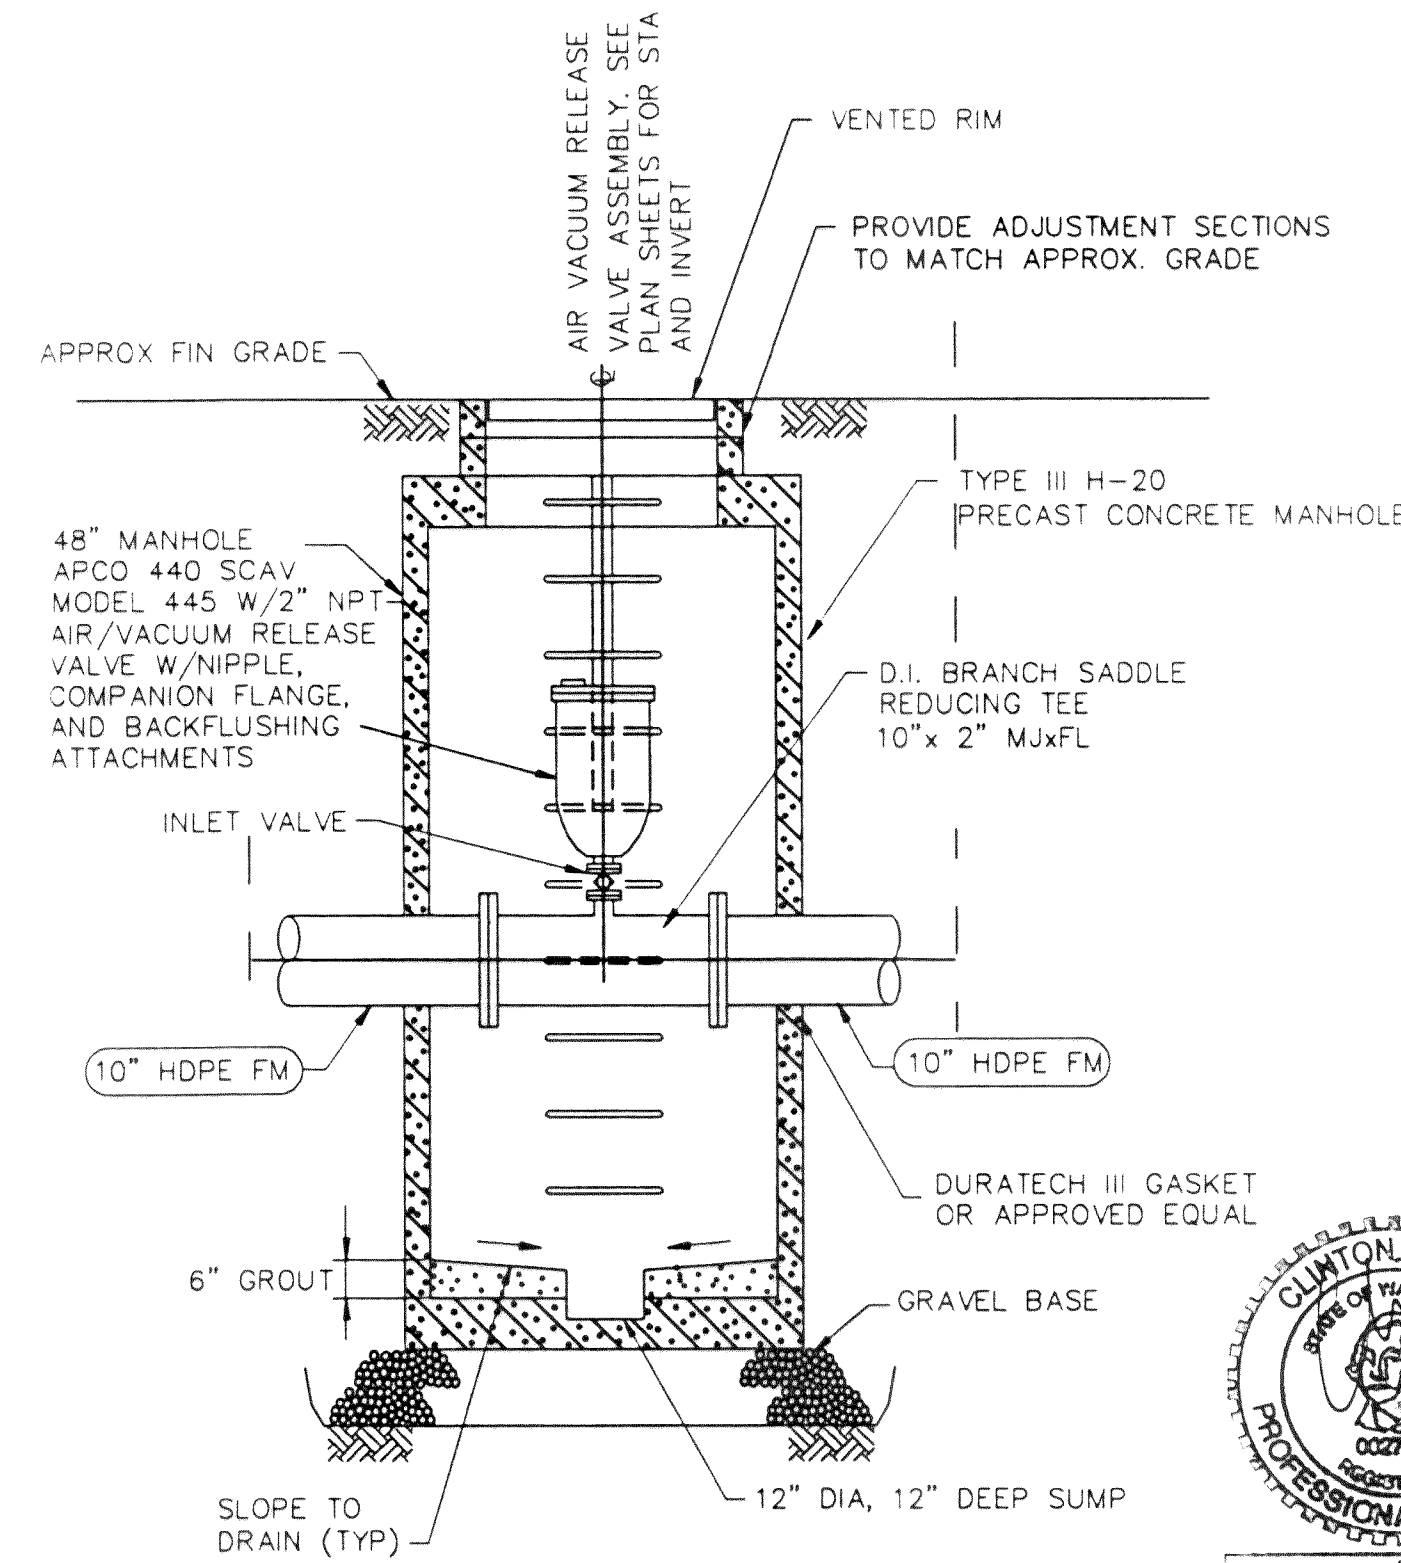

9 AIR RELEASE VALVE ASSEMBLY
NTS

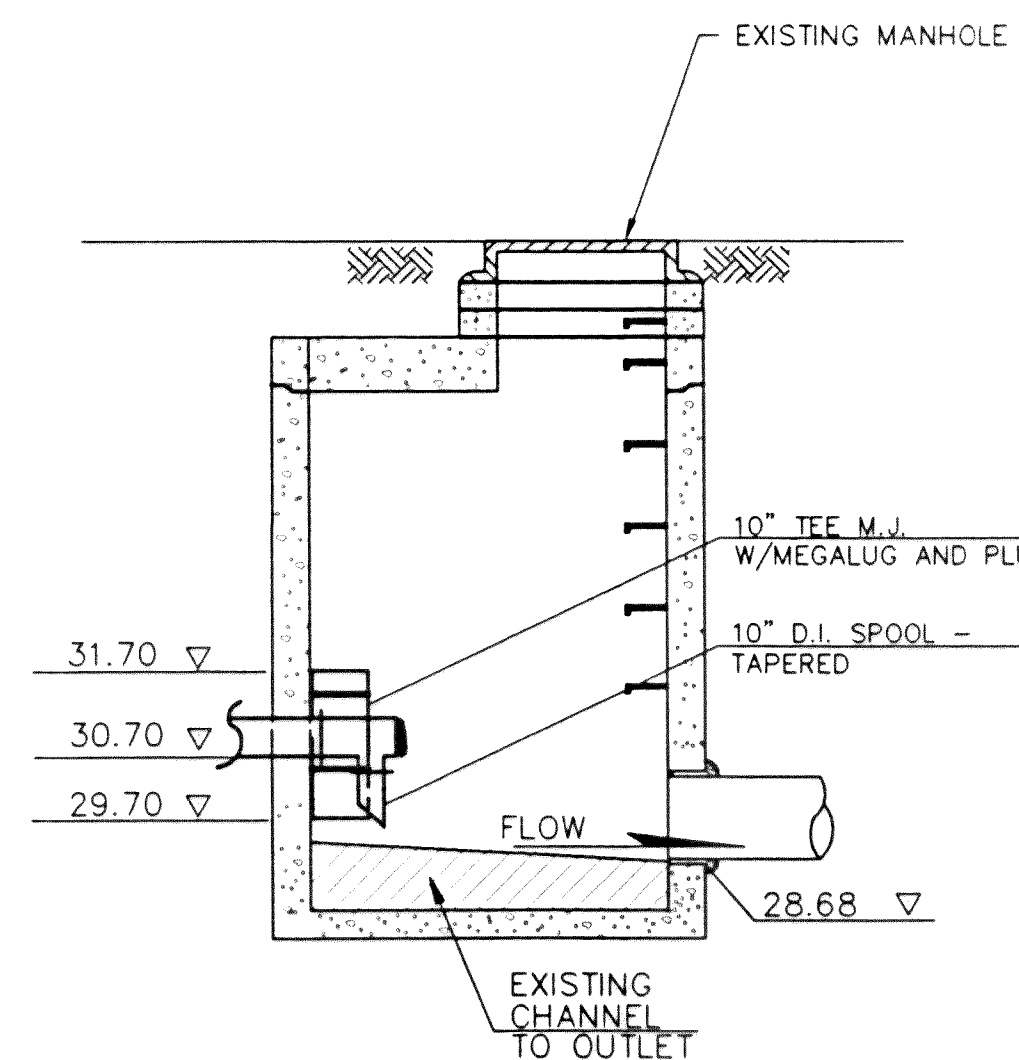


8 FORCE MAIN DISCHARGE
NTS

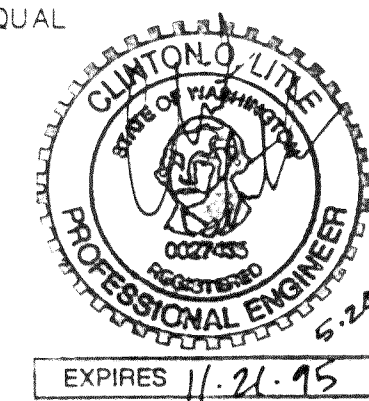

RECORD DRAWING

C:\DWG\2096RD14 10/07/94 15:17

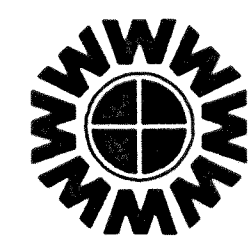

WEDEN ENGINEERING, INC.
119 GRAND AVENUE, SUITE D,
BELLINGHAM, WA. 98225 671-8200

ONE INCH AT FULL SCALE
IF NOT ONE INCH SCALE ACCORDINGLY


DESIGNED BY
DRAWN BY
CHECKED BY
JLW

**CITY OF FERNDAL U.L.I.D. NO. 7
SANITARY SEWER EXTENSION**

DETAILS

DATE
09/22/94
SCALE
AS SHOWN
REC. NO.
92096
SHEET
14
OF
16

00105.014 2-7-06 KR

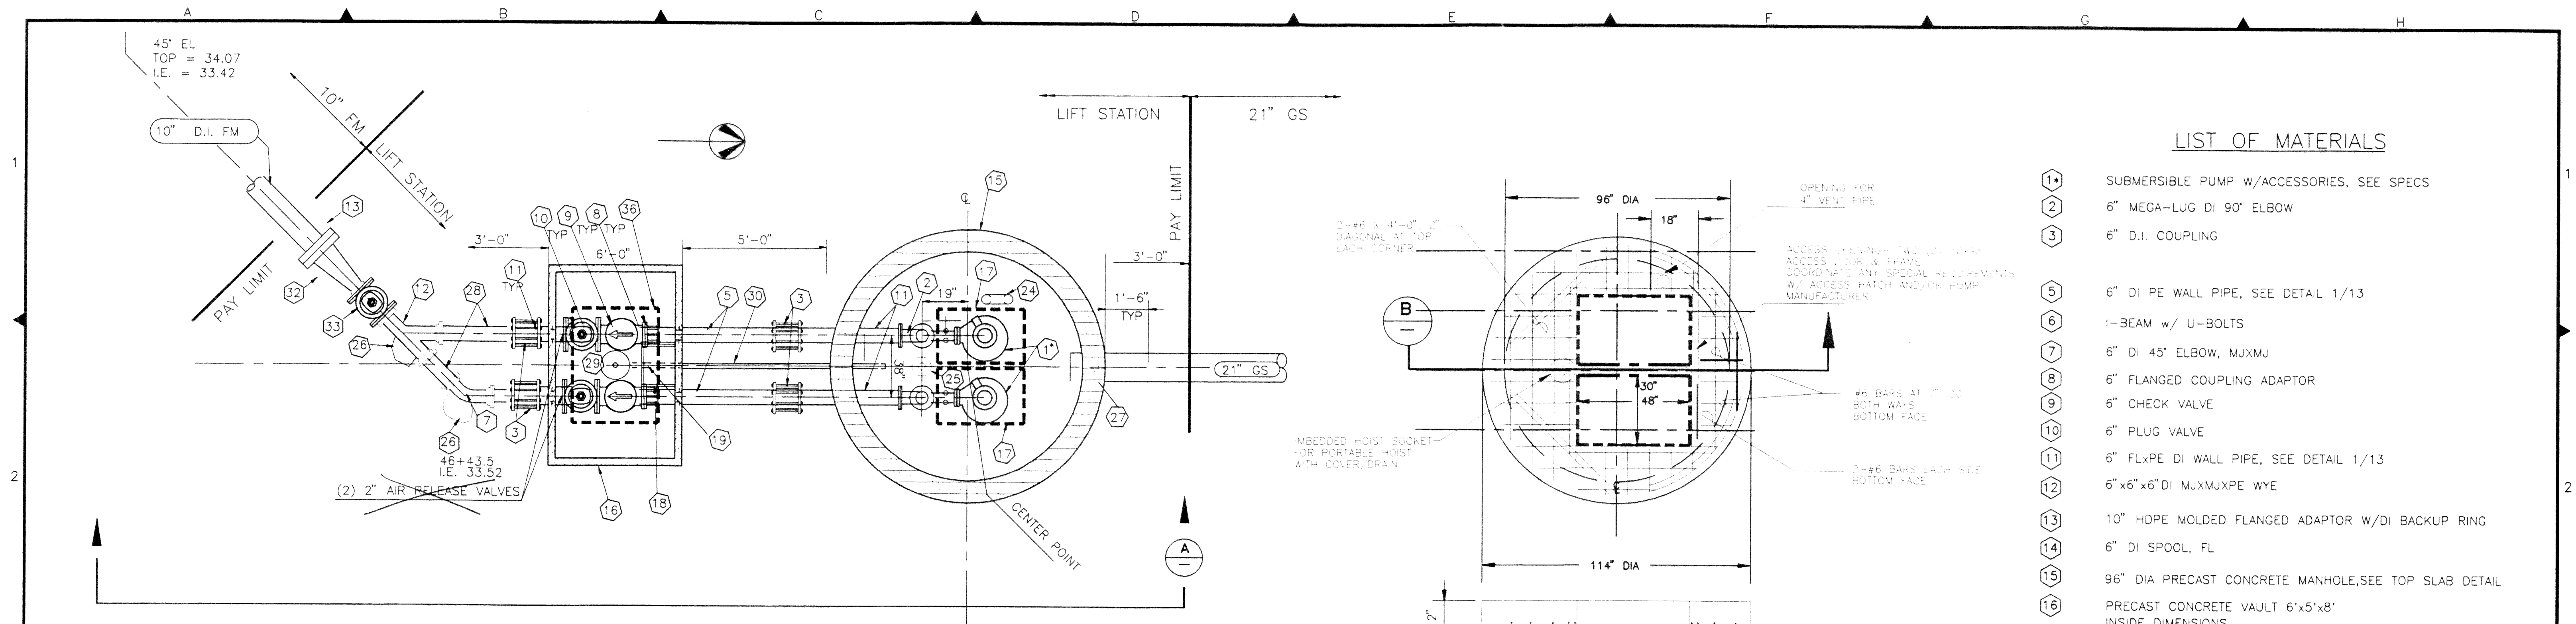


1 LIFT STATION PLAN
3/8" = 1'-0"

2 TOP SLAB SECTION
LIFT STATION TOP SLAB
3/8" = 1'-0"

- LIST OF MATERIALS**
- 1 SUBMERSIBLE PUMP W/ACCESSORIES, SEE SPECS
 - 2 6" MEGA-LUG DI 90° ELBOW
 - 3 6" D.I. COUPLING
 - 5 6" DI PE WALL PIPE, SEE DETAIL 1/13
 - 6 I-BEAM w/ U-BOLTS
 - 7 6" DI 45° ELBOW, MJXMJ
 - 8 6" FLANGED COUPLING ADAPTOR
 - 9 6" CHECK VALVE
 - 10 6" PLUG VALVE
 - 11 6" FLXPE DI WALL PIPE, SEE DETAIL 1/13
 - 12 6"x6"x6" DI MJXMJXPE WYE
 - 13 10" HDPE MOLDED FLANGED ADAPTOR W/DI BACKUP RING
 - 14 6" DI SPOOL, FL
 - 15 96" DIA PRECAST CONCRETE MANHOLE,SEE TOP SLAB DETAIL
 - 16 PRECAST CONCRETE VAULT 6'x5'x8' INSIDE DIMENSIONS
 - 17 ACCESS HATCH 30" X 48" CLEAR OPENING
 - 18 ACCESS LADDER, SEE DETAIL 3/13
 - 19 ELECTRICAL CONDUIT
 - 20 UPPER GUIDE BRACKET
 - 21 GUIDE BARS (2 PER PUMP) 2" DIA SS PIPE, SCH 40 w/ INTERMEDIATE SUPPORTS.
 - 22 PIPE SUPPORT, SEE DETAIL 5/13
 - 23 6" DI DISCHARGE ELBOW
 - 24 4" S.S. VENT PIPE W/WIRE MESH
 - 25 IMBEDDED HOIST SOCKET
 - 26 THRUST BLOCK, SEE DETAIL 4/13
 - 27 14" PVC SPOOL
 - 28 6" DI SPOOL, PE
 - 29 SLUMP AND GRATE
 - 30 2" PVC AND P-TRAP
 - 31 GRAVEL BASE, SEE SPECS
 - 32 6X10 DI REDUCER MJXPE
 - 33 6" ECCENTRIC PLUG VALVE FOR THROTTLING FLOW
 - 34 8" PVC SPOOL
 - 35 8" DI PE WALL PIPE, SEE DETAIL 1/13
 - 36 ACCESS HATCH 36" X 48" CLEAR OPENING




DESIGN CRITERIA

NUMBER OF PUMPS:	2
PUMP	ITT FLYGT
MODEL	3127 30
IMPELLER	433
PUMP HORSEPOWER:	7.5 HP
DESIGN FLOW RATE:	525 gpm @ 26.8 ft TDH
* PUMP PLACEMENT/LOCATION TO BE AS PER MANUFACTURER DESIGN OF FLYGT PUMP, MODEL 3170. AT PRESENT TIME FLYGT PUMPS, MODEL 3127-433, TO BE PLACE IN WETWELL @ LOCATION AS STATED ABOVE.	

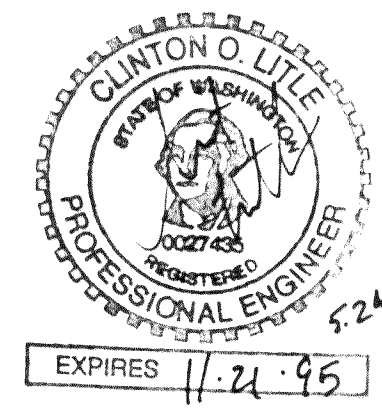



RECORD DRAWING

00105.016 2-7-06 KLR

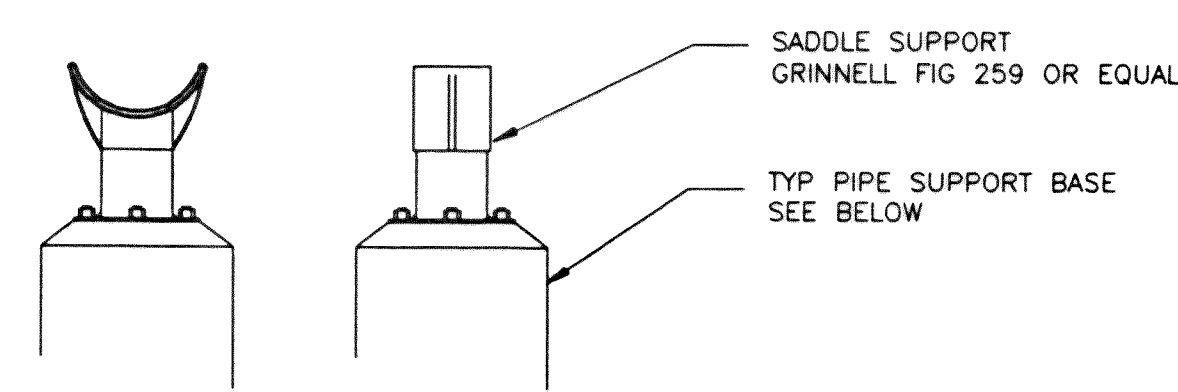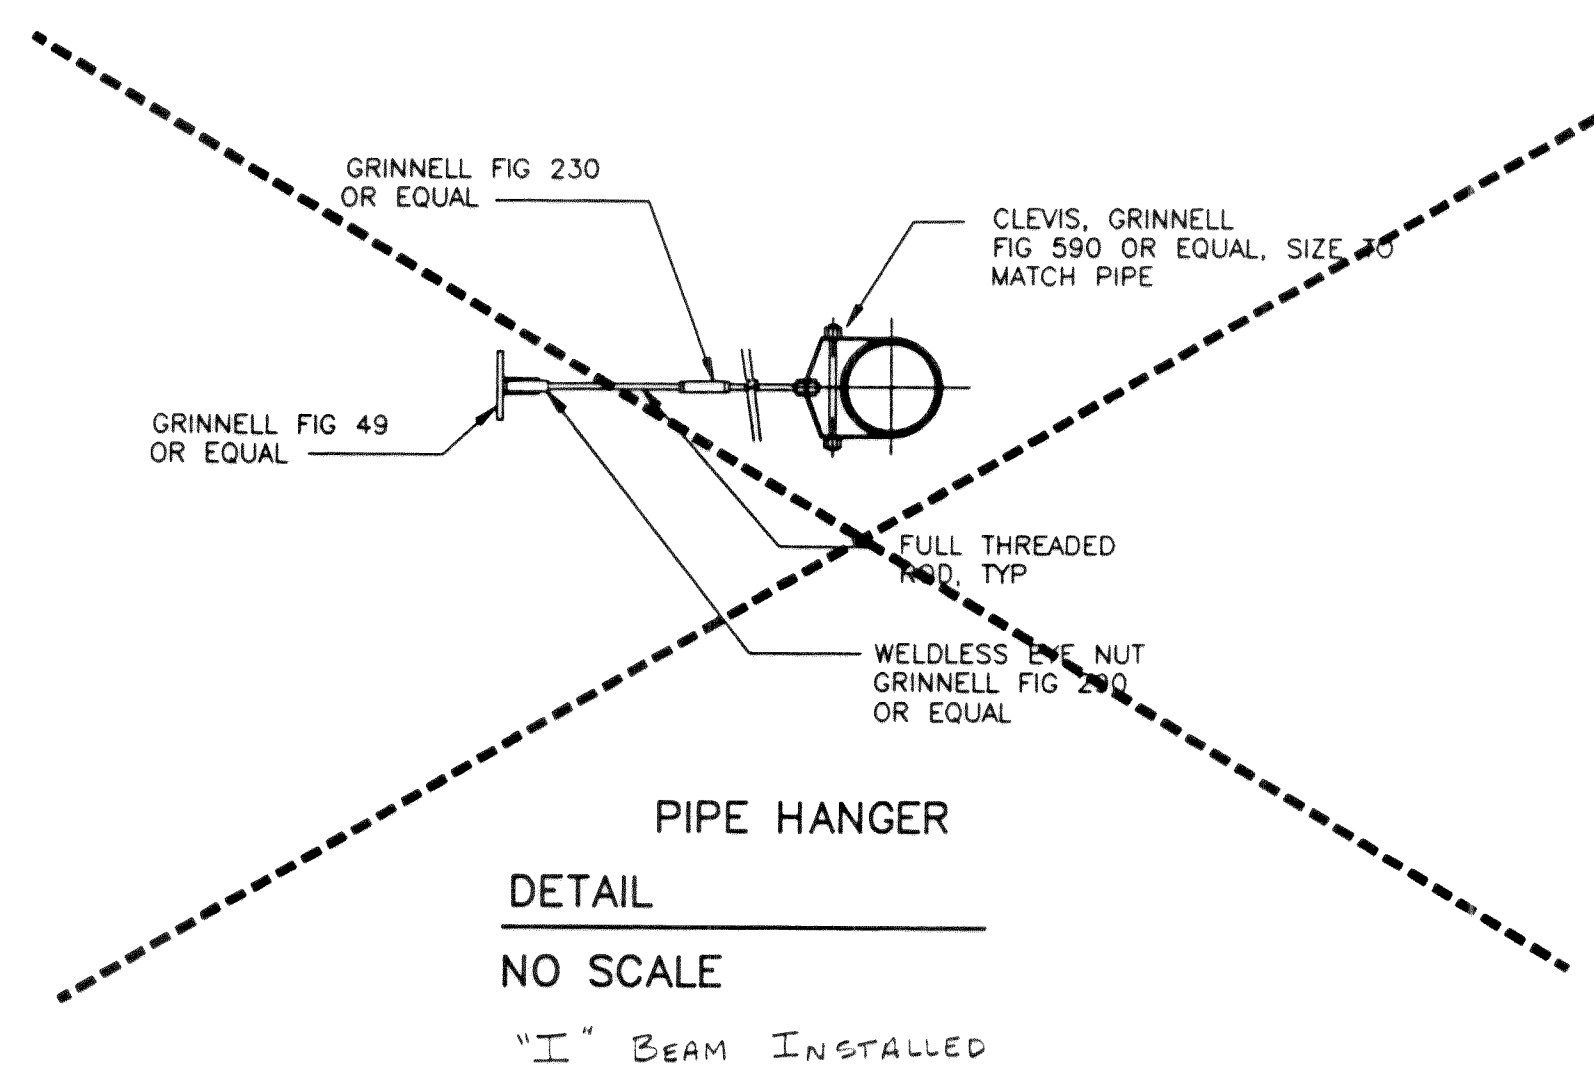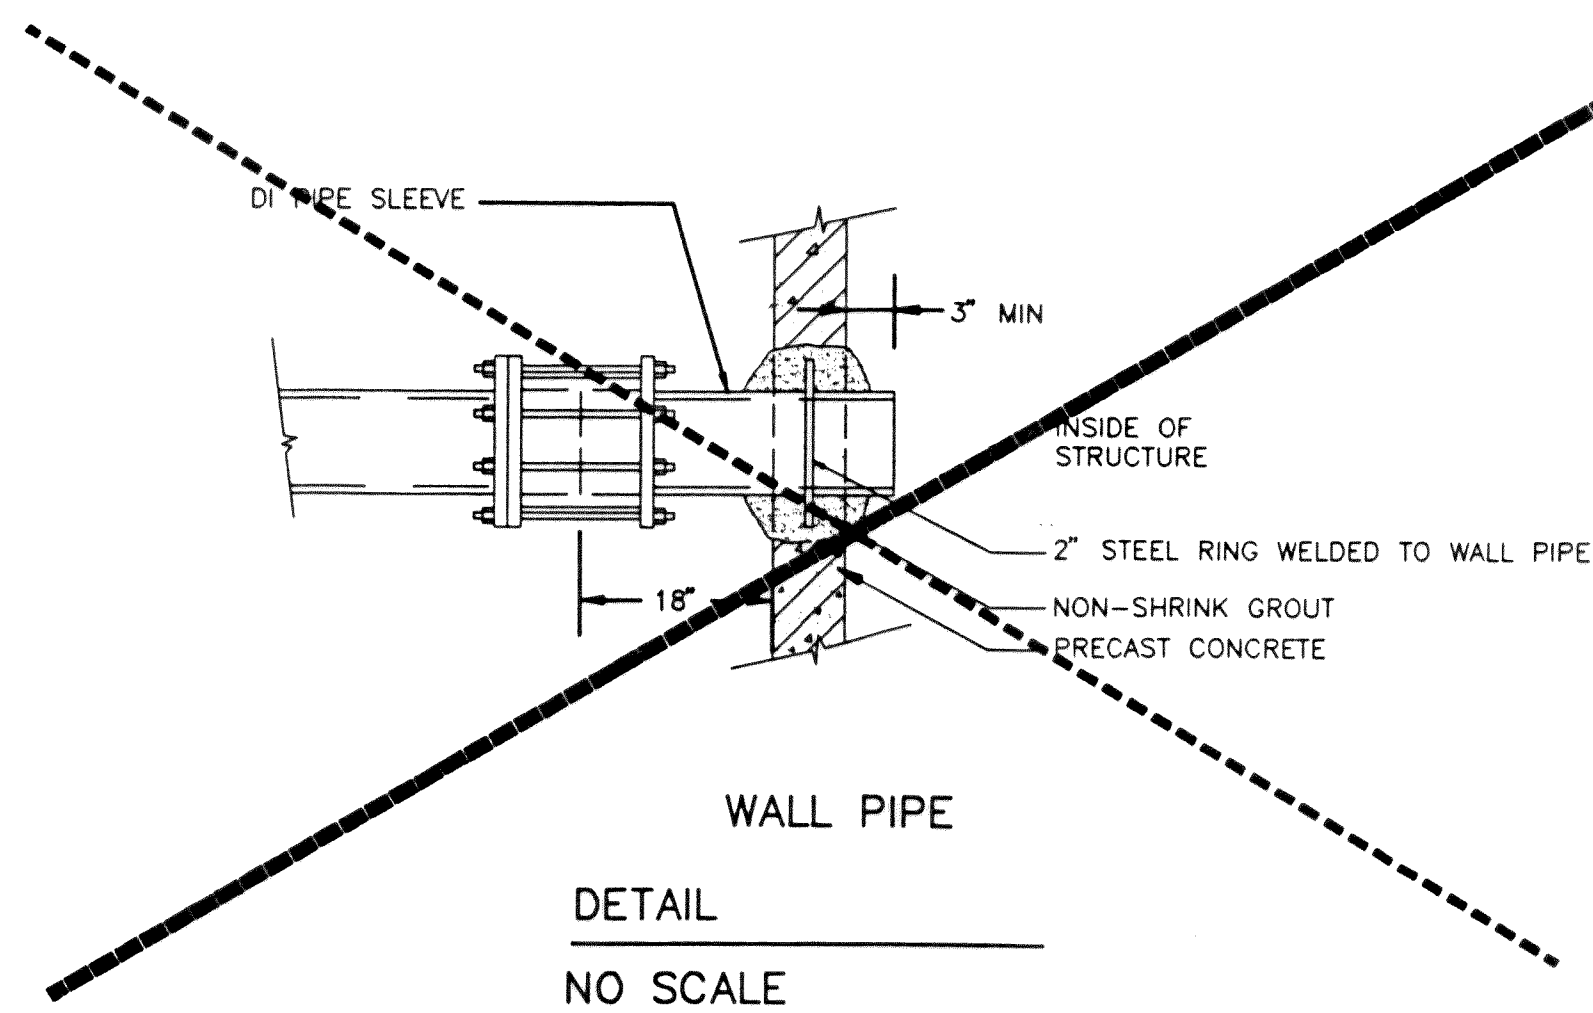


THRUST BLOCKING NOTES

1. BEARING AREAS ARE BASED ON MAXIMUM SOIL BEARING STRESS OF 1000 PSF.
2. LENGTH/HEIGHT AS REQUIRED TO OBTAIN BEARING AGAINST UNDISTURBED EARTH.
3. CONCRETE SHALL BE CLASS B.
4. REINFORCE THRUST BLOCKS WITH #3 BARS @ 12" O.C. EACH WAY, EACH FACE.
5. UNLESS OTHERWISE SPECIFIED, THRUST BLOCKS ARE NOT REQUIRED FOR PIPELINES WHICH USE ONLY FULLY RESTRAINED JOINTS, I.E. WELDED, VICTAULIC OR FLANGED, MECHANICAL JOINTS WITH SUPPLEMENTAL THRUST CONTROL ROD RESTRAINT, OR SPECIAL RESTRAINT JOINTS SHALL BE USED SUBJECT TO THE ENGINEER'S PRIOR WRITTEN REVIEW.

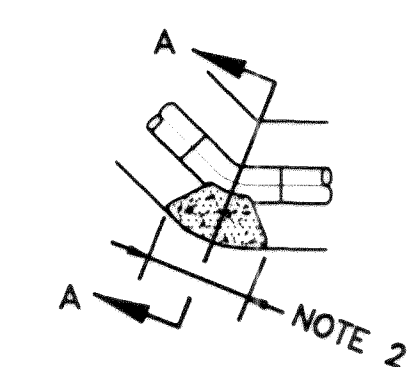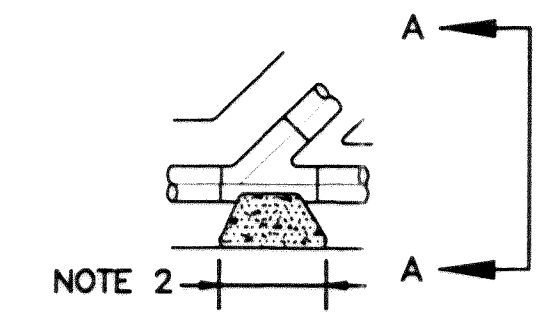


TYPICAL PIPE THRUST BLOCKING

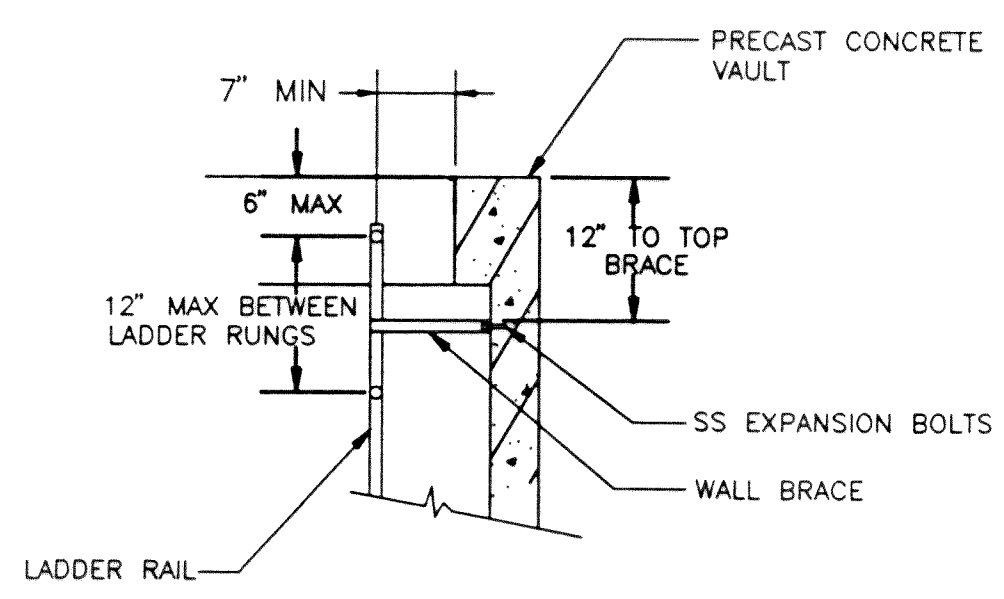

1. LADDER SHALL BE 16" WIDE, MEASURED AT INSIDE OF RAILS, UNLESS OTHERWISE DIRECTED BY ENGINEER
2. LADDER SHALL BE FABRICATED ENTIRELY OF STEEL AND HOT-DIPPED GALVANIZED AFTER FABRICATION
3. LADDER SHALL BE SECURELY FASTENED TO FLOOR
4. THE MAXIMUM DISTANCE BETWEEN THE BOTTOM RUNG AND FINISH FLOOR SHALL BE 15"

VAULT ACCESS LADDER


DETAIL
NO SCALE

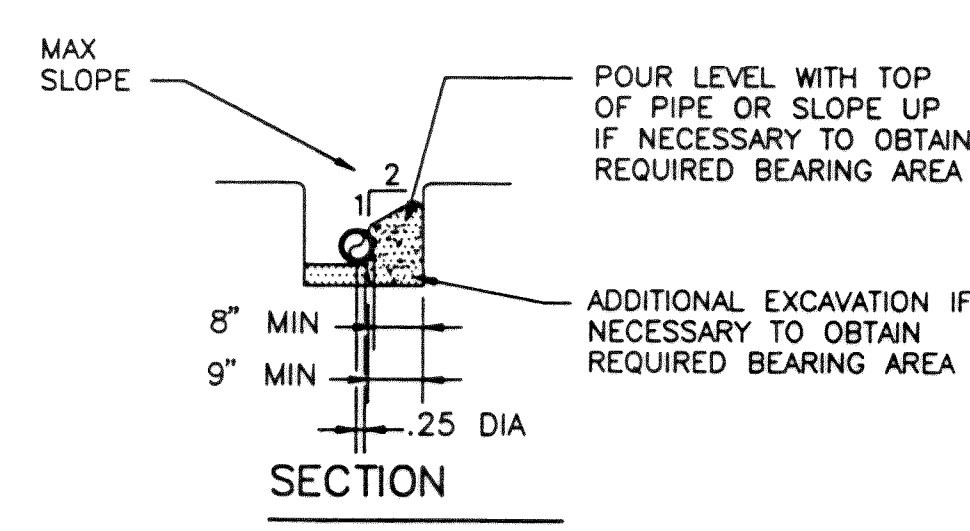

PIPE DIA IN	TEST PRESSURE PSIG	BEARING AREA (Square Feet)			
		TEE	90°	45°	22 1/2°
UP TO 4	0 - 150	3	4	2	1
6	0 - 150	6	8	4	2
8	0 - 150	10	15	8	4
10	0 - 150	16	23	12	6


THRUST BLOCKS

DETAIL
NO SCALE

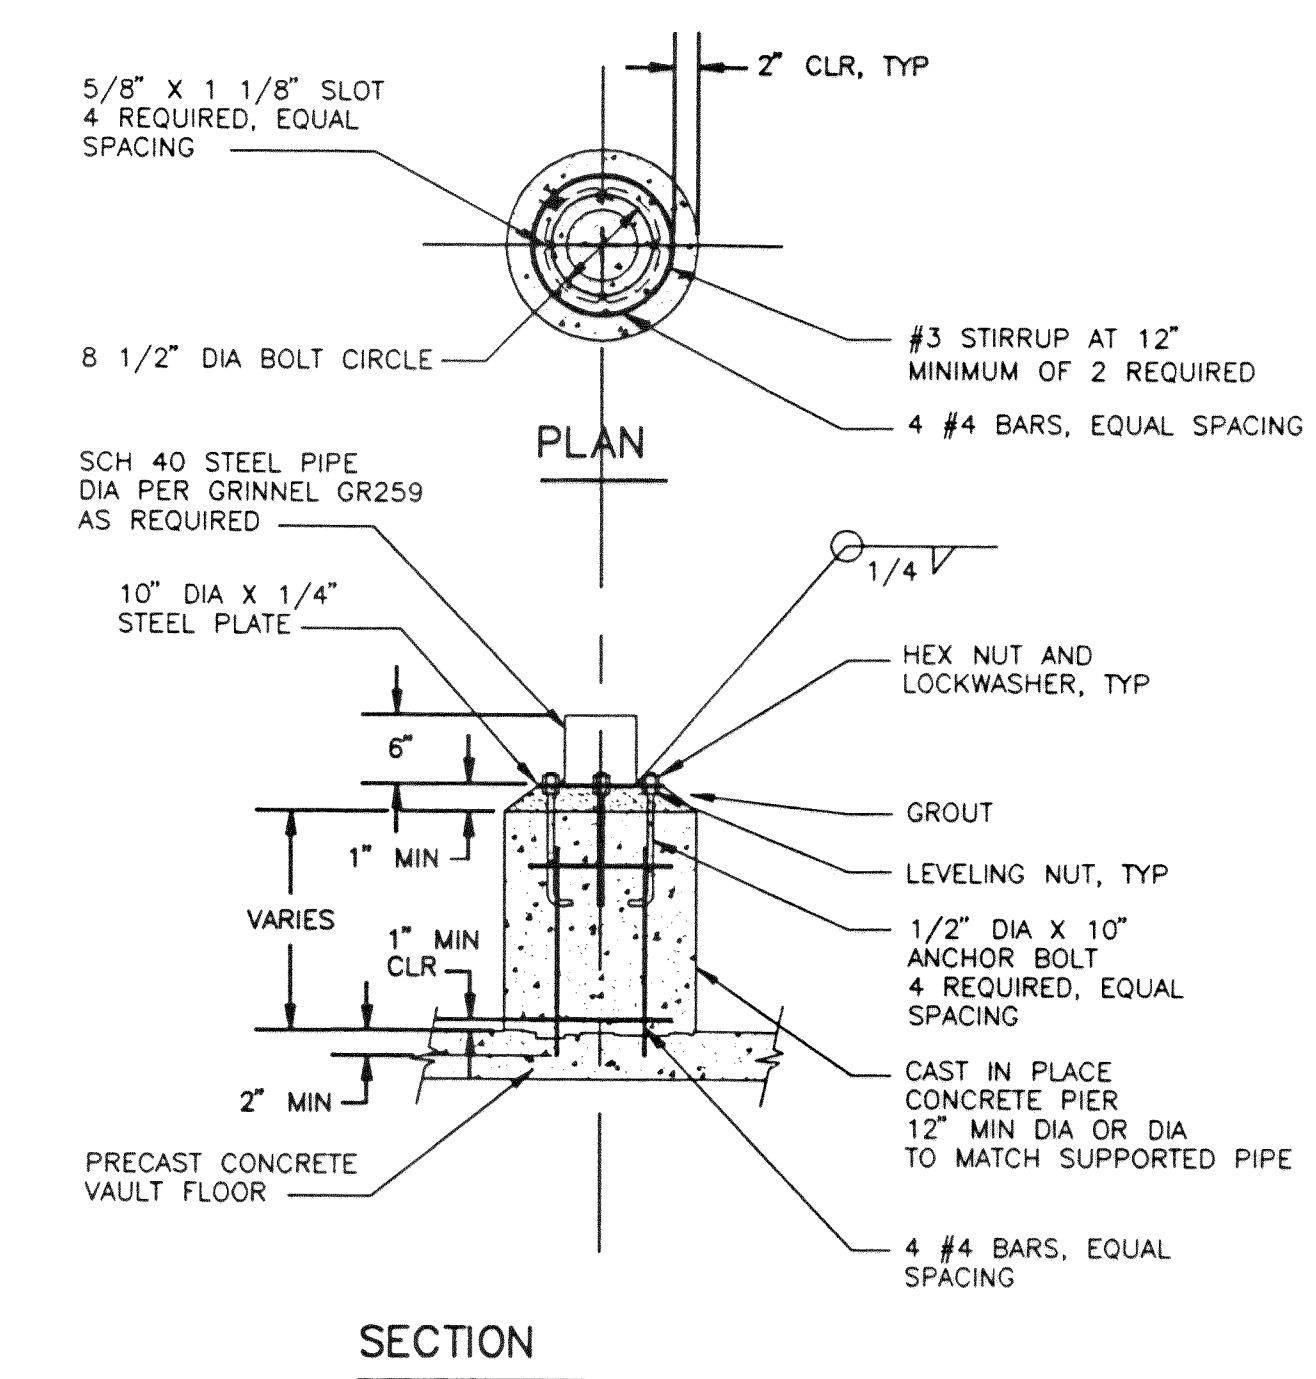


PIPE SUPPORT BASE

DETAIL
NO SCALE

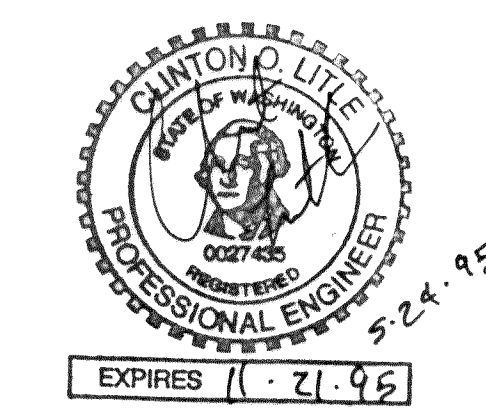

RECORD DRAWING

NO.	REVISIONS	BY	DATE

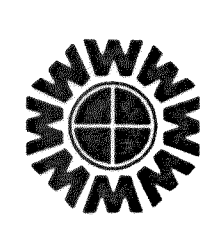

WEDEN ENGINEERING, INC.
119 GRAND AVENUE, SUITE D,
BELLINGHAM, WA. 98225 671-8200

ONE INCH AT FULL SCALE
IF NOT ONE INCH SCALE ACCORDINGLY

DESIGNED BY:
DRAWN BY:
CHECKED BY:

CITY OF FERNDAL U.L.I.D. NO. 7
SANITARY SEWER EXTENSION
LIFT STATION DETAILS

C:\DWG\2096RD16 11/14/94 15:31

DATE	SHEET
09/22/94	16
SCALE	OF
AS NOTED	
REC. NO.	
92096	16

SITE PLAN - LIFT STATION

SCALE: 1/16" = 1'-0"

SYMBOL LEGEND

- LIGHT
DUPLX RECEPTACLE
GFI RECEPTACLE, DOUBLE DUPLX
EXPOSED CONDUIT: UNLESS OTHERWISE INDICATED, SYMBOL DENOTES 1/2" C-2#12+1#12 GROUND
CONCEALED CONDUIT: UNLESS OTHERWISE INDICATED, SYMBOL DENOTES 1/2" C-2#12+1#12 GROUND
1/2" C-3#12+1#12 GROUND
DOOR POSITION INDICATION SWITCH (DPIS)
RELAY CONTACT, NORMALLY OPEN
RELAY CONTACT, NORMALLY CLOSED
CIRCUIT BREAKER
TRANSFORMER
- SINGLE POLE SWITCH
MOTOR OUTLET
MANUAL MOTOR STARTER
DISCONNECT SWITCH
JUNCTION BOX
METER
RELAY RELAY COIL
"DISTANT" CONNECTION TO FIELD DEVICE OR OTHER SYSTEM
KEY NOTE
CONDUIT AND WIRE IDENTIFIER

PANEL ELEVATION

NOT TO SCALE

LIFT STATION PLAN

1/4" = 1'-0"

LIFT STATION SECTION

1/4" = 1'-0"

KEYNOTES:

- 1 PROVIDE 36"Wx42"Lx32"H CONCRETE JUNCTION BOX, UTILITY VAULT CO #3642-LA WITH LOCKING STEEL COVER, #3642--2436P, OR APPROVED EQUAL. AREA WITHIN JUNCTION BOX SHALL BE CLASSIFIED AS CLASS 1 DIVISION 1.

2 PROVIDE 6'-0"x11'-0"x1'-0" CONCRETE PAD.

3 PROVIDE 60A-3P MANUAL TRANSFER SWITCH.

4 PROVIDE 40A-3P ENCLOSED CIRCUIT BREAKER, NEMA 3R.

5 PROVIDE POWER AND CONTROL PANEL, NEMA 3R.

6 PROVIDE TELEMETRY RTU CABINET, REFERENCE THE SPECIFICATIONS.

7 PROVIDE 3KVA, 10, 480-120/240V, TRANSFORMER, SQUARE D #3S40F OR EQUAL.

8 PROVIDE LOAD CENTER, 120/240V, 10, SQUARE D #NOD12M100RB OR EQUAL.

9 PROVIDE GENERATOR RECEPTACLE MOUNTED ON BACK OF EQUIPMENT ENCLOSURE. CROUSE-HINDS #AREA204227 WITH 2 1/2" HUB SIZE, BACK BOX, ANGLE ADAPTER, RECEPTACLE HOUSING, SPRING DOOR COVER, AND TYPE AP MATING PLUG.

10 PROVIDE 9'-4"Wx5'Hx2'D POWER AND CONTROL EQUIPMENT ENCLOSURE IN ACCORDANCE WITH CITY OF FERNDAL STANDARD DETAIL. MOUNT ENCLOSURE ON I-BEAM SUPPORTS TO GIVE A MINIMUM 12" CLEARANCE ABOVE CONCRETE SLAB.

11 PROVIDE LIGHT FIXTURE, CROUSE-HINDS #VXHF25GP.

12 PROVIDE LIGHT SWITCH.

13 PROVIDE GFI RECEPTACLE, QUADRAPLEX.

14 PROVIDE CLASS 1 DIVISION 1 CONDUIT SEALS, APPLETON #ESU SERIES.

15 3/4"x8'-0" COPPER CLAD GROUND ROD.


16 LIGHT FIXTURE, CROUSE-HINDS #EVBX210-T3C.

17 PROVIDE 16 GA STEEL BARRIER, ENCLOSURE DEPTH, TO SEPERATE THE RTU FROM OTHER DEVICES.

NOTE:
EQUIPMENT ENCLOSURE AND JUNCTION BOX
LOCATED TO EAST OF WET WELL.
SEE SHEET NO. 13.

ALARM ON EL. 24.00
LAG PUMP ON EL. 23.00
LEAD PUMP ON EL. 22.00
PUMP OFF EL. 18.50
LOW WATER ALARM EL. 12.50
THERMAL SWITCH AND FLOAT LEAKAGE
SENSOR INTEGRAL TO PUMP

NOTE: CLASS 1 DIVISION 1
HAZARDOUS AREA

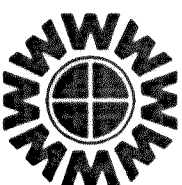

WEDEN ENGINEERING, INC.
119 GRAND AVENUE, SUITE D,
BELLINGHAM, WA. 98225 671-8200




MW Consulting Engineers
Great Northwest Building, Suite 200
North 222 Wolf Street, Spokane, WA 99201-0677
Telephone: 509.838.9020 FAX: 509.838.1123

ONE INCH AT FULL SCALE


IF NOT ONE INCH
SCALE ACCORDINGLY

DESIGNED BY:
RCP
DRAWN BY:
RCP
CHECKED BY:
RCP

CITY OF FERNDAL U.L.I.D. NO. 7
SANITARY SEWER EXTENSION
LIFT STATION

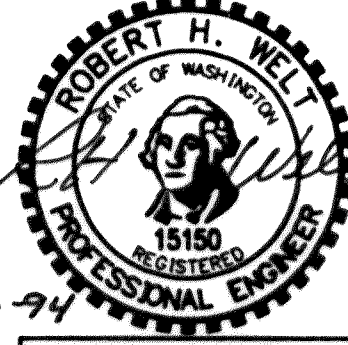

DATE	4/06/94	SHEET	17
SCALE	AS NOTED	OF	
REC. NO.			18

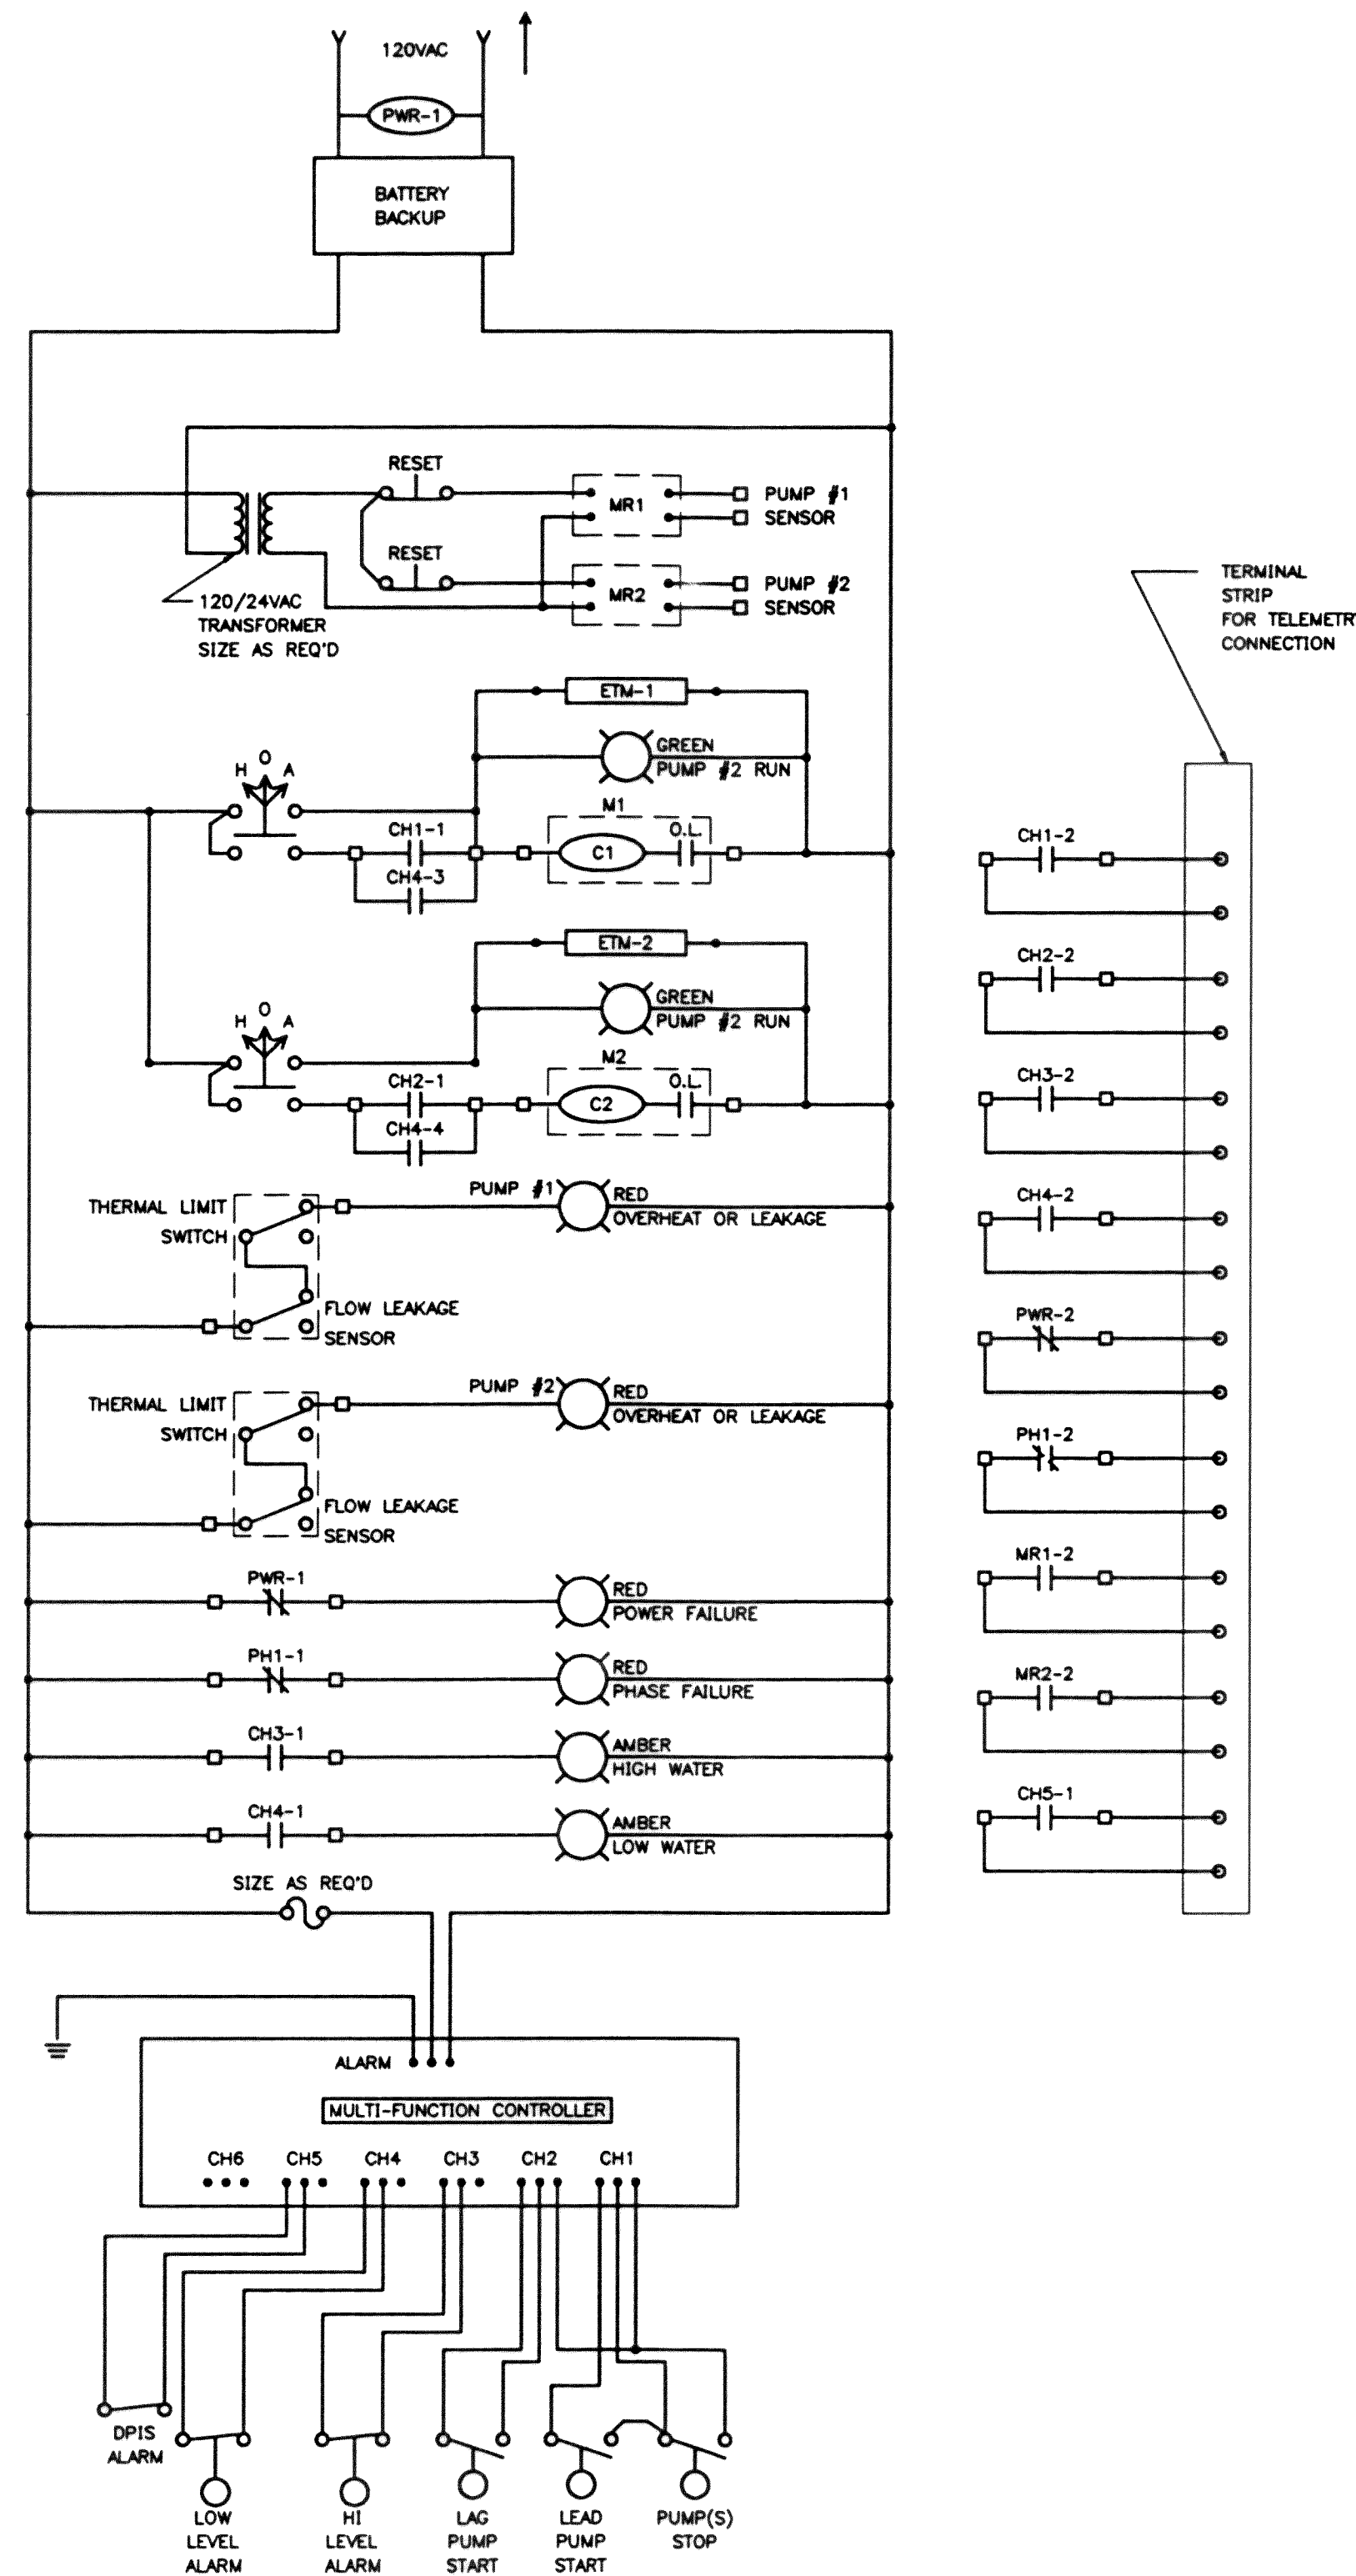

CONTROL LOGIC DIAGRAM


NOT TO SCALE

2

PUMP CONTROL PANEL

NOT TO SCALE

1

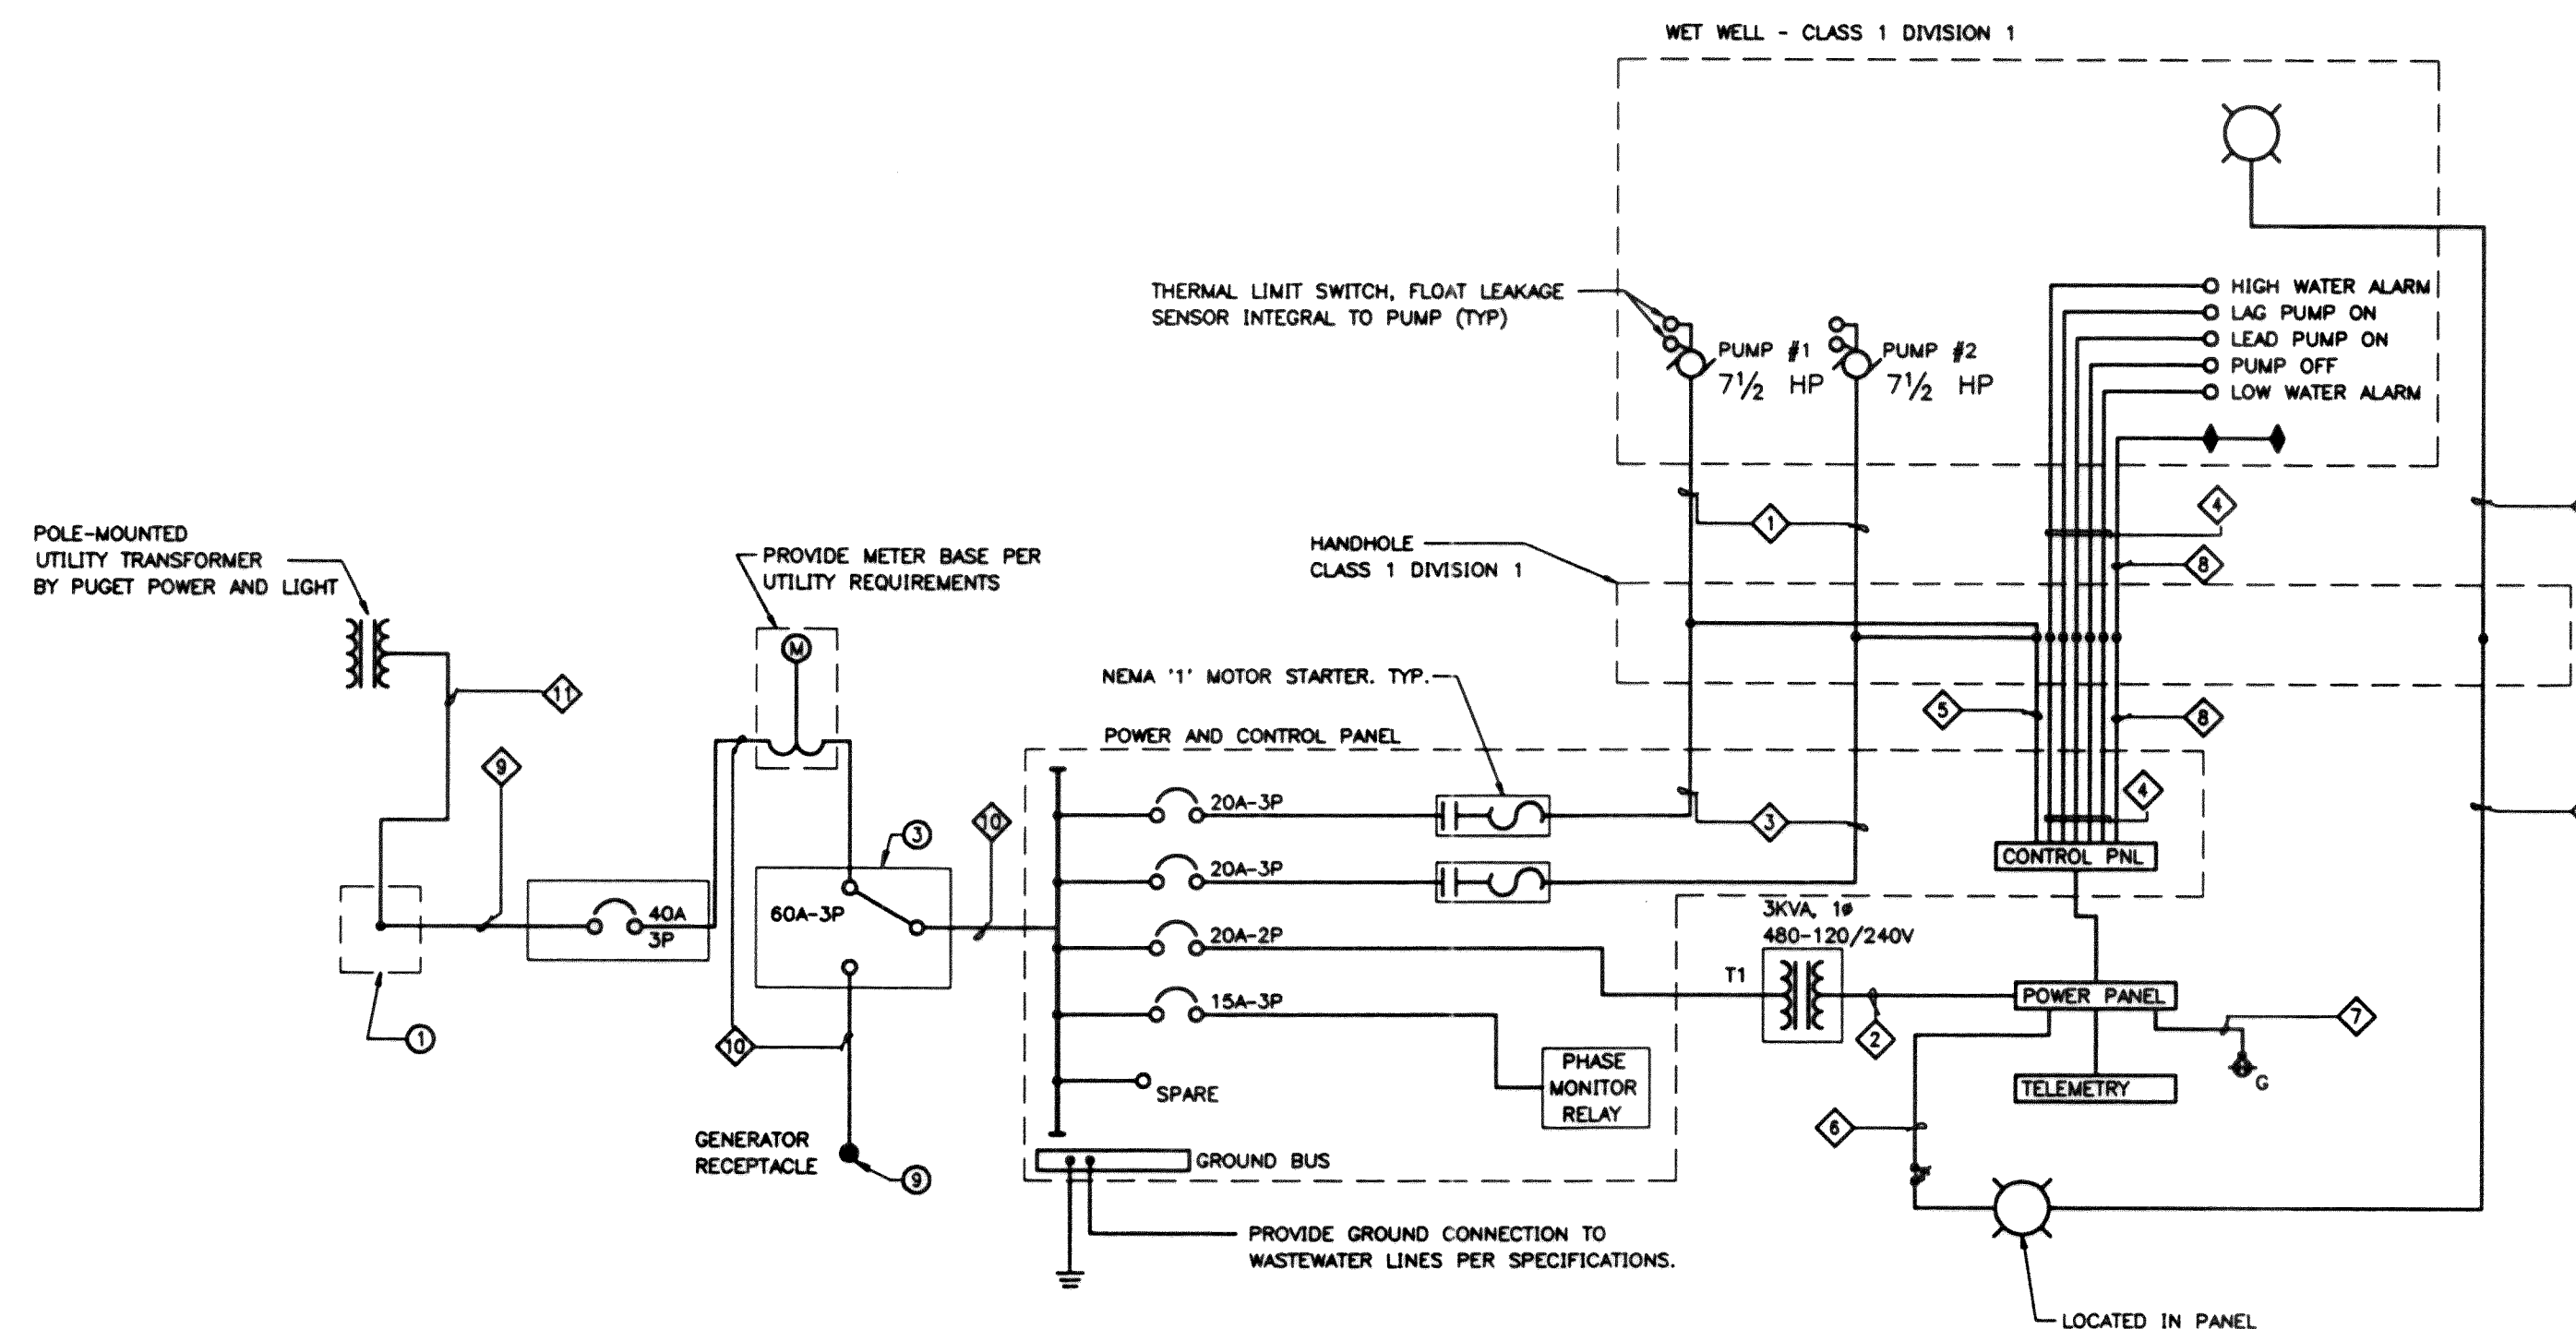

ONE-LINE DIAGRAM



NOTE:
SEE OPERATION AND MAINTENANCE MANUALS
FOR APPROVED SHOP DRAWING.

LOAD CALCULATION

	LTG	RECEPT	MOTORS	MISC	LINE TOTAL
PUMP #1			9141		9141
PUMP #2			9141		9141
POWER PANEL	600	180		1000	1780
CONNECTED LOAD					
DEMAND FACTOR	1.25	1.0	1.25	1.0	
DEMAND LOAD	750	180	20567	1000	22477
DEMAND AMPS AT 480V					27.1

RACEWAY AND WIRE SCHEDULE

- 1 1" C, WIRE BY PUMP MANUFACTURER
- 2 1/2" C - 3#12
- 3 1" C - 3#10+1#10 GND
- 4 2" C, WIRE BY FLOAT MANUFACTURER
- 5 1/2" C - 4#14
- 6 1/2" C - 2#12
- 7 1/2" C - 3#12+1#12 GND
- 8 1/2" C - 2#14
- 9 1" C - 3#8
- 10 1" C - 3#8+1#8 GND
- 11 2" C - WIRE BY PUGET POWER AND LIGHT

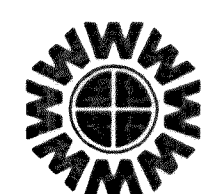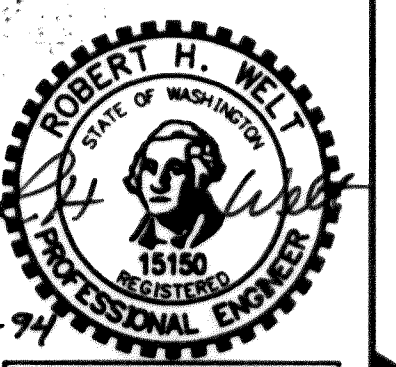

WEDEN ENGINEERING, INC.
119 GRAND AVENUE, SUITE D,
BELLINGHAM, WA 98225 671-8200



MW Consulting Engineers
Great Northwest Building, Suite 200
North 222 Wall Street, Spokane, WA 99201-0877
Telephone: 509.838.9020 FAX: 509.838.1123

ONE INCH AT FULL SCALE

IF NOT ONE INCH
SCALE ACCORDINGLY

DESIGNED BY:
RCP
DRAWN BY:
RCP
CHECKED BY:
RCP

CITY OF FERNDAL U.I.D. NO. 7
SANITARY SEWER EXTENSION
LIFT STATION

DATE
4/06/94
SCALE
NO SCALE
REC. NO.
SHEET
18
OF
18