

CITY OF FERNDALE
L.I.D. NO. 8

RECORD DRAWINGS FOR SANITARY SEWER IMPROVEMENTS
FERNDALE, WASHINGTON

SECTION 33, T 39 N, R 2 E
SECTION 4, T 38 N, R 2 E

CONSULTING ENGINEERS: WEDEN ENGINEERING, INC. 119 GRAND AVE., STE. D, BELLINGHAM, WA 98225 671-8200
OWNER: CITY OF FERNDALE
CONTACT PERSON: JOHN F. ELEY, DIRECTOR OF PUBLIC WORKS
STAN STREBEL, CITY MANAGER

DRAWING INDEX

SHEET NO.	TITLE
1.	COVER SHEET - VICINITY, NOTES, LEGEND
2.	SANITARY SEWER IMPROVEMENTS - KEY SHEET
3.	PLAN AND PROFILE - LATERAL G STA 0+00 TO STA 12+29
4.	PLAN AND PROFILE - LATERAL A STA 6+93 TO STA 17+93 - FORCE MAIN ALONG LABOUNTY AVENUE
5.	PLAN AND PROFILE - LATERAL A STA 0+00 TO STA 6+93
6.	PLAN AND PROFILE - LATERAL B STA 0+00 TO STA 9+60
7.	PLAN AND PROFILE - LATERAL B STA 9+60 TO STA 19+75
8.	PLAN AND PROFILE - LATERAL C STA 0+00 TO STA 10+36
9.	PLAN AND PROFILE - LATERAL D STA 0+00 TO STA 4+75D - LATERAL F STA 0+00 TO STA 5+47F
10.	PLAN AND PROFILE - LATERAL E STA 0+00 TO STA 14+82
11.	PLAN AND PROFILE - LATERAL E STA 12+32 TO STA 20+25
12.	LIFT STATION PLAN
13.	LIFT STATION DETAILS
14.	DETAILS
15.	DETAILS
16.	LIFT STATION ELECTRICAL DETAILS
17.	LIFT STATION ELECTRICAL DETAILS


GENERAL NOTES

- THE LOCATION AND SIZE OF EXISTING UTILITIES SHOWN IS APPROXIMATE. IT IS THE RESPONSIBILITY OF THE CONTRACTOR TO FIELD VERIFY THESE LOCATIONS PRIOR TO CONSTRUCTION.
- ALL WORK SHALL CONFORM TO THE STANDARD PLANS AND SPECIFICATIONS OF THE WASHINGTON STATE DEPARTMENT OF TRANSPORTATION (WSDOT), 1991, AND CITY OF FERNDALE STANDARDS UNLESS INDICATED OTHERWISE BY THE CONTRACT DOCUMENTS. IN CASE OF A CONFLICT BETWEEN THE REGULATORY STANDARDS OR SPECIFICATIONS, THE MORE STRINGENT REQUIREMENT WILL PREVAIL.
- UNDERGROUND UTILITIES ARE KNOWN TO EXIST IN THE AREA OF CONSTRUCTION. IT IS THE RESPONSIBILITY OF THE CONTRACTOR TO CONTACT THE UTILITY OWNERS FOR LOCATIONS AND TO NOTIFY THE ENGINEER PROMPTLY OF ANY CONFLICT.
- THE CONTRACTOR SHALL BE RESPONSIBLE FOR MAINTAINING THE INTEGRITY OF ADJACENT UTILITIES WHICH INCLUDE, BUT ARE NOT LIMITED TO, WATER, SEWER, STORM SEWER, POWER, TELEPHONE, CABLE TV, NATURAL GAS, IRRIGATION, AND STREET LIGHTING.
- THE CONTRACTOR SHALL BE RESPONSIBLE FOR MAINTAINING ALL EROSION CONTROL MEASURES THROUGHOUT THE DURATION OF THE PROJECT.
- ELEVATION REFERS TO U.S.C. & G.S. DATUM CARRIED FROM A KNOWN BENCH MARK.
- X,Y PARCEL NUMBERS ARE FROM THE WHATCOM COUNTY ASSESSORS OFFICE. OWNERSHIPS OF THESE PARCELS ARE ON RECORD WITH THE ABOVE REFERENCED OFFICE.
- THE COORDINATES ON THIS PLAN ARE BASED ON AN ASSUMED COORDINATE BASE.


LEGEND

EXISTING	PLAN	PROPOSED
	CATCH BASIN	
	CULVERT	
	DETAIL NUMBER SHEET FOUND	
	WATER LINE	
	STRAW BALE DAM	
	GATE VALVE	
	HYDRANT	
	THRUST BLOCK	
	CURB CUT	
	EASEMENT	
	LIGHTING	
	LIGHTING TRENCH	
	GAS	
	TELEPHONE	
	UNDERGROUND TELEPHONE	
	STORM DRAIN	
	ELECTRICAL	
	UNDERGROUND ELECTRICAL	
	SANITARY SEWER	
	FORCE MAIN	
	DITCH	
	SILT FENCE	
	ELEVATION CONTOUR	
	APPROXIMATE PROPERTY LINE	
	RIGHT OF WAY	
	EDGE OF PAVING	
PROFILE		
	EXISTING GROUND	
	MANHOLE / SANITARY SEWER	
	FORCE MAIN	
	CATCH BASIN / STORM PIPE	
	EXISTING PIPING	

PROJECT SITE

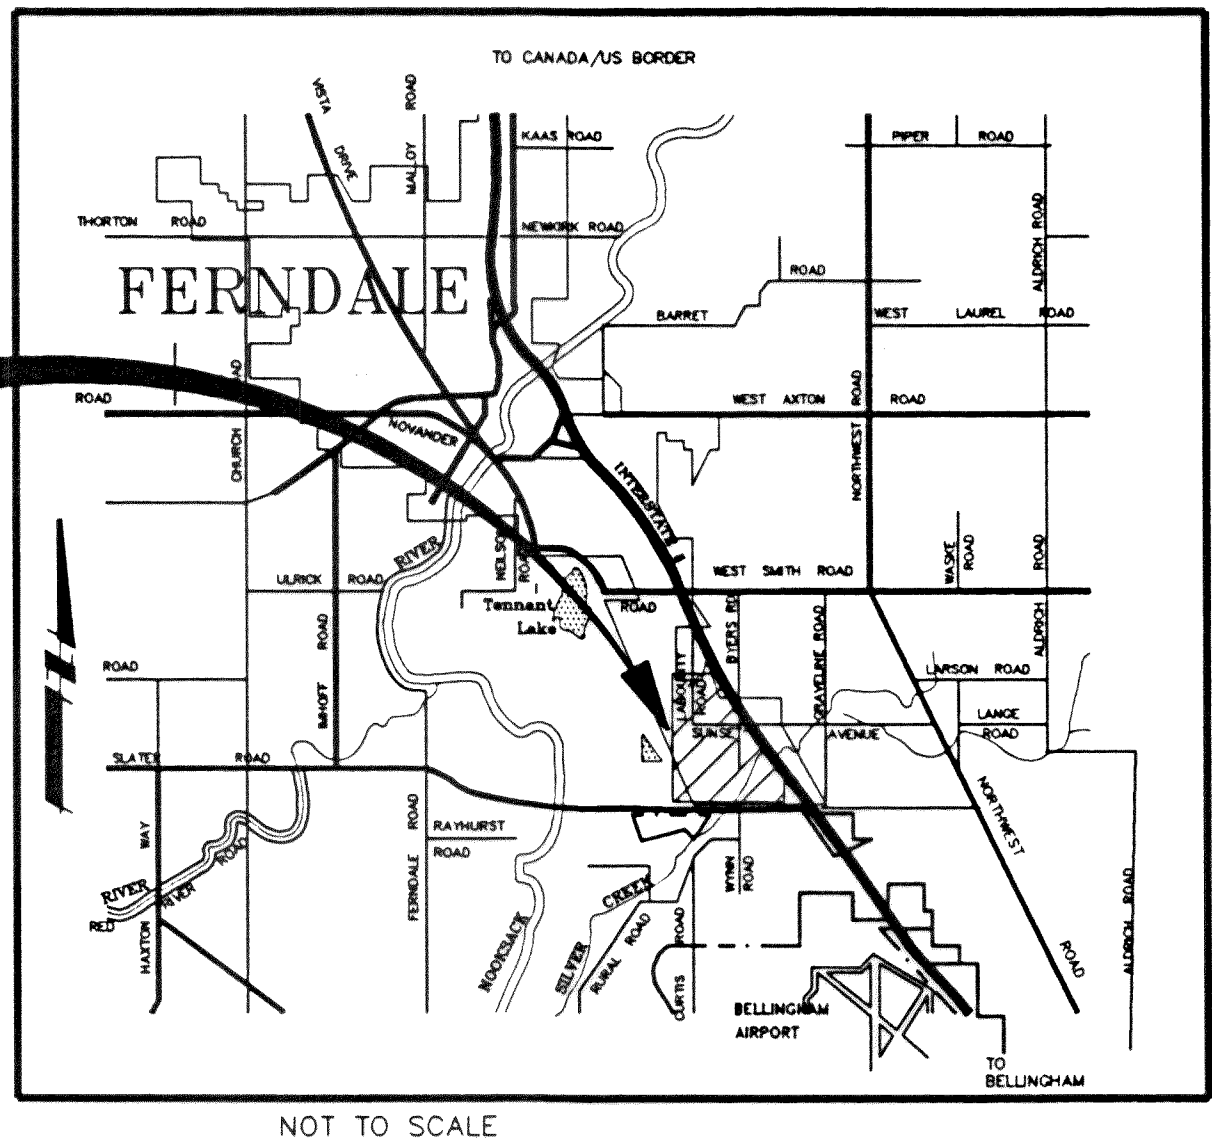


WARNING!
UTILITIES IN AREA
CALL UTILITY LOCATORS
PRIOR TO ANY EXCAVATION.

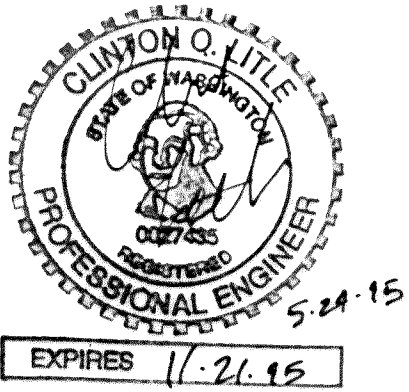

RECORD DRAWING

NO.	REVISIONS	BY	DATE

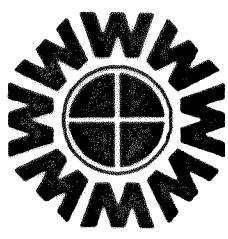

WEDEN ENGINEERING, INC.
119 GRAND AVENUE, SUITE D,
BELLINGHAM, WA. 98225 671-8200

ONE INCH AT FULL SCALE
IF NOT ONE INCH
SCALE ACCORDINGLY

DESIGNED BY
DRAWN BY
CHECKED BY

CITY OF FERNDALE L.I.D. NO. 8
SANITARY SEWER EXTENSION
TITLE, VICINITY MAP, LEGEND, NOTES, AND SHEET INDEX

C:\DWG\3022RD1A 10/14/94 09:32	DATE 10/14/94 SCALE AS NOTED REC. NO. 93022	SHEET 1 OF 17
--------------------------------	--	------------------------

00103.002 2.8.00 KR




SCALE 1 inch = 200 ft.



_____SS_____ GRAVITY SANITARY SEWER
 _____FM_____ FORCE MAIN SANITARY SEWER


✓ L.I.D. BOUNDARY

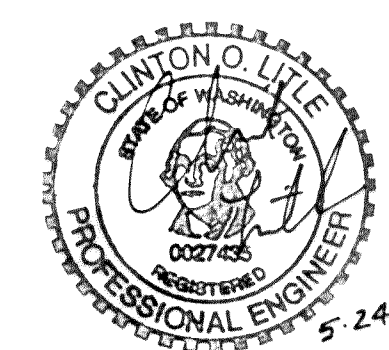

RECORD DRAWING

C:\DWG\3022RD2A 10/25/94 07:20

NO.	REVISIONS	BY	DATE

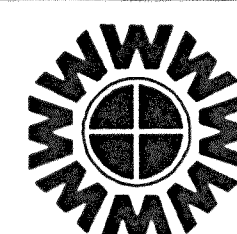

WEDEN ENGINEERING, INC.
119 GRAND AVENUE, SUITE D,
BELLINGHAM, WA. 98225 671-8200

ONE INCH AT FULL SCALE




IF NOT ONE INCH
SCALE ACCORDINGLY

DESIGNED BY
DRAWN BY
CHECKED BY



**CITY OF FERNDALE L.I.D. NO. 8
SANITARY SEWER EXTENSION
KEY MAP**

DATE 10/14/94	SHEET 2 OF 17
SCALE 1" = 200'	
REC. NO. 93022	

SECTION 33, T. 39N., R. 2E.

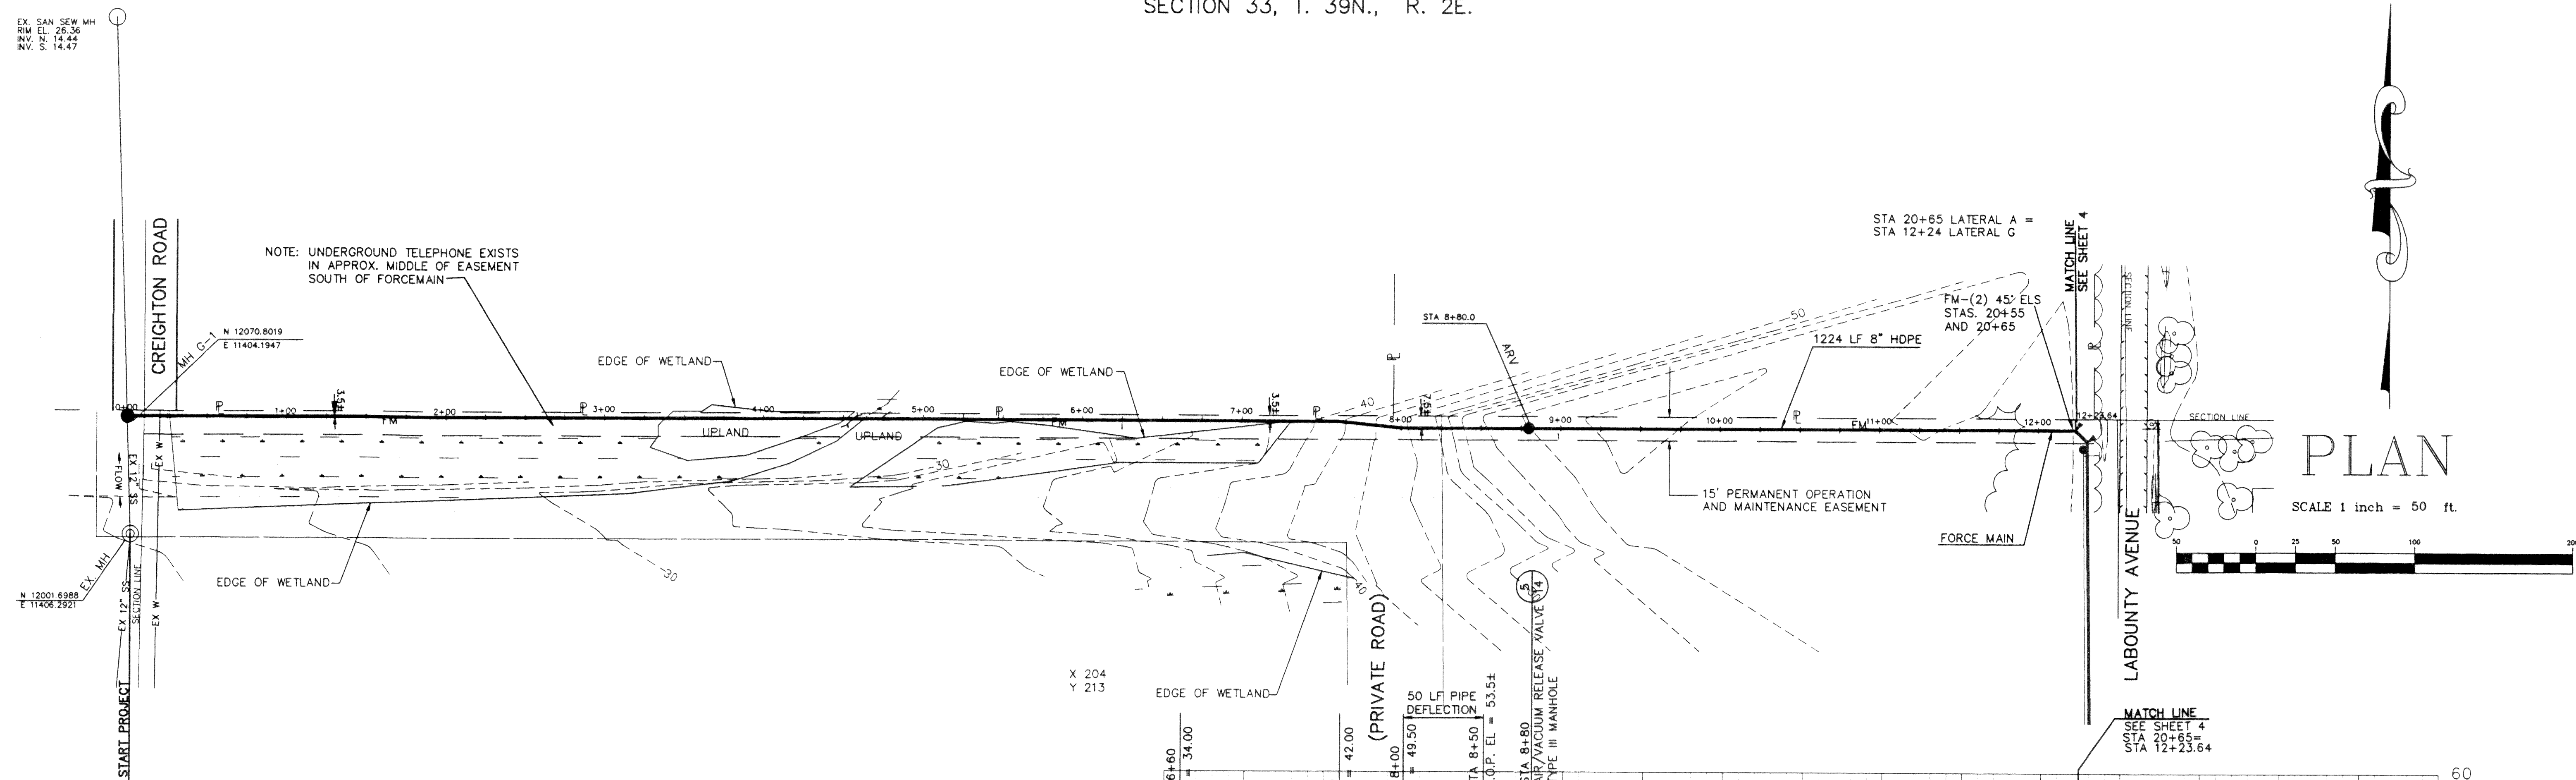


WARNING!
UTILITIES IN AREA
CALL UTILITY LOCATORS
PRIOR TO ANY EXCAVATION.

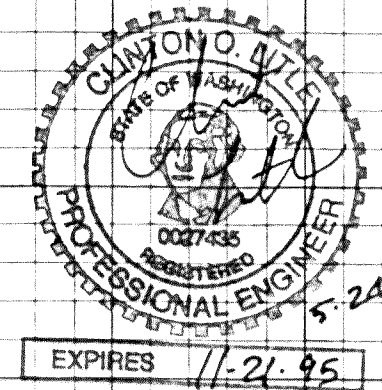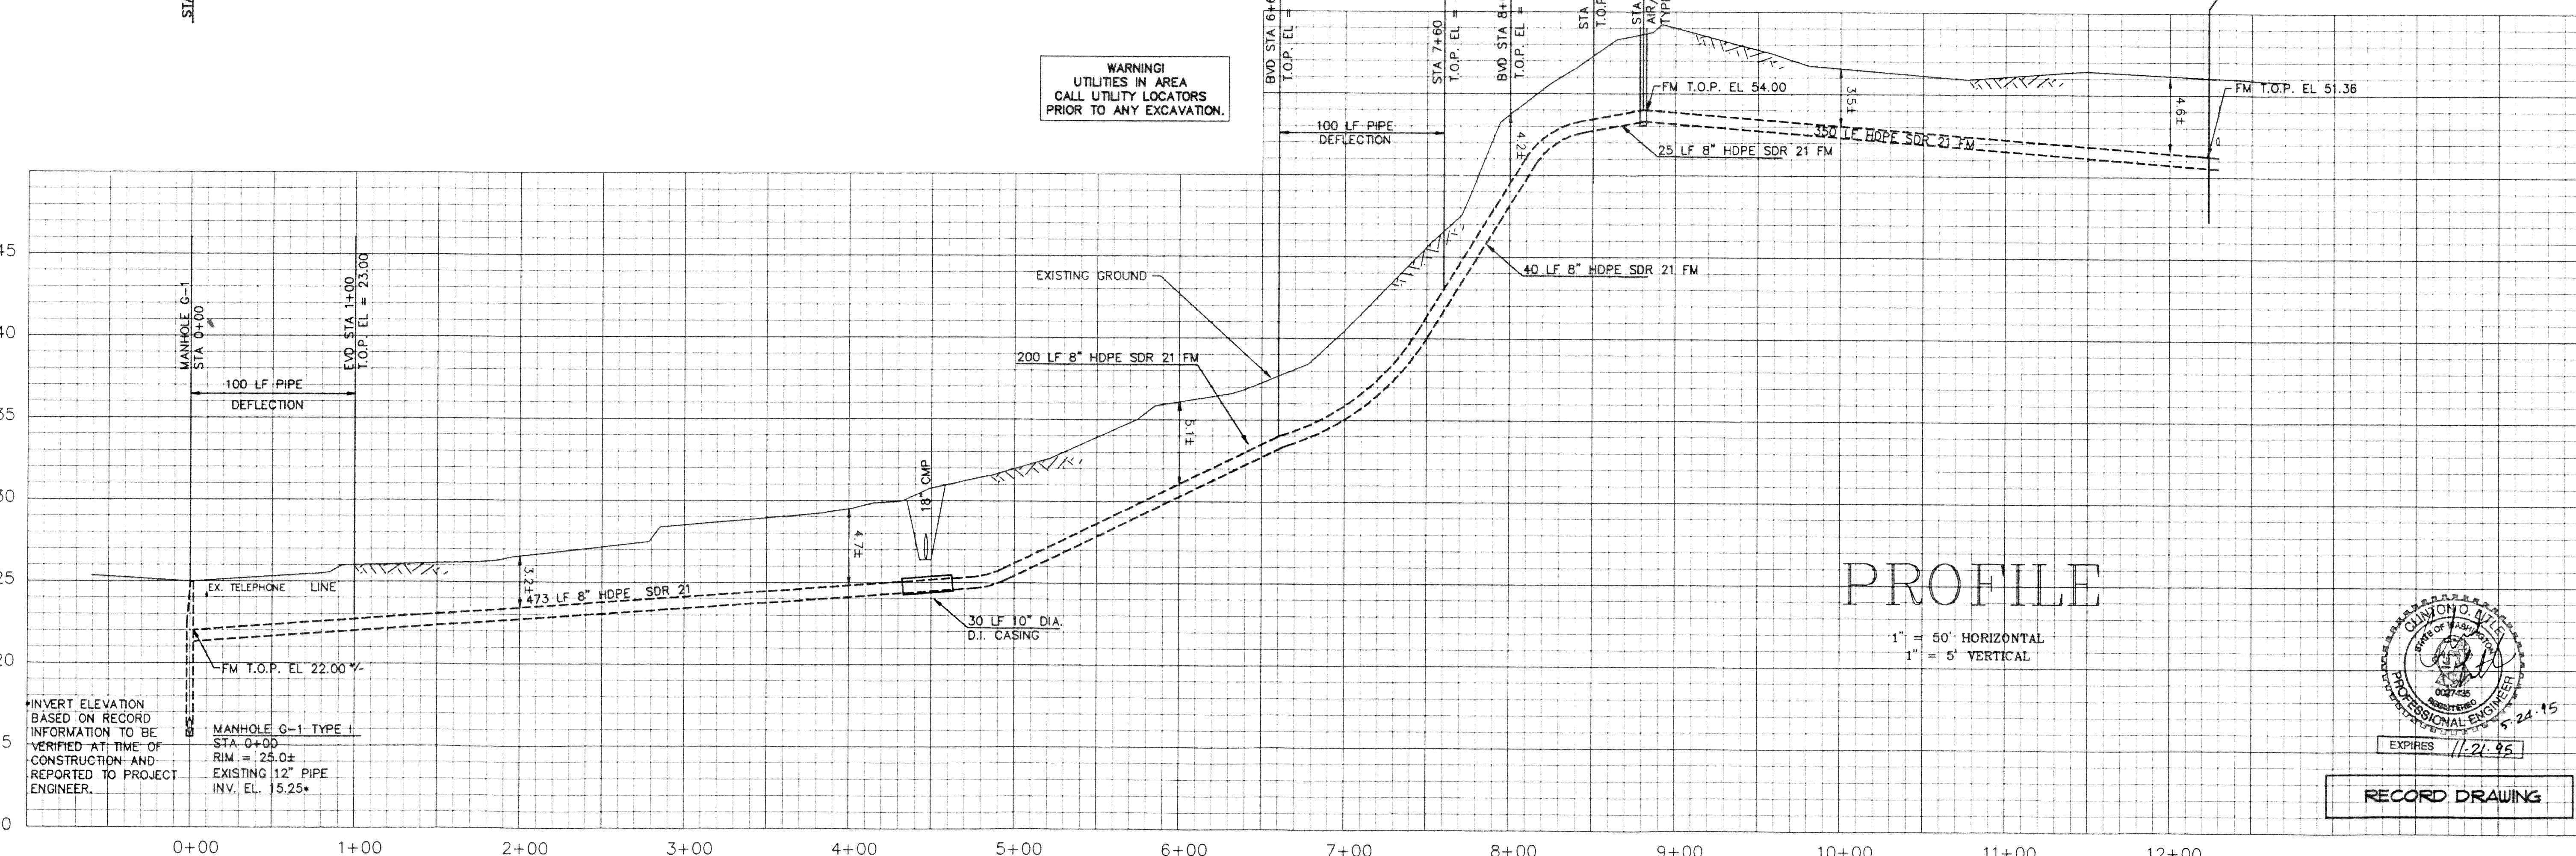

RECORD DRAWING

NO.	REVISIONS	BY	DATE

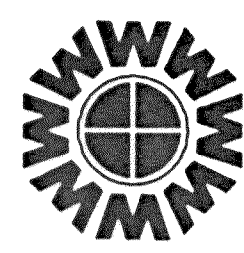


WEDEN ENGINEERING, INC.
119 GRAND AVENUE, SUITE D,
BELLINGHAM, WA. 98225 671-8200

ONE INCH AT FULL SCALE
IF NOT ONE INCH
SCALE ACCORDINGLY

DESIGNED BY
DRAWN BY
CHECKED BY

CITY OF FERNDALE L.I.D. NO. 8
SANITARY SEWER EXTENSION
PLAN PROFILE STA 0+00 TO STA 12+29
LATERAL G

C:\DWG\3022RD3A 11/15/94 10:11
DATE 10/14/94
SCALE 1"=50'H
REC. NO. 93022
SHEET 3 OF 17

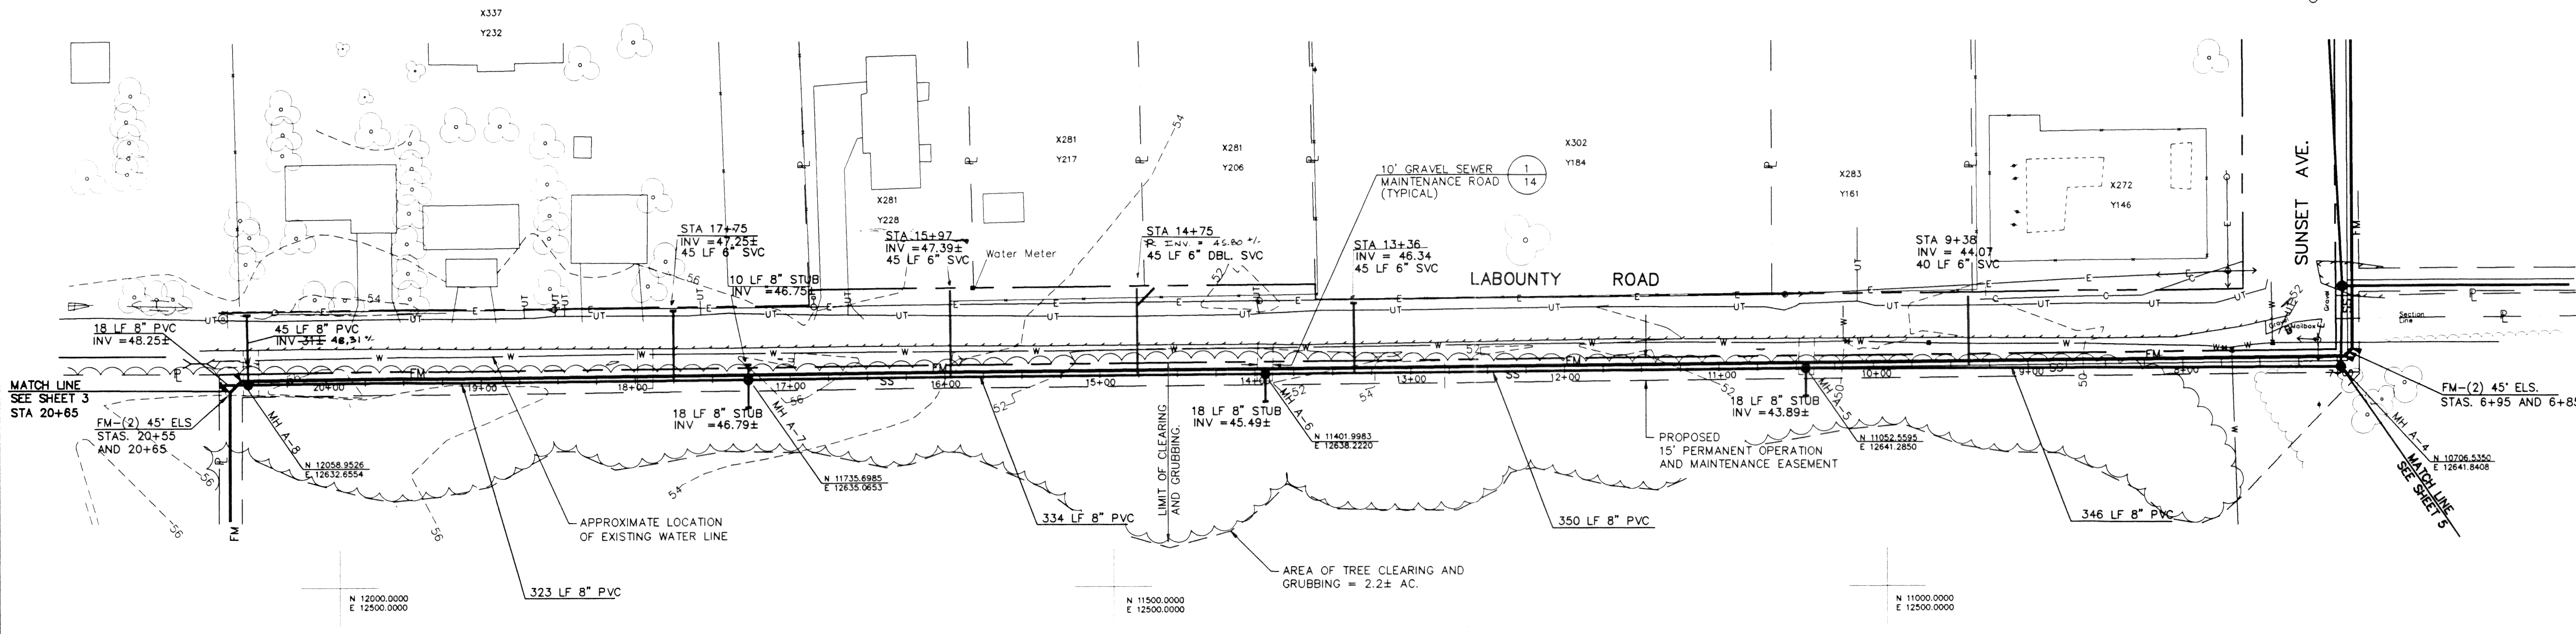

NOTE:
SIDE SEWER INVERT ELEVATIONS
GIVEN ARE APPROXIMATE, I.E. $\pm 0.5'$.

PLAN



SCALE 1 inch = 50 ft.




WARNING!
UTILITIES IN AREA
CALL UTILITY LOCATORS
PRIOR TO ANY EXCAVATION.

PROFILE

1" = 5' VERTICAL
1" = 50' HORIZONTAL

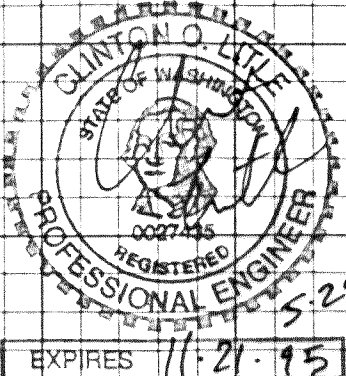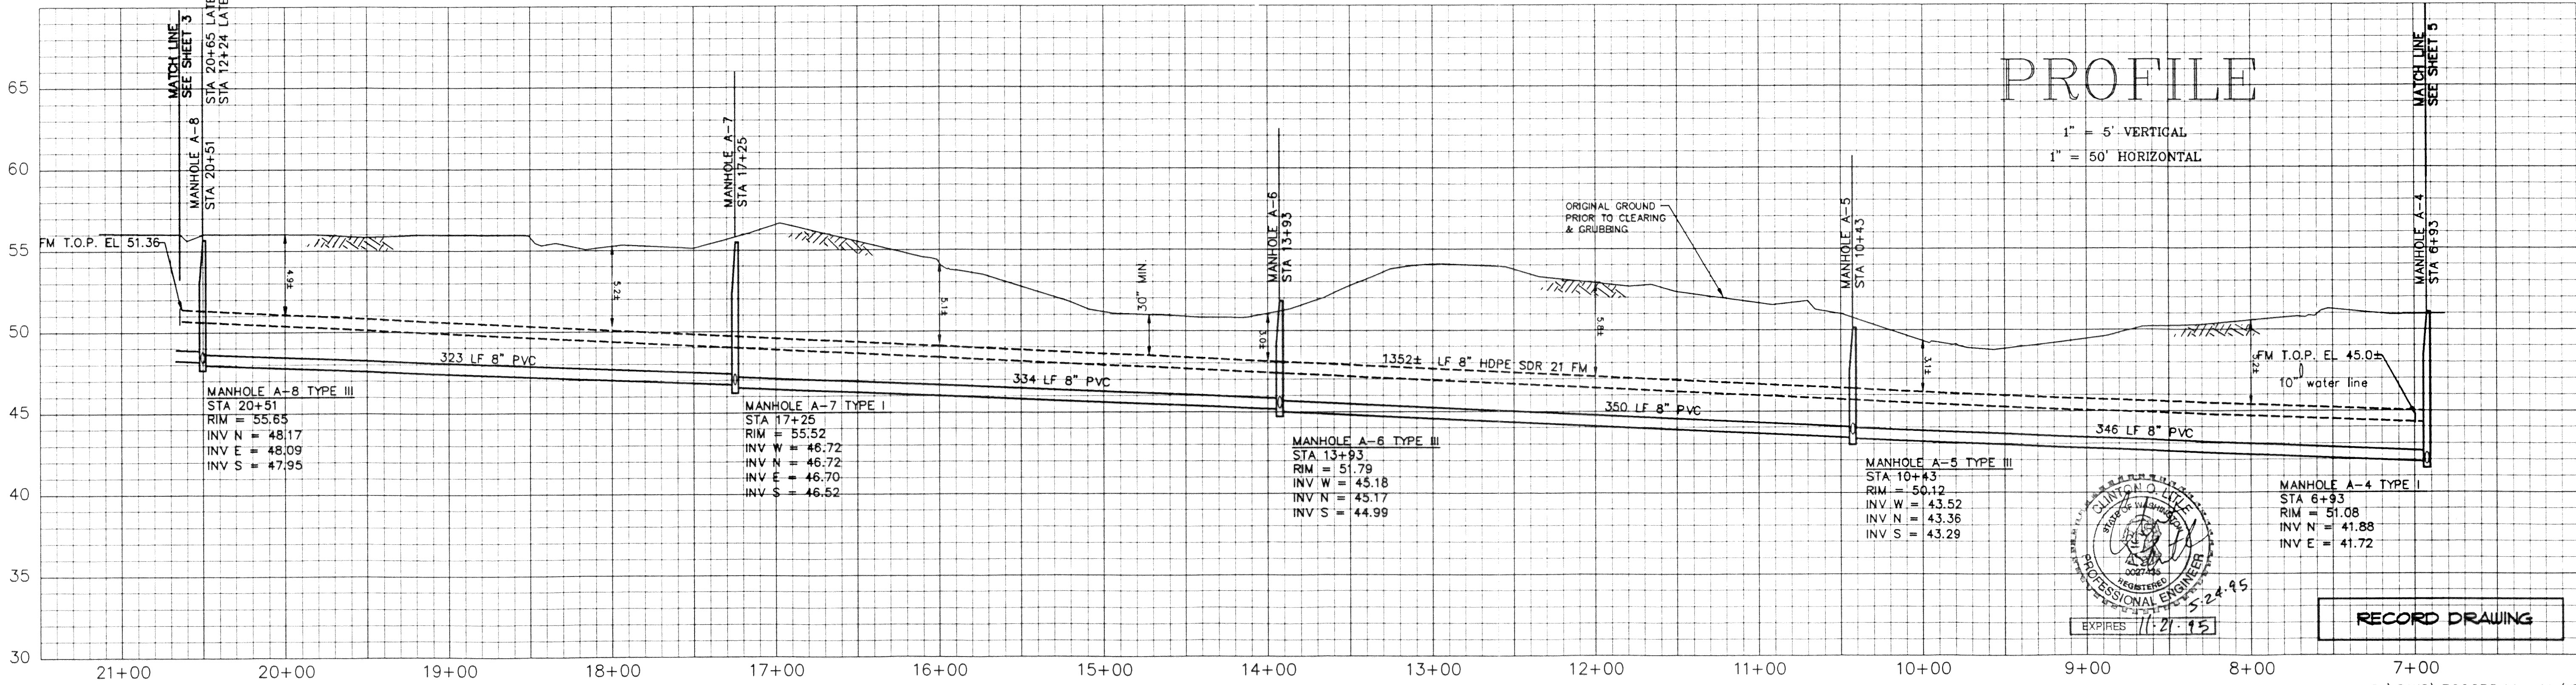

RECORD DRAWING

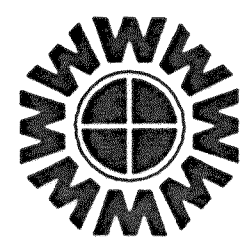

WEDEN ENGINEERING, INC.
119 GRAND AVENUE, SUITE D,
BELLINGHAM, WA. 98225 671-8200

ONE INCH AT FULL SCALE



IF NOT ONE INCH
SCALE ACCORDINGLY

DESIGNED BY

DRAWN BY

CHECKED BY

JW

CITY OF FERNDALE L.I.D. NO. 8
SANITARY SEWER EXTENSION
PLAN PROFILE STA 6+93 TO STA 17+93
LATERAL A

DATE

10/14/94

SCALE

1"=50'H

1"=5'V

REC. NO.


93022

SHEET

4



OF

17

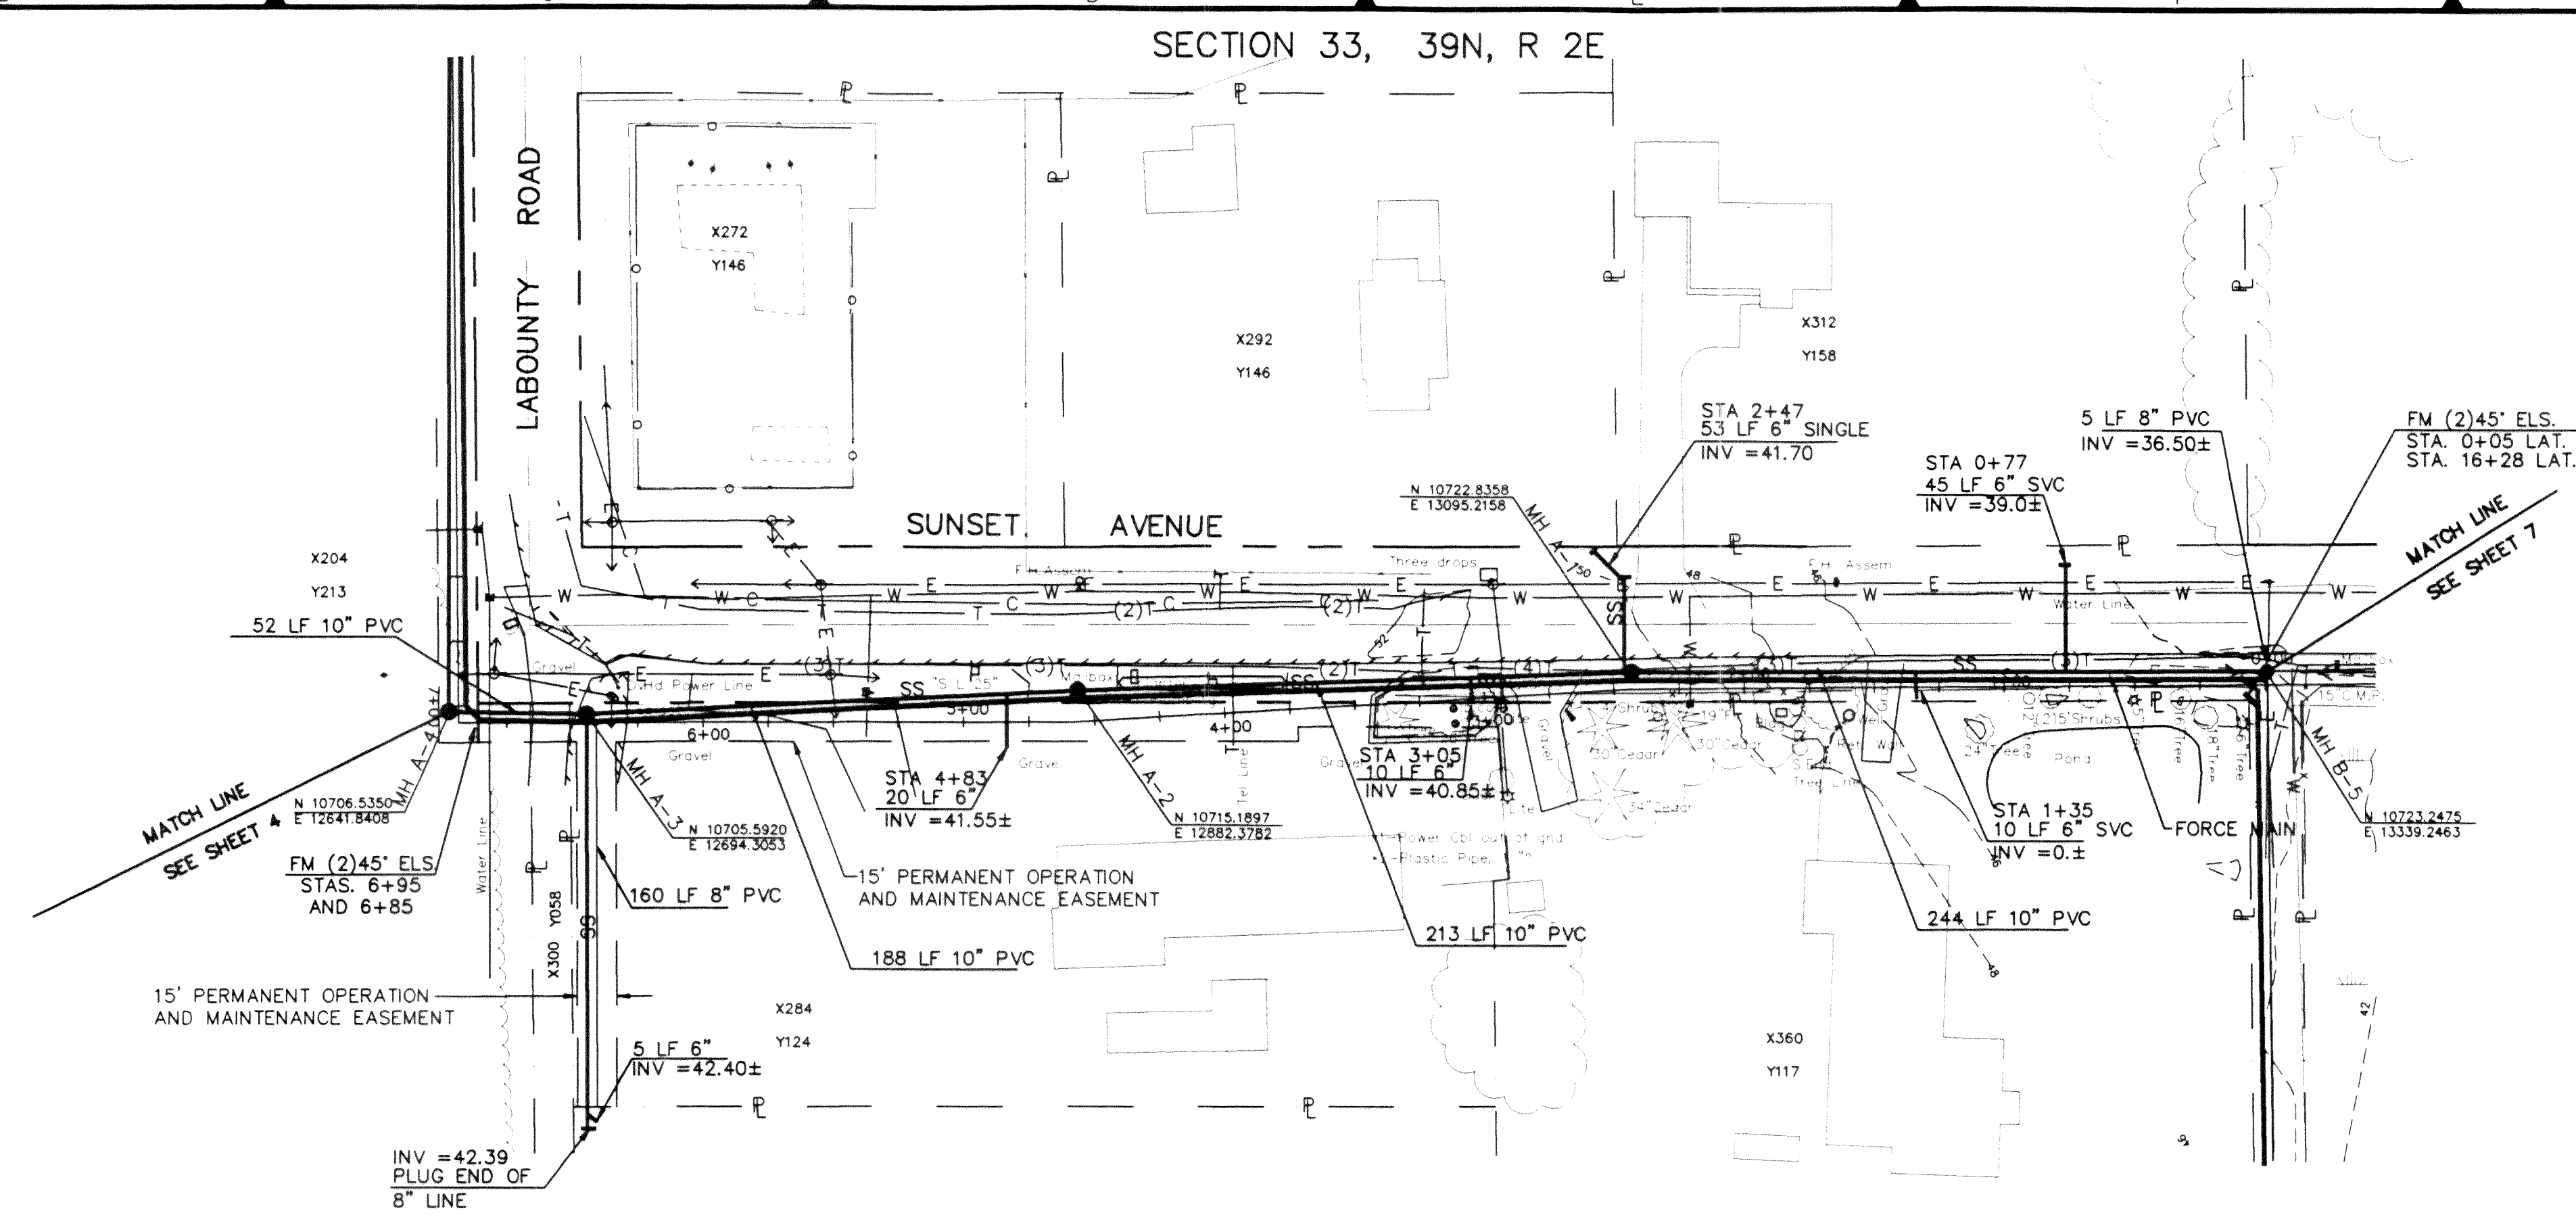

NOTE:
SIDE SEWER INVERT ELEVATIONS
GIVEN ARE APPROXIMATE, I.E. $\pm 0.5'$.

WARNING!
UTILITIES IN AREA
CALL UTILITY LOCATORS
PRIOR TO ANY EXCAVATION.

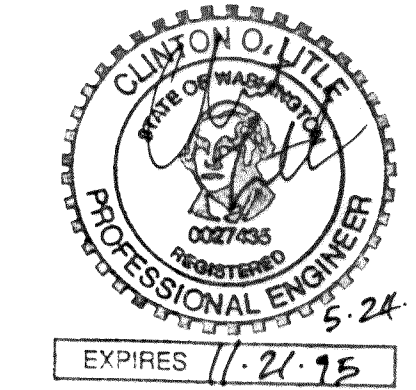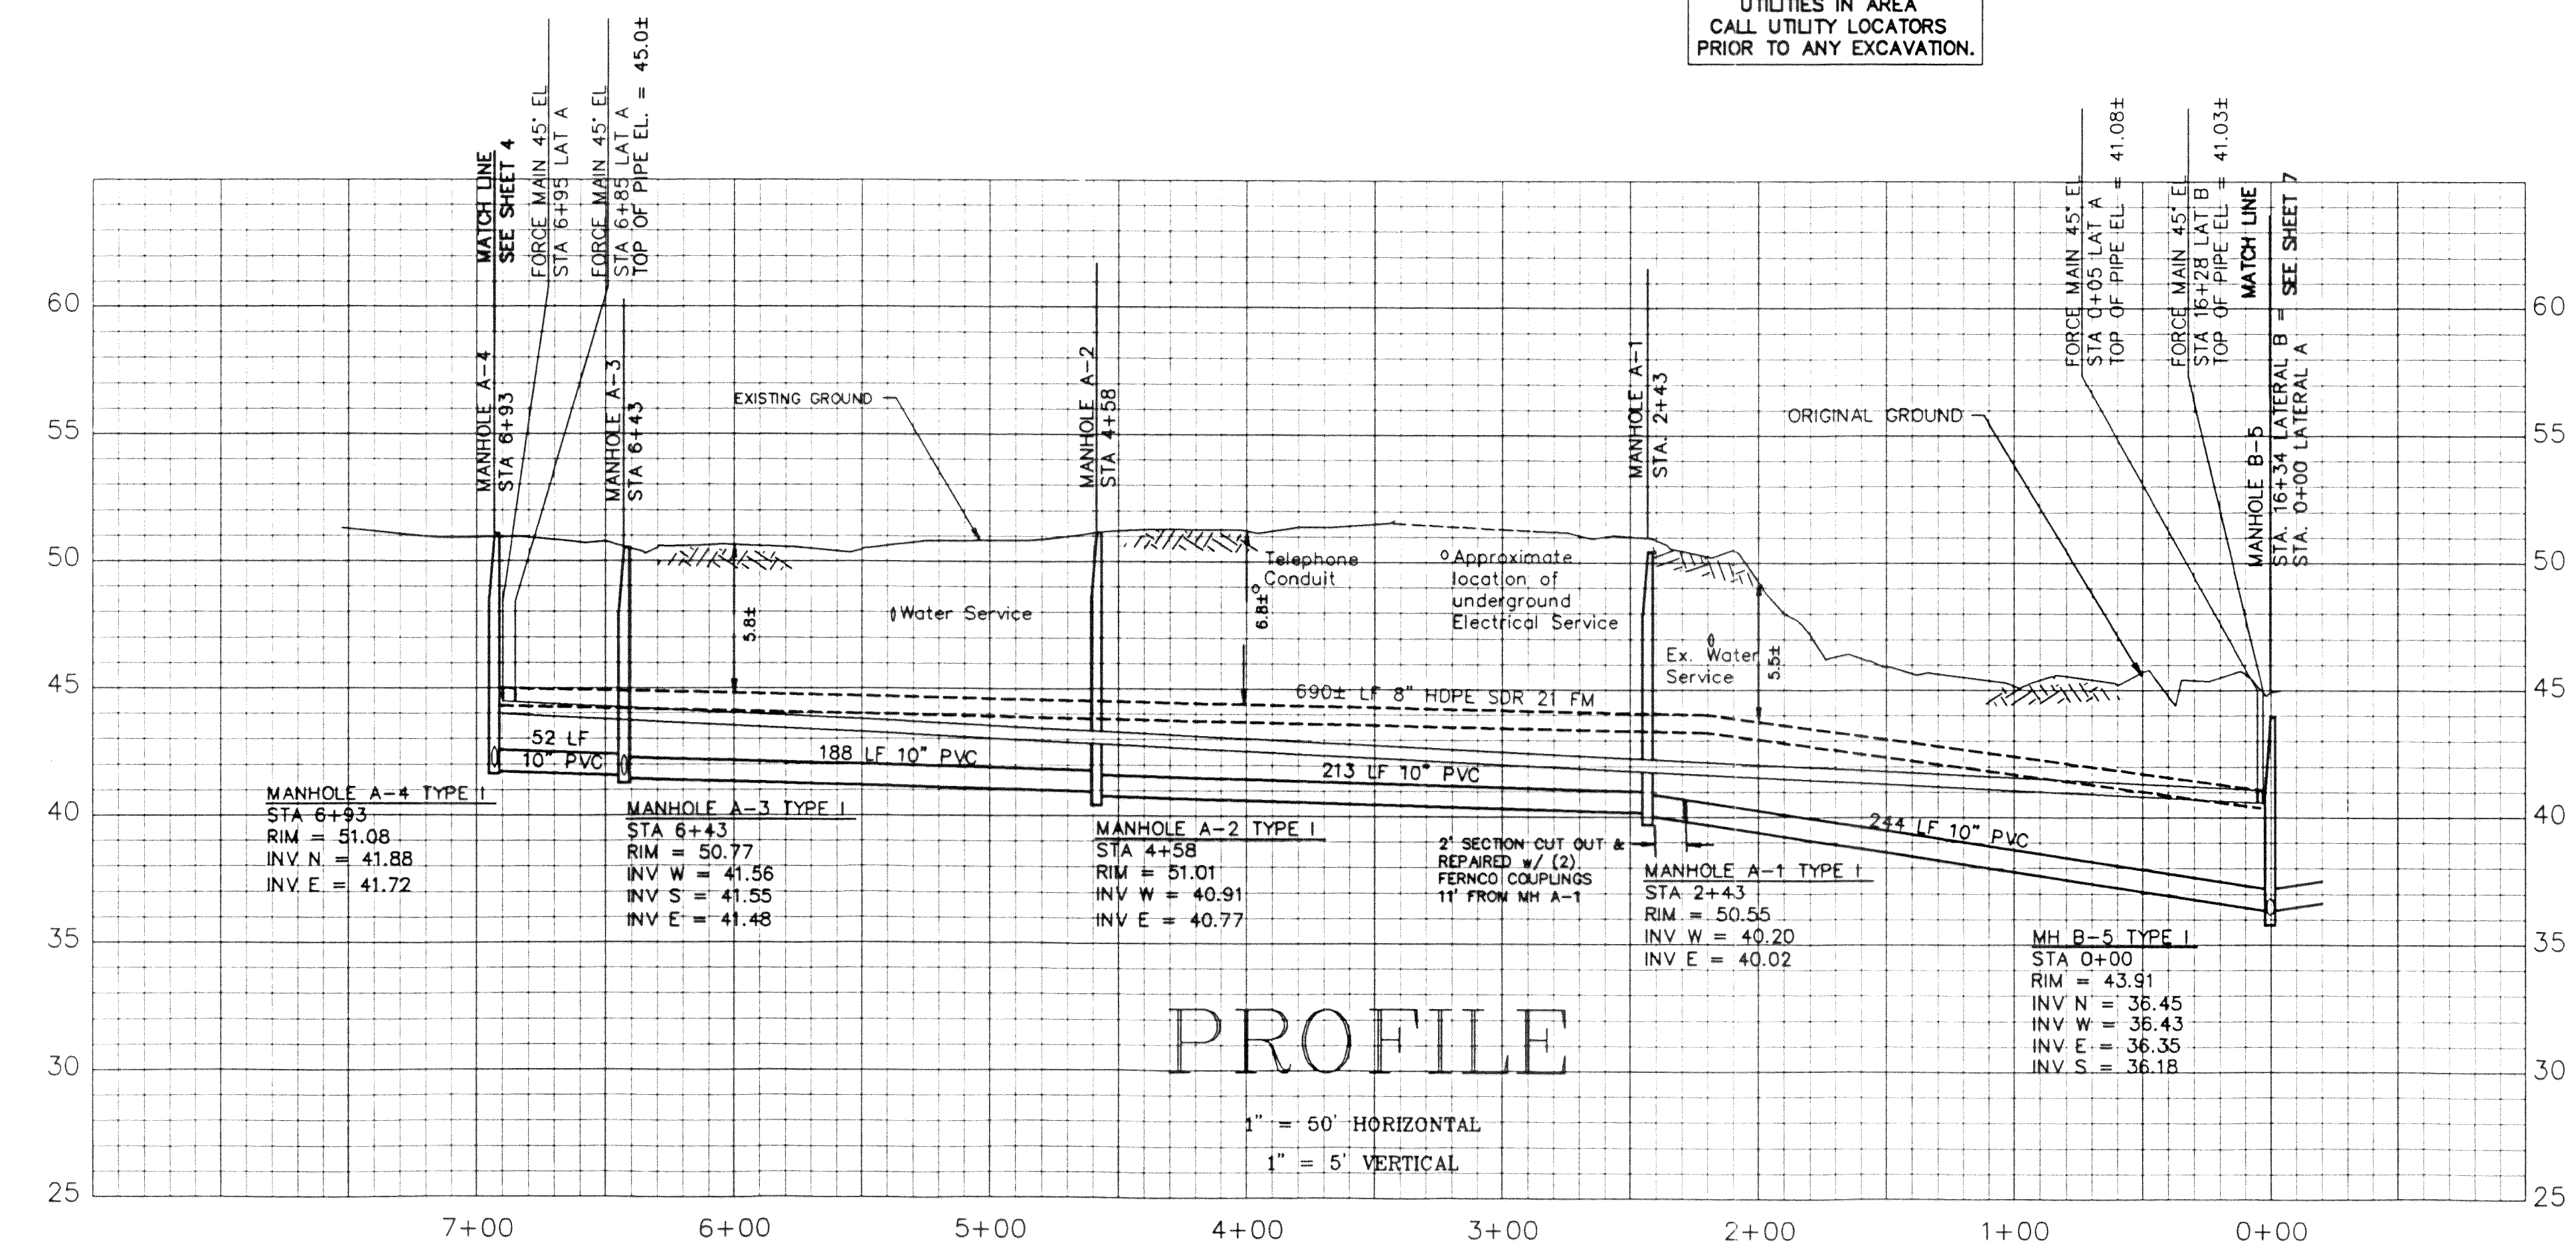

RECORD DRAWING

NO.	REVISIONS	BY	DATE

WEDEN ENGINEERING, INC.
119 GRAND AVENUE, SUITE D,
BELLINGHAM, WA. 98225 671-8200

ONE INCH AT FULL SCALE
IF NOT ONE INCH
SCALE ACCORDINGLY


DESIGNED BY
DRAWN BY
CHECKED BY

CITY OF FERNDAL L.I.D. NO. 8
SANITARY SEWER EXTENSION
PLAN PROFILE STA 0+00 TO STA 6+93
LATERAL A

DATE
10/14/94
SCALE
1"=50'H
1"=5'V
REC. NO.
93022

SHEET
5
OF
17


100103.004 2.8.06 KR

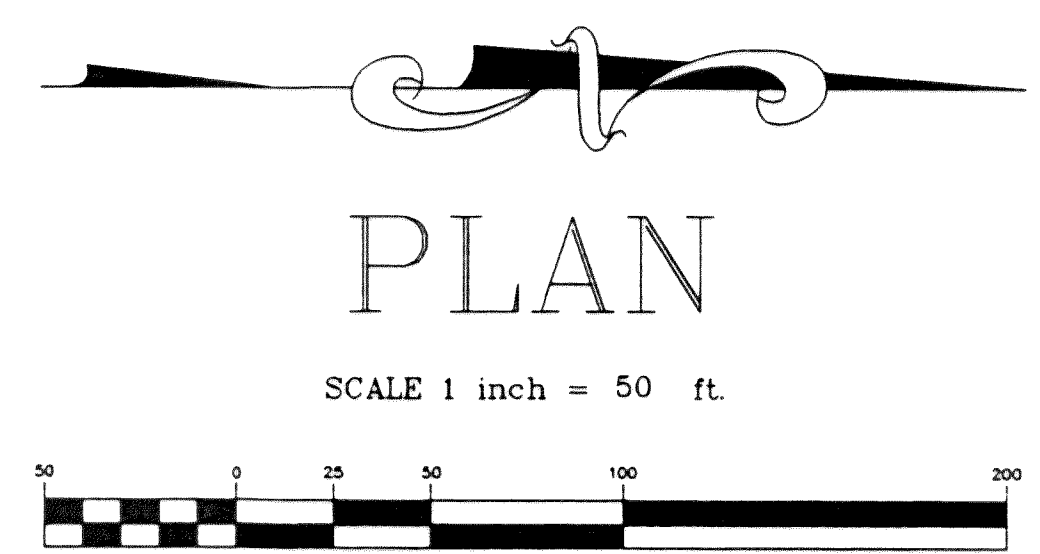

PLAN

SCALE 1 inch = 50 ft.

WARNING!
UTILITIES IN AREA
CALL UTILITY LOCATORS
PRIOR TO ANY EXCAVATION.

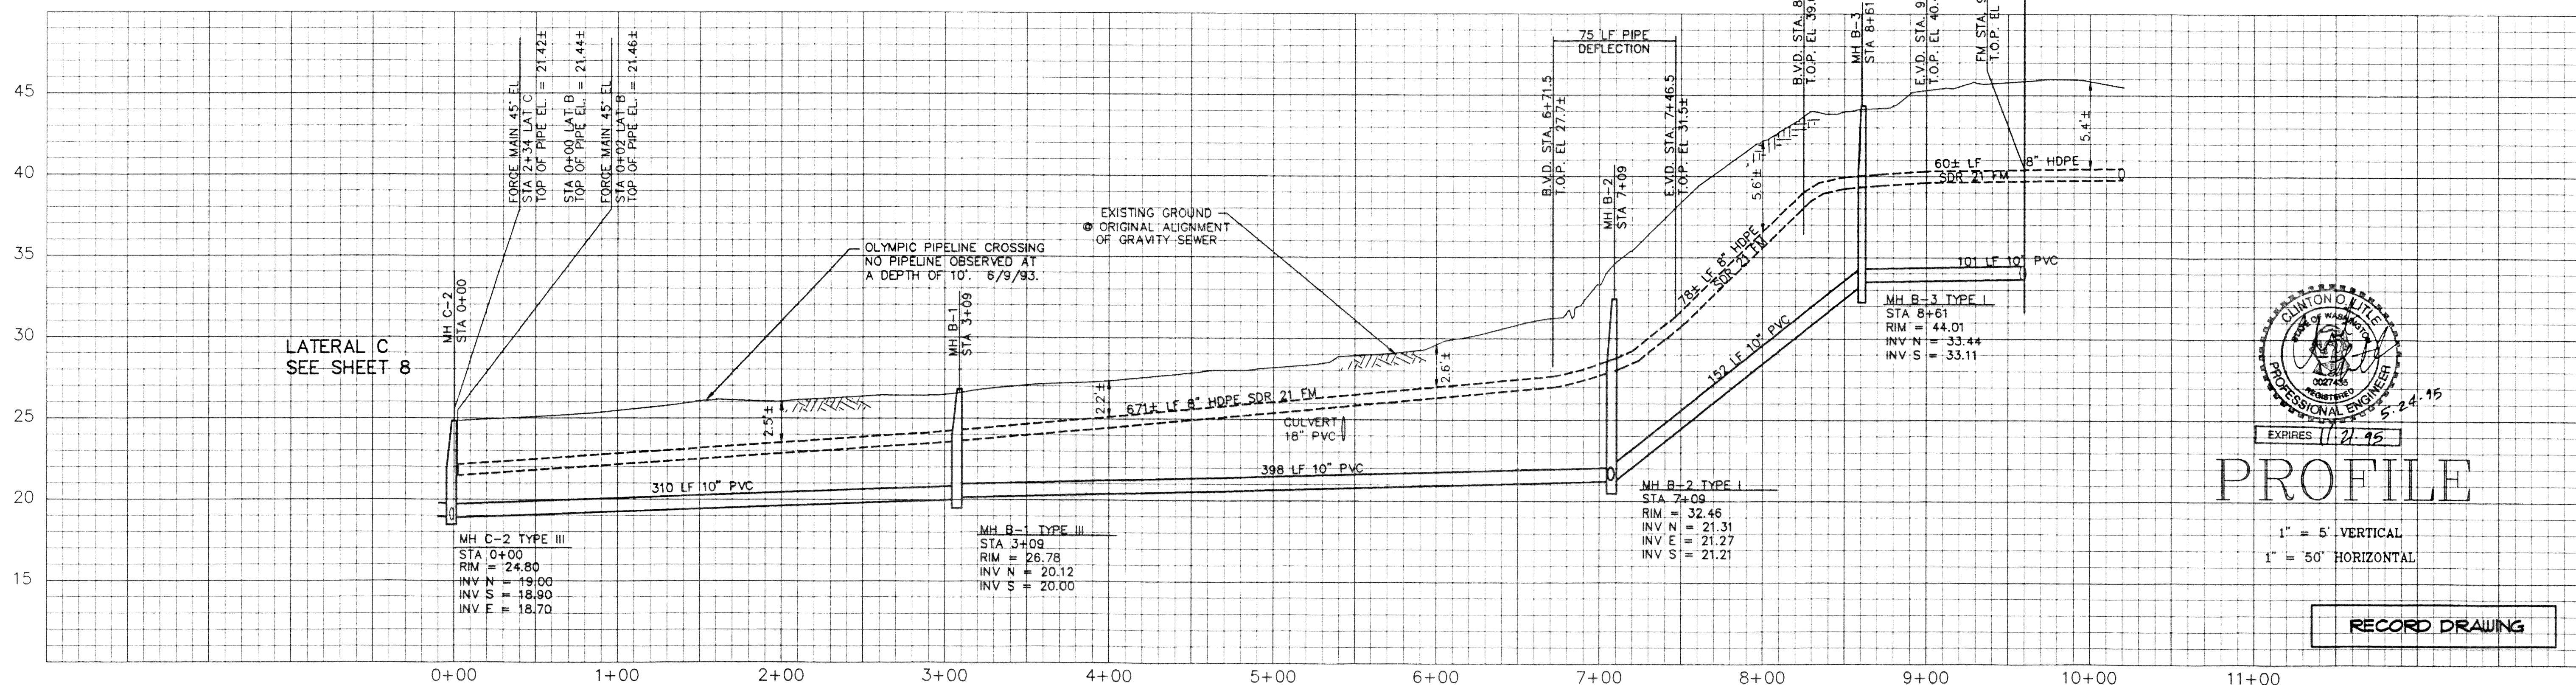


CLINTON O. LITTLE
STATE OF WASHINGTON
0027435
REGISTERED
PROFESSIONAL ENGINEER
EXPIRES 12-95

PROFILE

1" = 5' VERTICAL
1" = 50' HORIZONTAL

RECORD DRAWING

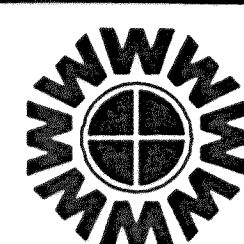

WEDEN ENGINEERING, INC.
119 GRAND AVENUE, SUITE D,
BELLINGHAM, WA. 98225 671-8200

IF NOT ONE INCH
SCALE ACCORDINGLY

ILW


CITY OF FERNDALE L.I.D. NO. 8
SANITARY SEWER EXTENSION
 PLAN PROFILE - STA 0+00 TO STA 9+60
 LATERAL B and FORCE MAIN

C:\DWG\3022RD6A 11/15/94 10:24

93022




"

NO.	REVISIONS	BY	DATE
-----	-----------	----	------

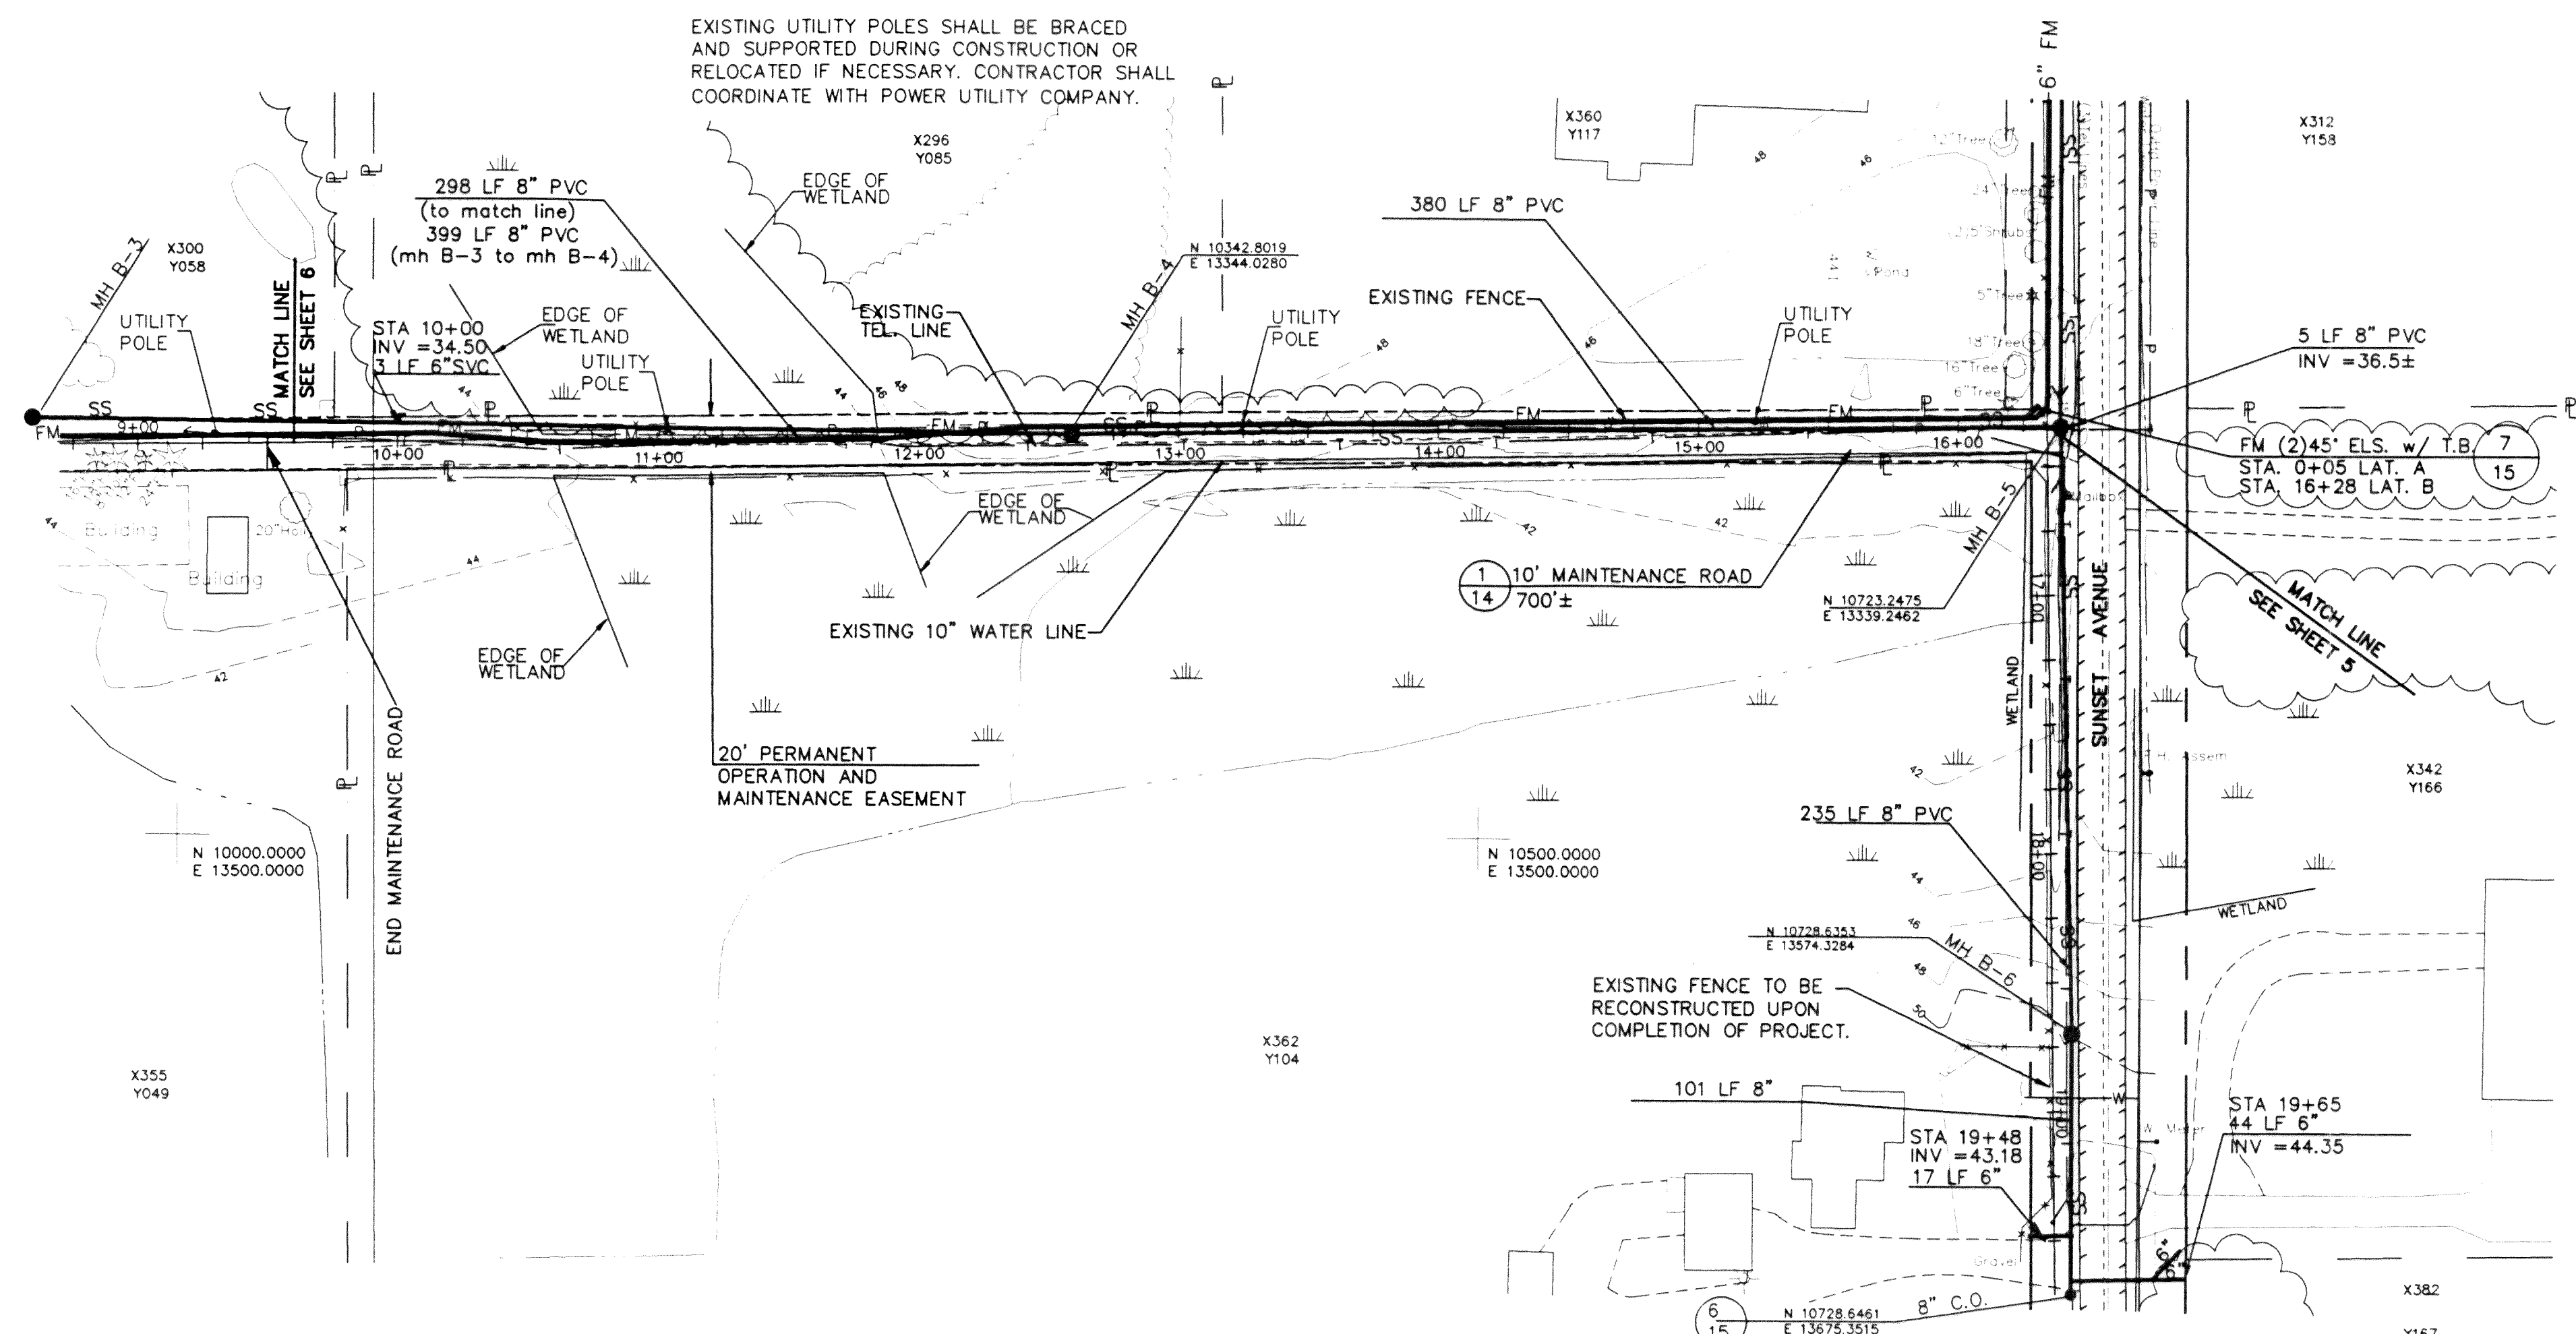

NOTE:
SIDE SEWER INVERT ELEVATIONS
GIVEN ARE APPROXIMATE, I.E. $\pm 0.5'$.

WARNING!
UTILITIES IN AREA
CALL UTILITY LOCATORS
PRIOR TO ANY EXCAVATION.

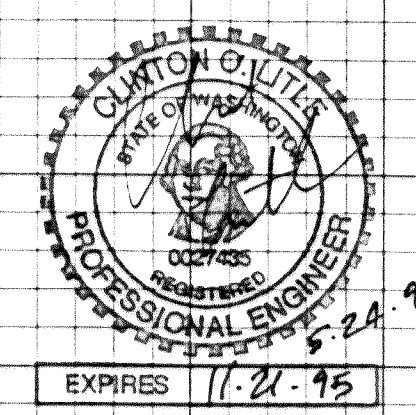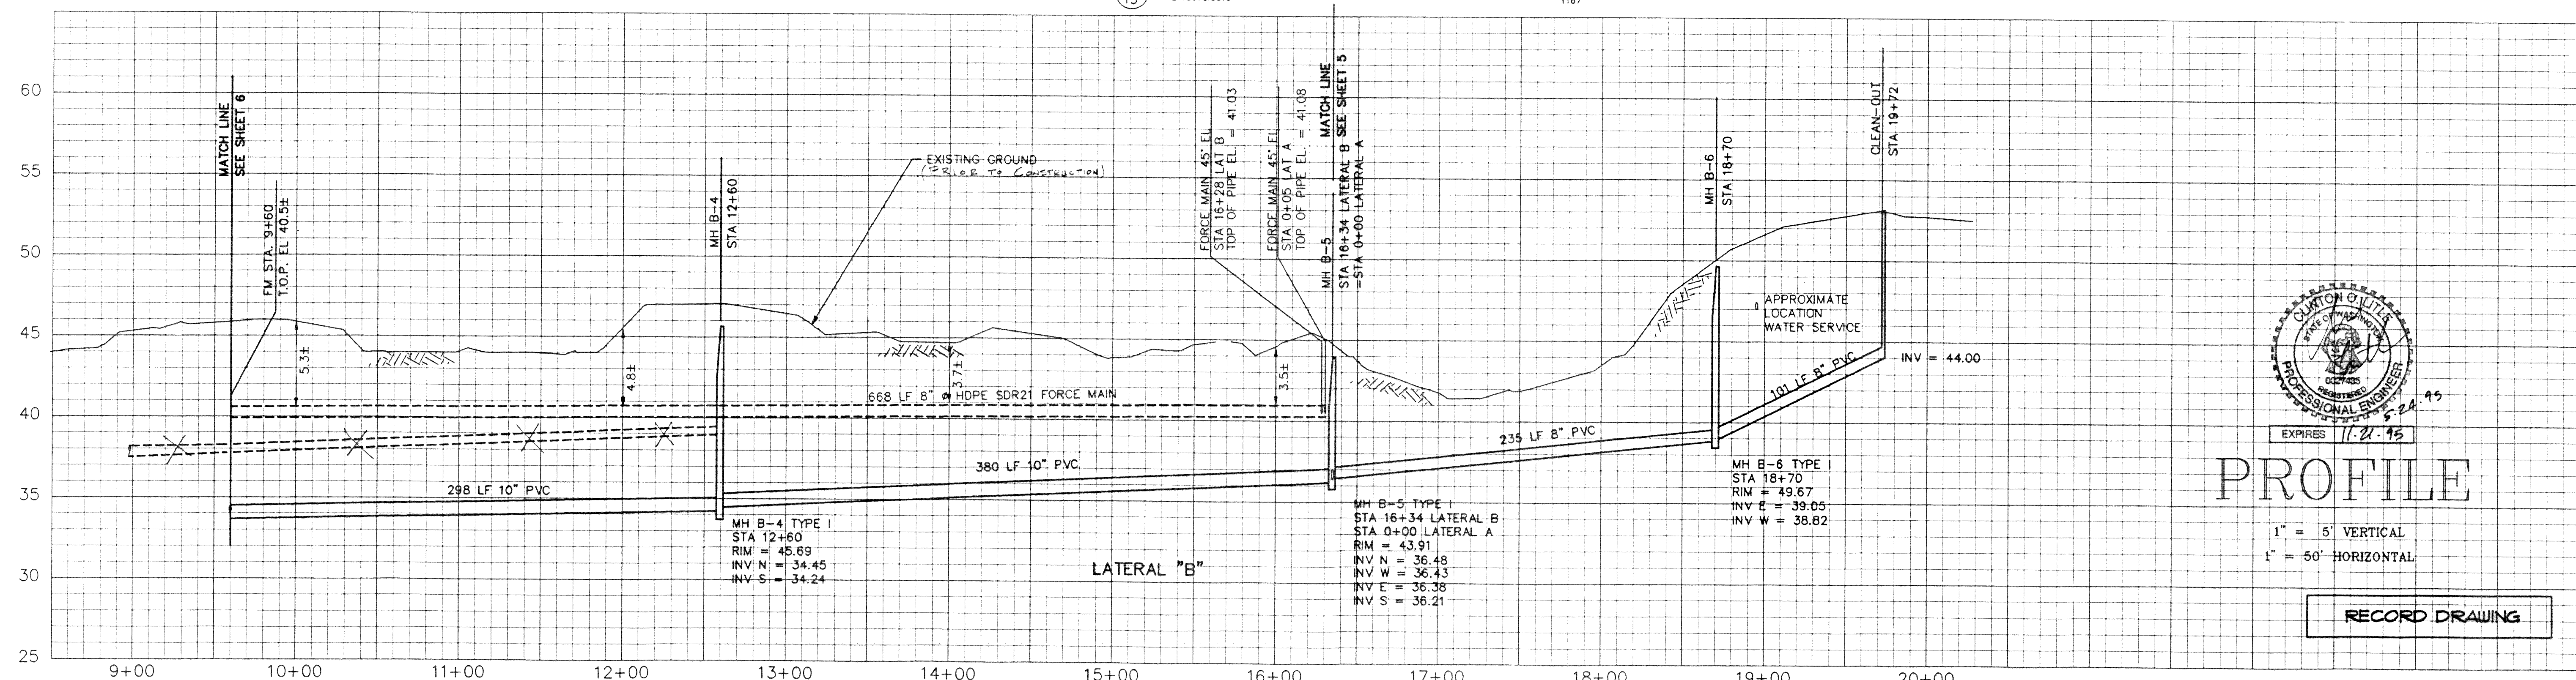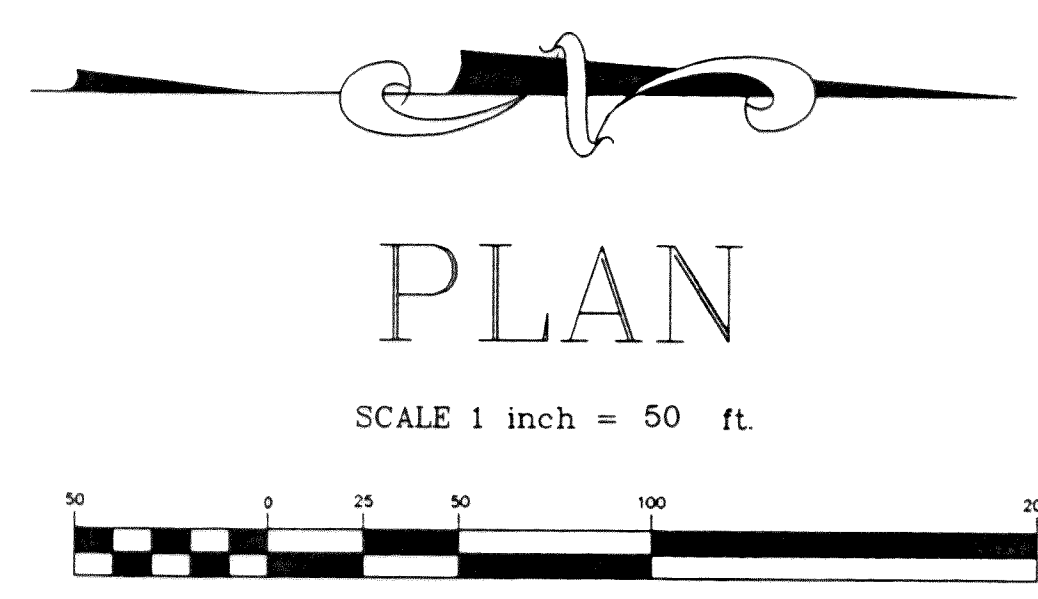

PROFILE
1" = 5' VERTICAL
1" = 50' HORIZONTAL

RECORD DRAWING


NO.	REVISIONS	BY	DATE

WEDEN ENGINEERING, INC.
119 GRAND AVENUE, SUITE D,
BELLINGHAM, WA. 98225 671-8200

DESIGNED BY	
DRAWN BY	
CHECKED BY	

CITY OF FERNDALE L.I.D. NO. 8
SANITARY SEWER EXTENSION
PLAN PROFILE STA 9+60 TO STA 19+75
LATERAL B and FORCE MAIN

DATE	10/14/94	SHEET	7
SCALE	1"=50' H 1"=5' V	OF	17
REC. NO.	93022		

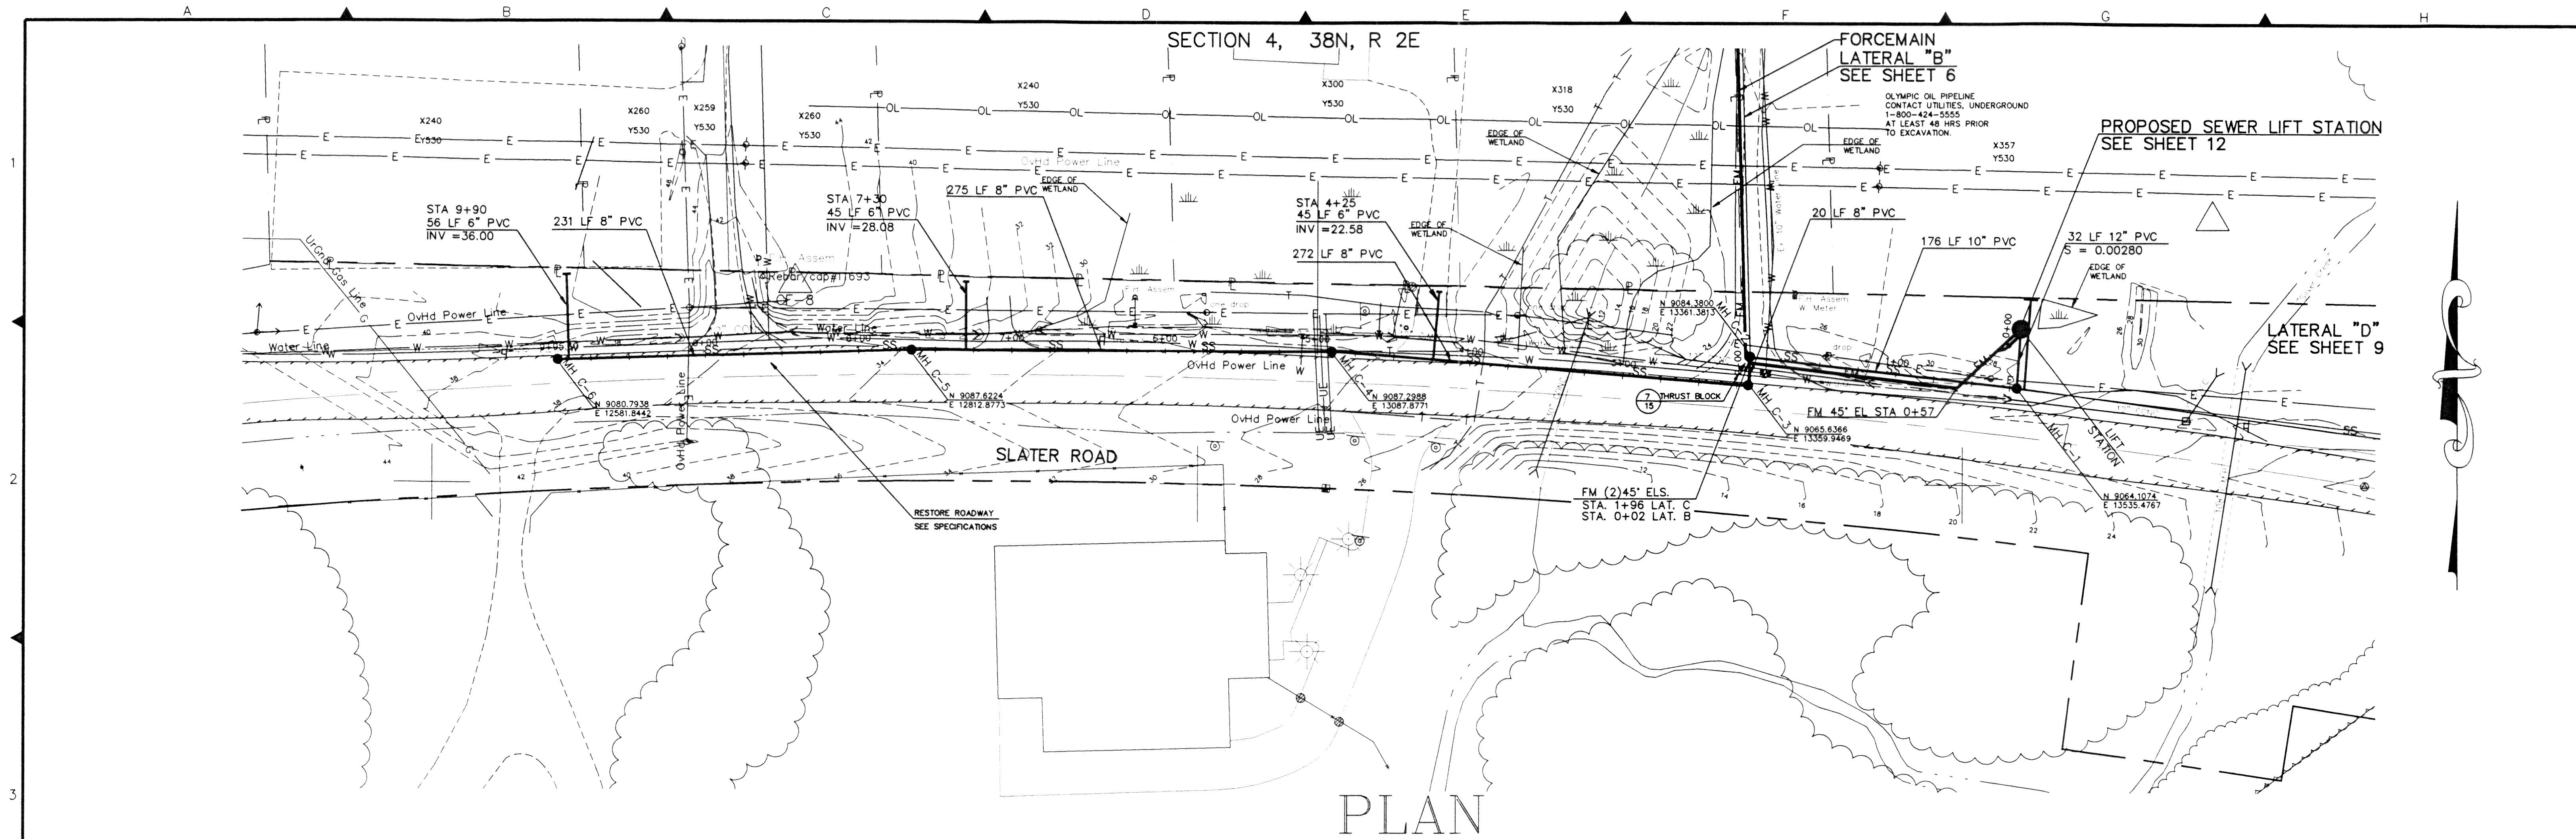


PLAN

WARNING!
UTILITIES IN AREA
CALL UTILITY LOCATORS
PRIOR TO ANY EXCAVATION.

SCALE 1 inch = 50 ft.




NOTE:
SIDE SEWER INVERT ELEVATIONS
GIVEN ARE APPROXIMATE, I.E. ±0.5'.

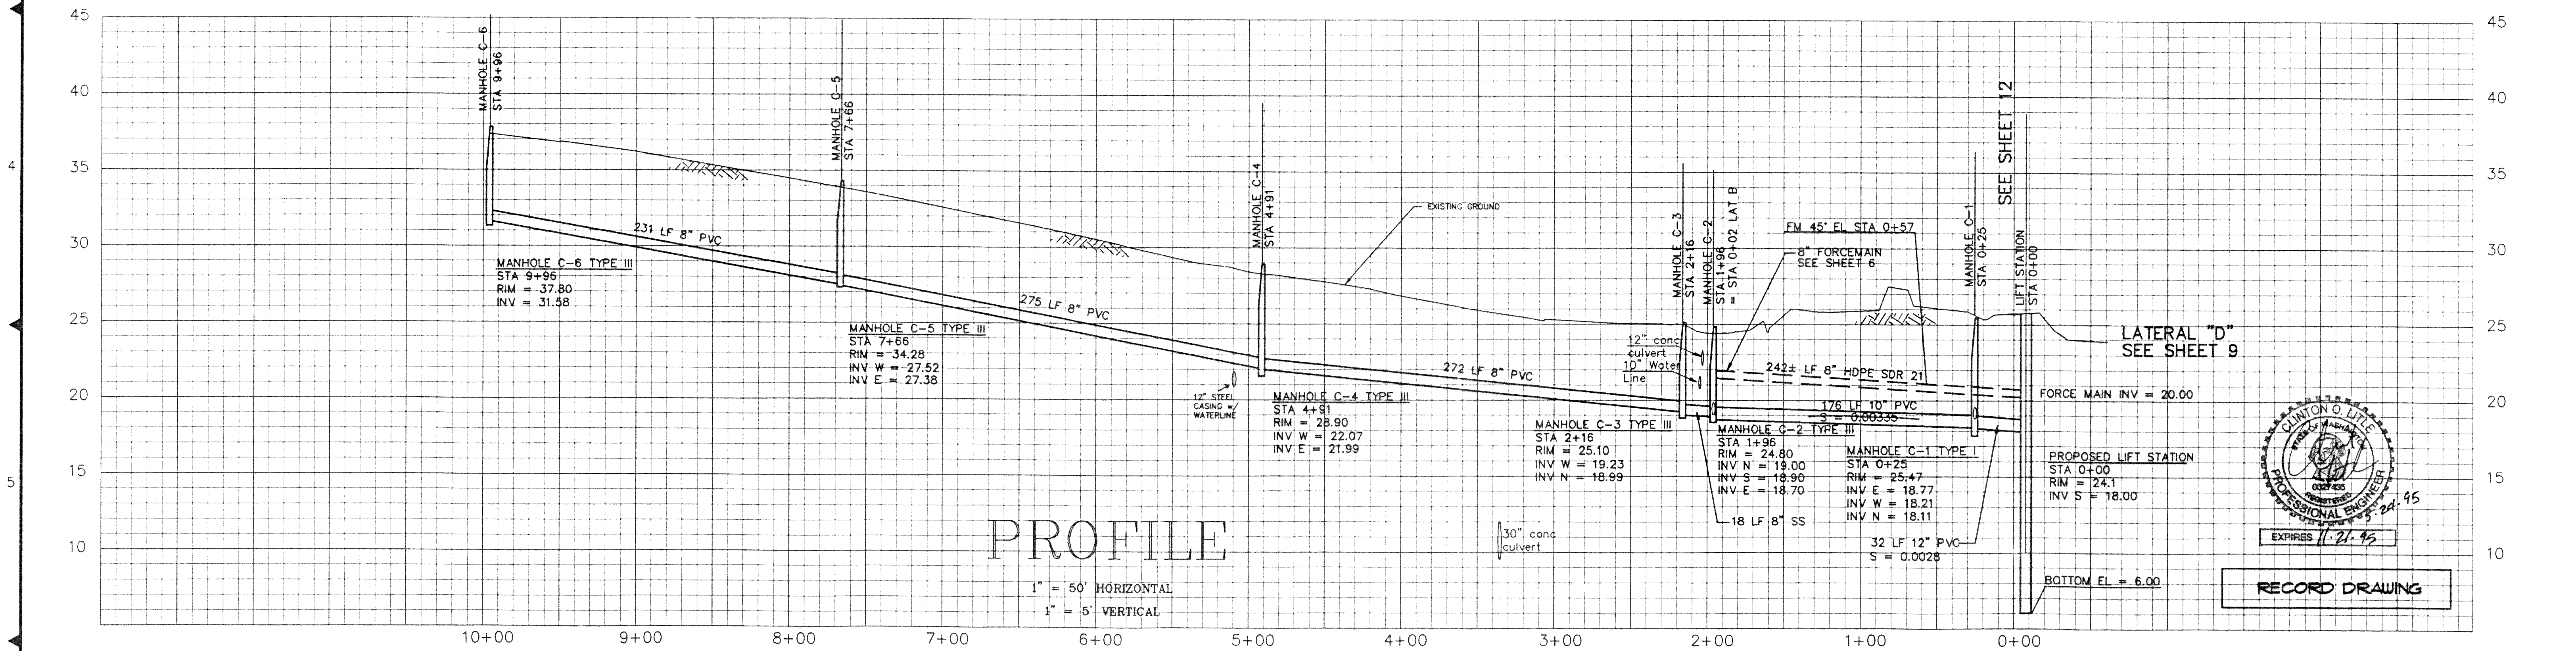


PROFILE

1" = 50' HORIZONTAL
1" = 5' VERTICAL

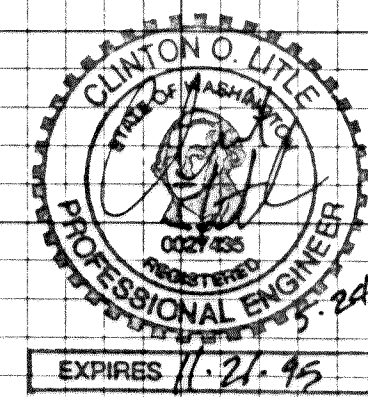

RECORD DRAWING

NO.	REVISIONS	BY	DATE

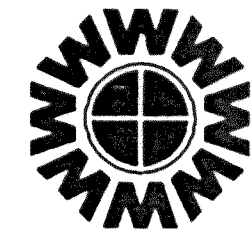




WEDEN ENGINEERING, INC.
119 GRAND AVENUE, SUITE D,
BELLINGHAM, WA. 98225 671-8200

ONE INCH AT FULL SCALE
IF NOT ONE INCH
SCALE ACCORDINGLY

DESIGNED BY
DRAWN BY
CHECKED BY

CITY OF FERNDALE L.I.D. NO. 8
SANITARY SEWER EXTENSION
PLAN PROFILE STA 0+00 TO STA 10+36
LATERAL C

C:\DWG\3022RD8A	01/04/95	15:24
DATE 10/14/94	SCALE 1"=50'H 1"=5'V	SHEET 8 OF 17
REC. NO. 93022		

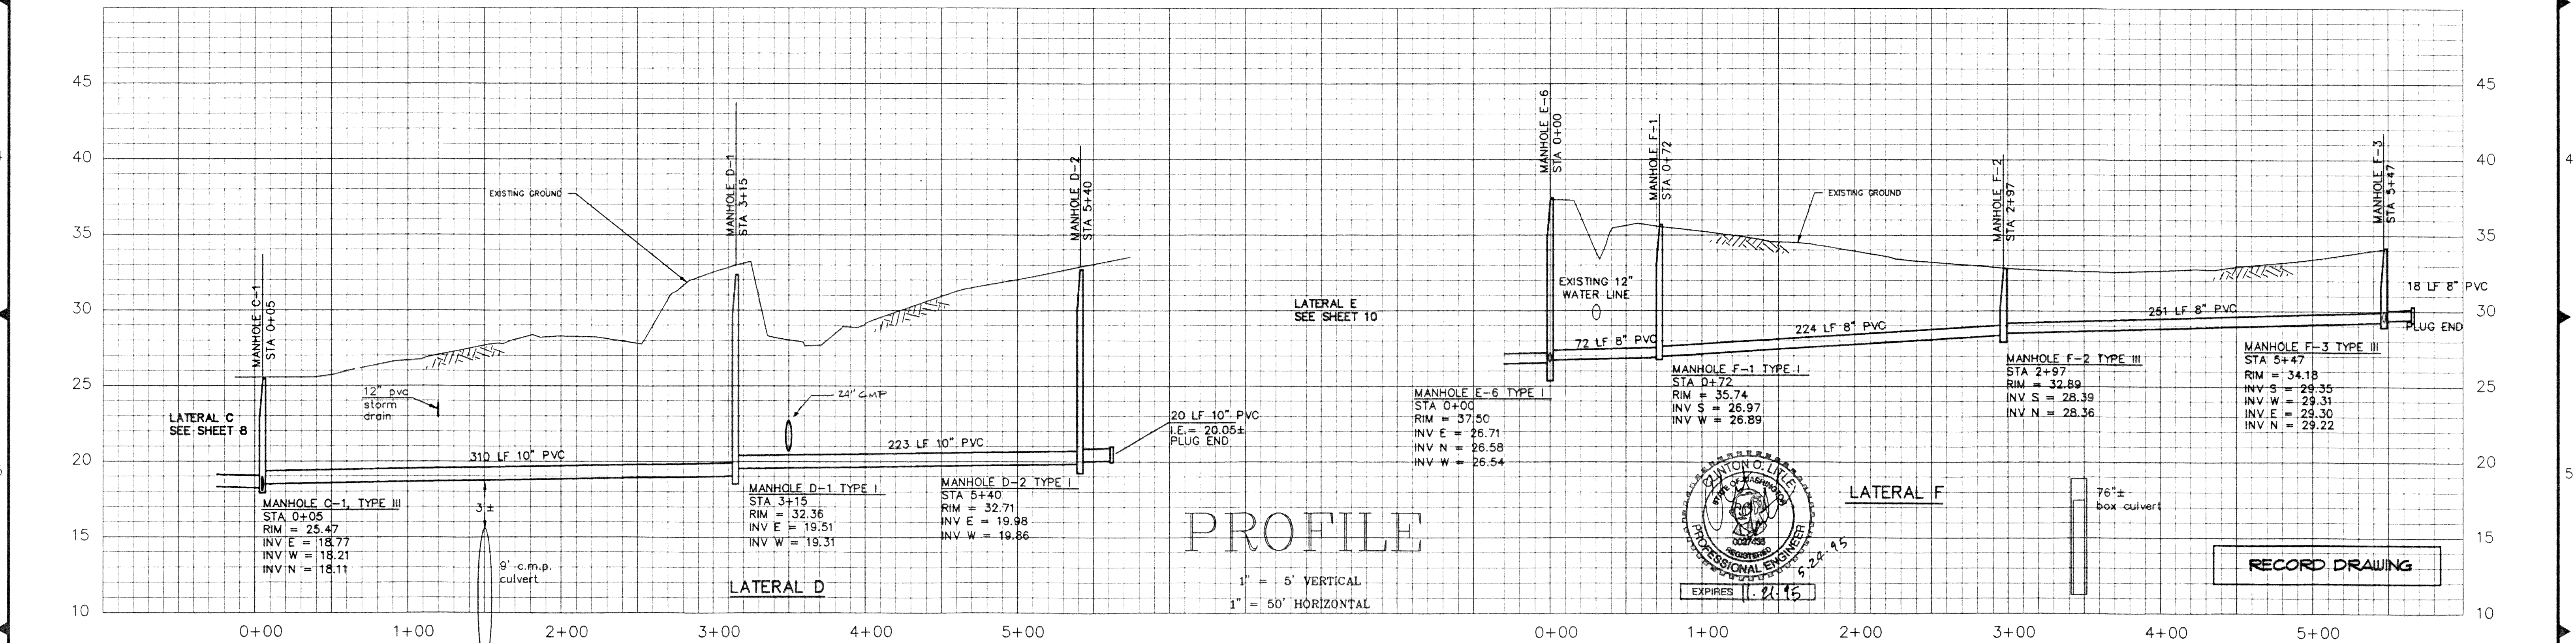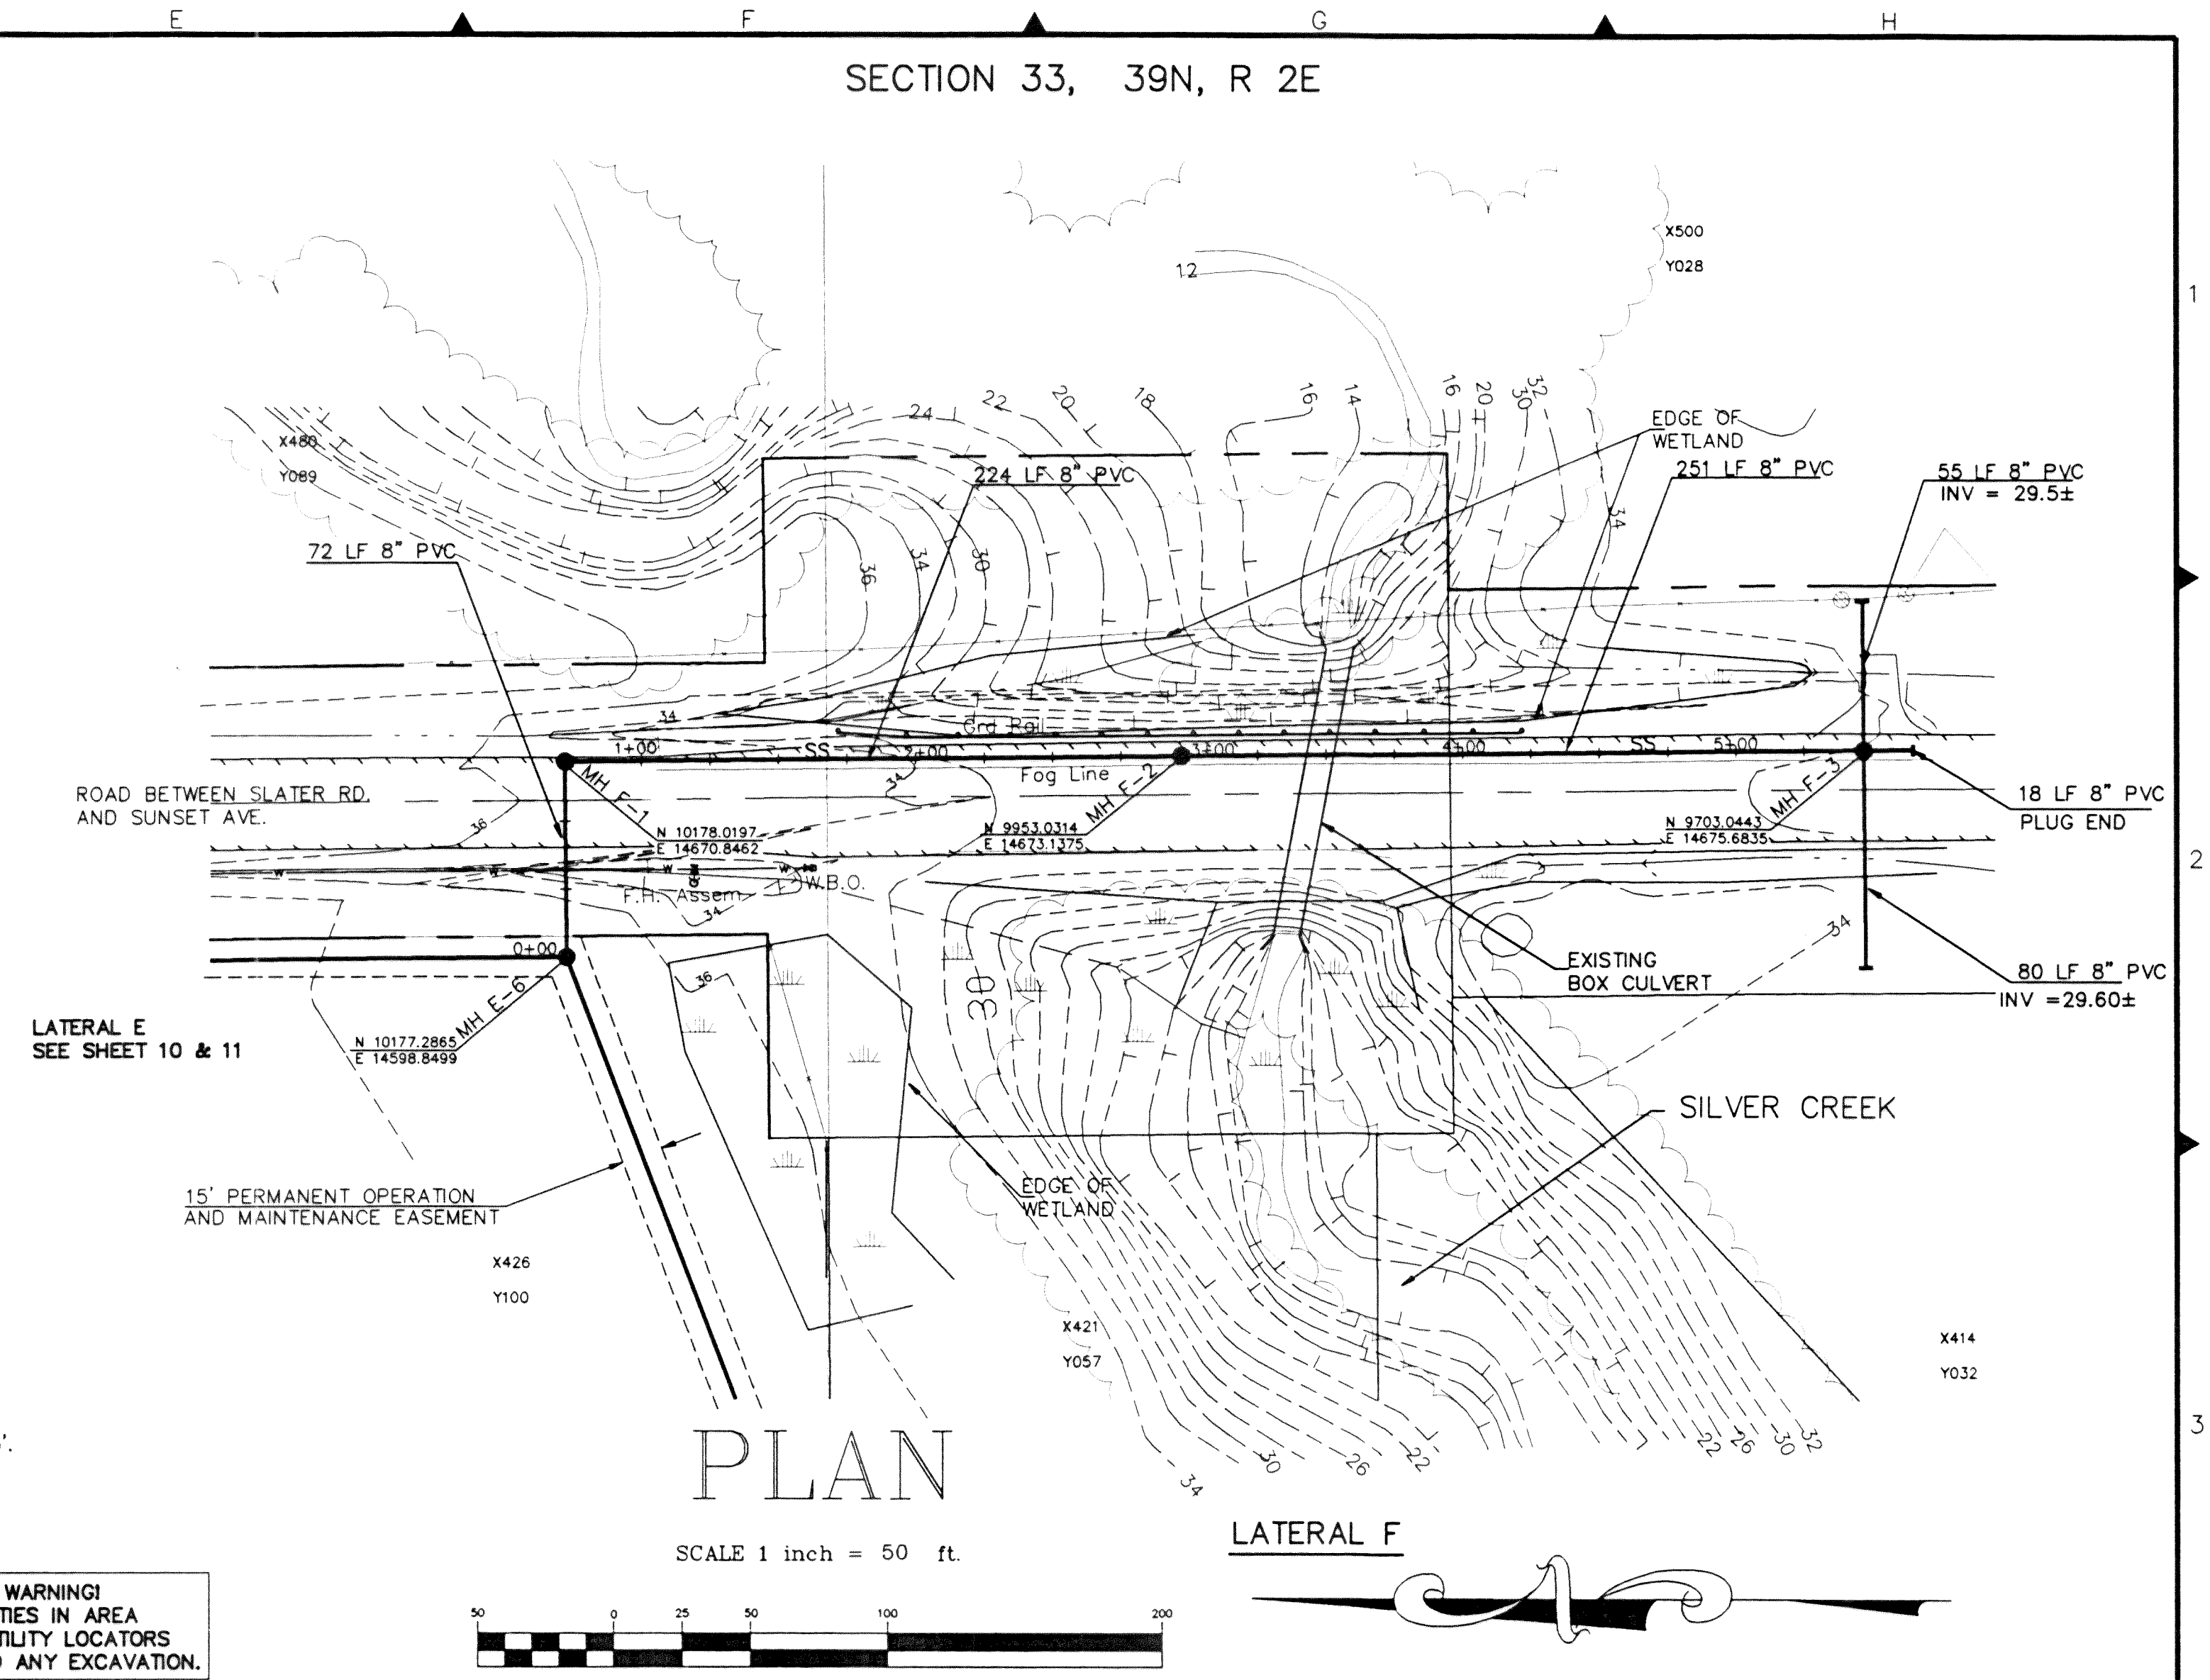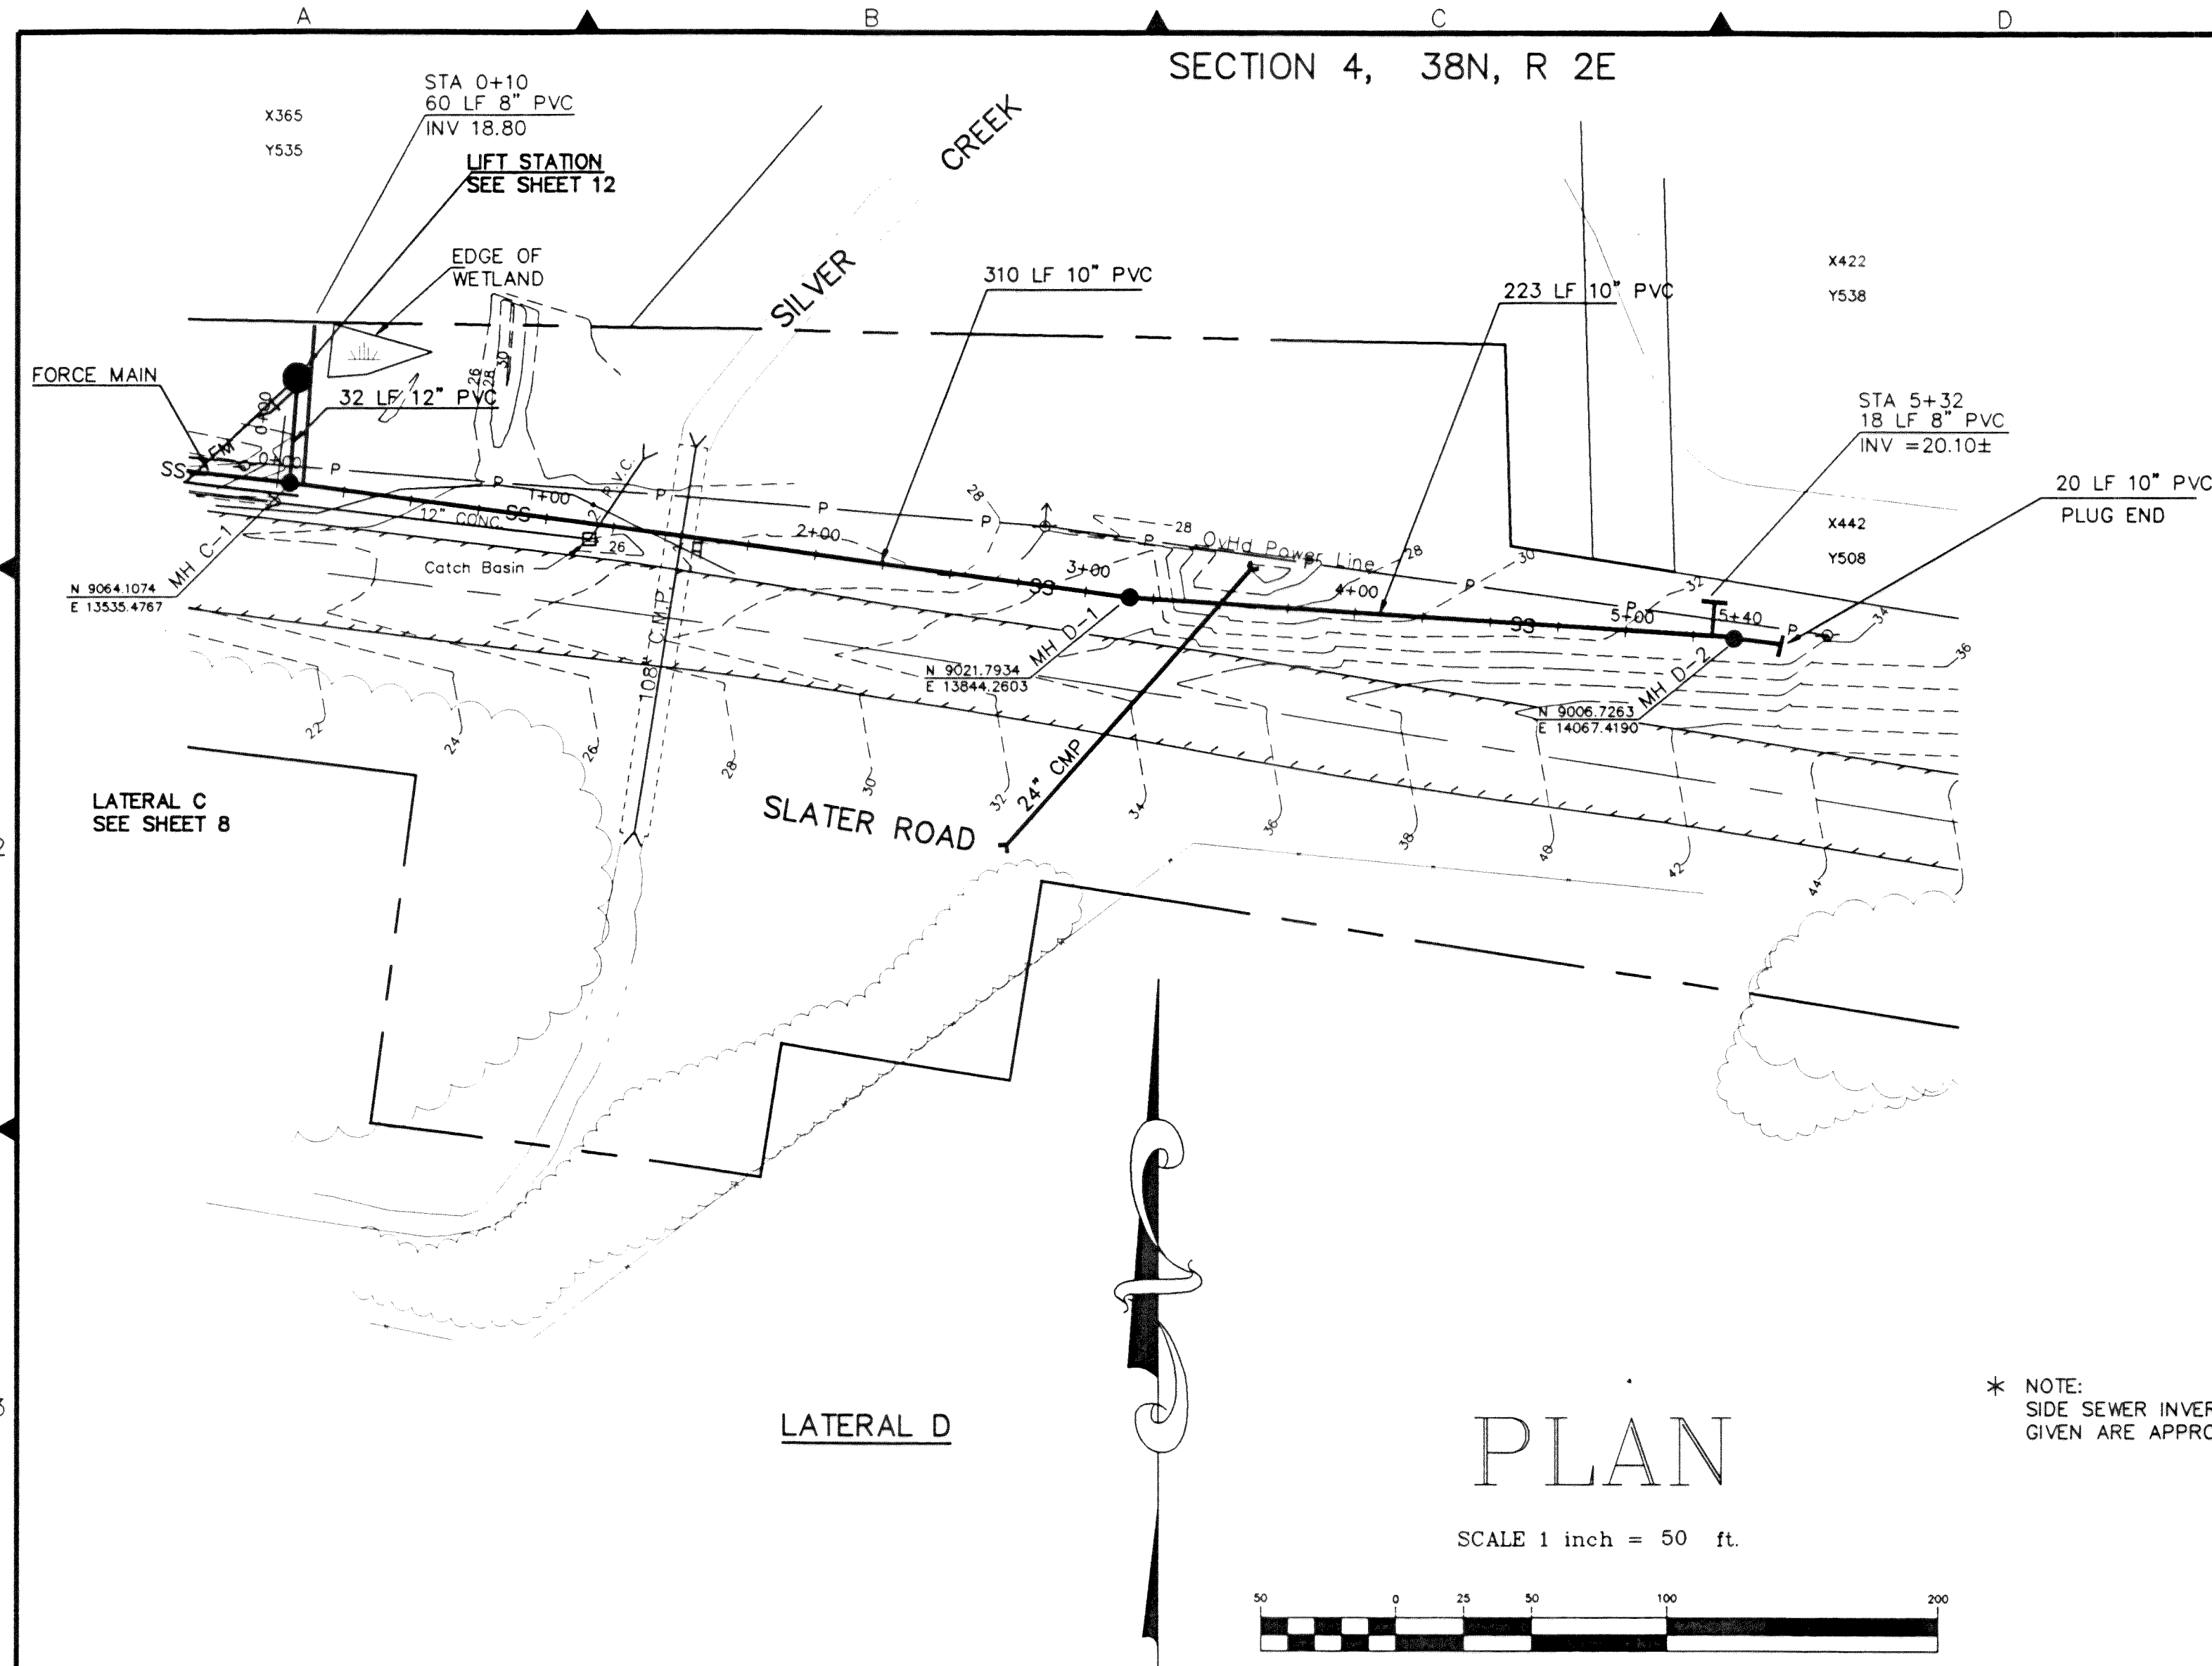

SECTION 33, 39N, R 2E

LATERAL B
SEE SHEET 6



LATERAL F
SEE SHEET 9

LATERAL E

WARNING!
UTILITIES IN AREA
CALL UTILITY LOCATORS
PRIOR TO ANY EXCAVATION.

PLAN

SCALE 1 inch = 50 ft.

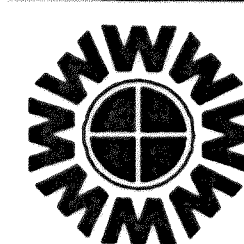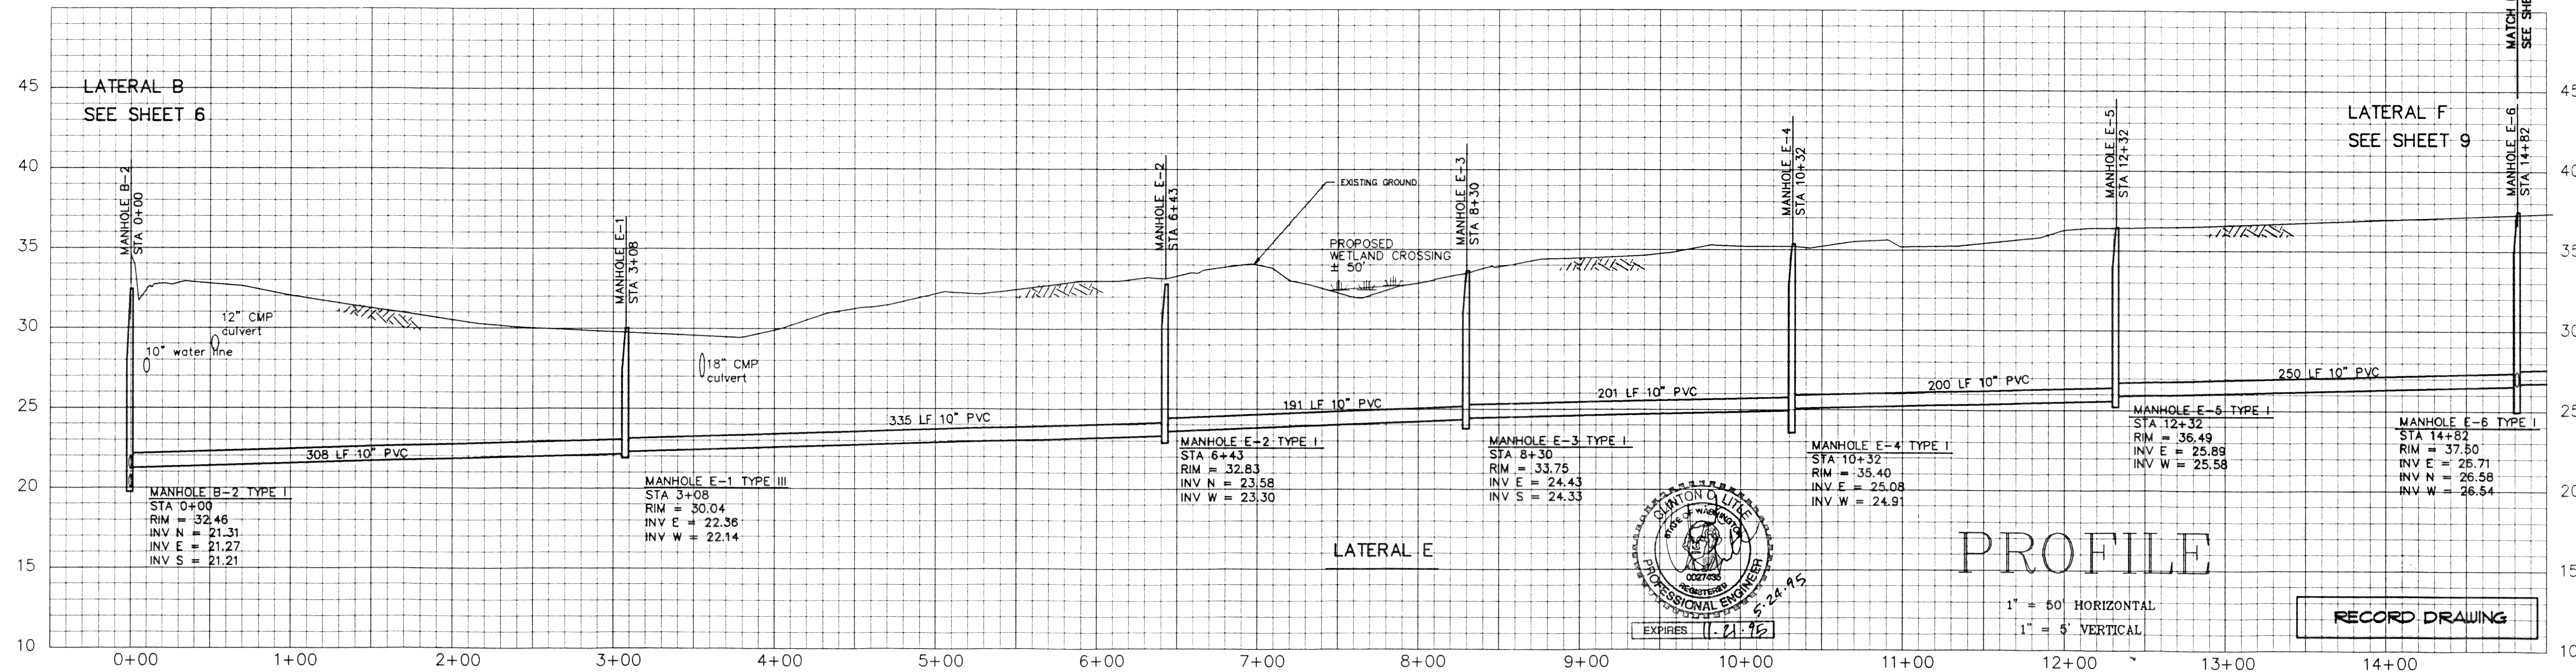

WEDEN ENGINEERING, INC.
119 GRAND AVENUE, SUITE D,
BELLINGHAM, WA. 98225 671-8200

ONE INCH AT FULL SCALE

IF NOT ONE INCH
SCALE ACCORDINGLY


DESIGNED BY

DRAWN BY

CHECKED BY

CITY OF FERNDALE L.I.D. NO. 8
SANITARY SEWER EXTENSION
PLAN PROFILE STA 0+00 TO STA 14+82
LATERAL E

DATE 10/14/94
SCALE 1"=50'H
1"=5'V
REC. NO. 93022
SHEET 10 OF 17

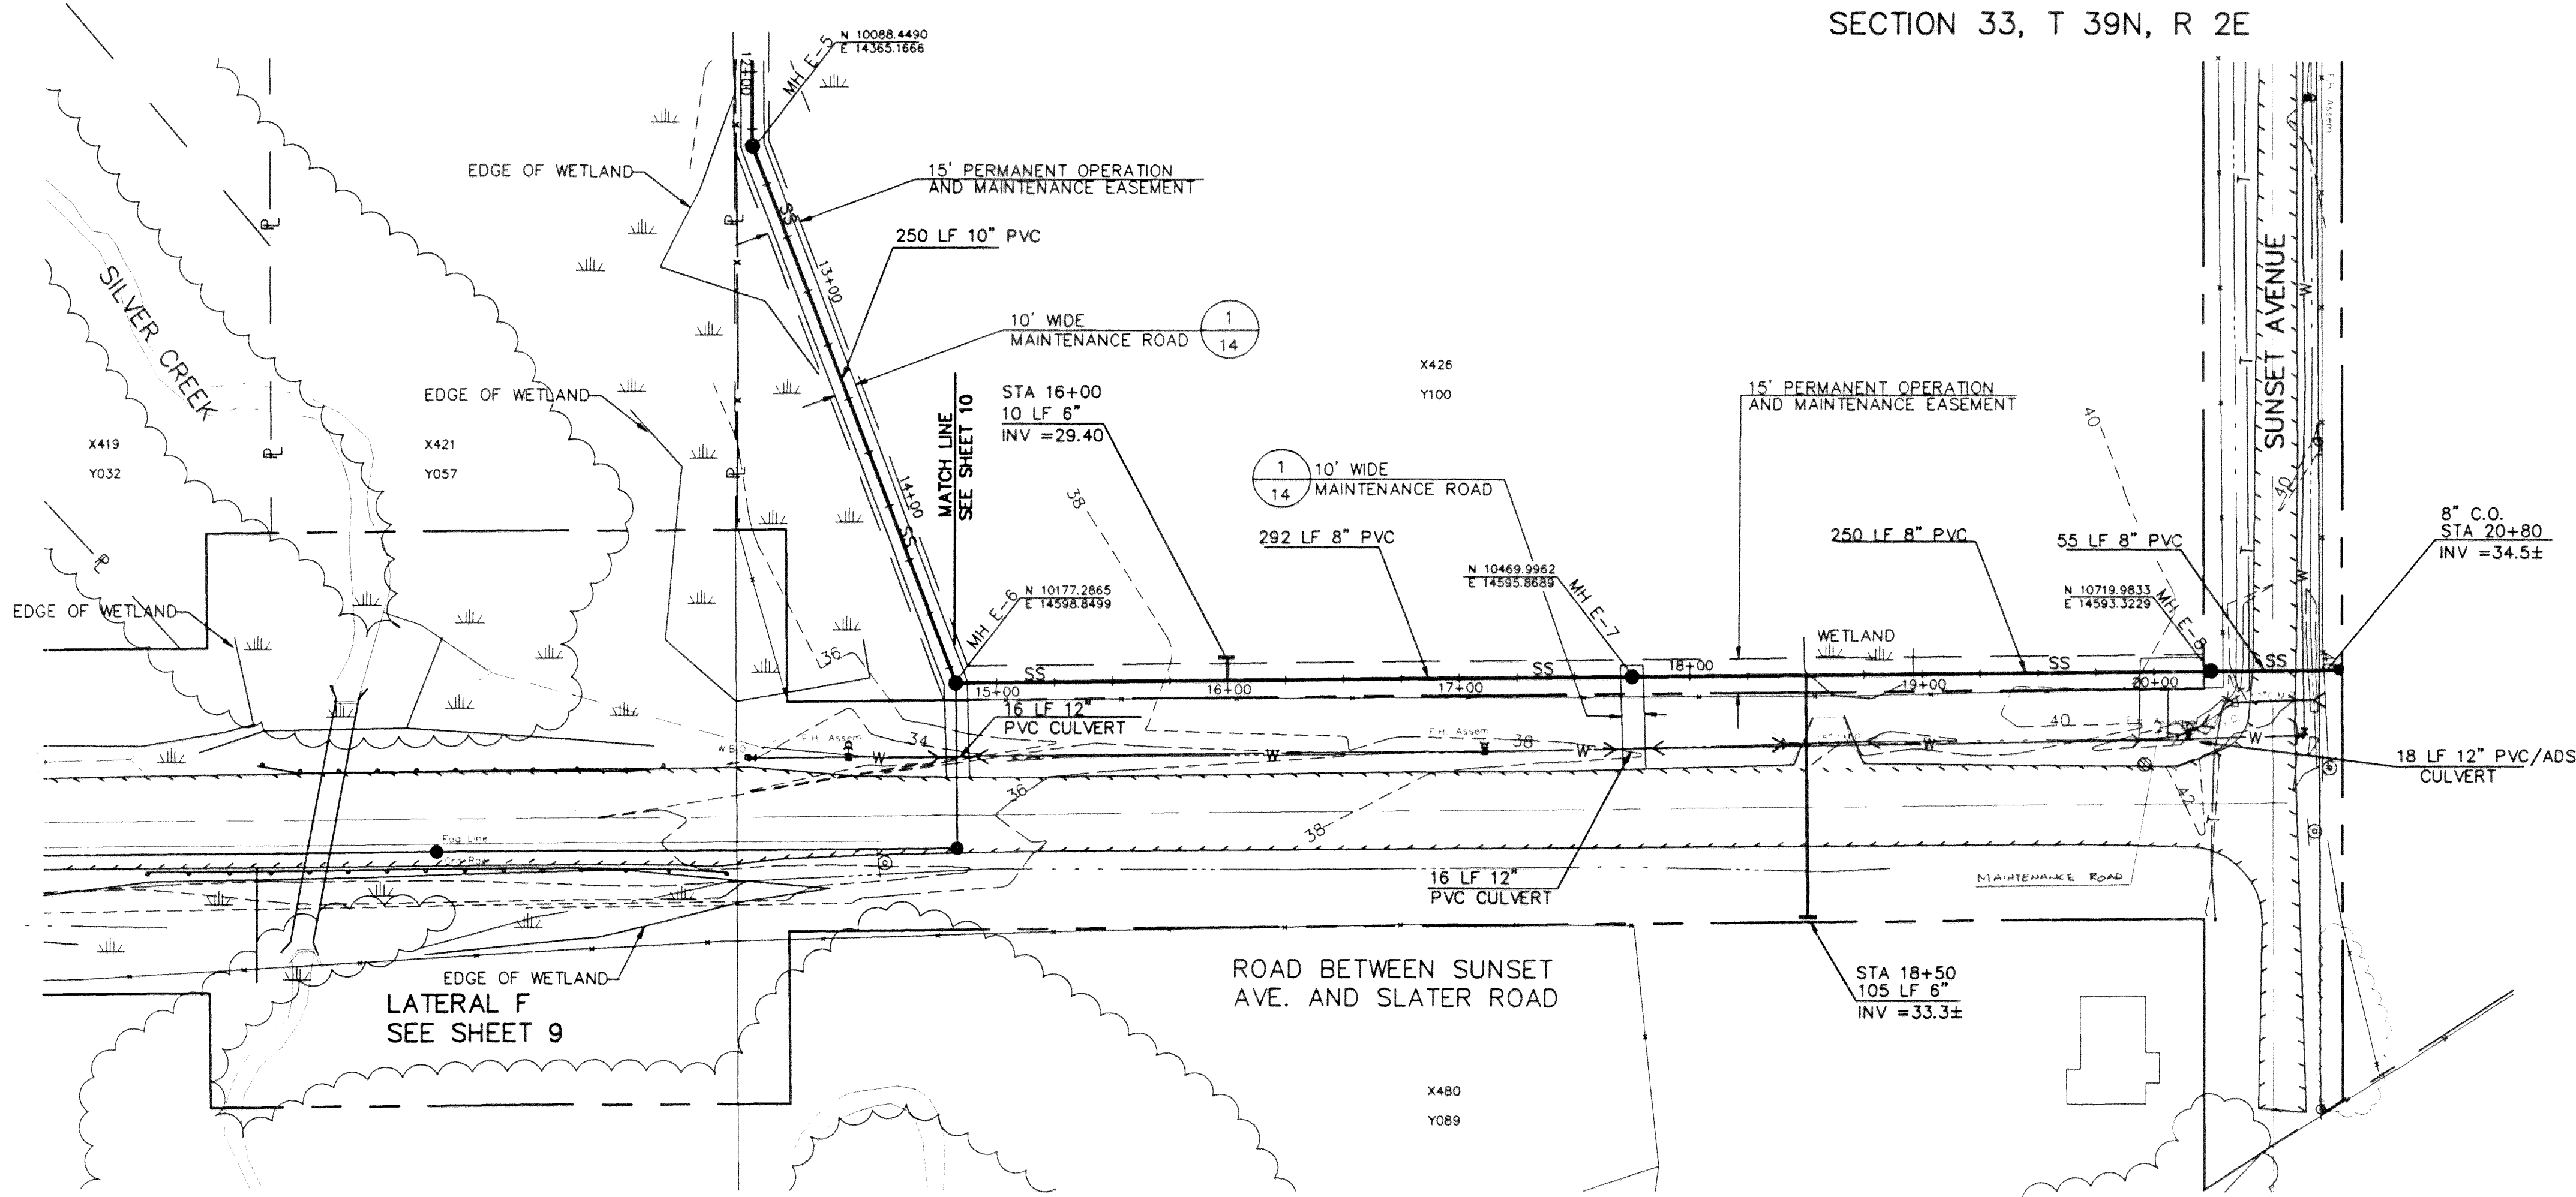


PLAN

SCALE 1 inch = 50 ft.


NOTE:
SIDE SEWER INVERT ELEVATIONS
GIVEN ARE APPROXIMATE, I.E. ±0.5'.

WARNING!
UTILITIES IN AREA
CALL UTILITY LOCATORS
PRIOR TO ANY EXCAVATION.

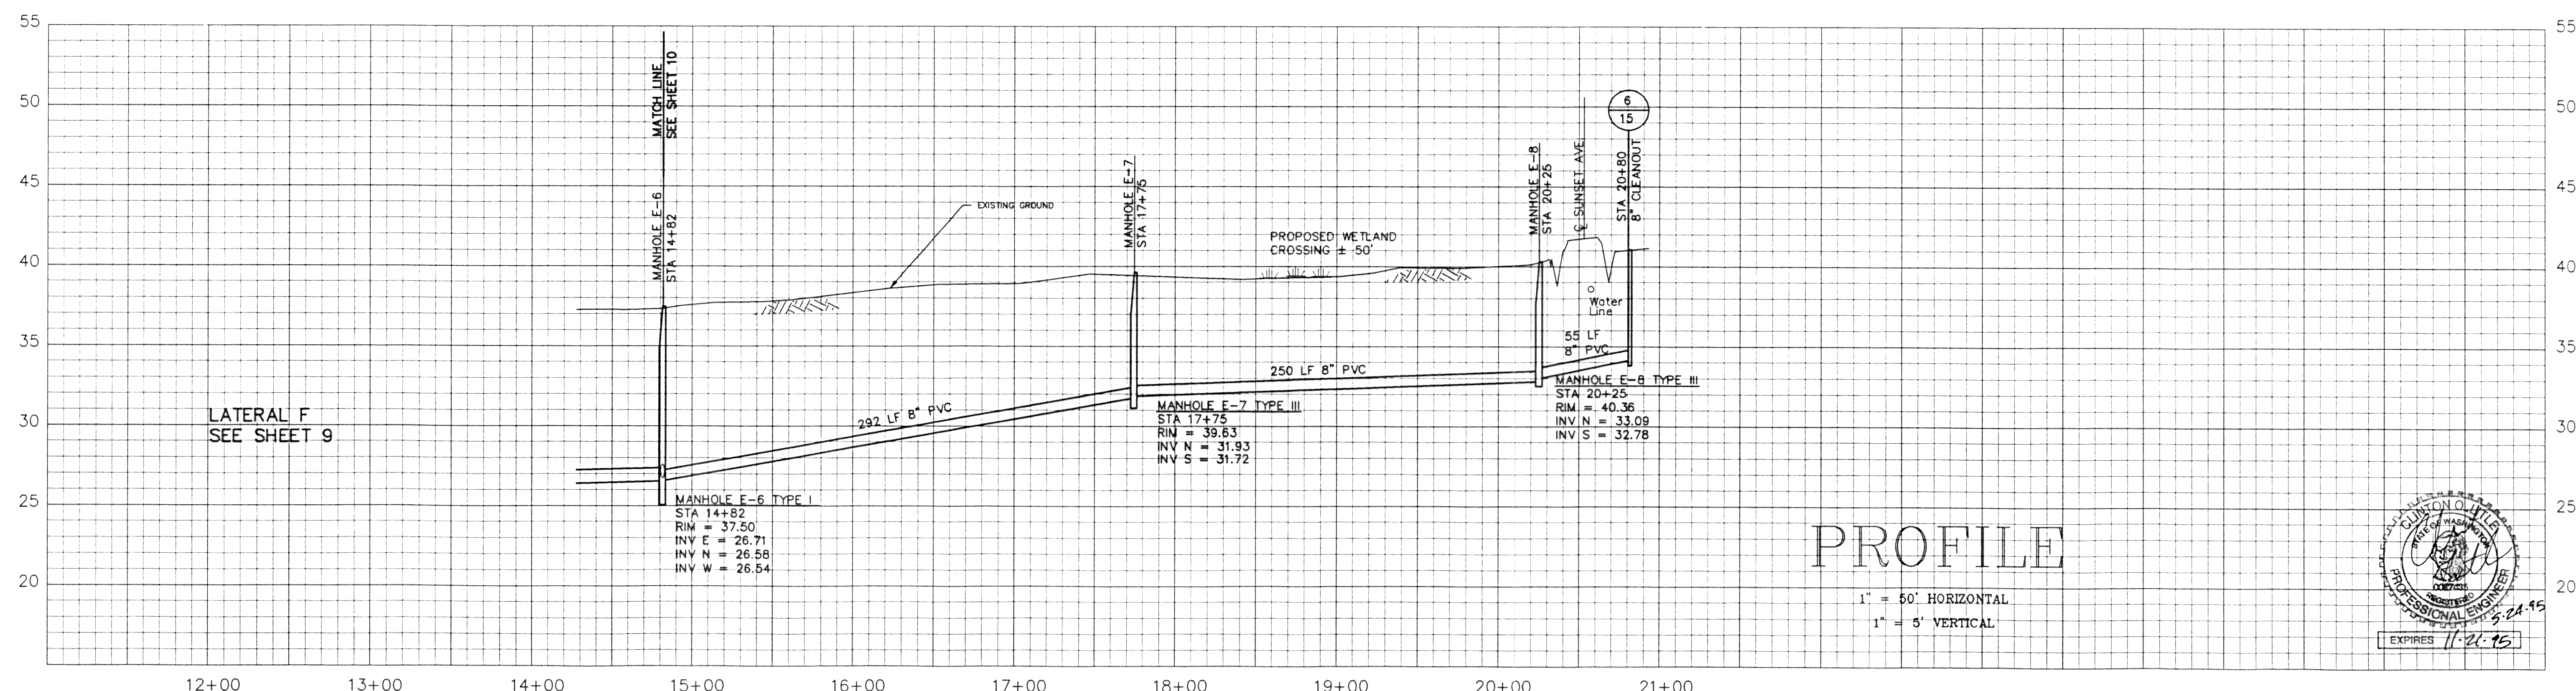

PROFILE

1" = 50' HORIZONTAL
1" = 5' VERTICAL

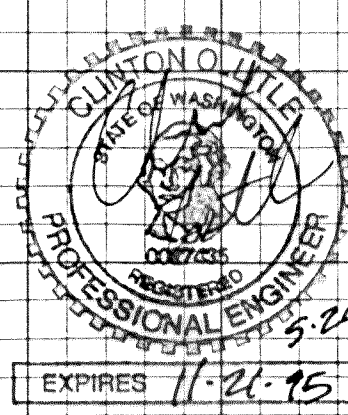

NO.	REVISIONS	BY	DATE




WEDEN ENGINEERING, INC.
119 GRAND AVENUE, SUITE D,
BELLINGHAM, WA. 98225 671-8200

DESIGNED BY	
DRAWN BY	
CHECKED BY	


CITY OF FERNDALE L.I.D. NO. 8
SANITARY SEWER EXTENSION
PLAN PROFILE STA 12+32 TO STA 20+25
LATERAL E

C:\DWG\3022RD11 11/15/94 11:08


DATE	10/14/94	SHEET	11
SCALE	1"=50'H 1"=5'V	OF	17
REC. NO.	93022		

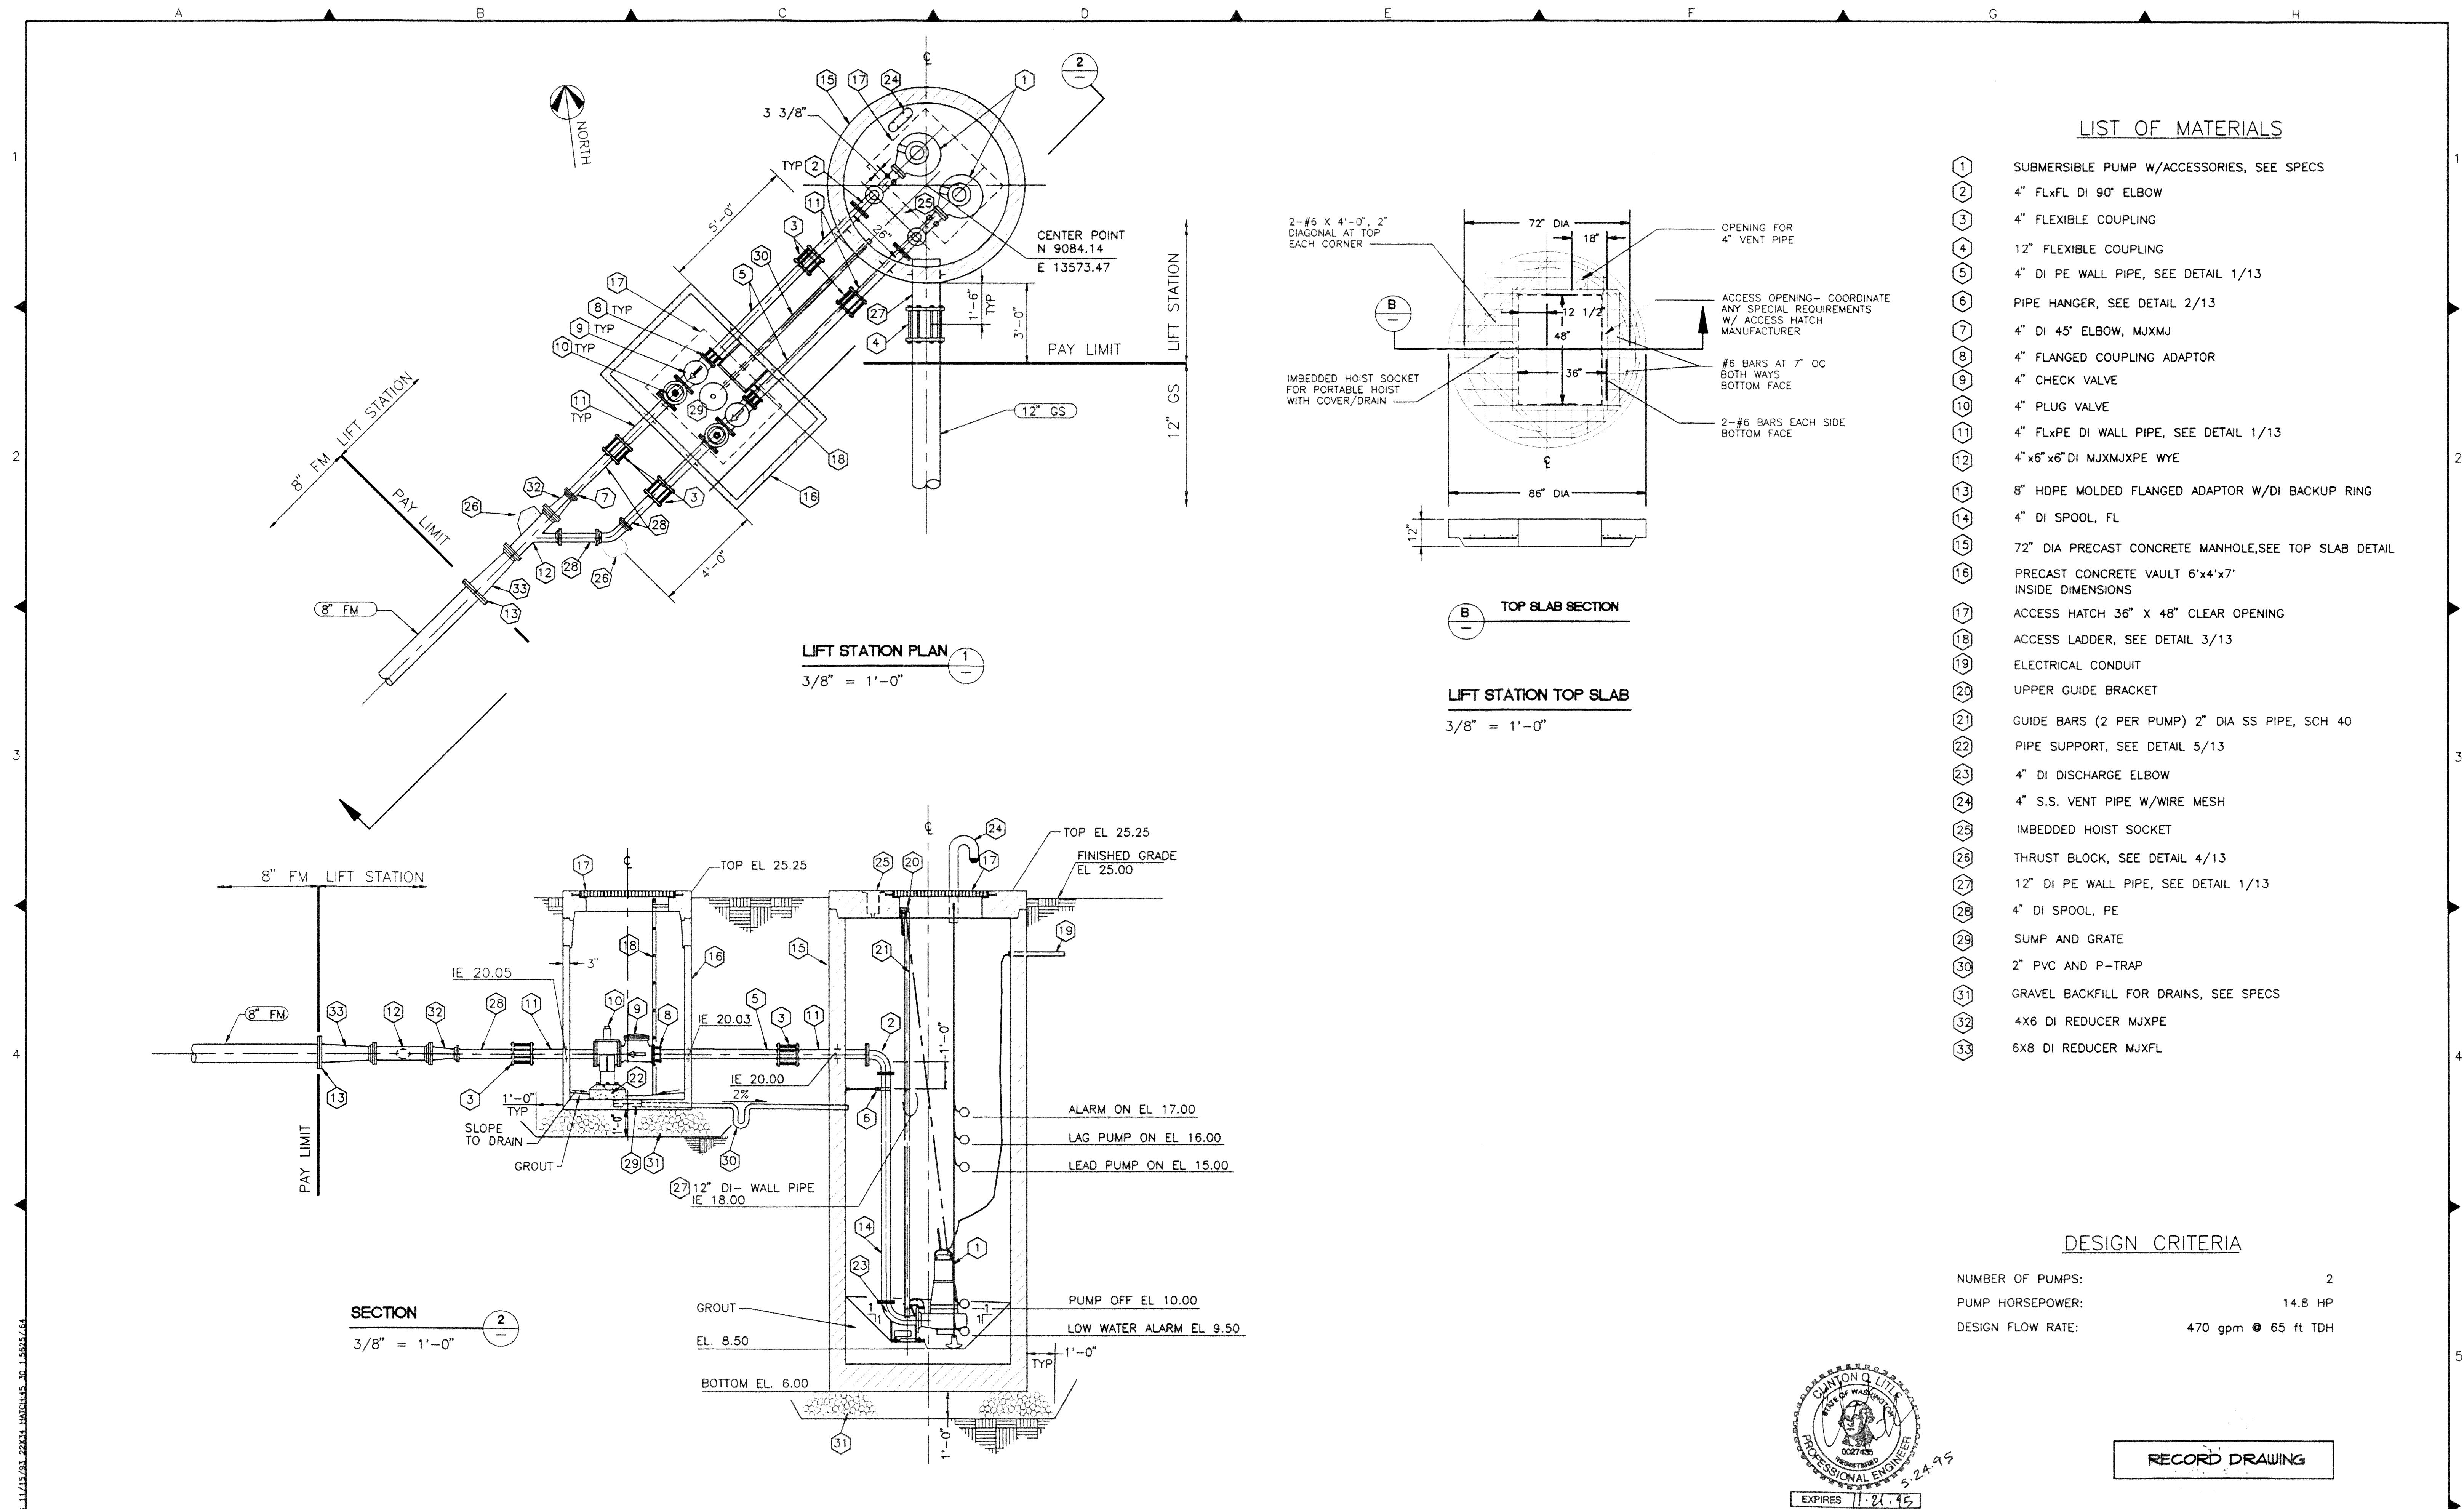


00103.013 2-8-06 KE

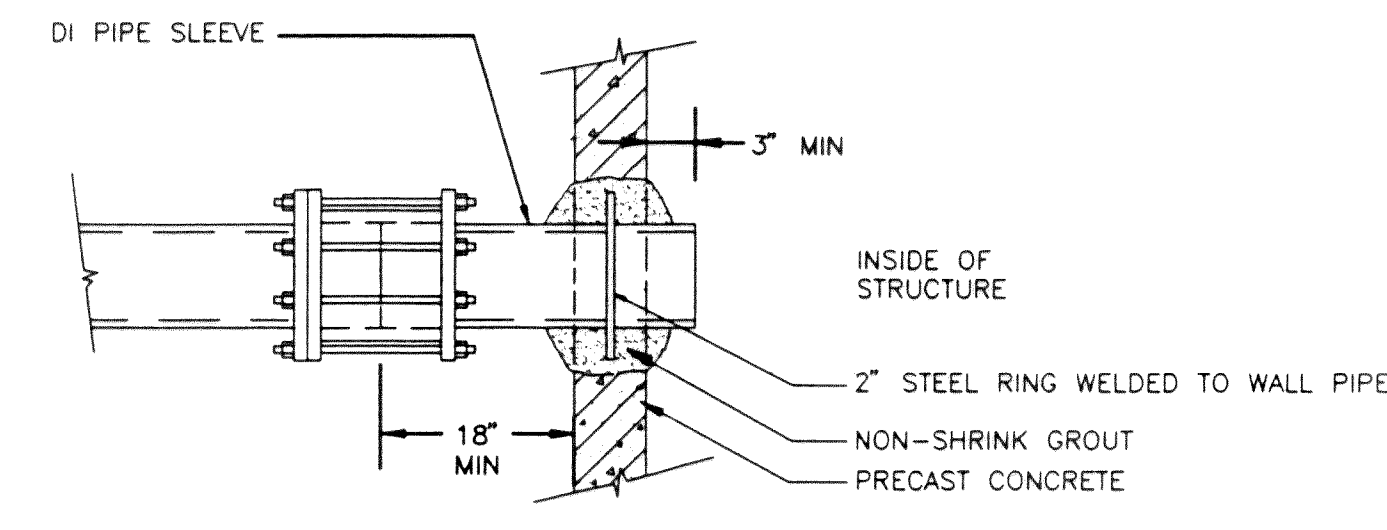

WALL PIPE
DETAIL 1
NO SCALE

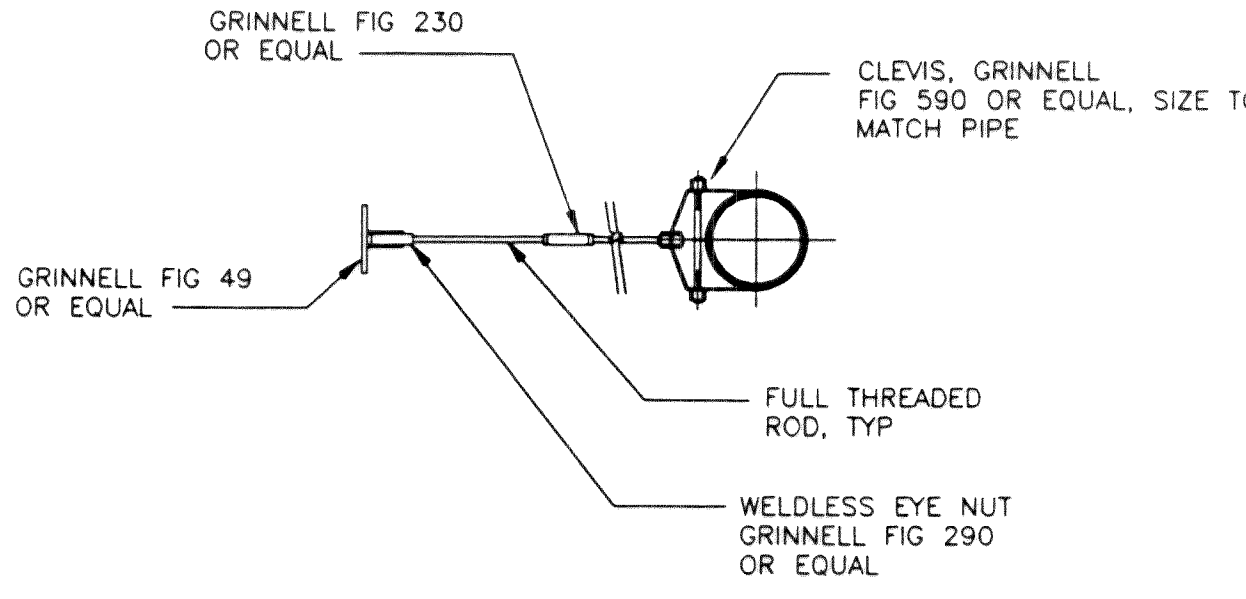



PIPE HANGER
DETAIL 2
NO SCALE

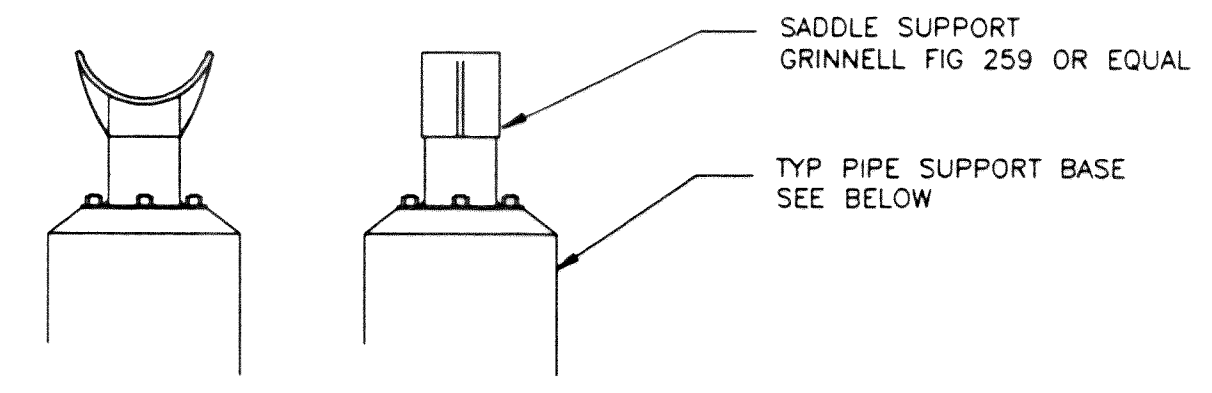


PIPE SUPPORT

THRUST BLOCKING NOTES

1. BEARING AREAS ARE BASED ON MAXIMUM SOIL BEARING STRESS OF 1000 PSF.
2. LENGTH/HEIGHT AS REQUIRED TO OBTAIN BEARING AGAINST UNDISTURBED EARTH.
3. CONCRETE SHALL BE CLASS B.
4. REINFORCE THRUST BLOCKS WITH #3 BARS @ 12" O.C. EACH WAY, EACH FACE.
5. UNLESS OTHERWISE SPECIFIED, THRUST BLOCKS ARE NOT REQUIRED FOR PIPELINES WHICH USE ONLY FULLY RESTRAINED JOINTS, I.E. WELDED, VICTAULIC OR FLANGED, MECHANICAL JOINTS WITH SUPPLEMENTAL THRUST CONTROL ROD RESTRAINT, OR SPECIAL RESTRAINT JOINTS SHALL BE USED SUBJECT TO THE ENGINEER'S PRIOR WRITTEN REVIEW.

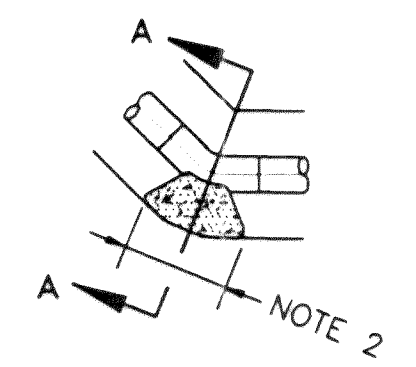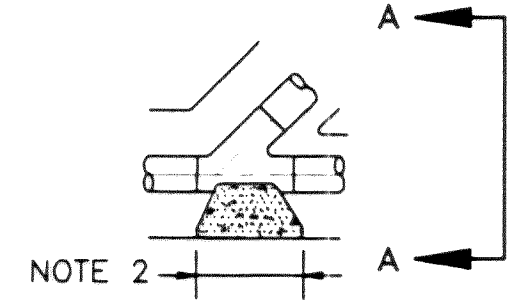


TYPICAL PIPE THRUST BLOCKING

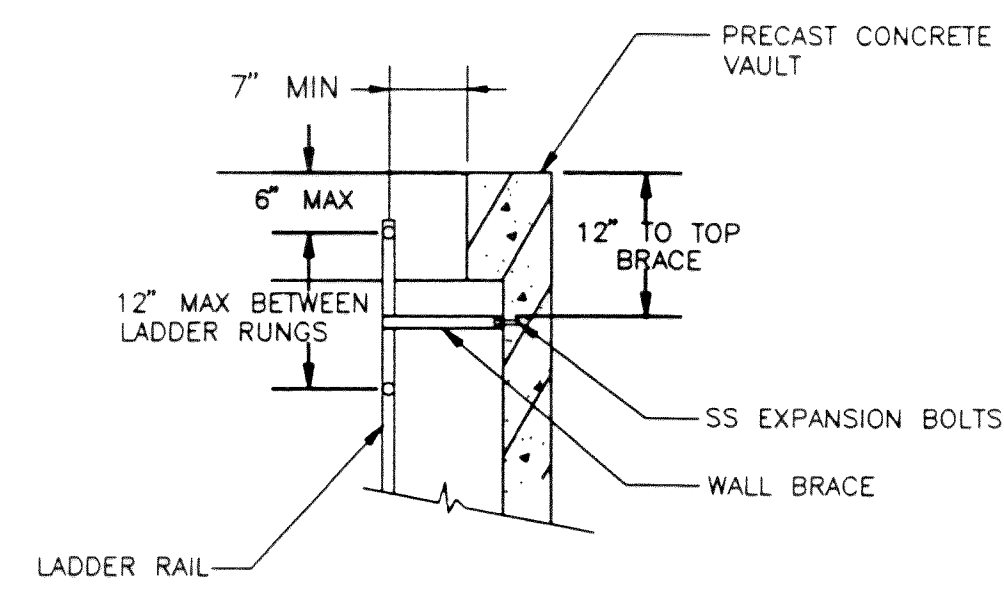

1. LADDER SHALL BE 16" WIDE, MEASURED AT INSIDE OF RAILS, UNLESS OTHERWISE DIRECTED BY ENGINEER
2. LADDER SHALL BE FABRICATED ENTIRELY OF STEEL AND HOT-DIPPED GALVANIZED AFTER FABRICATION
3. LADDER SHALL BE SECURELY FASTENED TO FLOOR
4. THE MAXIMUM DISTANCE BETWEEN THE BOTTOM RUNG AND FINISH FLOOR SHALL BE 15"


VAULT ACCESS LADDER
DETAIL 3
NO SCALE

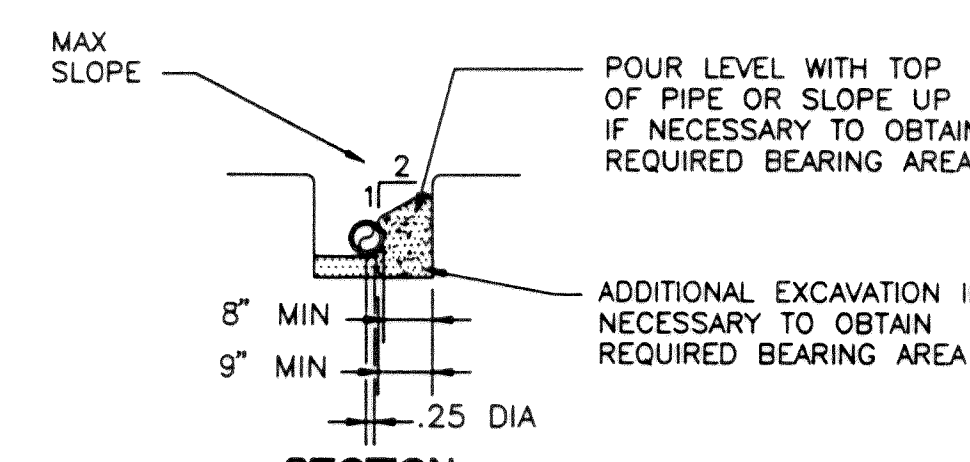


PIPE DIA IN	TEST PRESSURE PSIG	BENDS			
		TEE	90°	45°	22 1/2°
UP TO 4	0 - 150	3	4	2	1
6	0 - 150	6	8	4	2
8	0 - 150	10	15	8	4
10	0 - 150	16	23	12	6

THRUST BLOCKS

DETAIL 4
NO SCALE

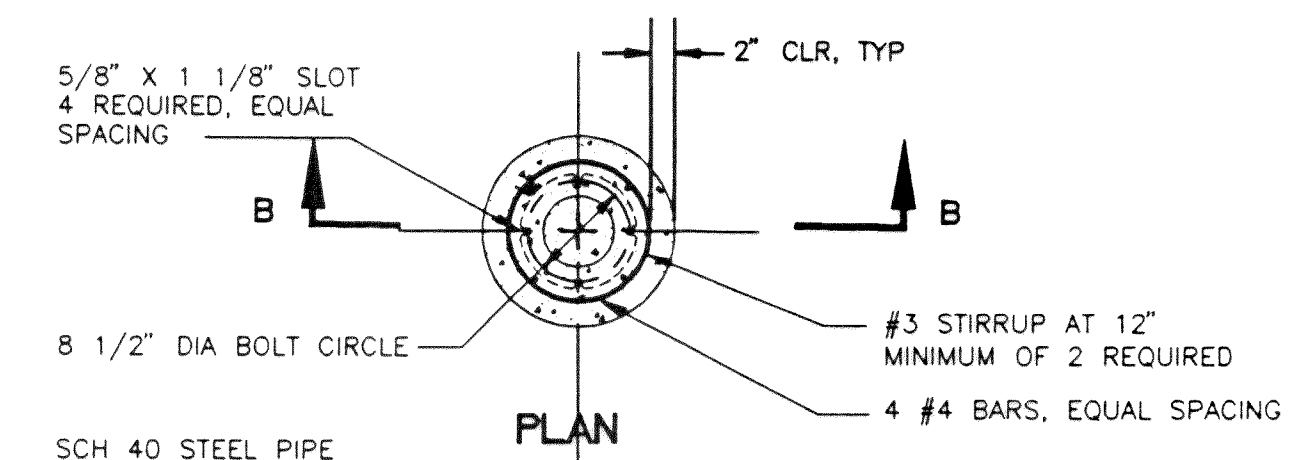


PLAN

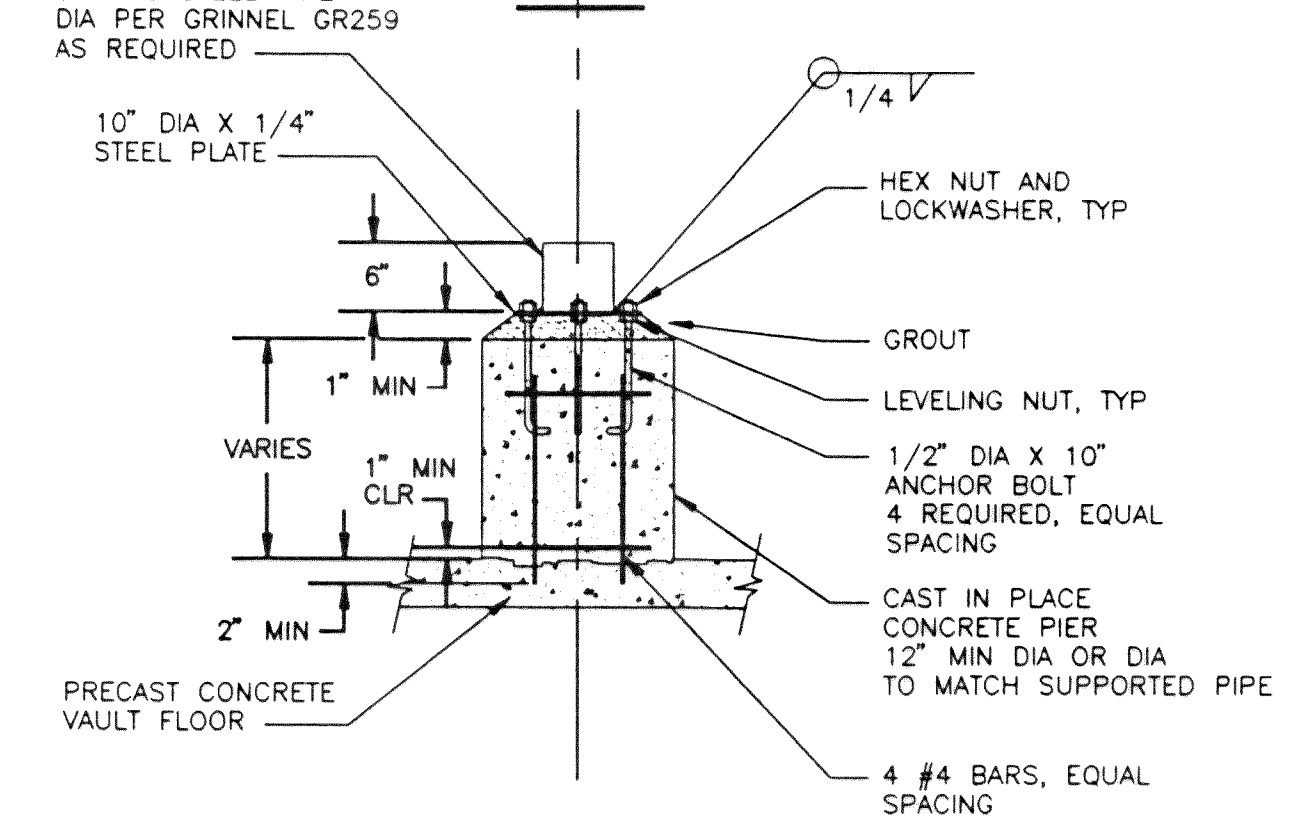

SECTION B

PIPE SUPPORT BASE

DETAIL 5
NO SCALE

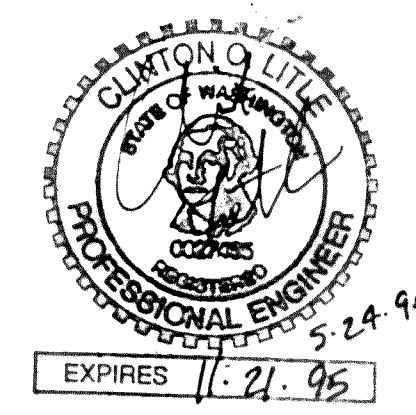

RECORD DRAWING

CINDWGN3022RD13 10/20/94 10:06

1:50 W323403 3022RD13 DWE 11/15/93 22134

NO.	REVISIONS	BY	DATE

WEDEN ENGINEERING, INC.
119 GRAND AVENUE, SUITE D,
BELLINGHAM, WA. 98225 671-8200

vasey engineering
1478 4th street
minden, nevada 89423
702-782-2582 fax 702/782-7051

1215 4th avenue, suite 1400
seattle, washington 98161
206/682-8264 fax 206/682-8491

ONE INCH AT FULL SCALE
IF NOT ONE INCH
SCALE ACCORDINGLY

DESIGNED BY:
MS


DRAWN BY:
BLB/TEP

CHECKED BY:
BH/MRD


CITY OF FERNDALE L.I.D. NO. 8
SANITARY SEWER EXTENSION
PUMP STATION DETAILS

DATE	SHEET
10/14/94	13
SCALE	OF
AS NOTED	17
REC. NO.	93022



00103.014 2-8-06 42

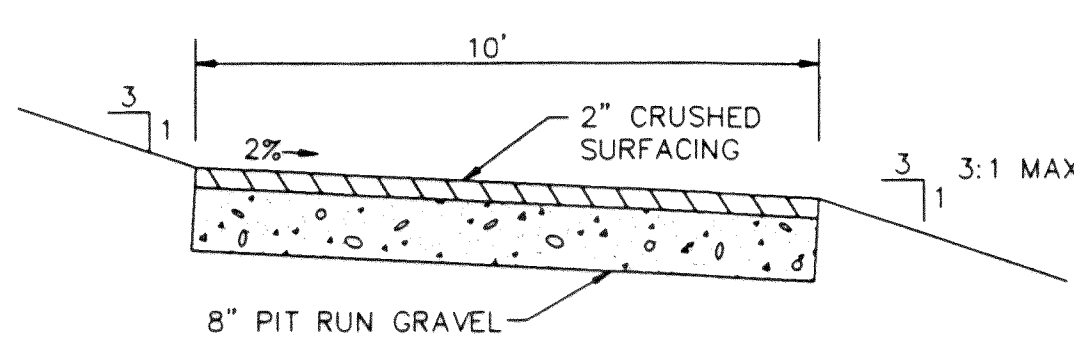


1 MAINTENANCE ROAD CROSS SECTION
3,7,10,11
NTS

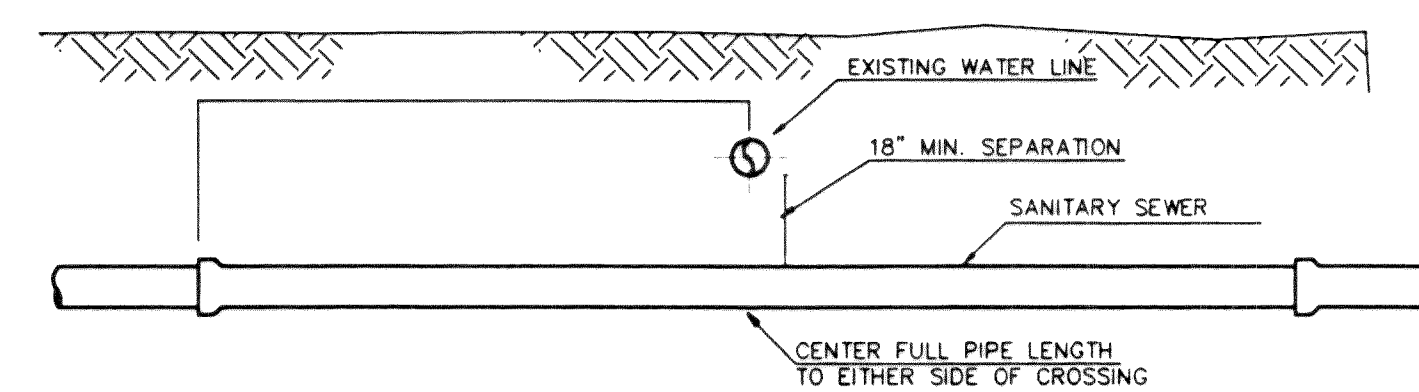


2 WATER LINE CROSSING DETAIL
NTS

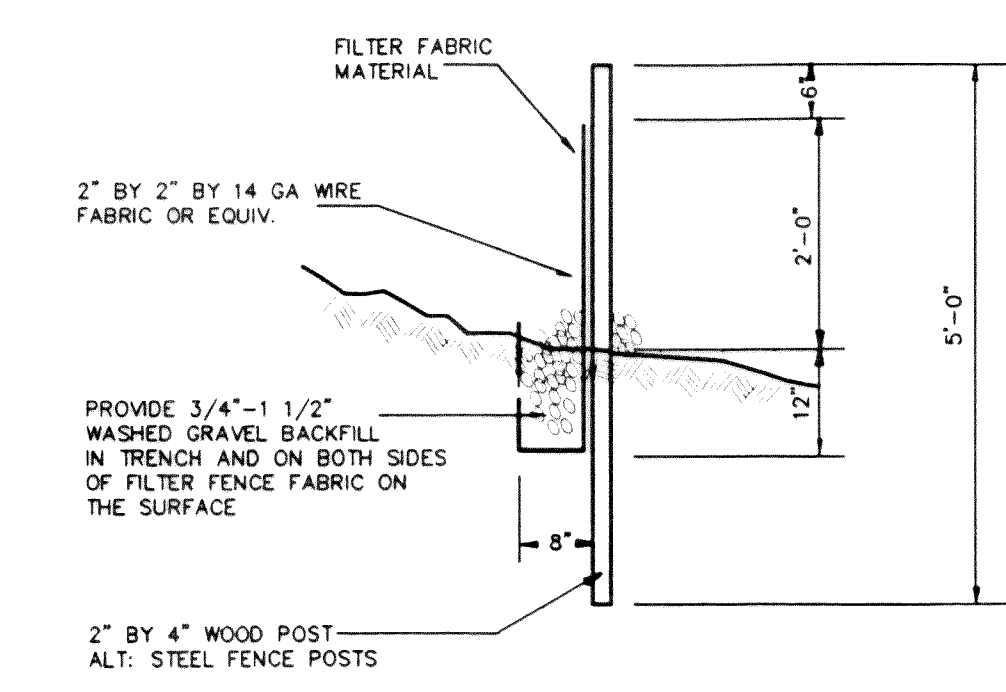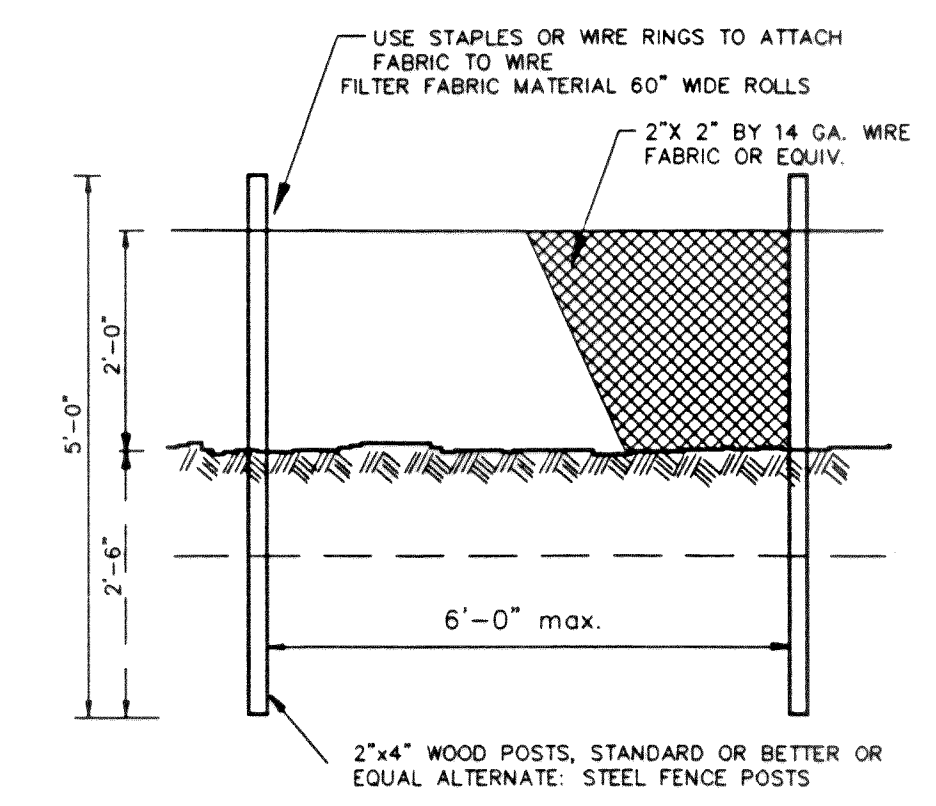


3 SILT FENCE
6,7,9,10
NTS

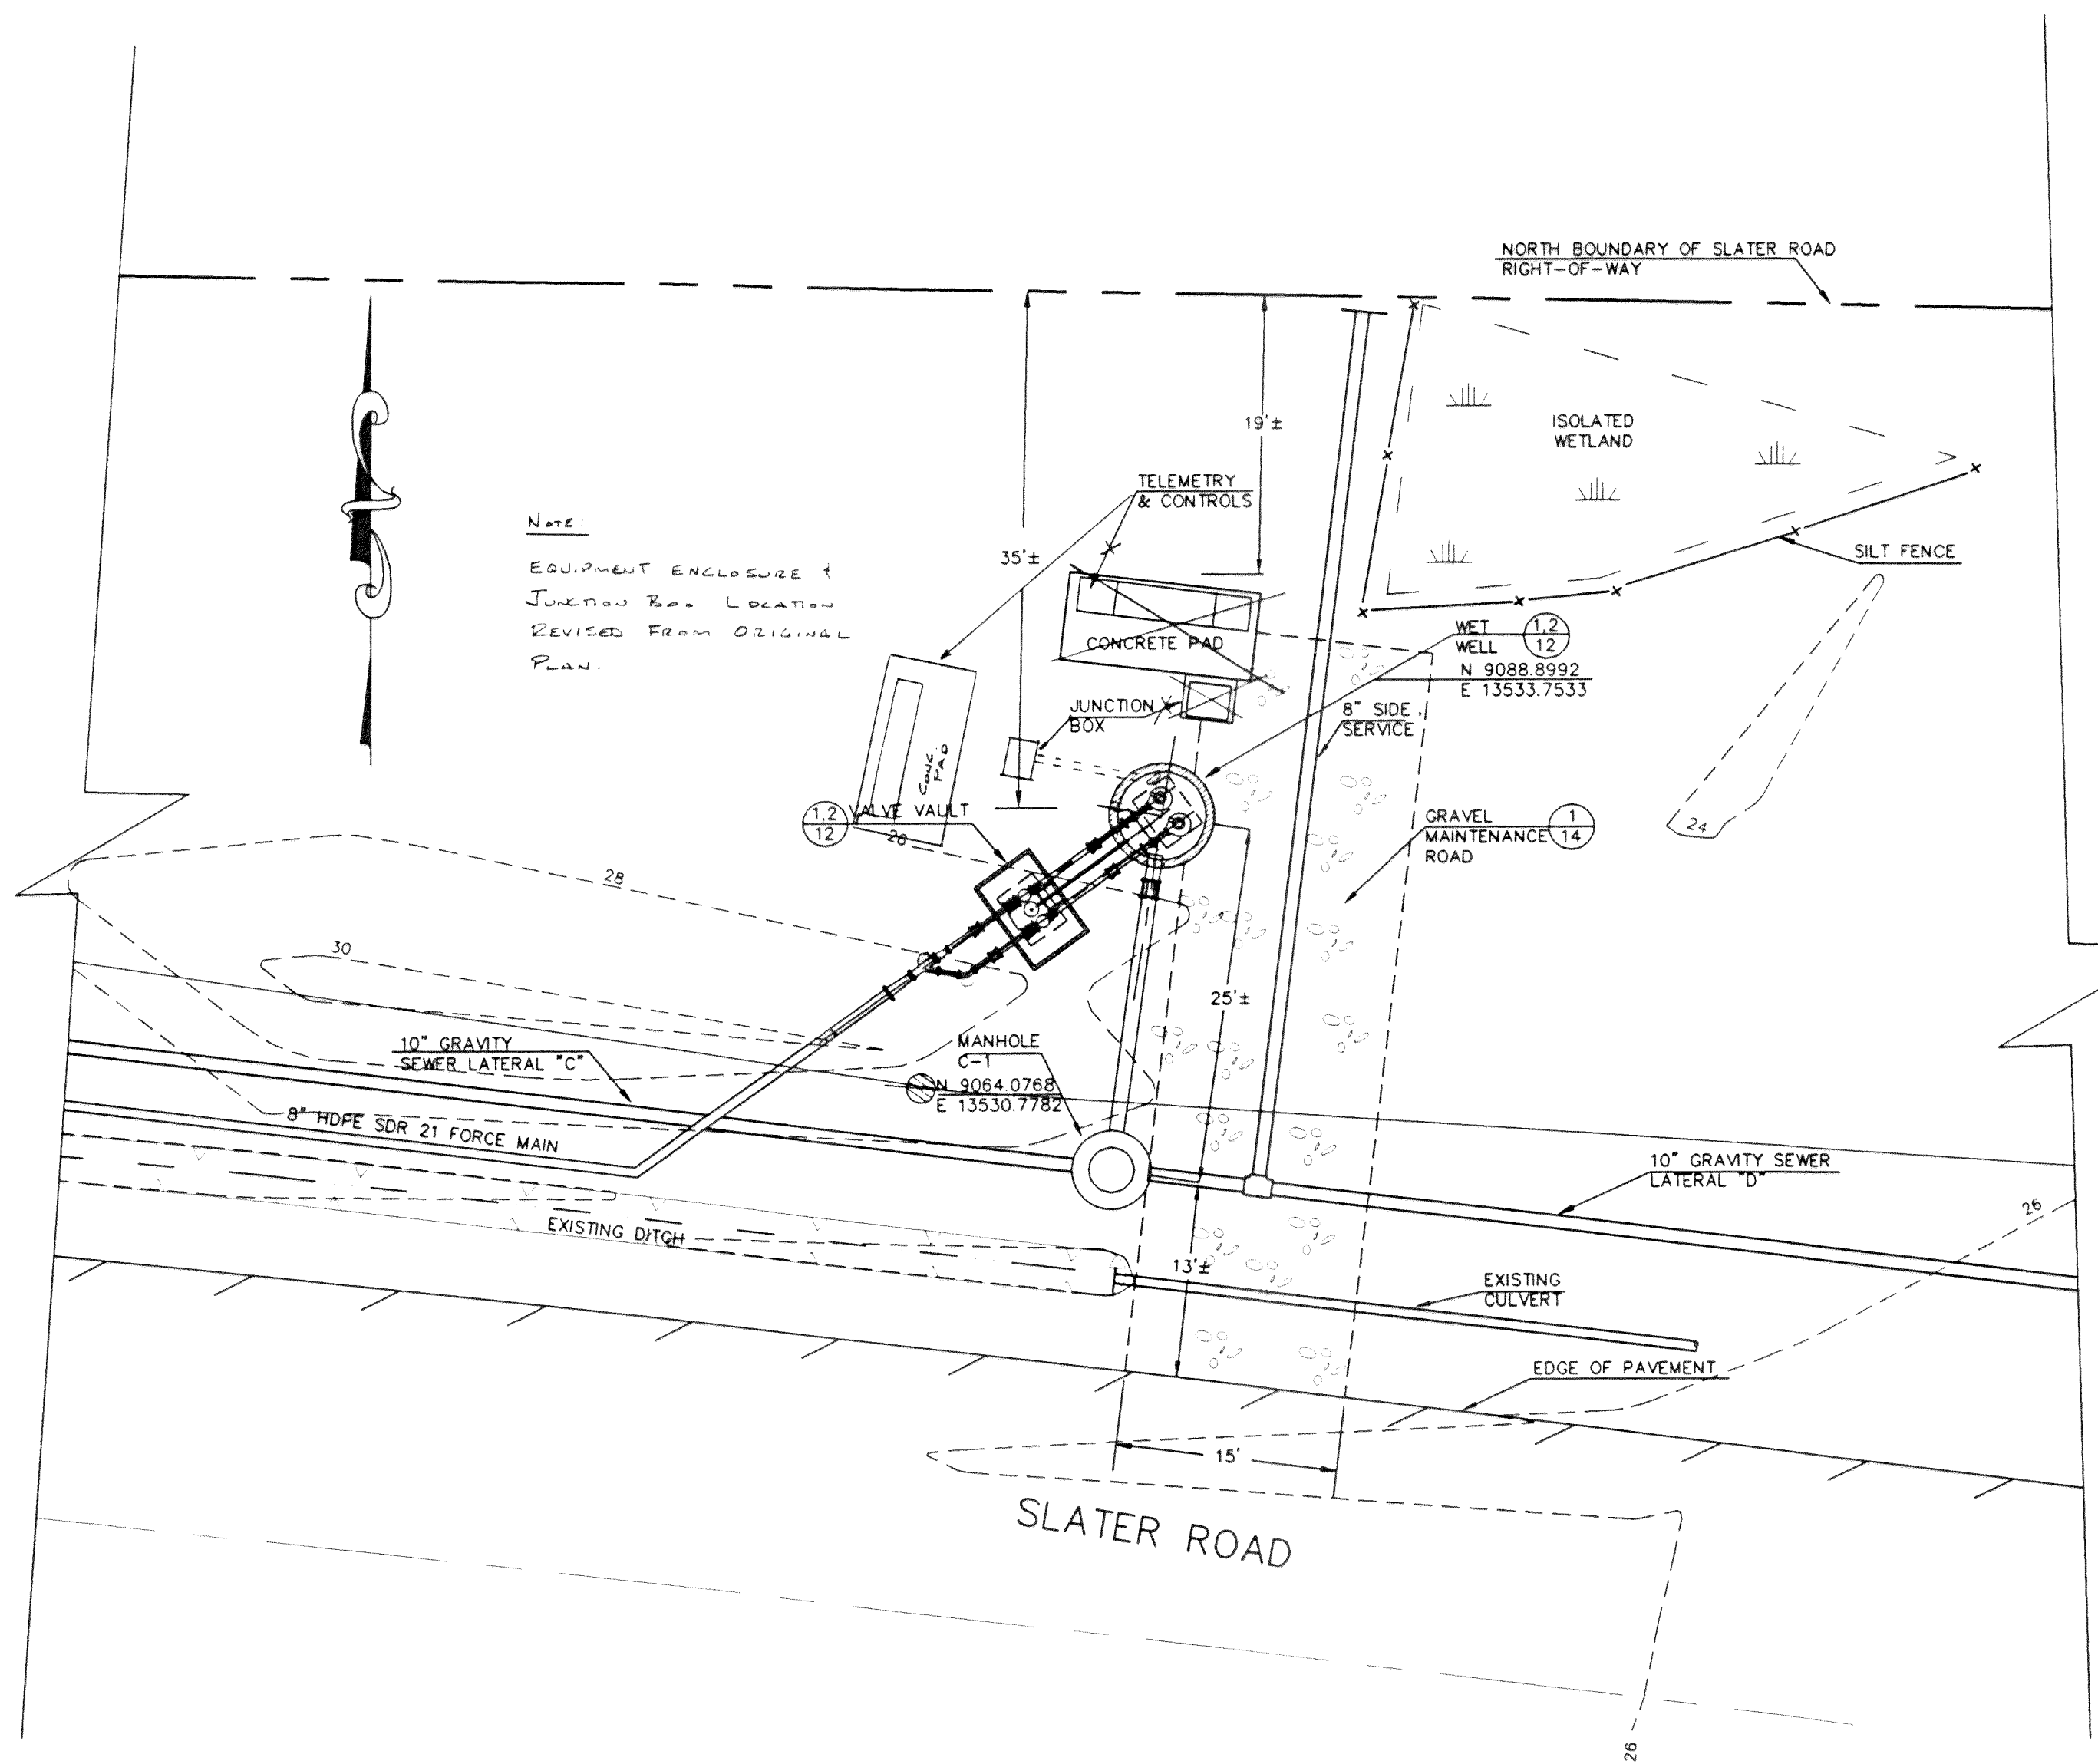


4 LIFT STATION SITE PLAN
8,12
1" = 10'

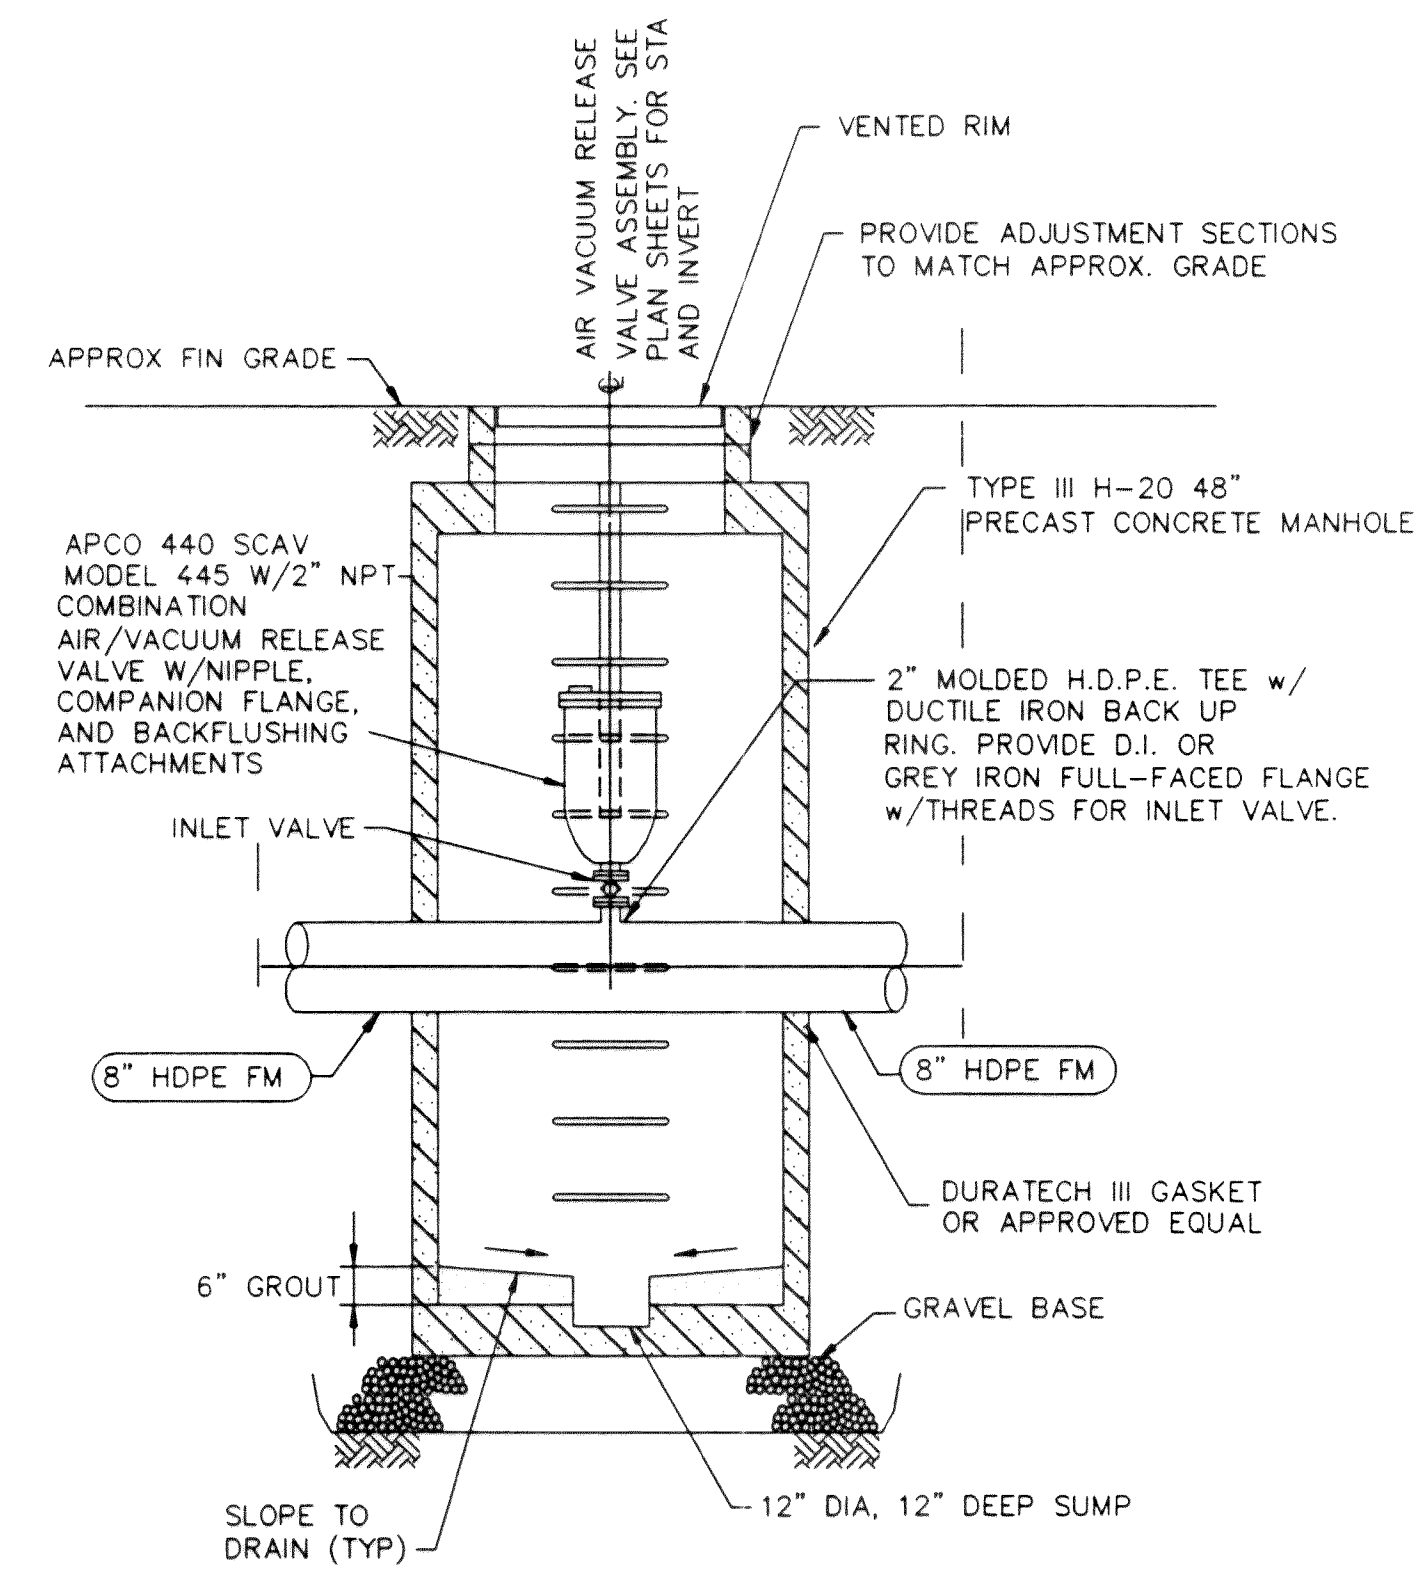

5 AIR RELEASE VALVE ASSEMBLY
3
NTS

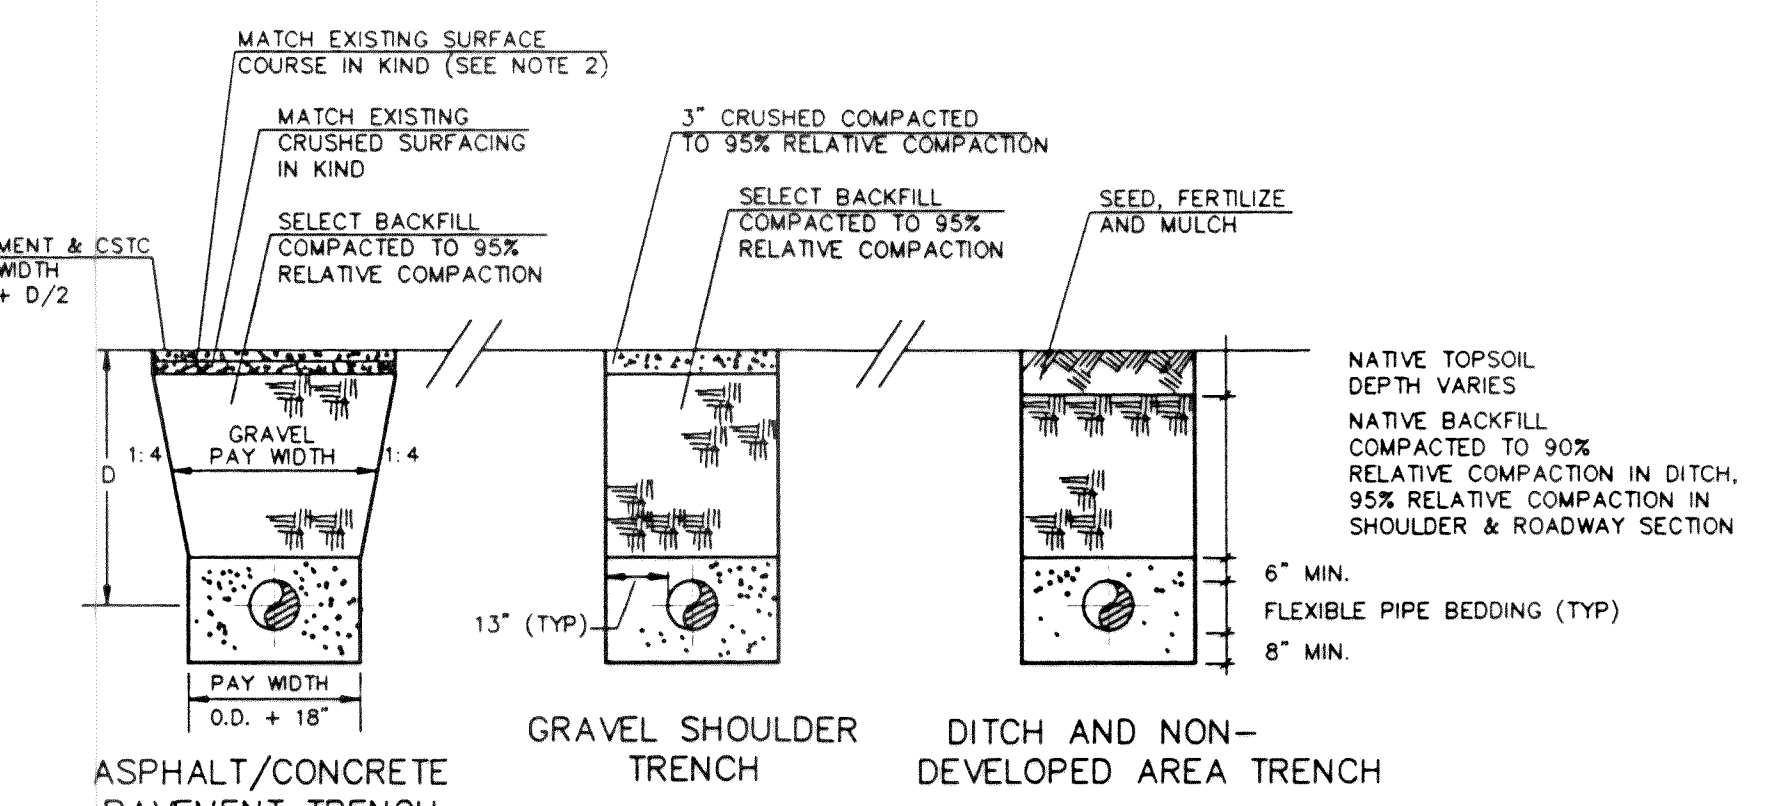


TRENCHING DETAIL
N.T.S.
NOTES: 1. NATIVE BACKFILL SHALL BE COMPACTED TO 90% RELATIVE COMPACTION.
2. SELECT BACKFILL/CRUSHED SURFACE COURSE SHALL BE COMPACTED TO 95% COMPACTION.
3. PAVEMENT SHALL BE SAW CUT, TACKED, AND COMPACTED TO 92% OF ABSOLUTE DENSITY.
4. P.C.C. REPLACEMENT SHALL BE 2" GREATER THAN EXISTING COURSE, 7" MINIMUM, 6.5 P.C.C. (HES - AIR ENTRAINED)
5. ALL TRENCH RESTORATION SHALL MEET EITHER CITY OF FERNDAL OR WHATCOM COUNTY STANDARDS

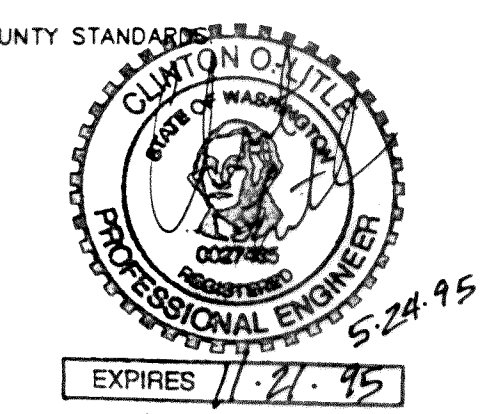

RECORD DRAWING

NO.	REVISIONS	BY	DATE

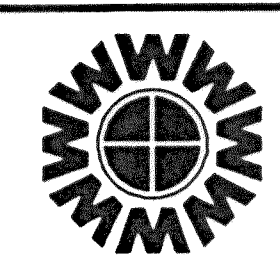


WEDEN ENGINEERING, INC.
119 GRAND AVENUE, SUITE D,
BELLINGHAM, WA. 98225 671-8200


ONE INCH AT FULL SCALE	DESIGNED BY
IF NOT ONE INCH SCALE ACCORDINGLY	DRAWN BY
	CHECKED BY

**CITY OF FERNDAL L.I.D. NO. 8
SANITARY SEWER EXTENSION**
DETAILS


C:\DWG\3022RD14	10/20/94	10-10
DATE	10/14/94	SHEET
SCALE	AS SHOWN	14 OF
REC. NO.	93022	17

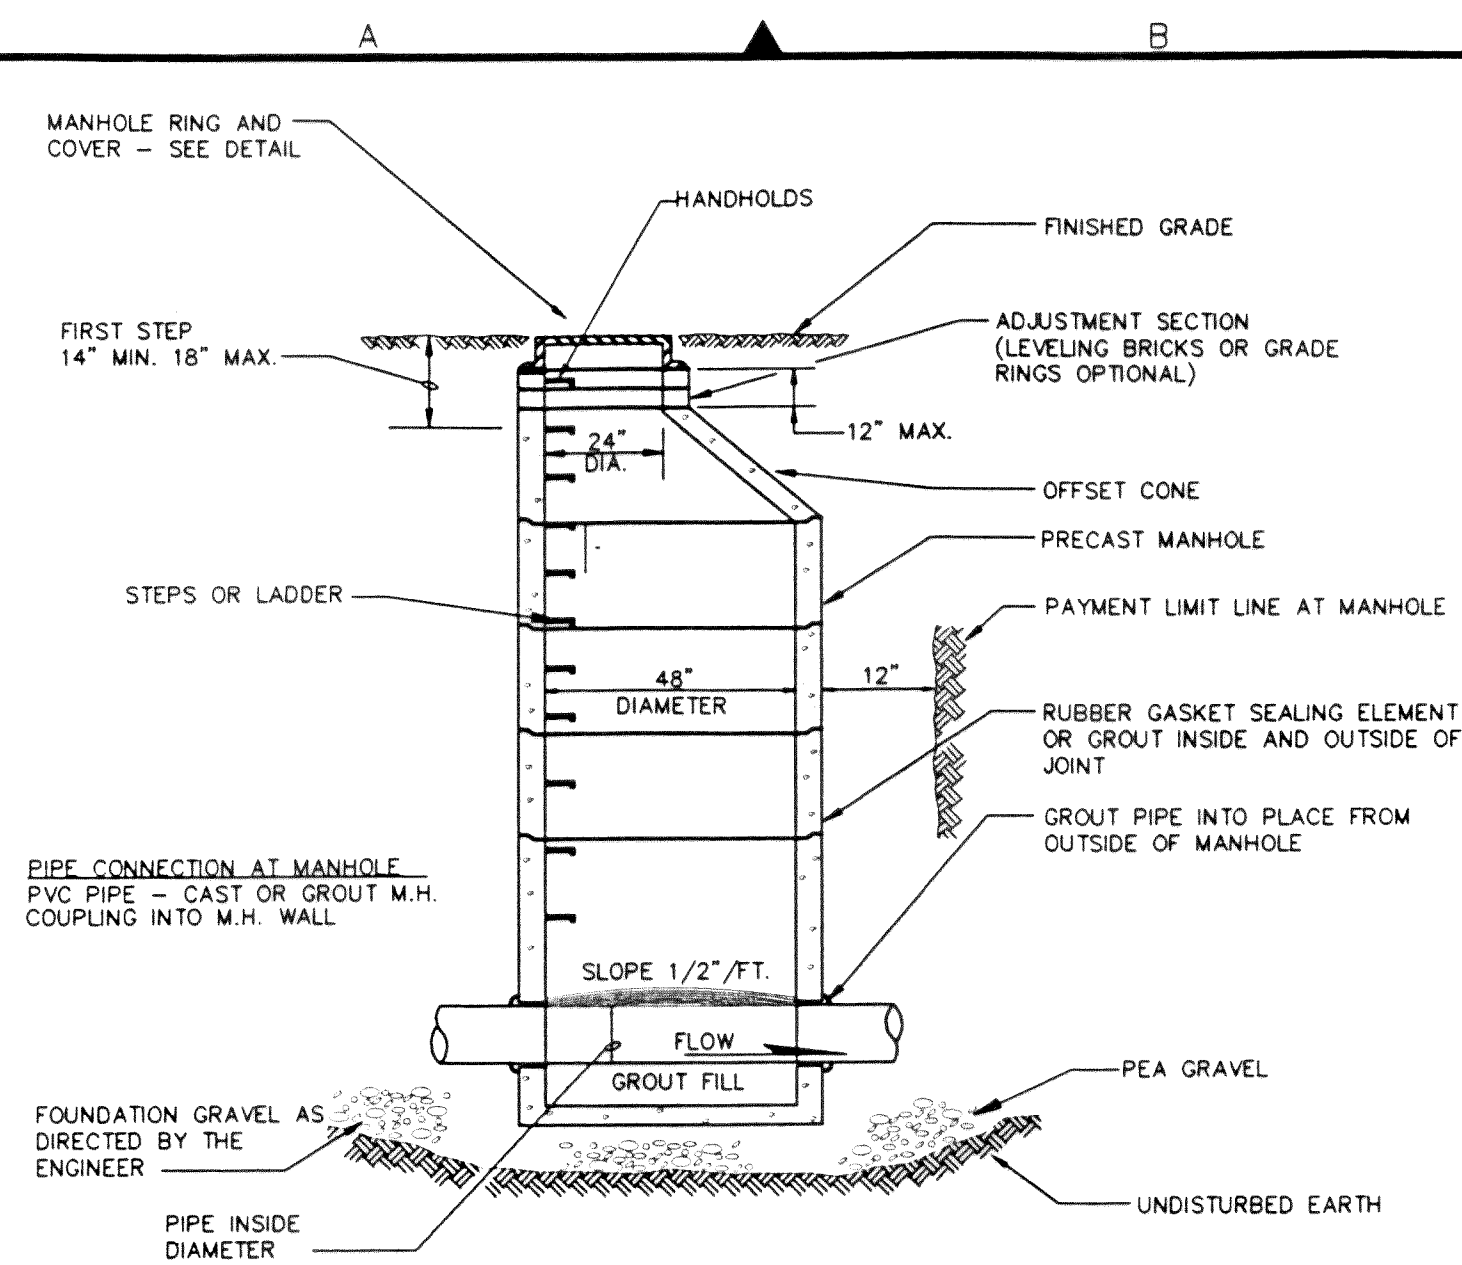


1 PRECAST MANHOLE - TYPE I
NTS

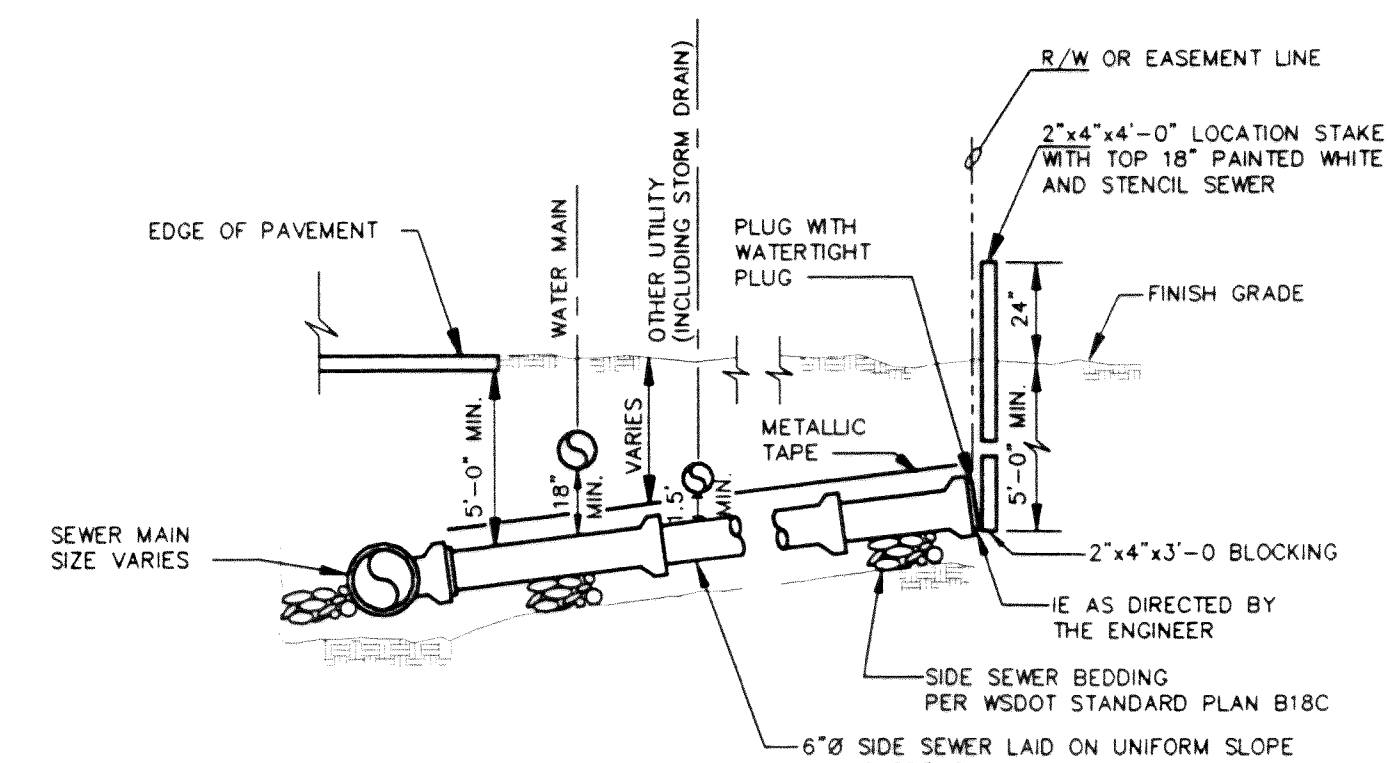


3 SIDE SERVICES SHALLOW INSTALLATION
15" AND SMALLER MAINS
NTS

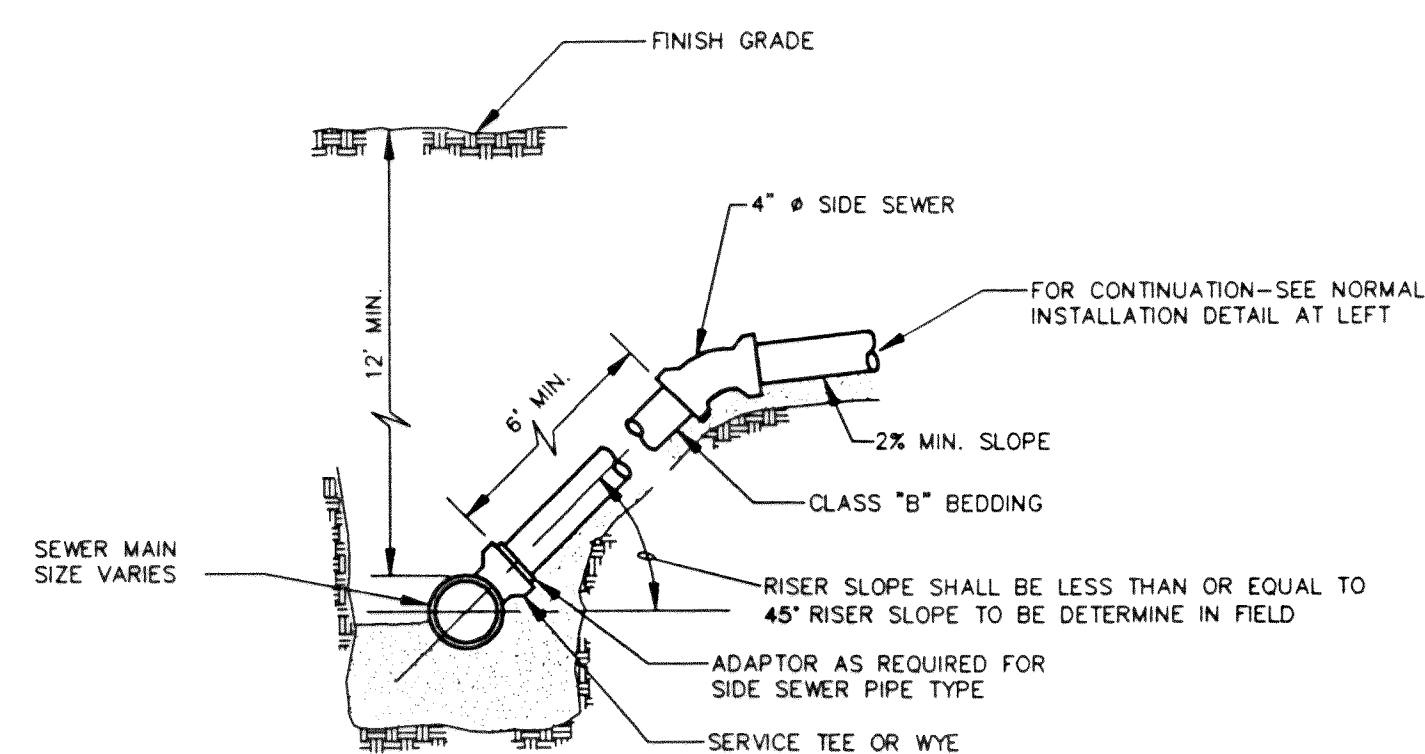


5 SIDE SERVICES DEEP INSTALLATION
NTS

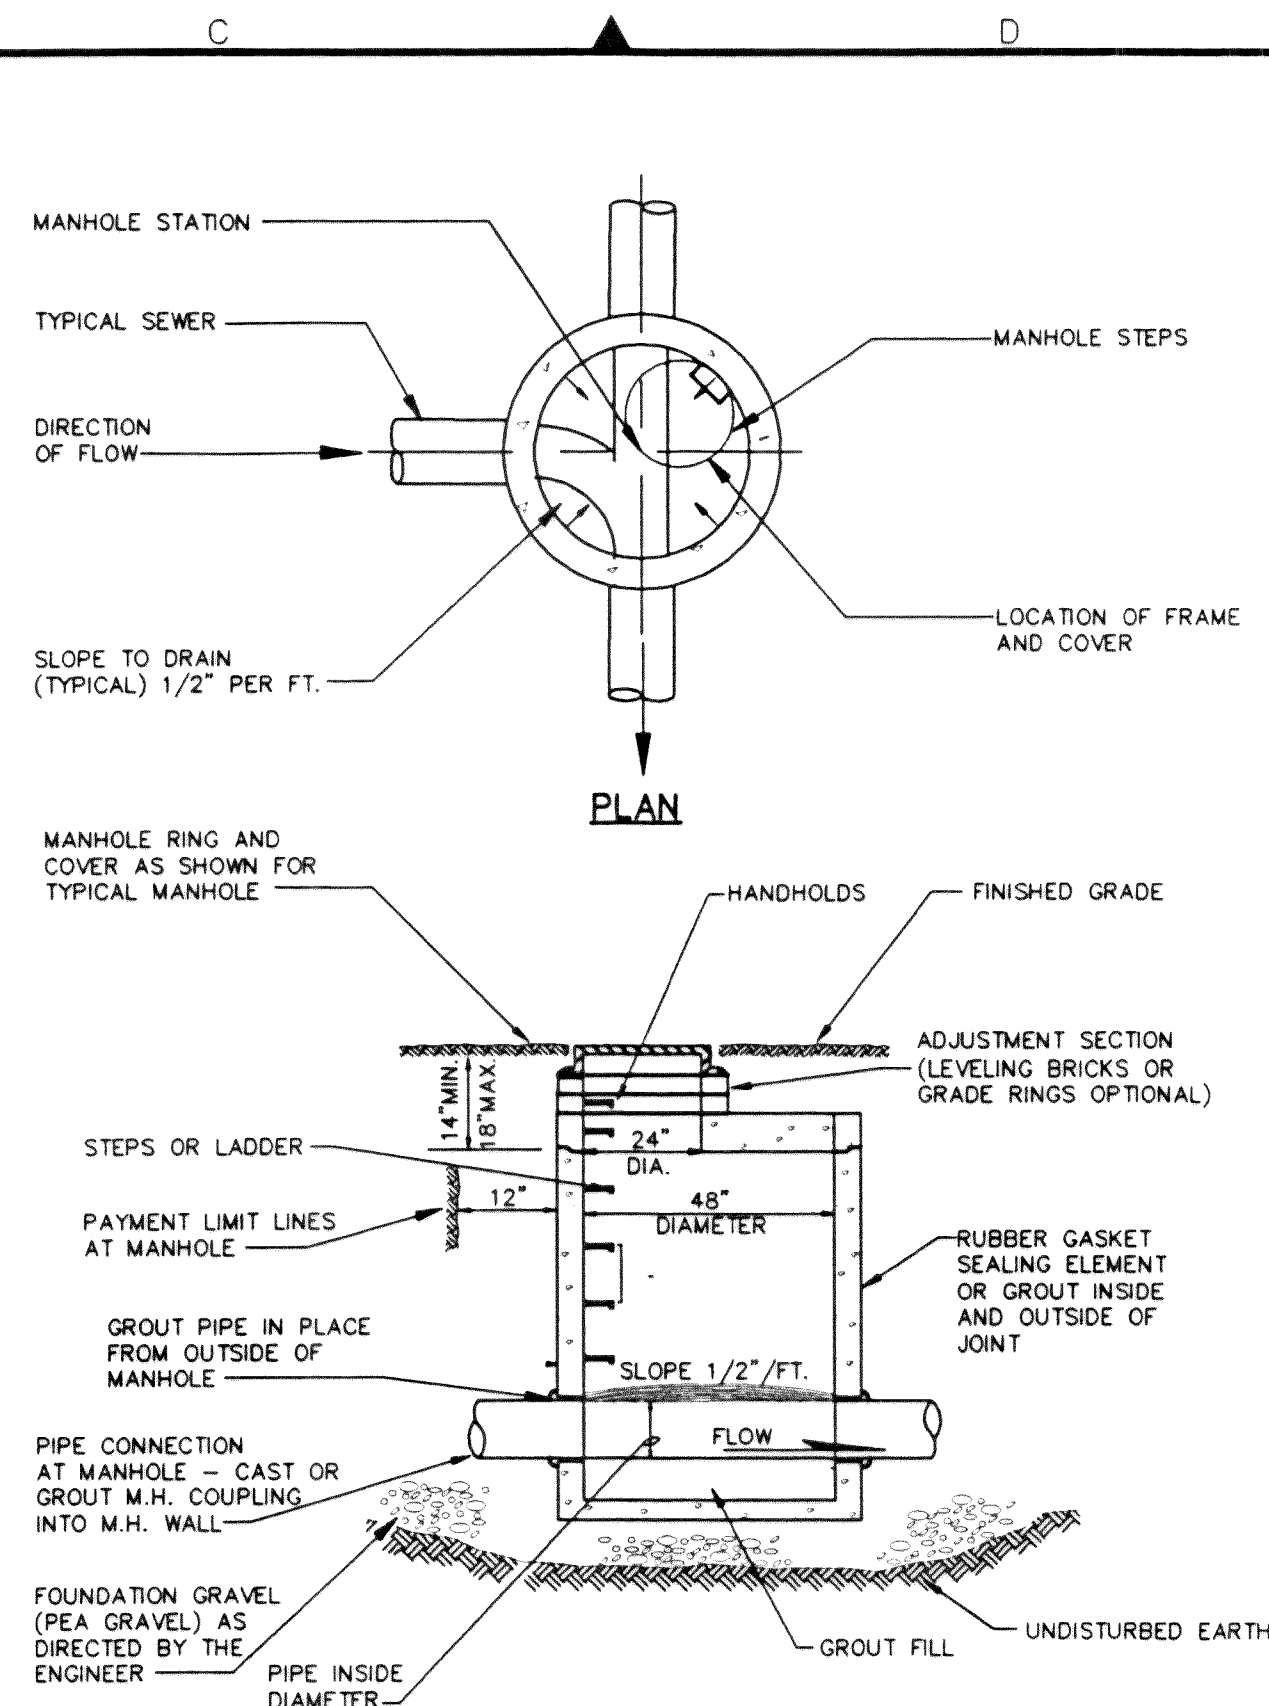


2 PRECAST MANHOLE - TYPE III
NOT TO SCALE

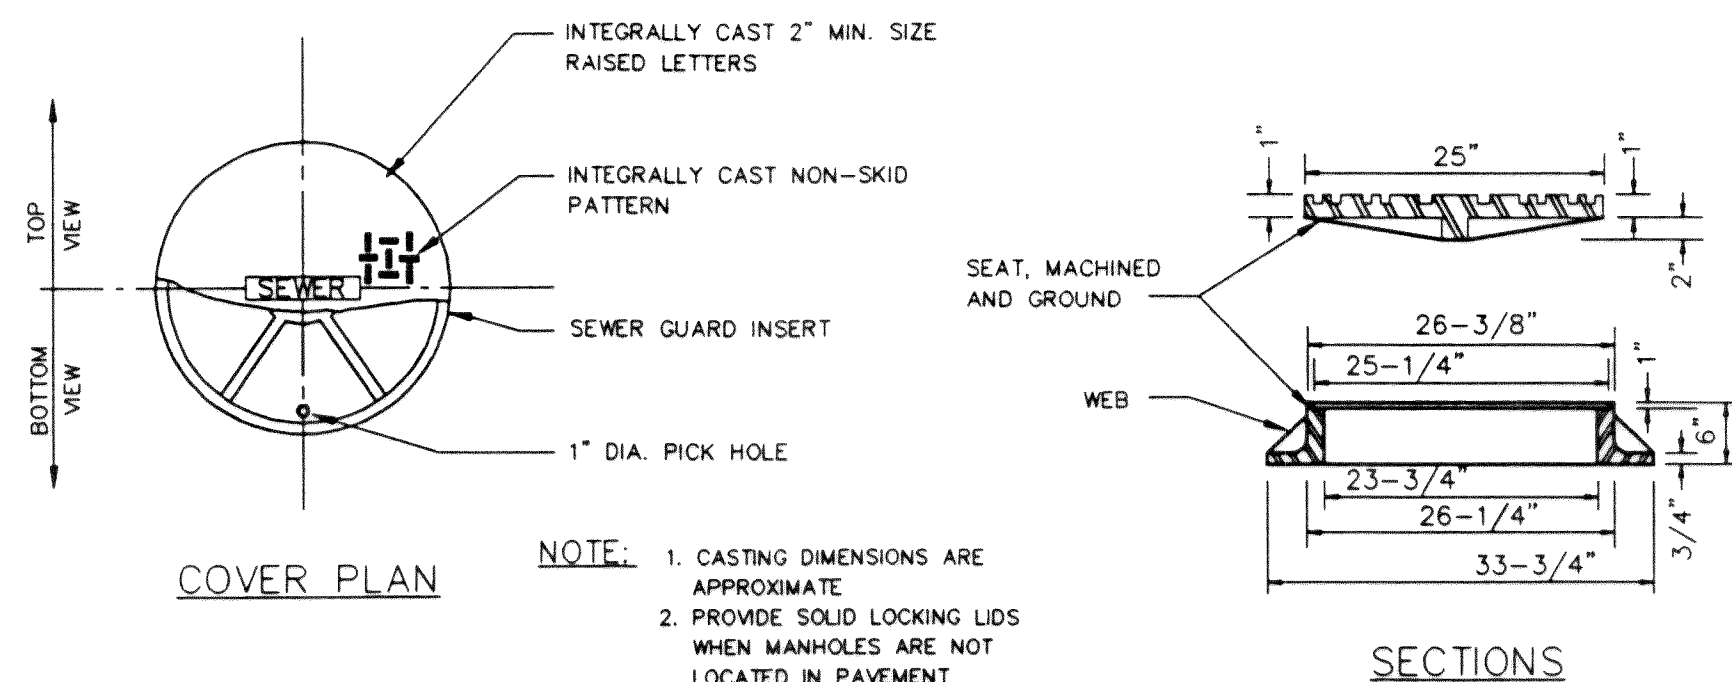

4 MANHOLE FRAME AND COVER
NTS

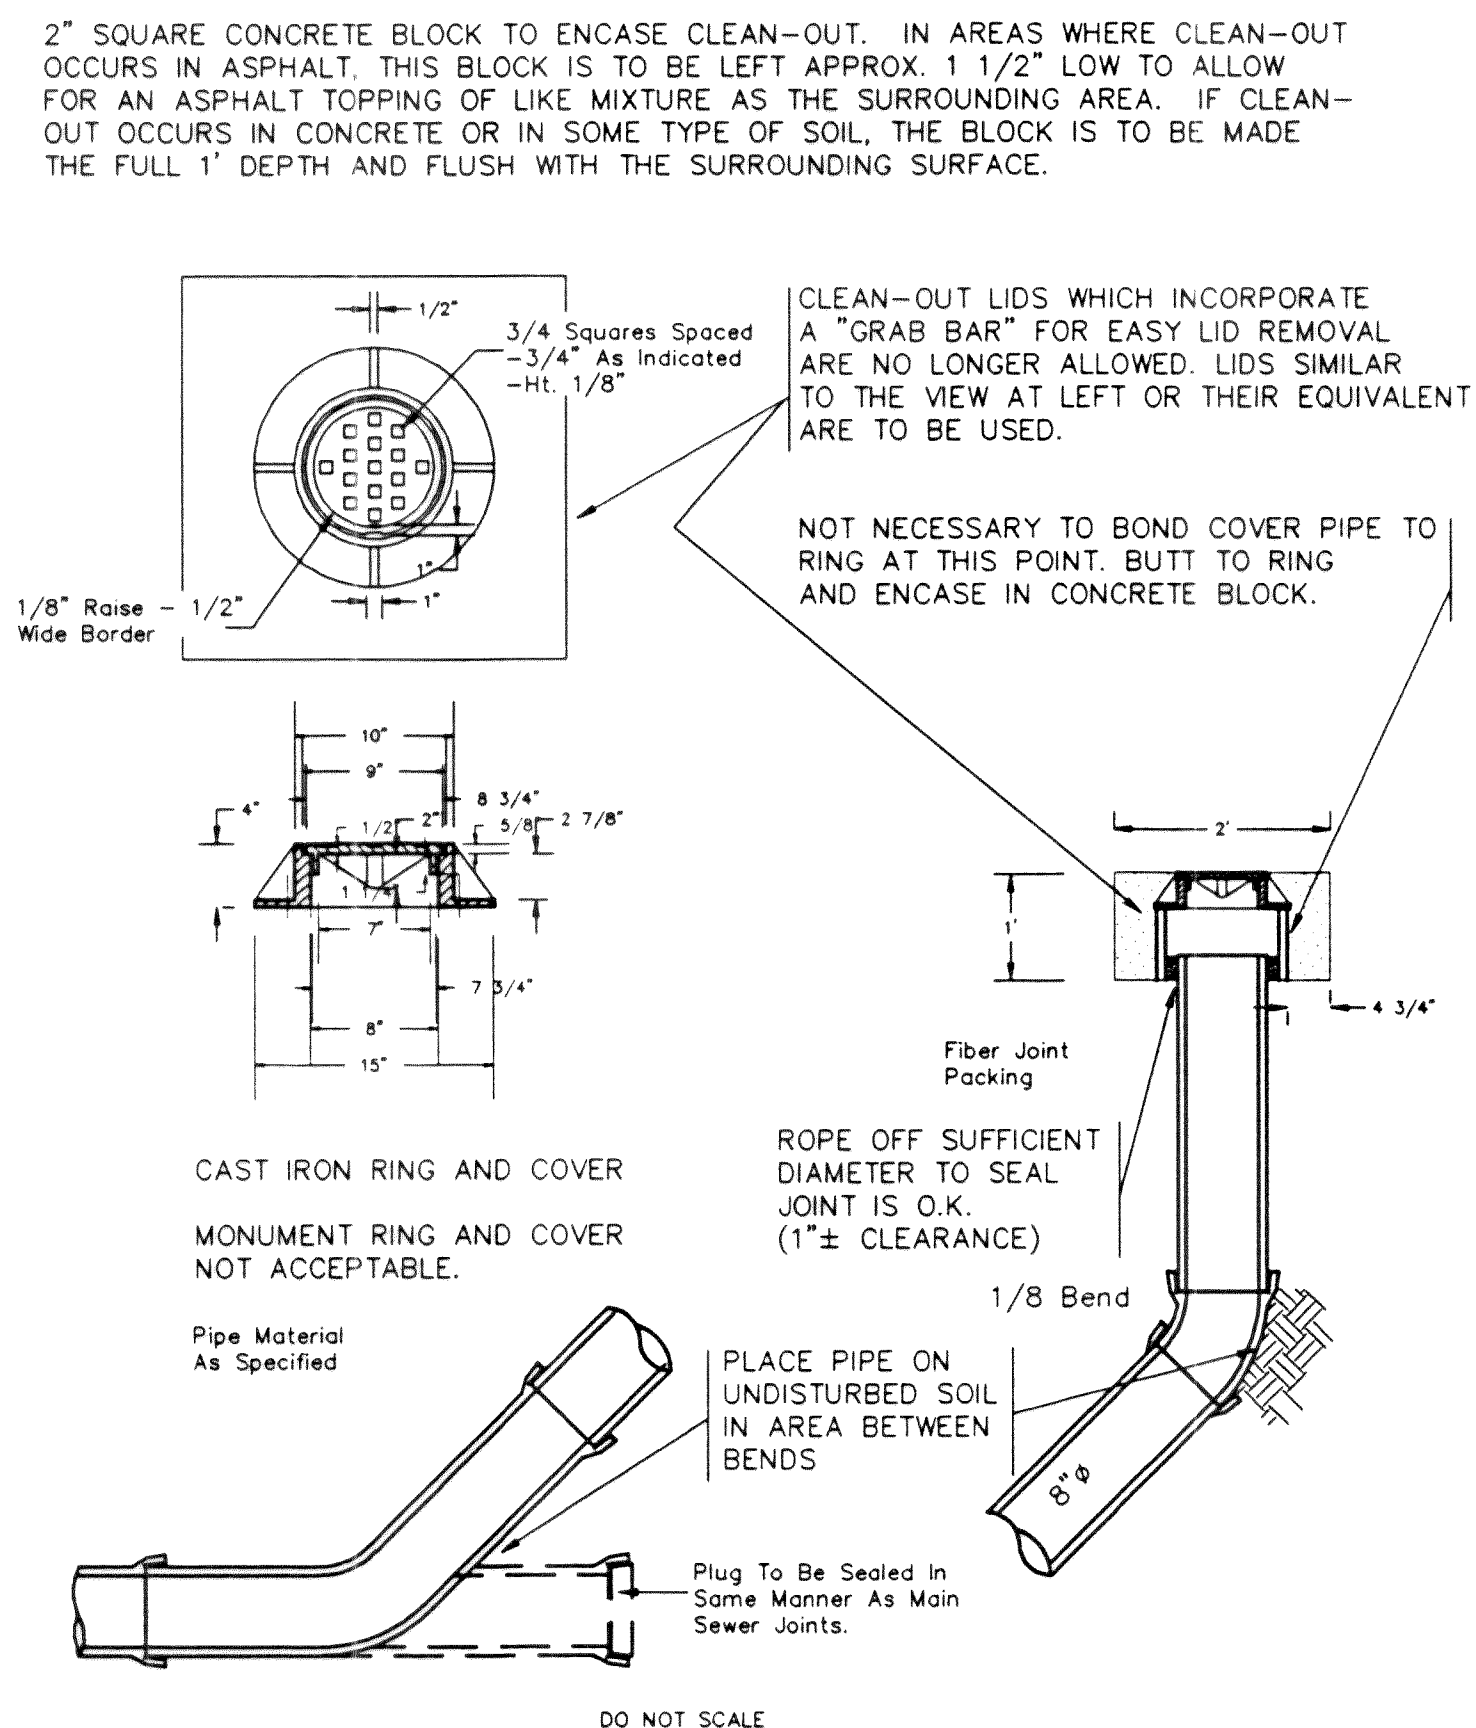

6 SANITARY SEWER CLEANOUT
NOT TO SCALE

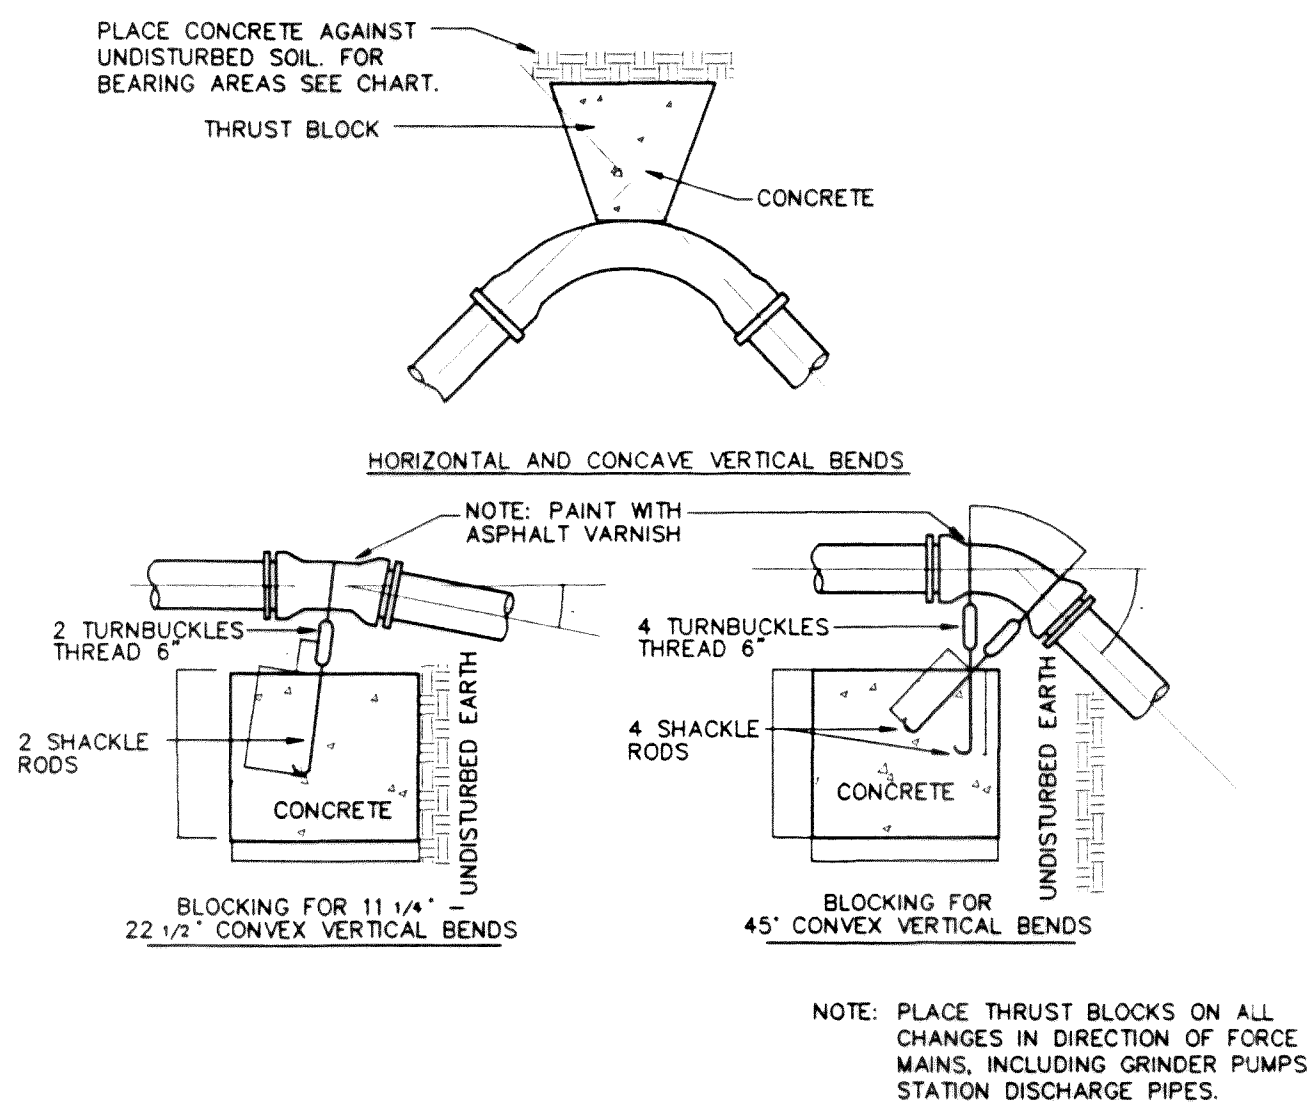


7 THRUST BLOCK DETAILS - FORCE MAIN
NTS

HORIZONTAL AND CONCAVE VERTICAL THRUST BLOCKS


THRUST BLOCK BEARING AREA				
FITTING OR BRANCH SIZE	45"	22 1/2"	11 1/4"	TEE AND DEAD END
6"	1.2	1.0	1.0	1.5

CONVEX VERTICAL THRUST BLOCKS				
PIPE SIZE INCHES	VERTICAL BEND DEGREES - V.B. -	VOLUME OF BLOCKING CU. FT. - S -	SIDE OF CUBE FEET - S -	SHACKLE ROD DIAMETER - V.B. -
6"	11 1/4	2.2	1.3	5/8
22 1/2	4.1	1.6	5/8	1.25
45	6.9	1.9	5/8	1.25

BASED ON TEST PRESSURE OF 50 PSI AND SOIL BEARING PRESSURE OF 1000 PSF

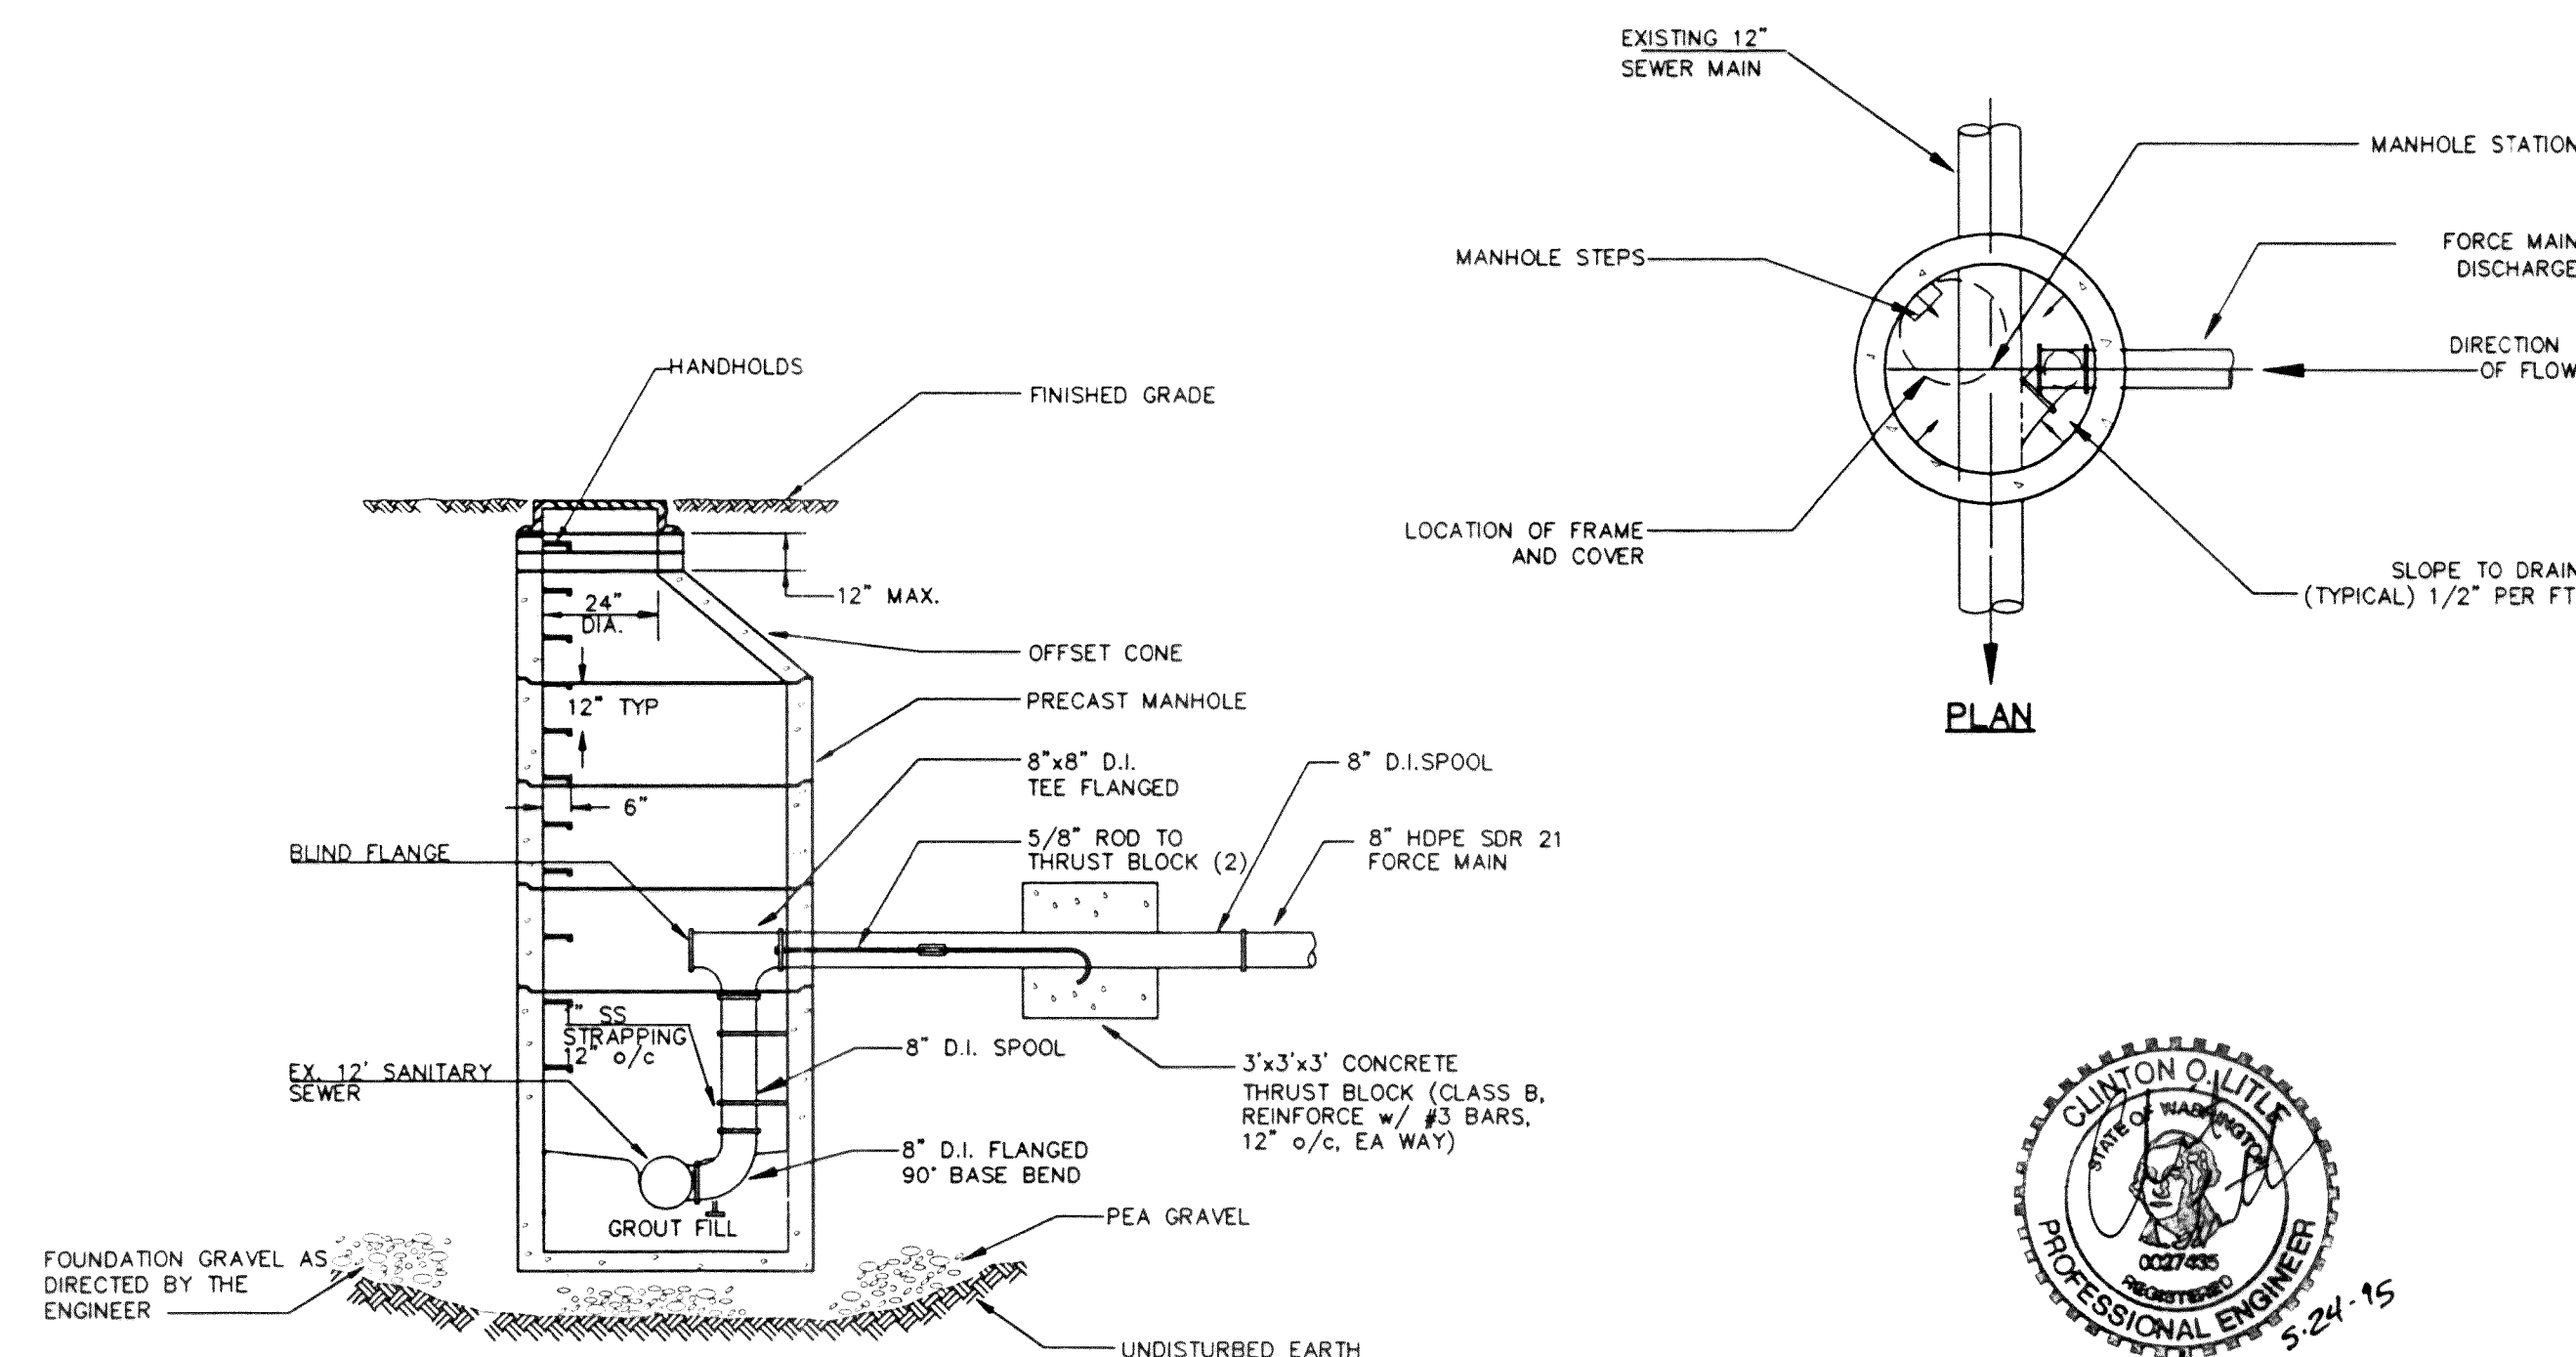

9 FORCE MAIN DISCHARGE
NTS

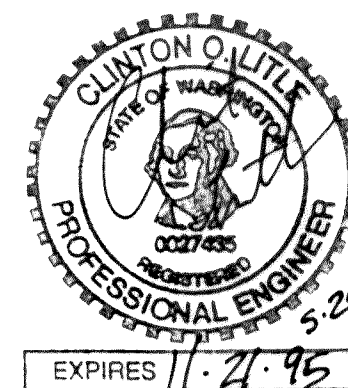

RECORD DRAWING

NO.	REVISIONS	BY	DATE



WEDEN ENGINEERING, INC.
119 GRAND AVENUE, SUITE D,
BELLINGHAM, WA. 98225 671-8200

ONE INCH AT FULL SCALE
IF NOT ONE INCH SCALE ACCORDINGLY


DESIGNED BY
DRAWN BY
CHECKED BY

**CITY OF FERNDALE L.I.D. NO. 8
SANITARY SEWER EXTENSION**

DETAILS

C:\DWG\3022RD15	10/20/94	10:17
DATE	10/14/94	SHEET
SCALE	AS SHOWN	15
REC. NO.	93022	OF
		17

A B C D E F G H

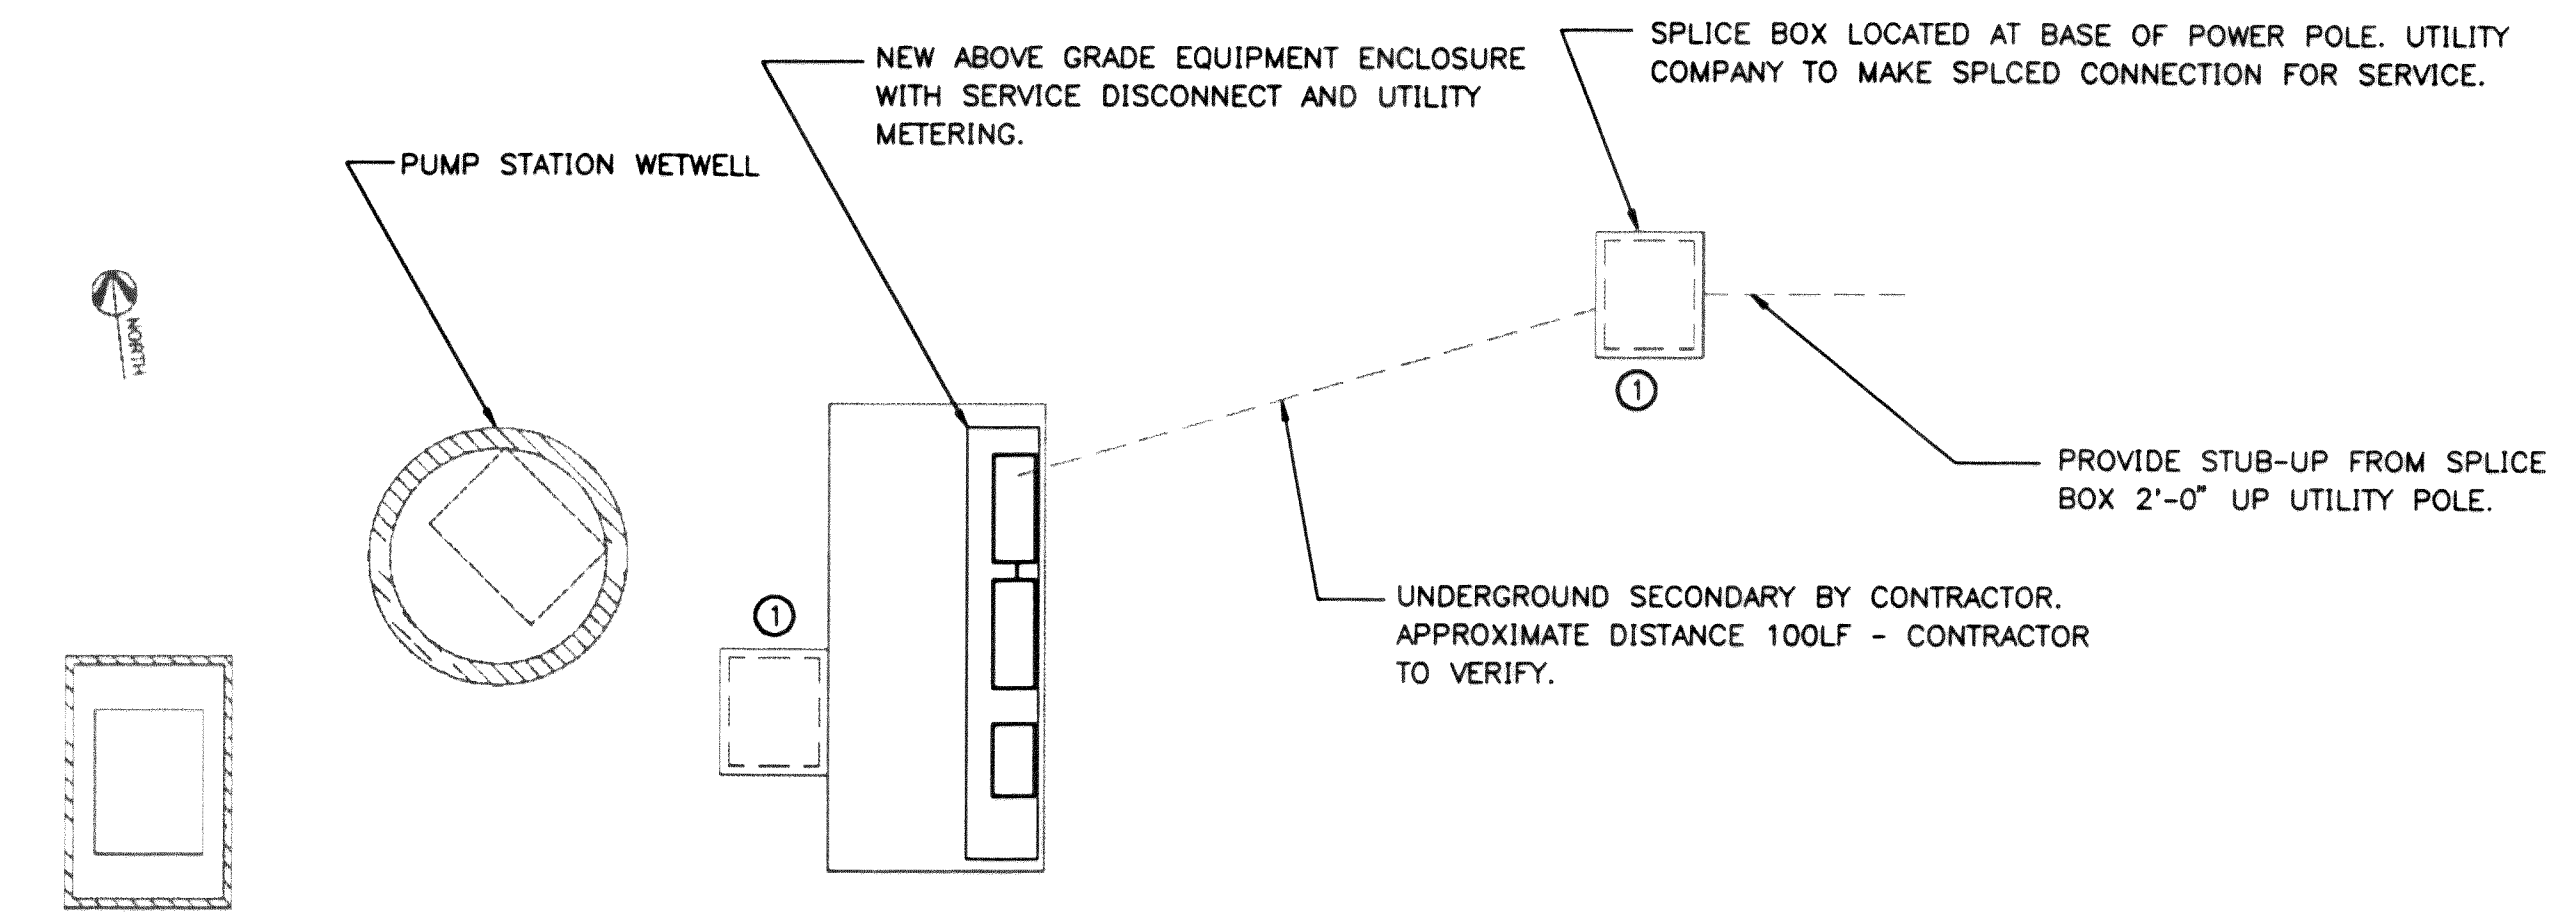


SITE PLAN - LIFT STATION

SCALE: 3/16" = 1'-0"

SYMBOL LEGEND


- | | | | |
|--|---|--|--|
| | LIGHT DUPLEX RECEPTACLE | | SINGLE POLE SWITCH |
| | GFI RECEPTACLE, DOUBLE DUPLEX | | MOTOR OUTLET |
| | EXPOSED CONDUIT: UNLESS OTHERWISE INDICATED, SYMBOL DENOTES 1/2" C-2#12+1#12 GROUND | | MANUAL MOTOR STARTER |
| | CONCEALED CONDUIT: UNLESS OTHERWISE INDICATED, SYMBOL DENOTES 1/2" C-2#12+1#12 GROUND | | DISCONNECT SWITCH |
| | DOOR POSITION INDICATION SWITCH (DPIS) | | JUNCTION BOX |
| | RELAY CONTACT, NORMALLY OPEN | | METER |
| | RELAY CONTACT, NORMALLY CLOSED | | RELAY COIL |
| | CIRCUIT BREAKER | | "DISTANT" CONNECTION TO FIELD DEVICE OR OTHER SYSTEM |
| | TRANSFORMER | | CONDUIT AND WIRE IDENTIFIER |

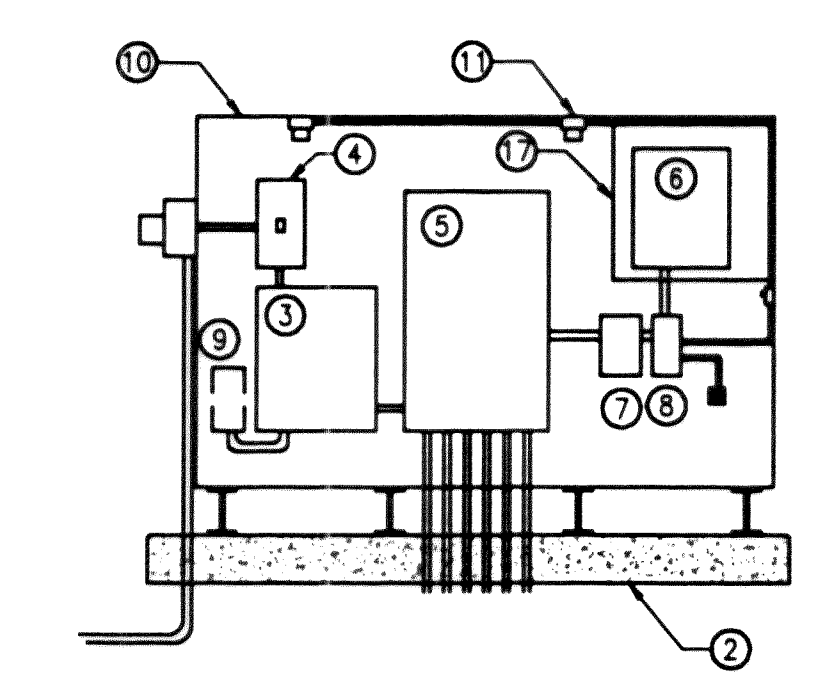

PANEL ELEVATION

NOT TO SCALE


1

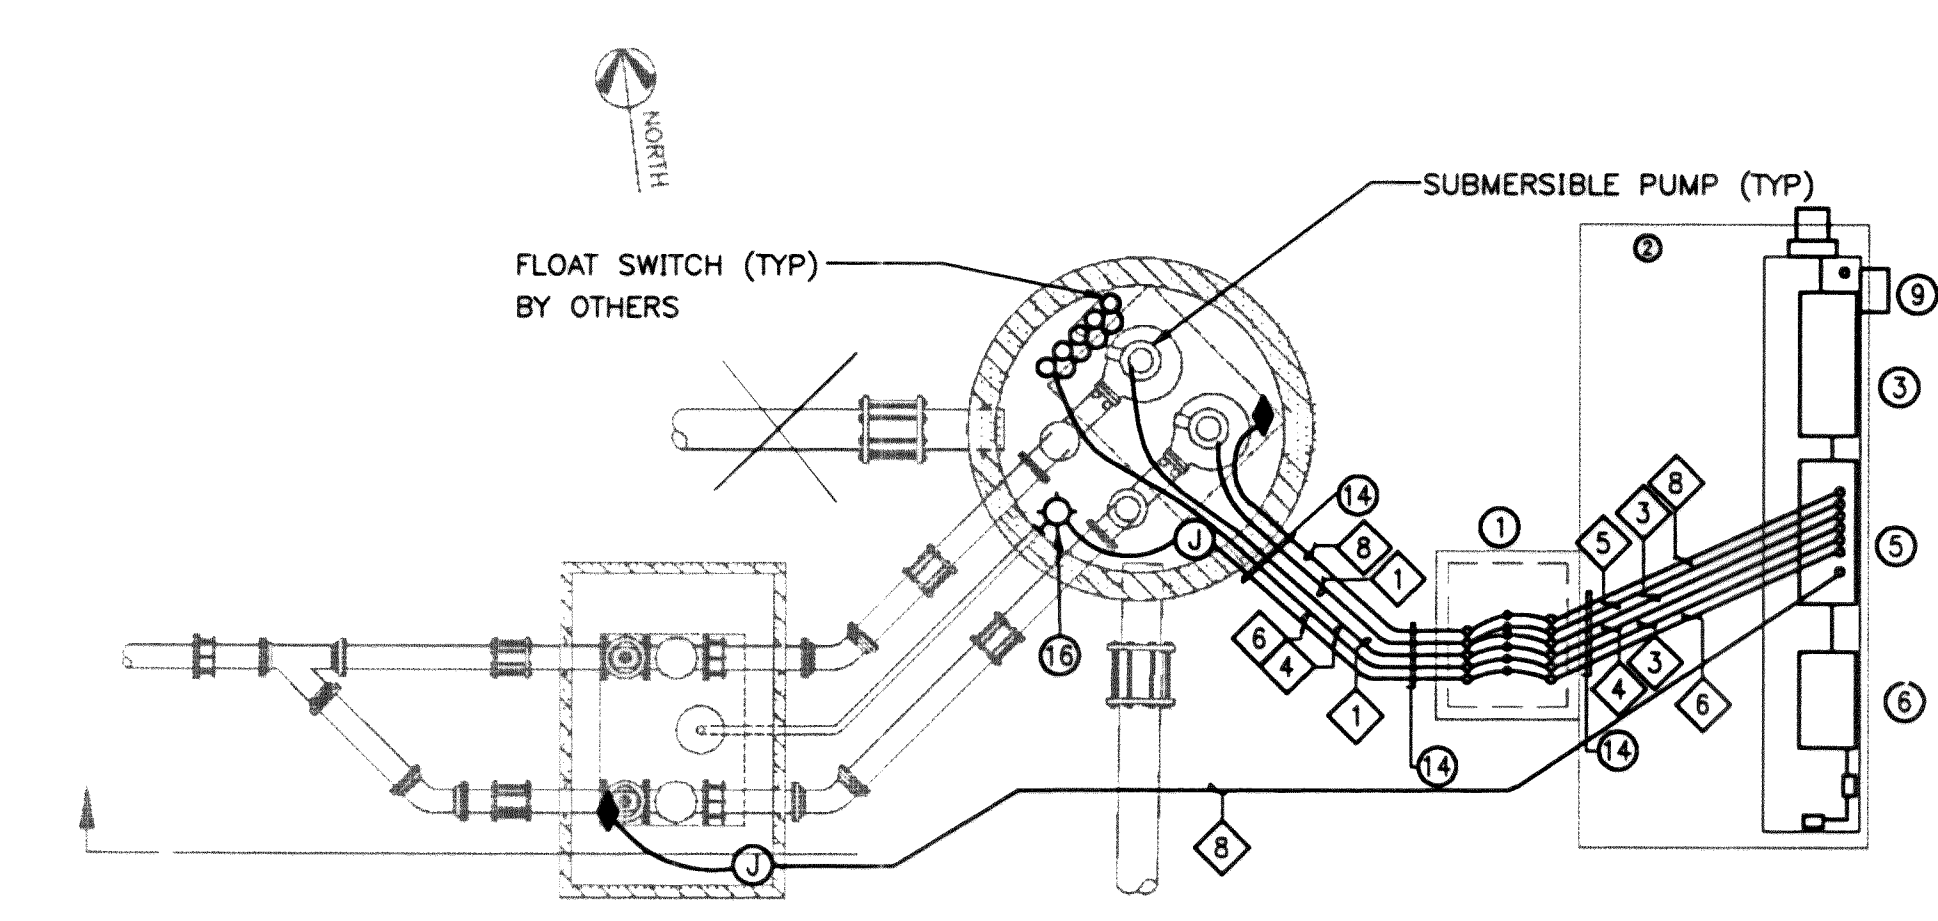

LIFT STATION PLAN

1/4" = 1'-0"

2

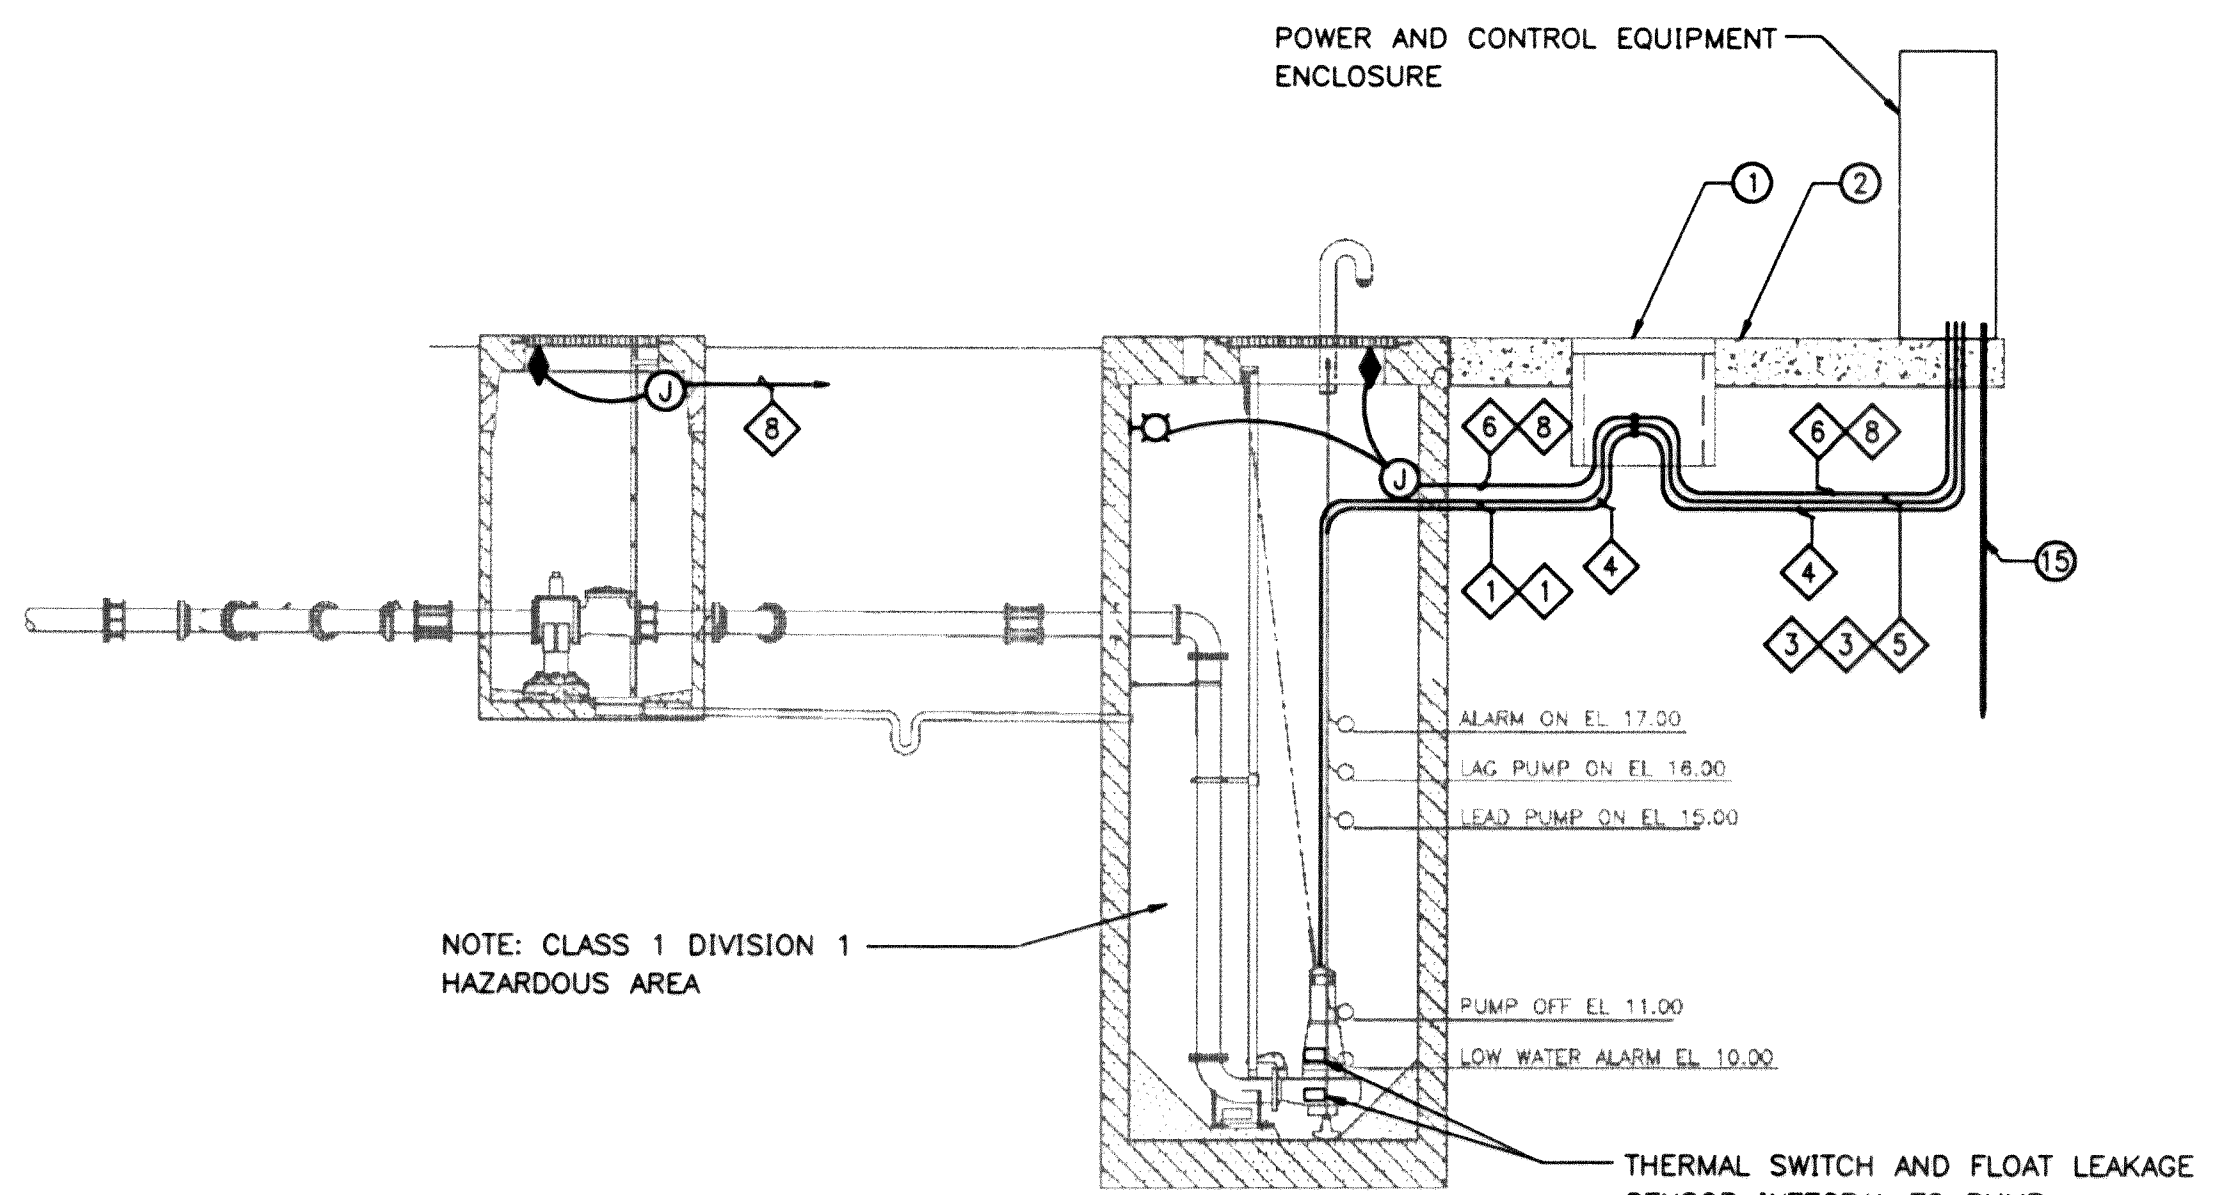

LIFT STATION SECTION

1/4" = 1'-0"

3

KEYNOTES:

- PROVIDE 36"Wx42"Lx32"H CONCRETE JUNCTION BOX, UTILITY VAULT CO #3642-LA WITH LOCKING STEEL COVER, #3642--2436P, OR APPROVED EQUAL. AREA WITHIN JUNCTION BOX SHALL BE CLASSIFIED AS CLASS 1 DIVISION 1.
- PROVIDE 6'-0"x13'-0"x1'-0" CONCRETE PAD.
- PROVIDE 60A-3P MANUAL TRANSFER SWITCH.
- PROVIDE 60A-3P ENCLOSED CIRCUIT BREAKER, NEMA 3R.
- PROVIDE POWER AND CONTROL PANEL, NEMA 3R.
- PROVIDE TELEMETRY RTU CABINET, REFERENCE THE SPECIFICATIONS.
- PROVIDE 3KVA, 1Ø, 480-120/240V, TRANSFORMER, SQUARE D #3S40F OR EQUAL.
- PROVIDE LOAD CENTER, 120/240V, 1Ø, SQUARE D #NQOD12M100RB OR EQUAL.
- PROVIDE GENERATOR RECEPTACLE MOUNTED ON BACK OF EQUIPMENT ENCLOSURE. CROUSE-HINDS #AREA204227 WITH 2 1/2" HUB SIZE, BACK BOX, ANGLE ADAPTER, RECEPTACLE HOUSING, SPRING DOOR COVER, AND TYPE AP MATING PLUG.
- PROVIDE 10"Wx6"Hx2'D POWER AND CONTROL EQUIPMENT ENCLOSURE IN ACCORDANCE WITH CITY OF FERNDAL STANDARD DETAIL. MOUNT ENCLOSURE ON I-BEAM SUPPORTS TO GIVE A MINIMUM 12" CLEARANCE ABOVE CONCRETE SLAB.
- PROVIDE LIGHT FIXTURE, CROUSE-HINDS #VXHF25GP.
- PROVIDE LIGHT SWITCH.
- PROVIDE GFI RECEPTACLE, QUADRAPLEX.
- PROVIDE CLASS 1 DIVISION 1 CONDUIT SEALS, APPLETON #ESU SERIES.
- 3/4"x8'-0" COPPER CLAD GROUND ROD.
- LIGHT FIXTURE, CROUSE-HINDS #EVBX210-T3C.
- PROVIDE 16 GA STEEL BARRIER, ENCLOSURE DEPTH, TO SEPERATE THE RTU FROM OTHER DEVICES.

NO. REVISIONS BY DATE



ONE INCH AT FULL SCALE

IF NOT ONE INCH SCALE ACCORDINGLY

DESIGNED BY: RCP


DRAWN BY: RCP

CHECKED BY: RCP

CITY OF FERNDAL L.I.D. NO. 8

SANITARY SEWER EXTENSION

LIFT STATION

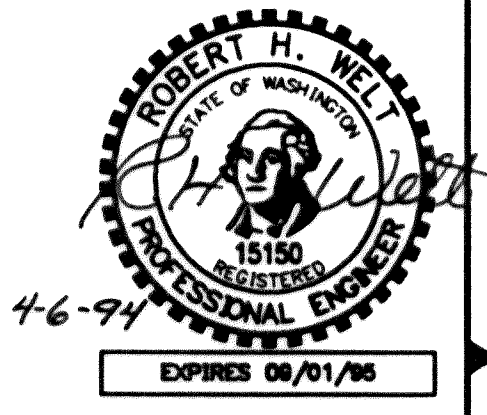

DATE 4/06/94


SCALE AS NOTED

REC. NO.

SHEET 16 OF 17

04-05-1994 94A32E11 UPDATE-10 REV-0 CDM JAMES Z-SCHT

00103.016 2-8-06 K2

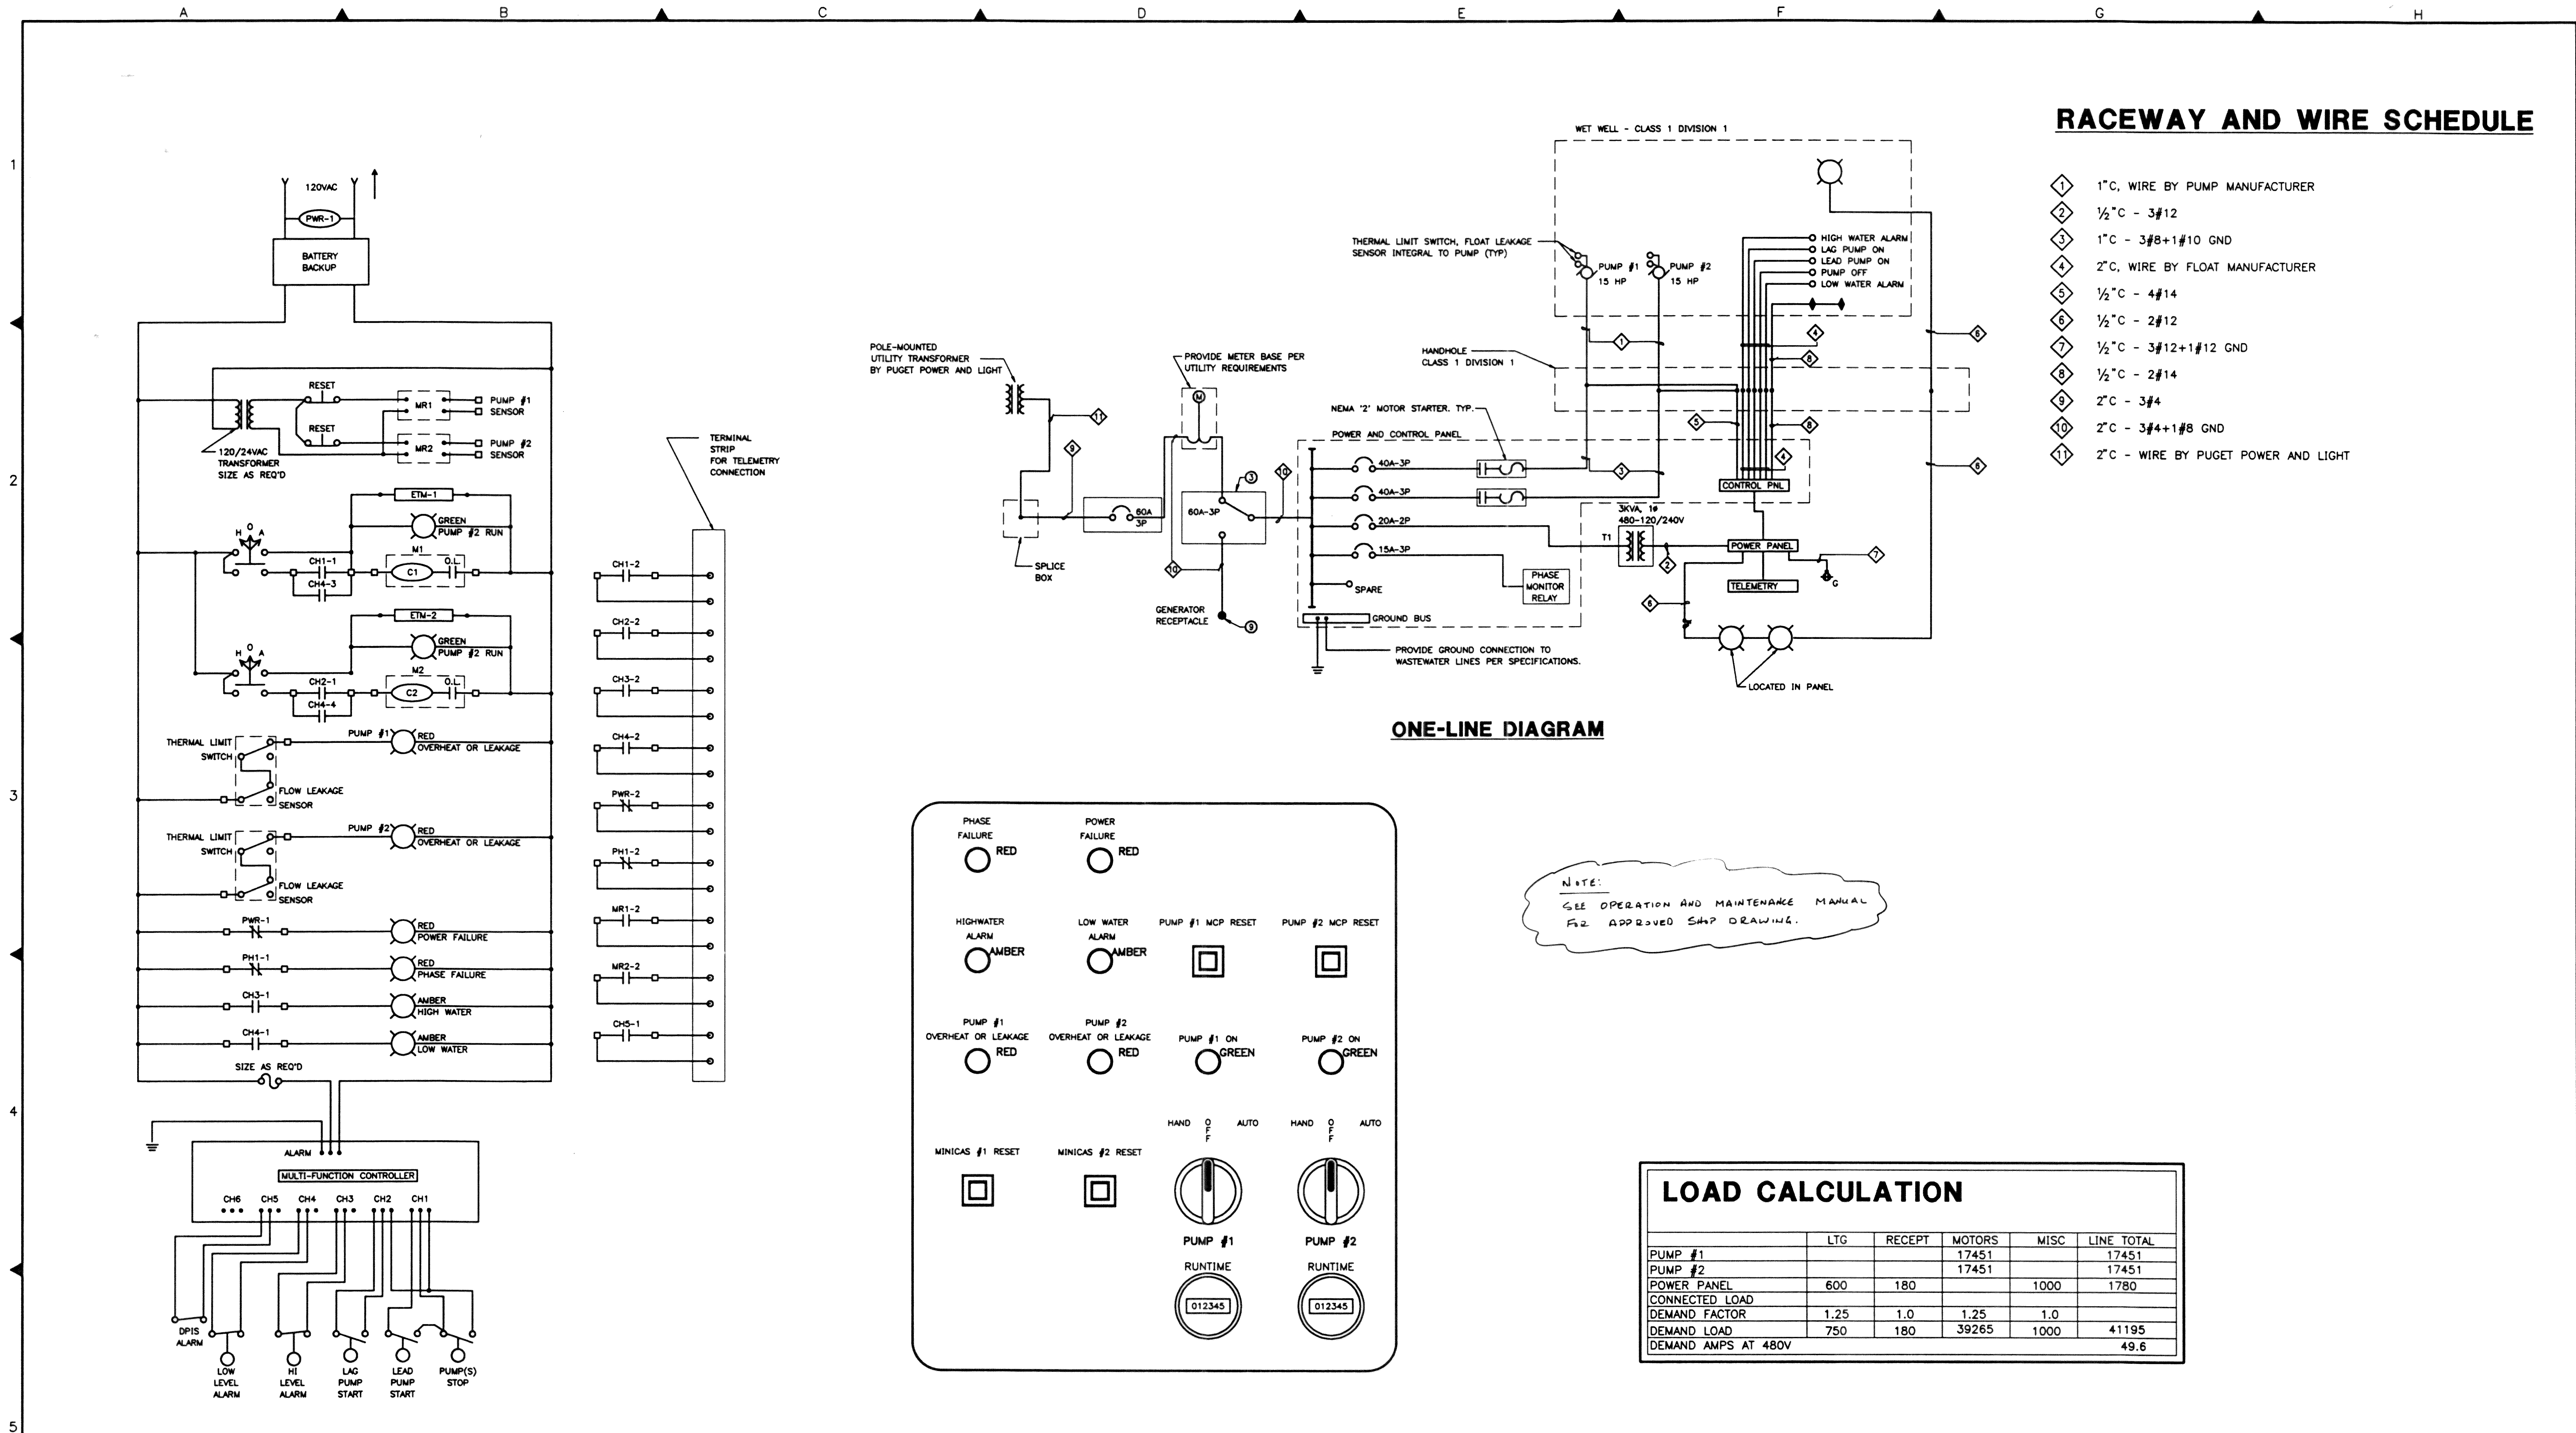

RACEWAY AND WIRE SCHEDULE

- 1 1" C, WIRE BY PUMP MANUFACTURER
- 2 1/2" C - 3#12
- 3 1" C - 3#8+1#10 GND
- 4 2" C, WIRE BY FLOAT MANUFACTURER
- 5 1/2" C - 4#14
- 6 1/2" C - 2#12
- 7 1/2" C - 3#12+1#12 GND
- 8 1/2" C - 2#14
- 9 2" C - 3#4
- 10 2" C - 3#4+1#8 GND
- 11 2" C - WIRE BY PUGET POWER AND LIGHT

NOTE:
SEE OPERATION AND MAINTENANCE MANUAL
FOR APPROVED SHOP DRAWINGS.

LOAD CALCULATION

	LTG	RECEPT	MOTORS	MISC	LINE TOTAL
PUMP #1			17451		17451
PUMP #2			17451		17451
POWER PANEL	600	180		1000	1780
CONNECTED LOAD					
DEMAND FACTOR	1.25	1.0	1.25	1.0	
DEMAND LOAD	750	180	39265	1000	41195
DEMAND AMPS AT 480V					49.6


CONTROL LOGIC DIAGRAM

NOT TO SCALE

PUMP CONTROL PANEL

NOT TO SCALE

NO.	REVISIONS	BY	DATE

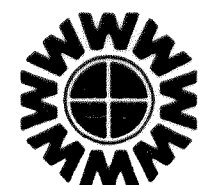

WEDEN ENGINEERING, INC.
119 GRAND AVENUE, SUITE D
BELLINGHAM, WA 98225 671-8200




MW Consulting Engineers
Great Northwest Building, Suite 200
North 222 Wall Street, Spokane, WA 99201-0877
Telephone: 509.838.9020 FAX: 509.838.1123

ONE INCH AT FULL SCALE
IF NOT ONE INCH
SCALE ACCORDINGLY

DESIGNED BY:
RCP
DRAWN BY:
RCP
CHECKED BY:
RCP

CITY OF FERNDAL L.I.D. NO. 8
SANITARY SEWER EXTENSION
LIFT STATION

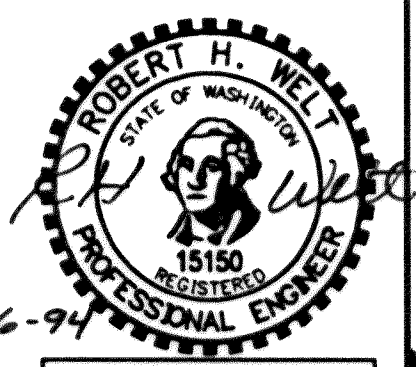

DATE 4/06/94	SHEET 17
SCALE NO SCALE	OF 17
REC. NO.	

04-05-1994 9343321 UPDATE-6 REV-0 CUM

00103.017 2.8.06 KR